

PLOT DATE: 4/2/2021 8:27:04 AM CAD USER: ECHIN

PATH: J:\Fresno COG-FN-16105-GSB Final Design\CADD\Sheets\Region 3 - Fowler\GSB_R3_D1-D7.dwg

LEGEND


	DITCH FLOW LINE OR SWALE		PROPOSED Culv/PIPE
	EXISTING Culv/PIPE		PROPOSED DI
			BERM BLOCK

ABBREVIATIONS


AP	ANGLE POINT
CULV	CULVERT
DI	DRAINAGE INLET
GB	GRADE BREAK
MH	MANHOLE
RCP	REINFORCED CONCRETE PIPE
SD	STORM DRAIN

NOTES

- RIGHT-OF-WAY INFORMATION IS AVAILABLE AT THE CITY OF FOWLER OFFICE.
- EXISTING DRAINAGE LOCATIONS ARE APPROXIMATE. CONTRACTOR SHALL VERIFY LOCATION AND ELEVATIONS BEFORE MODIFYING EXISTING DRAINAGE FACILITIES.

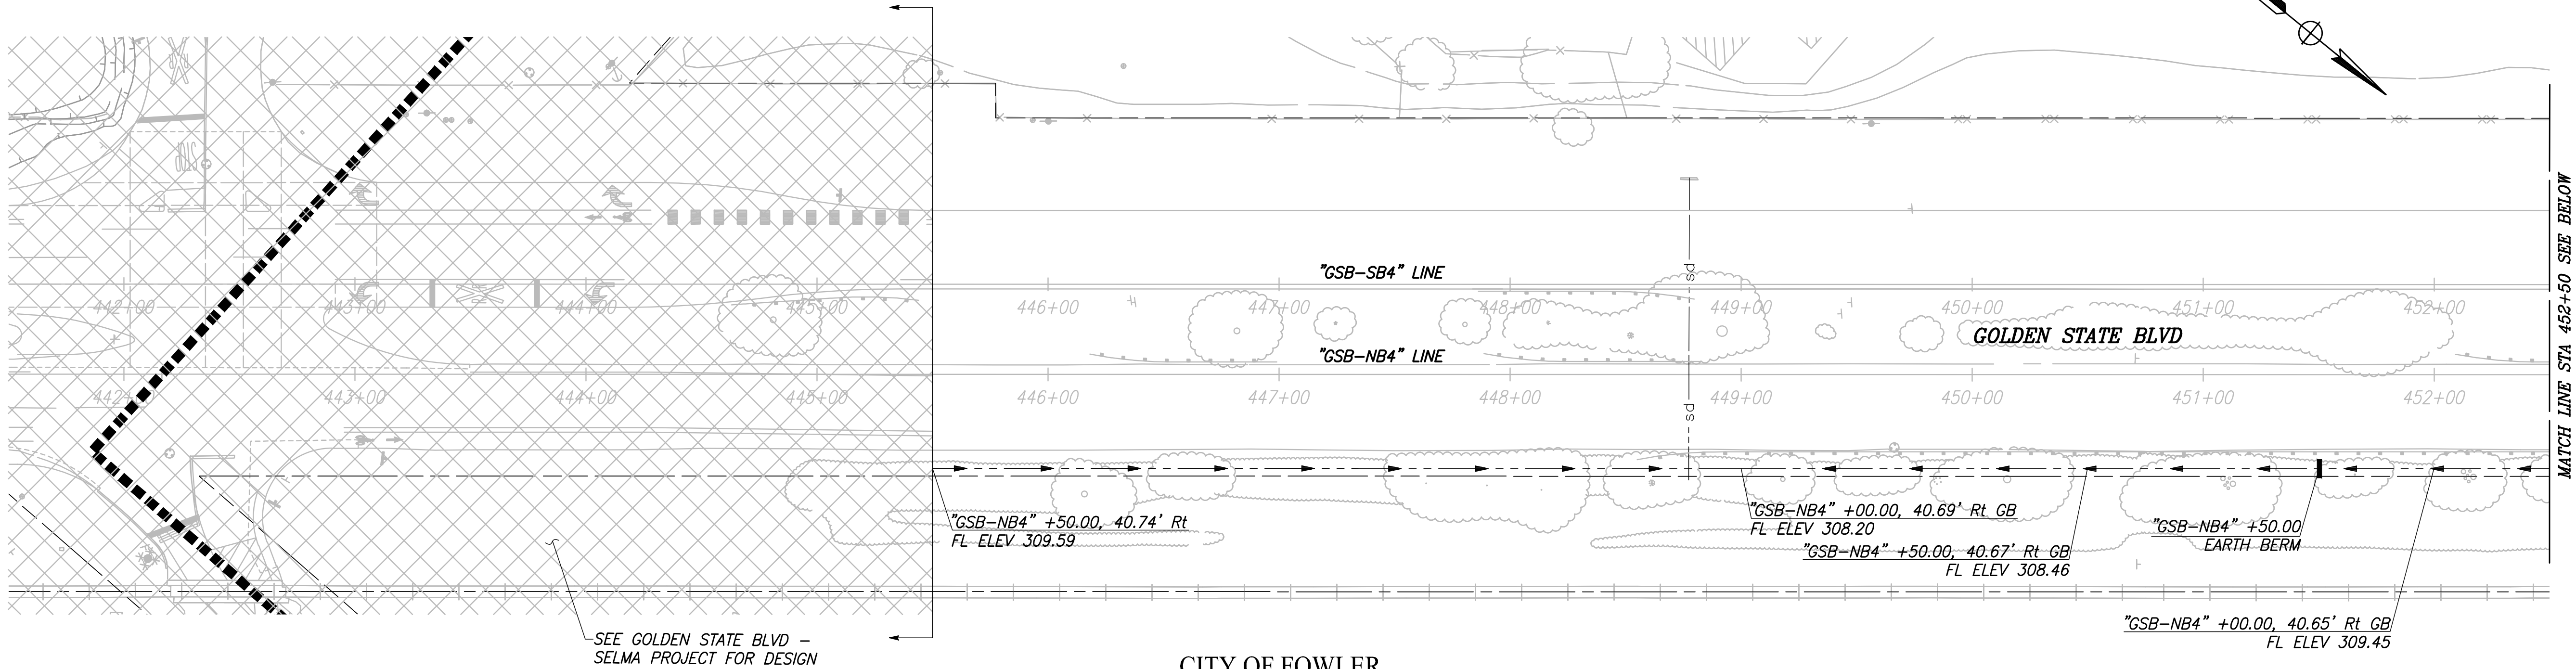

CITY OF FOWLER
GOLDEN STATE BLVD
SCALE: 1" = 40'

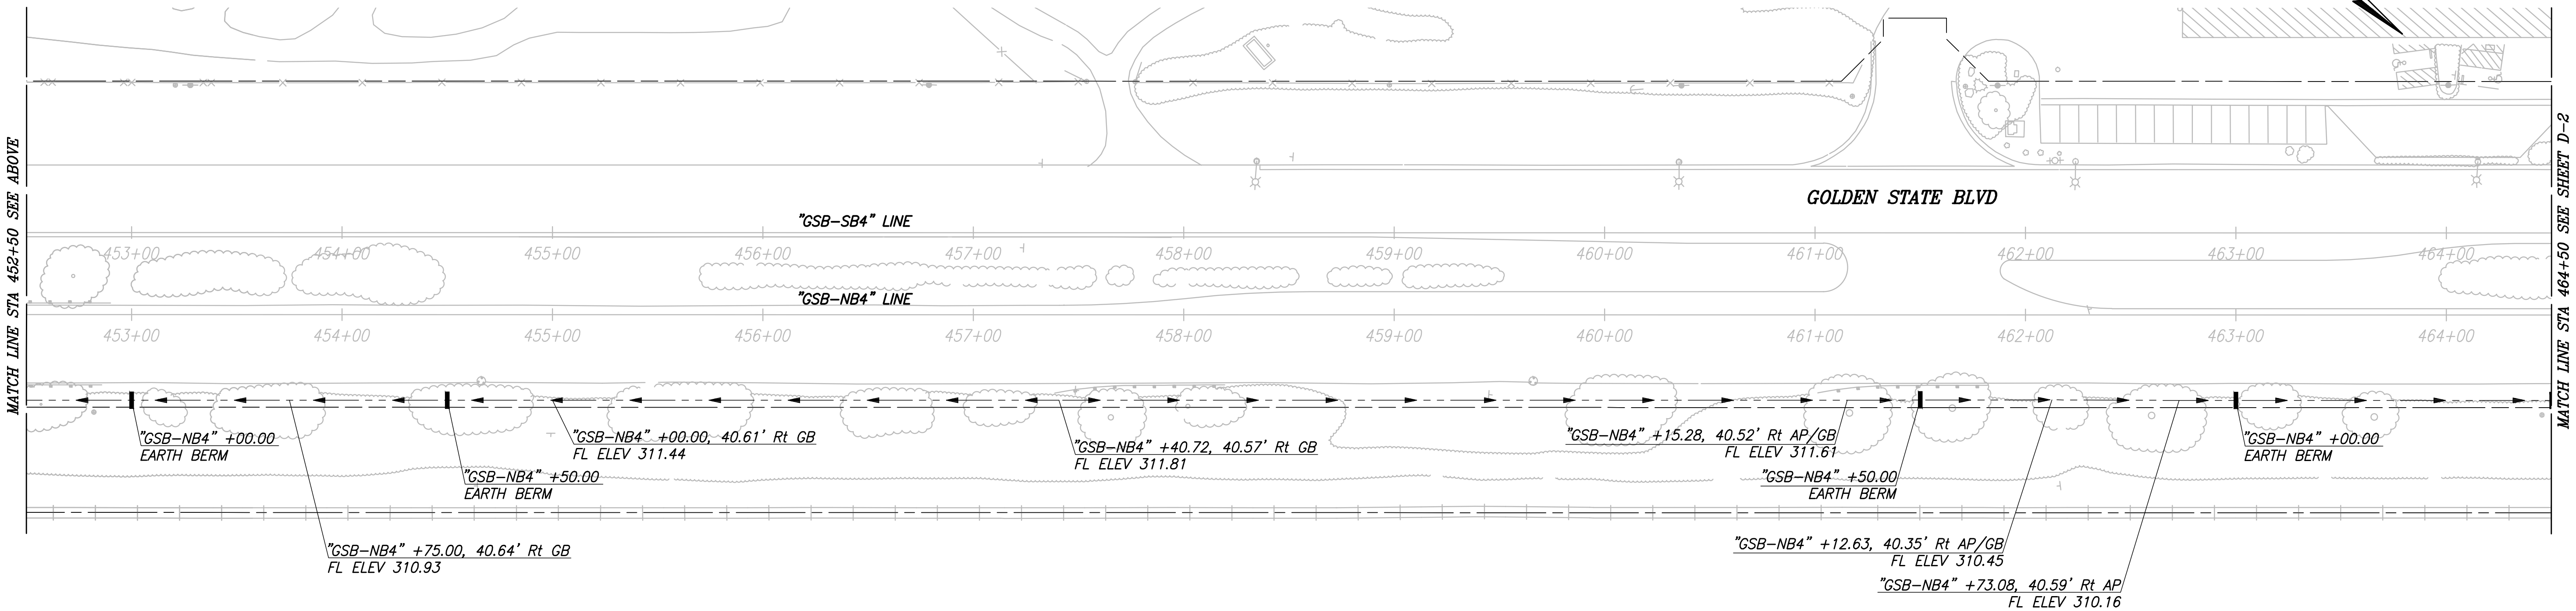

DESIGNED:	DATE	RECORD DRAWING	
ERIK CHIN	####	RESIDENT ENGINEER	DATE
DRAWN:	####		
DILLON ALAMEDA	####		
CHECKED:	####		
ED NORIEGA	####		

FOR RIGHT OF WAY DATA AND ACCURATE ACCESS DETERMINATION, SEE DOCUMENTS IN THE DEPARTMENT OF PUBLIC WORKS AND PLANNING.



CALL BEFORE YOU DIG




MARK THOMAS

TENTATIVE PLANS FOR DESIGN	
SUPERVISING ENGINEER	DATE





PROJECT	
GOLDEN STATE CORRIDOR - ECONOMIC DEVELOPMENT AND INFRASTRUCTURE IMPROVEMENTS	
FOWLER REGION	

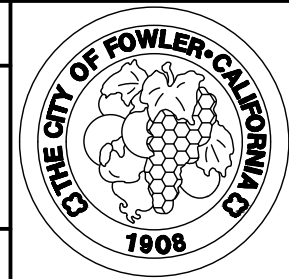

DEPARTMENT OF PUBLIC WORKS AND PLANNING		
DRAINAGE PLAN		
DRAWING NO. D-1	SHEET NO. 59	TOTAL 142

PLOT DATE: 4/2/2021 8:27:33 AM CAD USER: ECHIN


PATH: J:\Fresno COG-FN-16105-GSB Final Design\CADD\Sheets\Region 3 - Fowler\GSB_R3_D1-D7.dwg

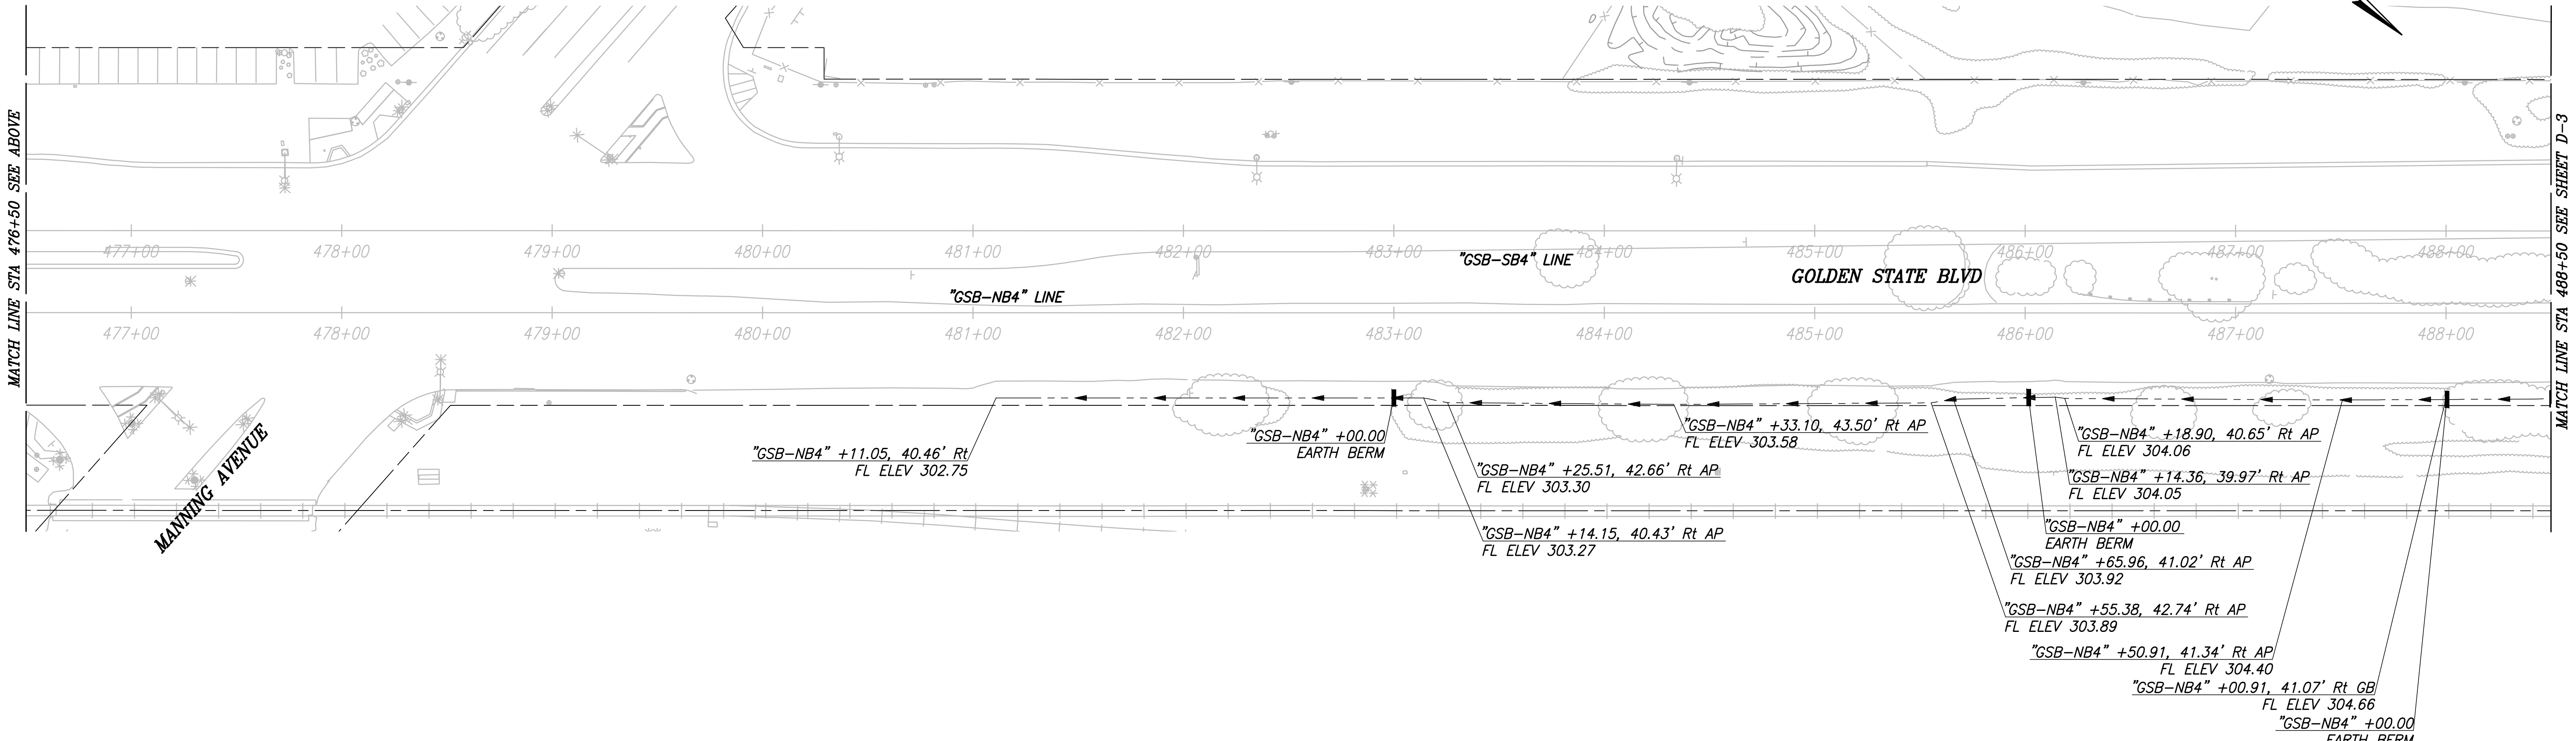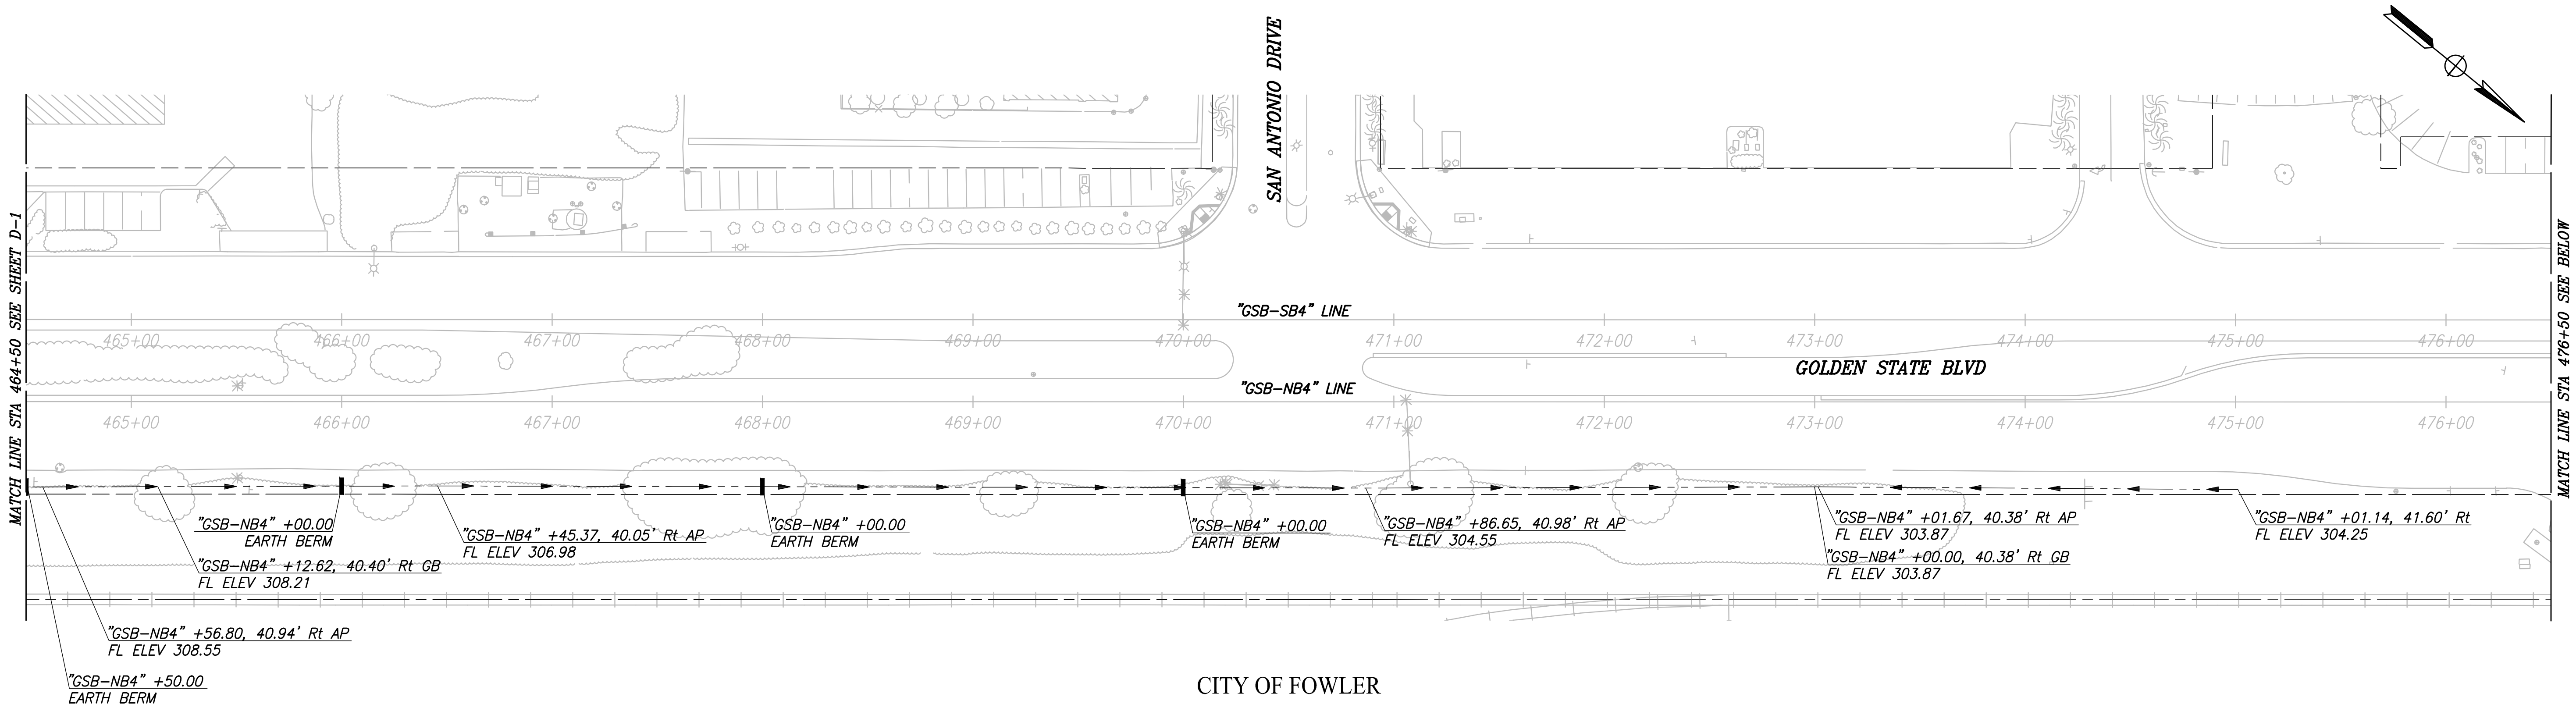


	DATE	RECORD DRAWING					PROJECT			DEPARTMENT OF PUBLIC WORKS AND PLANNING		
DESIGNED: ERIK CHIN	####	RESIDENT ENGINEER	DATE				GOLDEN STATE CORRIDOR - ECONOMIC DEVELOPMENT AND INFRASTRUCTURE IMPROVEMENTS			DRAINAGE PLAN		
DRAWN: DILLON ALAMEDA	####											
CHECKED: ED NORIEGA	####											
FOR RIGHT OF WAY DATA AND ACCURATE ACCESS DETERMINATION, SEE DOCUMENTS IN THE DEPARTMENT OF PUBLIC WORKS AND PLANNING.				CALL BEFORE YOU DIG			FOWLER REGION			DRAWING NO. D-2	SHEET NO. 60	TOTAL 142

PLOT DATE: 4/2/2021 8:28:03 AM CAD USER: ECHIN



PATH: J:\Fresno COG-FN-16105-GSB Final Design\CADD\Sheets\Region 3 - Fowler\GSB_R3_D1-D7.dwg

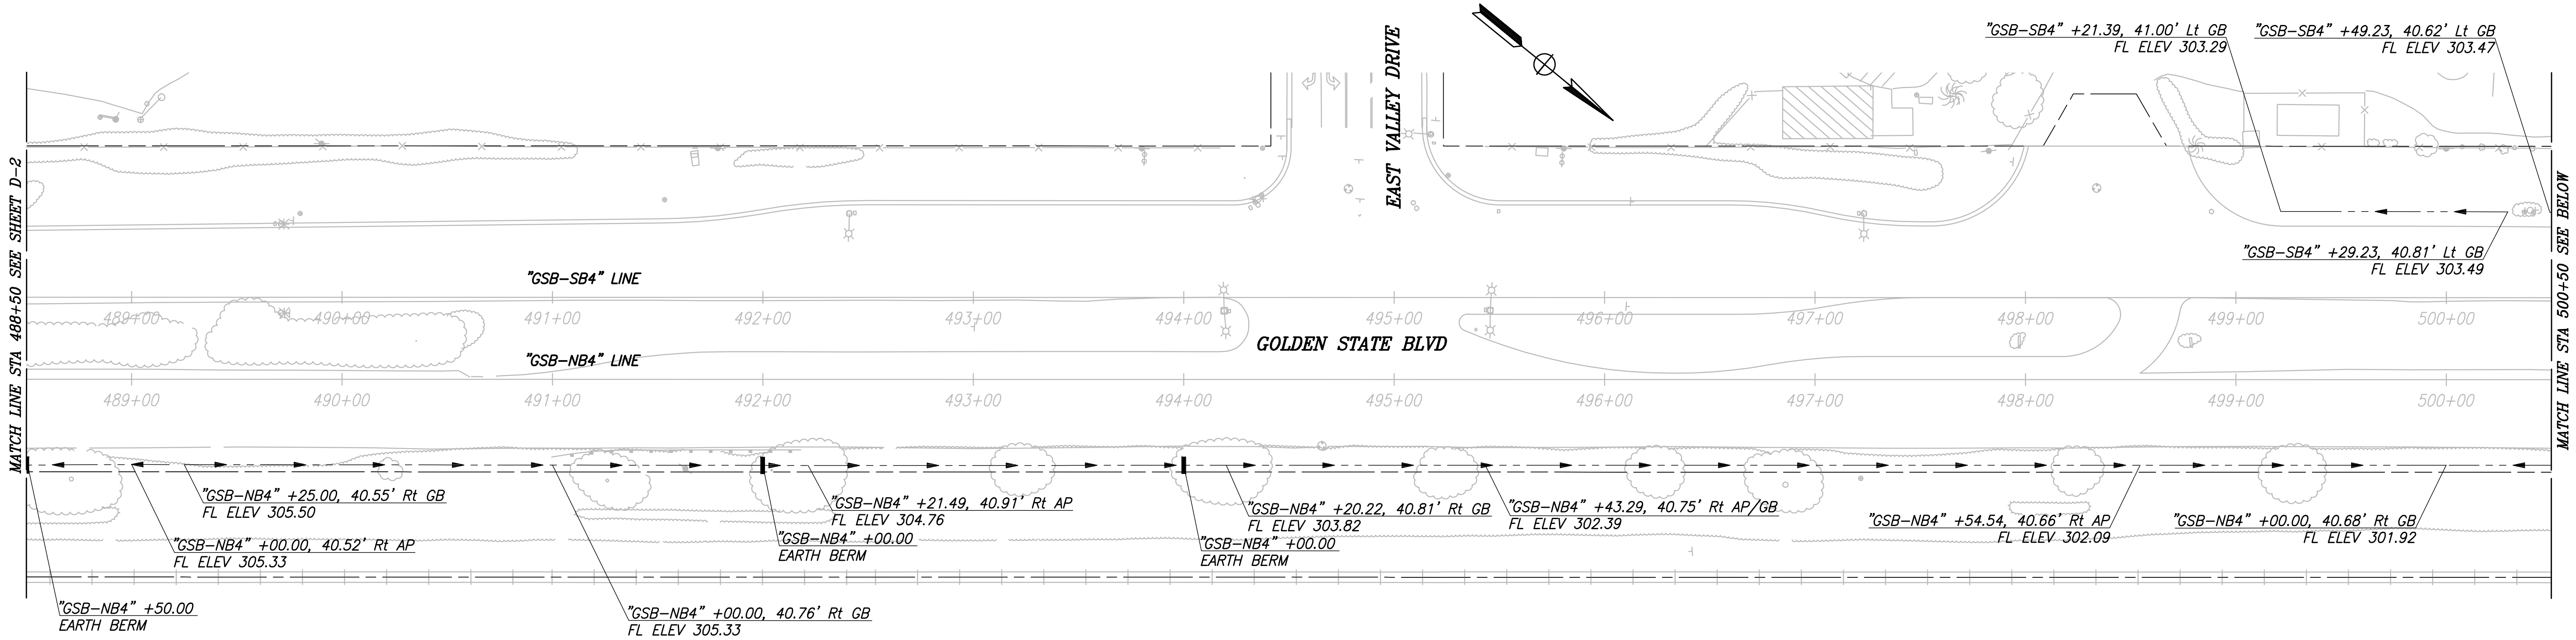

CITY OF FOWLER
GOLDEN STATE BLVD
SCALE: 1" = 40'

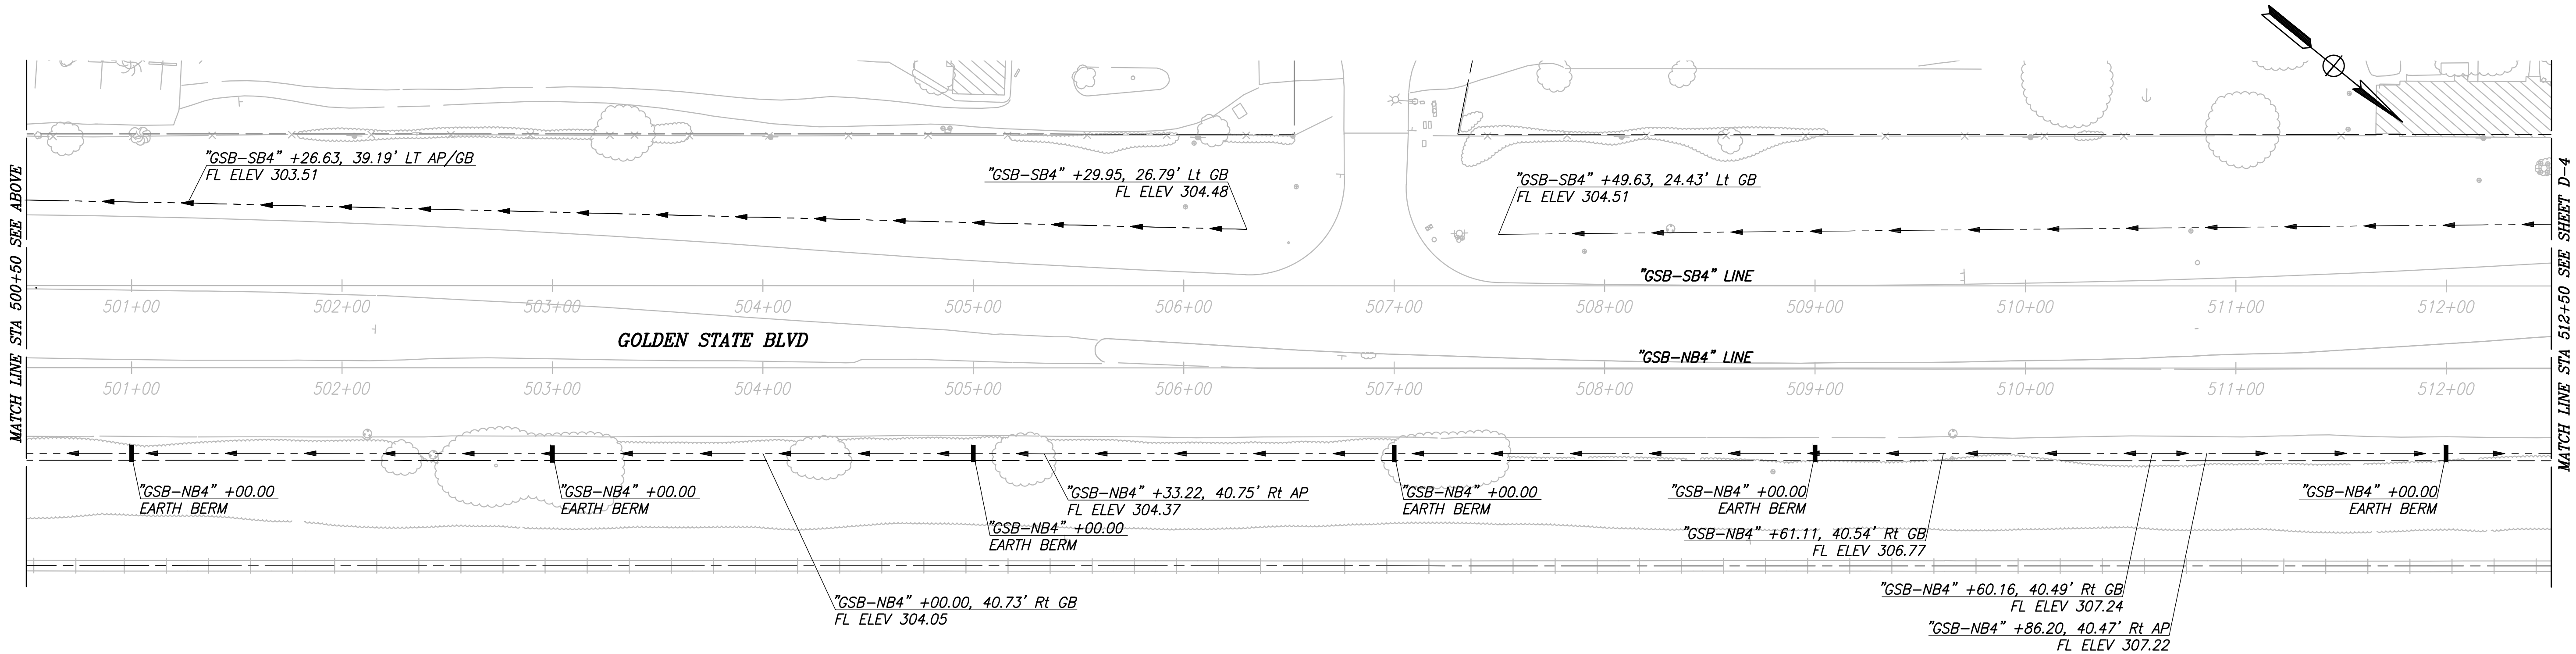


	DATE	RECORD DRAWING					PROJECT			DEPARTMENT OF PUBLIC WORKS AND PLANNING	
DESIGNED: ERIK CHIN	####	RESIDENT ENGINEER	DATE				GOLDEN STATE CORRIDOR - ECONOMIC DEVELOPMENT AND INFRASTRUCTURE IMPROVEMENTS			DRAINAGE PLAN	
DRAWN: DILLON ALAMEDA	####										
CHECKED: ED NORIEGA	####										
FOR RIGHT OF WAY DATA AND ACCURATE ACCESS DETERMINATION, SEE DOCUMENTS IN THE DEPARTMENT OF PUBLIC WORKS AND PLANNING.				CALL BEFORE YOU DIG			SUPERVISING ENGINEER		DATE		
								FOWLER REGION			

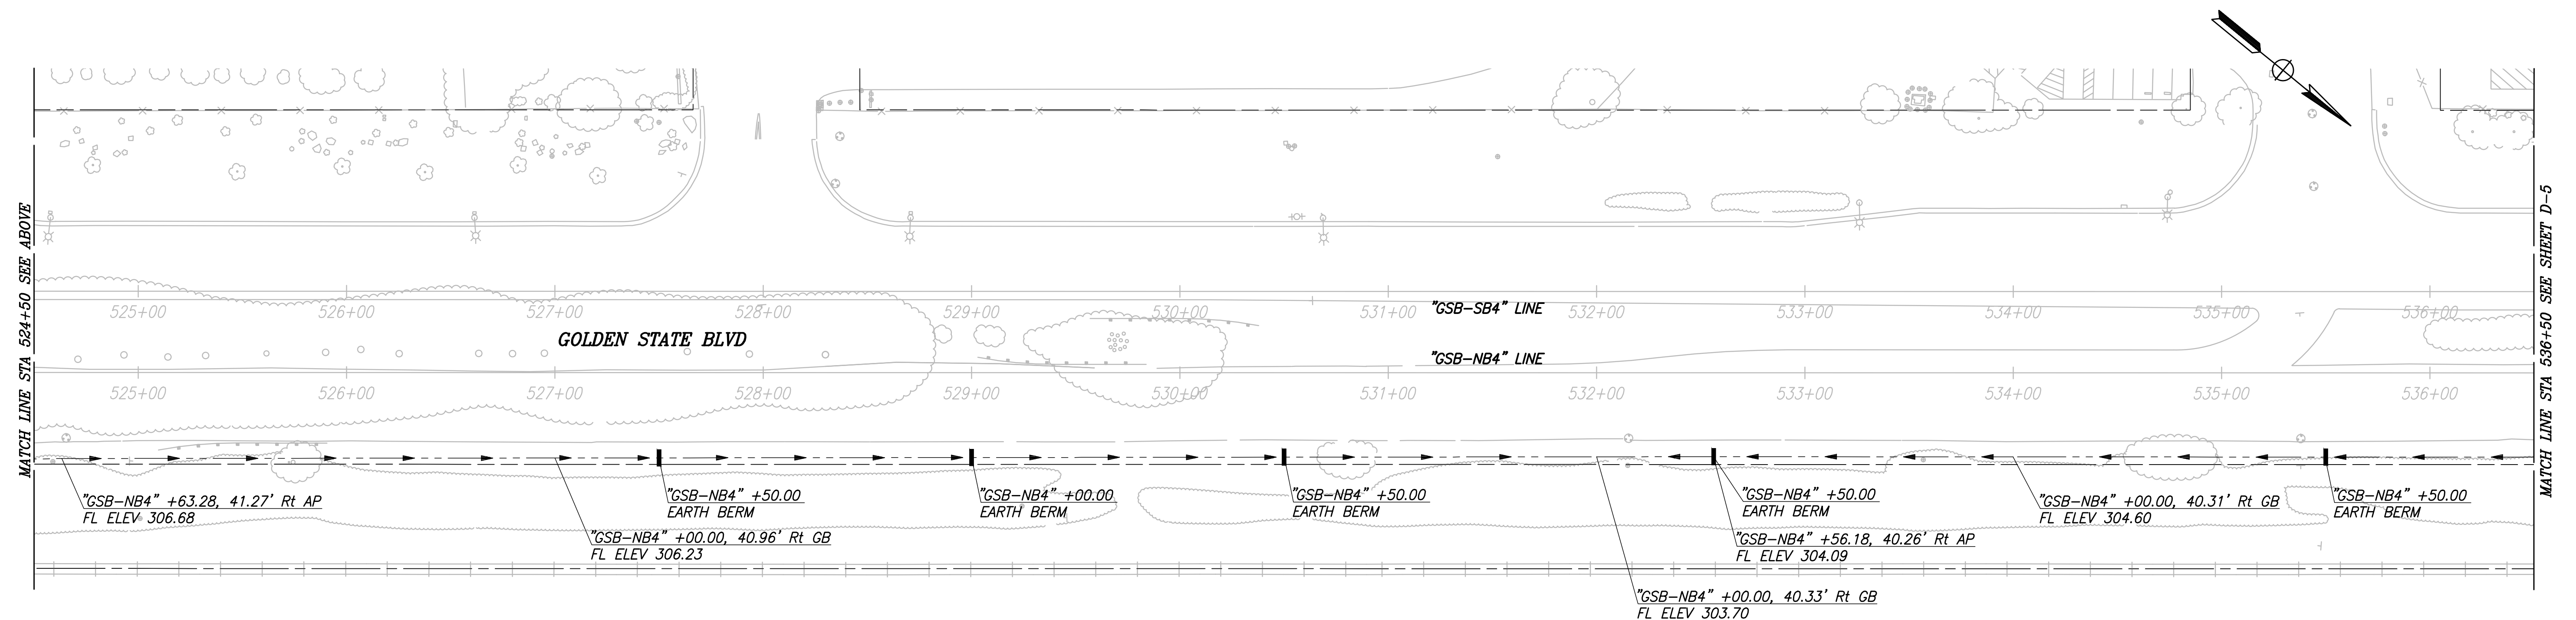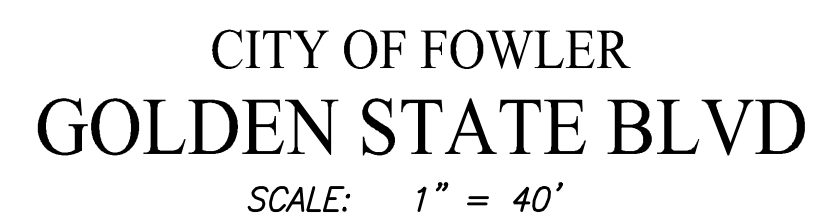


		DATE	RECORD DRAWING		  MARK THOMAS		PROJECT			DEPARTMENT OF PUBLIC WORKS AND PLANNING	
DESIGNED: ERIK CHIN	####	RESIDENT ENGINEER		DATE			GOLDEN STATE CORRIDOR - ECONOMIC DEVELOPMENT AND INFRASTRUCTURE IMPROVEMENTS			DRAINAGE PLAN	
DRAWN: DILLON ALAMEDA	####										
CHECKED: ED NORIEGA	####										
FOR RIGHT OF WAY DATA AND ACCURATE ACCESS DETERMINATION, SEE DOCUMENTS IN THE DEPARTMENT OF PUBLIC WORKS AND PLANNING.						FOWLER REGION		DRAWING NO. D-4		SHEET NO. 62	TOTAL 142

PATH: J:\Fresno COG-FN-16105-GSB Final Design\CADD\Sheets\Region 3 - Fowler\GSB_R3_D1-D7.dwg
PLOT DATE: 4/2/2021 8:29:02 AM CAD USER: ECHIN

PATH: J:\Fresno COG-FN-16105-GSB Final Design\CADD\Sheets\Region 3 - Fowler\GSB_R3_D1-D7.dwg
PLOT DATE: 4/2/2021 8:29:02 AM CAD USER: ECHIN

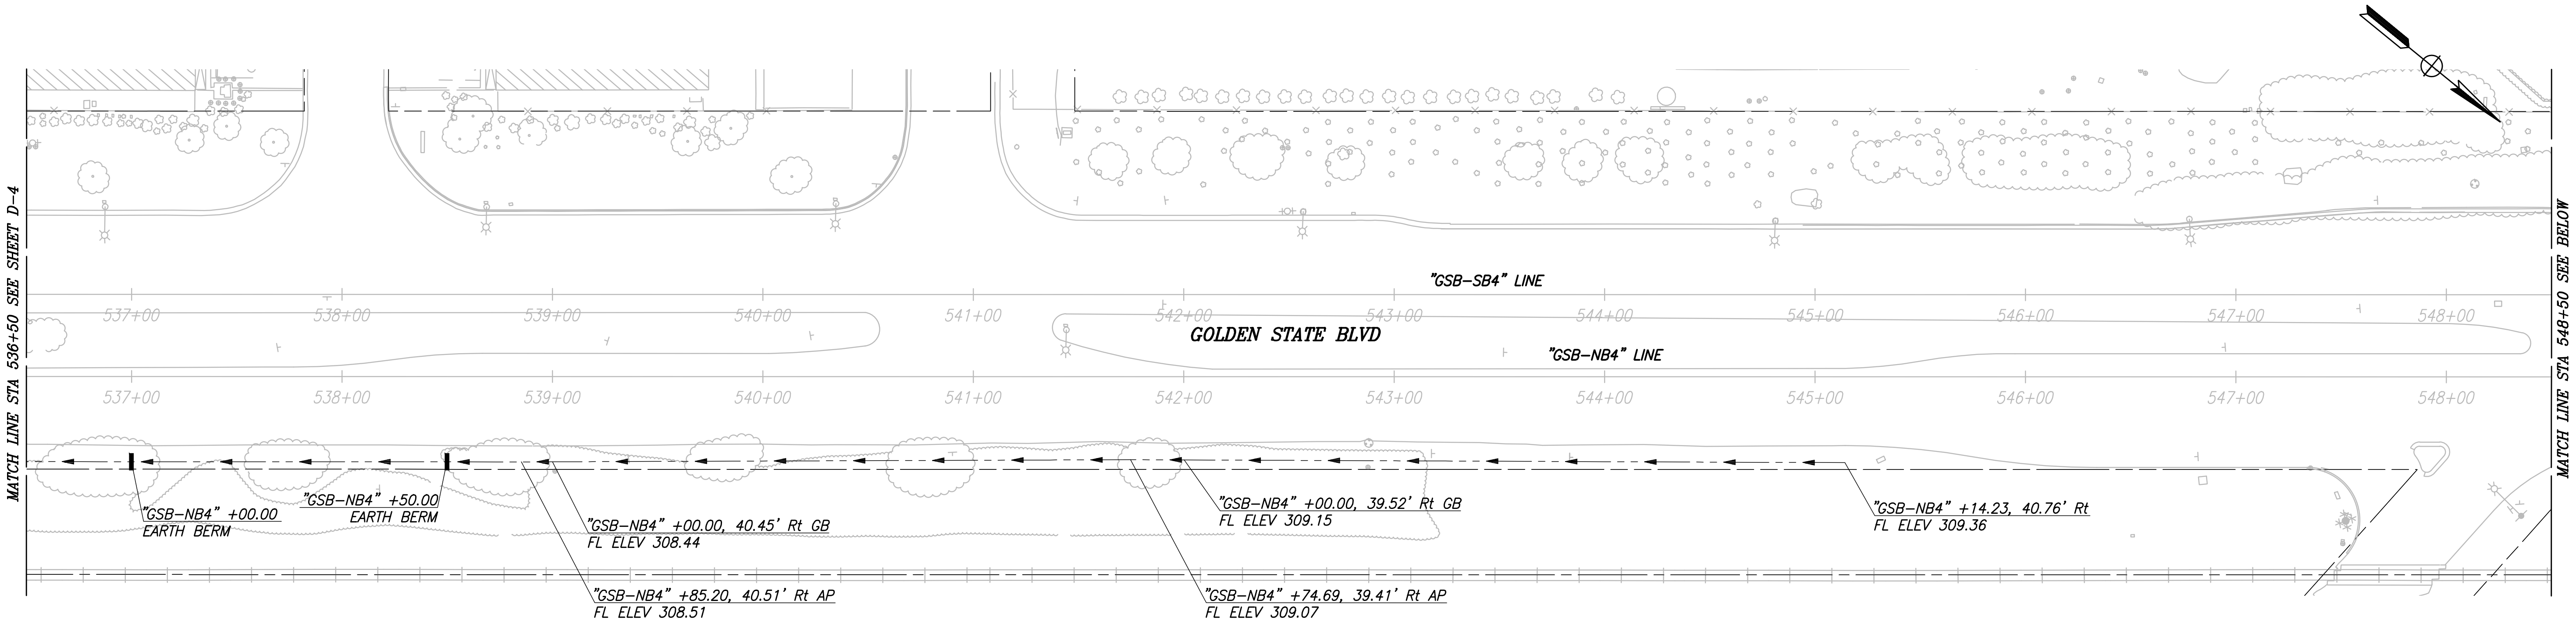

CITY OF FOWLER
GOLDEN STATE BLVD
SCALE: 1" = 40'

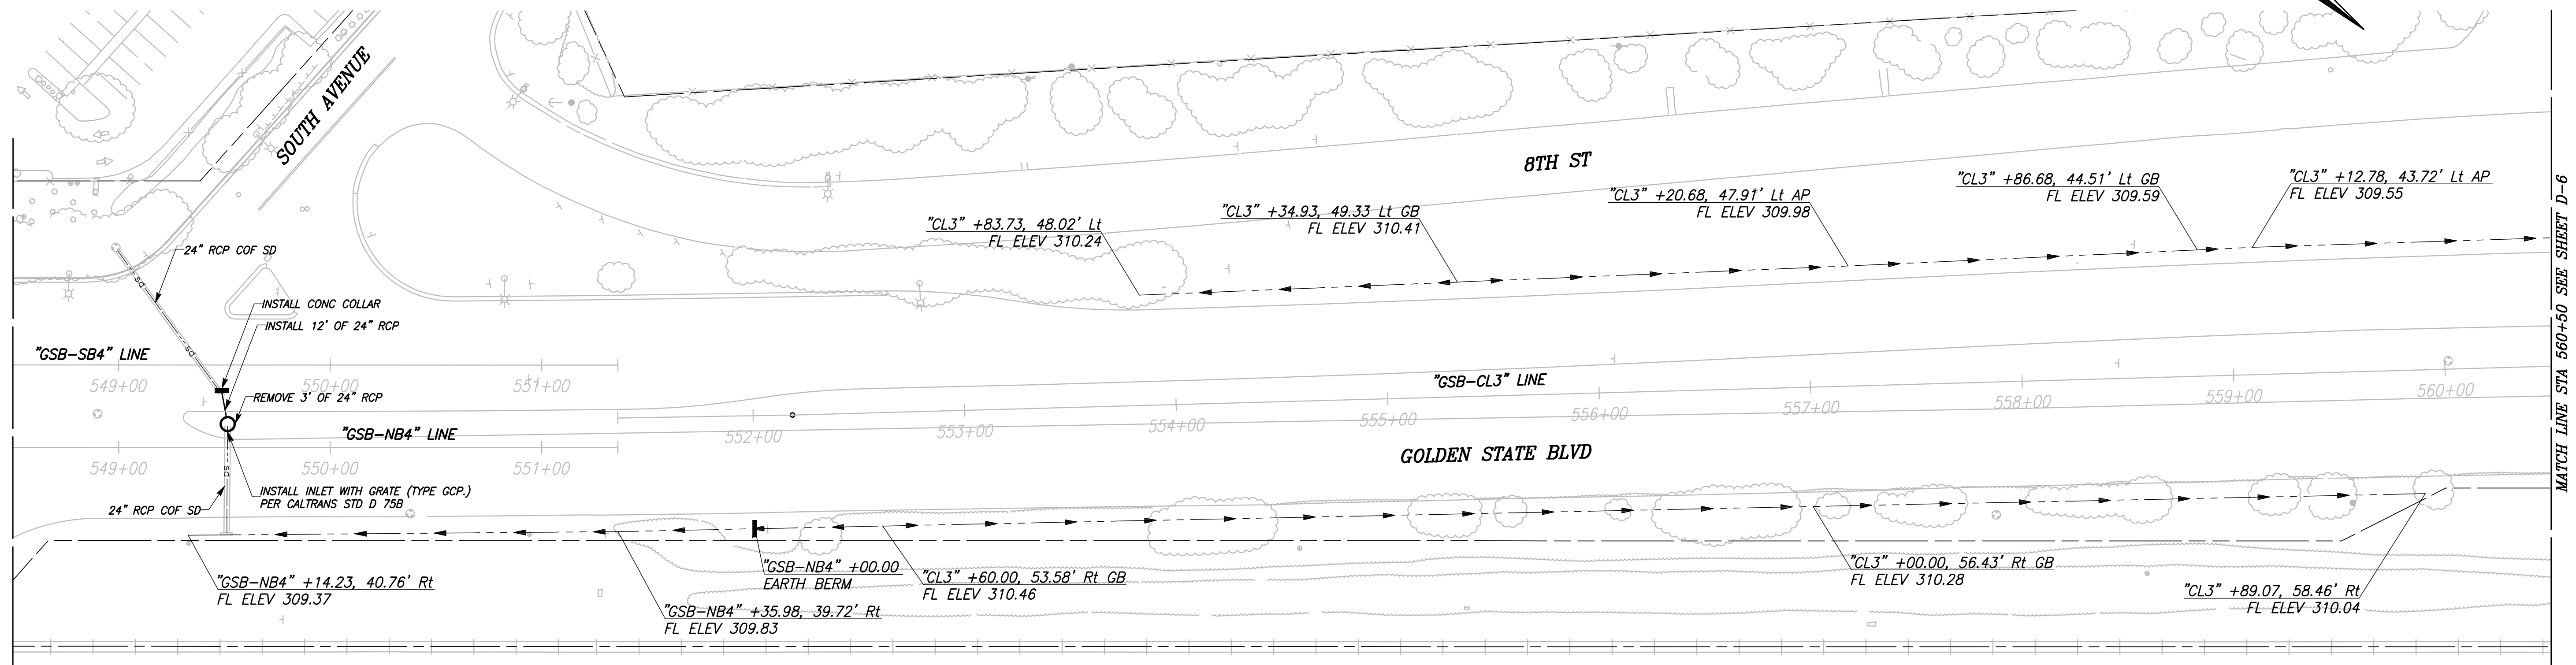


RECORD DRAWING	
DESIGNED: ERIK CHIN	DATE: ####
DRAWN: DILLON ALAMEDA	DATE: ####
CHECKED: ED NORIEGA	DATE: ####



TENTATIVE PLANS FOR DESIGN
SUPERVISING ENGINEER
DATE: 4/2/2021




PROJECT
GOLDEN STATE CORRIDOR - ECONOMIC DEVELOPMENT AND INFRASTRUCTURE IMPROVEMENTS
FOWLER REGION

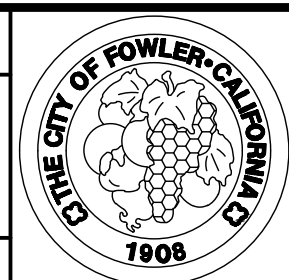

DEPARTMENT OF PUBLIC WORKS AND PLANNING
DRAWING NO. D-5
SHEET NO. 63
TOTAL 142

PLOT DATE: 4/2/2021 8:29:42 AM CAD USER: ECHIN

PATH: J:\Fresno COG-FN-16105-GSB Final Design\CADD\Sheets\Region 3 - Fowler\GSB_R3-D1-D7.dwg

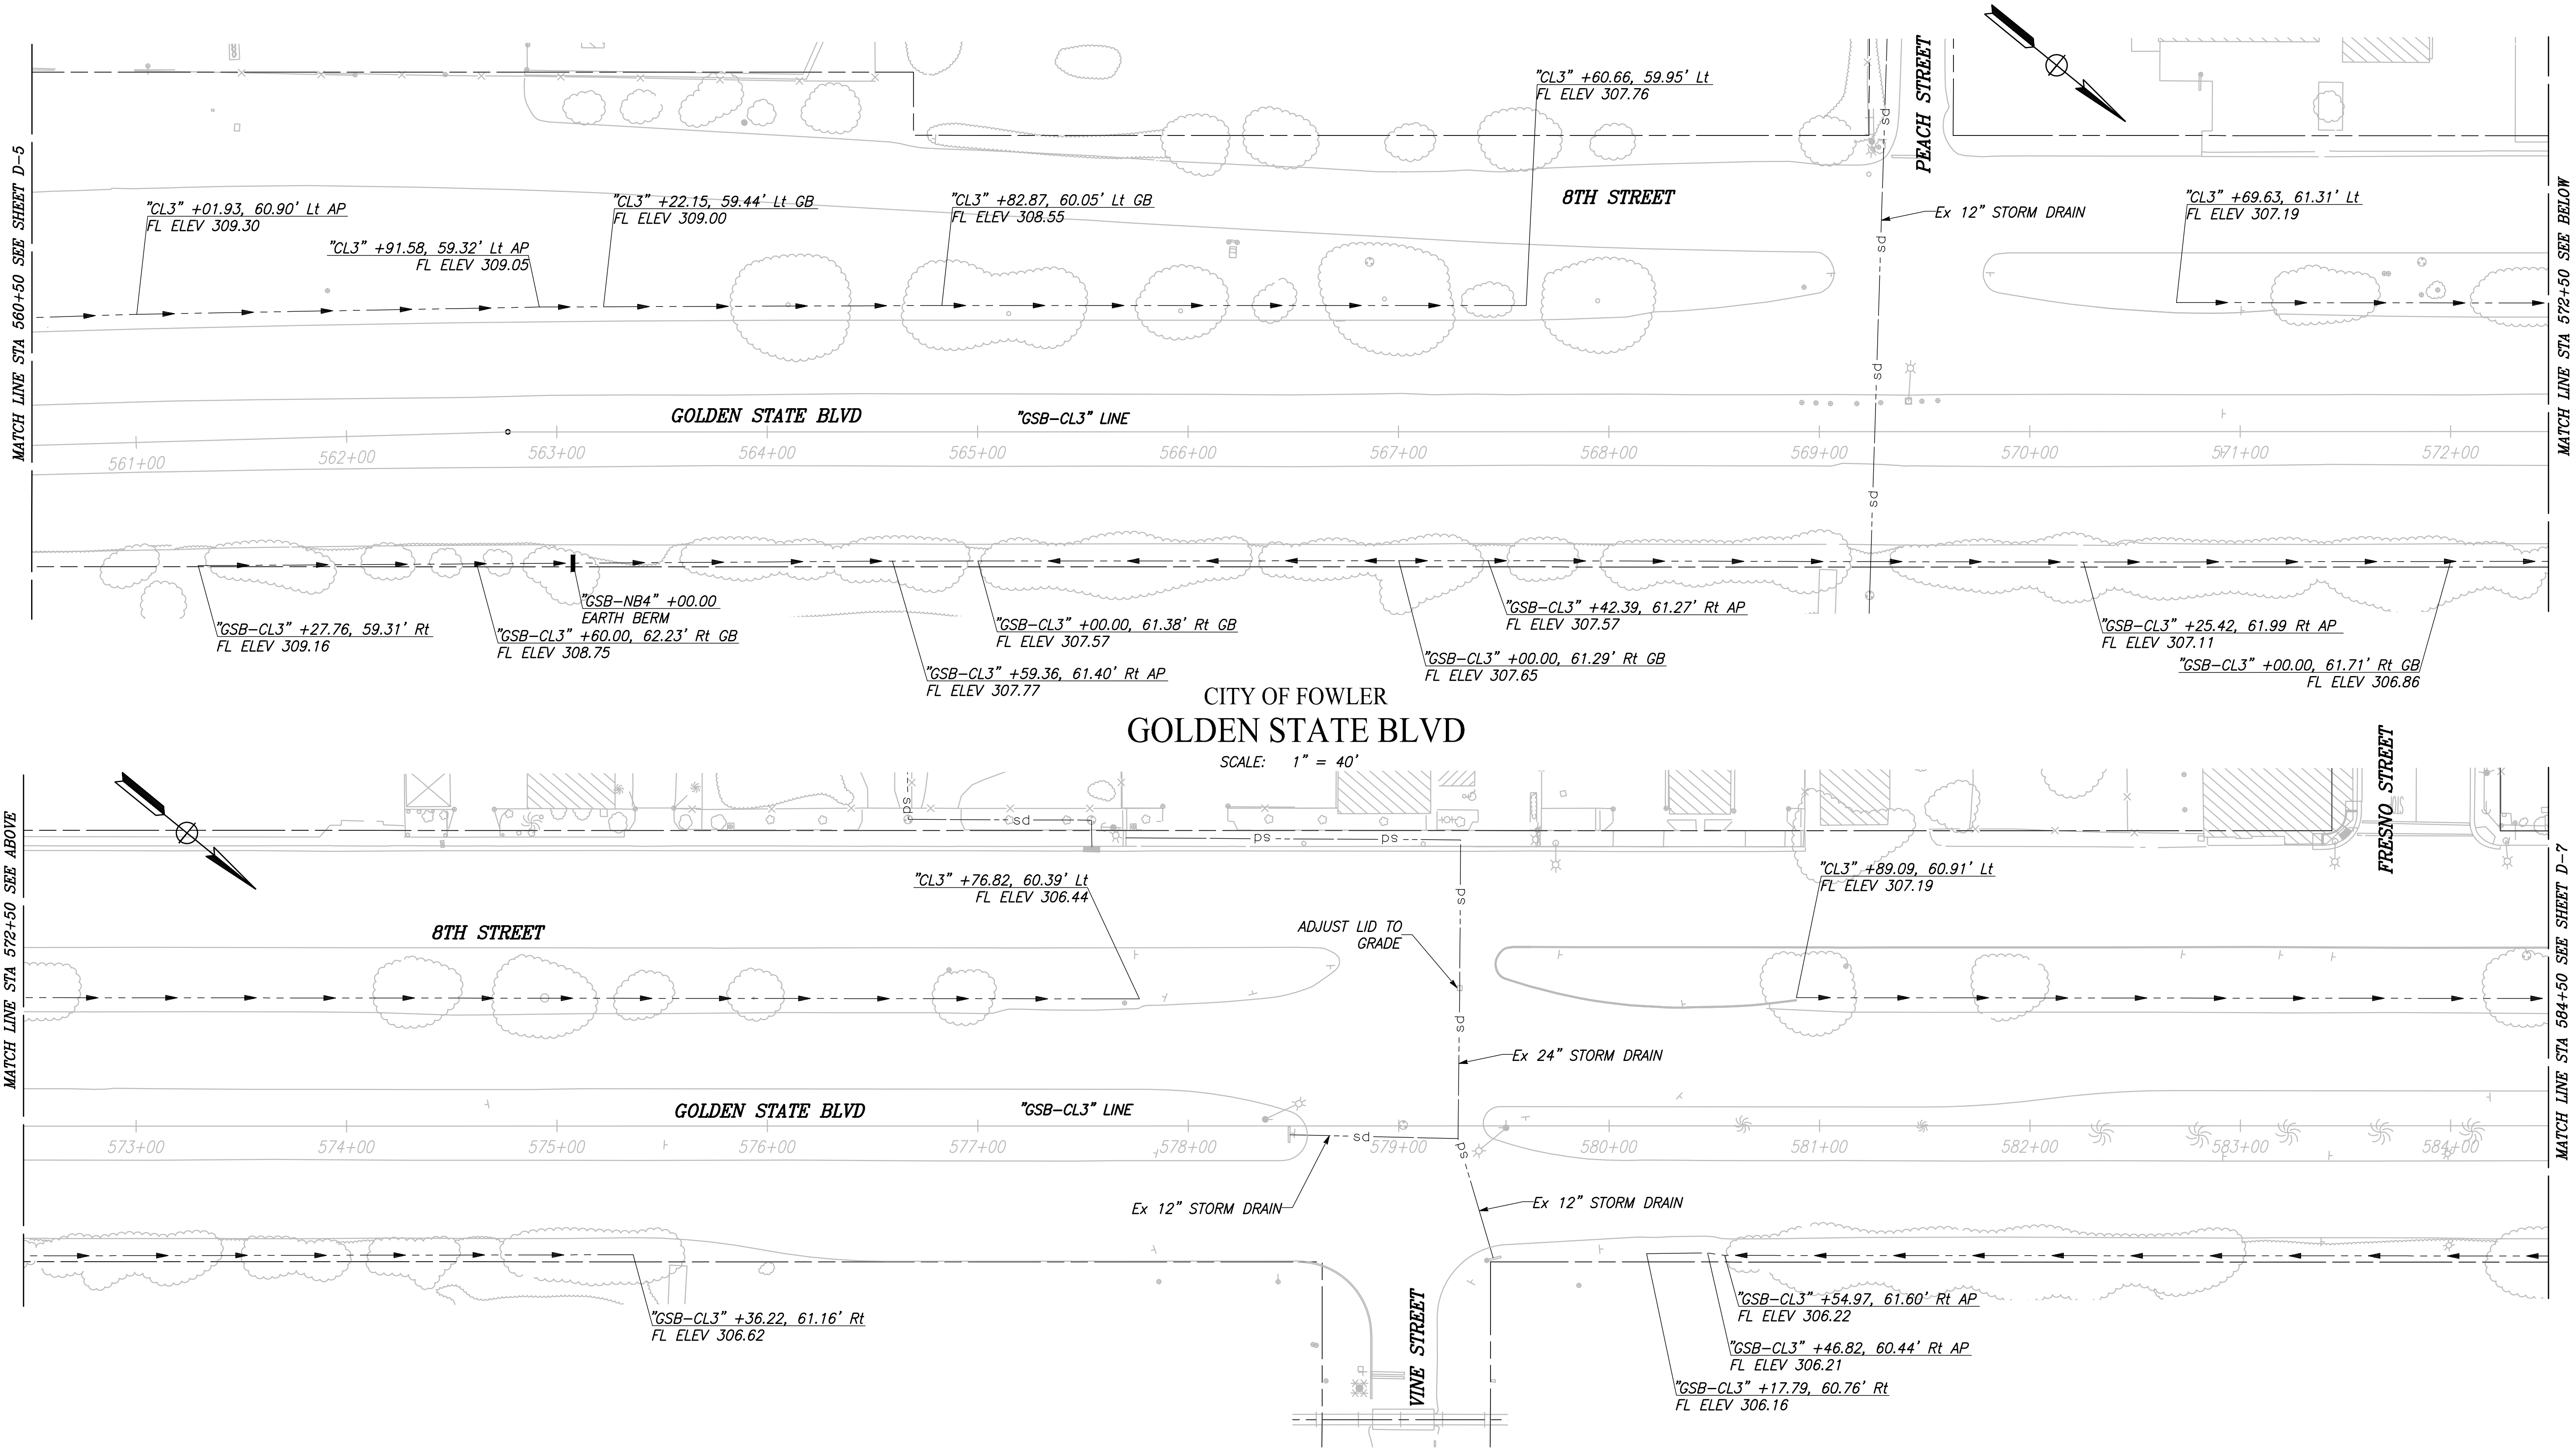


RECORD DRAWING			
DESIGNED: ERIK CHIN	DATE: ####	RESIDENT ENGINEER	DATE
DRAWN: DILLON ALAMEDA	DATE: ####		
CHECKED: ED NORIEGA	DATE: ####		
FOR RIGHT OF WAY DATA AND ACCURATE ACCESS DETERMINATION, SEE DOCUMENTS IN THE DEPARTMENT OF PUBLIC WORKS AND PLANNING.			




TENTATIVE PLANS FOR DESIGN	DATE
SUPERVISING ENGINEER	



PROJECT
GOLDEN STATE CORRIDOR - ECONOMIC DEVELOPMENT AND INFRASTRUCTURE IMPROVEMENTS
FOWLER REGION

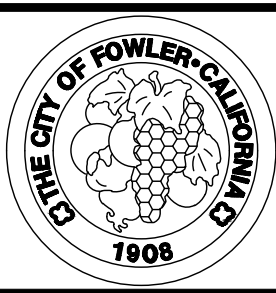


DEPARTMENT OF PUBLIC WORKS AND PLANNING		
DRAINAGE PLAN		
DRAWING NO. D-6	SHEET NO. 64	TOTAL 142

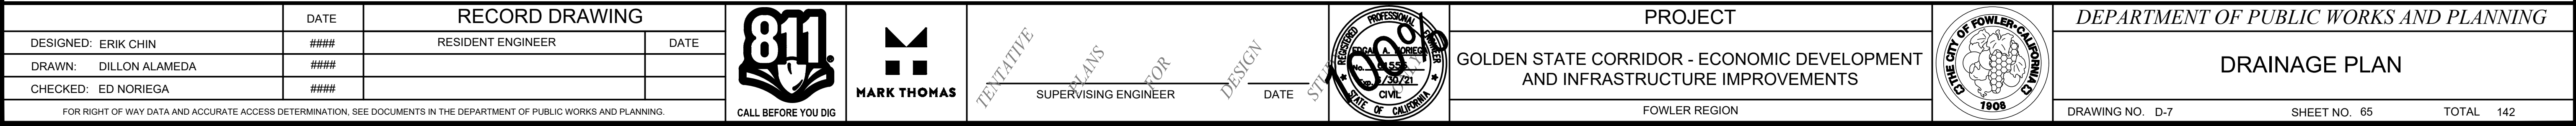


PLOT DATE: 4/2/2021 8:31:26 AM CAD USER: NYANES


PATH: J:\Fresno COG-FN-16105-GSB Final Design\CADD\Sheets\Region 3 - Fowler\GSB_R3_D8-D14.dwg

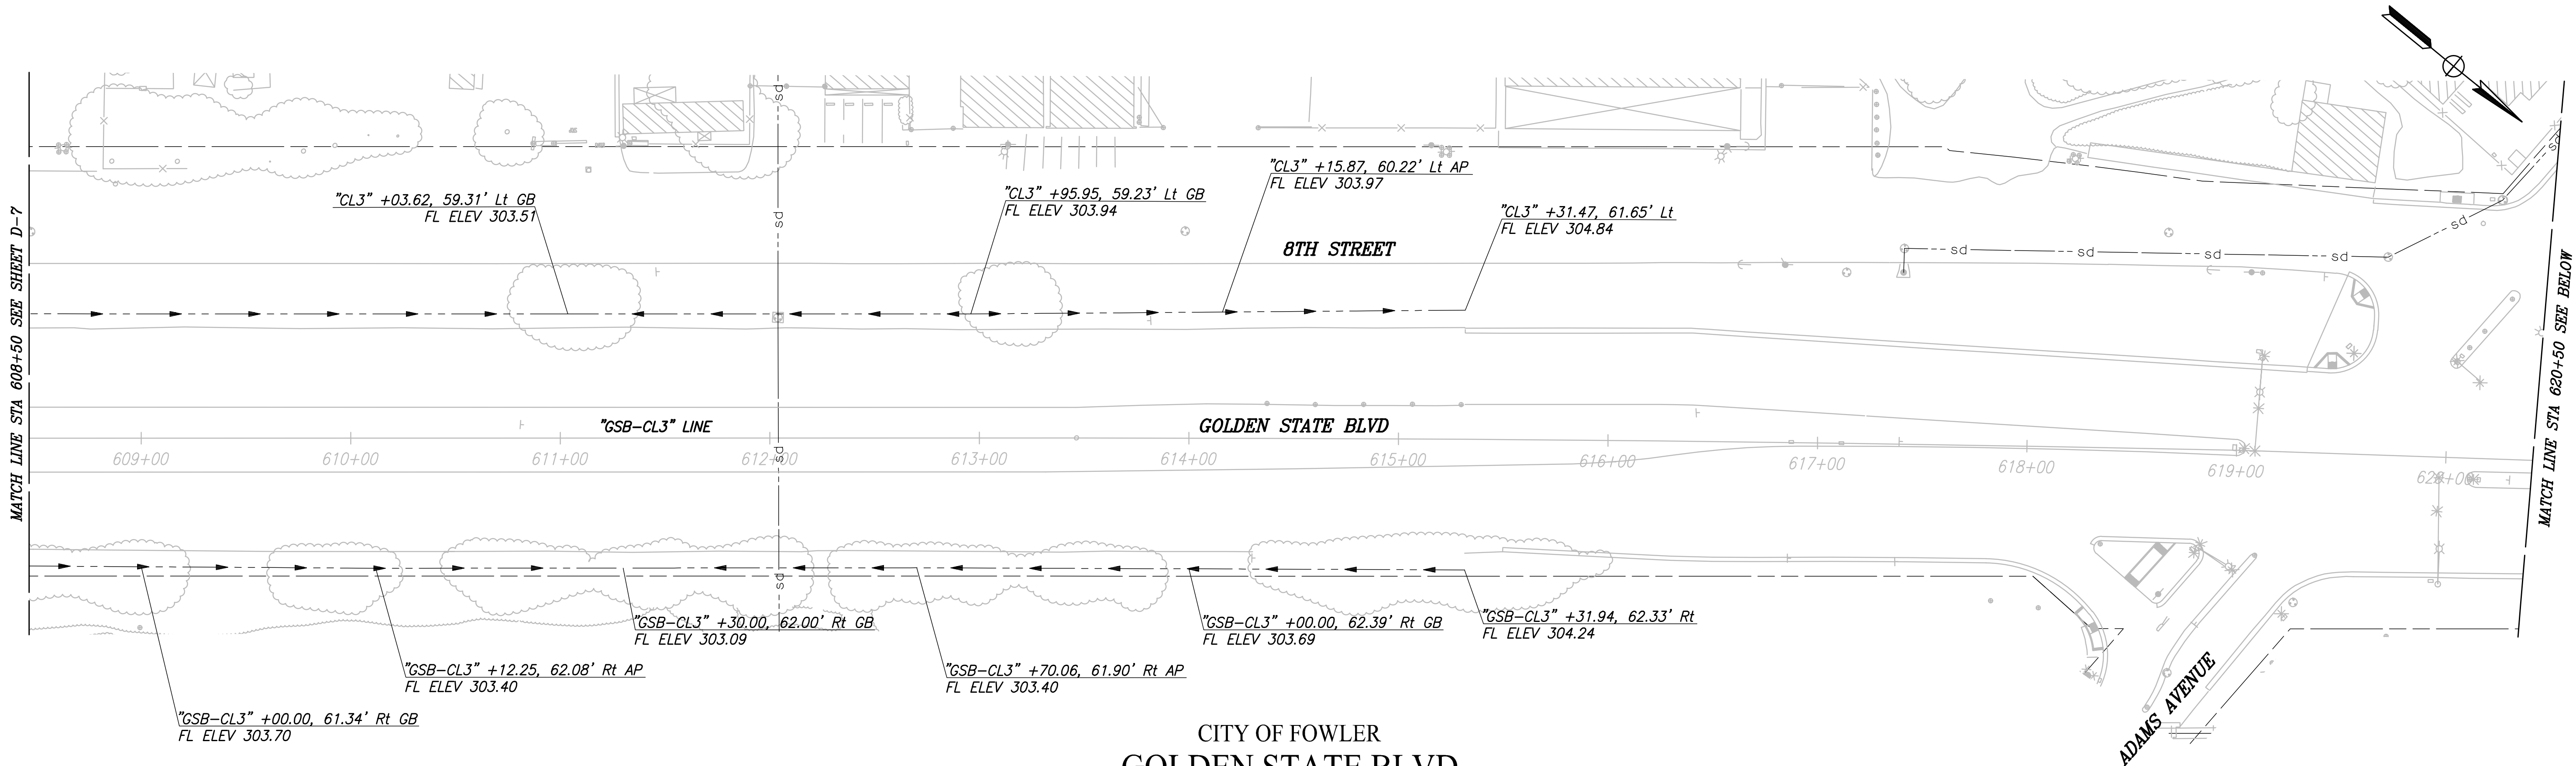

CITY OF FOWLER
GOLDEN STATE BLVD
SCALE: 1" = 40'

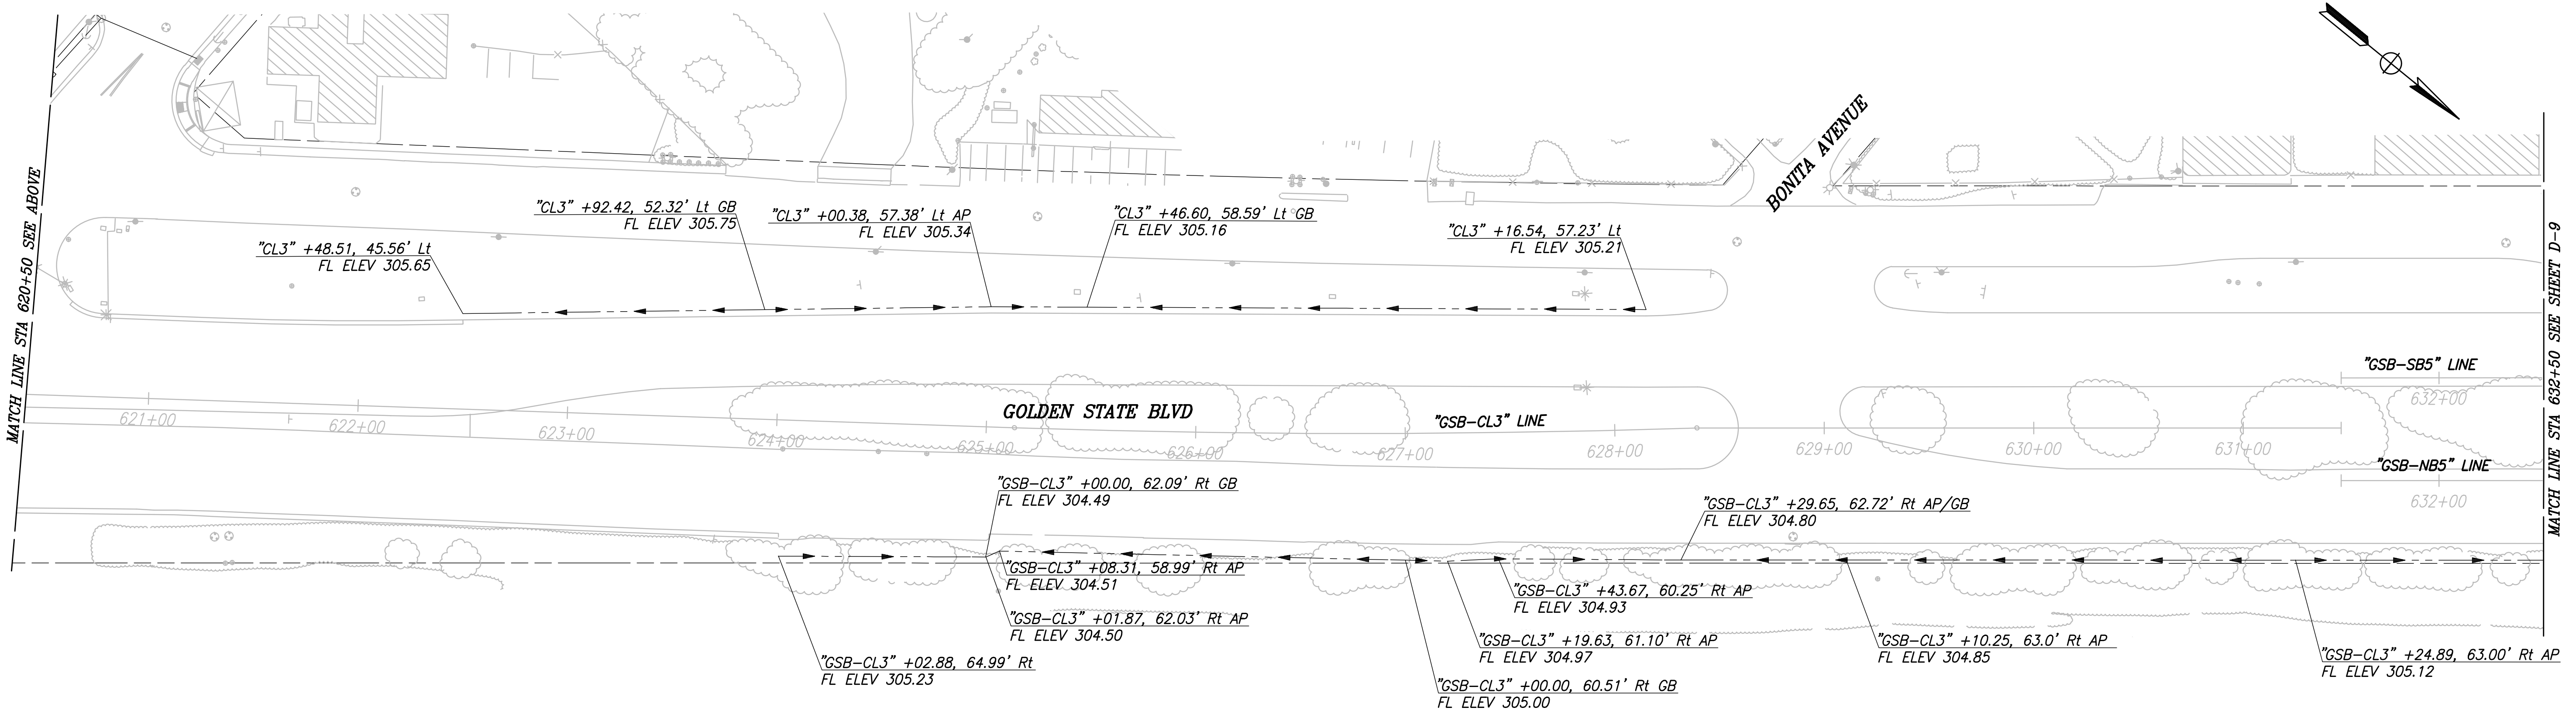

RECORD DRAWING			
DESIGNED: ERIK CHIN	DATE: ####	RESIDENT ENGINEER	DATE
DRAWN: DILLON ALAMEDA	DATE: ####		
CHECKED: ED NORIEGA	DATE: ####		
FOR RIGHT OF WAY DATA AND ACCURATE ACCESS DETERMINATION, SEE DOCUMENTS IN THE DEPARTMENT OF PUBLIC WORKS AND PLANNING.			

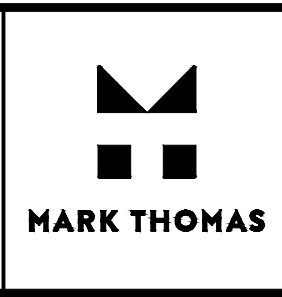

TENTATIVE PLANS FOR DESIGN

SUPERVISING ENGINEER


DATE



PROJECT

GOLDEN STATE CORRIDOR - ECONOMIC DEVELOPMENT AND INFRASTRUCTURE IMPROVEMENTS

FOWLER REGION

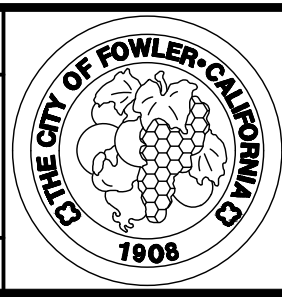

DEPARTMENT OF PUBLIC WORKS AND PLANNING

DRAINAGE PLAN


DRAWING NO. D-8



SHEET NO. 66

TOTAL 142

PLOT DATE: 4/2/2021 8:31:50 AM CAD USER: NYANES


PATH: J:\Fresno COG-FN-16105-GSB Final Design\CADD\Sheets\Region 3 - Fowler\GSB_R3_D8-D14.dwg

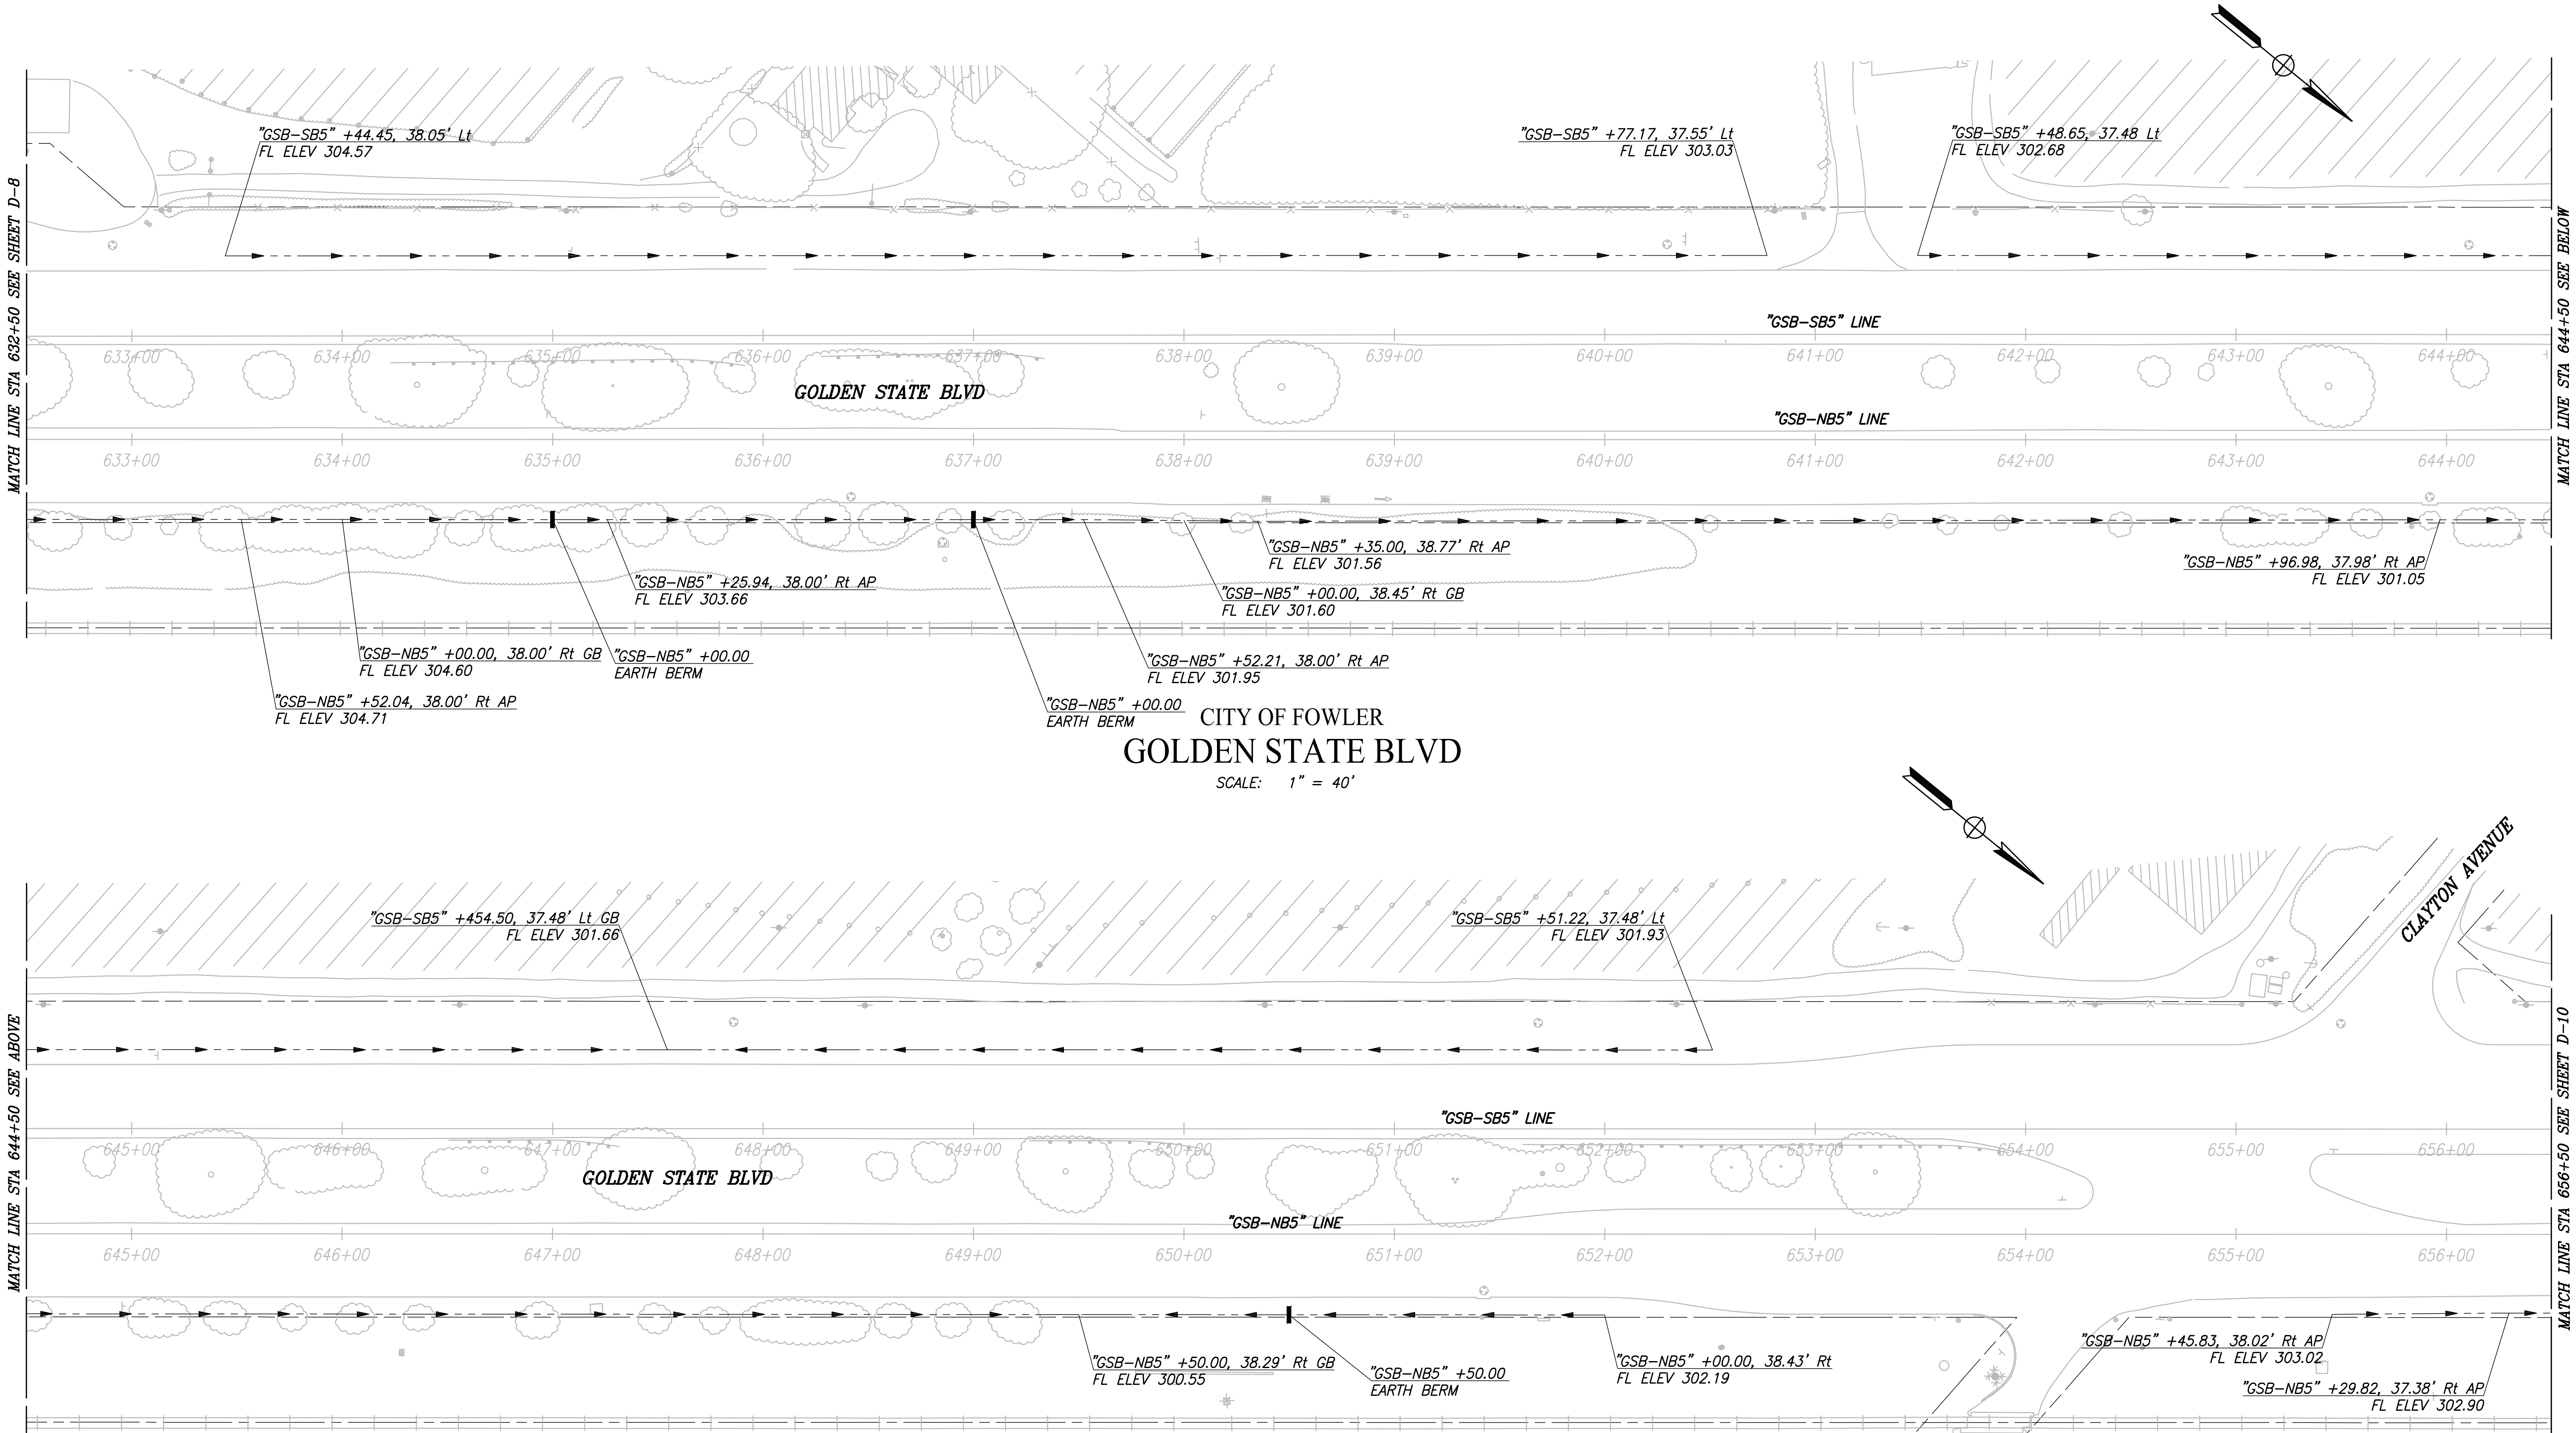

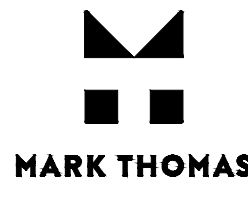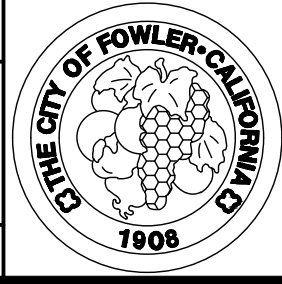
DESIGNED: ERIK CHIN		DATE	RECORD DRAWING	
DRAWN: DILLON ALAMEDA		####	RESIDENT ENGINEER	DATE
CHECKED: ED NORIEGA		####		
FOR RIGHT OF WAY DATA AND ACCURATE ACCESS DETERMINATION, SEE DOCUMENTS IN THE DEPARTMENT OF PUBLIC WORKS AND PLANNING.				
				
CALL BEFORE YOU DIG		TENTATIVE PLANS FOR DESIGN		DATE
SUPERVISING ENGINEER		PROJECT		
		GOLDEN STATE CORRIDOR - ECONOMIC DEVELOPMENT AND INFRASTRUCTURE IMPROVEMENTS		
		FOWLER REGION		
		DEPARTMENT OF PUBLIC WORKS AND PLANNING		
		DRAINAGE PLAN		
DRAWING NO. D-9		SHEET NO. 67		TOTAL 142

PLOT DATE: 4/2/2021 8:32:11 AM
 CAD USER: NYANES

PATH: J:\Fresno COG-FN-16105-GSB Final Design\CADD\Sheets\Region 3 - Fowler\GSB_R3_D8-D14.dwg

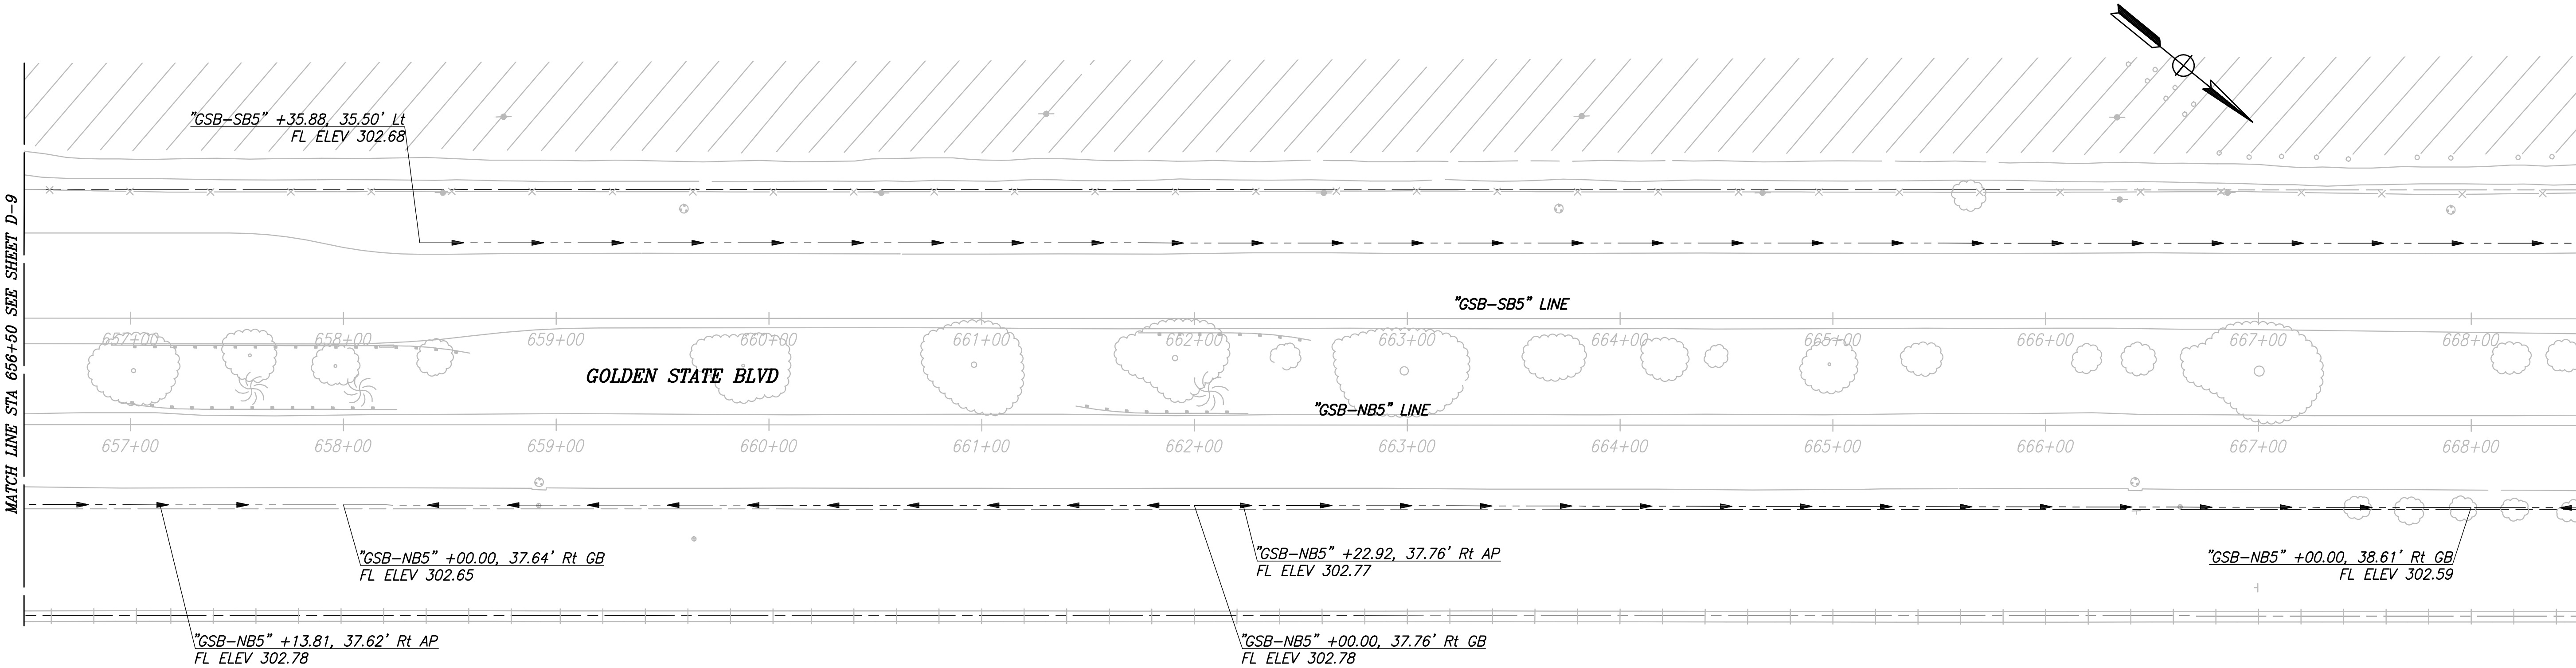

CITY OF FOWLER
 GOLDEN STATE BLVD
 SCALE: 1" = 40'

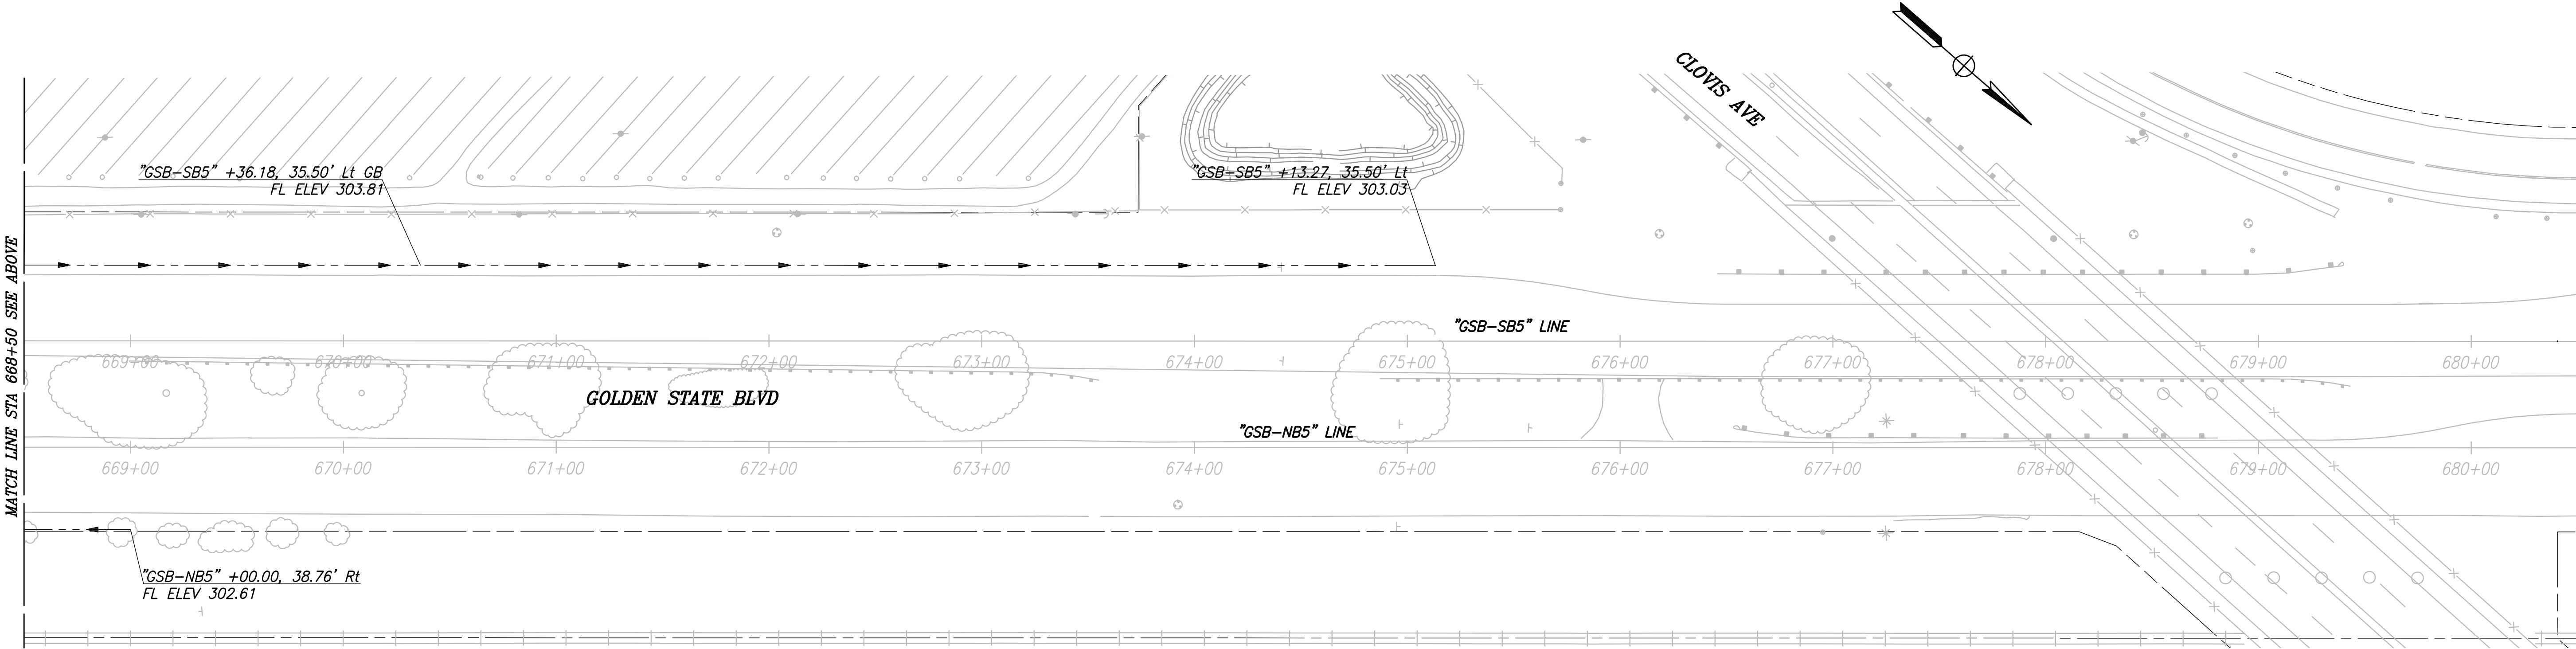

	DATE	RECORD DRAWING	
DESIGNED: ERIK CHIN	####	RESIDENT ENGINEER	DATE
DRAWN: DILLON ALAMEDA	####		
CHECKED: ED NORIEGA	####		


FOR RIGHT OF WAY DATA AND ACCURATE ACCESS DETERMINATION, SEE DOCUMENTS IN THE DEPARTMENT OF PUBLIC WORKS AND PLANNING.



TENTATIVE PLANS FOR DESIGN	
SUPERVISING ENGINEER	DATE




PROJECT
GOLDEN STATE CORRIDOR - ECONOMIC DEVELOPMENT AND INFRASTRUCTURE IMPROVEMENTS
FOWLER REGION

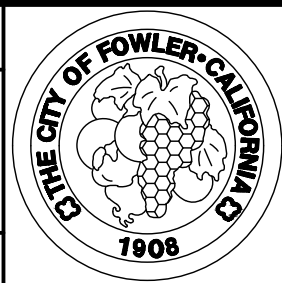

DEPARTMENT OF PUBLIC WORKS AND PLANNING		
DRAINAGE PLAN		
DRAWING NO. D-10	SHEET NO. 68	TOTAL 142


PLOT DATE: 4/2/2021 8:32:34 AM CAD USER: NYANES

PATH: J:\Fresno COG-FN-16105-GSB Final Design\CADD\Sheets\Region 3 - Fowler\GSB_R3_D8-D14.dwg

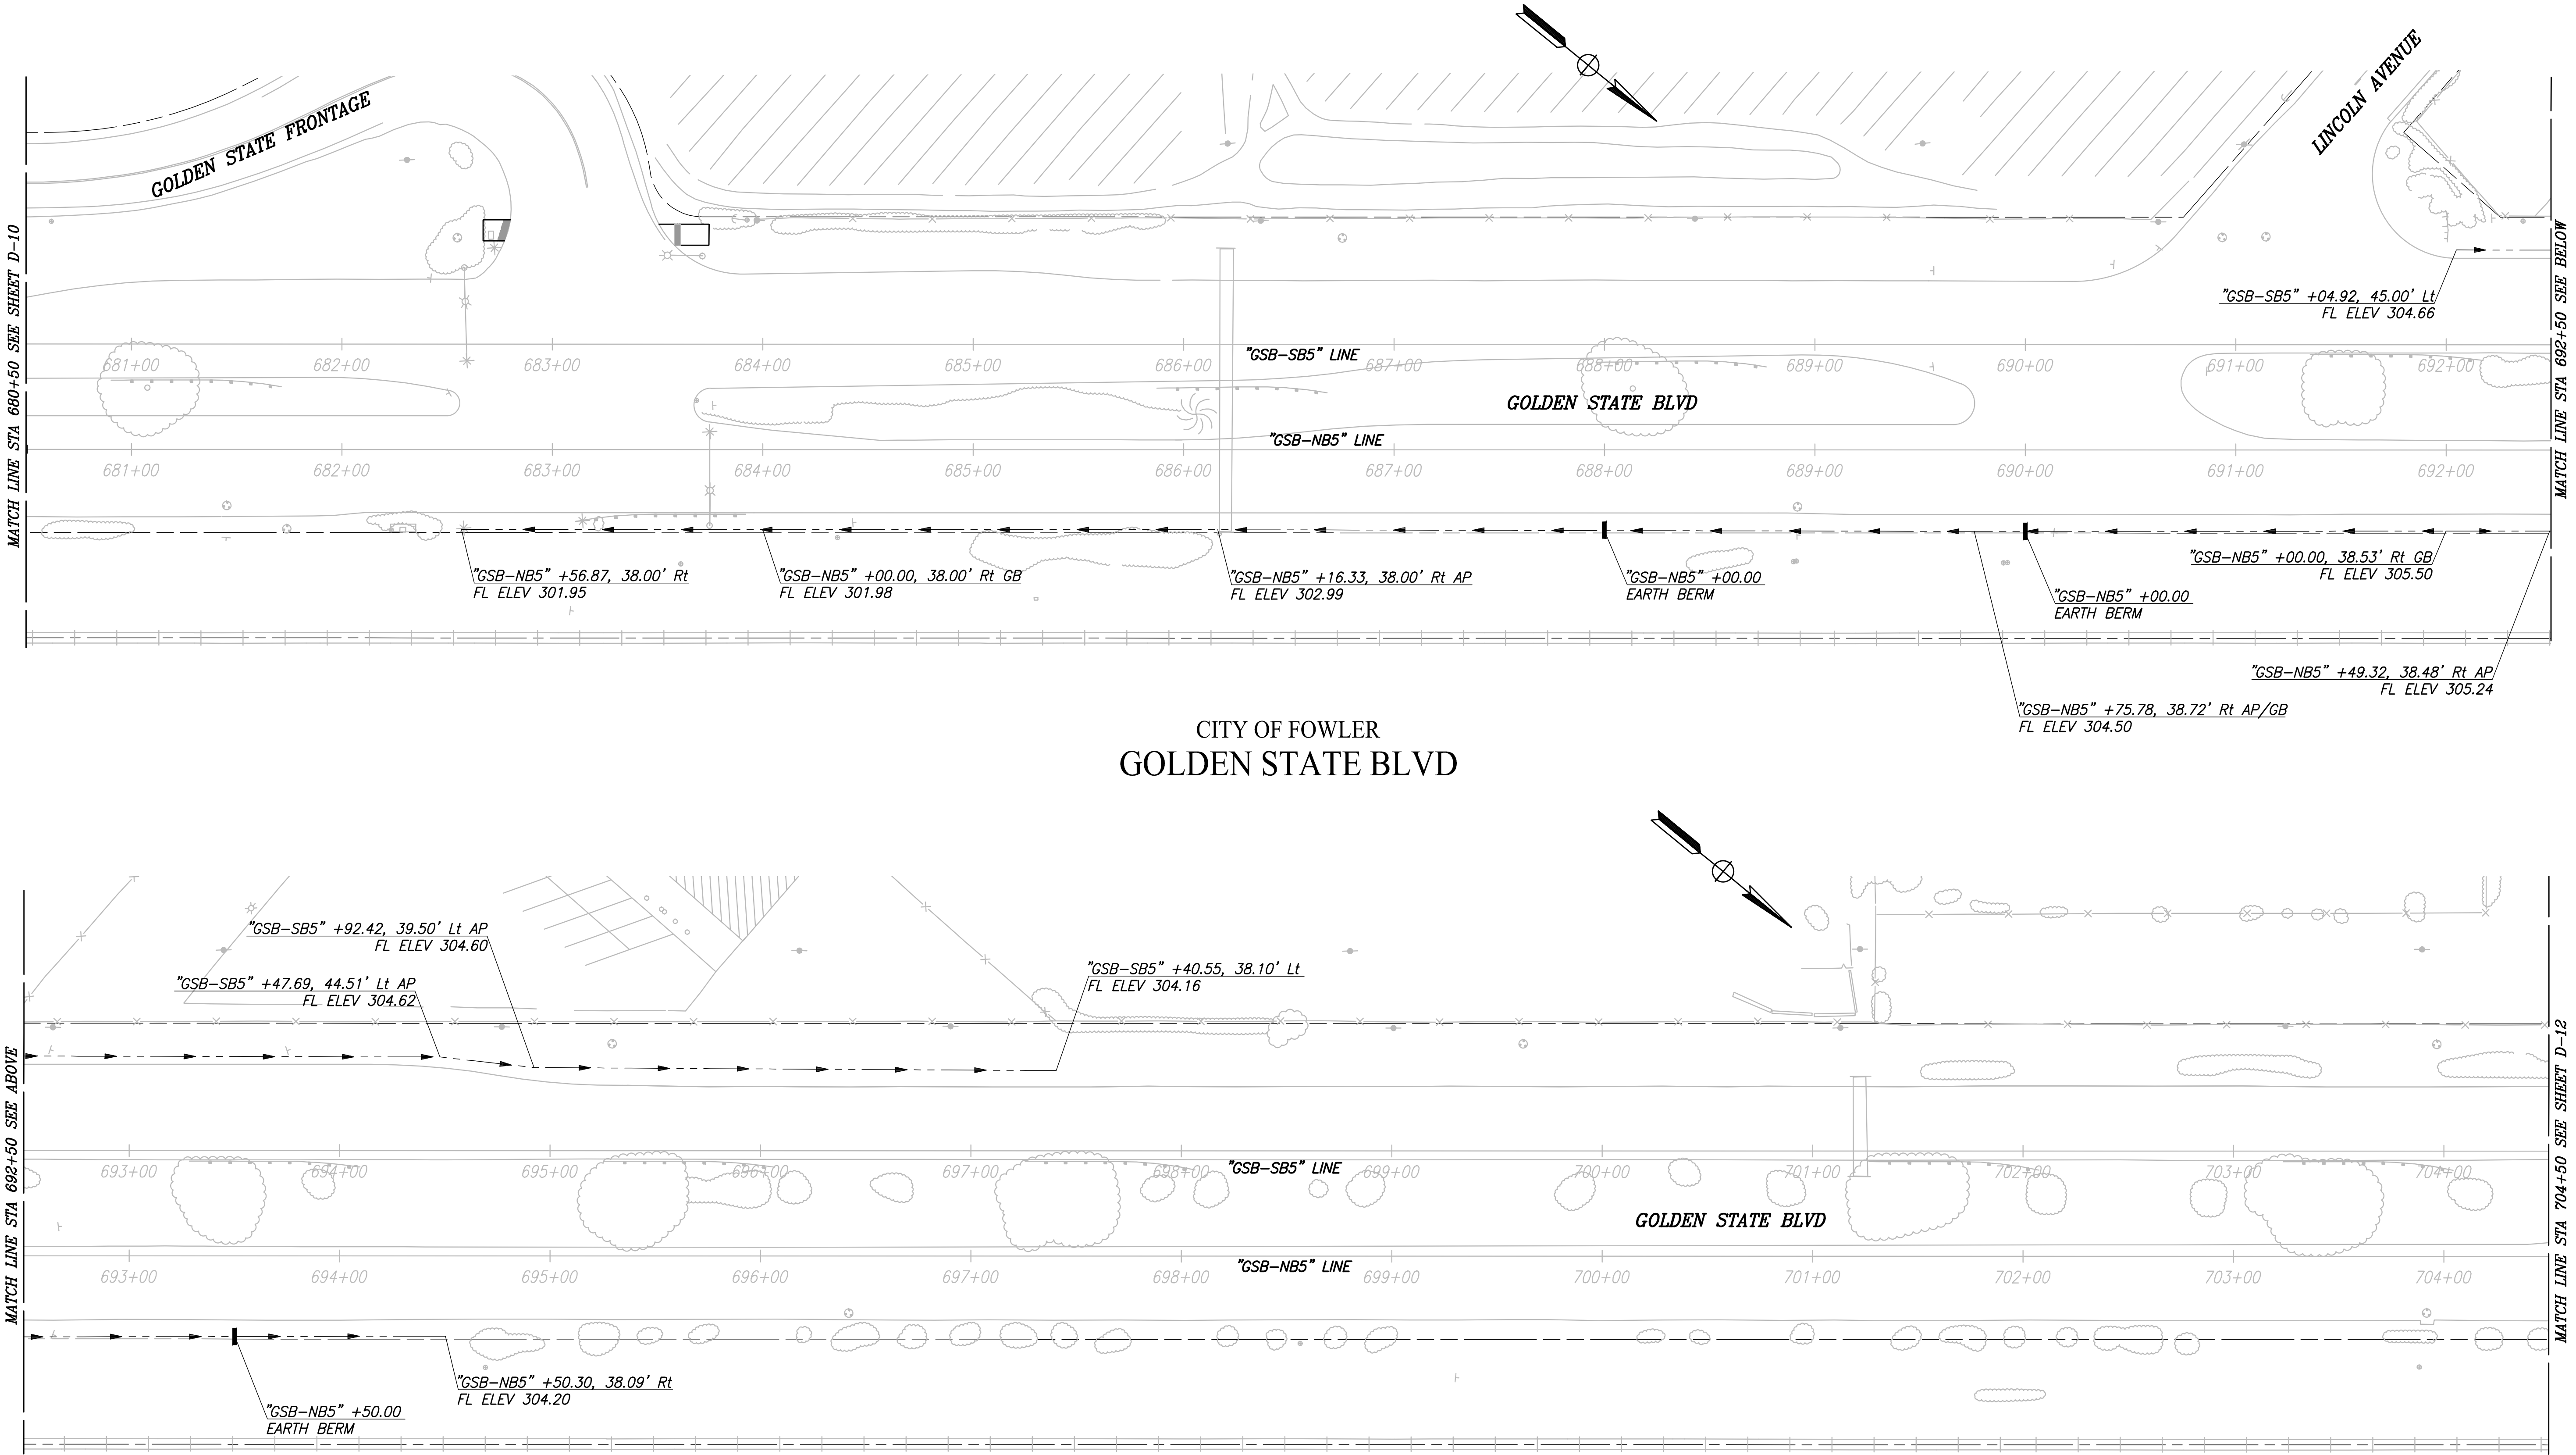

RECORD DRAWING	
DESIGNED: ERIK CHIN	DATE: ####
DRAWN: DILLON ALAMEDA	DATE: ####
CHECKED: ED NORIEGA	DATE: ####


FOR RIGHT OF WAY DATA AND ACCURATE ACCESS DETERMINATION, SEE DOCUMENTS IN THE DEPARTMENT OF PUBLIC WORKS AND PLANNING.

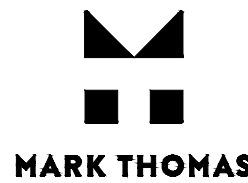

TENTATIVE PLANS FOR DESIGN	
SUPERVISING ENGINEER	DATE




PROJECT
GOLDEN STATE CORRIDOR - ECONOMIC DEVELOPMENT AND INFRASTRUCTURE IMPROVEMENTS
FOWLER REGION

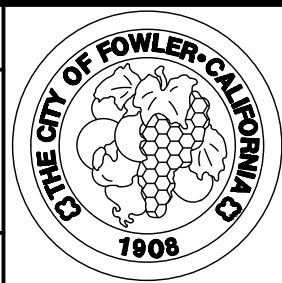

DEPARTMENT OF PUBLIC WORKS AND PLANNING		
DRAINAGE PLAN		
DRAWING NO. D-11	SHEET NO. 69	TOTAL 142

PLOT DATE: 4/2/2021 8:33:00 AM CAD USER: NYANES

PATH: J:\Fresno COG-FN-16105-GSB Final Design\CADD\Sheets\Region 3 - Fowler\GSB_R3_D8-D14.dwg

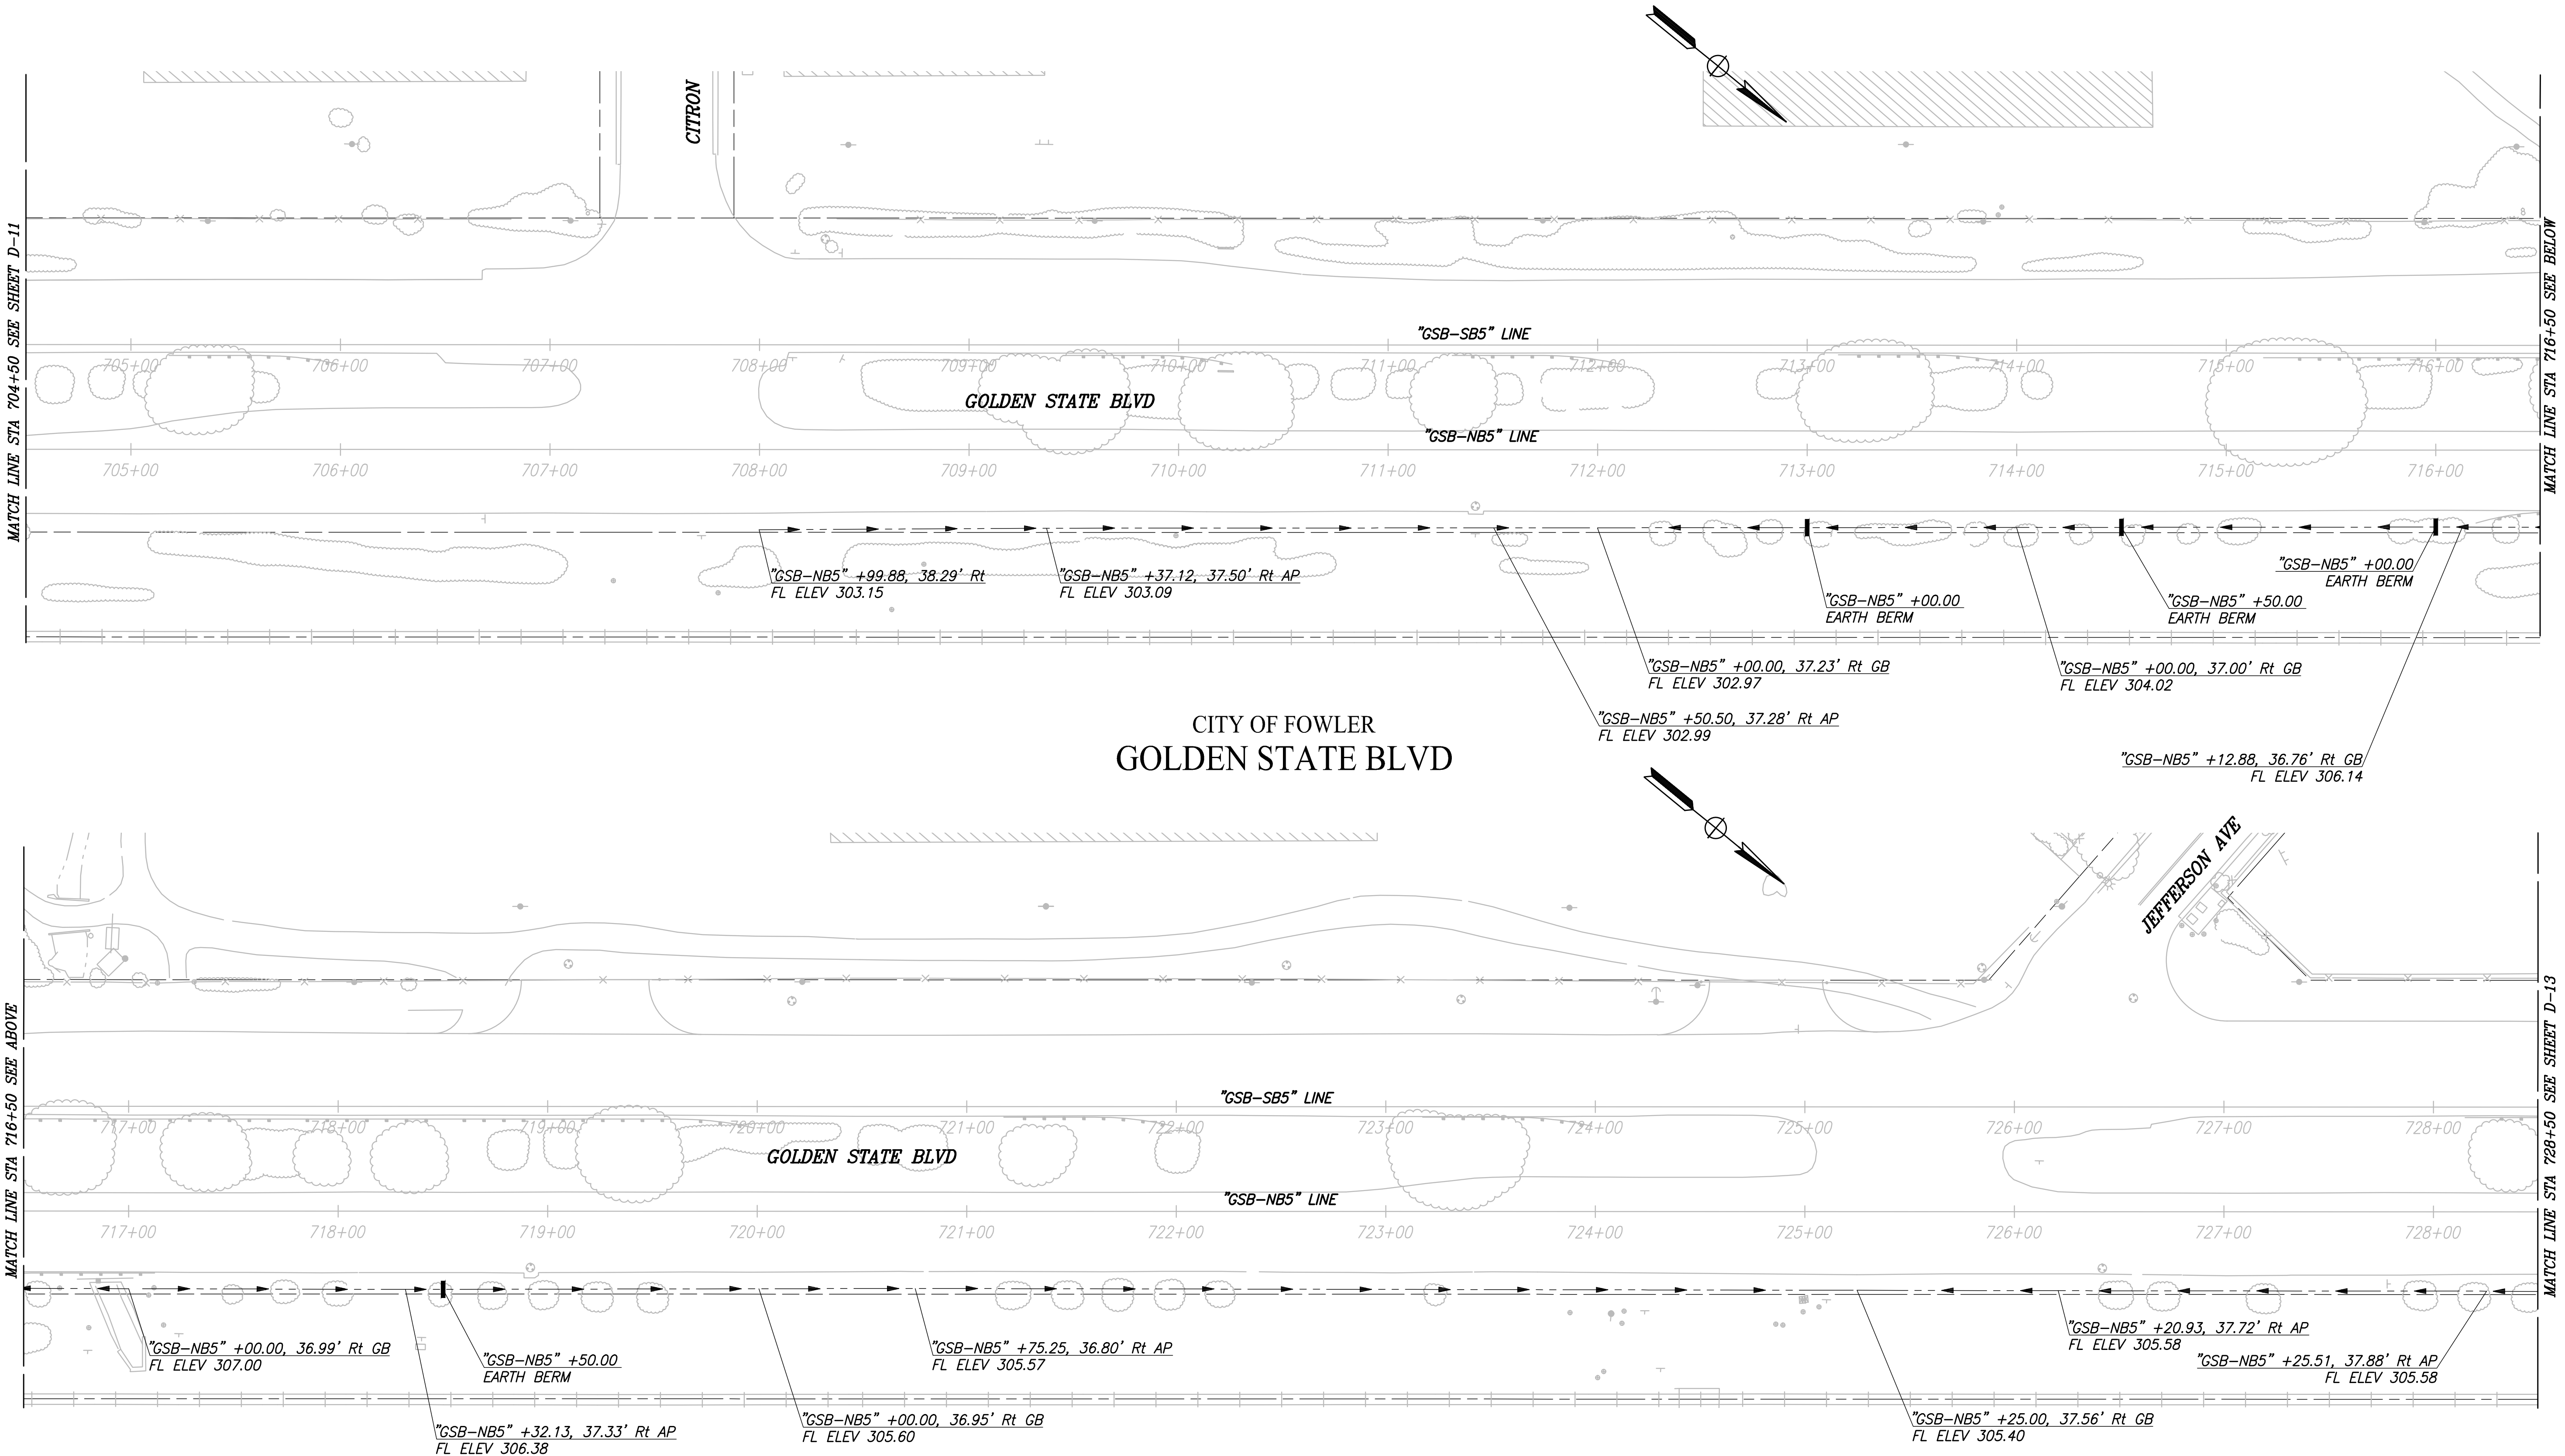

CITY OF FOWLER
GOLDEN STATE BLVD

RECORD DRAWING			
DESIGNED: ERIK CHIN	DATE: ####	RESIDENT ENGINEER	DATE
DRAWN: DILLON ALAMEDA	####		
CHECKED: ED NORIEGA	####		


FOR RIGHT OF WAY DATA AND ACCURATE ACCESS DETERMINATION, SEE DOCUMENTS IN THE DEPARTMENT OF PUBLIC WORKS AND PLANNING.



TENTATIVE PLANS FOR DESIGN	
SUPERVISING ENGINEER	DATE




PROJECT	
GOLDEN STATE CORRIDOR - ECONOMIC DEVELOPMENT AND INFRASTRUCTURE IMPROVEMENTS	
FOWLER REGION	

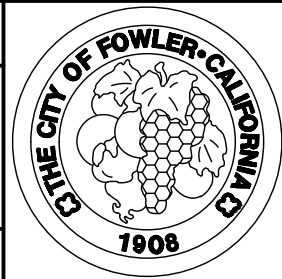

DEPARTMENT OF PUBLIC WORKS AND PLANNING		
DRAINAGE PLAN		
DRAWING NO. D-12	SHEET NO. 70	TOTAL 142

PLOT DATE: 4/2/2021 8:33:14 AM
 CAD USER: NYANES

PATH: J:\Fresno COG-FN-16105-GSB Final Design\CADD\Sheets\Region 3 - Fowler\GSB_R3_D8-D14.dwg

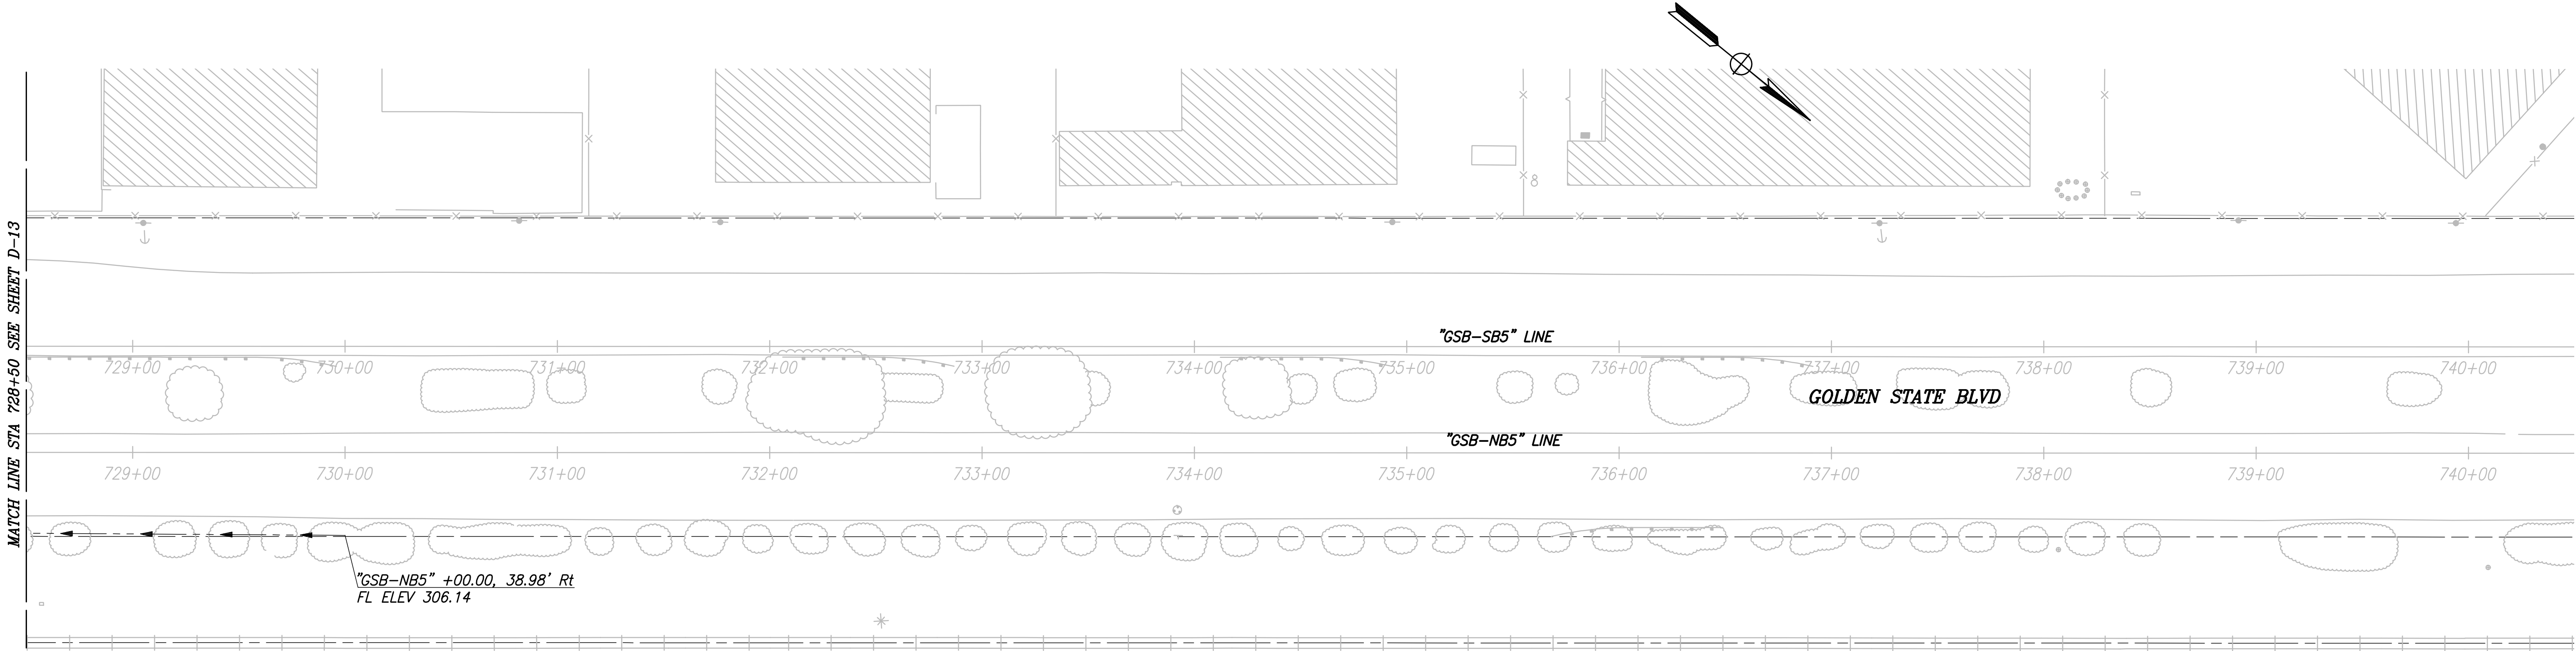

CITY OF FOWLER
 GOLDEN STATE BLVD
 SCALE: 1" = 40'

	DATE	RECORD DRAWING	
DESIGNED: ERIK CHIN	####	RESIDENT ENGINEER	DATE
DRAWN: DILLON ALAMEDA	####		
CHECKED: ED NORIEGA	####		


FOR RIGHT OF WAY DATA AND ACCURATE ACCESS DETERMINATION, SEE DOCUMENTS IN THE DEPARTMENT OF PUBLIC WORKS AND PLANNING.





TENTATIVE PLANS FOR DESIGN	
SUPERVISING ENGINEER	DATE




PROJECT
GOLDEN STATE CORRIDOR - ECONOMIC DEVELOPMENT AND INFRASTRUCTURE IMPROVEMENTS
FOWLER REGION

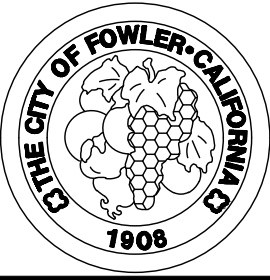

DEPARTMENT OF PUBLIC WORKS AND PLANNING		
DRAINAGE PLAN		
DRAWING NO. D-13	SHEET NO. 71	TOTAL 142

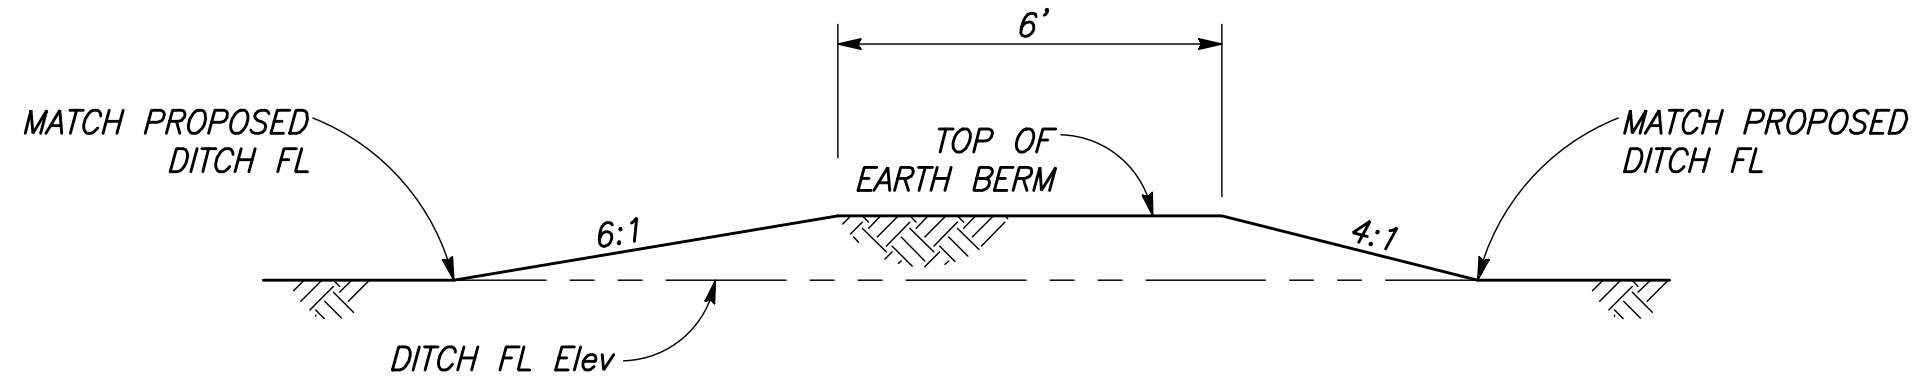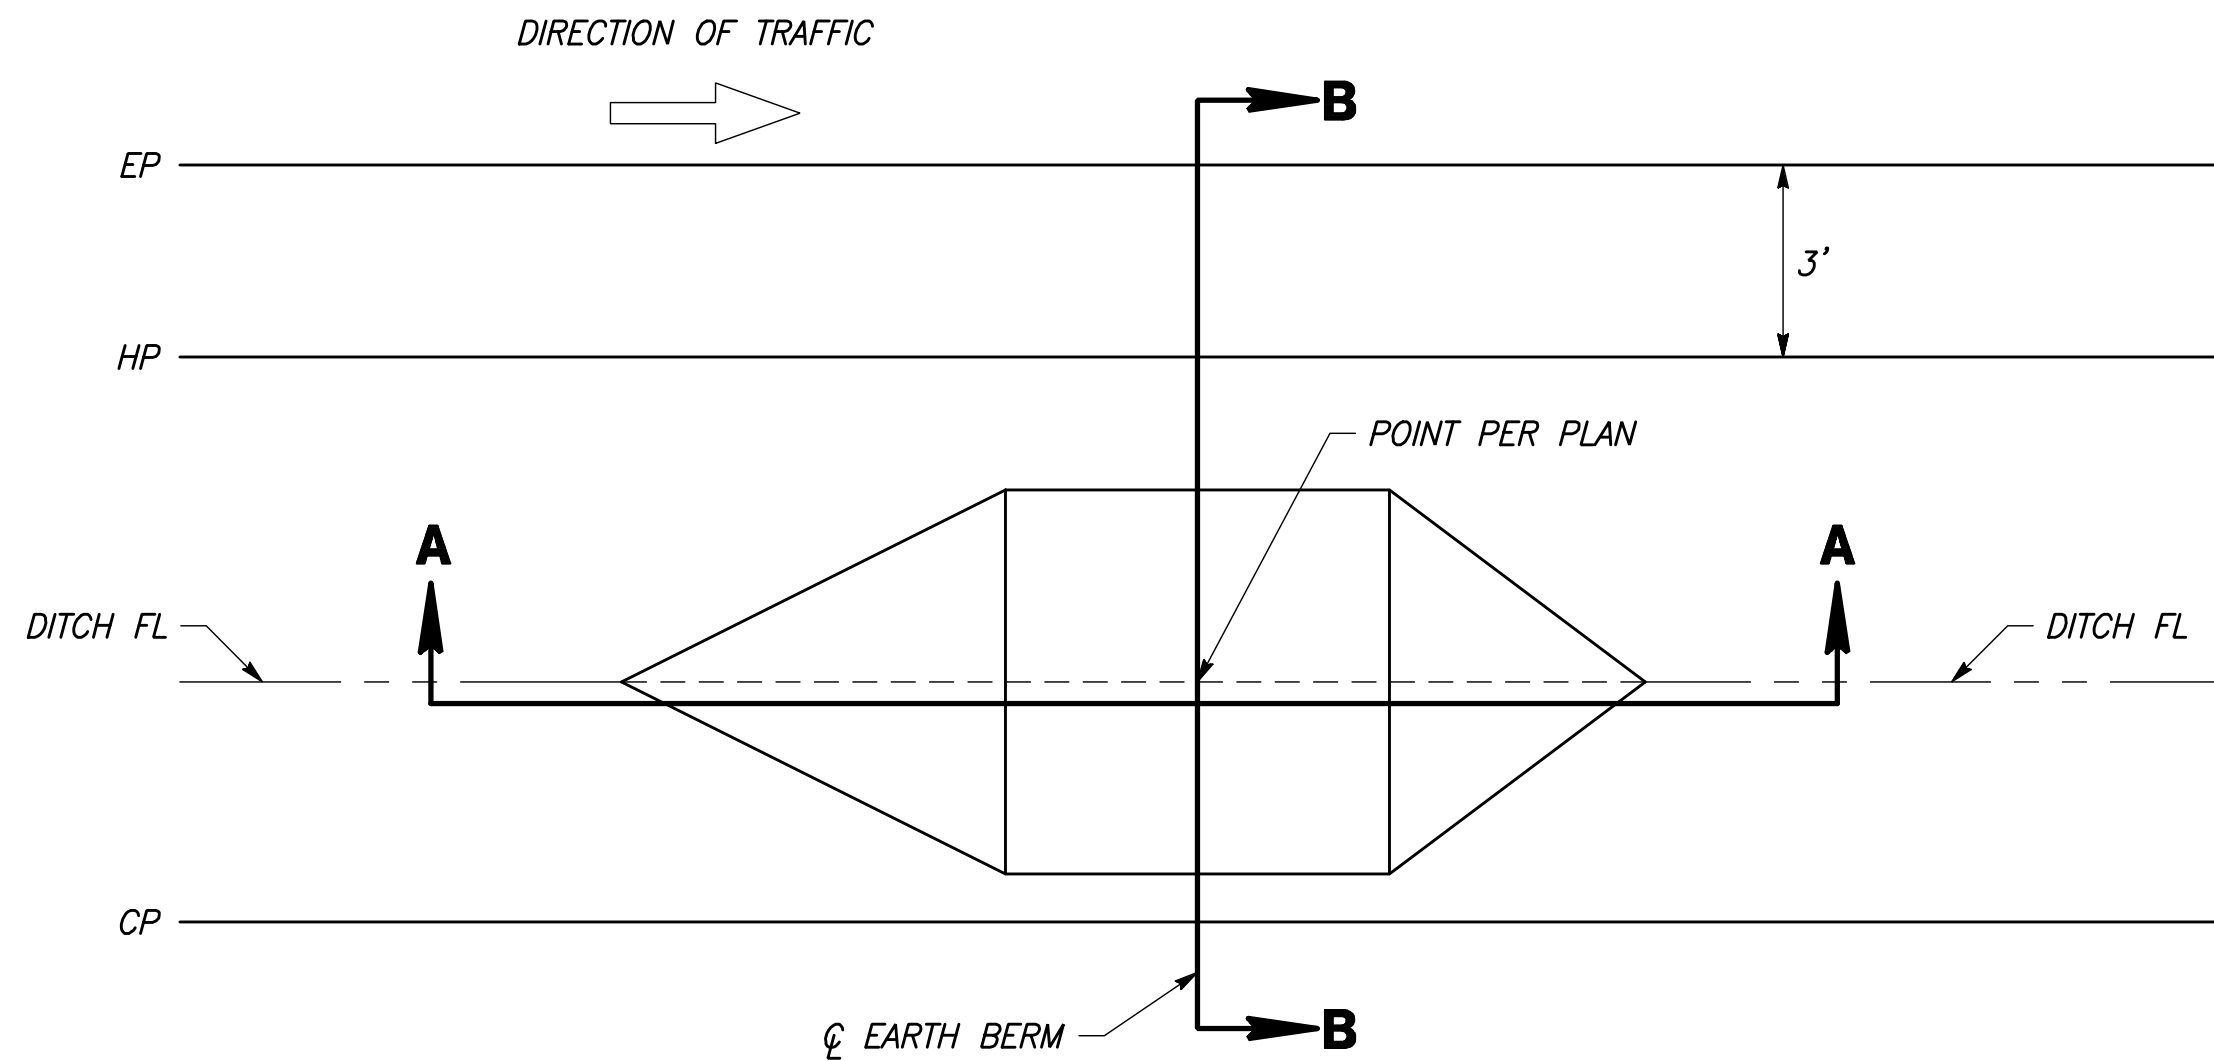


SECTION A-A

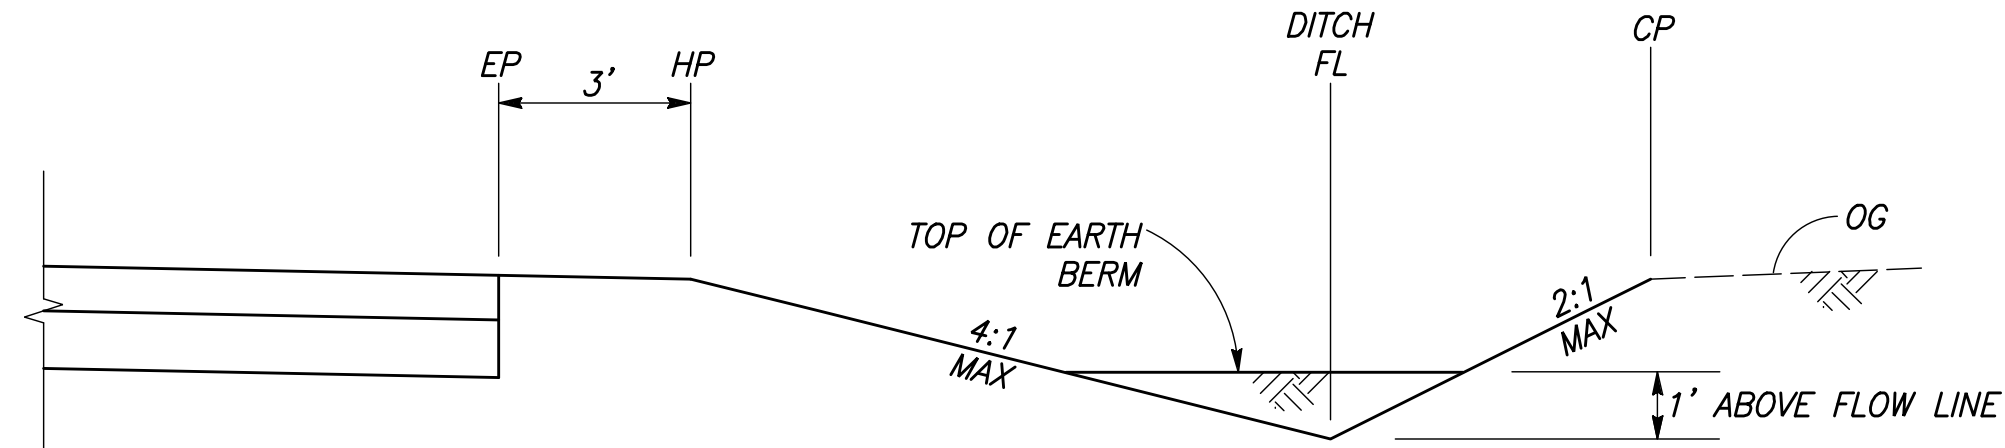

SECTION B-B


EARTH BERM

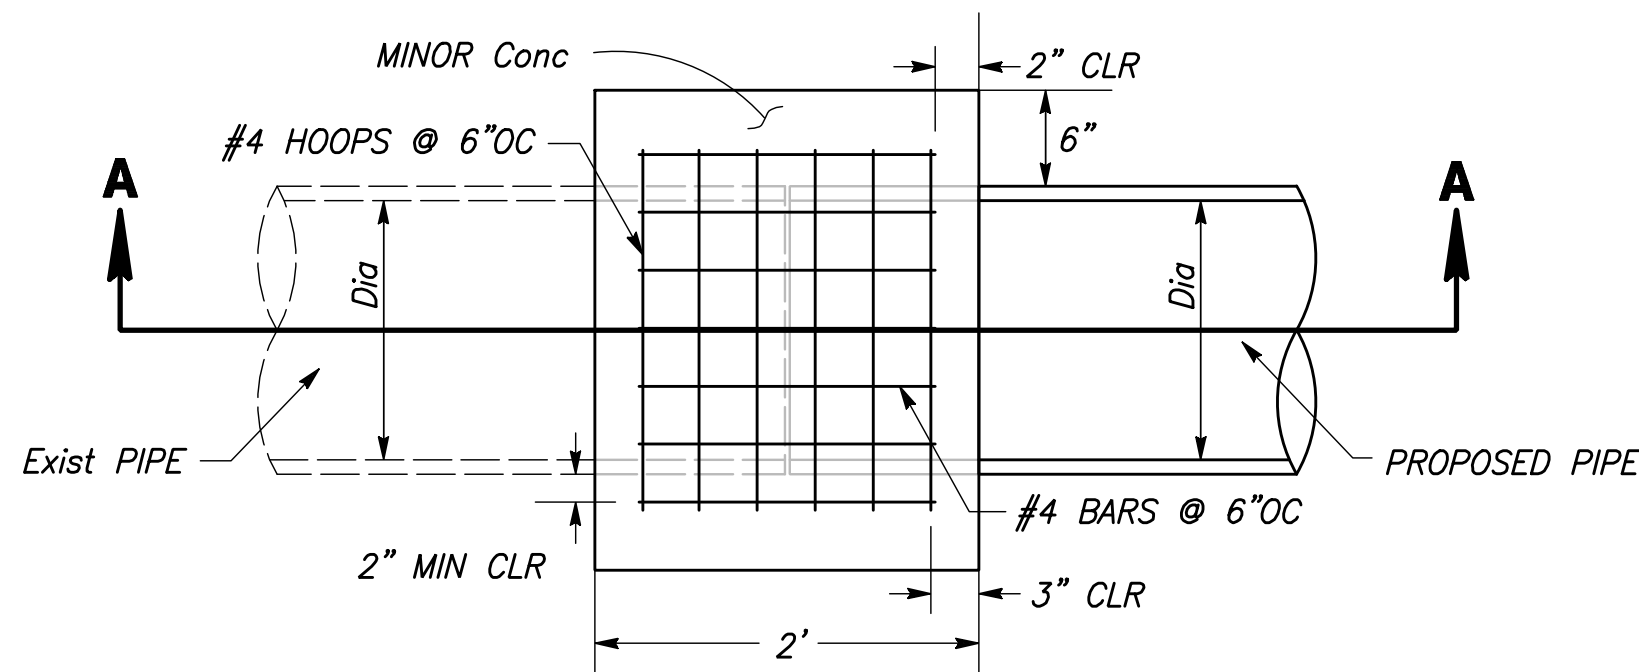

PLAN


NOTES:

1. JOIN PIPES AT INVERTS.

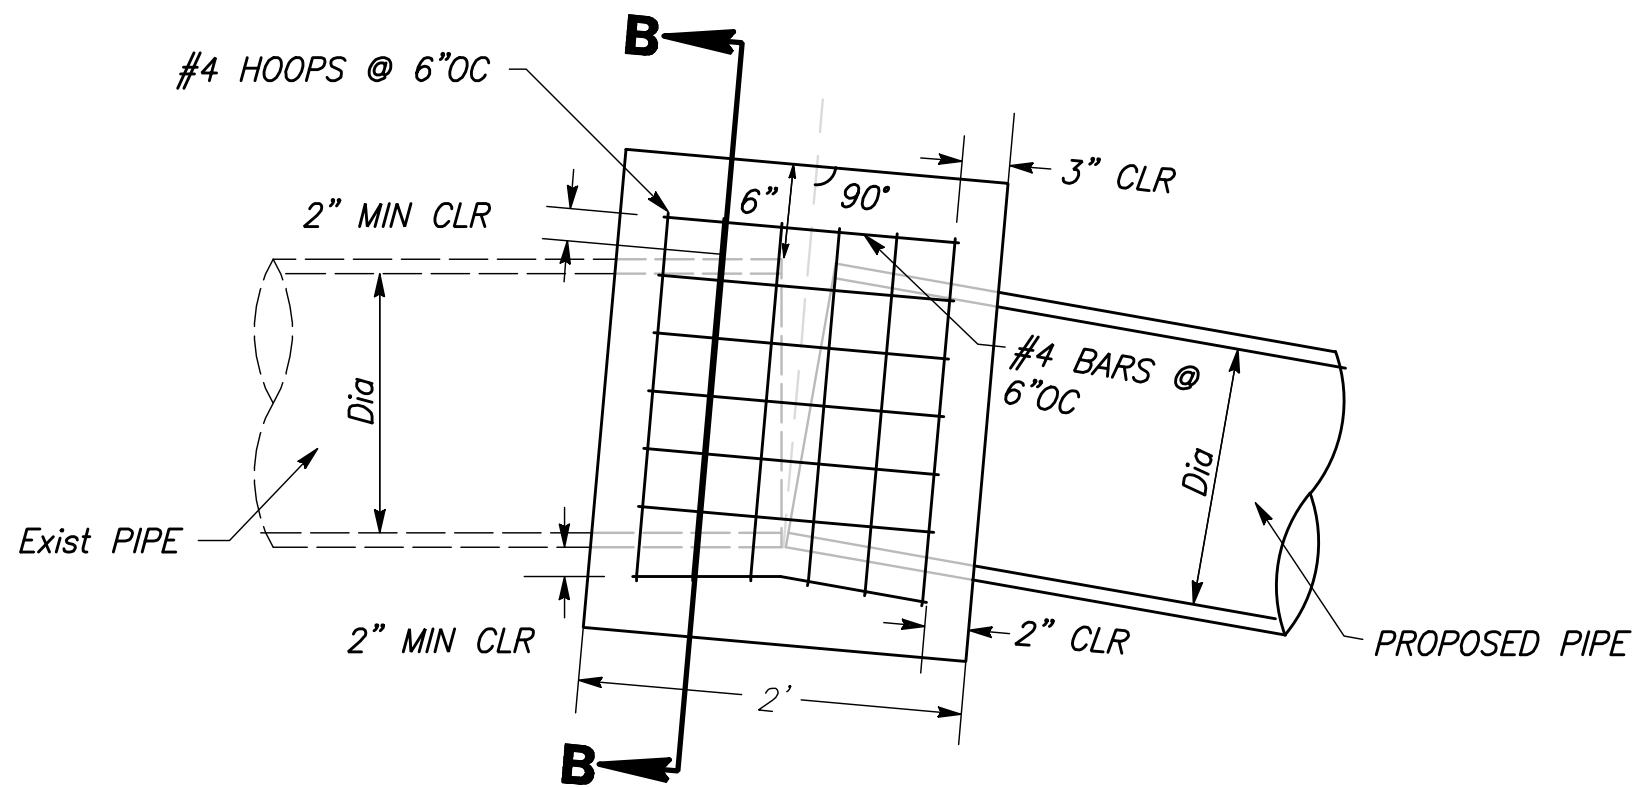

SECTION A-A


CONCRETE COLLAR

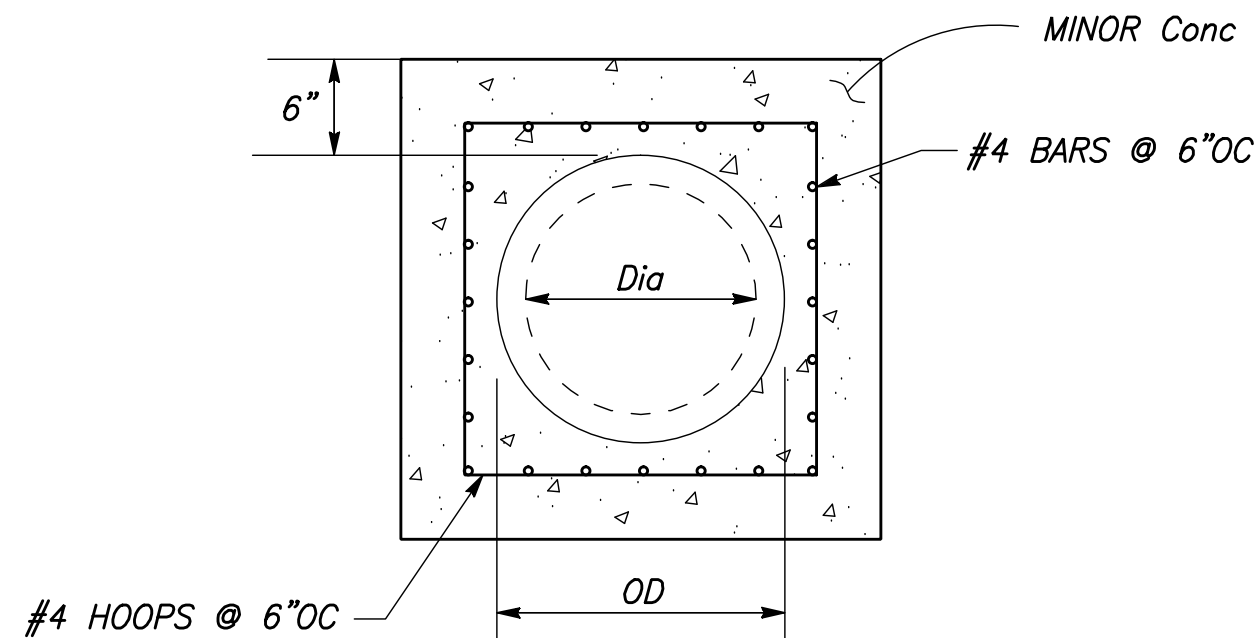

SECTION B-B

DESIGNED:	DATE	RECORD DRAWING	
ERIK CHIN	####	RESIDENT ENGINEER	DATE
DRAWN:	####		
DILLON ALAMEDA	####		
CHECKED:	####		
ED NORIEGA	####		


FOR RIGHT OF WAY DATA AND ACCURATE ACCESS DETERMINATION, SEE DOCUMENTS IN THE DEPARTMENT OF PUBLIC WORKS AND PLANNING.

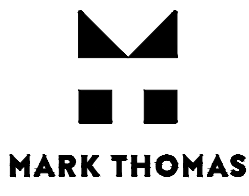

TENTATIVE PLANS FOR DESIGN	
SUPERVISING ENGINEER	DATE



PROJECT
GOLDEN STATE CORRIDOR - ECONOMIC DEVELOPMENT AND INFRASTRUCTURE IMPROVEMENTS
FOWLER REGION

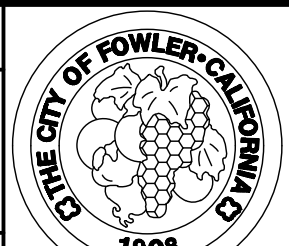

DEPARTMENT OF PUBLIC WORKS AND PLANNING		
DRAINAGE PLAN		
DRAWING NO. DD-1	SHEET NO. 72	TOTAL 142


PATH: J:\Fresno COG-FN-16105-GSB Final Design\CADD\Sheets\Region 3 - Fowler\GSB_R3_U1-U7.dwg
PLOT DATE: 4/2/2021 8:35:10 AM
CAD USER: NYANES

LEGEND	
—e—(oh)—	(E)ELECTRIC OVERHEAD
—g—	(E)GAS
---s---	(E)SEWER
---sd---	(E)STORM DRAIN
—w—	(E)WATER
—t—	(E)TELECOM
—fo—	(E)FIBER OPTIC
—irr—	(E)IRRIGATION

ABBREVIATIONS	
ATT	AMERICAN TELEPHONE AND TELEGRAPH
COF	CITY OF FOWLER
COK	CITY OF KINGSBERG
COS	CITY OF SELMA
FO	FIBER OPTIC
IRR	IRRIGATION
NATGAS	NATURAL GAS
OH	OVER HEAD
PGE	PACIFIC GAS AND ELECTRIC
SD	STORM DRAIN
STA	STATION
TELECOM	TELEPHONE COMMUNICATION
UG	UNDERGROUND
(E)	EXISTING
(P)	PROPOSED

UTILITY NOTES:	
1	ADJUST (E) WATER VALVE TO GRADE
2	ADJUST (E) STORM DRAIN MH TO GRADE
3	ADJUST (E) SEWER MH TO GRADE
4	ADJUST (E) COMM MH TO GRADE


- NOTES
1. THE CONTRACTOR SHALL BE RESPONSIBLE FOR CONTACTING THE RESPECTIVE UTILITY COMPANIES 48 HOURS PRIOR TO WORKING AROUND ANY OF THEIR UNDERGROUND UTILITIES FOR VERIFICATION AT THE SITE OF ANY POSSIBLE CONFLICTS WITH THE PROPOSED IMPROVEMENTS SHOWN ON THESE PLANS.
 2. THE TYPES, LOCATIONS, SIZES, AND DEPTHS OF EXISTING UNDERGROUND UTILITIES SHOWN ON THESE PLANS WERE OBTAINED FROM SOURCES OF VARYING RELIABILITY. THE CONTRACTOR IS CAUTIONED THAT ONLY ACTUAL EXCAVATION WILL REVEAL THE TYPES, EXTENT, SIZES, LOCATIONS, AND DEPTHS OF SUCH UNDERGROUND UTILITIES. THE CITY OF SELMA AND ITS CONSULTANT, MARK THOMAS & COMPANY INC., CAN NOT ASSUME THE RESPONSIBILITY FOR THE COMPLETENESS OR ACCURACY OF THE DELINEATION OF SUCH UTILITIES NOR THE EXISTENCE OF OTHER BURIED OBJECTS OF SUCH UNDERGROUND UTILITIES WHICH MAY BE ENCOUNTERED BUT WHICH ARE NOT SHOWN ON THESE PLANS.
 3. FOR UTILITY CONTACT INFORMATION SEE SHEET G-1.
 4. ALL UTILITY MANHOLE AND VAULT COVERS THAT REQUIRE ADJUSTMENT DUE TO CHANGES IN GRADE DURING CONSTRUCTION SHALL BE DONE IN COMPLIANCE OF THE CITY OF SELMA STANDARDS AND REQUIREMENTS.
 5. ALL UTILITIES, UTILITY POLES, UTILITY MANHOLES, OR ANY OTHER FACILITIES ASSOCIATED WITH A PUBLIC OR PRIVATE UTILITY OWNER REPRESENTED ON THESE PLANS SHALL BE CONSIDERED "TO REMAIN" UNLESS INDICATED OTHERWISE.

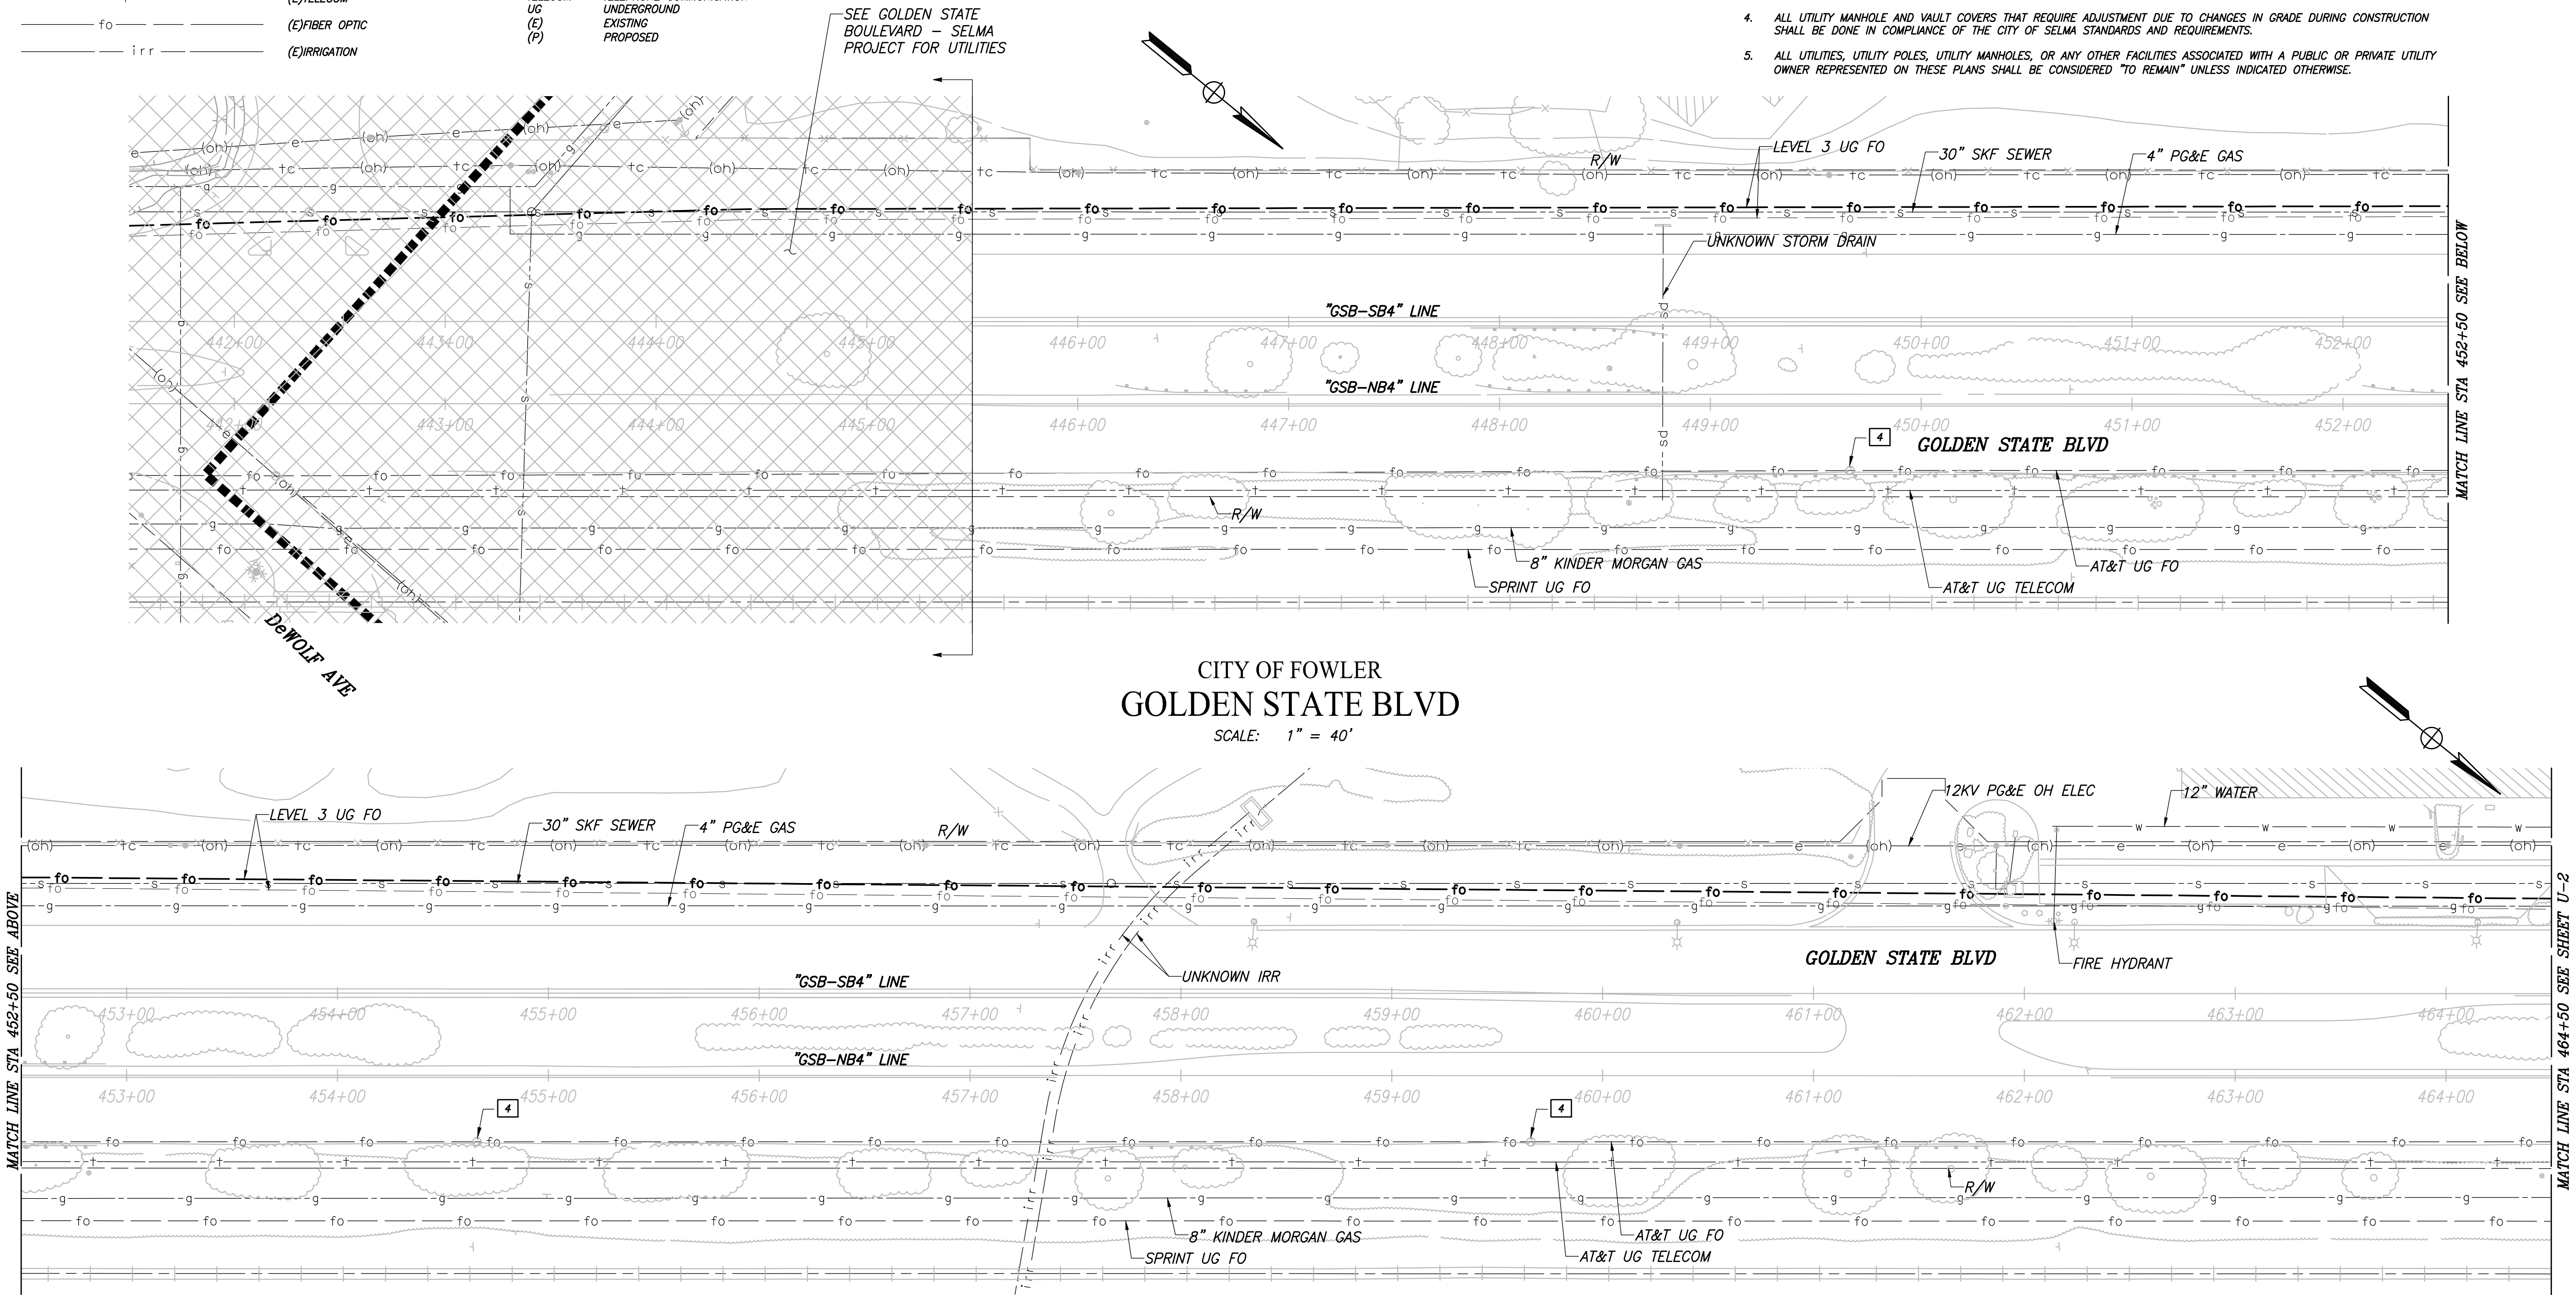


DESIGNED: ERIK CHIN		DATE	RECORD DRAWING	
DRAWN: DILLON ALAMEDA		####	RESIDENT ENGINEER	DATE
CHECKED: ED NORIEGA		####		
FOR RIGHT OF WAY DATA AND ACCURATE ACCESS DETERMINATION, SEE DOCUMENTS IN THE DEPARTMENT OF PUBLIC WORKS AND PLANNING.				
811 CALL BEFORE YOU DIG		MARK THOMAS SUPERVISING ENGINEER		DATE
TENTATIVE PLANS FOR DESIGN		PROFESSIONAL SEAL MARK THOMAS CIVIL ENGINEER STATE OF CALIFORNIA 1230/21		PROJECT
GOLDEN STATE CORRIDOR - ECONOMIC DEVELOPMENT AND INFRASTRUCTURE IMPROVEMENTS		FOWLER REGION		DEPARTMENT OF PUBLIC WORKS AND PLANNING
CITY OF FOWLER - CALIFORNIA 1908		UTILITY PLAN		DRAWING NO. U-1
				SHEET NO. 73
				TOTAL 142


CAD USER: NYANES
PLOT DATE: 4/2/2021 8:35:36 AM

PATH: J:\Fresno COG-FN-16105-GSB Final Design\CADD\Sheets\Region 3 - Fowler\GSB_R3_U1-U7.dwg

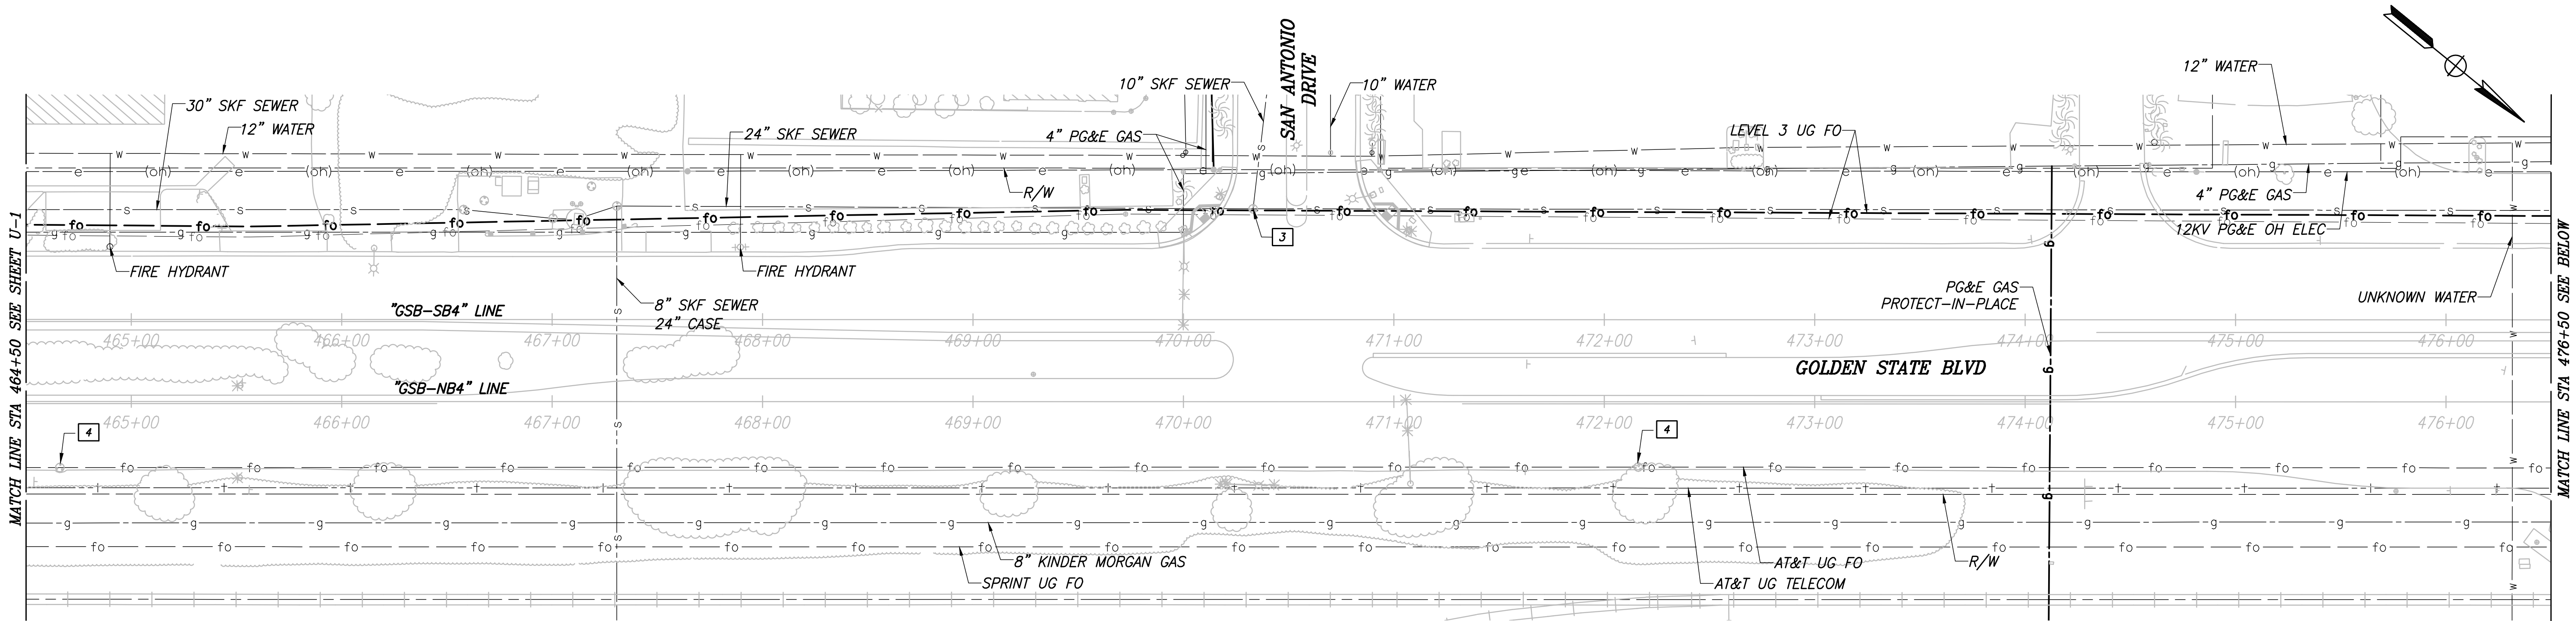


CITY OF FOWLER
GOLDEN STATE BLVD
SCALE: 1" = 40'

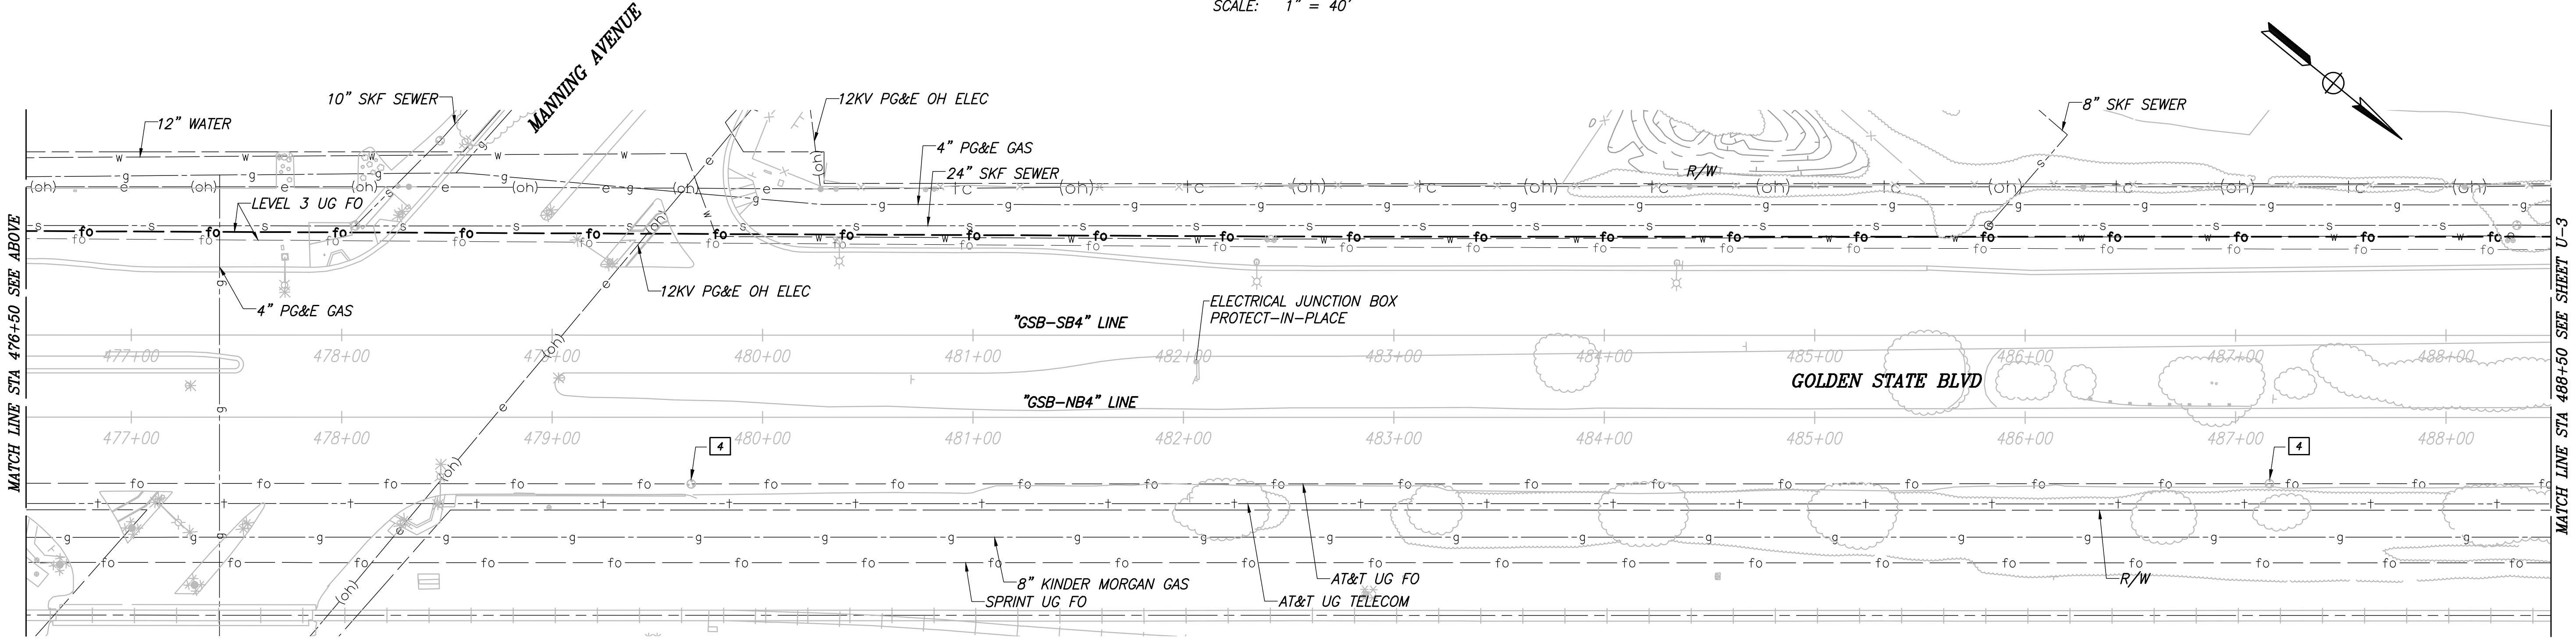

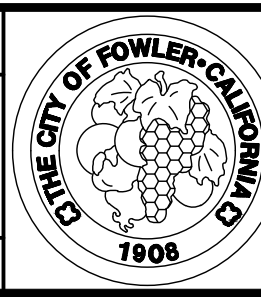
DESIGNED: ERIK CHIN		DATE	RECORD DRAWING	
DRAWN: DILLON ALAMEDA		####	RESIDENT ENGINEER	DATE
CHECKED: ED NORIEGA		####		
FOR RIGHT OF WAY DATA AND ACCURATE ACCESS DETERMINATION, SEE DOCUMENTS IN THE DEPARTMENT OF PUBLIC WORKS AND PLANNING.				
 CALL BEFORE YOU DIG		 MARK THOMAS		
TENTATIVE PLANS FOR DESIGN		SUPERVISING ENGINEER		DATE
PROJECT			GOLDEN STATE CORRIDOR - ECONOMIC DEVELOPMENT AND INFRASTRUCTURE IMPROVEMENTS	
FOWLER REGION				
		DEPARTMENT OF PUBLIC WORKS AND PLANNING		
		UTILITY PLAN		
DRAWING NO. U-2		SHEET NO. 74		TOTAL 142

CAD USER: NYANES
PLOT DATE: 4/2/2021 8:36:02 AM

PATH: J:\Fresno COG-FN-16105-GSB Final Design\CADD\Sheets\Region 3 - Fowler\GSB_R3_U1-U7.dwg

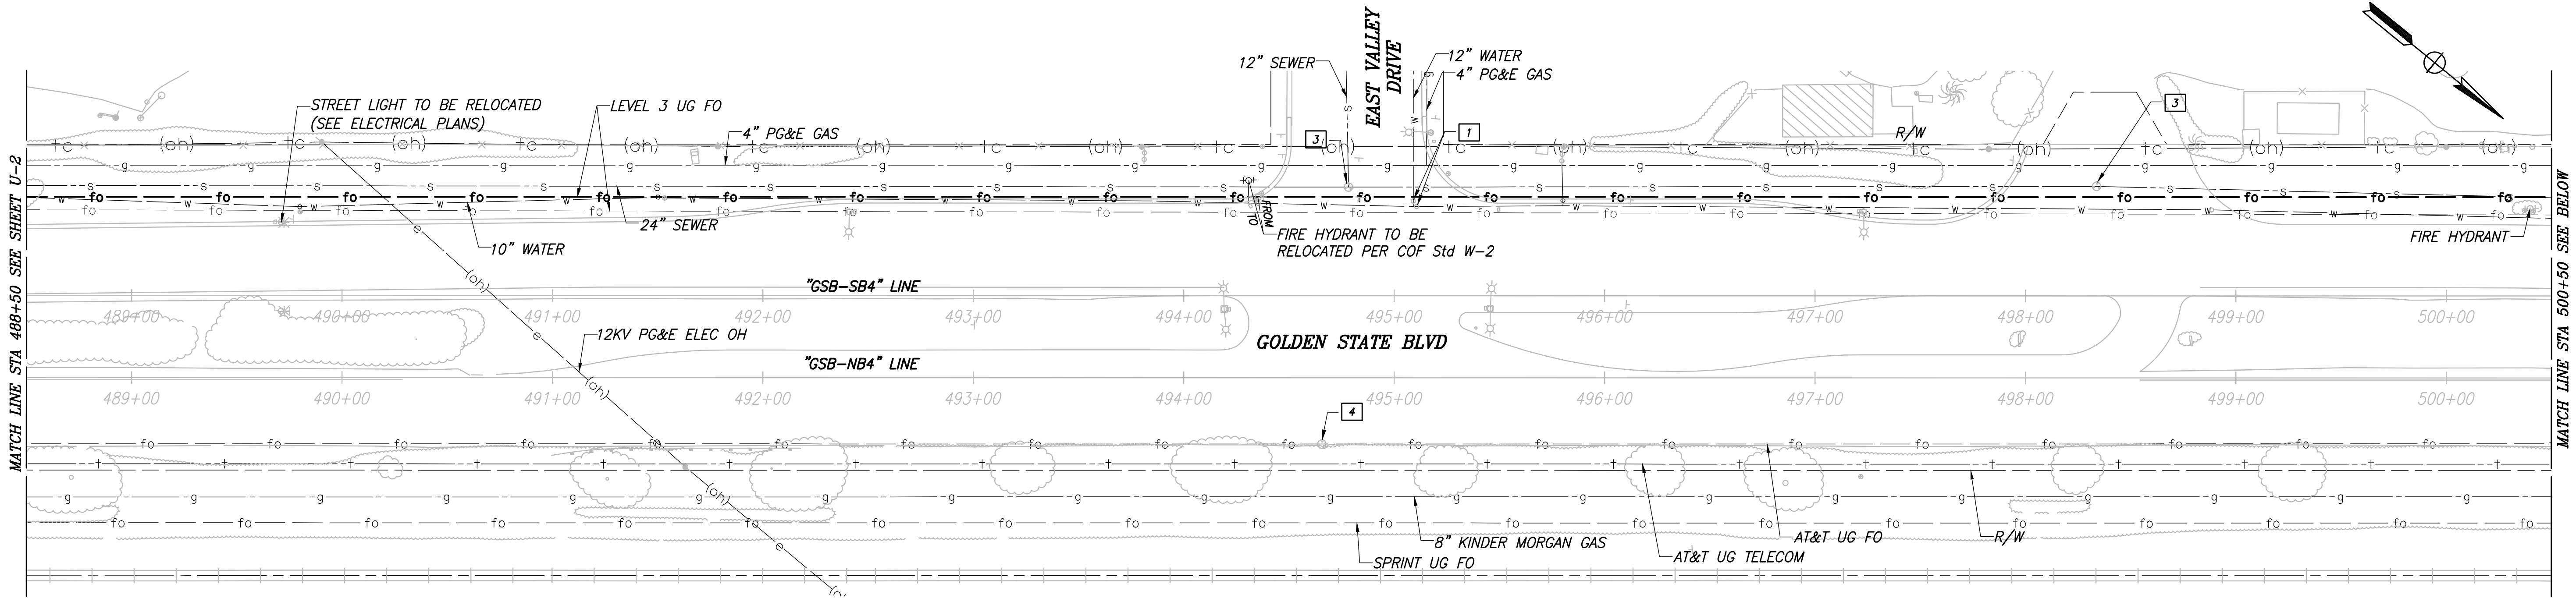


CITY OF FOWLER
GOLDEN STATE BLVD
SCALE: 1" = 40'

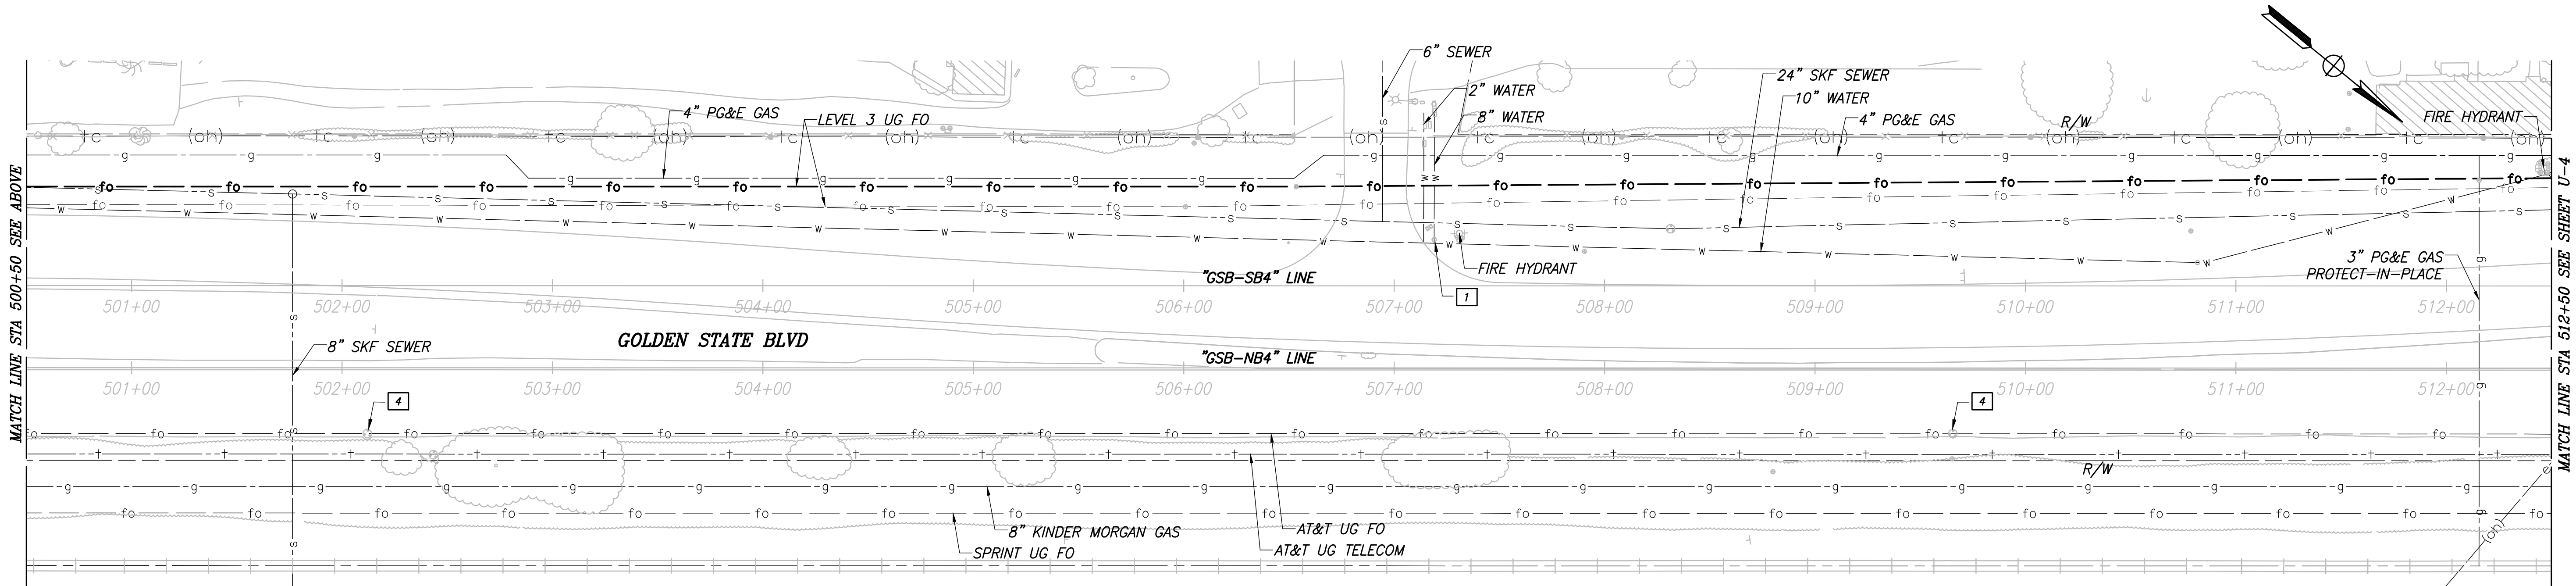

RECORD DRAWING		
DESIGNED: ERIK CHIN	DATE: ####	RESIDENT ENGINEER
DRAWN: DILLON ALAMEDA	DATE: ####	
CHECKED: ED NORIEGA	DATE: ####	


FOR RIGHT OF WAY DATA AND ACCURATE ACCESS DETERMINATION, SEE DOCUMENTS IN THE DEPARTMENT OF PUBLIC WORKS AND PLANNING.

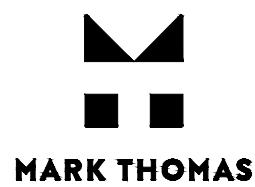


TENTATIVE PLANS FOR DESIGN
SUPERVISING ENGINEER
DATE: 4/2/21




PROJECT
GOLDEN STATE CORRIDOR - ECONOMIC DEVELOPMENT AND INFRASTRUCTURE IMPROVEMENTS
FOWLER REGION

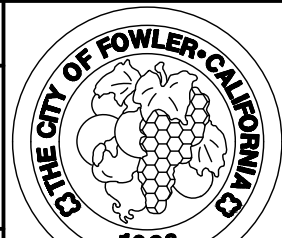


DEPARTMENT OF PUBLIC WORKS AND PLANNING
UTILITY PLAN
DRAWING NO. U-3
SHEET NO. 75
TOTAL 142

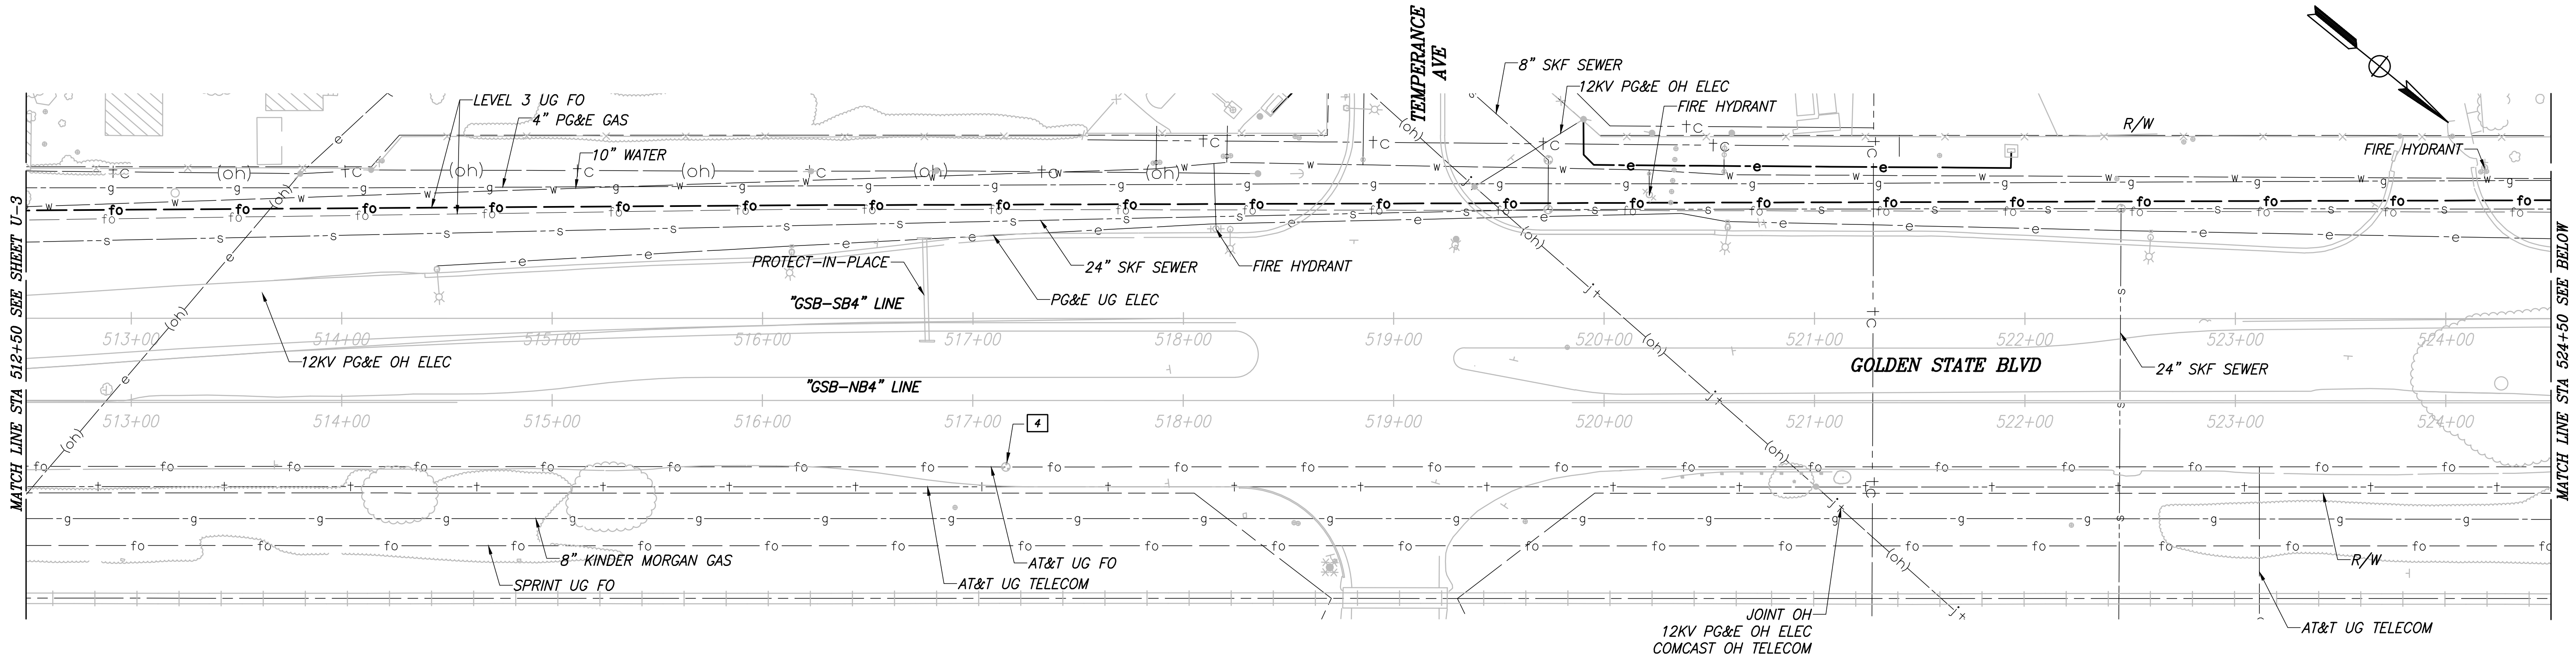


CITY OF FOWLER
GOLDEN STATE BLVD
SCALE: 1" = 40'

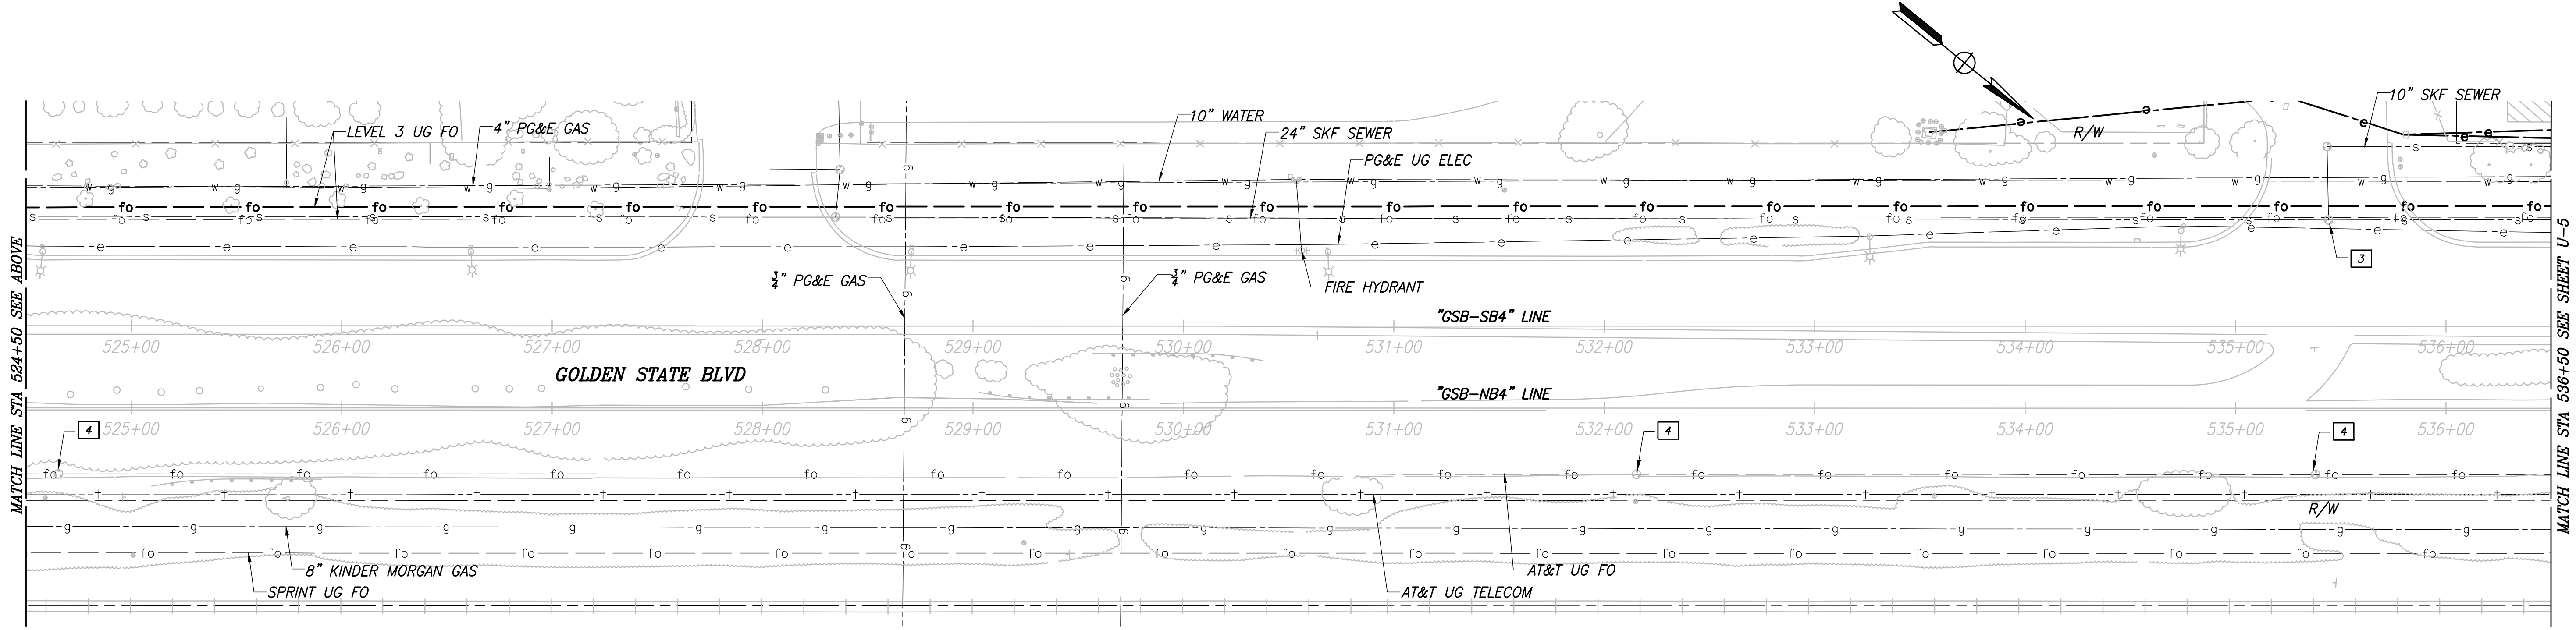

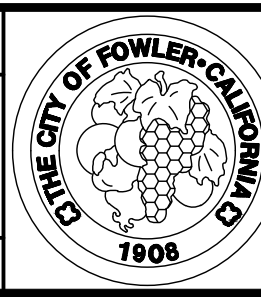
DESIGNED: ERIK CHIN		DATE	RECORD DRAWING	
DRAWN: DILLON ALAMEDA		####	RESIDENT ENGINEER	DATE
CHECKED: ED NORIEGA		####		
FOR RIGHT OF WAY DATA AND ACCURATE ACCESS DETERMINATION, SEE DOCUMENTS IN THE DEPARTMENT OF PUBLIC WORKS AND PLANNING.				
				
CALL BEFORE YOU DIG		TENTATIVE PLANS FOR DESIGN		DATE
SUPERVISING ENGINEER		PROJECT		
		GOLDEN STATE CORRIDOR - ECONOMIC DEVELOPMENT AND INFRASTRUCTURE IMPROVEMENTS		
		FOWLER REGION		
		DEPARTMENT OF PUBLIC WORKS AND PLANNING		
		UTILITY PLAN		
DRAWING NO. U-4		SHEET NO. 76		TOTAL 142

CAD USER: NYANES
PLOT DATE: 4/2/2021 8:36:45 AM

PATH: J:\Fresno COG-FN-16105-GSB Final Design\CADD\Sheets\Region 3 - Fowler\GSB_R3_U1-U7.dwg

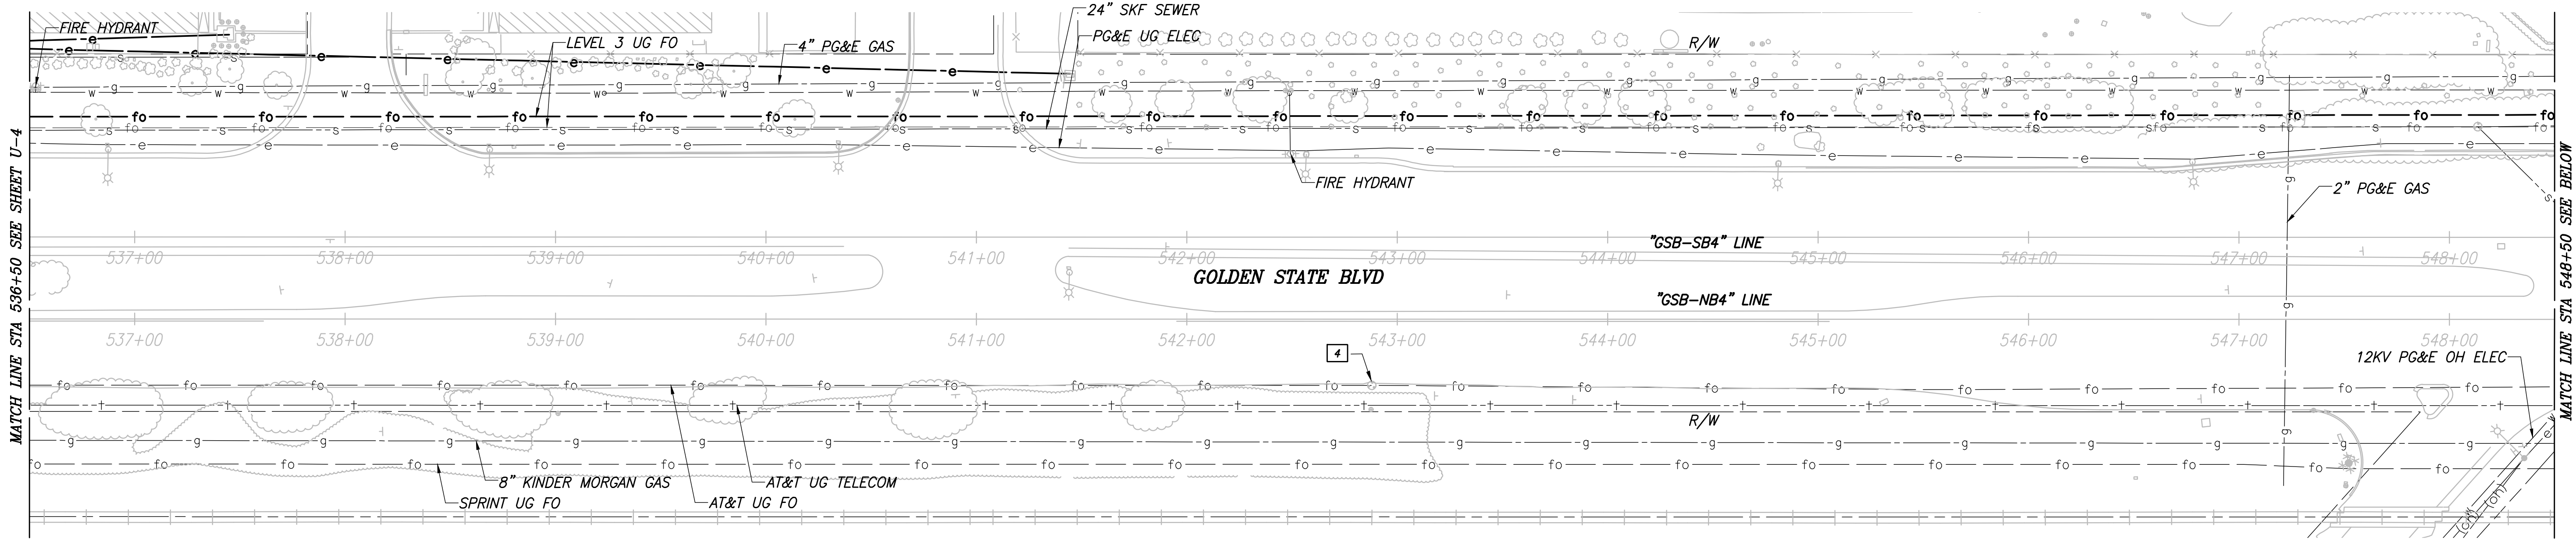

CITY OF FOWLER
GOLDEN STATE BLVD
SCALE: 1" = 40'

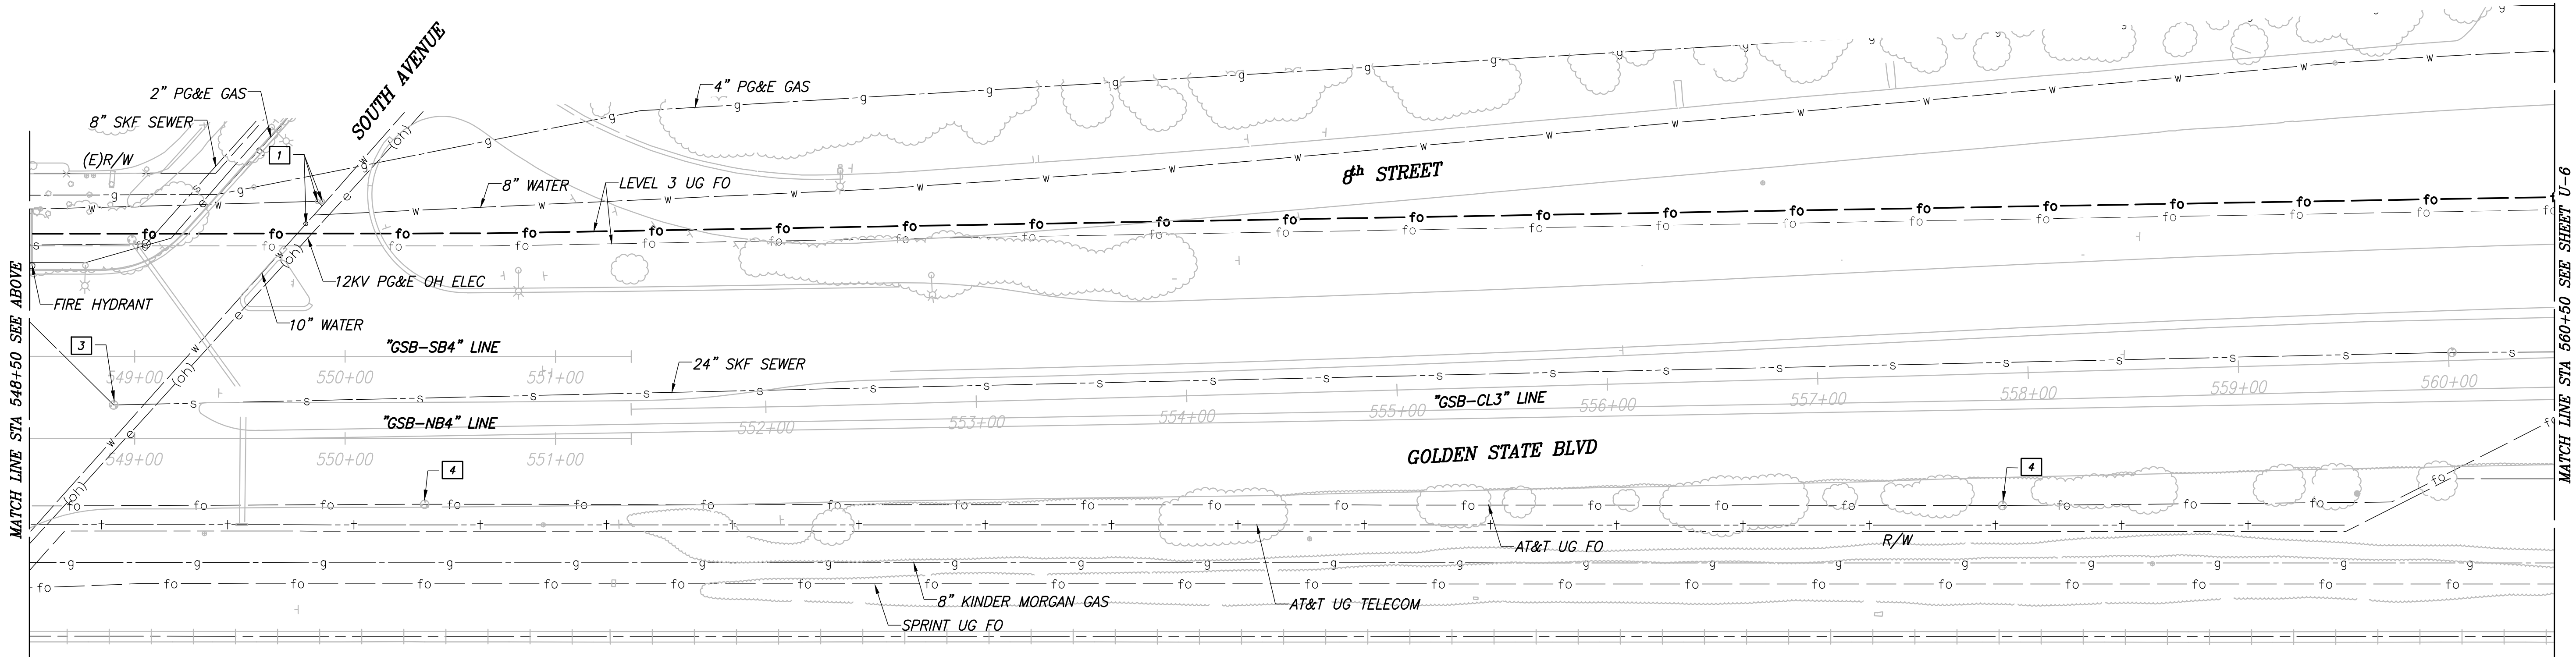

DESIGNED: ERIK CHIN		DATE: ####	RECORD DRAWING	
DRAWN: DILLON ALAMEDA		DATE: ####	RESIDENT ENGINEER	
CHECKED: ED NORIEGA		DATE: ####		
FOR RIGHT OF WAY DATA AND ACCURATE ACCESS DETERMINATION, SEE DOCUMENTS IN THE DEPARTMENT OF PUBLIC WORKS AND PLANNING.				



CALL BEFORE YOU DIG



MARK THOMAS

TENTATIVE PLANS FOR DESIGN


SUPERVISING ENGINEER

DATE: 4/2/21




ERIK CHIN
CIVIL
STATE OF CALIFORNIA
1230721


PROJECT	
GOLDEN STATE CORRIDOR - ECONOMIC DEVELOPMENT AND INFRASTRUCTURE IMPROVEMENTS	
FOWLER REGION	

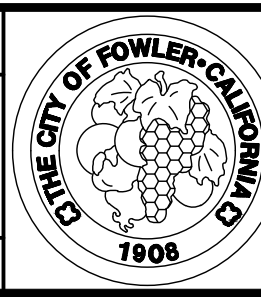


THE CITY OF FOWLER, CALIFORNIA
1908

DEPARTMENT OF PUBLIC WORKS AND PLANNING		
UTILITY PLAN		
DRAWING NO. U-5	SHEET NO. 77	TOTAL 142

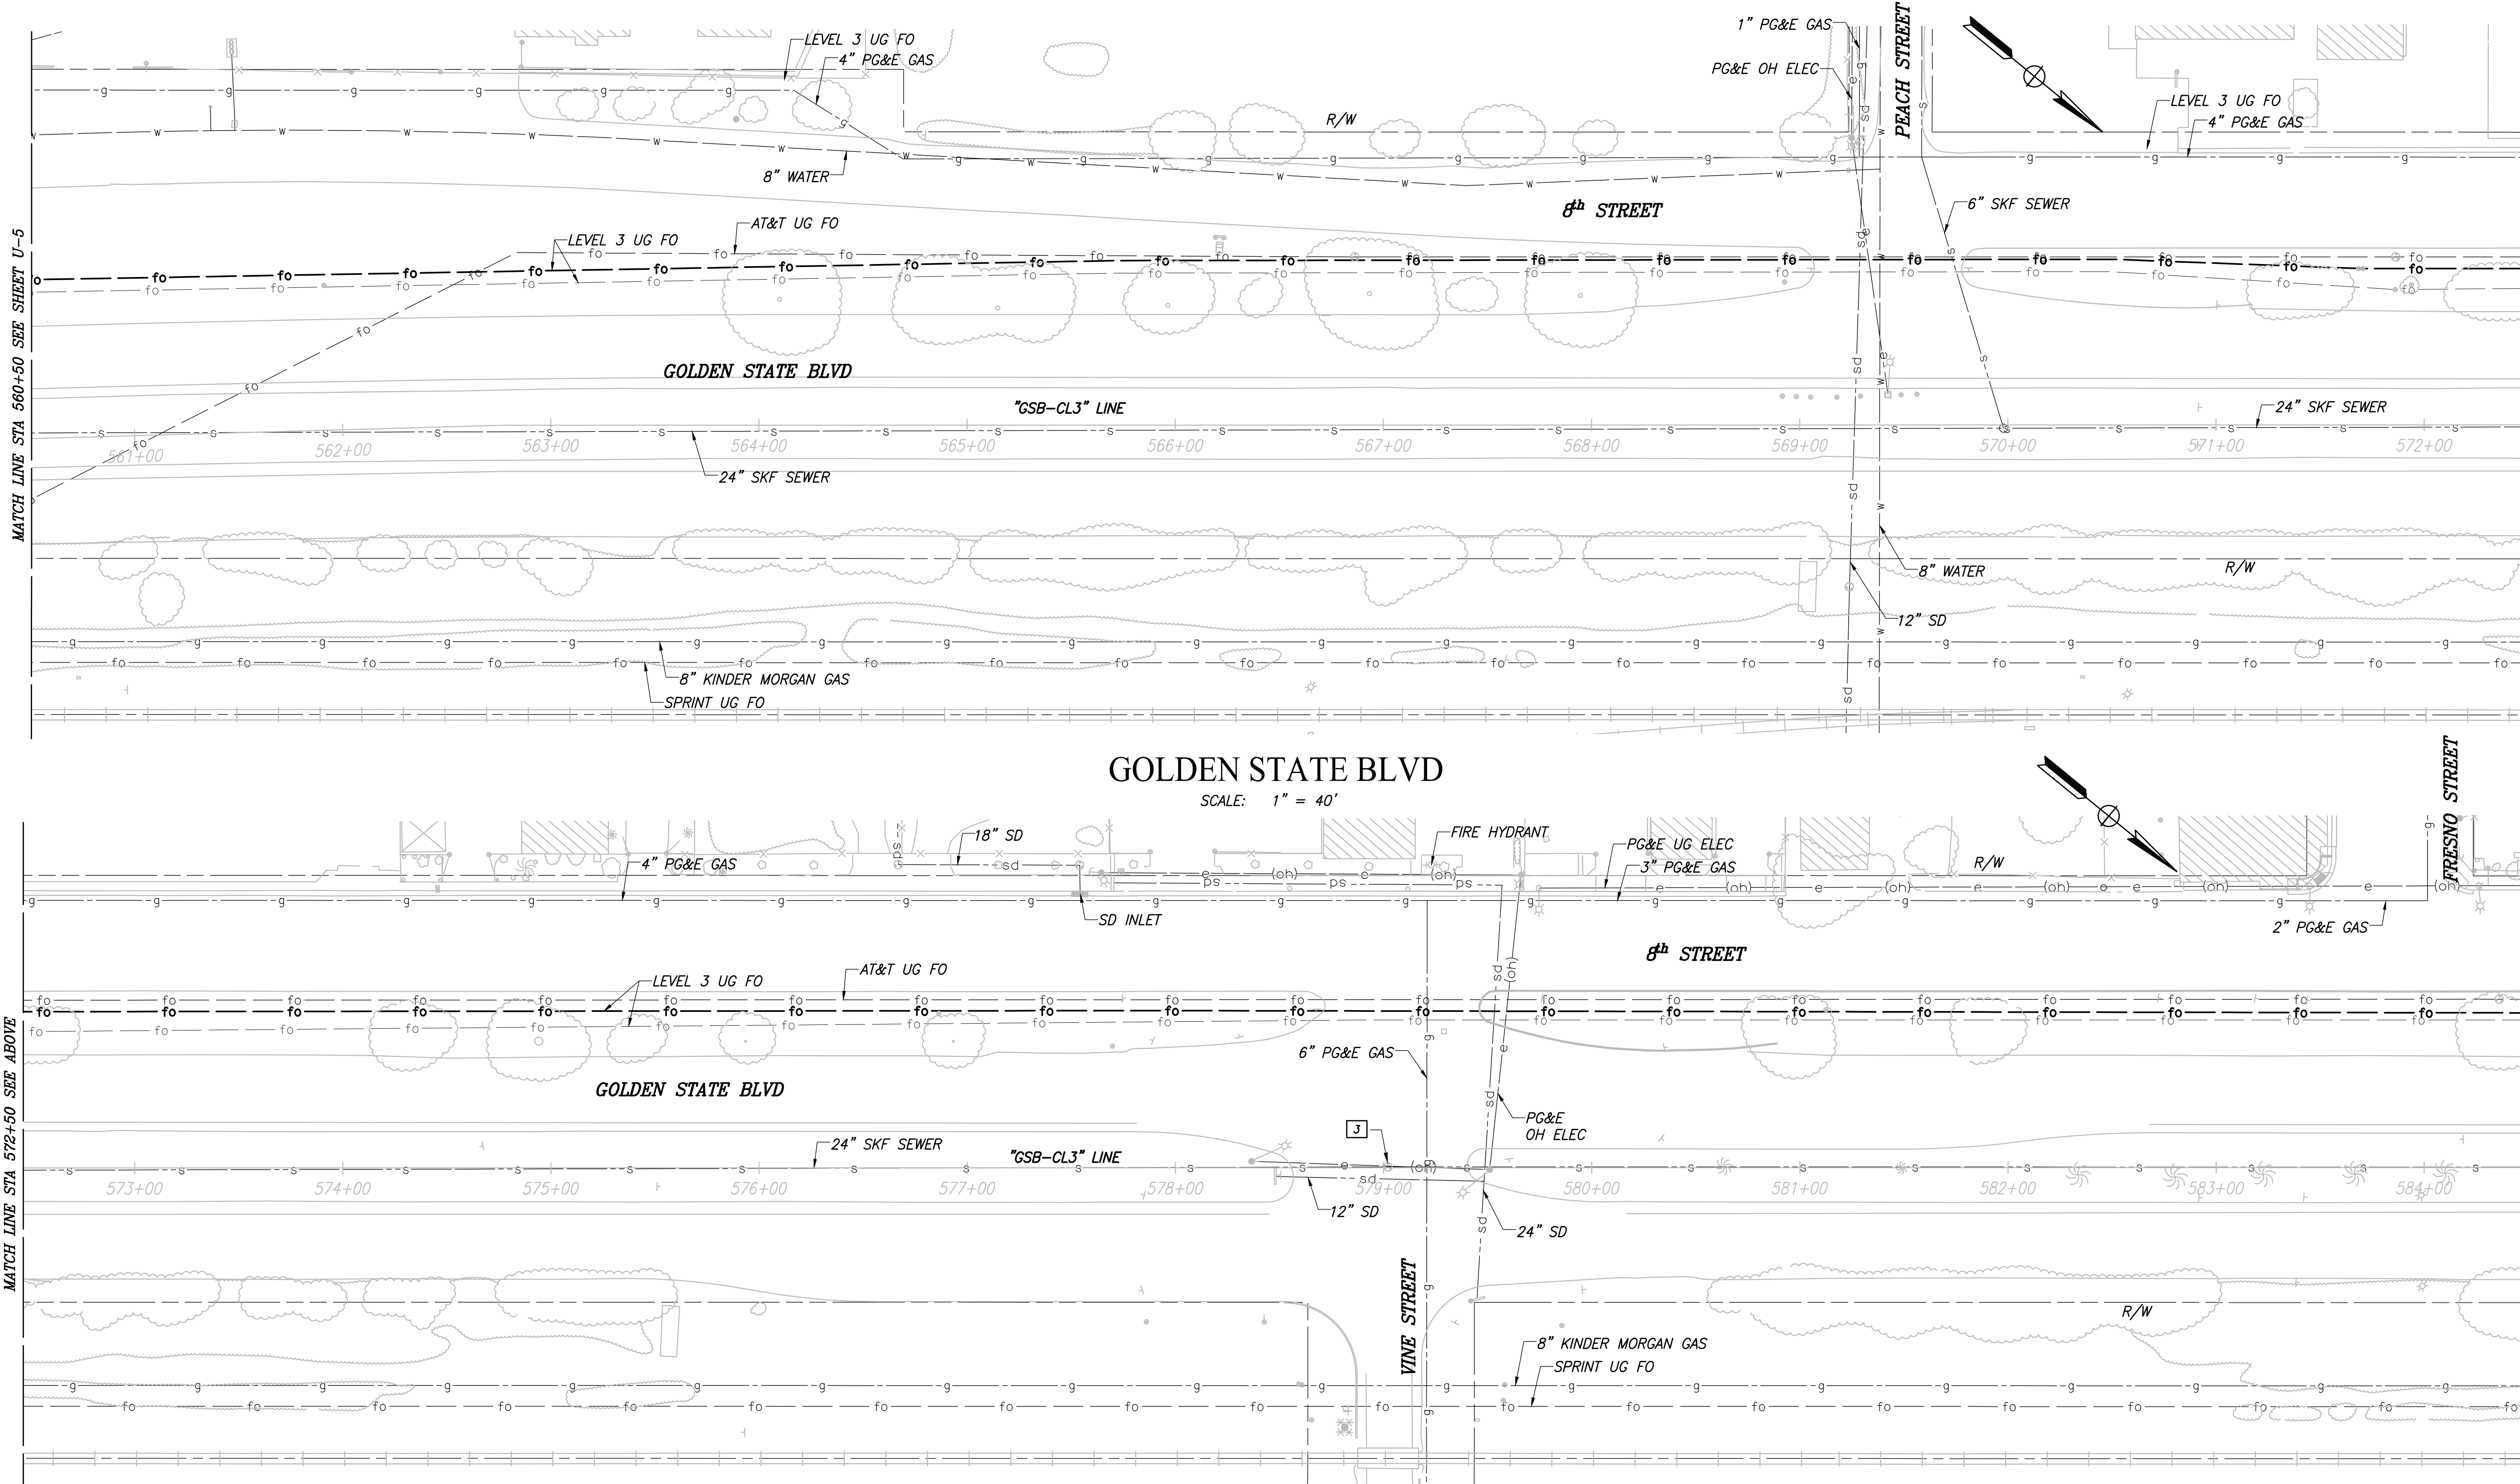


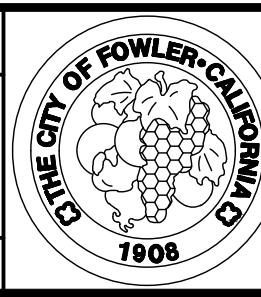DESIGNED: ERIK CHIN		DATE	RECORD DRAWING	
DRAWN: DILLON ALAMEDA		####	RESIDENT ENGINEER	DATE
CHECKED: ED NORIEGA		####		
FOR RIGHT OF WAY DATA AND ACCURATE ACCESS DETERMINATION, SEE DOCUMENTS IN THE DEPARTMENT OF PUBLIC WORKS AND PLANNING.				
				
CALL BEFORE YOU DIG		TENTATIVE PLANS FOR DESIGN		DATE
SUPERVISING ENGINEER		PROJECT		
		GOLDEN STATE CORRIDOR - ECONOMIC DEVELOPMENT AND INFRASTRUCTURE IMPROVEMENTS		
		FOWLER REGION		
		DEPARTMENT OF PUBLIC WORKS AND PLANNING		
		UTILITY PLAN		
DRAWING NO. U-6		SHEET NO. 78		TOTAL 142

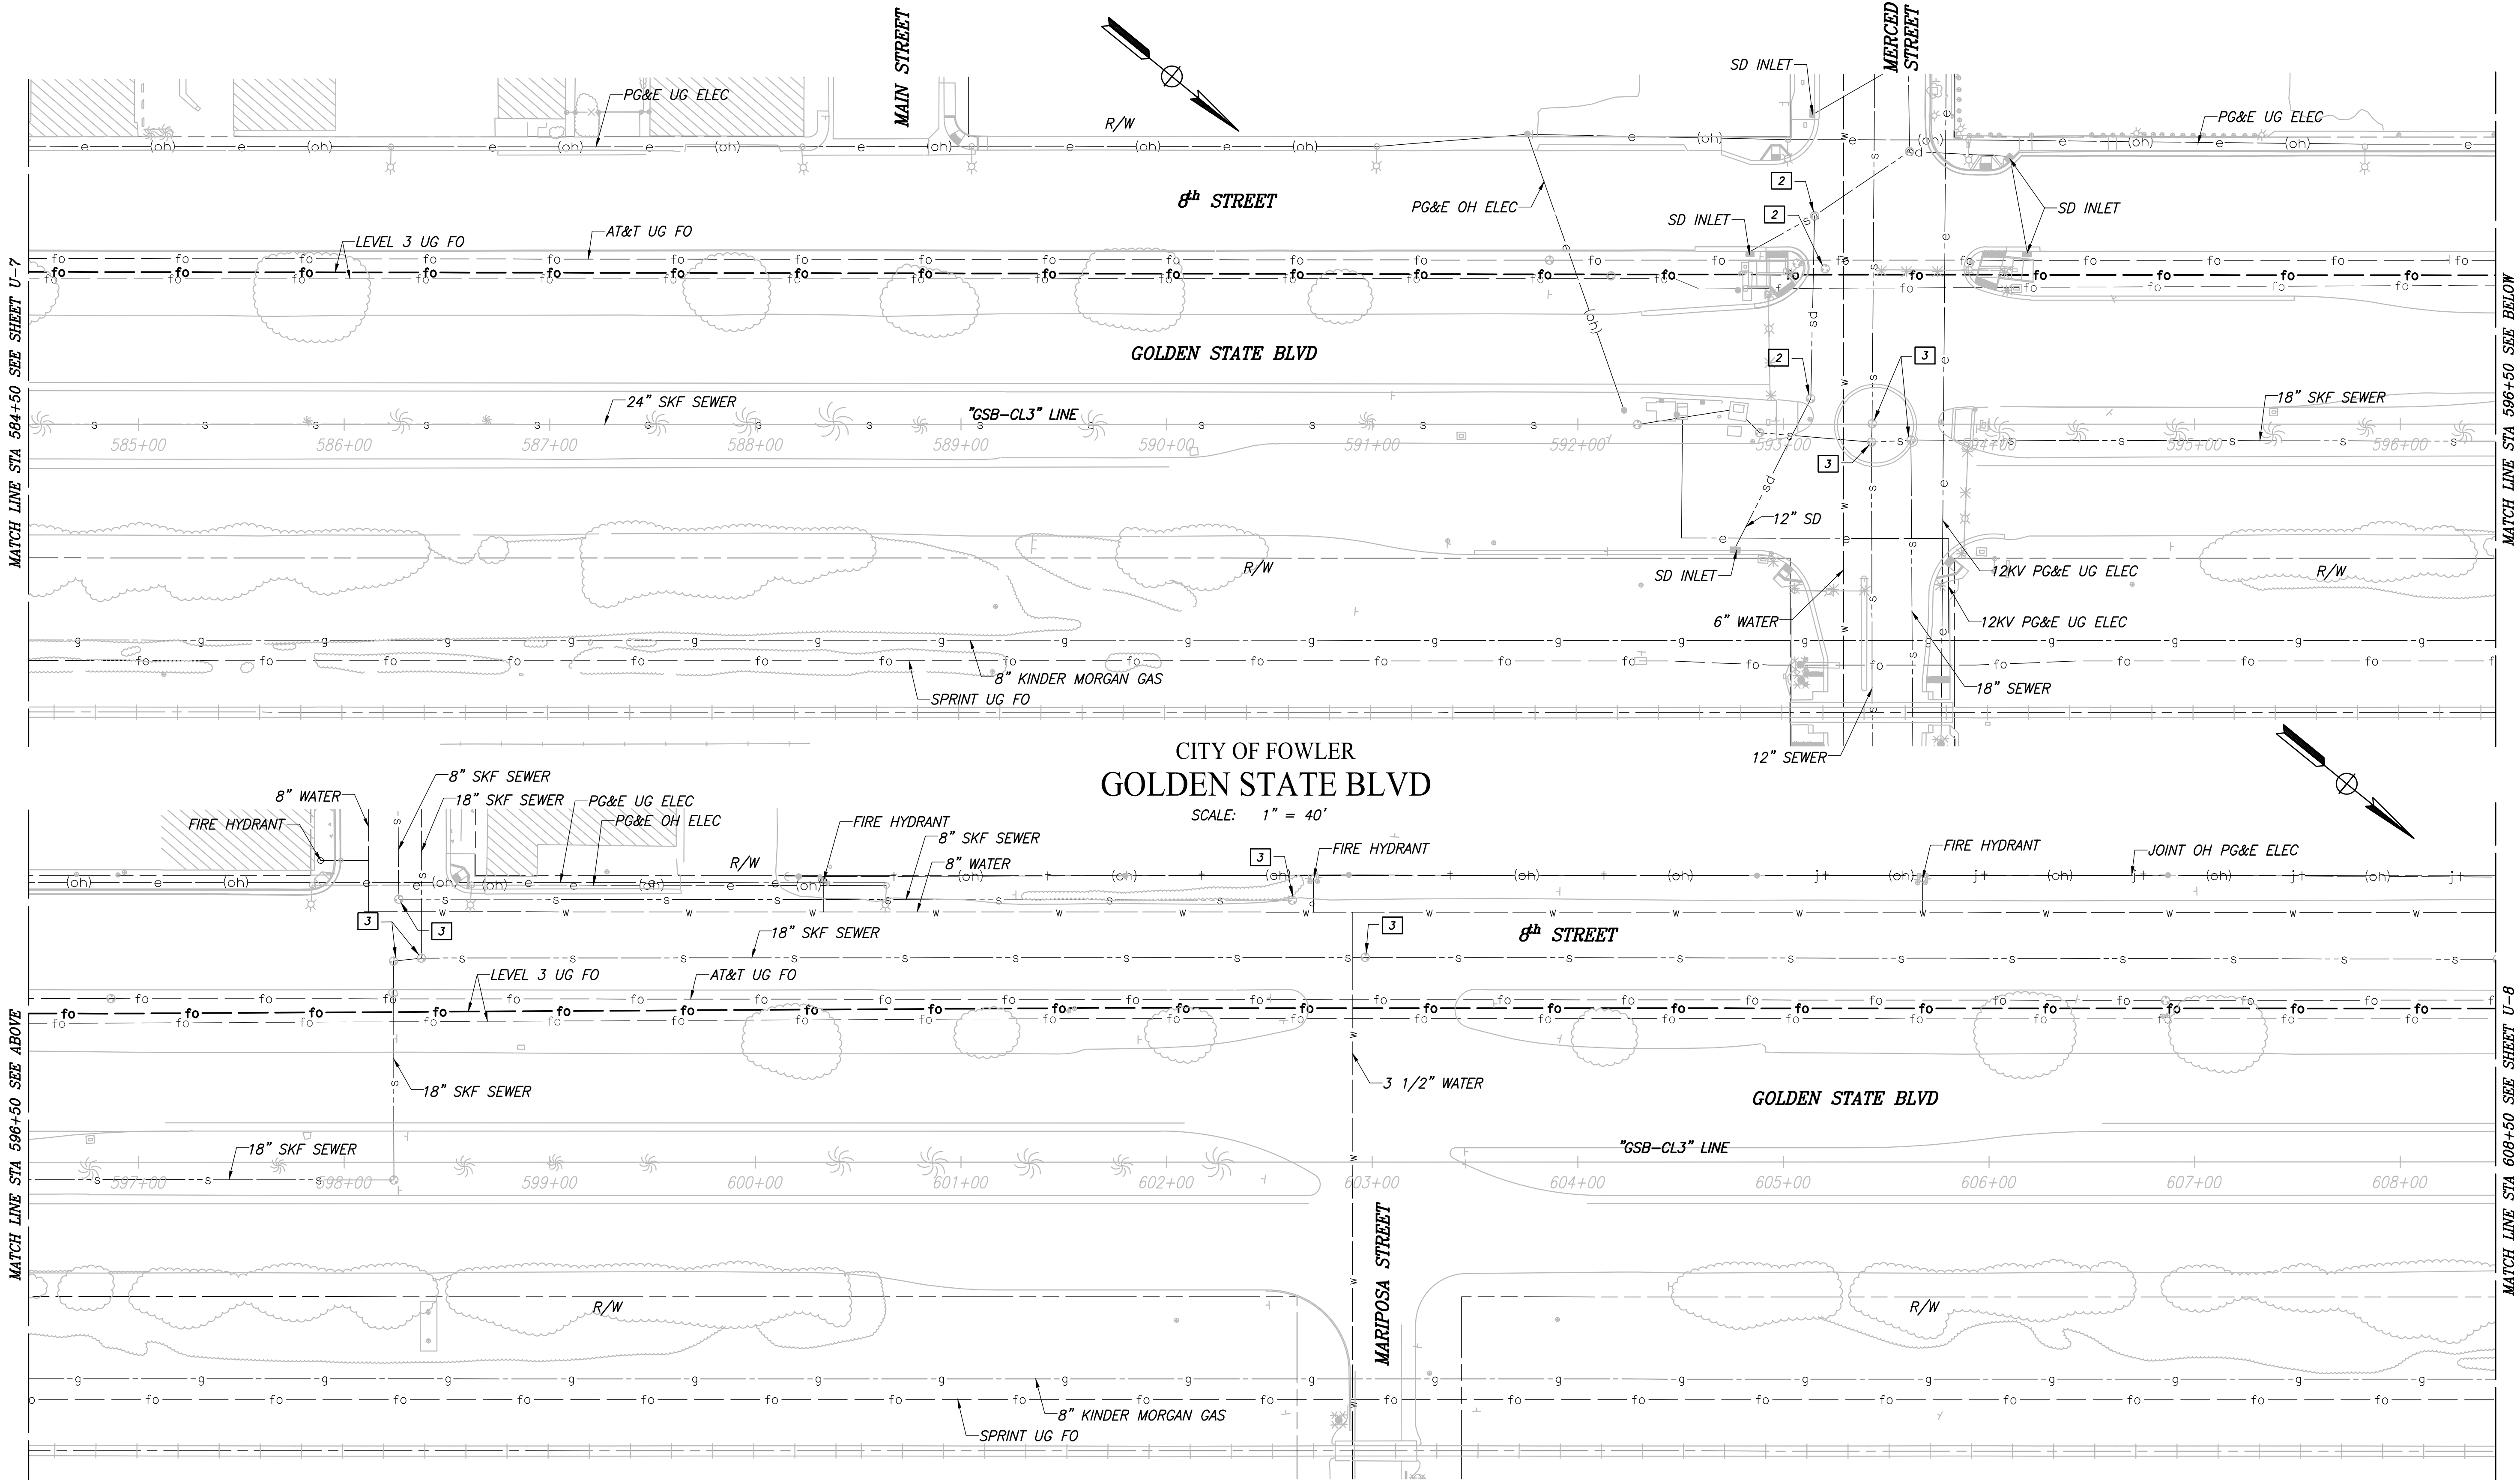

RECORD DRAWING			
DESIGNED: ERIK CHIN	DATE: ####	RESIDENT ENGINEER	DATE
DRAWN: DILLON ALAMEDA	DATE: ####		
CHECKED: ED NORIEGA	DATE: ####		

FOR RIGHT OF WAY DATA AND ACCURATE ACCESS DETERMINATION, SEE DOCUMENTS IN THE DEPARTMENT OF PUBLIC WORKS AND PLANNING.

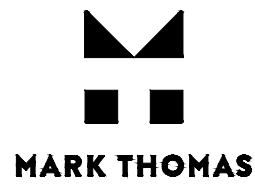

TENTATIVE PLANS FOR DESIGN	
SUPERVISING ENGINEER	DATE




PROJECT
GOLDEN STATE CORRIDOR - ECONOMIC DEVELOPMENT AND INFRASTRUCTURE IMPROVEMENTS
FOWLER REGION




DEPARTMENT OF PUBLIC WORKS AND PLANNING		
UTILITY PLAN		
DRAWING NO. U-7	SHEET NO. 79	TOTAL 142

PLOT DATE: 4/2/2021 8:38:32 AM CAD USER: NYANES

PATH: J:\Fresno COG-FN-16105-GSB Final Design\CADD\Sheets\Region 3 - Fowler\GSB_R3_U8-U14.dwg

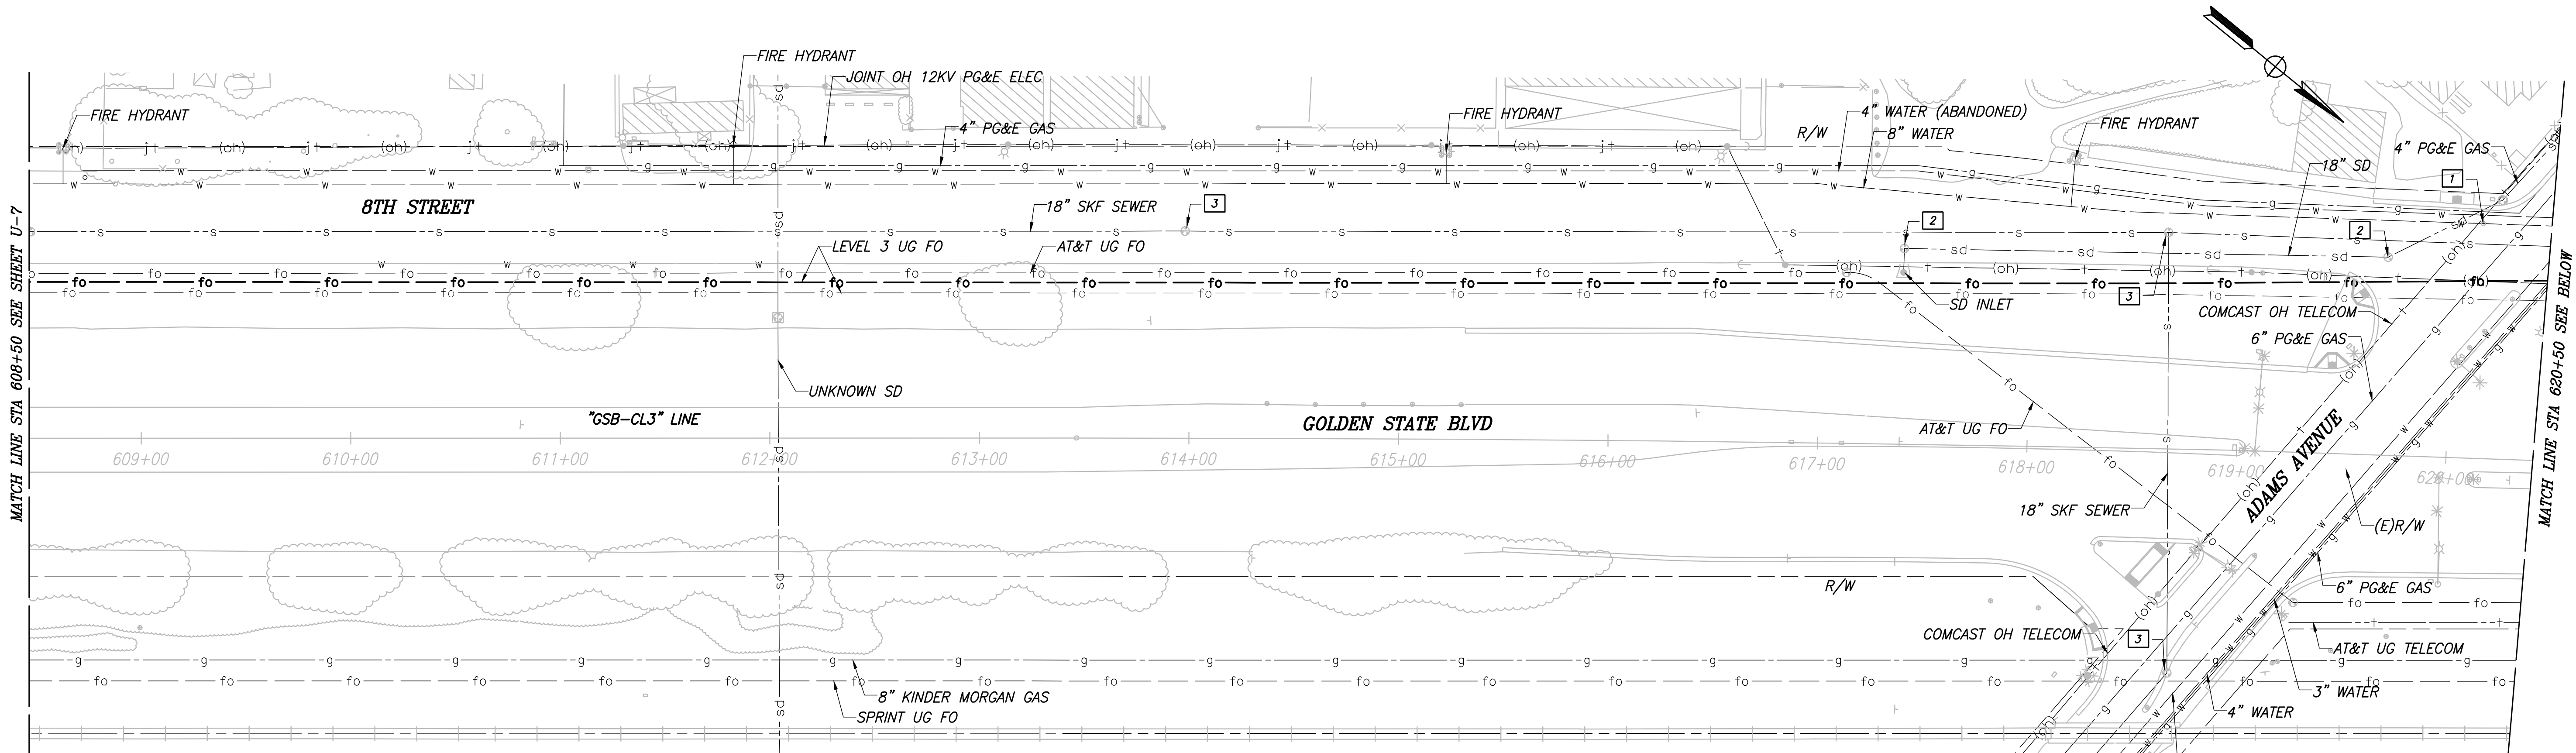

CITY OF FOWLER
GOLDEN STATE BLVD
SCALE: 1" = 40'

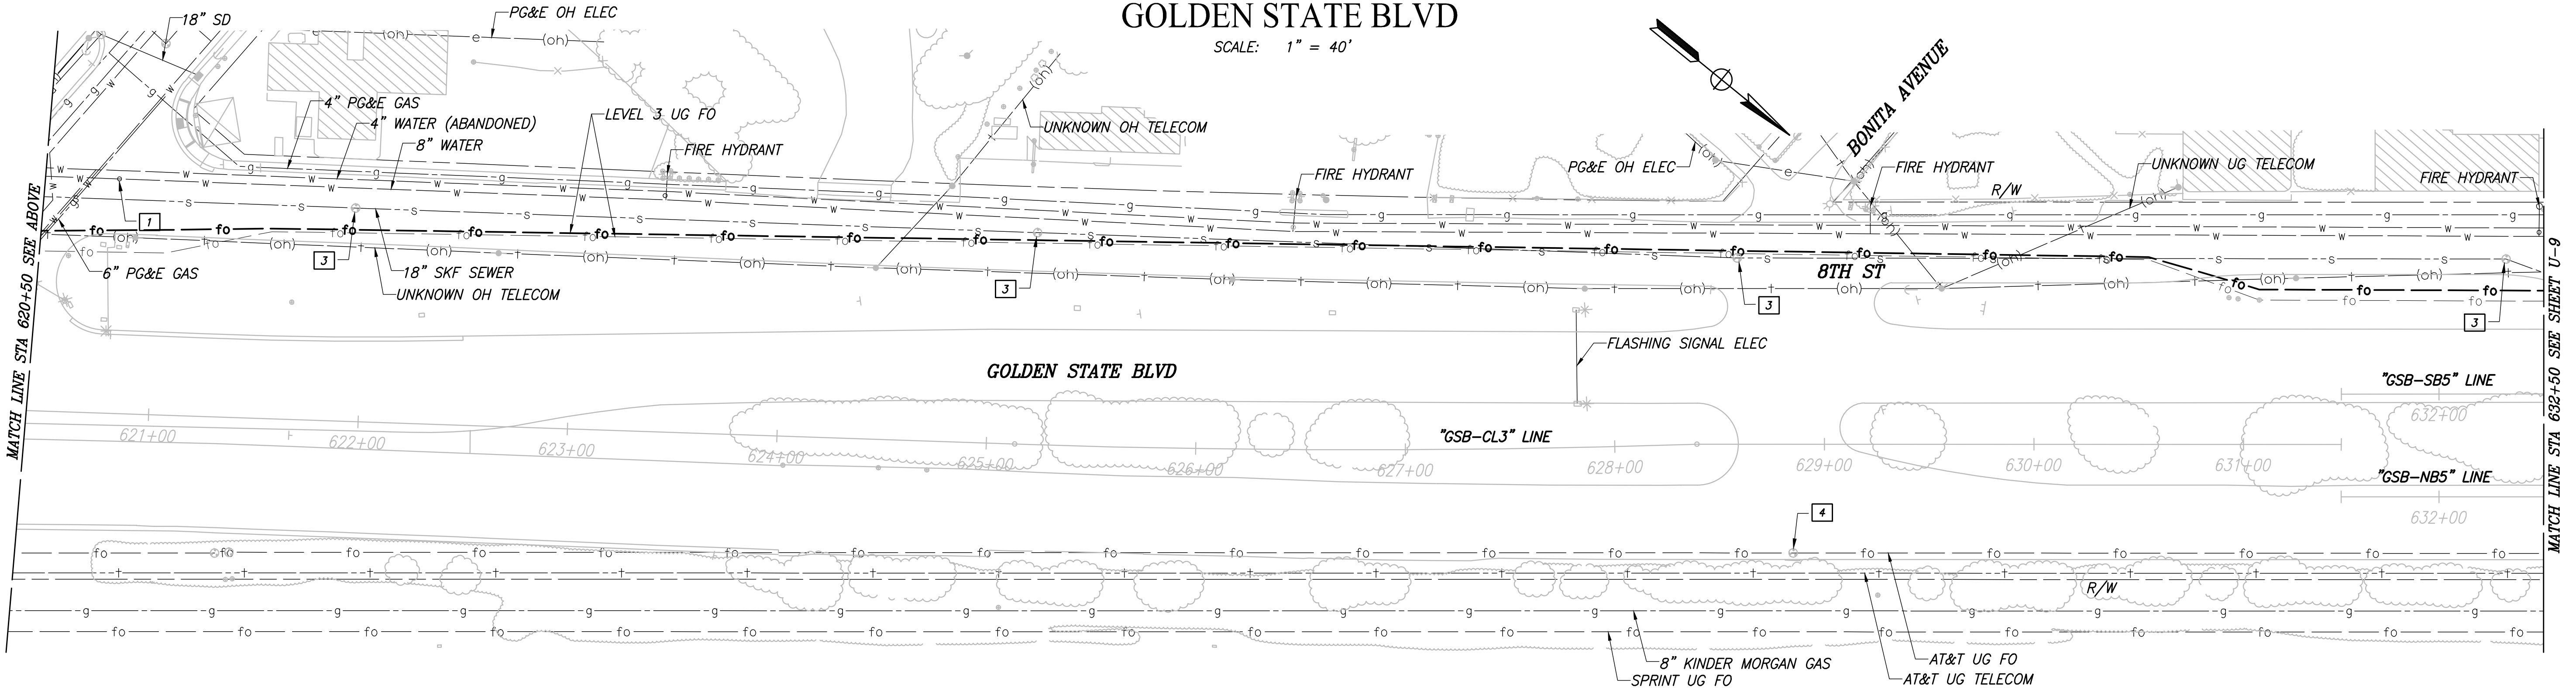

RECORD DRAWING		
DESIGNED: ERIK CHIN	DATE: ####	RESIDENT ENGINEER
DRAWN: DILLON ALAMEDA	DATE: ####	
CHECKED: ED NORIEGA	DATE: ####	


FOR RIGHT OF WAY DATA AND ACCURATE ACCESS DETERMINATION, SEE DOCUMENTS IN THE DEPARTMENT OF PUBLIC WORKS AND PLANNING.



TENTATIVE PLANS FOR DESIGN	
SUPERVISING ENGINEER	DATE




PROJECT
GOLDEN STATE CORRIDOR - ECONOMIC DEVELOPMENT AND INFRASTRUCTURE IMPROVEMENTS
FOWLER REGION

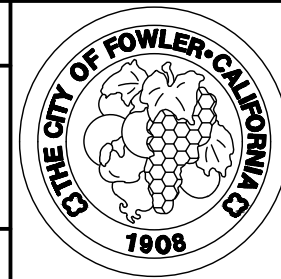


DEPARTMENT OF PUBLIC WORKS AND PLANNING		
UTILITY PLAN		
DRAWING NO. U-8	SHEET NO. 80	TOTAL 142

PLOT DATE: 4/2/2021 8:38:55 AM CAD USER: NYANES

PATH: J:\Fresno COG-FN-16105-GSB Final Design\CADD\Sheets\Region 3 - Fowler\GSB_R3_U8-U14.dwg

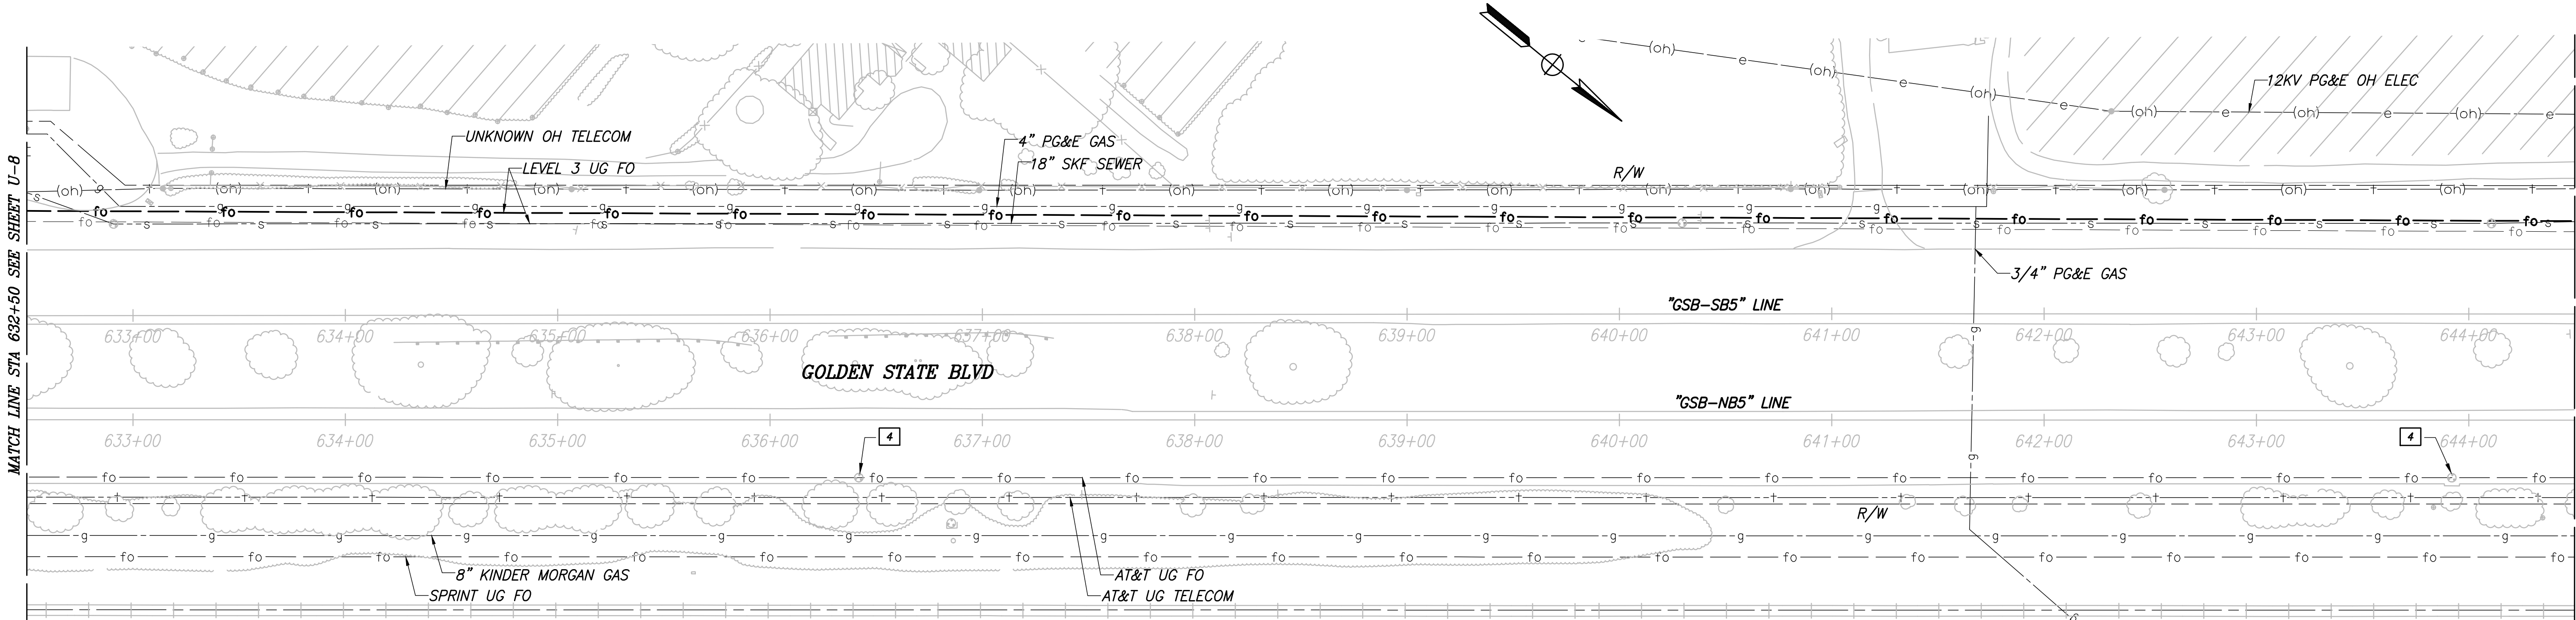


CITY OF FOWLER
GOLDEN STATE BLVD
SCALE: 1" = 40'

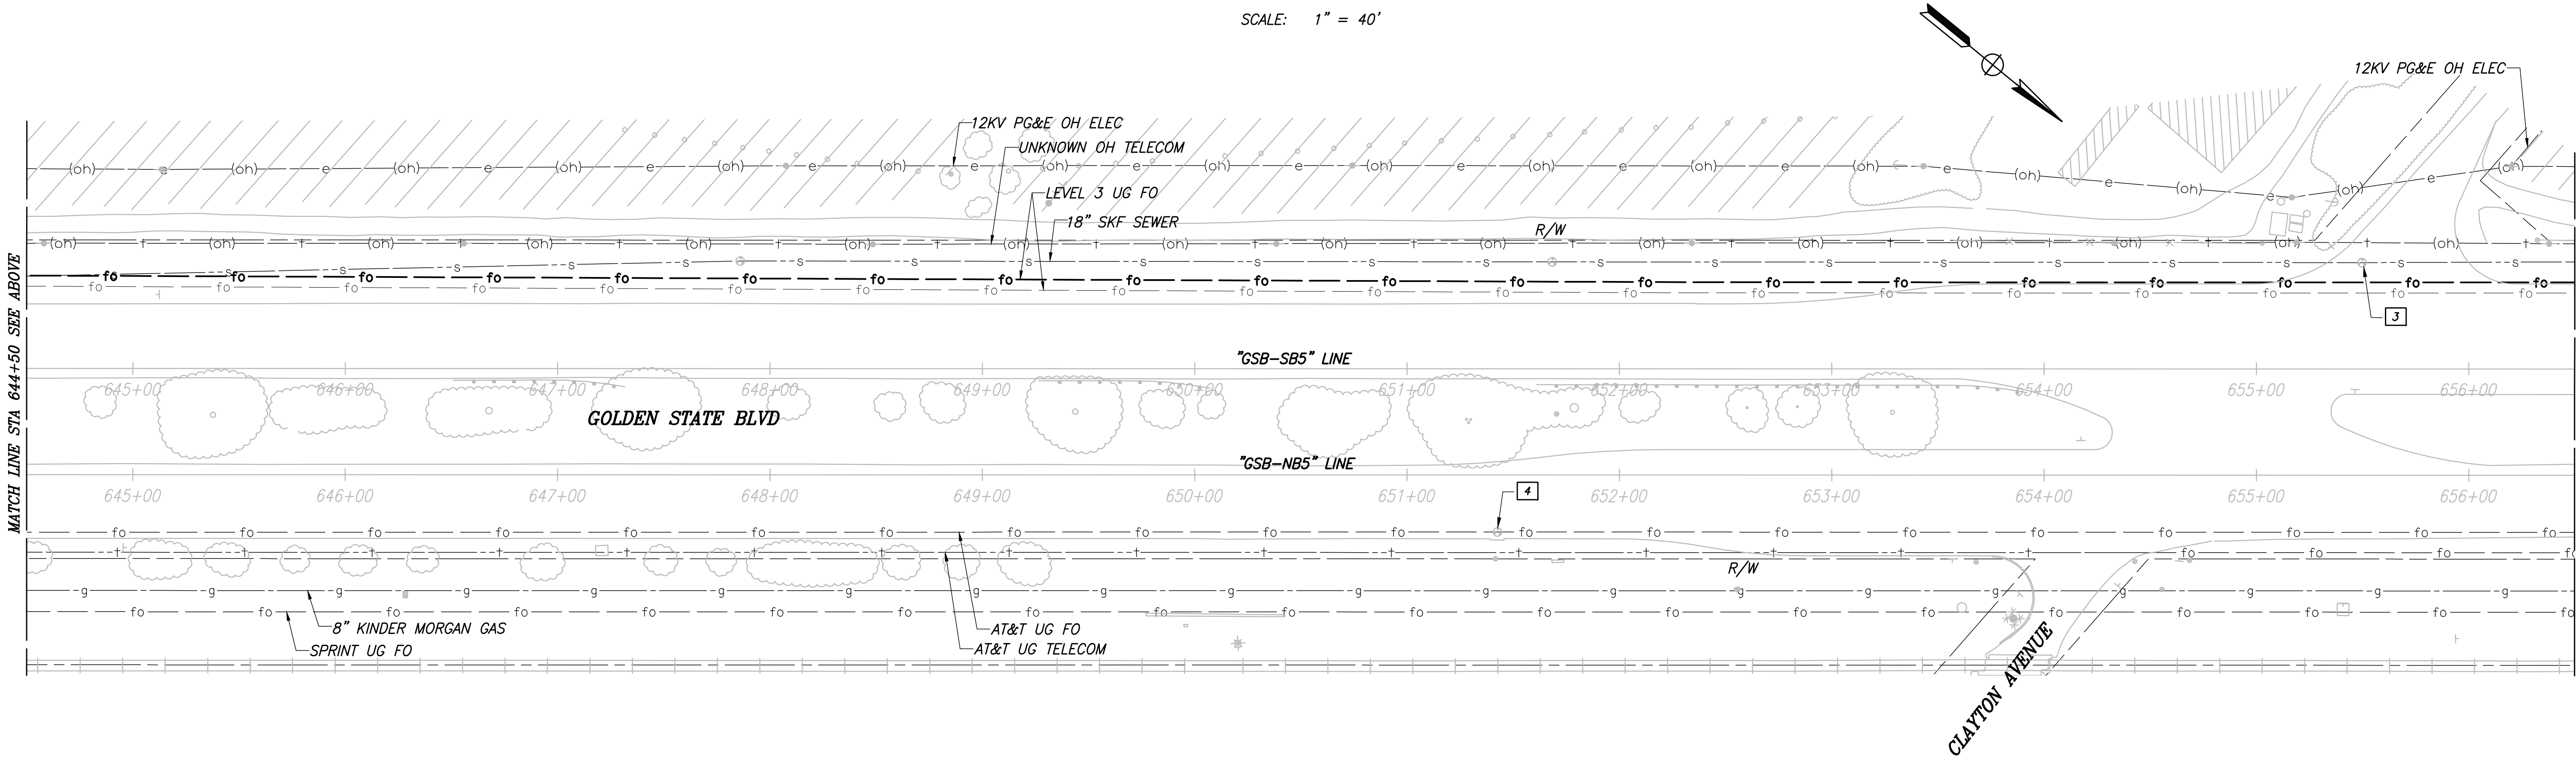


RECORD DRAWING		DATE
DESIGNED: ERIK CHIN	####	
DRAWN: DILLON ALAMEDA	####	
CHECKED: ED NORIEGA	####	


FOR RIGHT OF WAY DATA AND ACCURATE ACCESS DETERMINATION, SEE DOCUMENTS IN THE DEPARTMENT OF PUBLIC WORKS AND PLANNING.

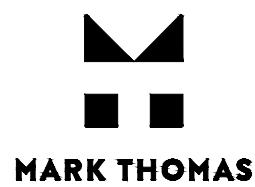


TENTATIVE PLANS FOR DESIGN	
SUPERVISING ENGINEER	DATE

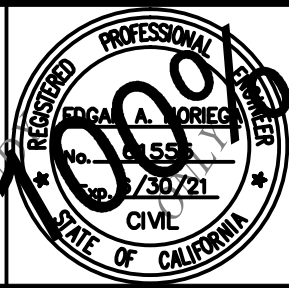


PROJECT
GOLDEN STATE CORRIDOR - ECONOMIC DEVELOPMENT AND INFRASTRUCTURE IMPROVEMENTS
FOWLER REGION

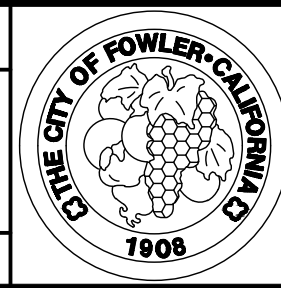

DEPARTMENT OF PUBLIC WORKS AND PLANNING		
UTILITY PLAN		
DRAWING NO. U-9	SHEET NO. 81	TOTAL 142

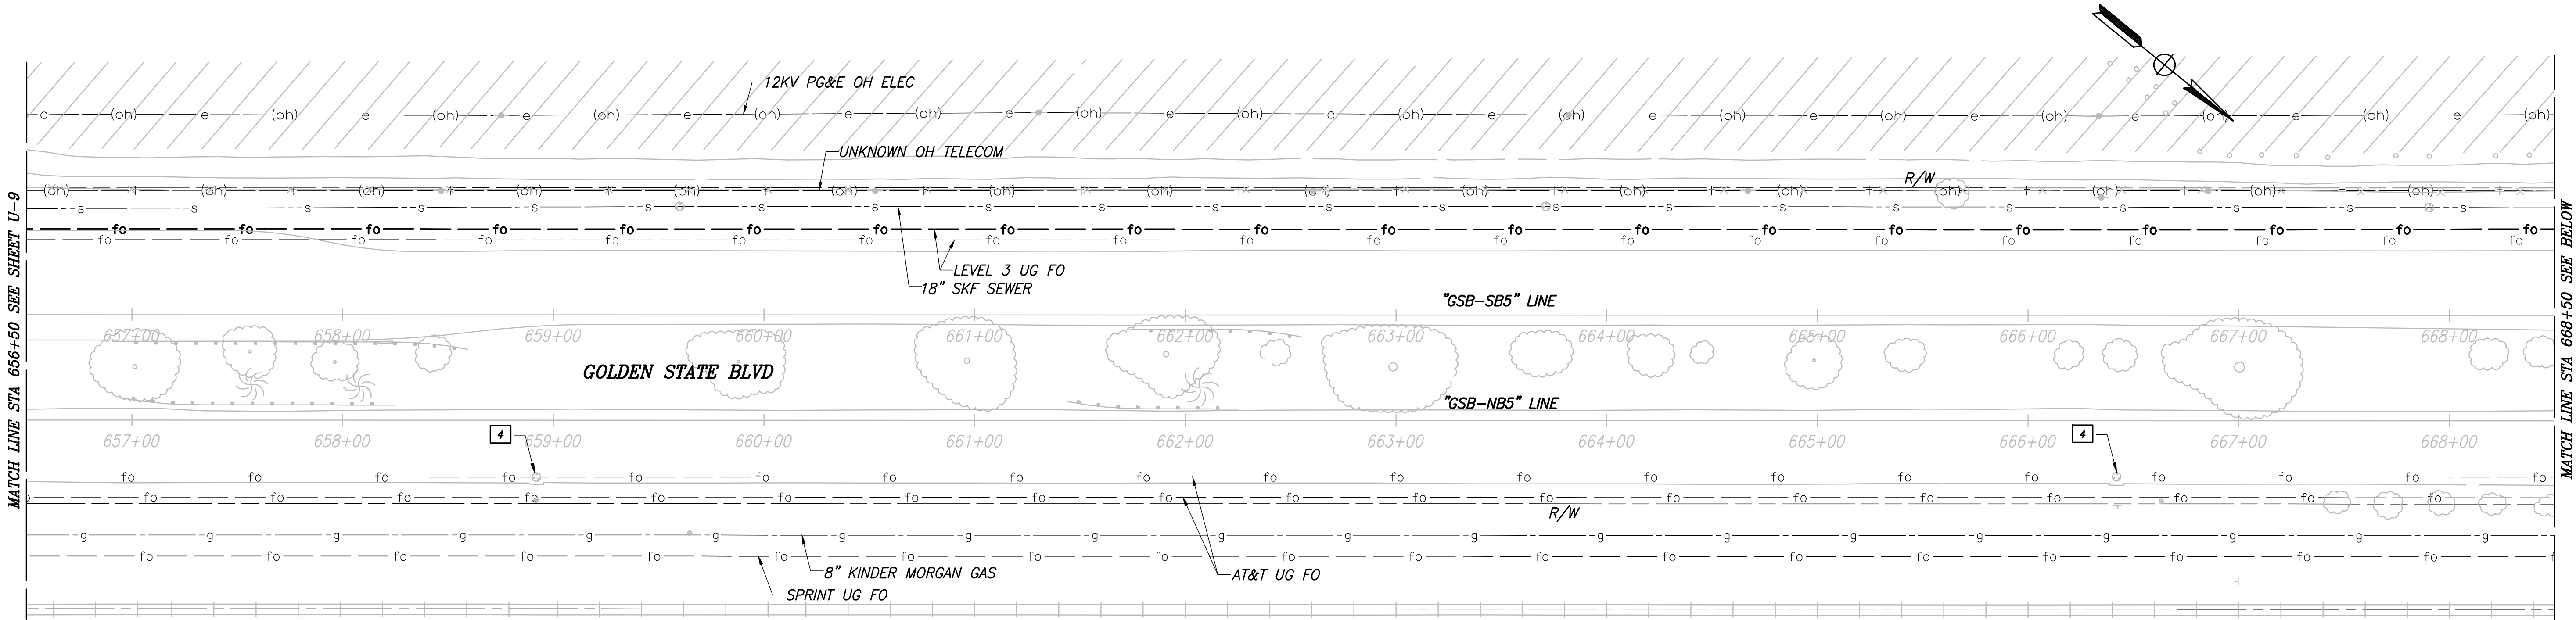

CITY OF FOWLER
GOLDEN STATE BLVD
SCALE: 1" = 40'

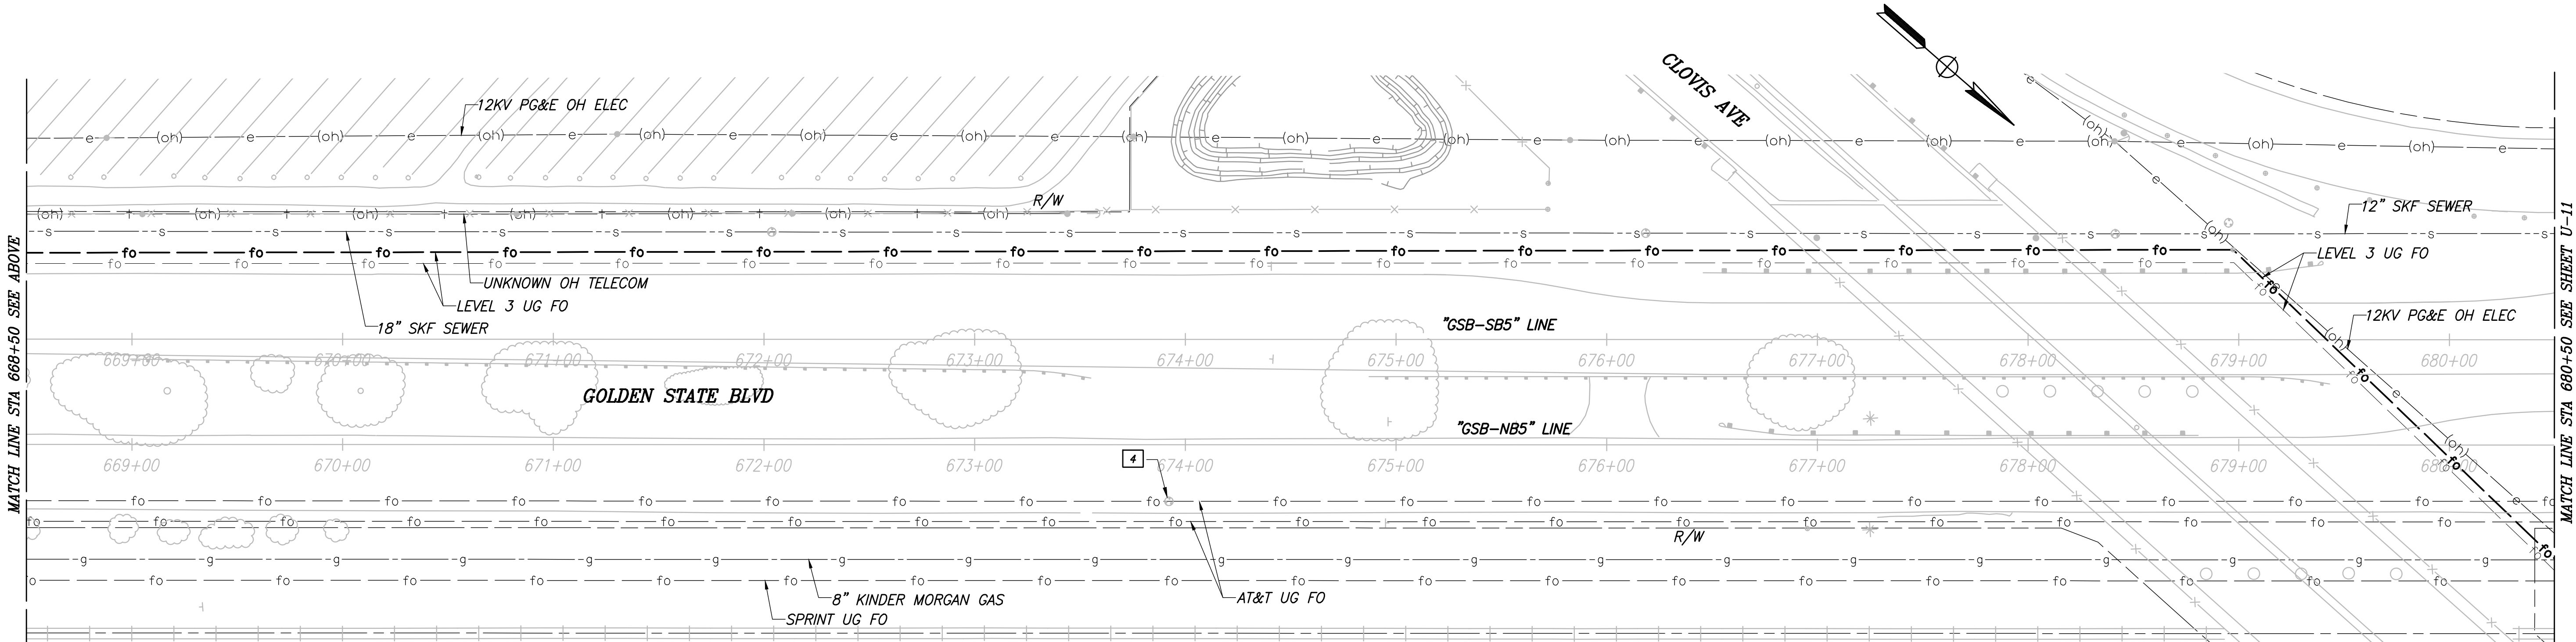

RECORD DRAWING		DATE
DESIGNED: ERIK CHIN	####	
DRAWN: DILLON ALAMEDA	####	
CHECKED: ED NORIEGA	####	


FOR RIGHT OF WAY DATA AND ACCURATE ACCESS DETERMINATION, SEE DOCUMENTS IN THE DEPARTMENT OF PUBLIC WORKS AND PLANNING.



TENTATIVE PLANS FOR DESIGN
SUPERVISING ENGINEER
DATE




PROJECT
GOLDEN STATE CORRIDOR - ECONOMIC DEVELOPMENT AND INFRASTRUCTURE IMPROVEMENTS
FOWLER REGION

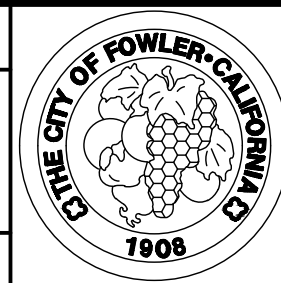


DEPARTMENT OF PUBLIC WORKS AND PLANNING
UTILITY PLAN
DRAWING NO. U-10 SHEET NO. 82 TOTAL 142

PLOT DATE: 4/2/2021 8:39:39 AM CAD USER: NYANFS

PATH: J:\Fresno COG-FN-16105-GSB Final Design\CADD\Sheets\Region 3 - Fowler\GSB_R3_U8-U14.dwg

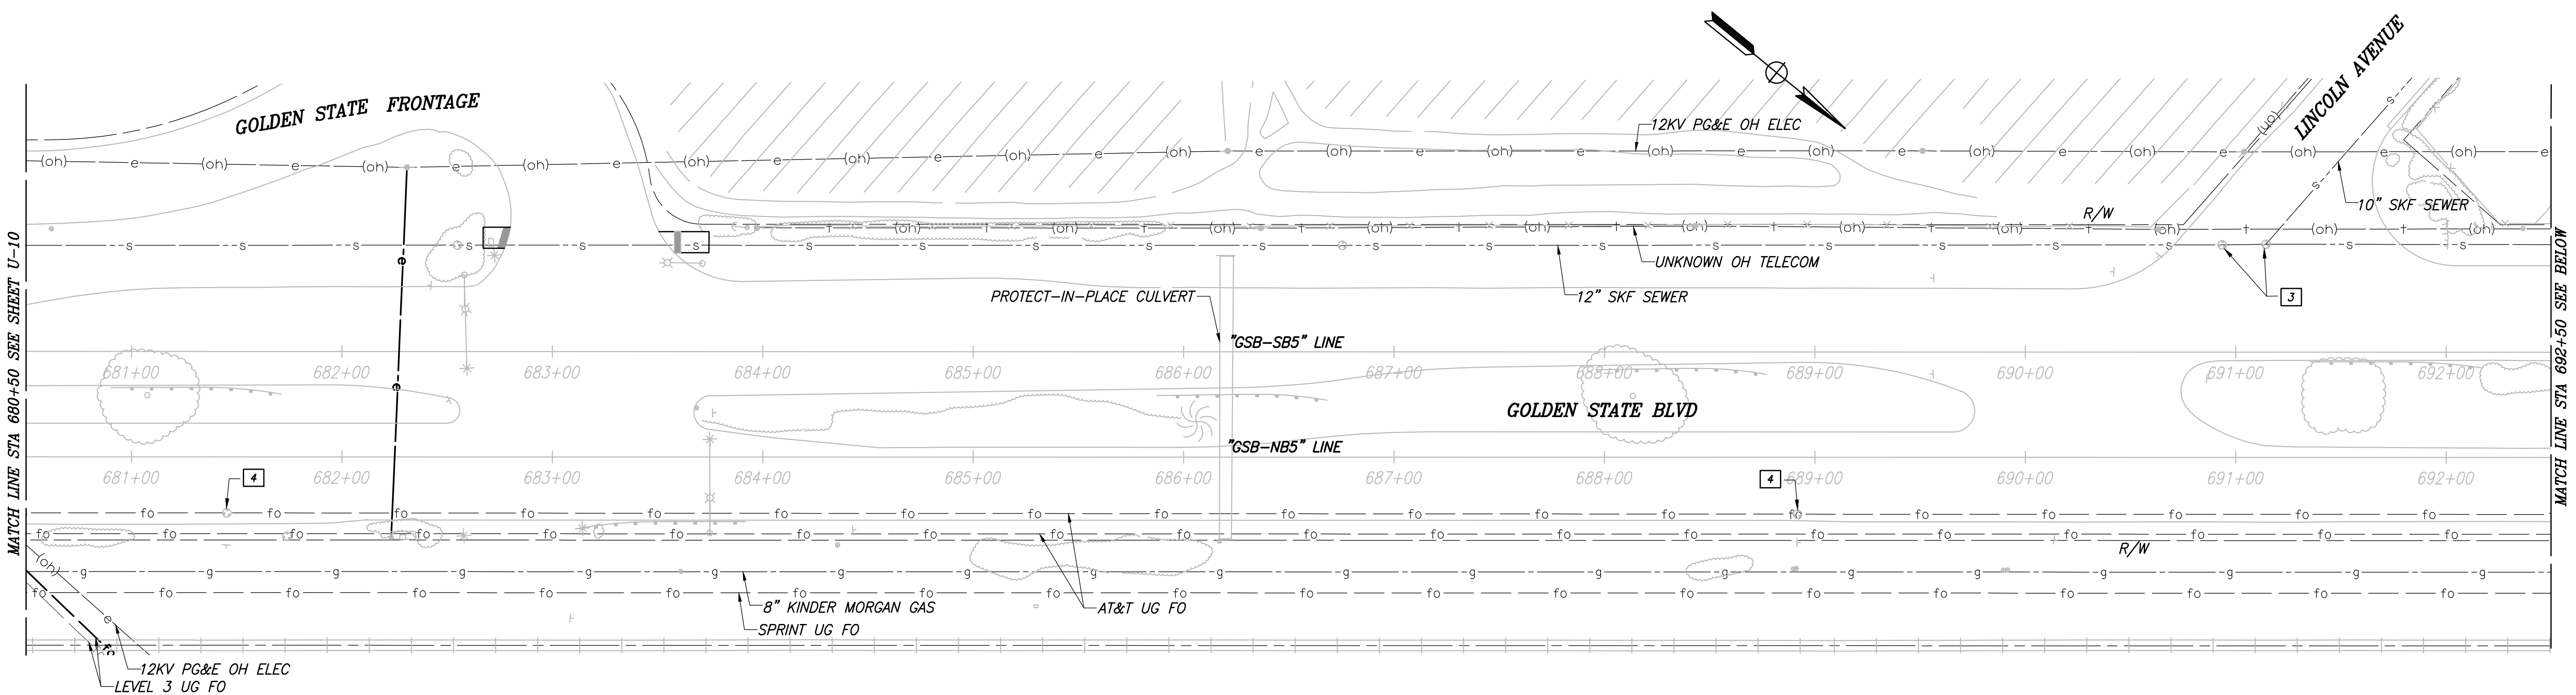

CITY OF FOWLER
GOLDEN STATE BLVD
SCALE: 1" = 40'

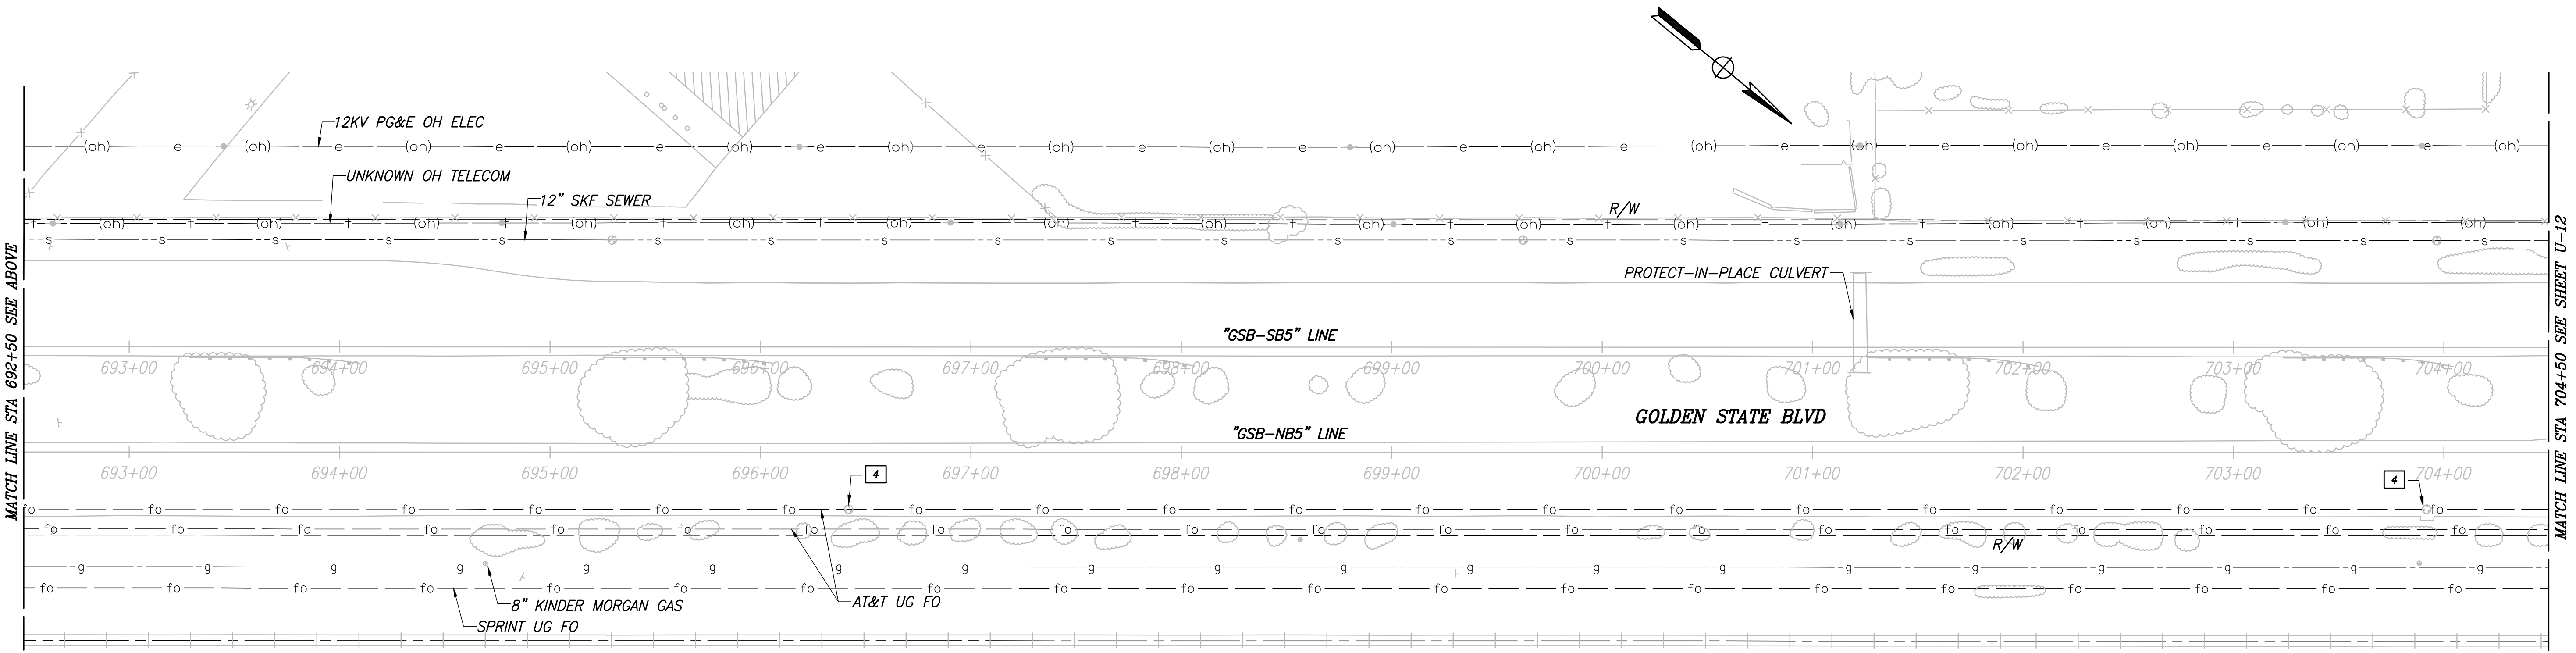

RECORD DRAWING			
DESIGNED: ERIK CHIN	DATE: ####	RESIDENT ENGINEER	DATE
DRAWN: DILLON ALAMEDA	DATE: ####		
CHECKED: ED NORIEGA	DATE: ####		


FOR RIGHT OF WAY DATA AND ACCURATE ACCESS DETERMINATION, SEE DOCUMENTS IN THE DEPARTMENT OF PUBLIC WORKS AND PLANNING.



TENTATIVE PLANS FOR DESIGN
SUPERVISING ENGINEER
DATE




PROJECT
GOLDEN STATE CORRIDOR - ECONOMIC DEVELOPMENT AND INFRASTRUCTURE IMPROVEMENTS
FOWLER REGION

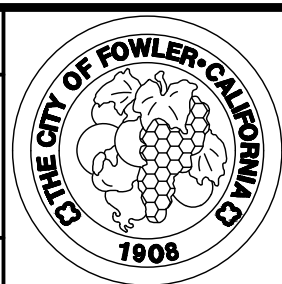


DEPARTMENT OF PUBLIC WORKS AND PLANNING
UTILITY PLAN
DRAWING NO. U-11 SHEET NO. 83 TOTAL 142

PLOT DATE: 4/2/2021 8:40:02 AM
 CAD USER: NYANES

PATH: J:\Fresno COG-FN-16105-GSB Final Design\CADD\Sheets\Region 3 - Fowler\GSB_R3_U8-U14.dwg

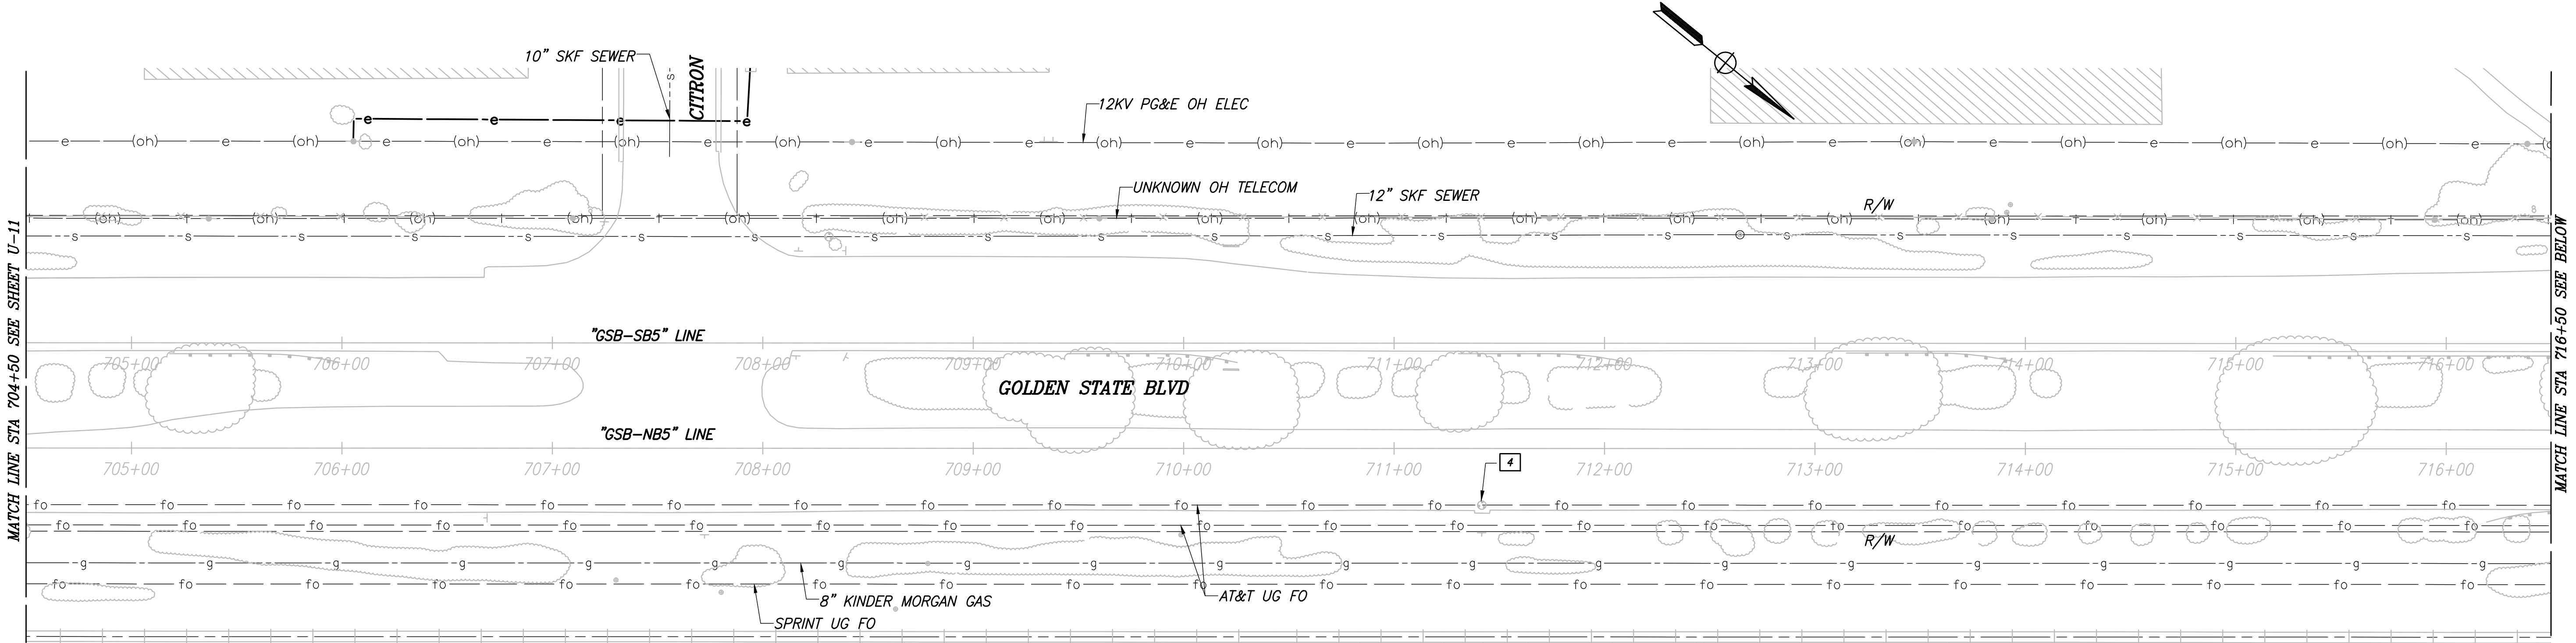

CITY OF FOWLER
 GOLDEN STATE BLVD
 SCALE: 1" = 40'

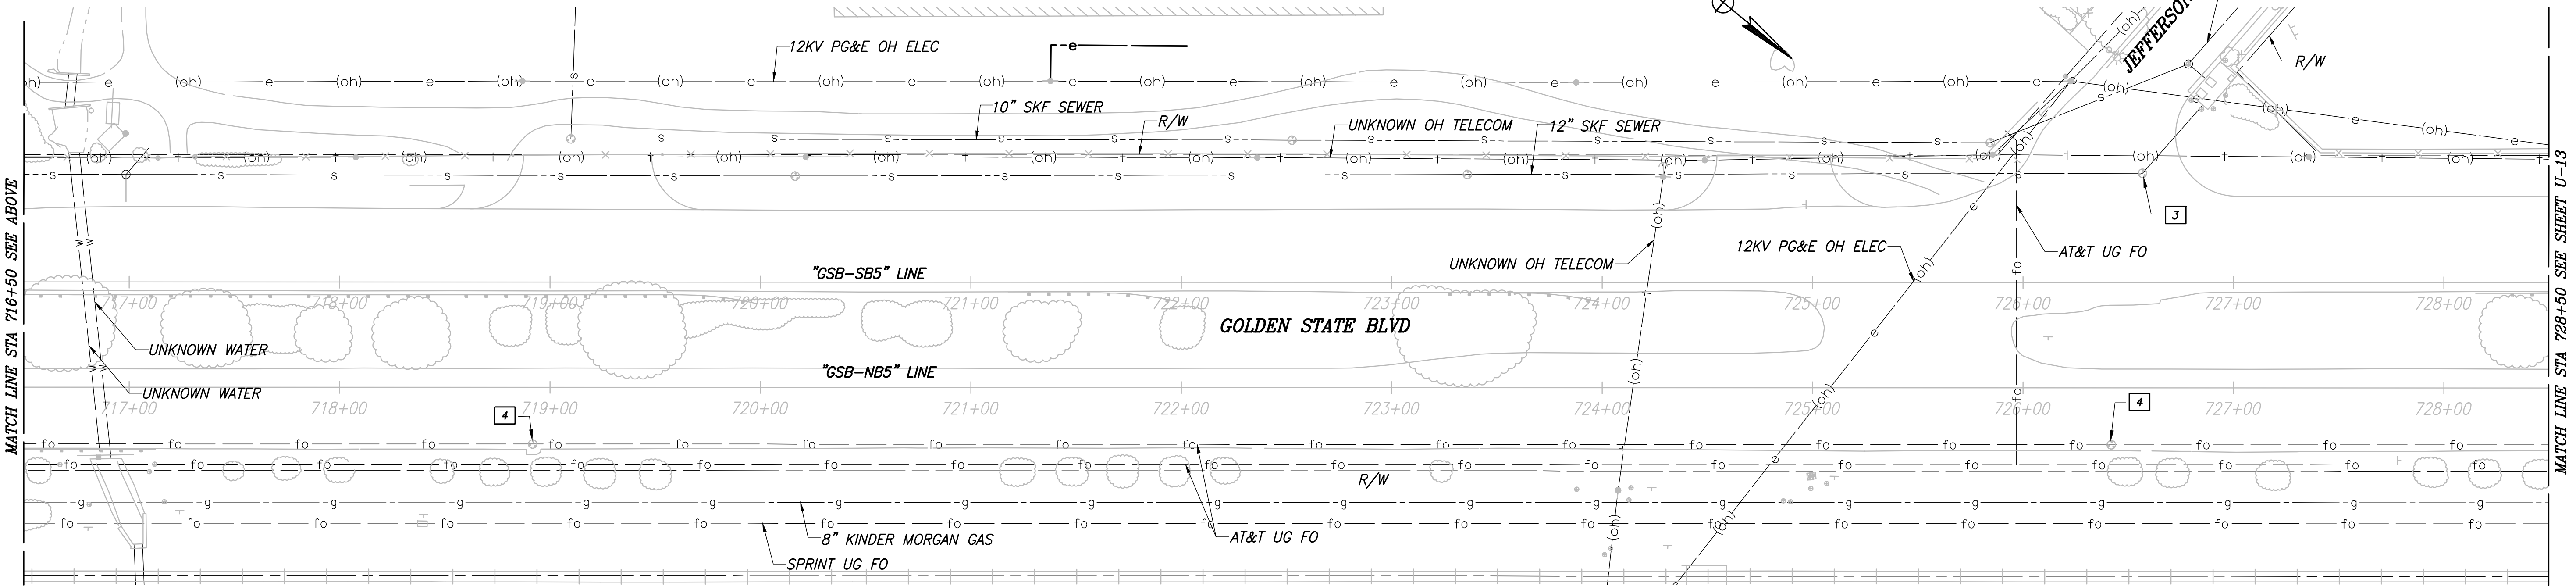

	DATE	RECORD DRAWING	
DESIGNED: ERIK CHIN	####	RESIDENT ENGINEER	DATE
DRAWN: DILLON ALAMEDA	####		
CHECKED: ED NORIEGA	####		


FOR RIGHT OF WAY DATA AND ACCURATE ACCESS DETERMINATION, SEE DOCUMENTS IN THE DEPARTMENT OF PUBLIC WORKS AND PLANNING.



TENTATIVE PLANS FOR DESIGN	DATE
SUPERVISING ENGINEER	




PROJECT
GOLDEN STATE CORRIDOR - ECONOMIC DEVELOPMENT AND INFRASTRUCTURE IMPROVEMENTS
FOWLER REGION

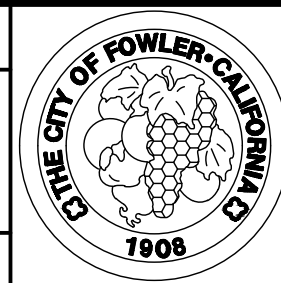


DEPARTMENT OF PUBLIC WORKS AND PLANNING		
UTILITY PLAN		
DRAWING NO. U-12	SHEET NO. 84	TOTAL 142

PLOT DATE: 4/2/2021 8:40:28 AM
 CAD USER: NYANES

PATH: J:\Fresno COG-FN-16105-GSB Final Design\CADD\Sheets\Region 3 - Fowler\GSB_R3_U8-U14.dwg

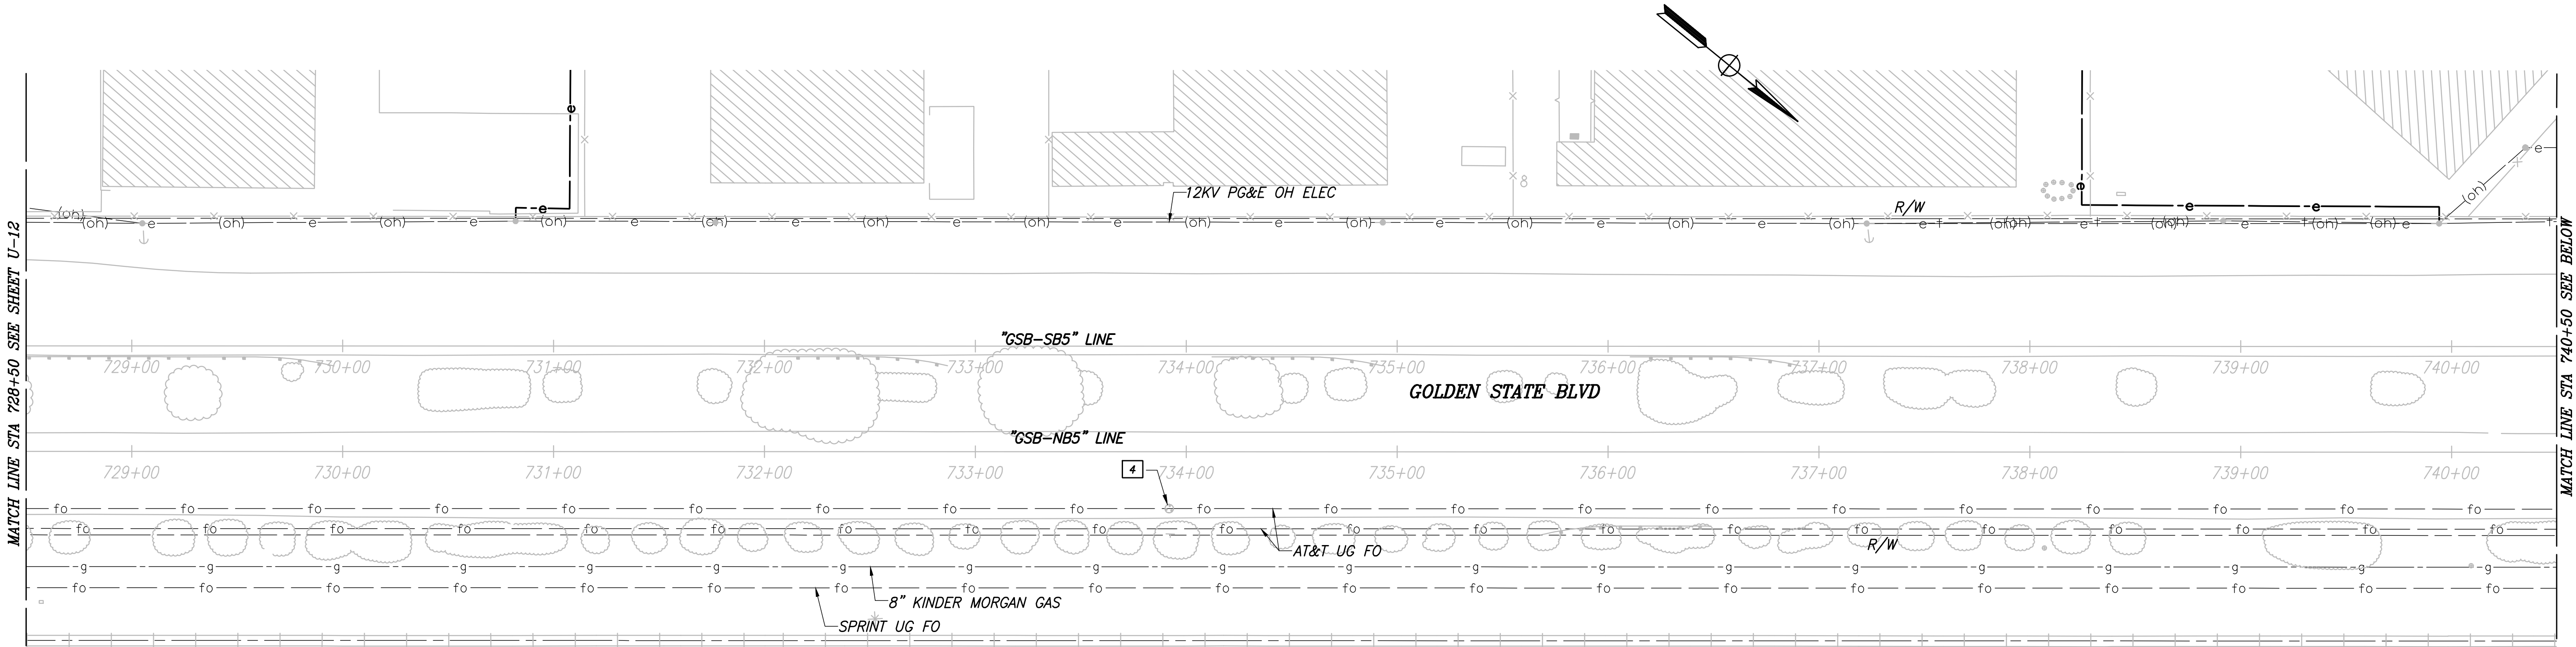


CITY OF FOWLER
 GOLDEN STATE BLVD
 SCALE: 1" = 40'

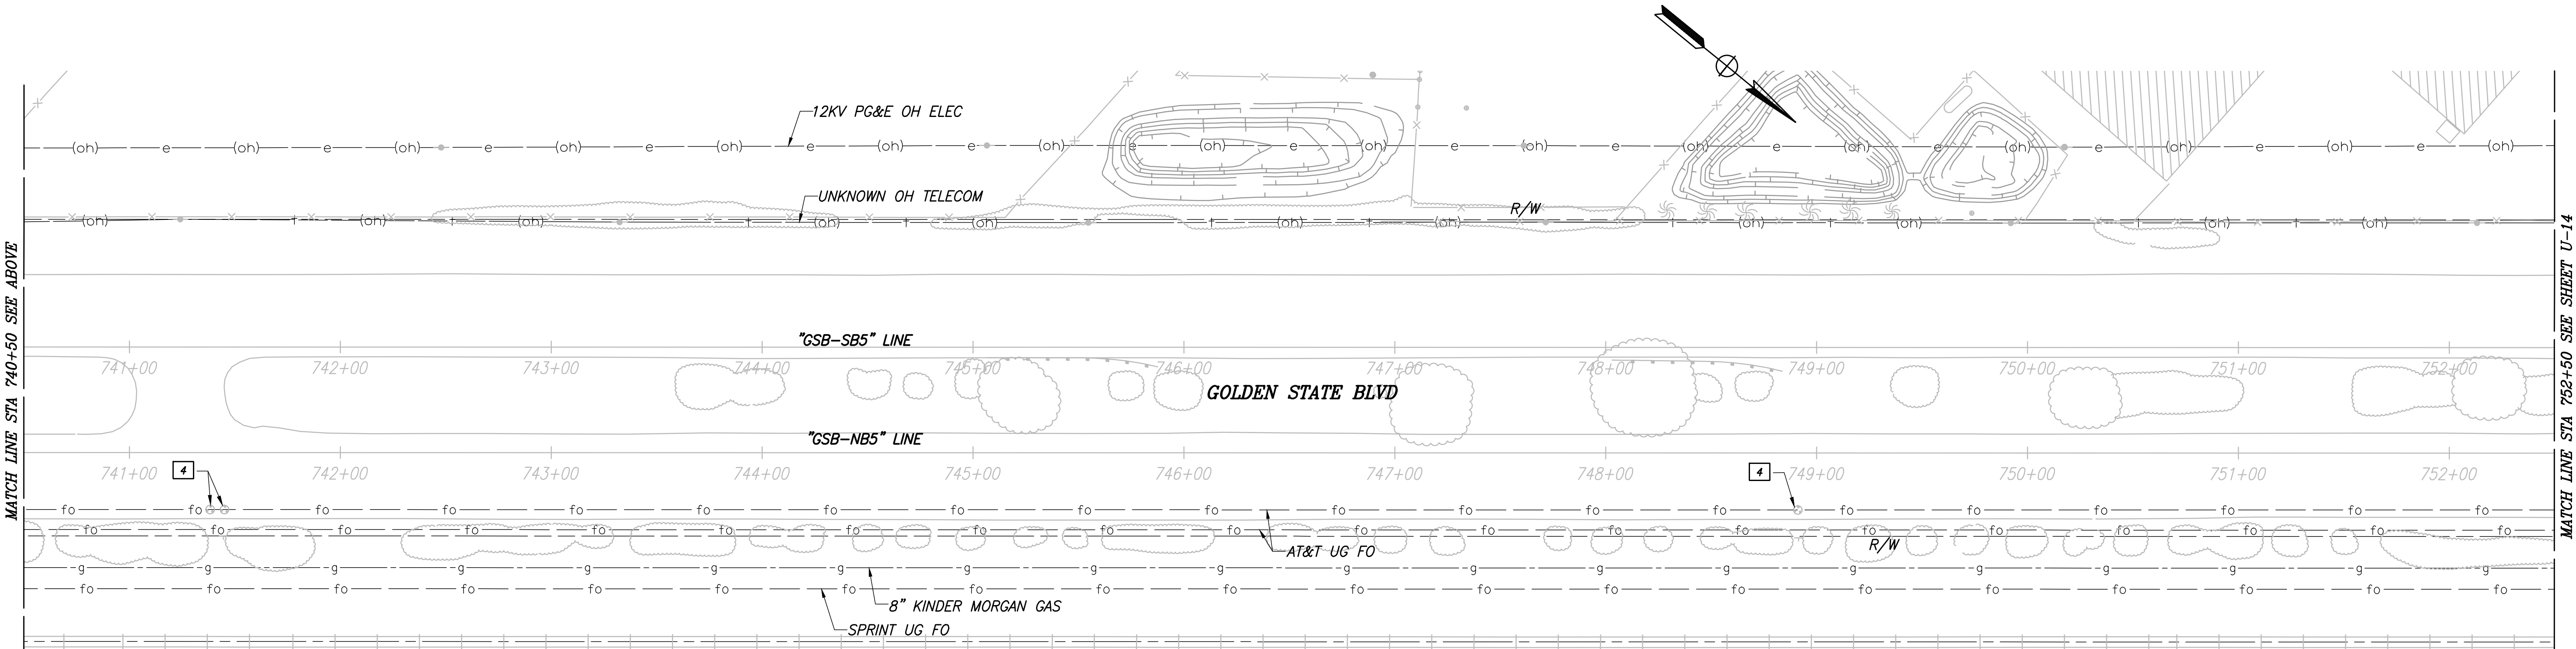

	DATE	RECORD DRAWING	
DESIGNED: ERIK CHIN	####	RESIDENT ENGINEER	DATE
DRAWN: DILLON ALAMEDA	####		
CHECKED: ED NORIEGA	####		

FOR RIGHT OF WAY DATA AND ACCURATE ACCESS DETERMINATION, SEE DOCUMENTS IN THE DEPARTMENT OF PUBLIC WORKS AND PLANNING.

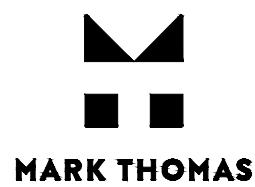


TENTATIVE PLANS FOR DESIGN


SUPERVISING ENGINEER DATE



PROJECT
 GOLDEN STATE CORRIDOR - ECONOMIC DEVELOPMENT AND INFRASTRUCTURE IMPROVEMENTS
 FOWLER REGION

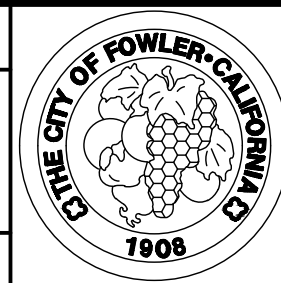

DEPARTMENT OF PUBLIC WORKS AND PLANNING
 UTILITY PLAN
 DRAWING NO. U-13 SHEET NO. 85 TOTAL 142

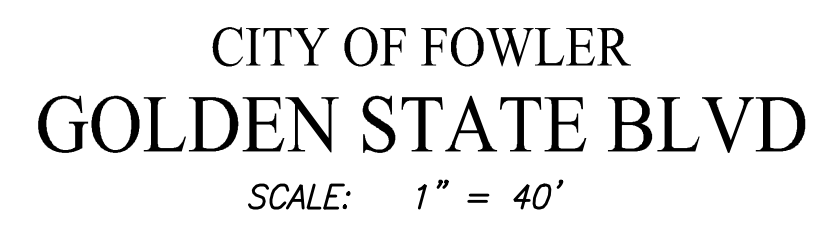

	DATE	RECORD DRAWING		 CALL BEFORE YOU DIG	 MARK THOMAS		PROJECT			<i>DEPARTMENT OF PUBLIC WORKS AND PLANNING</i>		
DESIGNED: ERIK CHIN	####	RESIDENT ENGINEER	DATE				GOLDEN STATE CORRIDOR - ECONOMIC DEVELOPMENT AND INFRASTRUCTURE IMPROVEMENTS			UTILITY PLAN		
DRAWN: DILLON ALAMEDA	####											
CHECKED: ED NORIEGA	####						FOWLER REGION					
FOR RIGHT OF WAY DATA AND ACCURATE ACCESS DETERMINATION, SEE DOCUMENTS IN THE DEPARTMENT OF PUBLIC WORKS AND PLANNING.							DATE			DRAWING NO. U-14		
							SHEET NO. 86		TOTAL 142			

CAD USER: ESF@FVLEDA
PLOT DATE: 4/2/2021 8:41:21 AM


PATH: J:\Fresno COG-FN-16105-GSB Final Design\CADD Sheets\Region 3 - Fowler\GSB_R3_CS-1.dwg

NOTES

1. LOCATIONS OF CONSTRUCTION AREA SIGNS ARE APPROXIMATE. EXACT LOCATIONS TO BE DETERMINED BY THE ENGINEER.
2. ALL TRAFFIC CONTROL SHALL CONFORM WITH THE MOST RECENT 2015 CALTRANS STANDARD PLANS AND THE CALIFORNIA MANUAL FOR UNIFORM TRAFFIC CONTROL DEVICES (MUTCD).
3. CHANGEABLE MESSAGE SIGNS SHALL BE PLACED TWO WEEKS PRIOR TO CONSTRUCTION.
4. CONTRACTOR TO PROVIDE REASONABLE MEANS FOR PROPERTY OWNERS ADJACENT CONSTRUCTION TO ACCESS PROPERTIES AT ALL TIMES.
5. CONTRACTOR TO COORDINATE ANY DRIVEWAY CLOSURES WITH PROPERTY OWNERS BEFORE REMOVING ACCESS.
6. CONTRACTOR TO PROVIDE A MINIMUM OF ONE-11' LANE, IN EACH DIRECTION, ACCESS ALONG GOLDEN STATE BOULEVARD AND 8TH STREET AT ALL TIMES.

LEGEND


- RECONSTRUCT ROADWAY AREA
- TEMPORARY ROADWAY CLOSURE (LOCAL ACCESS ONLY)
- CONSTRUCTION AREA SIGN SINGLE POST
- TRAFFIC AREA DIRECTION
- CHANGEABLE MESSAGE SIGN (CMS)
- TYPE III BARRICADE

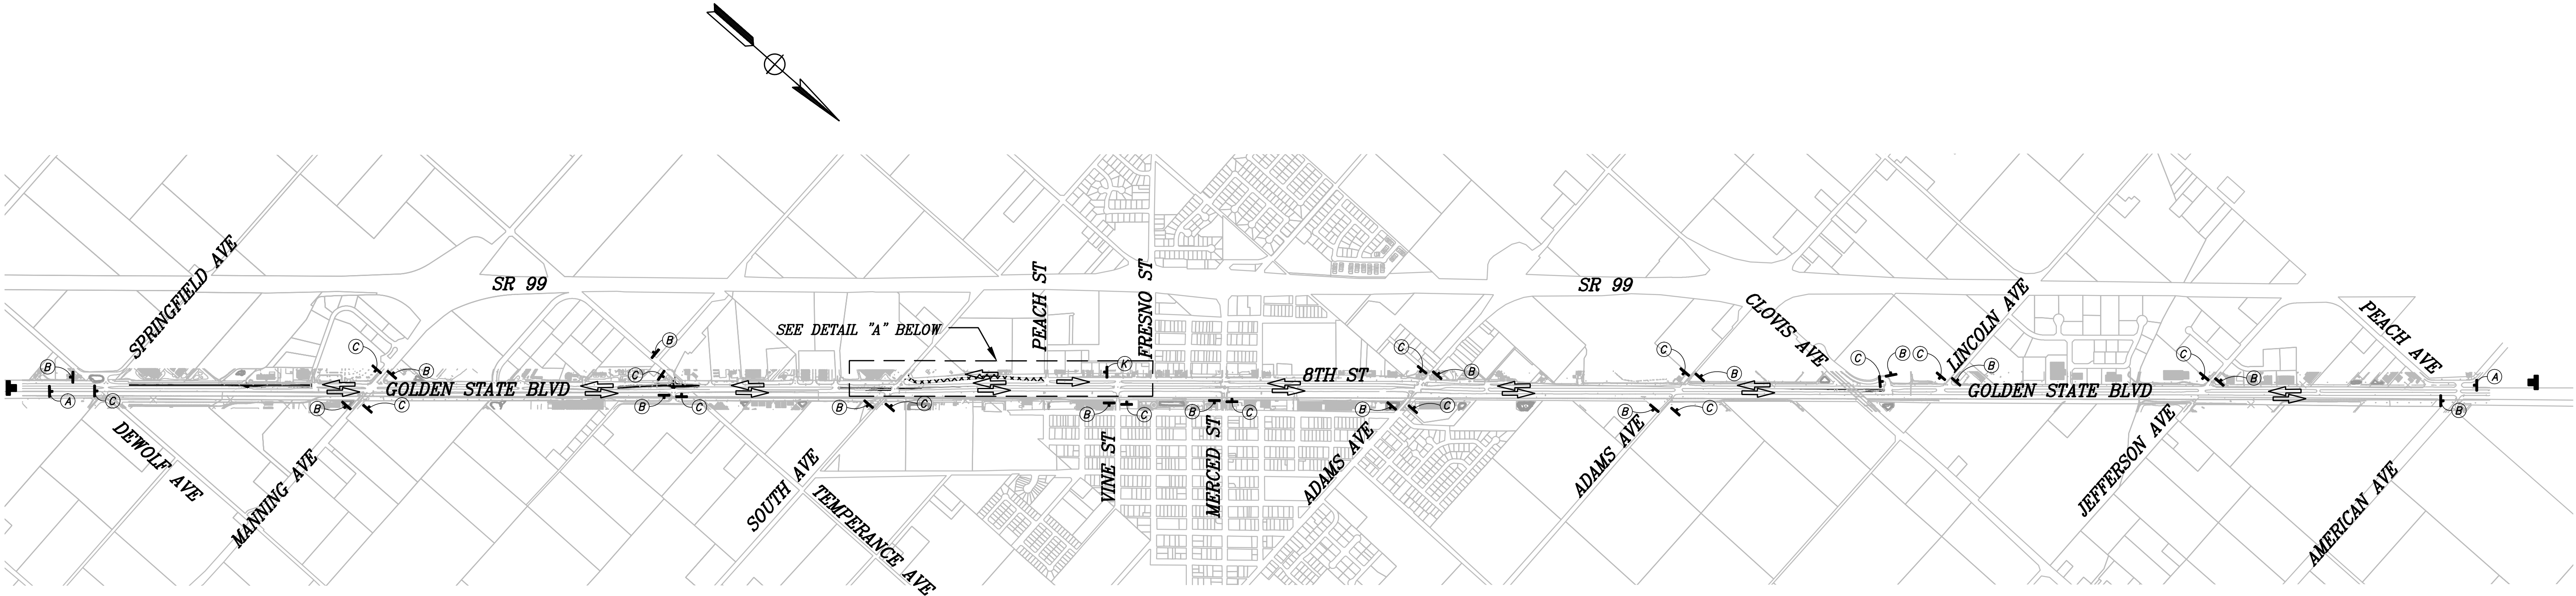

STATIONARY MOUNTED CONSTRUCTION AREA SIGNS

SIGN LETTER	SIGN CODE	PANEL SIZE	SIGN MESSAGE	EACH [N]
A	G20-1	90"x48"	ROAD WORK NEXT 7 MILES	2
B	G20-2	36"x18"	END ROAD WORK	15
C	W20-1	36"x36"	ROAD WORK AHEAD	15
D	W20-3	36"x36"	ROAD CLOSED AHEAD	1
E	W20-2	36"x36"	DETOUR AHEAD	1
F	R11-4	60"x30"	ROAD CLOSED TO THRU TRAFFIC	2
G	M4-10(R)	48"x18"	DETOUR ARROW RIGHT	1
H	M4-10(L)	48"x18"	DETOUR ARROW LEFT	1
I	M4-8A	24"x18"	END DETOUR	1
J	M4-9	30"x24"	DETOUR WITH ARROW LEFT	2
K	M4-9	30"x24"	DETOUR WITH ARROW RIGHT	1
L	D3-1	30"x18"	8TH STREET	3
TOTAL				45

[N] NOT A SEPARATE PAY ITEM, FOR INFORMATION ONLY.

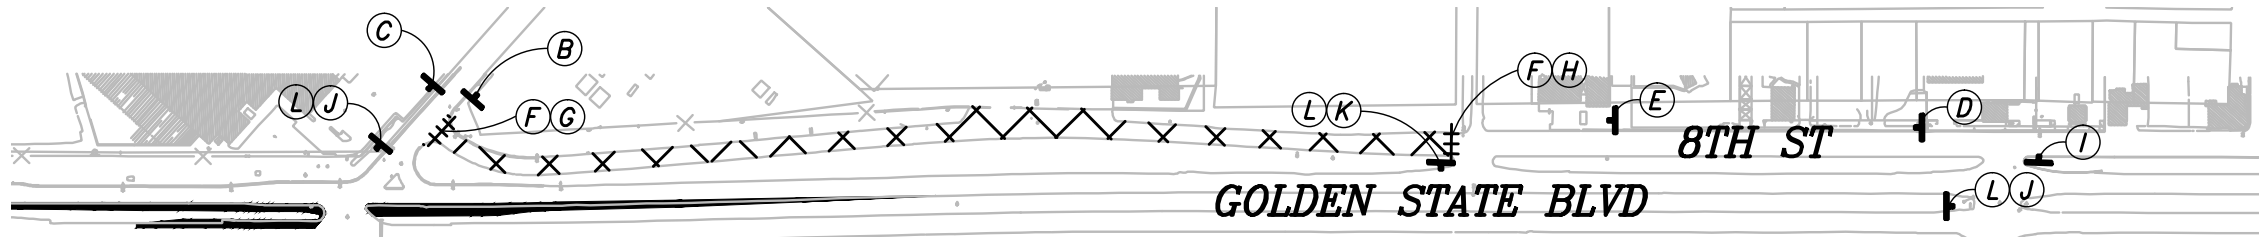

DETAIL "A"

DESIGNED: ERIK CHIN

DRAWN: DILLON ALAMEDA

CHECKED: DANIEL ROEBAER

DATE: ####

DATE: ####

DATE: ####

FOR RIGHT OF WAY DATA AND ACCURATE ACCESS DETERMINATION, SEE DOCUMENTS IN THE DEPARTMENT OF PUBLIC WORKS AND PLANNING.

811

CALL BEFORE YOU DIG

MARK THOMAS

SUPERVISING ENGINEER

DATE: 4/2/21

PROJECT

GOLDEN STATE CORRIDOR - ECONOMIC DEVELOPMENT AND INFRASTRUCTURE IMPROVEMENTS

FOWLER REGION

THE CITY OF FOWLER, CALIFORNIA

1908

DEPARTMENT OF PUBLIC WORKS AND PLANNING

CONSTRUCTION AREA SIGNS

DRAWING NO. CS-1 SHEET NO. 87 TOTAL 142

CAD USER: NYANES
PLOT DATE: 4/2/2021 8:42:12 AM

PATH: J:\Fresno COG-FN-16105-GSB Final Design\CADD\Sheets\Region 3 - Fowler\GSB_R3_SC1-SC2.dwg
MATCH LINE - SEE TOP RIGHT
MATCH LINE - SEE BOTTOM LEFT

NOTES

1. TRAFFIC CONTROL SHOWN ON PLANS, INCLUDING LOCATIONS OF CONSTRUCTION AREA SIGNS, ARE APPROXIMATE AND INTENDED TO BE UTILIZED FOR STAGING PURPOSES ONLY. ALL TRAFFIC CONTROL SHALL BE APPROVED BY CITY OF FOWLER AND COUNTY OF FRESNO PUBLIC WORKS DEPARTMENT PRIOR TO CONSTRUCTION. ALL SIGN LOCATIONS SHALL BE APPROVED BY THE ENGINEER.
2. ALL TRAFFIC CONTROL SHALL CONFORM WITH THE 2015 CALTRANS STANDARD PLANS AND THE CALIFORNIA MANUAL FOR UNIFORM TRAFFIC CONTROL DEVICES (MUTCD).
3. CONTRACTOR TO PROVIDE A MINIMUM OF ONE-11' LANE OF ACCESS IN EACH DIRECTION ALONG GOLDEN STATE BOULEVARD DURING CONSTRUCTION AT ALL TIMES.
4. CONTRACTOR TO PROVIDE REASONABLE MEANS FOR PROPERTY OWNERS THAT ARE ADJACENT TO CONSTRUCTION TO ACCESS PROPERTIES AT ALL TIMES.
5. CONTRACTOR TO COORDINATE ANY DRIVEWAY CLOSURES WITH PROPERTY OWNERS BEFORE IMPACTING ACCESS.
6. CONTRACTOR SHALL COORDINATE WITH UPRR DURING ALL STAGES OF CONSTRUCTION.

TRAFFIC STAGE 1


1. WORK NOT NECESSARY FOR STAGING OPERATION CAN BE DONE AT ANY TIME AND IS NOT SHOWN.

LEGEND

- CONSTRUCTION THIS STAGE
- CONSTRUCTION THIS STAGE
- CONSTRUCTION ITEM THIS STAGE

CONSTRUCTION STAGE 1

1. CONSTRUCT MEDIAN CONCRETE AND FDR ON SOUTHBOUND GOLDEN STATE BOULEVARD BETWEEN SOUTHERN PROJECT LIMITS AND SAN ANTONIO DRIVE. DO NOT CONSTRUCT FINAL LIFT OF HMA.
2. CONSTRUCT CONVENTIONAL PAVEMENT SLIVER WIDENING BETWEEN SOUTHER PROJECT LIMITS AND MANNING AVENUE. DO NOT CONSTRUCT FINAL LIFT OF HMA.
3. CONSTRUCT FDR, CURB AND GUTTER, AND CONCRETE WORK AT TEMPERANCE AVENUE AND GOLDEN STATE BOULEVARD INTERSECTION. DO NOT CONSTRUCT FINAL LIFT OF HMA.
4. CONSTRUCT CONVENTIONAL PAVEMENT SLIVER WIDENING AT TEMPERANCE AVENUE AND GOLDEN STATE BOULEVARD INTERSECTION. DO NOT CONSTRUCT FINAL LIFT OF HMA.

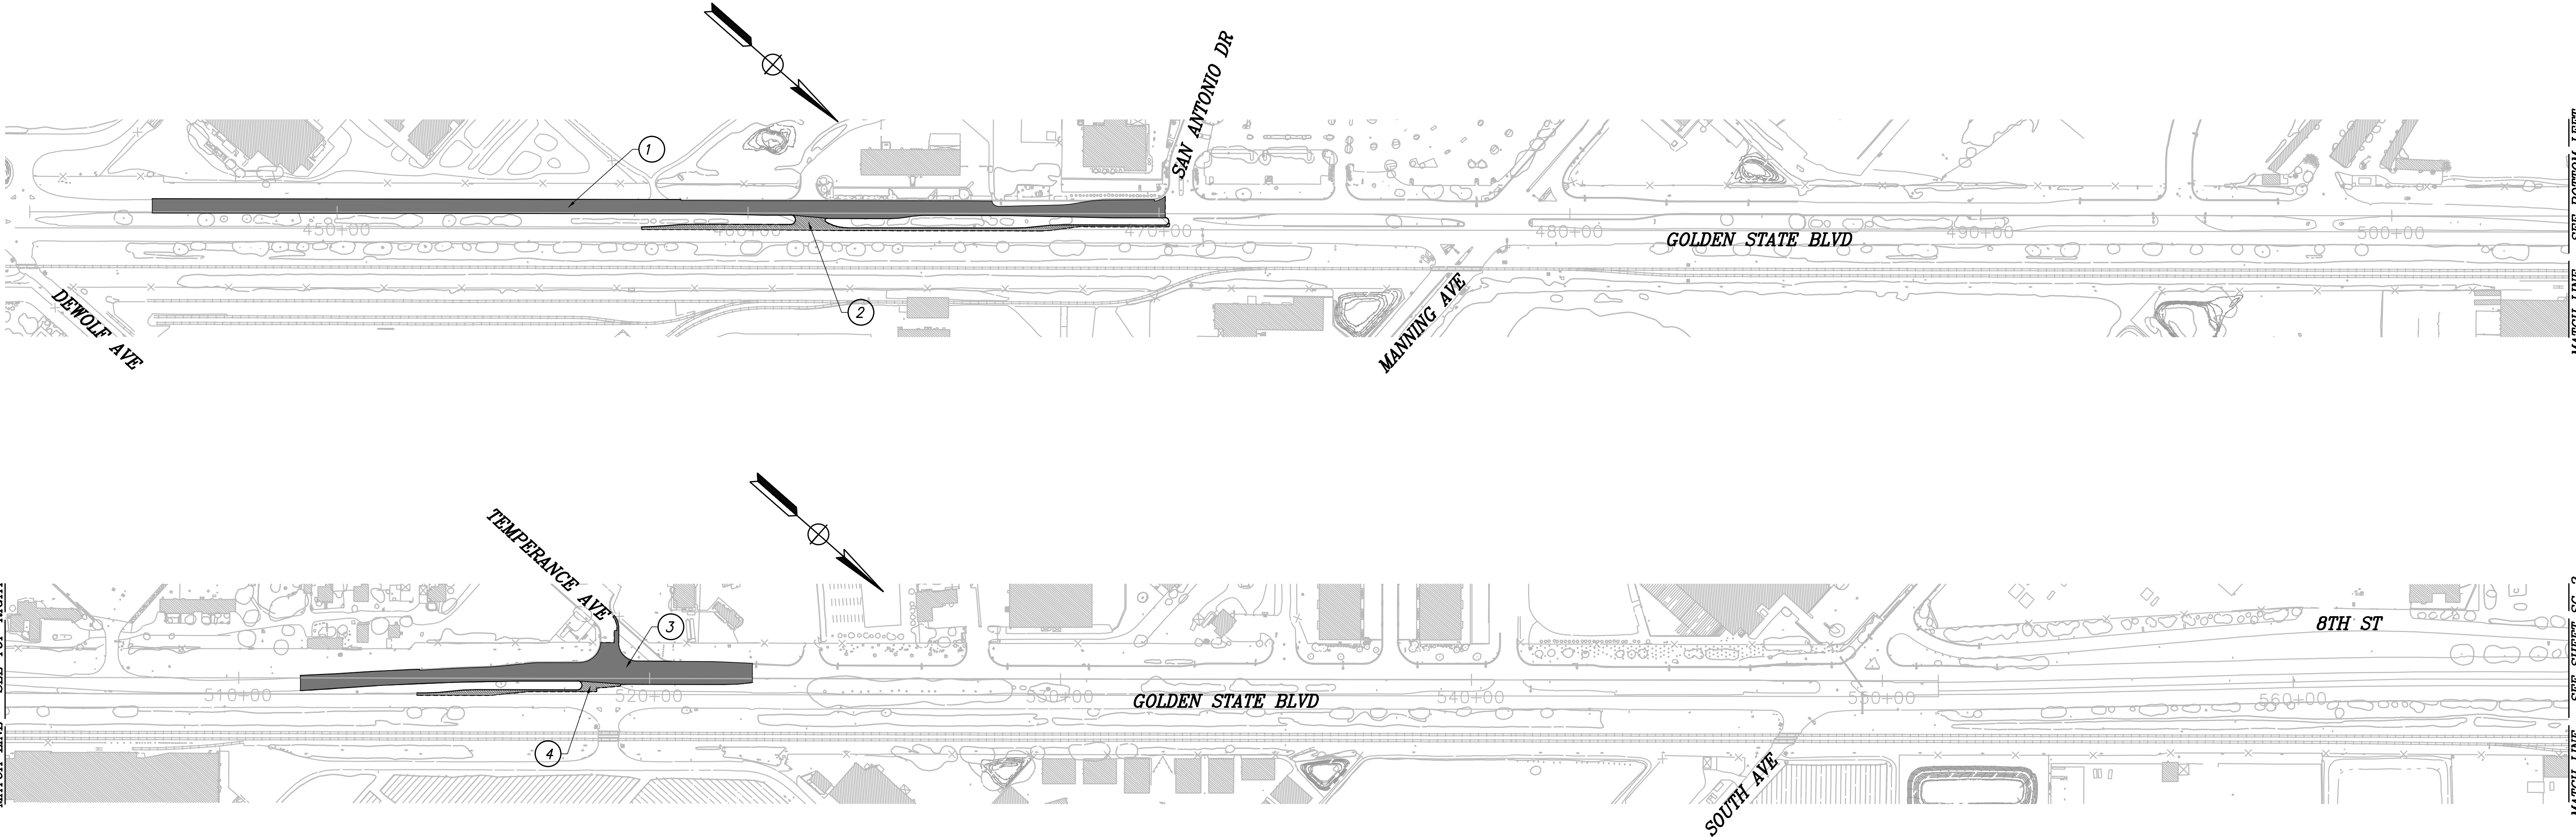

RECORD DRAWING	
DESIGNED: ERIK CHIN	DATE: ####
DRAWN: DILLON ALAMEDA	DATE: ####
CHECKED: DANIEL ROBAER	DATE: ####


FOR RIGHT OF WAY DATA AND ACCURATE ACCESS DETERMINATION, SEE DOCUMENTS IN THE DEPARTMENT OF PUBLIC WORKS AND PLANNING.



TENTATIVE PLANS FOR DESIGN	
SUPERVISING ENGINEER	DATE



PROJECT
GOLDEN STATE CORRIDOR - ECONOMIC DEVELOPMENT AND INFRASTRUCTURE IMPROVEMENTS
FOWLER REGION

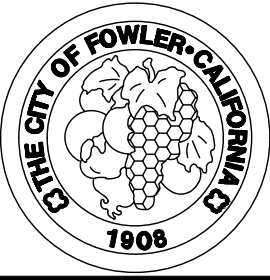

DEPARTMENT OF PUBLIC WORKS AND PLANNING	
STAGE CONSTRUCTION - STAGE 1	

DRAWING NO. SC-1 SHEET NO. 88 TOTAL 142

CAD USER: NYANES


PLOT DATE: 4/2/2021 8:43:08 AM

PATH: J:\Fresno COG-FN-16105-GSB Final Design\CADD\Sheets\Region 3 - Fowler\GSB_R3_SC1-SC2.dwg

MATCH LINE - SEE SHEET SC-1

MATCH LINE - SEE TOP RIGHT

MATCH LINE - SEE MIDDLE RIGHT

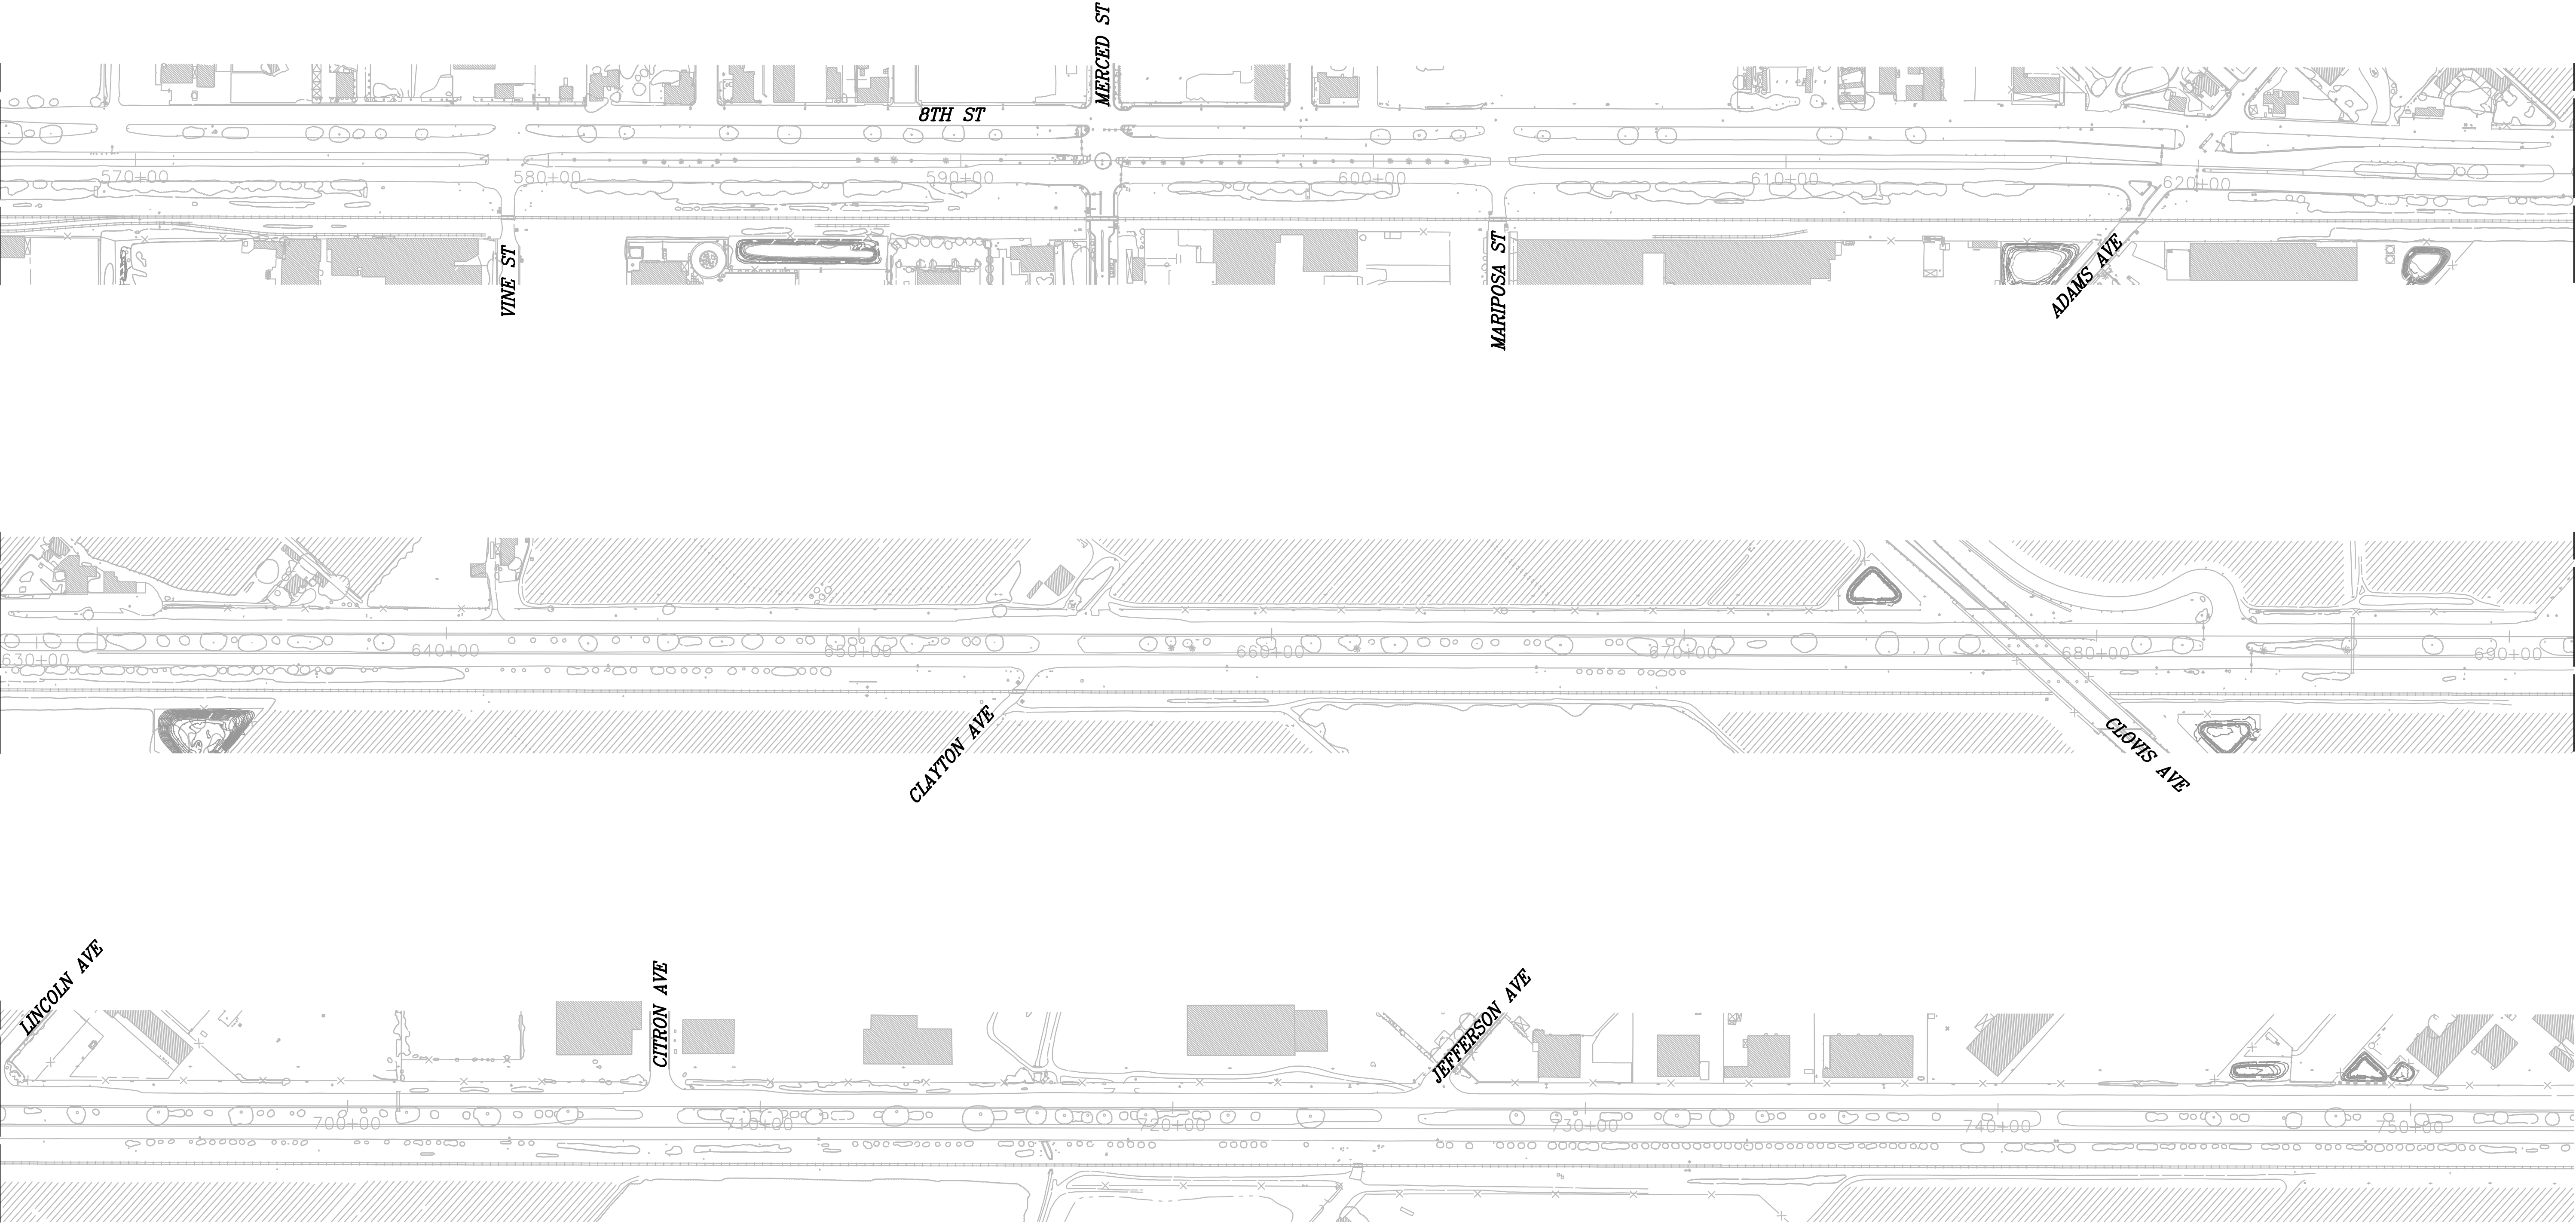

MATCH LINE - SEE MIDDLE LEFT

MATCH LINE - SEE BOTTOM LEFT

RECORD DRAWING	
DESIGNED: ERIK CHIN	DATE: ####
DRAWN: DILLON ALAMEDA	DATE: ####
CHECKED: ED NORIEGA	DATE: ####


FOR RIGHT OF WAY DATA AND ACCURATE ACCESS DETERMINATION, SEE DOCUMENTS IN THE DEPARTMENT OF PUBLIC WORKS AND PLANNING.



TENTATIVE PLANS FOR DESIGN	
SUPERVISING ENGINEER	DATE



PROJECT
GOLDEN STATE CORRIDOR - ECONOMIC DEVELOPMENT AND INFRASTRUCTURE IMPROVEMENTS
FOWLER REGION

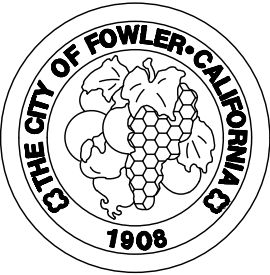

DEPARTMENT OF PUBLIC WORKS AND PLANNING		
STAGE CONSTRUCTION - STAGE 1		
DRAWING NO. SC-2	SHEET NO. 89	TOTAL 142

CAD USER: NYANES

PLOT DATE: 4/2/2021 8:43:58 AM

PATH: J:\Fresno COG-FN-16105-GSB Final Design\CADD\Sheets\Region 3 - Fowler\GSB_R3_SC3 -SC4.dwg

NOTES

1. TRAFFIC CONTROL SHOWN ON PLANS, INCLUDING LOCATIONS OF CONSTRUCTION AREA SIGNS, ARE APPROXIMATE AND INTENDED TO BE UTILIZED FOR STAGING PURPOSES ONLY. ALL TRAFFIC CONTROL SHALL BE APPROVED BY CITY OF FOWLER AND COUNTY OF FRESNO PUBLIC WORKS DEPARTMENT PRIOR TO CONSTRUCTION. ALL SIGN LOCATIONS SHALL BE APPROVED BY THE ENGINEER.
2. ALL TRAFFIC CONTROL SHALL CONFORM WITH THE 2015 CALTRANS STANDARD PLANS AND THE CALIFORNIA MANUAL FOR UNIFORM TRAFFIC CONTROL DEVICES (MUTCD).
3. CONTRACTOR TO PROVIDE A MINIMUM OF ONE-11' LANE OF ACCESS IN EACH DIRECTION ALONG GOLDEN STATE BOULEVARD DURING CONSTRUCTION AT ALL TIMES.
4. CONTRACTOR TO PROVIDE REASONABLE MEANS FOR PROPERTY OWNERS THAT ARE ADJACENT TO CONSTRUCTION TO ACCESS PROPERTIES AT ALL TIMES.
5. CONTRACTOR TO COORDINATE ANY DRIVEWAY CLOSURES WITH PROPERTY OWNERS BEFORE IMPACTING ACCESS.
6. CONTRACTOR SHALL COORDINATE WITH UPRR DURING ALL STAGES OF CONSTRUCTION.

TRAFFIC STAGE 2

1. WORK NOT NECESSARY FOR STAGING OPERATION CAN BE DONE AT ANY TIME AND IS NOT SHOWN.

LEGEND

- CONSTRUCTION THIS STAGE
- #


CONSTRUCTION ITEM THIS STAGE

CONSTRUCTION STAGE 2

- 1

CONSTRUCT CURB AND GUTTER, MEDIAN CURB, SIDEWALK, CURB RAMPS, CONCRETE, AND ADJACENT SHOULDER WORK AS SHOWN ON CD-SHEETS. DO NOT CONSTRUCT FINAL LIFT OF HMA.
- 2



CONSTRUCT REMAINING LEFT TURN LANES, RIGHT TURN LANES, AND WIDENING AREAS. DO NOT CONSTRUCT FINAL LIFT OF HMA.

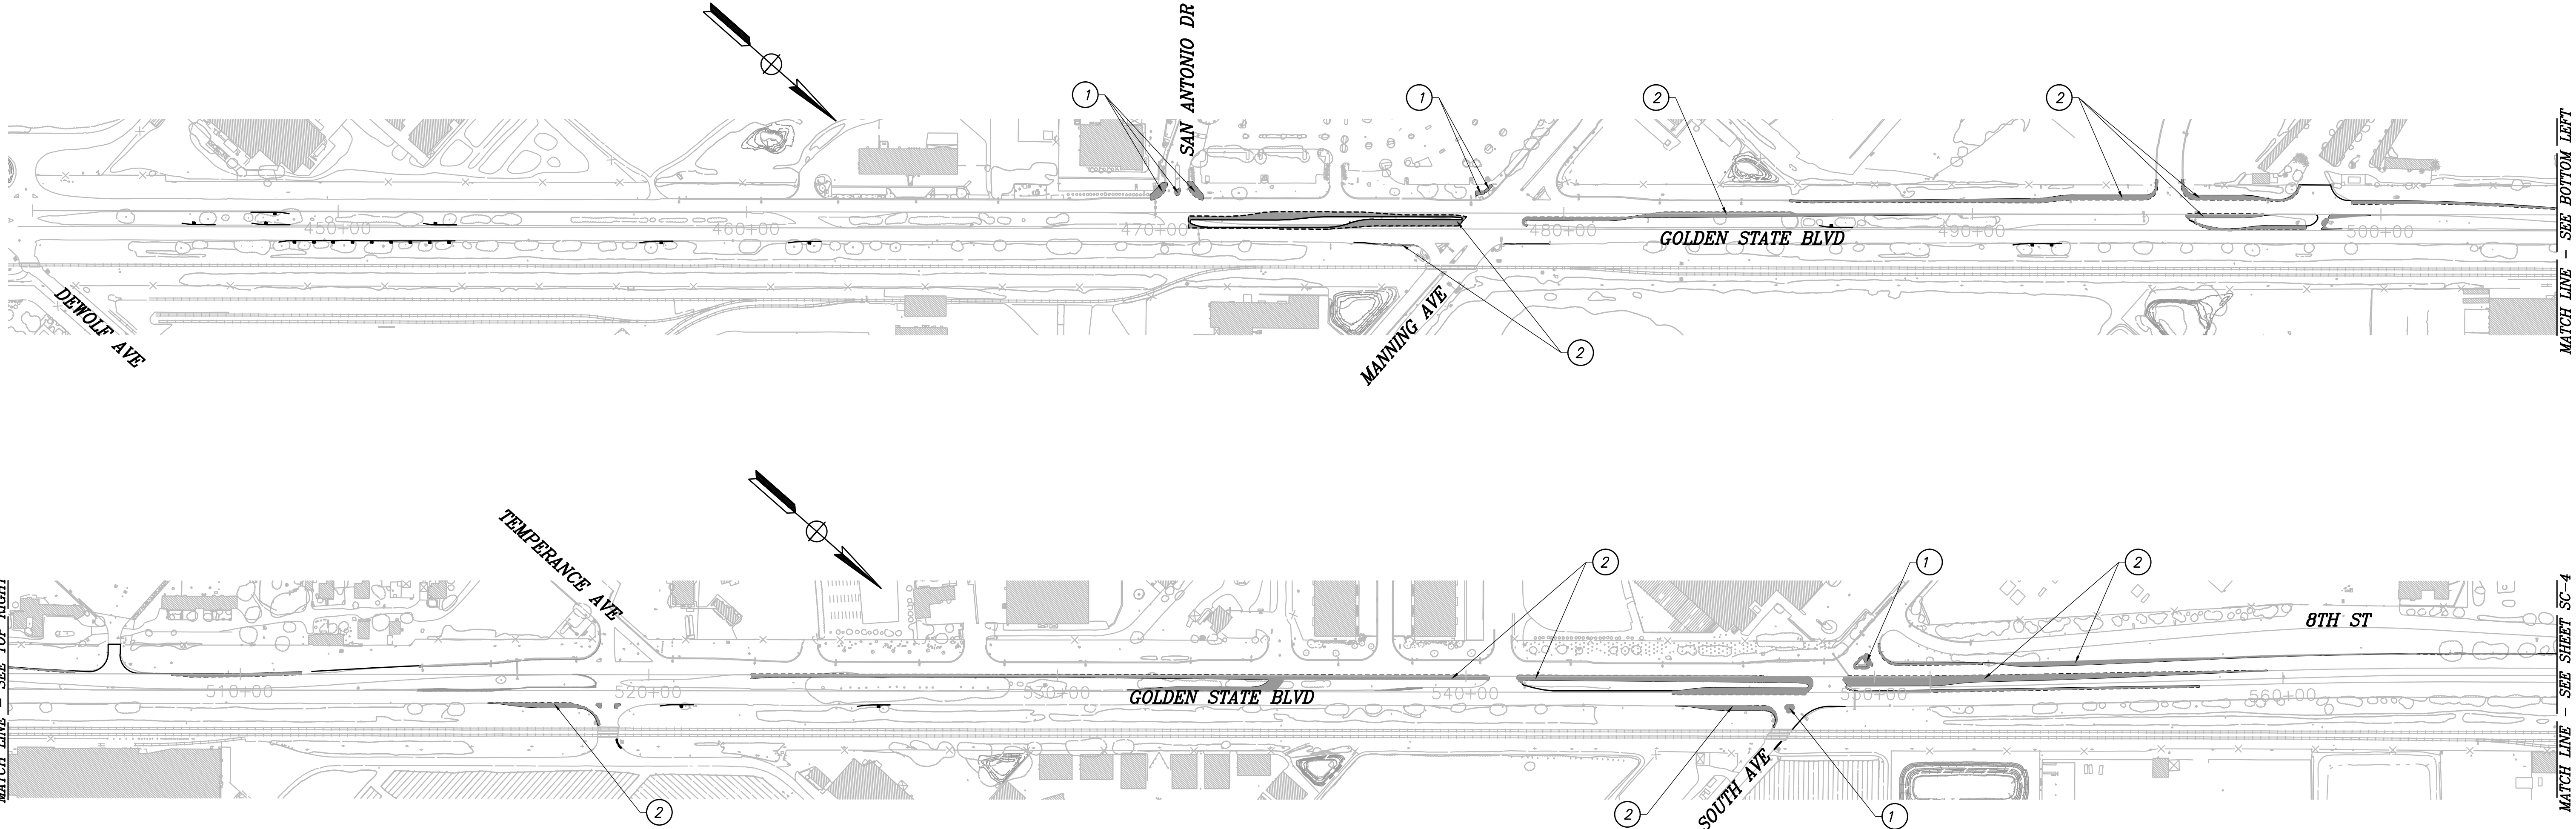

MATCH LINE - SEE TOP RIGHT

MATCH LINE - SEE BOTTOM LEFT

MATCH LINE - SEE SHEET SC-4

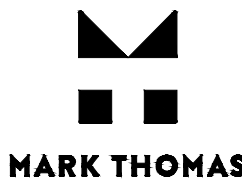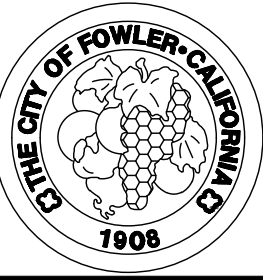DESIGNED: ERIK CHIN		DATE	RECORD DRAWING	
DRAWN: DILLON ALAMEDA		####	RESIDENT ENGINEER	DATE
CHECKED: ED NORIEGA		####		
FOR RIGHT OF WAY DATA AND ACCURATE ACCESS DETERMINATION, SEE DOCUMENTS IN THE DEPARTMENT OF PUBLIC WORKS AND PLANNING.				
				
CALL BEFORE YOU DIG		SUPERVISING ENGINEER		DATE
PROJECT		GOLDEN STATE CORRIDOR - ECONOMIC DEVELOPMENT AND INFRASTRUCTURE IMPROVEMENTS		
FOWLER REGION				
DEPARTMENT OF PUBLIC WORKS AND PLANNING		STAGE CONSTRUCTION - STAGE 2		
DRAWING NO. SC-3		SHEET NO. 90		TOTAL 142

CAD USER: NYANES


PLOT DATE: 4/2/2021 8:44:38 AM

PATH: J:\Fresno COG-FN-16105-GSB Final Design\CADD\Sheets\Region 3 - Fowler\GSB_R3_SC3 -SC4.dwg

MATCH LINE - SEE SHEET SC-3

MATCH LINE - SEE TOP RIGHT

MATCH LINE - SEE MIDDLE RIGHT

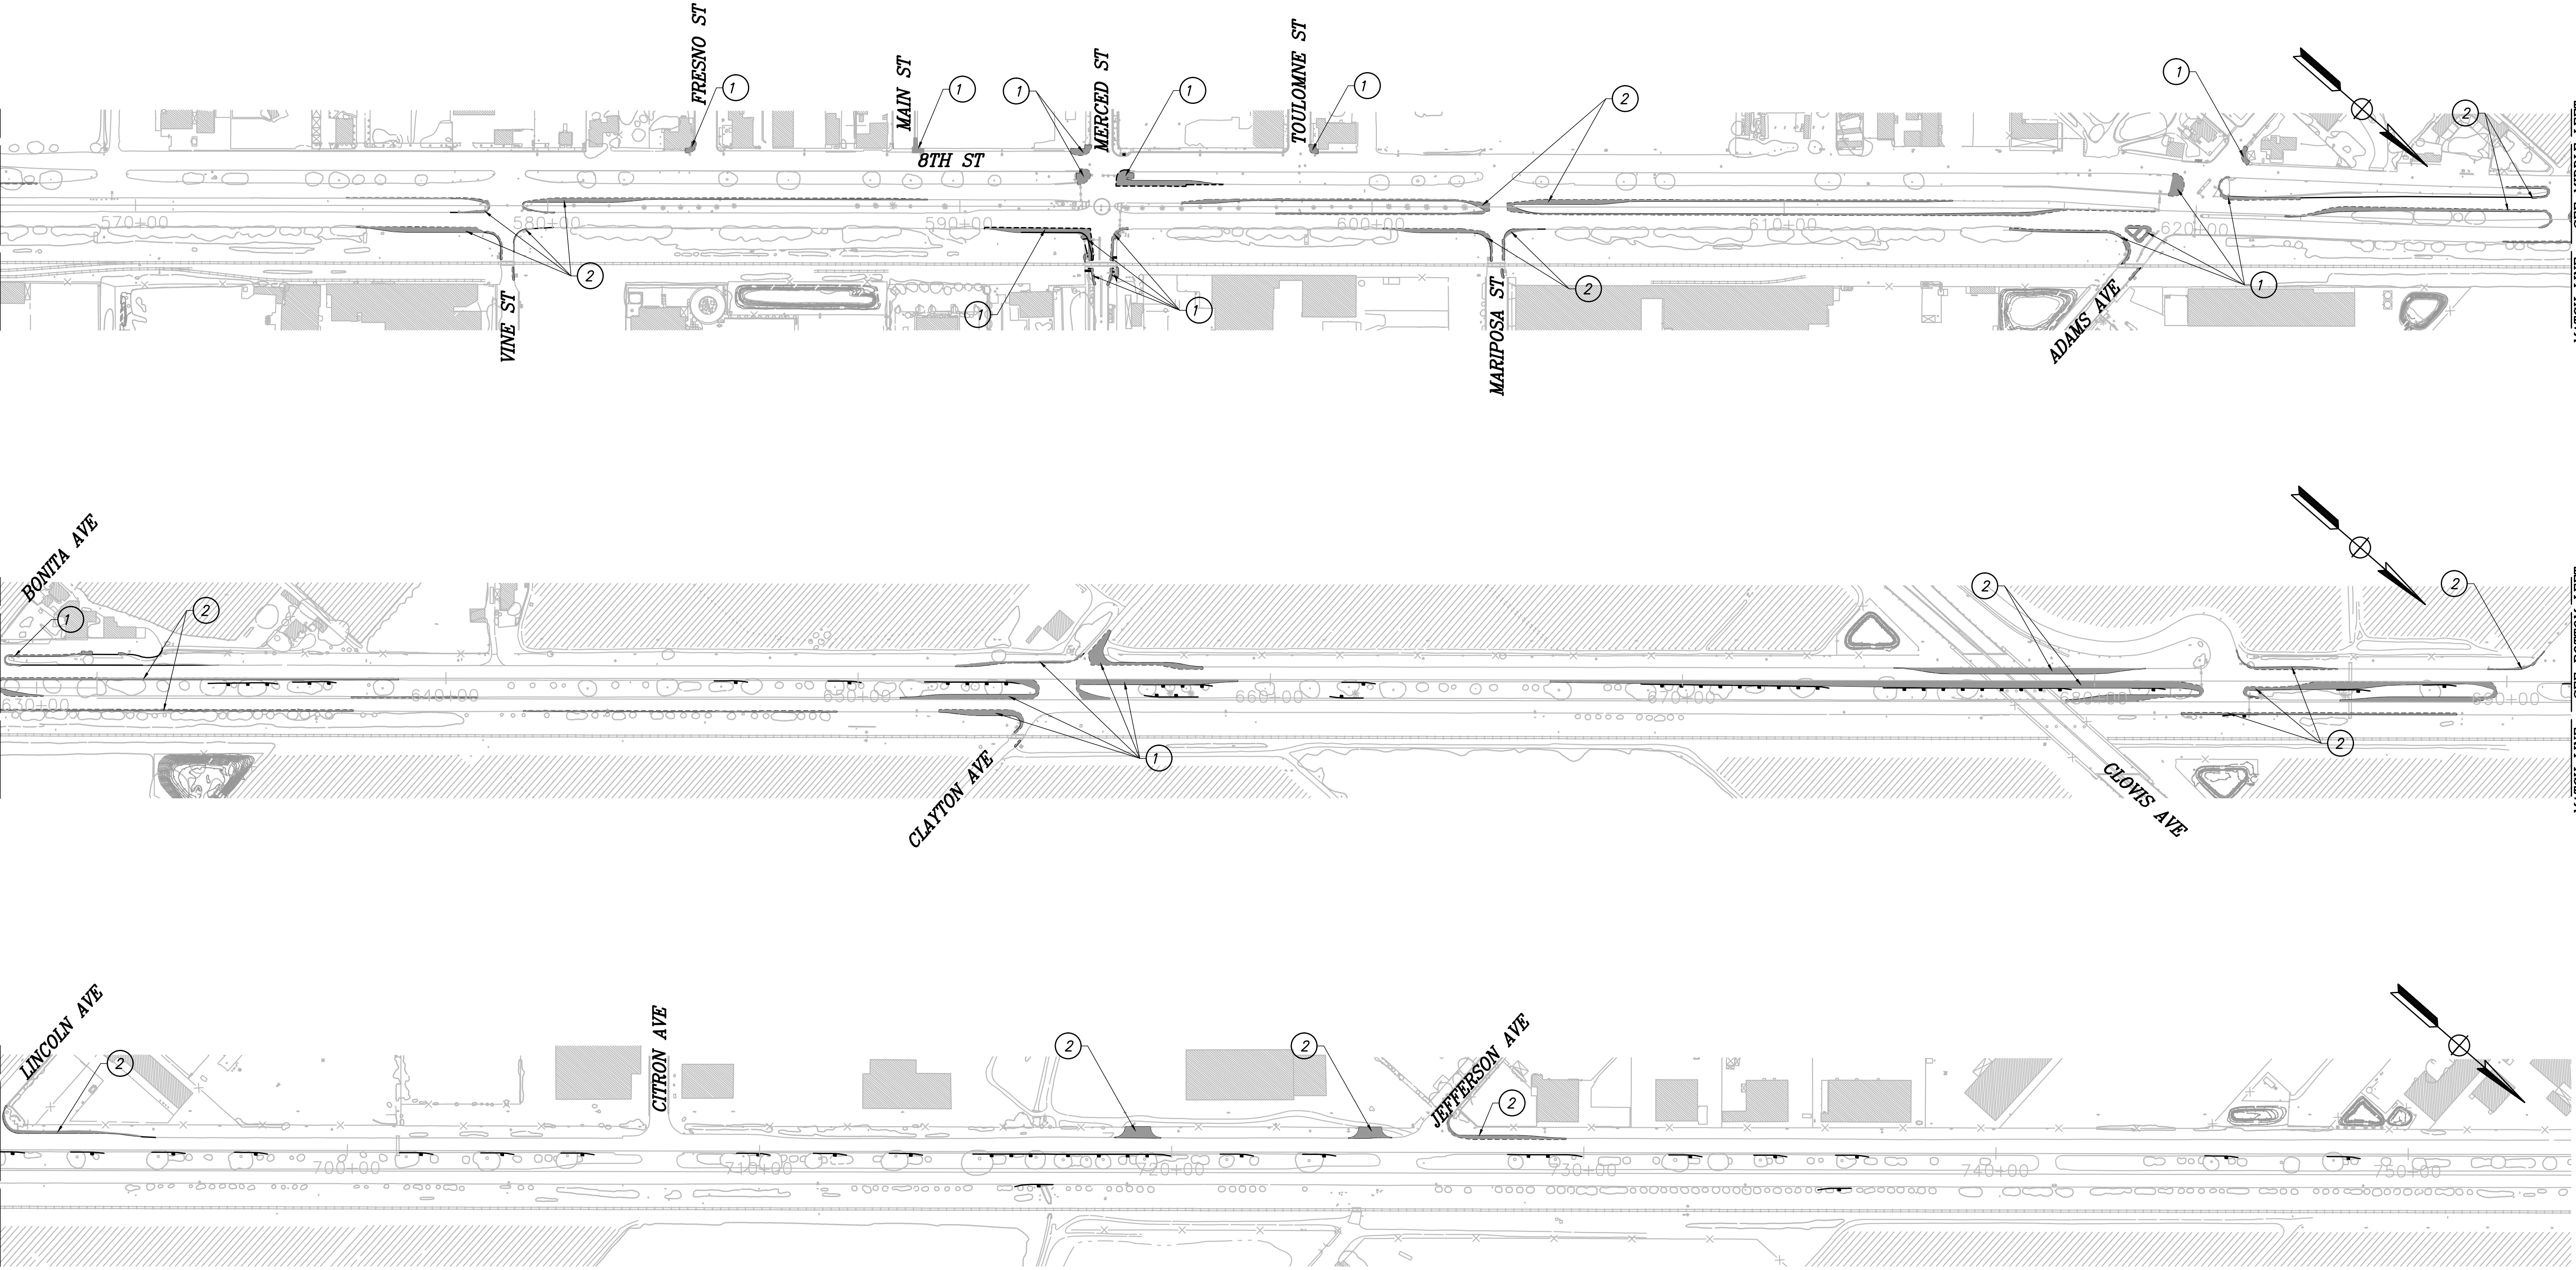

RECORD DRAWING	
DESIGNED: ERIK CHIN	DATE: ####
DRAWN: DILLON ALAMEDA	DATE: ####
CHECKED: ED NORIEGA	DATE: ####


FOR RIGHT OF WAY DATA AND ACCURATE ACCESS DETERMINATION, SEE DOCUMENTS IN THE DEPARTMENT OF PUBLIC WORKS AND PLANNING.



TENTATIVE PLANS FOR DESIGN	DATE: _____
SUPERVISING ENGINEER	DATE: _____



PROJECT
GOLDEN STATE CORRIDOR - ECONOMIC DEVELOPMENT AND INFRASTRUCTURE IMPROVEMENTS
FOWLER REGION

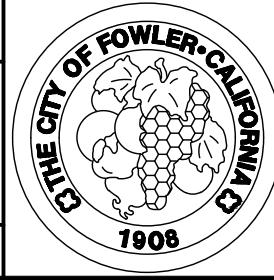

DEPARTMENT OF PUBLIC WORKS AND PLANNING		
STAGE CONSTRUCTION - STAGE 2		
DRAWING NO. SC-4	SHEET NO. 91	TOTAL 142

PATH: J:\Fresno COG-FN-16105-GSB Final Design\CADD\Sheets\Region 3 - Fowler\GSB_R3_SC5 -SC6.dwg
PLOT DATE: 4/2/2021 8:45:48 AM
CAD USER: NYANES

NOTES

- 1. TRAFFIC CONTROL SHOWN ON PLANS, INCLUDING LOCATIONS OF CONSTRUCTION AREA SIGNS, ARE APPROXIMATE AND INTENDED TO BE UTILIZED FOR STAGING PURPOSES ONLY. ALL TRAFFIC CONTROL SHALL BE APPROVED BY CITY OF FOWLER AND COUNTY OF FRESNO PUBLIC WORKS DEPARTMENT PRIOR TO CONSTRUCTION. ALL SIGN LOCATIONS SHALL BE APPROVED BY THE ENGINEER.
- 2. ALL TRAFFIC CONTROL SHALL CONFORM WITH THE 2015 CALTRANS STANDARD PLANS AND THE CALIFORNIA MANUAL FOR UNIFORM TRAFFIC CONTROL DEVICES (MUTCD).
- 3. CONTRACTOR TO PROVIDE A MINIMUM OF ONE-11' LANE OF ACCESS IN EACH DIRECTION ALONG GOLDEN STATE BOULEVARD DURING CONSTRUCTION AT ALL TIMES.
- 4. CONTRACTOR TO PROVIDE REASONABLE MEANS FOR PROPERTY OWNERS THAT ARE ADJACENT TO CONSTRUCTION TO ACCESS PROPERTIES AT ALL TIMES.
- 5. CONTRACTOR TO COORDINATE ANY DRIVEWAY CLOSURES WITH PROPERTY OWNERS BEFORE IMPACTING ACCESS.
- 6. CONTRACTOR SHALL COORDINATE WITH UPRR DURING ALL STAGES OF CONSTRUCTION.

TRAFFIC STAGE 3


- 1. WORK NOT NECESSARY FOR STAGING OPERATION CAN BE DONE AT ANY TIME AND IS NOT SHOWN.

LEGEND

- [Solid Grey Box] CONSTRUCTION THIS STAGE
- [Diagonal Lines Box] CONSTRUCTION THIS STAGE
- [Dotted Box] CONSTRUCTION THIS STAGE
- [Cross-hatched Box] CONSTRUCTION THIS STAGE
- [Circle with #] CONSTRUCTION ITEM THIS STAGE

CONSTRUCTION STAGE 3




- 1. CONSTRUCT CIR AND FINAL LIFT OF HMA FROM DEWOLF AVE TO 250' NORTH OF MANNING AVE.
- 2. CONSTRUCT CIR AND FINAL LIFT OF HMA FROM 250' NORTH OF MANNING AVE TO 350' NORTH OF TEMPERANCE AVE.
- 3. CONSTRUCT CIR AND FINAL LIFT OF HMA FROM 350' NORTH OF TEMPERANCE AVE TO MERCED ST.
- 4. CONSTRUCT GRIND/HMA OVERLAY IMPROVEMENTS AT MERCED ST INTERSECTION.
- 5. CONSTRUCT CIR AND FINAL LIFT OF HMA FROM MERCED ST TO 900' NORTH OF ADAMS AVE.
- 6. CONSTRUCT GRIND/HMA OVERLAY IMPROVEMENTS ALONG 8TH STREET
- 7. CONSTRUCT CIR AND FINAL LIFT OF HMA FROM 900' NORTH OF VINE AVE TO 370' SOUTH OF CLOVIS AVE.
- 8. CONSTRUCT CIR AND FINAL LIFT OF HMA FROM 370' SOUTH OF CLOVIS AVE TO 850' SOUTH OF AMERICAN AVE.

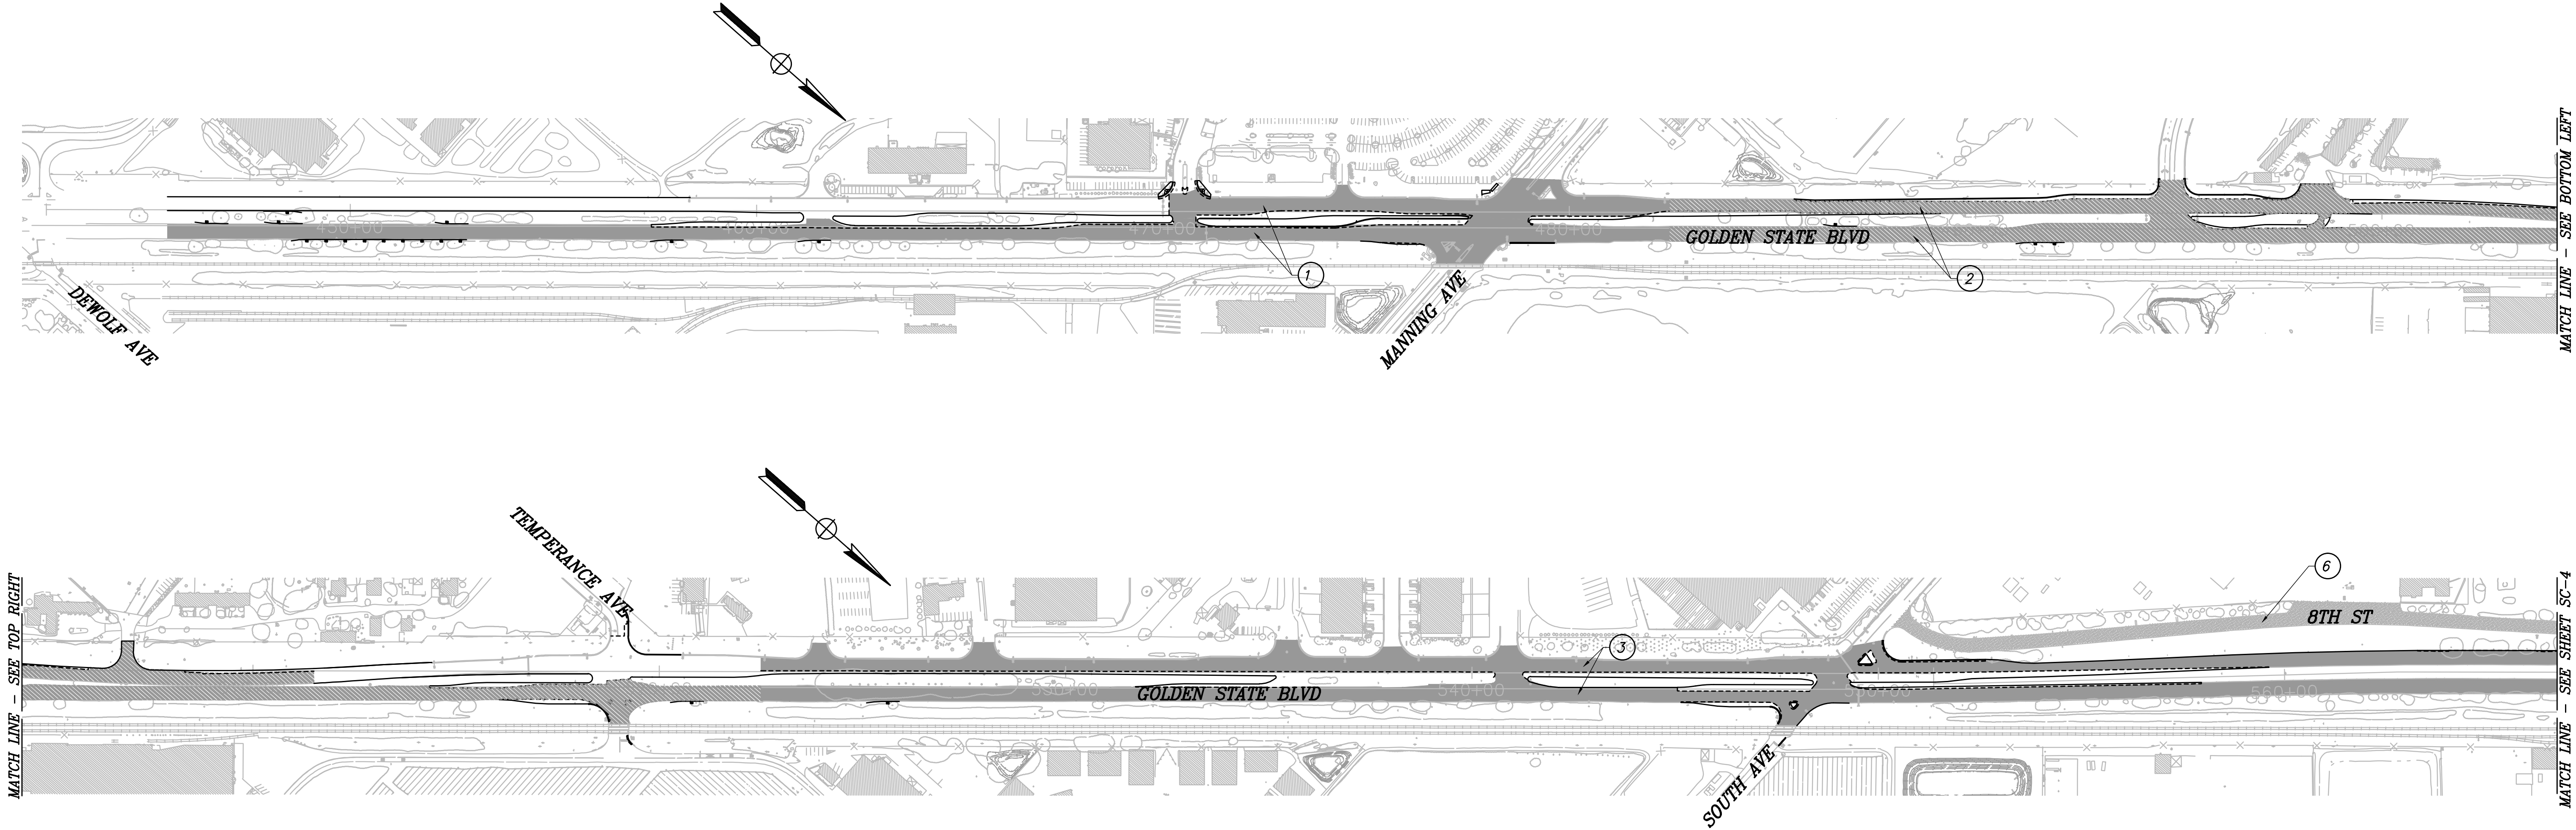

MATCH LINE - SEE TOP RIGHT

MATCH LINE - SEE BOTTOM LEFT

MATCH LINE - SEE SHEET SC-4

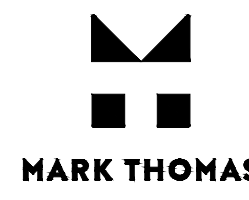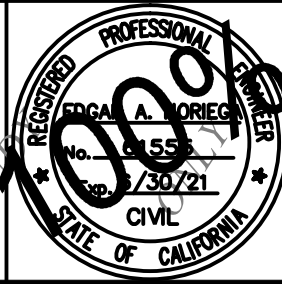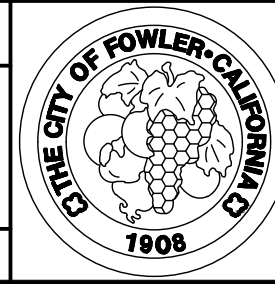		DATE	RECORD DRAWING		 CALL BEFORE YOU DIG	 MARK THOMAS	 TENTATIVE PLANS FOR DESIGN	PROJECT			DEPARTMENT OF PUBLIC WORKS AND PLANNING		
DESIGNED: ERIK CHIN		####	RESIDENT ENGINEER	DATE				GOLDEN STATE CORRIDOR - ECONOMIC DEVELOPMENT AND INFRASTRUCTURE IMPROVEMENTS			STAGE CONSTRUCTION - STAGE 3		
DRAWN: DILLON ALAMEDA		####						SUPERVISING ENGINEER			DATE		
CHECKED: DANIEL ROBER		####											
FOR RIGHT OF WAY DATA AND ACCURATE ACCESS DETERMINATION, SEE DOCUMENTS IN THE DEPARTMENT OF PUBLIC WORKS AND PLANNING.													
							FOWLER REGION		DRAWING NO. SC-5			SHEET NO. 92	TOTAL 142


MATCH LINE - SEE SHEET SC-5

MATCH LINE - SEE TOP RIGHT

MATCH LINE - SEE MIDDLE RIGHT


MATCH LINE - SEE MIDDLE LEFT

MATCH LINE - SEE BOTTOM LEFT

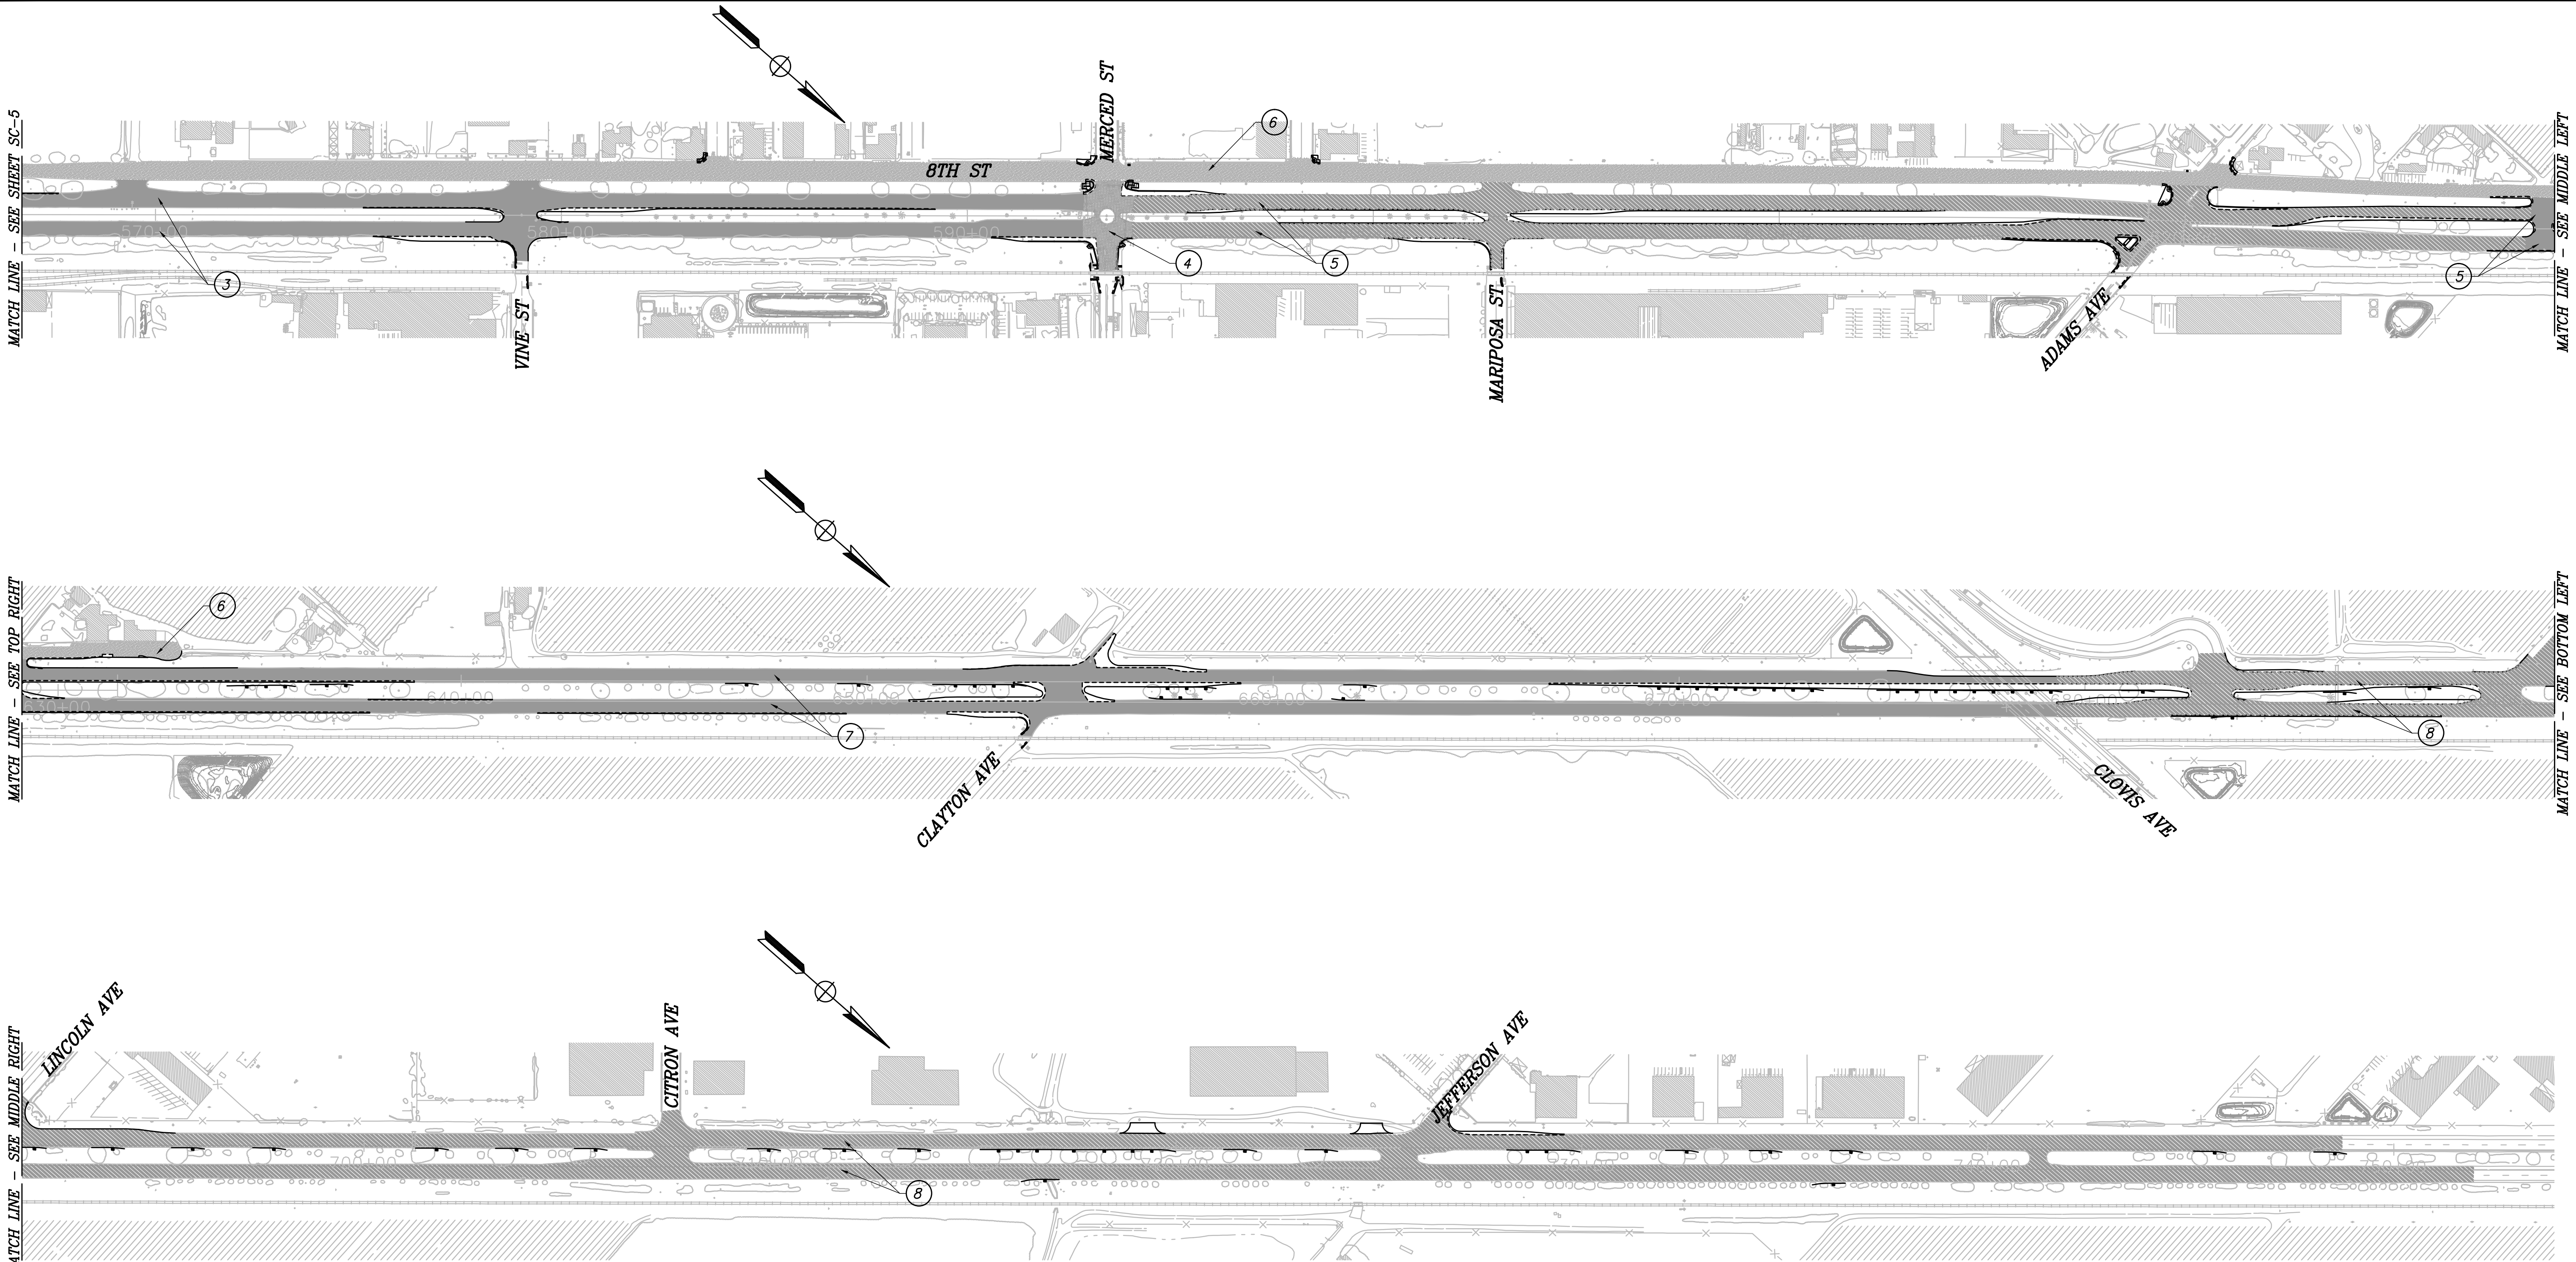

RECORD DRAWING	
DESIGNED: ERIK CHIN	DATE: ####
DRAWN: DILLON ALAMEDA	DATE: ####
CHECKED: ED NORIEGA	DATE: ####

FOR RIGHT OF WAY DATA AND ACCURATE ACCESS DETERMINATION, SEE DOCUMENTS IN THE DEPARTMENT OF PUBLIC WORKS AND PLANNING.

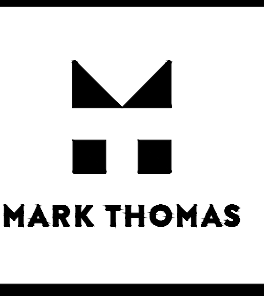

TENTATIVE PLANS FOR DESIGN


SUPERVISING ENGINEER DATE



PROJECT

GOLDEN STATE CORRIDOR - ECONOMIC DEVELOPMENT AND INFRASTRUCTURE IMPROVEMENTS

FOWLER REGION

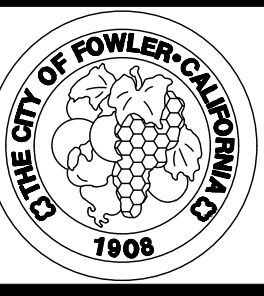

DEPARTMENT OF PUBLIC WORKS AND PLANNING

 
STAGE CONSTRUCTION - STAGE 3

DRAWING NO. SC-6 SHEET NO. 93 TOTAL 142

NOTES

1. CROSSWALK TO BE 10' WIDE PER COUNTY OF FRESNO STD ST 42 UNLESS OTHERWISE NOTED

LEGEND

- 

24" WIDE WHITE LIMIT LINE FOR RAILROAD CROSSING

 
12" WIDE WHITE LIMIT LINE

YIELD LINE PER CALTRANS STD PLAN A24E

CROSSWALK

DENOTES PROPOSED DETAIL NUMBER PER CALTRANS STD PLANS

DENOTES EXISTING DETAIL NUMBER PER CALTRANS STD PLANS

CHANGE IN TRAFFIC STRIPE
- 

CHANGE IN TRAFFIC STRIPE

STREET NAME SIGN

EXISTING SINGLE POST ROADSIDE SIGN

PROPOSED SINGLE POST ROADSIDE SIGN

PROPOSED ROADSIDE SIGN SSBM

REMOVE EXISTING STRIPING AND MARKING (HAZARDOUS MATERIAL)
- 

AHEAD

SIGNAL

STOP

KEEP

CLEAR

YIELD

"AHEAD" MARKING PER CALTRANS STD PLAN A24D

"SIGNAL" MARKING PER CALTRANS STD PLAN A24D

"STOP" MARKING PER CALTRANS STD PLAN A24D

"KEEP" MARKING PER CALTRANS STD PLAN A24D

"CLEAR" MARKING PER CALTRANS STD PLAN A24E

"YIELD" MARKING PER CALTRANS STD PLAN A24D
- 

BIKE LANE SYMBOL WITH PERSON PER CALTRANS STD PLAN A24C

TYPE IV (L) ARROW PER CALTRANS STD PLAN A24B

TYPE IV (R) ARROW PER CALTRANS STD PLAN A24B

TYPE VI ARROW PER CALTRANS STD PLAN A24A

TYPE VII ARROW PER CALTRANS STD PLAN A24A

TYPE I ARROW PER CALTRANS STD PLAN A24A
- 

EXISTING SIGN TO BE SALVAGED AND REPLACED



EXISTING SIGN TO REMAIN



EXISTING SIGN TO BE RESET OR RELOCATED


EXISTING SIGN TO BE REMOVED AND SALVAGED

INSTALL ROADSIDE SIGN

RAILROAD CROSSING SYMBOL PER CALTRANS STD PLAN A24B

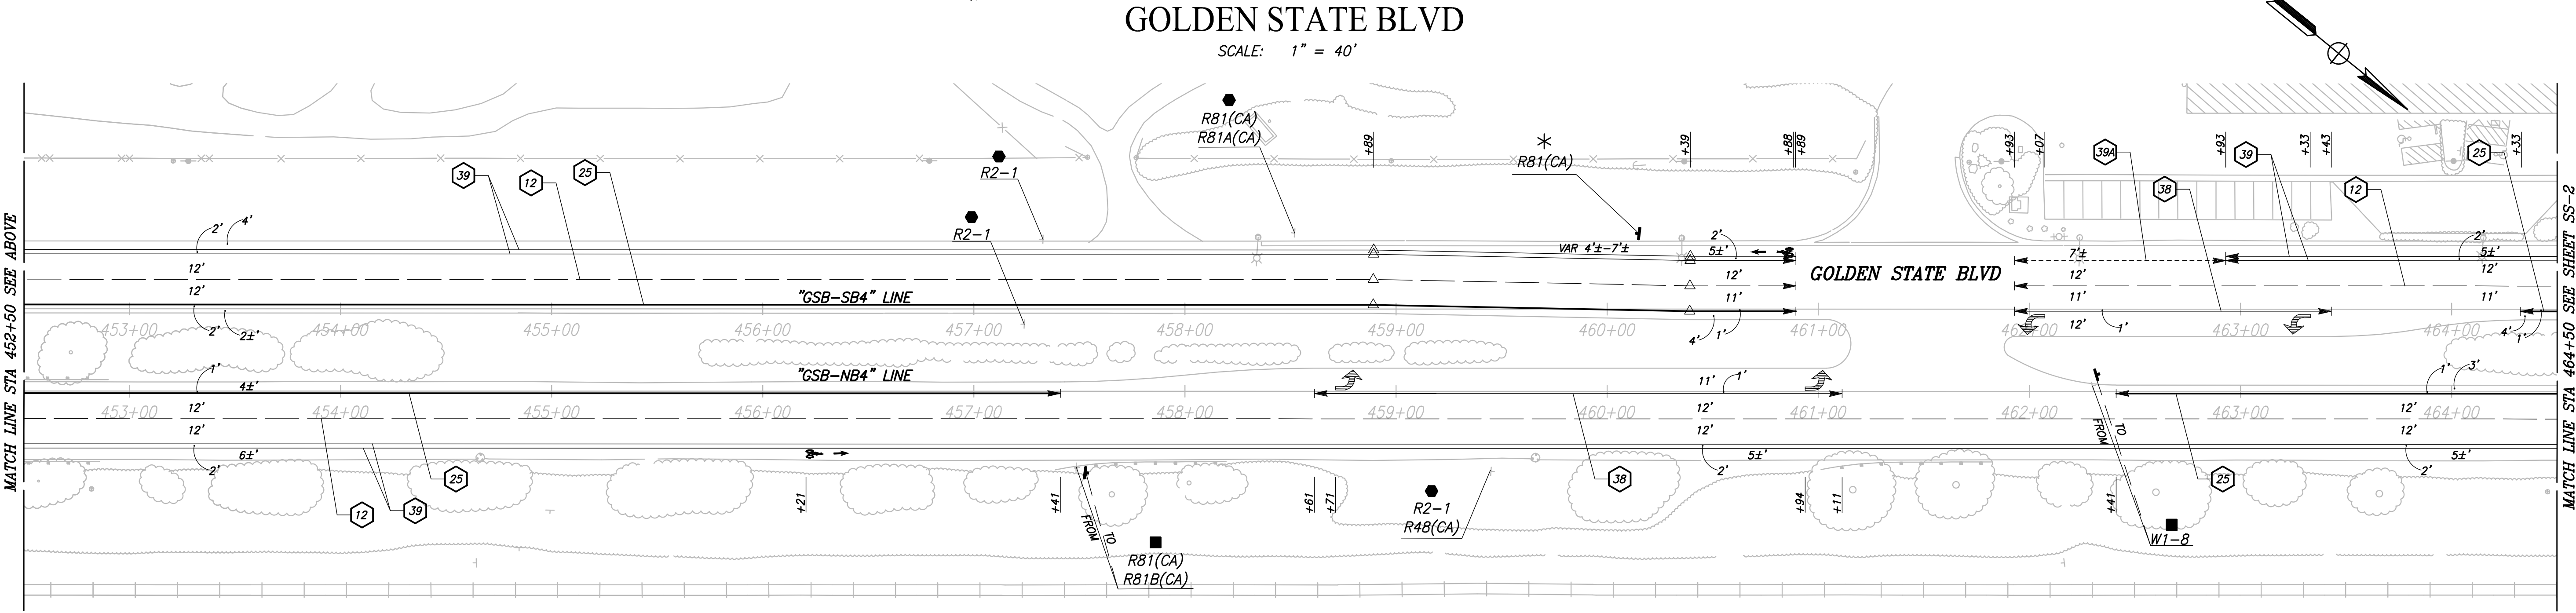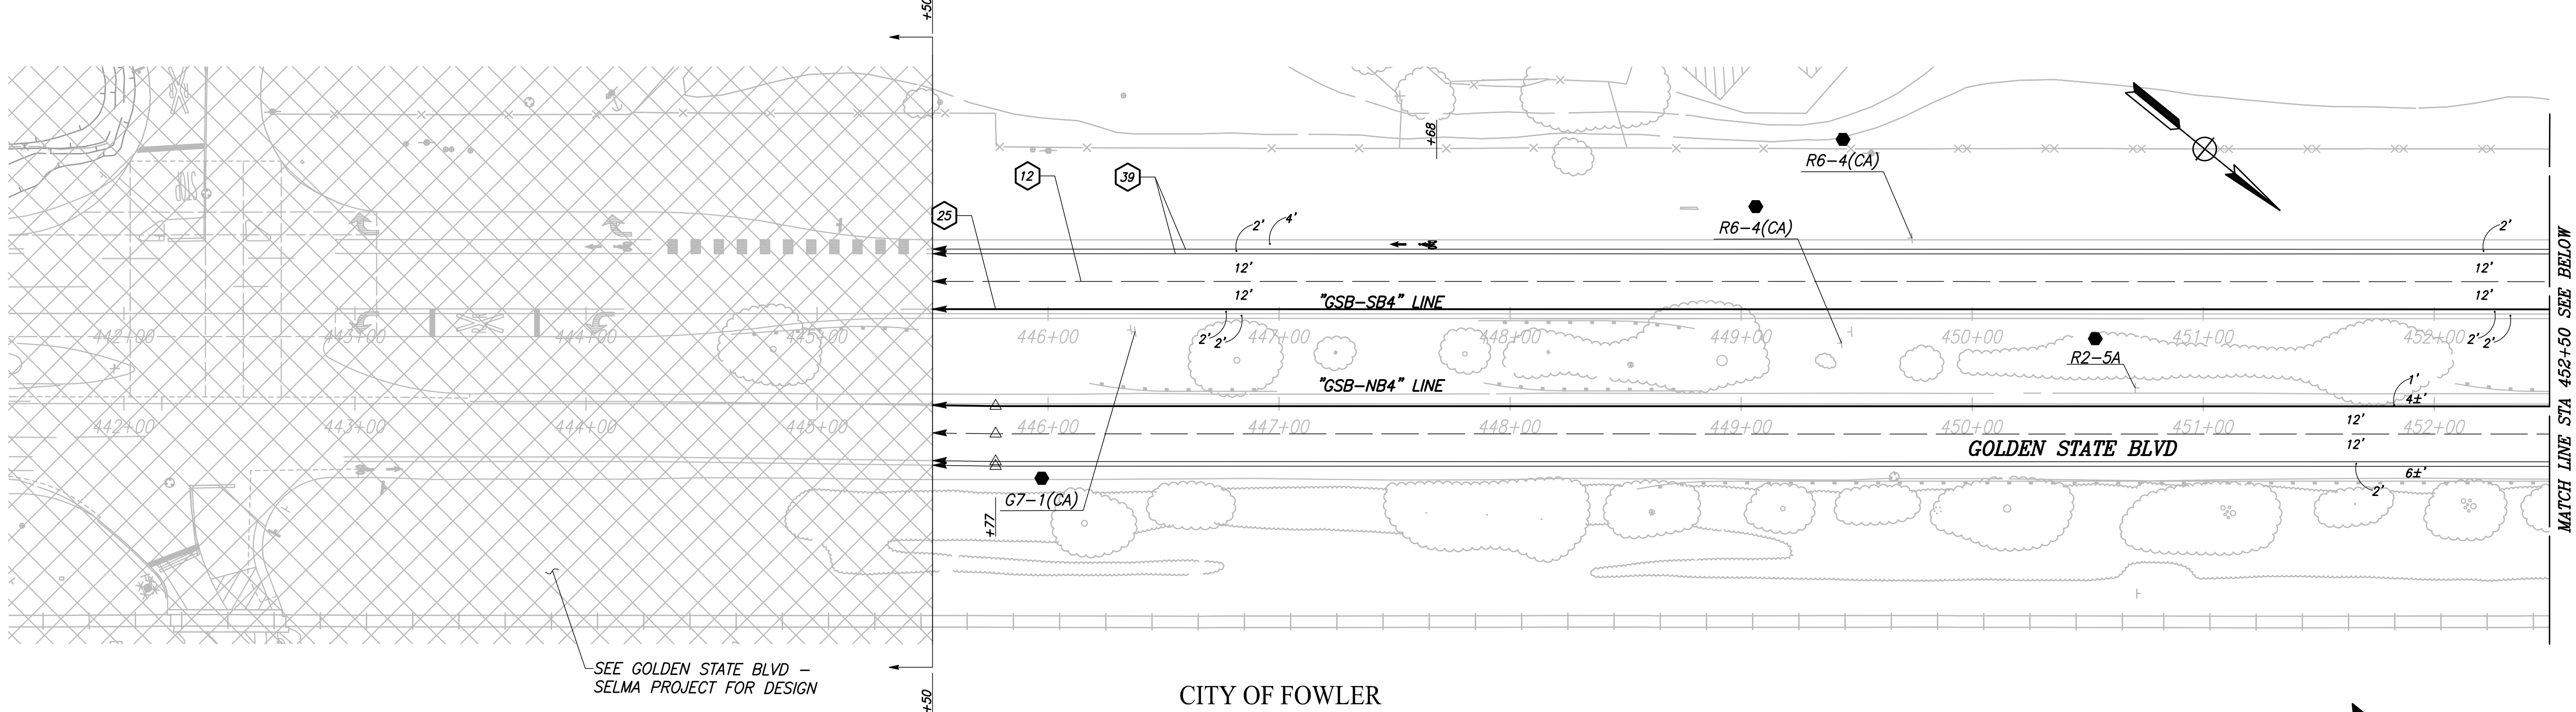

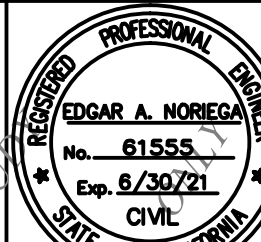
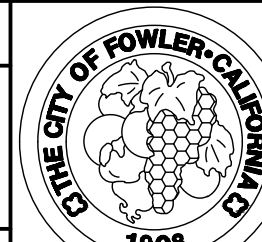
		DATE	RECORD DRAWING					PROJECT			DEPARTMENT OF PUBLIC WORKS AND PLANNING		
DESIGNED: ERIK CHIN		####	RESIDENT ENGINEER					DATE	GOLDEN STATE CORRIDOR - ECONOMIC DEVELOPMENT AND INFRASTRUCTURE IMPROVEMENTS		SIGNING AND STRIPING		
DRAWN: DILLON ALAMEDA		####											
CHECKED: ED NORIEGA		####											
FOR RIGHT OF WAY DATA AND ACCURATE ACCESS DETERMINATION, SEE DOCUMENTS IN THE DEPARTMENT OF PUBLIC WORKS AND PLANNING.													
CALL BEFORE YOU DIG						TENTATIVE PLANS FOR DESIGN STUDY		SUPERVISING ENGINEER		DATE	DRAWING NO. SS-1		
											SHEET NO. 94		
											TOTAL 142		

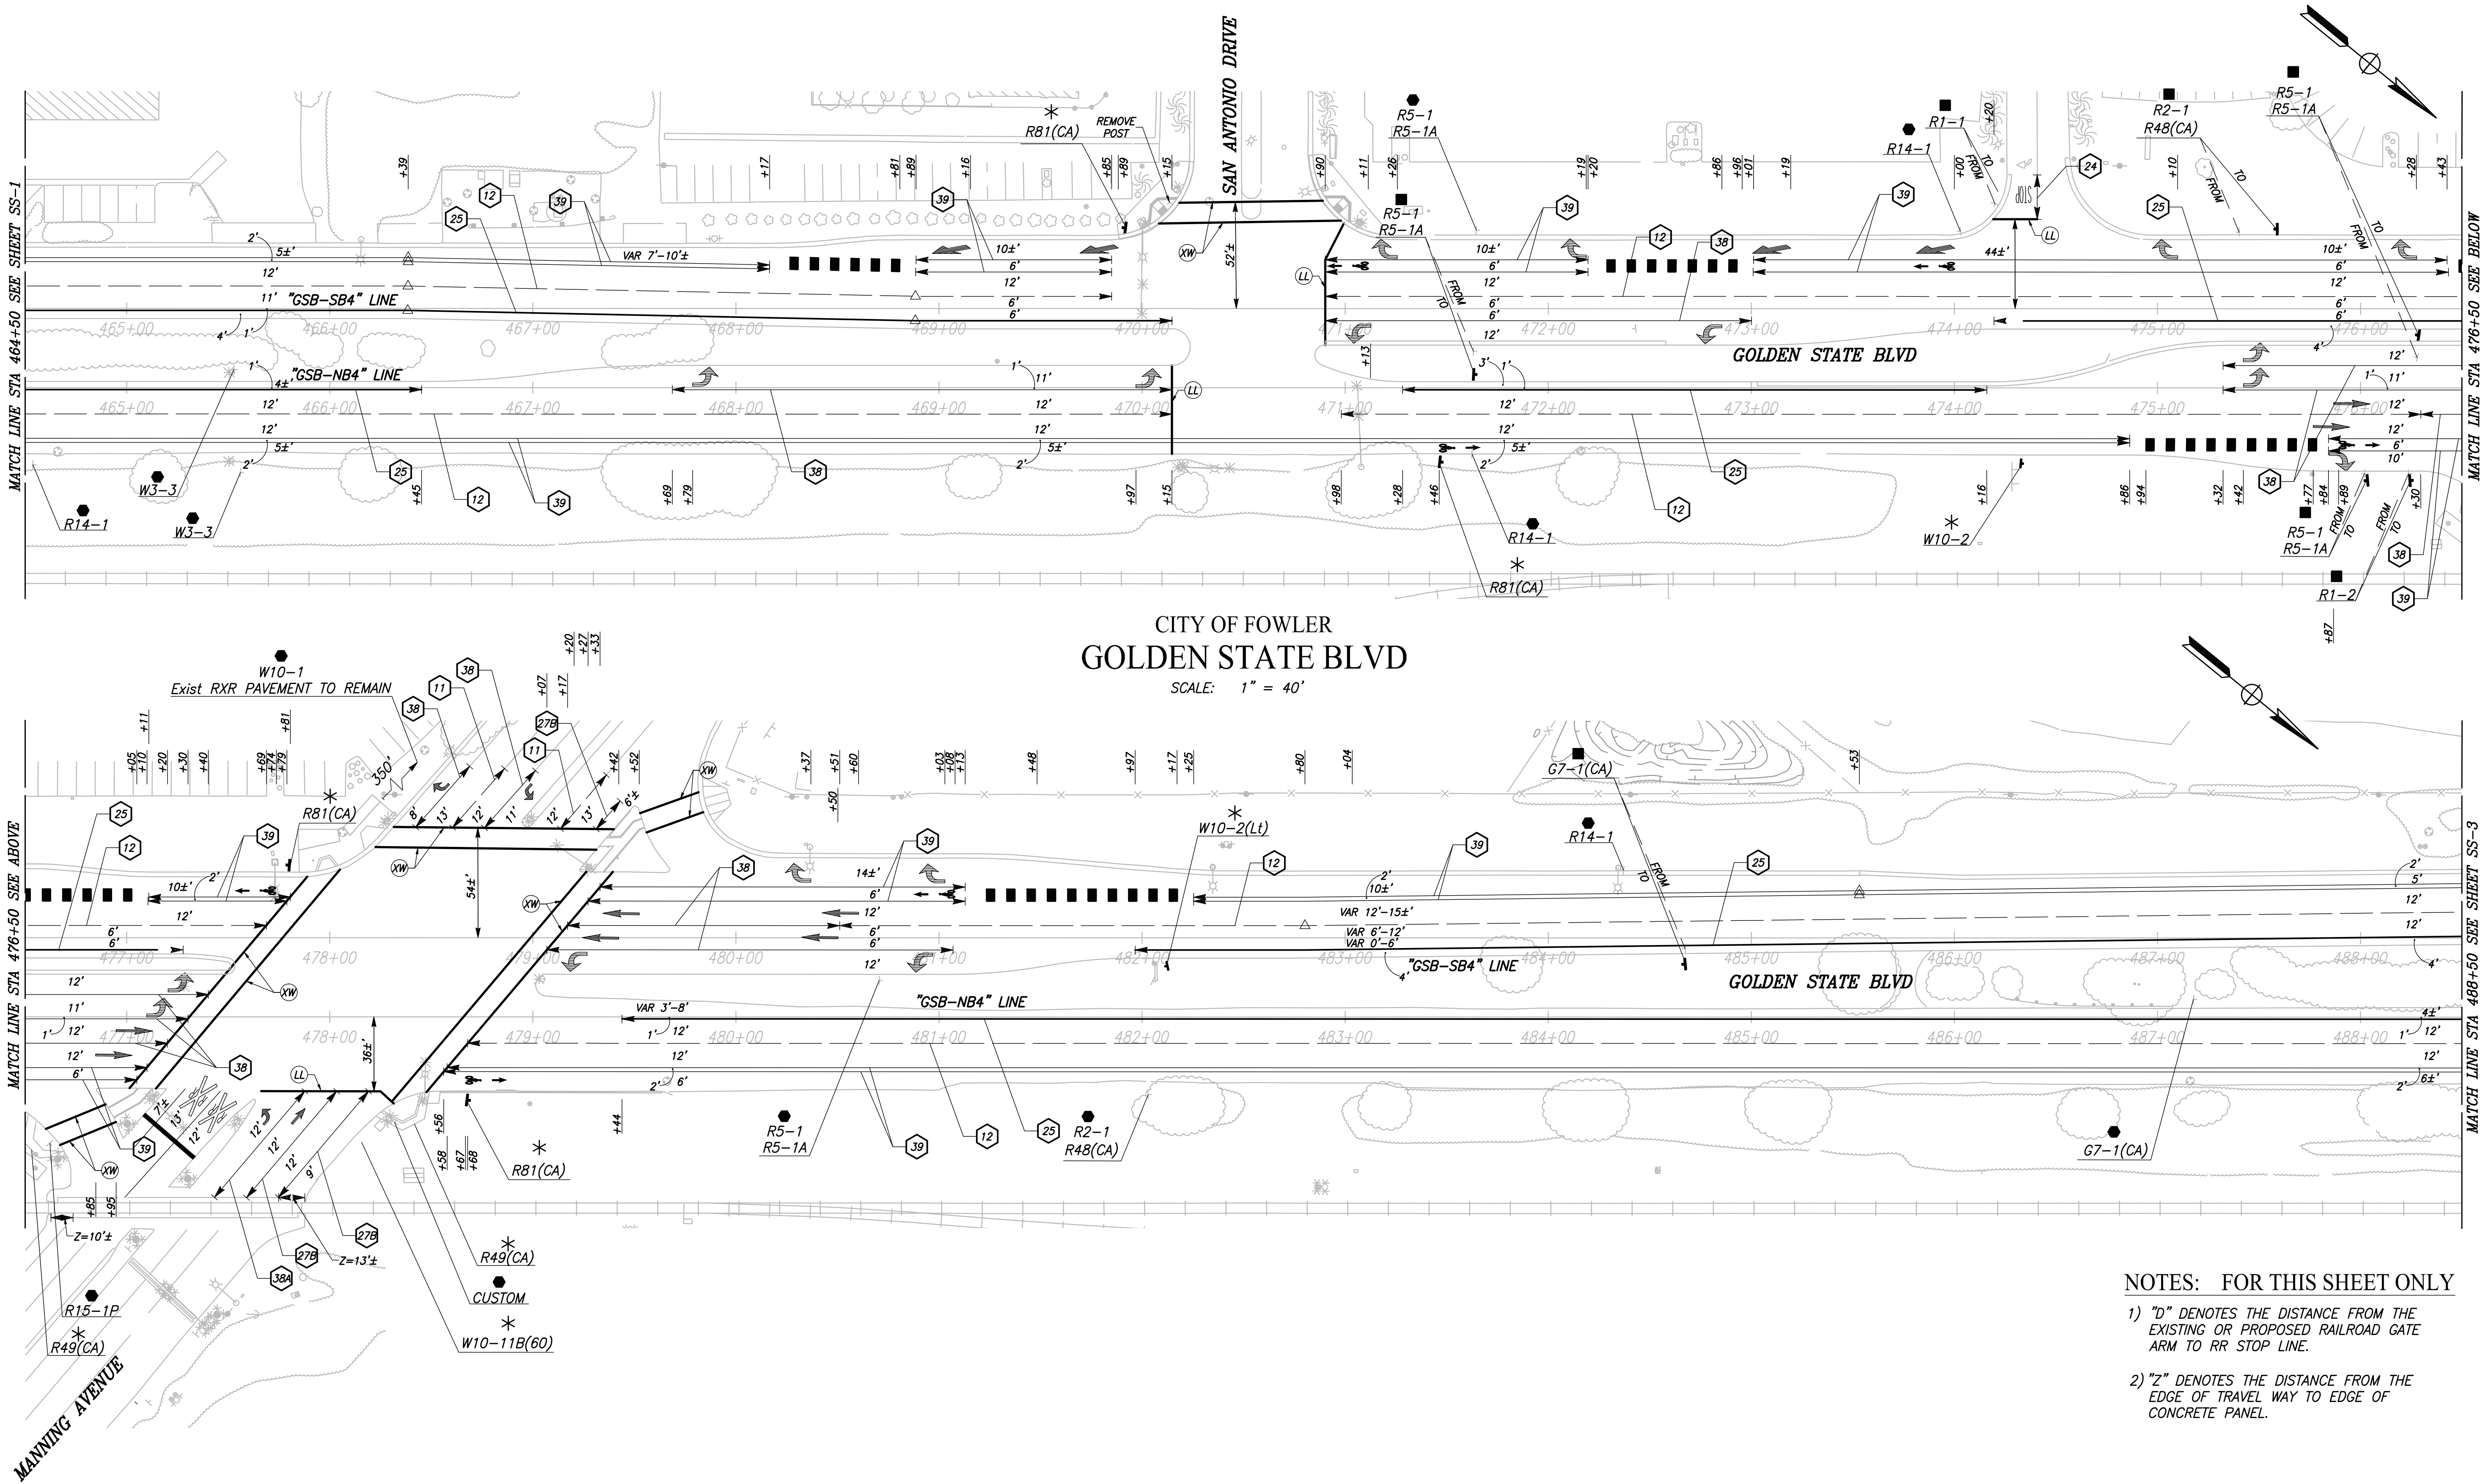


CITY OF FOWLER
GOLDEN STATE BLVD
SCALE: 1" = 40'

- NOTES: FOR THIS SHEET ONLY
- 1) "D" DENOTES THE DISTANCE FROM THE EXISTING OR PROPOSED RAILROAD GATE ARM TO RR STOP LINE.
 - 2) "Z" DENOTES THE DISTANCE FROM THE EDGE OF TRAVEL WAY TO EDGE OF CONCRETE PANEL.

	DATE	RECORD DRAWING					PROJECT			DEPARTMENT OF PUBLIC WORKS AND PLANNING		
DESIGNED: ERIK CHIN	####	RESIDENT ENGINEER	DATE				GOLDEN STATE CORRIDOR - ECONOMIC DEVELOPMENT AND INFRASTRUCTURE IMPROVEMENTS			SIGNING AND STRIPING		
DRAWN: DILLON ALAMEDA	####											
CHECKED: ED NORIEGA	####											
FOR RIGHT OF WAY DATA AND ACCURATE ACCESS DETERMINATION, SEE DOCUMENTS IN THE DEPARTMENT OF PUBLIC WORKS AND PLANNING.				CALL BEFORE YOU DIG	TENTATIVE PLANS FOR DESIGN	SUPERVISING ENGINEER	DATE	FOWLER REGION		DRAWING NO. SS-2	SHEET NO. 95	TOTAL 142

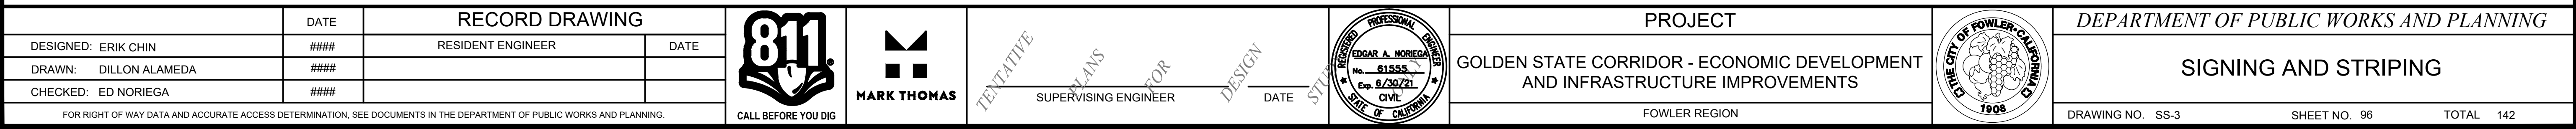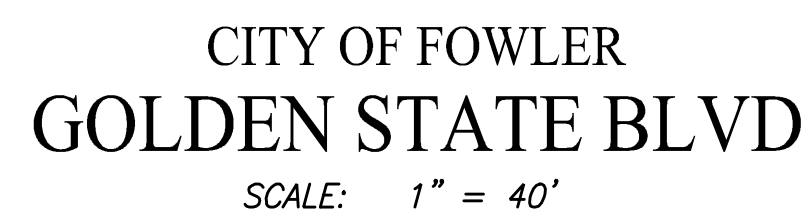

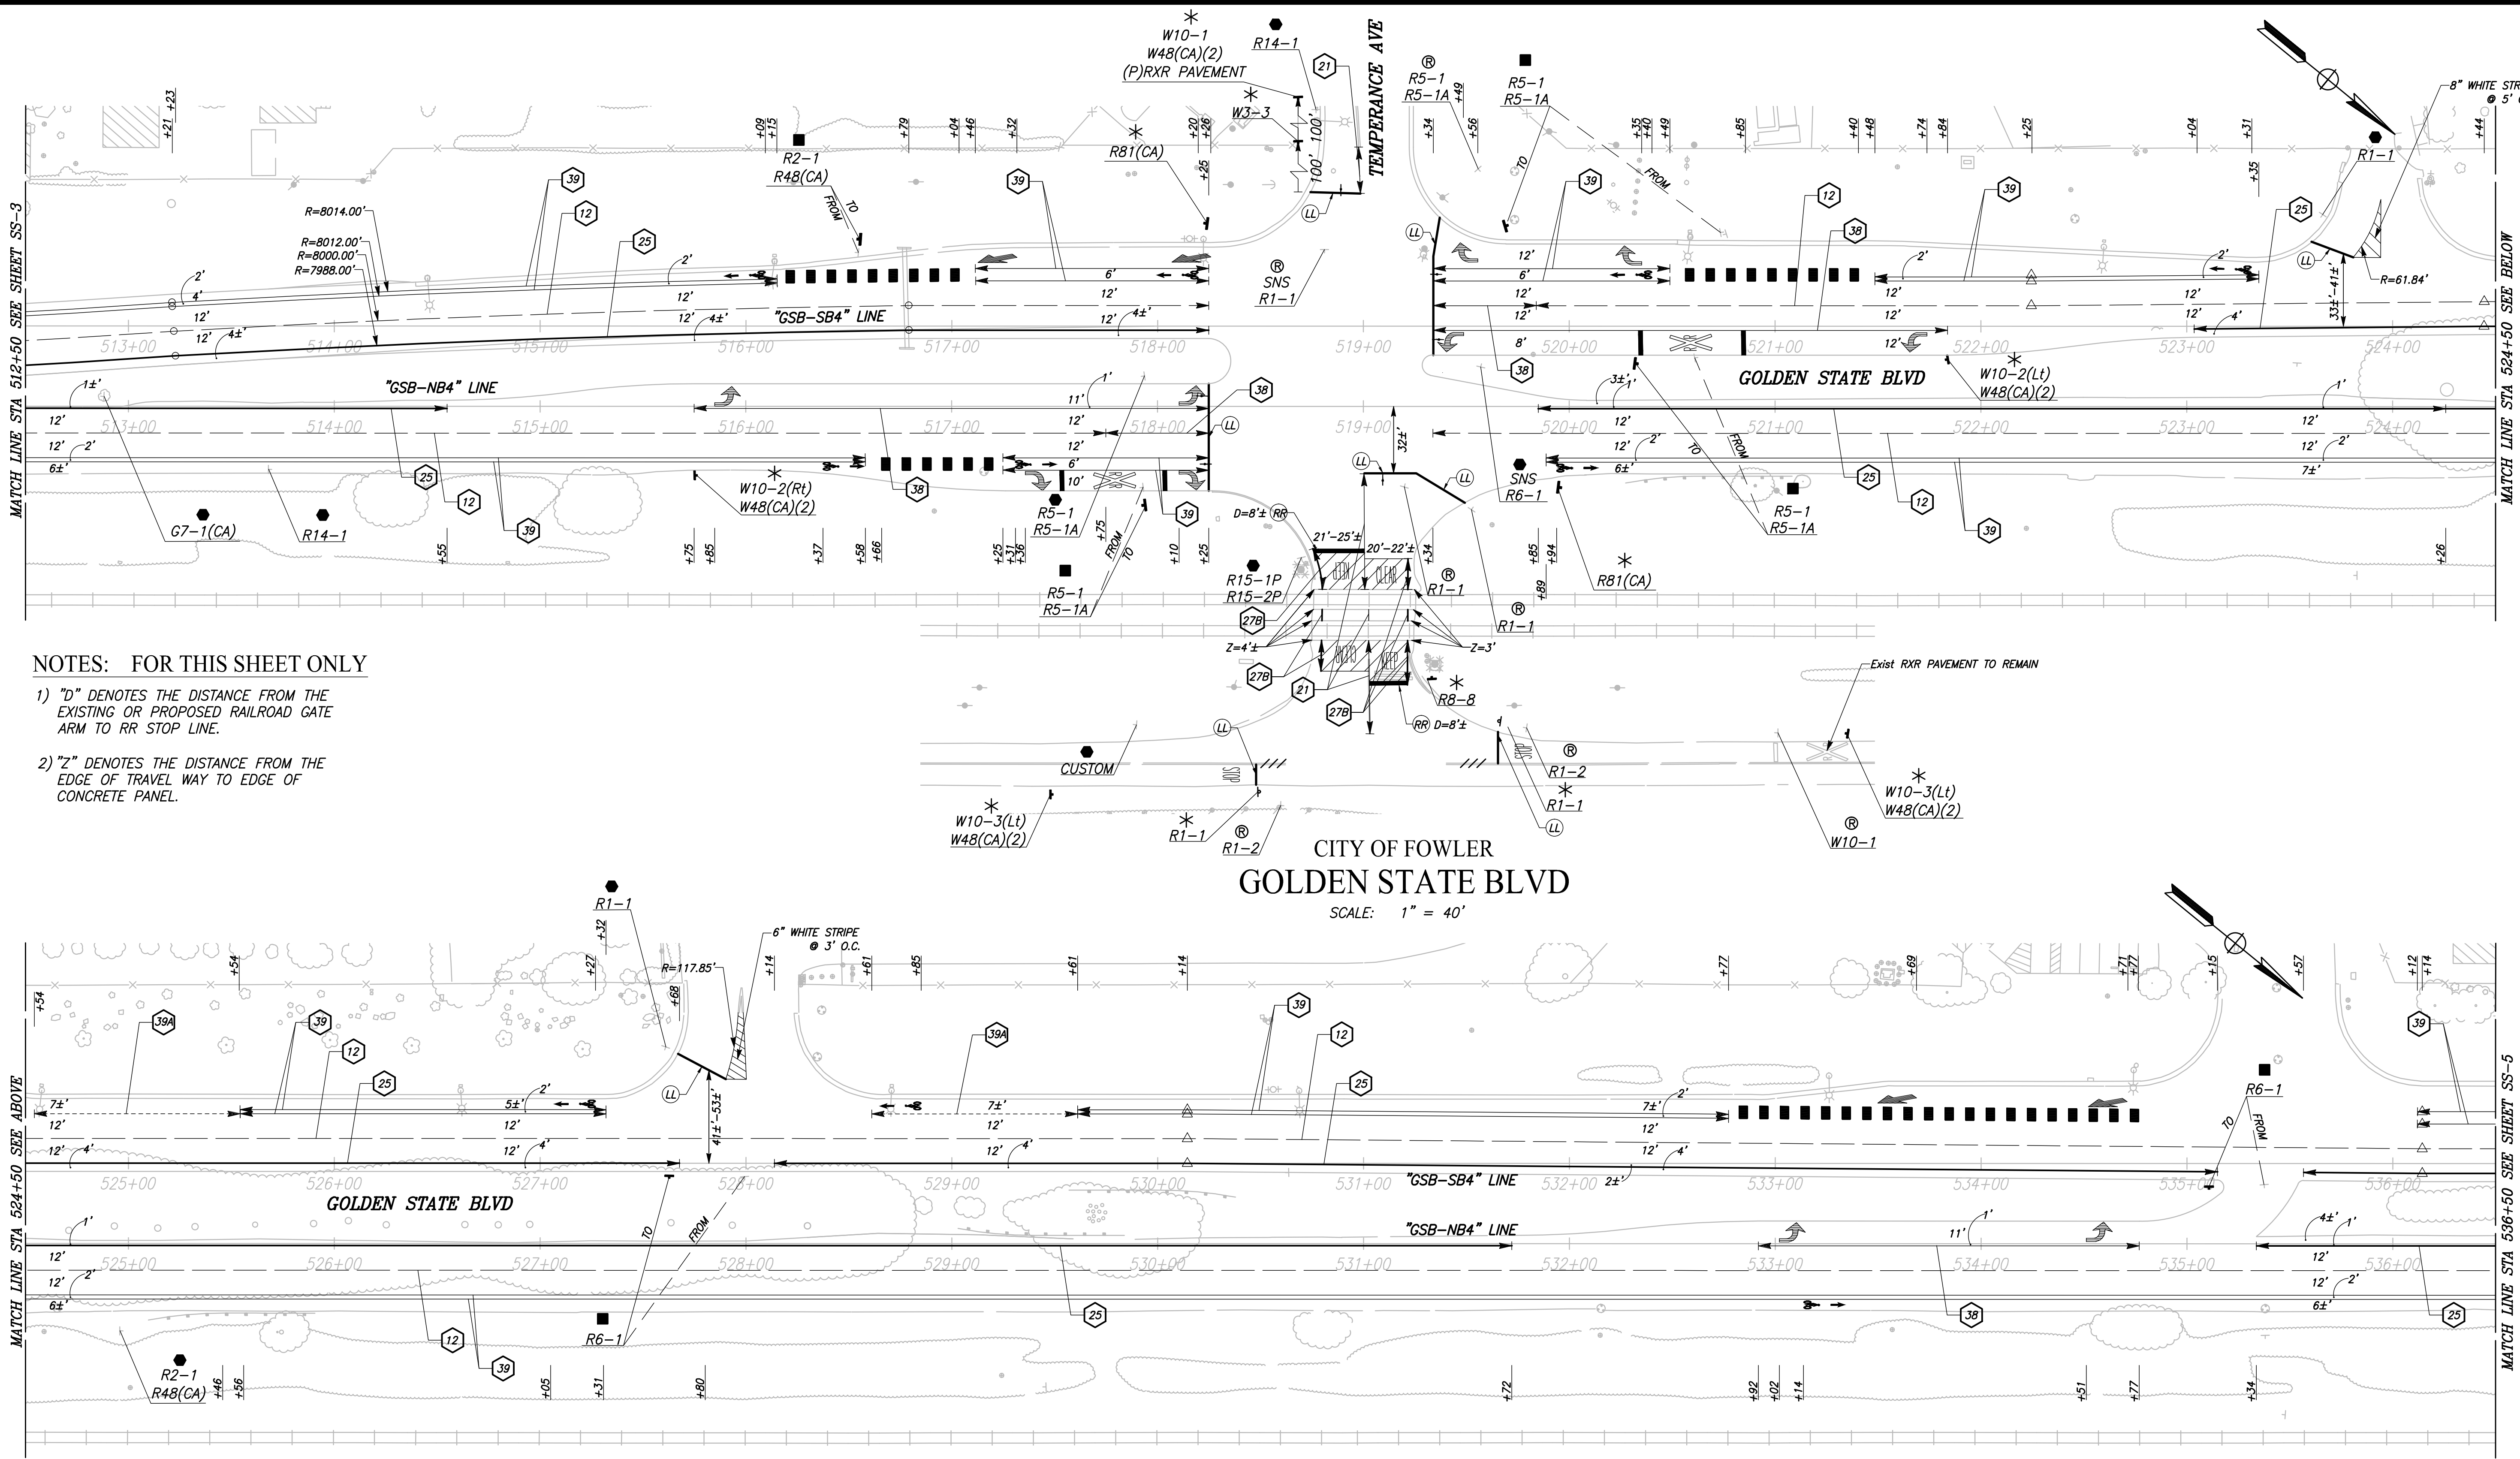


NOTES: FOR THIS SHEET ONLY

1) "D" DENOTES THE DISTANCE FROM THE EXISTING OR PROPOSED RAILROAD GATE ARM TO RR STOP LINE.

2) "Z" DENOTES THE DISTANCE FROM THE EDGE OF TRAVEL WAY TO EDGE OF CONCRETE PANEL.


CITY OF FOWLER
GOLDEN STATE BLVD
SCALE: 1" = 40'

	DATE	RECORD DRAWING				TENTATIVE PLANS FOR DESIGN		PROJECT			DEPARTMENT OF PUBLIC WORKS AND PLANNING	
DESIGNED: ERIK CHIN	####	RESIDENT ENGINEER	DATE					GOLDEN STATE CORRIDOR - ECONOMIC DEVELOPMENT AND INFRASTRUCTURE IMPROVEMENTS			SIGNING AND STRIPING	
DRAWN: DILLON ALAMEDA	####											
CHECKED: ED NORIEGA	####											
FOR RIGHT OF WAY DATA AND ACCURATE ACCESS DETERMINATION, SEE DOCUMENTS IN THE DEPARTMENT OF PUBLIC WORKS AND PLANNING.								FOWLER REGION		DRAWING NO. SS-4		
CALL BEFORE YOU DIG								SUPERVISING ENGINEER		DATE	SHEET NO. 97	
											TOTAL 142	

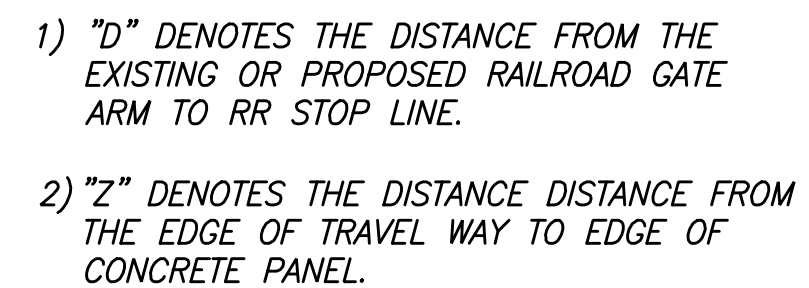


	DATE	RECORD DRAWING		 CALL BEFORE YOU DIG	 MARK THOMAS	 EDGAR A. NORIEGA No. 61555 Exp. 6/30/21 CIVIL 	PROJECT		 CITY OF FOWLER - CALIFORNIA 1908	<i>DEPARTMENT OF PUBLIC WORKS AND PLANNING</i>		
DESIGNED: ERIK CHIN	####	RESIDENT ENGINEER	DATE				GOLDEN STATE CORRIDOR - ECONOMIC DEVELOPMENT AND INFRASTRUCTURE IMPROVEMENTS			SIGNING AND STRIPING		
DRAWN: DILLON ALAMEDA	####											
CHECKED: ED NORIEGA	####											
FOR RIGHT OF WAY DATA AND ACCURATE ACCESS DETERMINATION, SEE DOCUMENTS IN THE DEPARTMENT OF PUBLIC WORKS AND PLANNING.				 TENTATIVE PLANS FOR DESIGN	DATE	FOWLER REGION	DRAWING NO. SS-5			SHEET NO. 98	TOTAL 142	

PATH: J:\Fresno COG-FN-16105-GSB Final Design\CADD\Sheets\Region 3 - Fowler\GSB_R3_SSI-SS7.dwg PLOT DATE: 4/2/2021 8:51:40 AM CAD USER: ECHIN

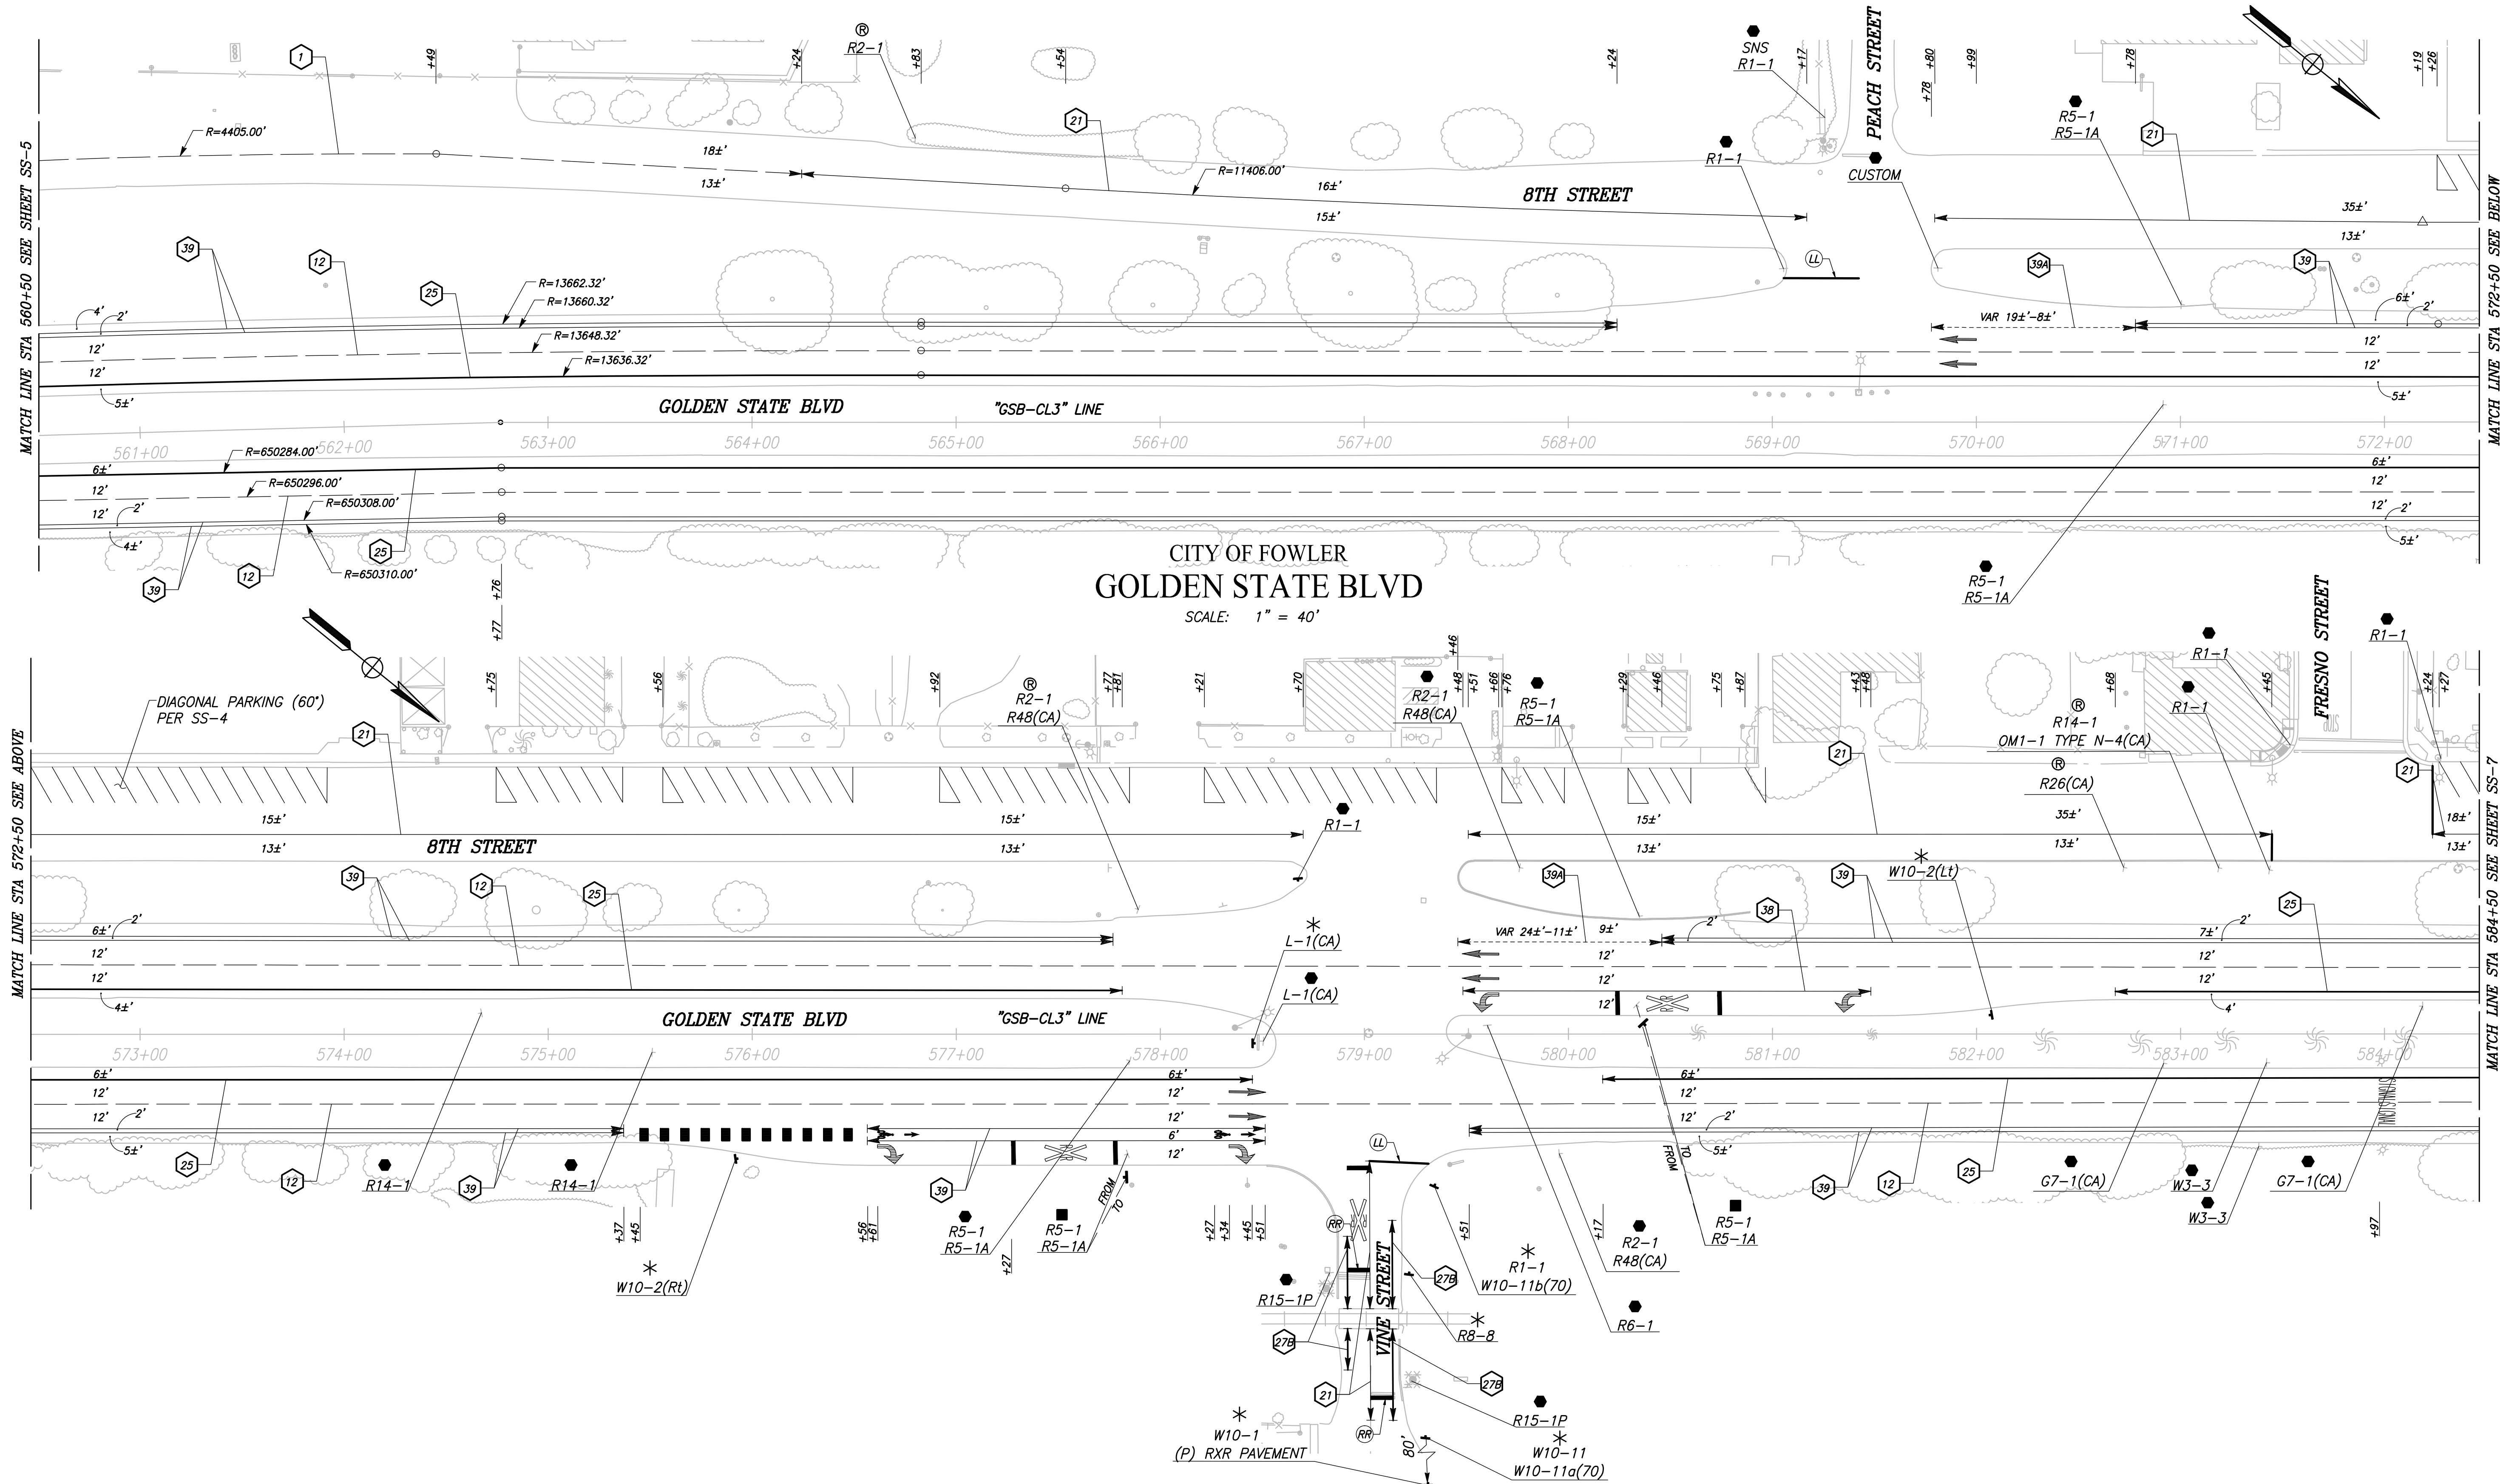


DESIGNED: ERIK CHIN		DATE	RECORD DRAWING	
DRAWN: DILLON ALAMEDA		####	RESIDENT ENGINEER	DATE
CHECKED: ED NORIEGA		####		
FOR RIGHT OF WAY DATA AND ACCURATE ACCESS DETERMINATION, SEE DOCUMENTS IN THE DEPARTMENT OF PUBLIC WORKS AND PLANNING.				

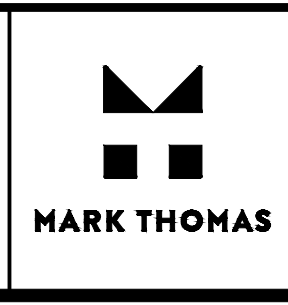

TENTATIVE PLANS FOR DESIGN


SUPERVISING ENGINEER DATE

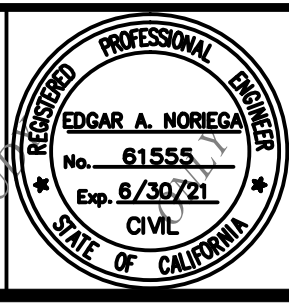

PROJECT

GOLDEN STATE CORRIDOR - ECONOMIC DEVELOPMENT AND INFRASTRUCTURE IMPROVEMENTS


FOWLER REGION

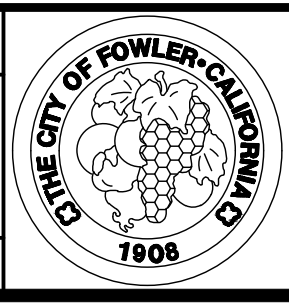


DEPARTMENT OF PUBLIC WORKS AND PLANNING

SIGNING AND STRIPING

DRAWING NO. SS-6 SHEET NO. 99 TOTAL 142

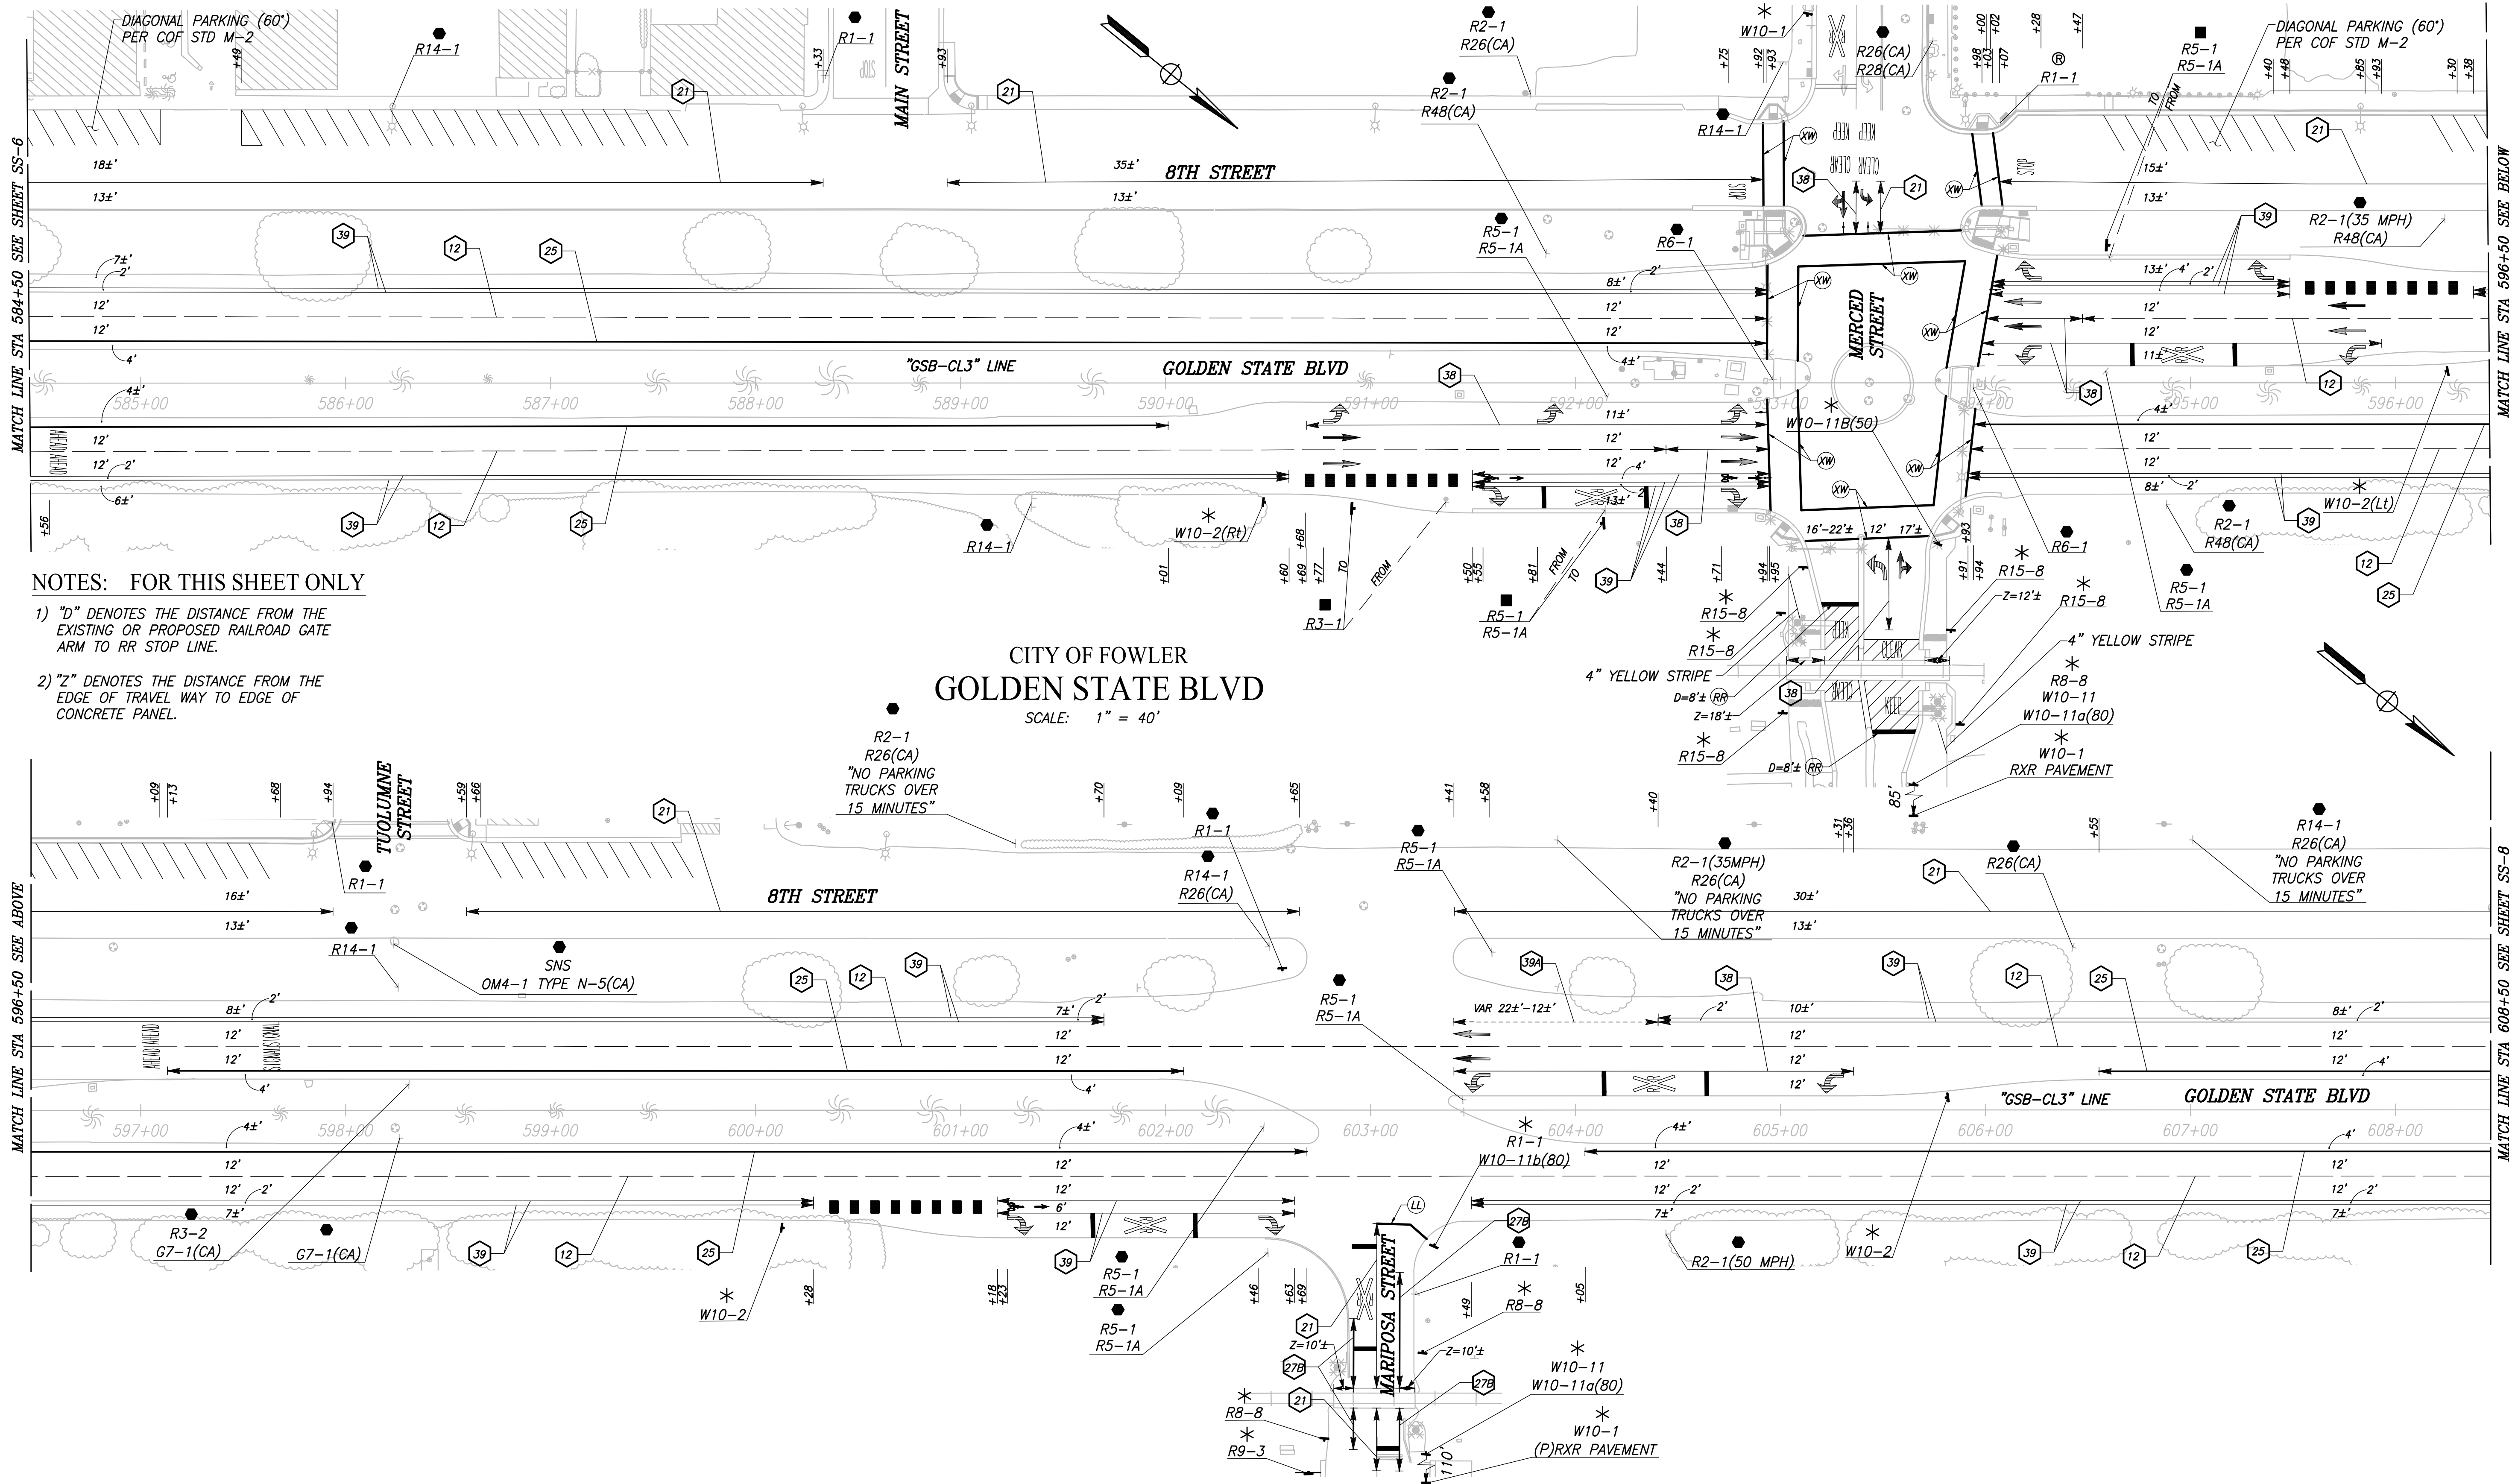

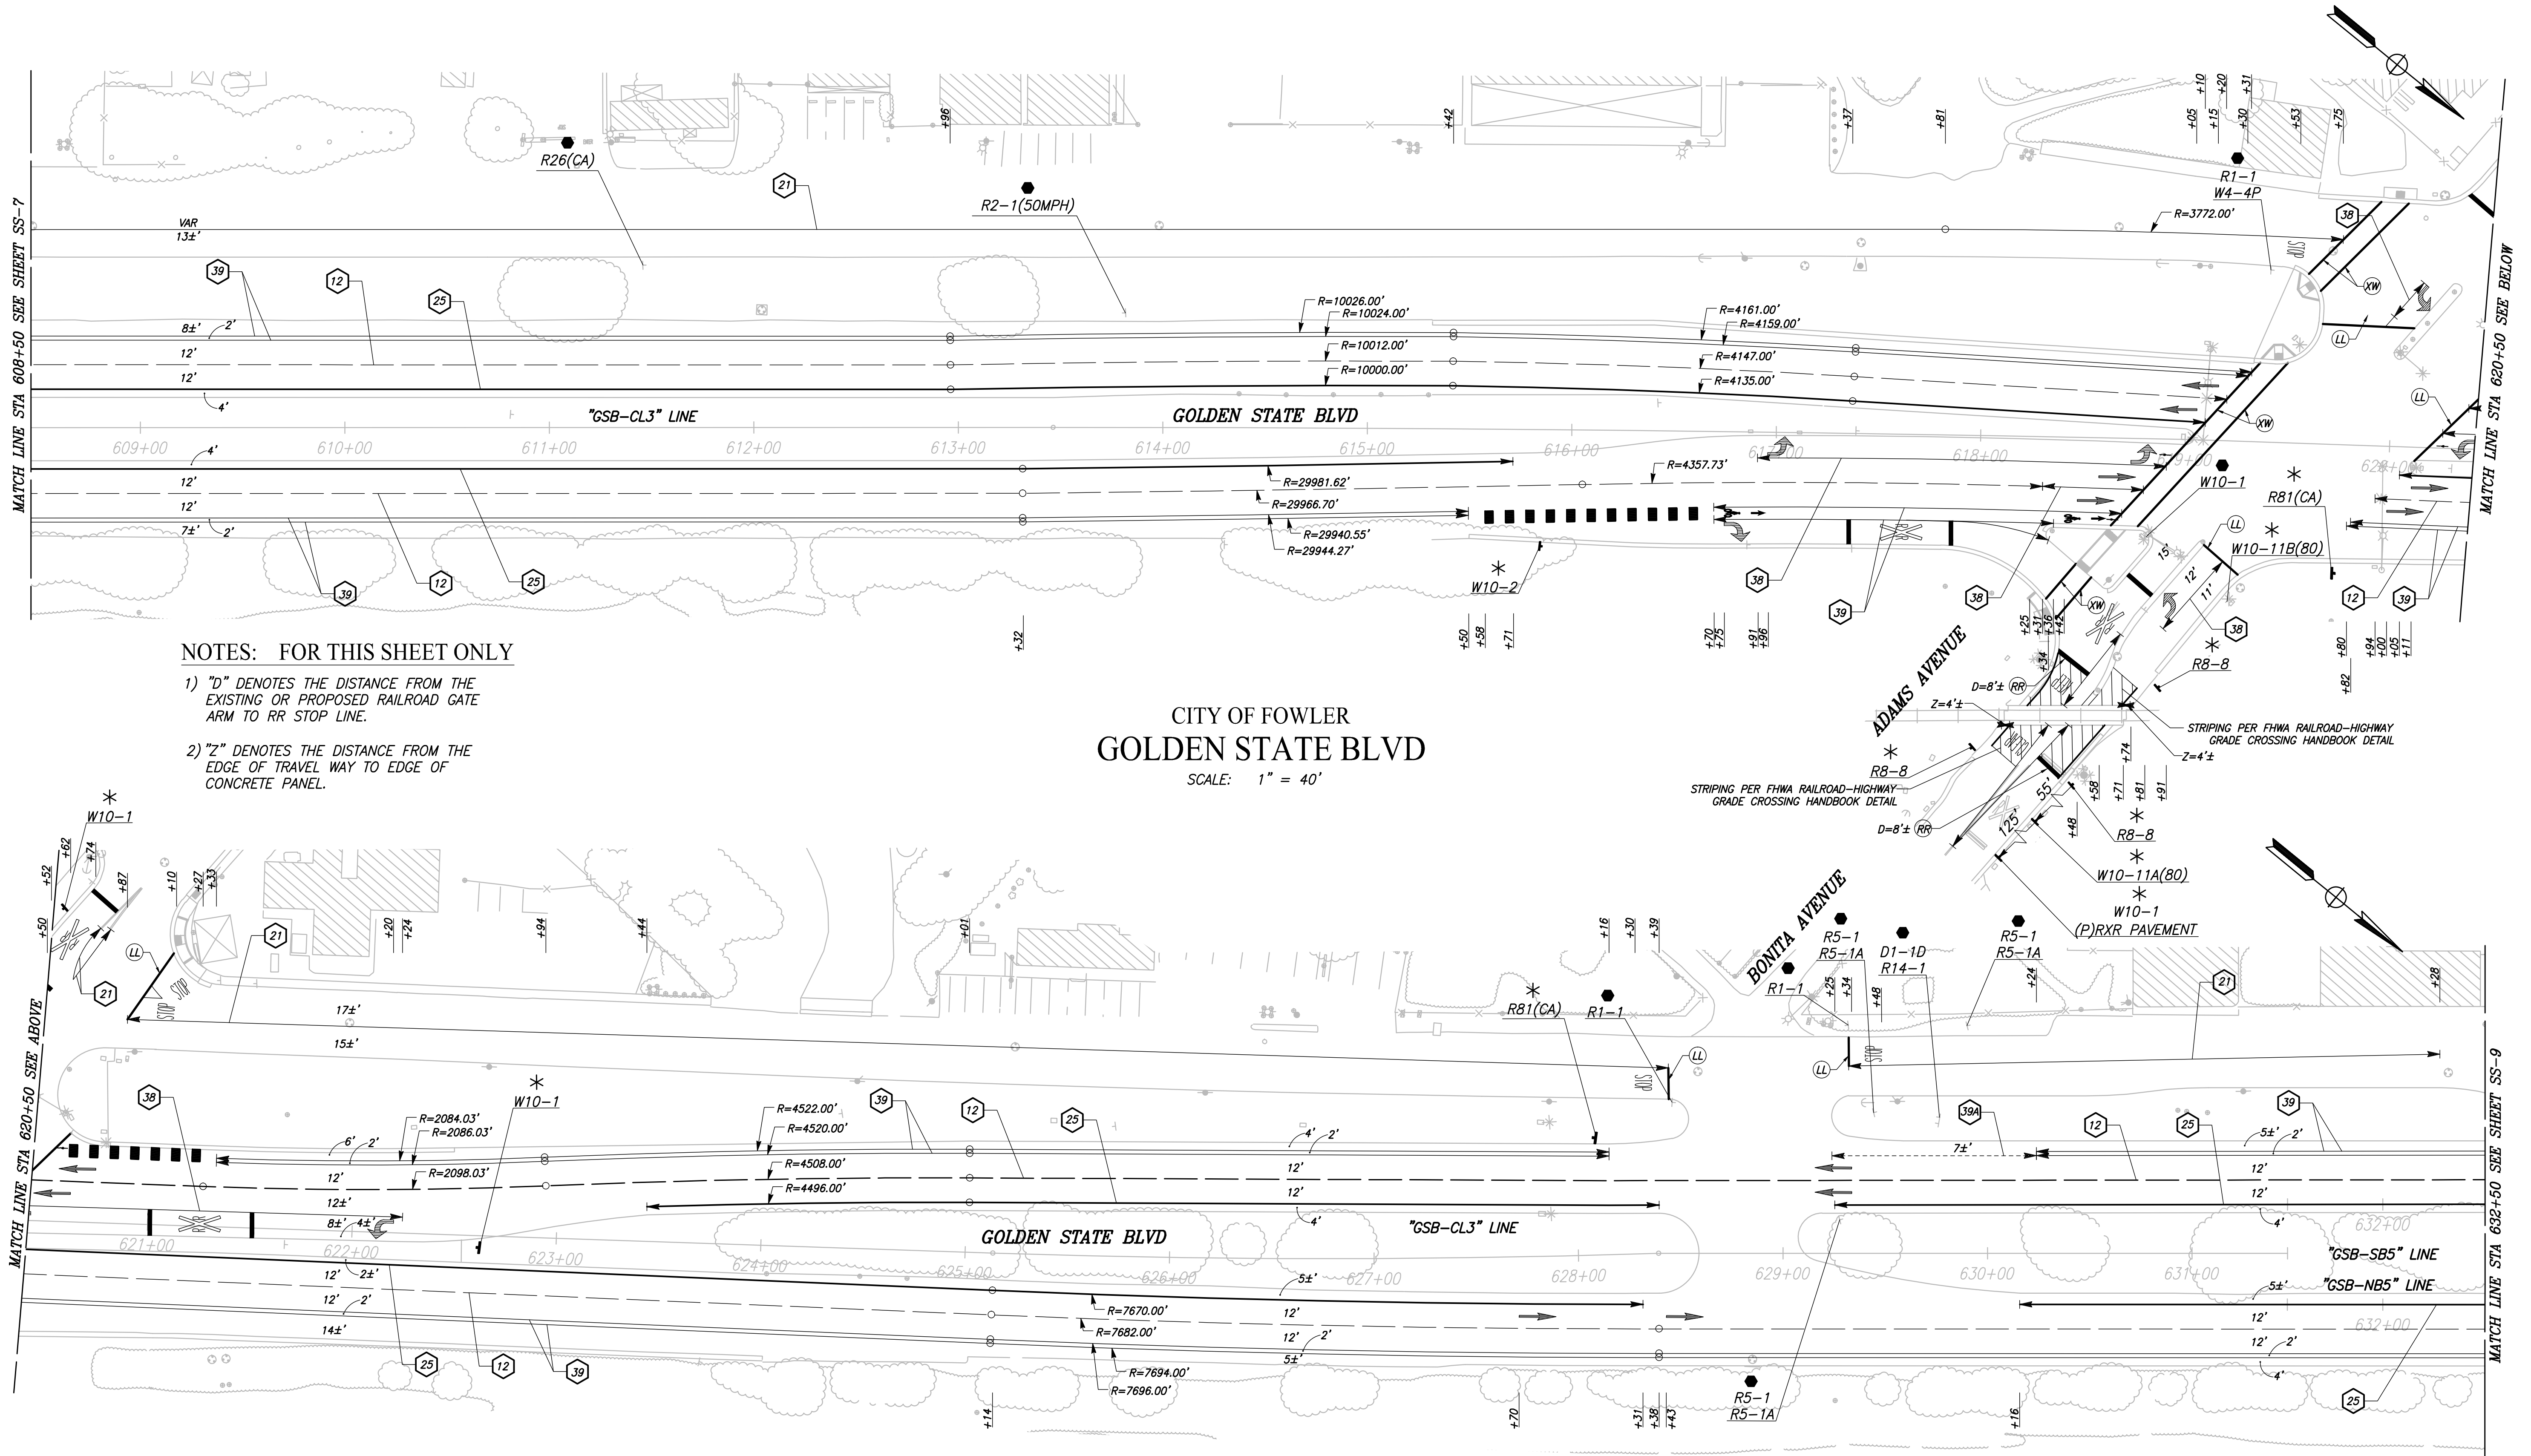

NOTES: FOR THIS SHEET ONLY

- 1) "D" DENOTES THE DISTANCE FROM THE EXISTING OR PROPOSED RAILROAD GATE ARM TO RR STOP LINE.
- 2) "Z" DENOTES THE DISTANCE FROM THE EDGE OF TRAVEL WAY TO EDGE OF CONCRETE PANEL.

CITY OF FOWLER
GOLDEN STATE BLVD

SCALE: 1" = 40'


DESIGNED: ERIK CHIN		DATE	RECORD DRAWING	
DRAWN: DILLON ALAMEDA		####	RESIDENT ENGINEER	DATE
CHECKED: ED NORIEGA		####		
FOR RIGHT OF WAY DATA AND ACCURATE ACCESS DETERMINATION, SEE DOCUMENTS IN THE DEPARTMENT OF PUBLIC WORKS AND PLANNING.				



TENTATIVE PLANS FOR DESIGN	
SUPERVISING ENGINEER	DATE




PROJECT	
GOLDEN STATE CORRIDOR - ECONOMIC DEVELOPMENT AND INFRASTRUCTURE IMPROVEMENTS	
FOWLER REGION	

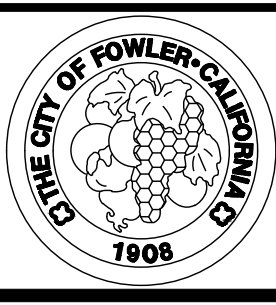


DEPARTMENT OF PUBLIC WORKS AND PLANNING		
SIGNING AND STRIPING		
DRAWING NO. SS-8	SHEET NO. 101	TOTAL 142

PLOT DATE: 4/2/2021 8:53:38 AM CAD USER: ECHIN

PATH: J:\Fresno COG-FN-16105-GSB Final Design\CADD\Sheets\Region 3 - Fowler\GSB_R3_SS8-SS13.dwg

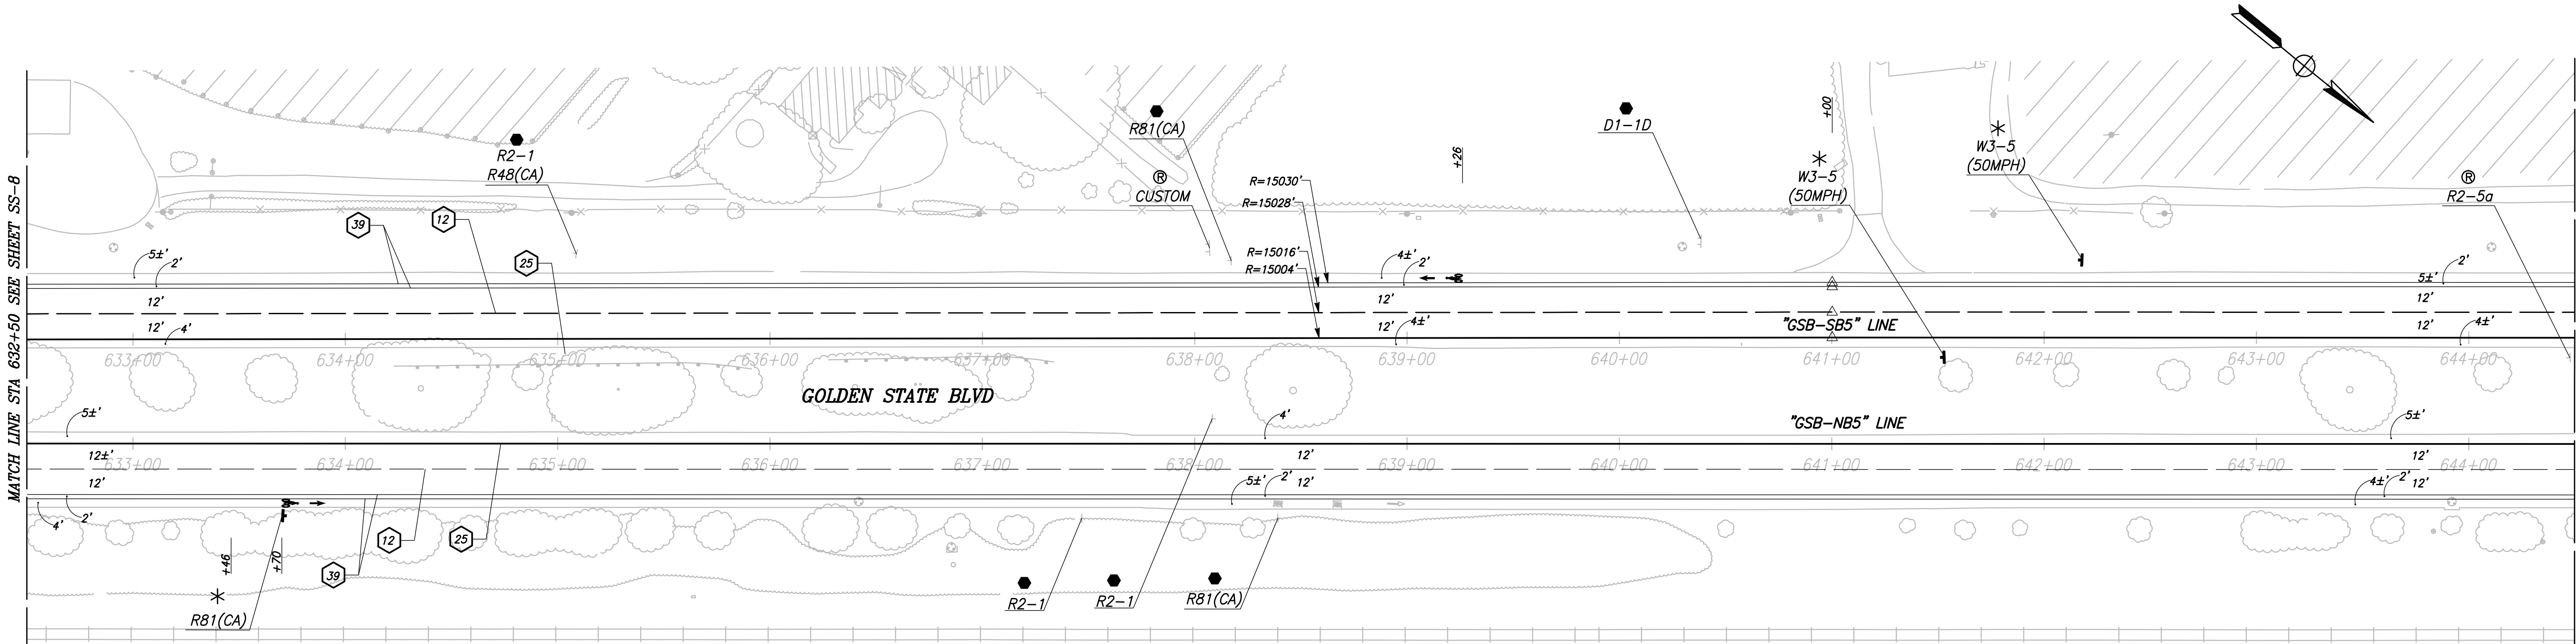

CITY OF FOWLER
GOLDEN STATE BLVD
SCALE: 1" = 40'

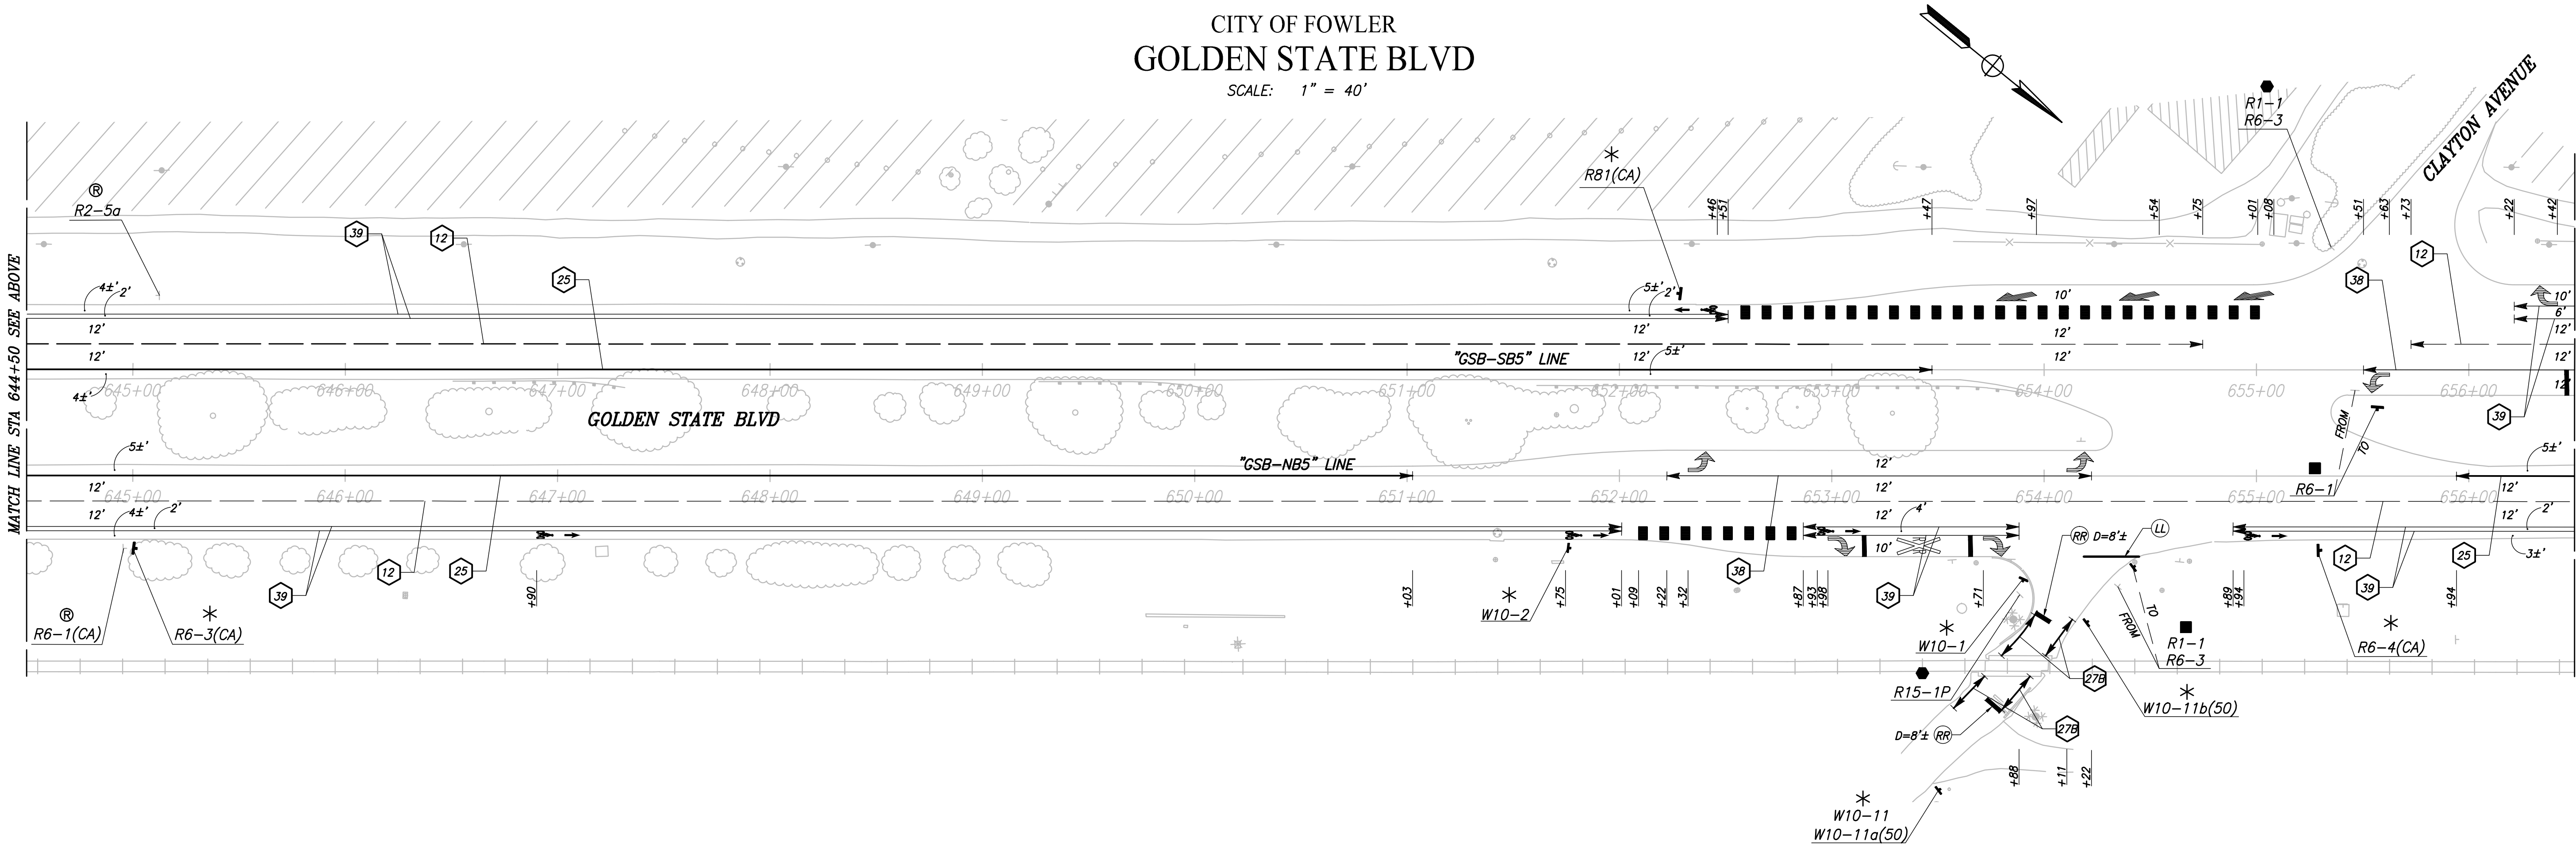


RECORD DRAWING	
DESIGNED: ERIK CHIN	DATE: ####
DRAWN: DILLON ALAMEDA	DATE: ####
CHECKED: ED NORIEGA	DATE: ####



TENTATIVE PLANS FOR DESIGN	SUPERVISING ENGINEER	DATE
----------------------------	----------------------	------




PROJECT
GOLDEN STATE CORRIDOR - ECONOMIC DEVELOPMENT AND INFRASTRUCTURE IMPROVEMENTS
FOWLER REGION

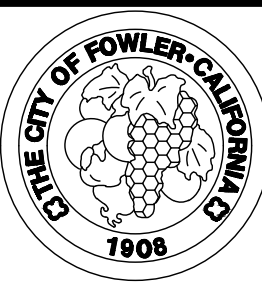


DEPARTMENT OF PUBLIC WORKS AND PLANNING		
SIGNING AND STRIPING		
DRAWING NO. SS-9	SHEET NO. 102	TOTAL 142

PATH: J:\Fresno COG-FN-16105-GSB Final Design\CADD\Drawings\Region 3 - Fowler\GSB_R3_SS8-SS13.dwg
PLOT DATE: 4/2/2021 8:54:01 AM
CAD USER: ECHIN


PATH: J:\Fresno COG-FN-16105-GSB Final Design\CADD\Drawings\Region 3 - Fowler\GSB_R3_SS8-SS13.dwg
PLOT DATE: 4/2/2021 8:54:01 AM
CAD USER: ECHIN

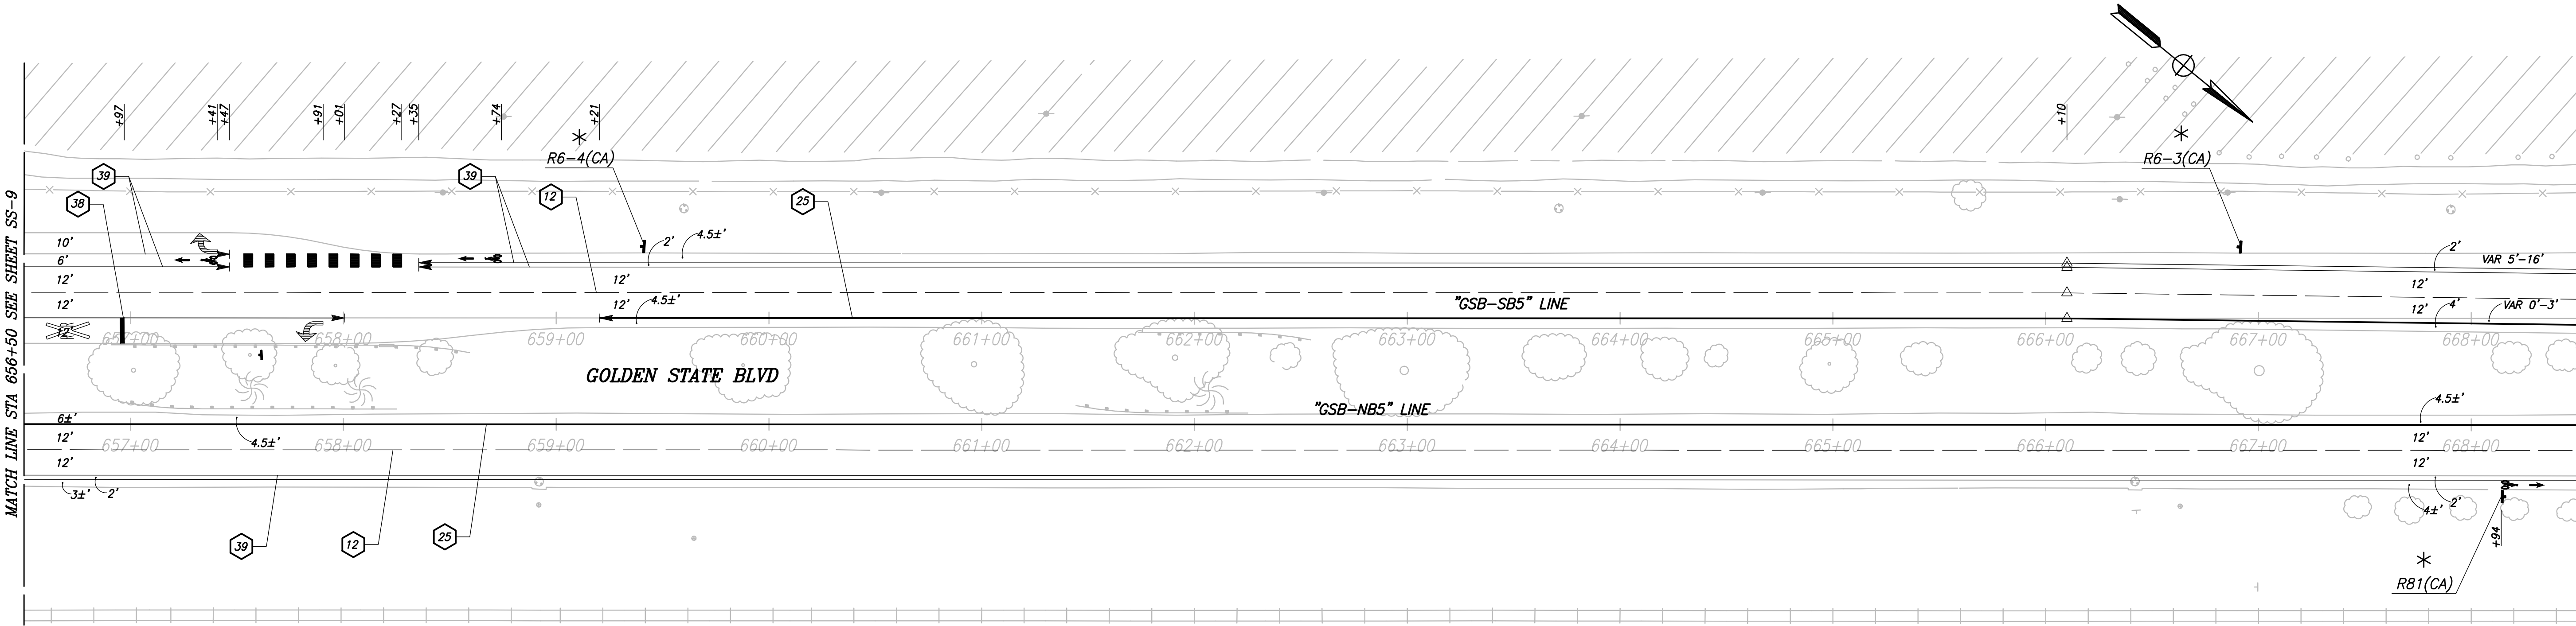


CITY OF FOWLER
GOLDEN STATE BLVD
SCALE: 1" = 40'

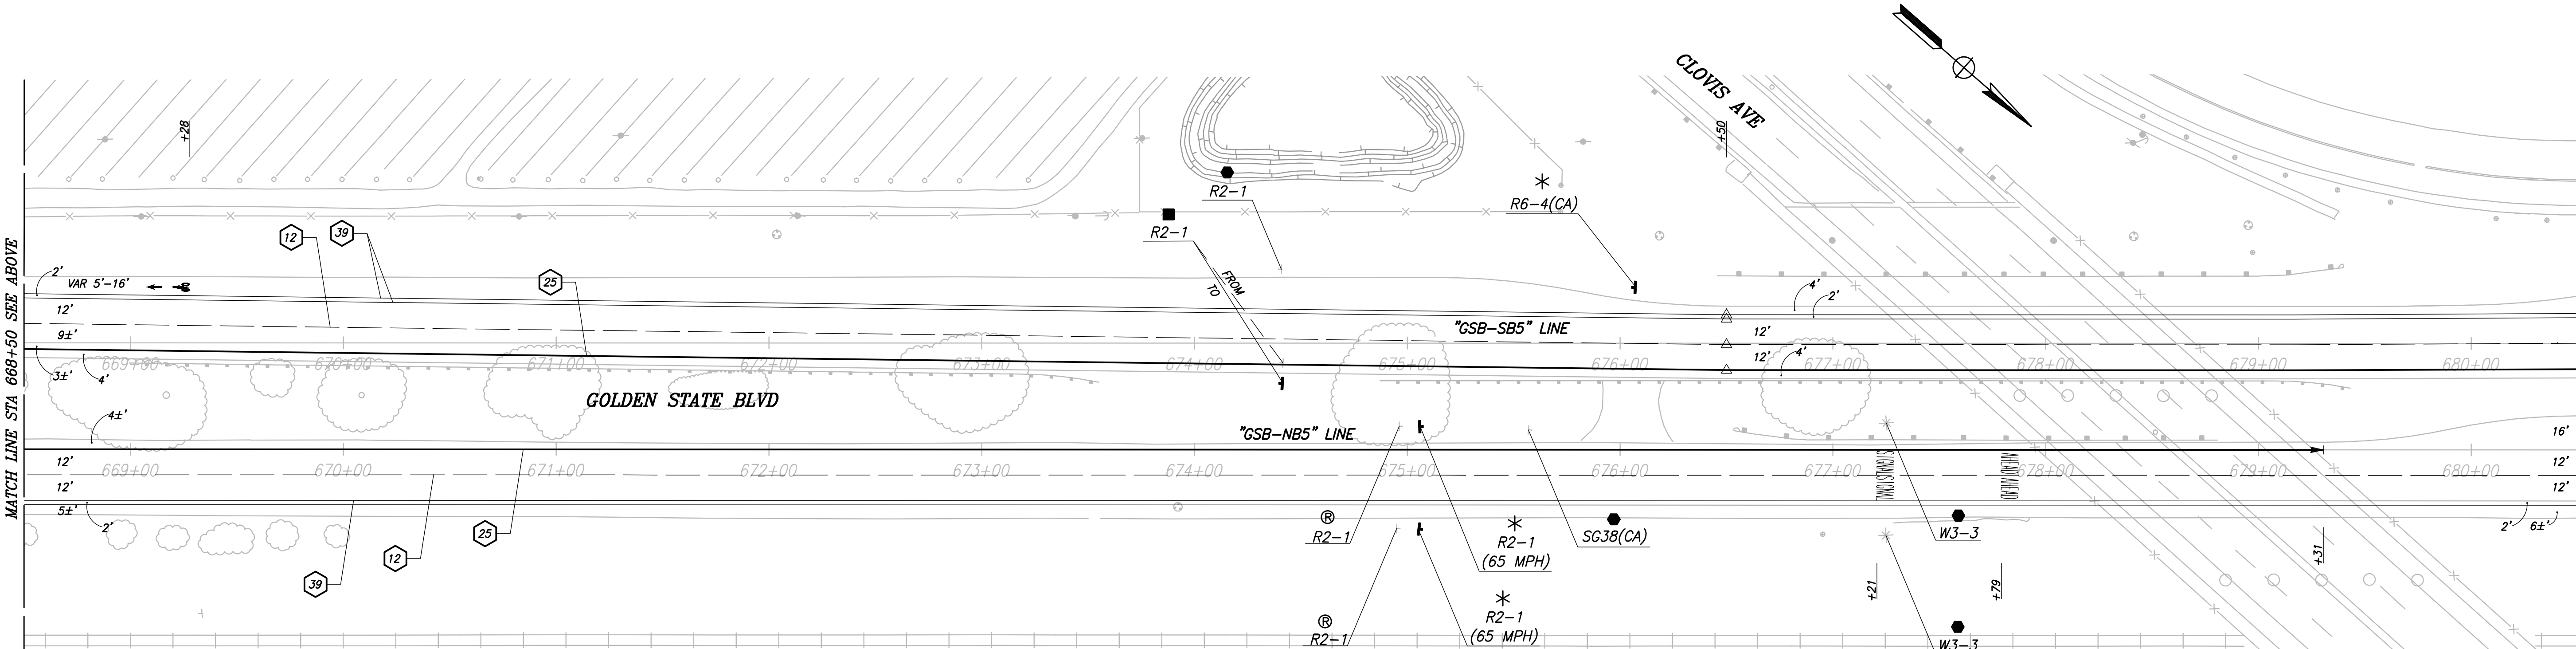


RECORD DRAWING	
DESIGNED: ERIK CHIN	DATE: ####
DRAWN: DILLON ALAMEDA	DATE: ####
CHECKED: ED NORIEGA	DATE: ####

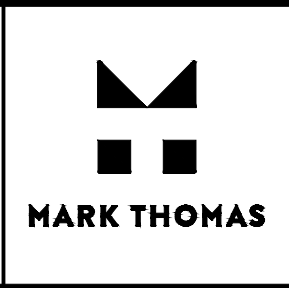


TENTATIVE PLANS FOR DESIGN
SUPERVISING ENGINEER
DATE

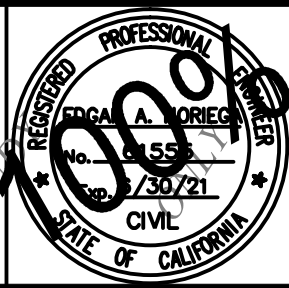


PROJECT
GOLDEN STATE CORRIDOR - ECONOMIC DEVELOPMENT AND INFRASTRUCTURE IMPROVEMENTS
FOWLER REGION

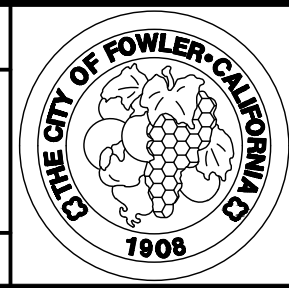


DEPARTMENT OF PUBLIC WORKS AND PLANNING
SIGNING AND STRIPING
DRAWING NO. SS-10
SHEET NO. 103
TOTAL 142

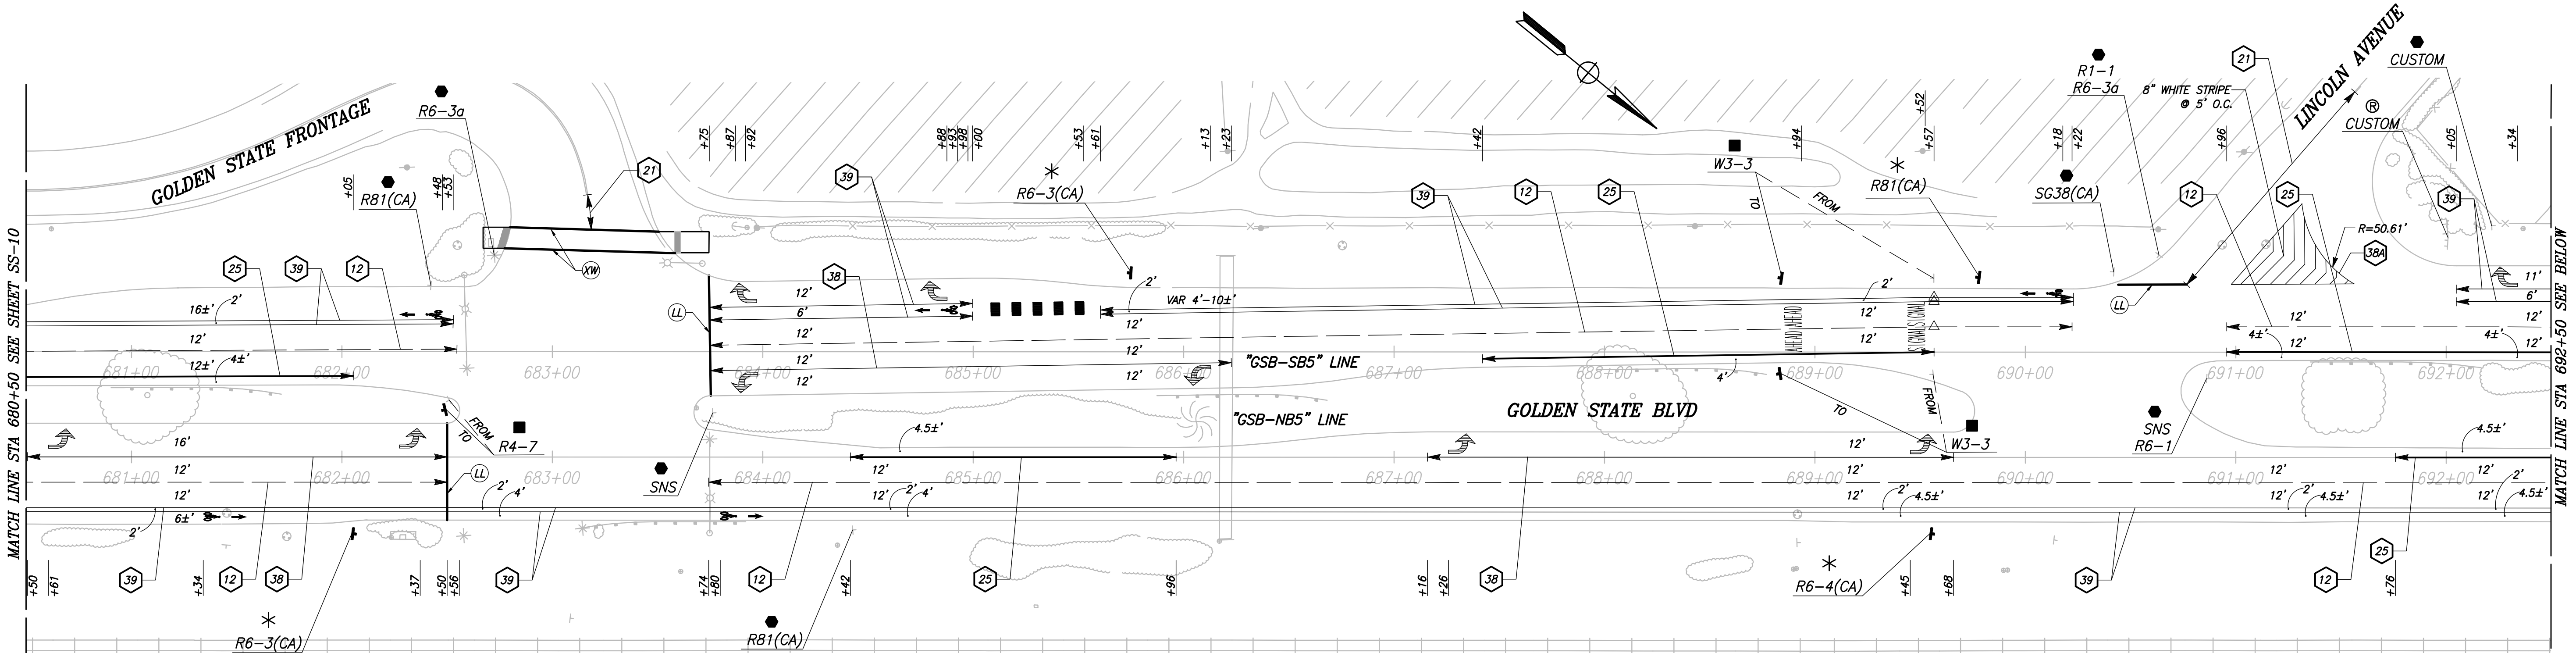

CITY OF FOWLER
GOLDEN STATE BLVD
SCALE: 1" = 40'

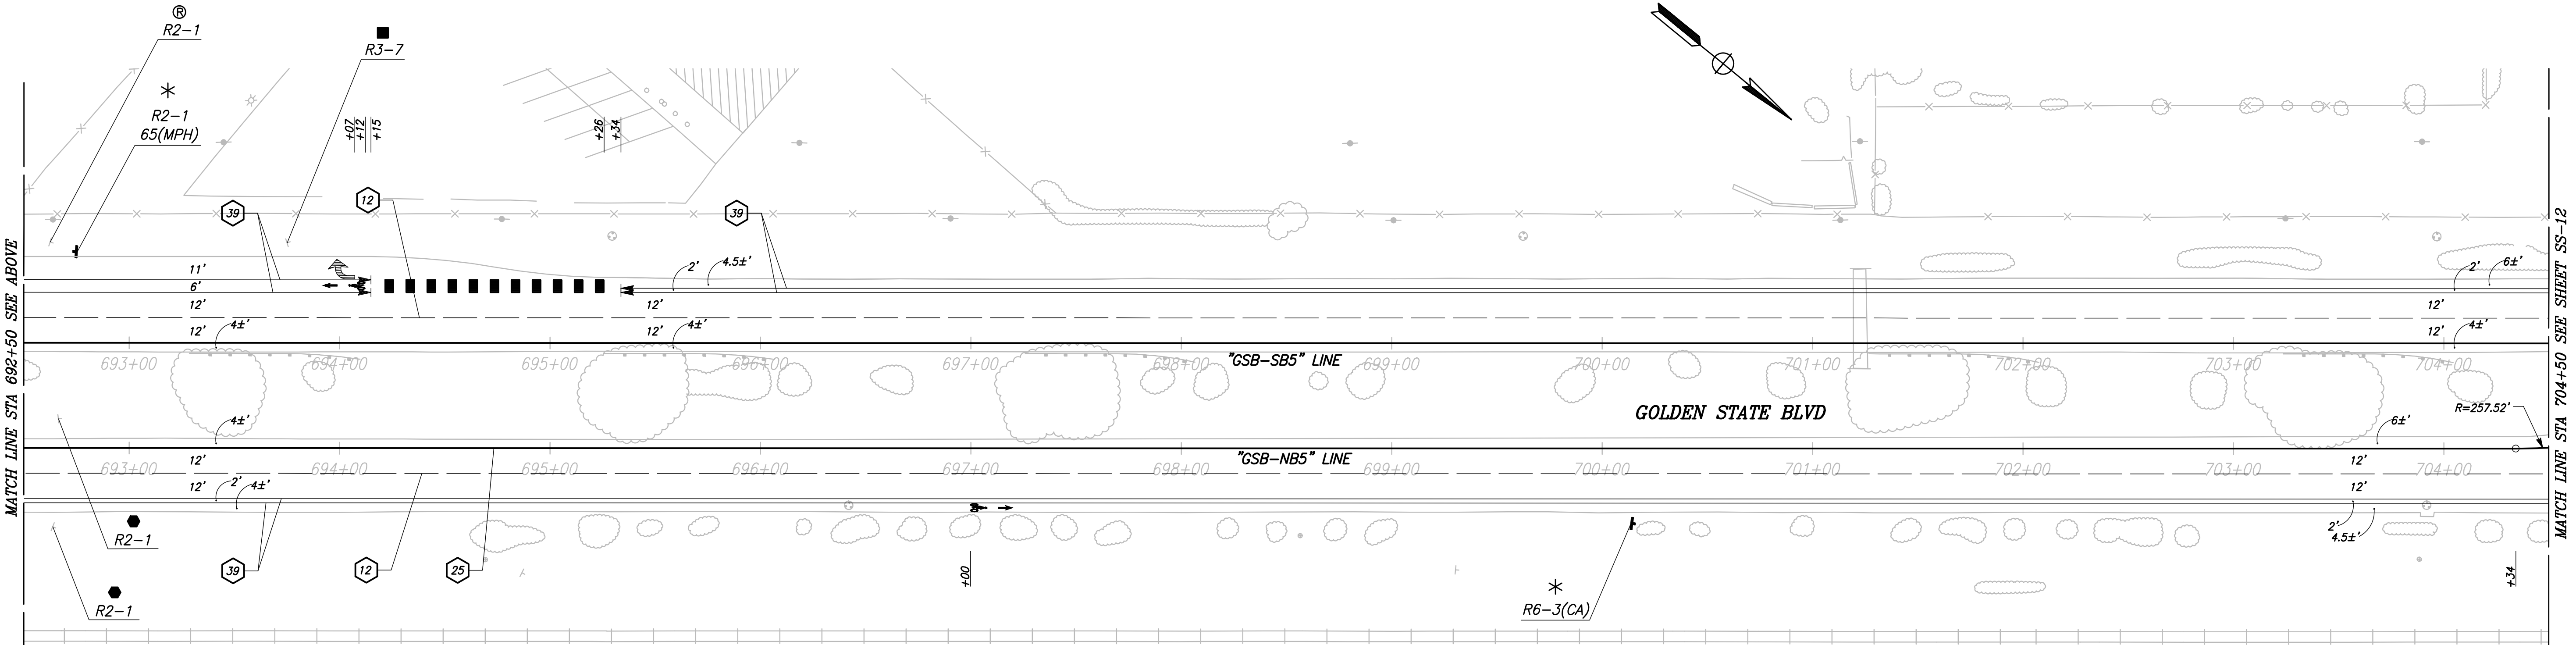


RECORD DRAWING		
DESIGNED: ERIK CHIN	DATE: ####	RESIDENT ENGINEER: _____
DRAWN: DILLON ALAMEDA	DATE: ####	DATE: _____
CHECKED: ED NORIEGA	DATE: ####	DATE: _____
FOR RIGHT OF WAY DATA AND ACCURATE ACCESS DETERMINATION, SEE DOCUMENTS IN THE DEPARTMENT OF PUBLIC WORKS AND PLANNING.		

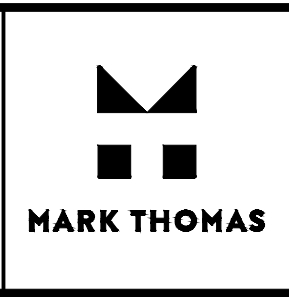


TENTATIVE PLANS FOR DESIGN
SUPERVISING ENGINEER: _____
DATE: _____




PROJECT
GOLDEN STATE CORRIDOR - ECONOMIC DEVELOPMENT AND INFRASTRUCTURE IMPROVEMENTS
FOWLER REGION

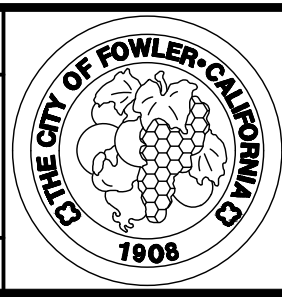

DEPARTMENT OF PUBLIC WORKS AND PLANNING
SIGNING AND STRIPING
DRAWING NO. SS-11 SHEET NO. 104 TOTAL 142

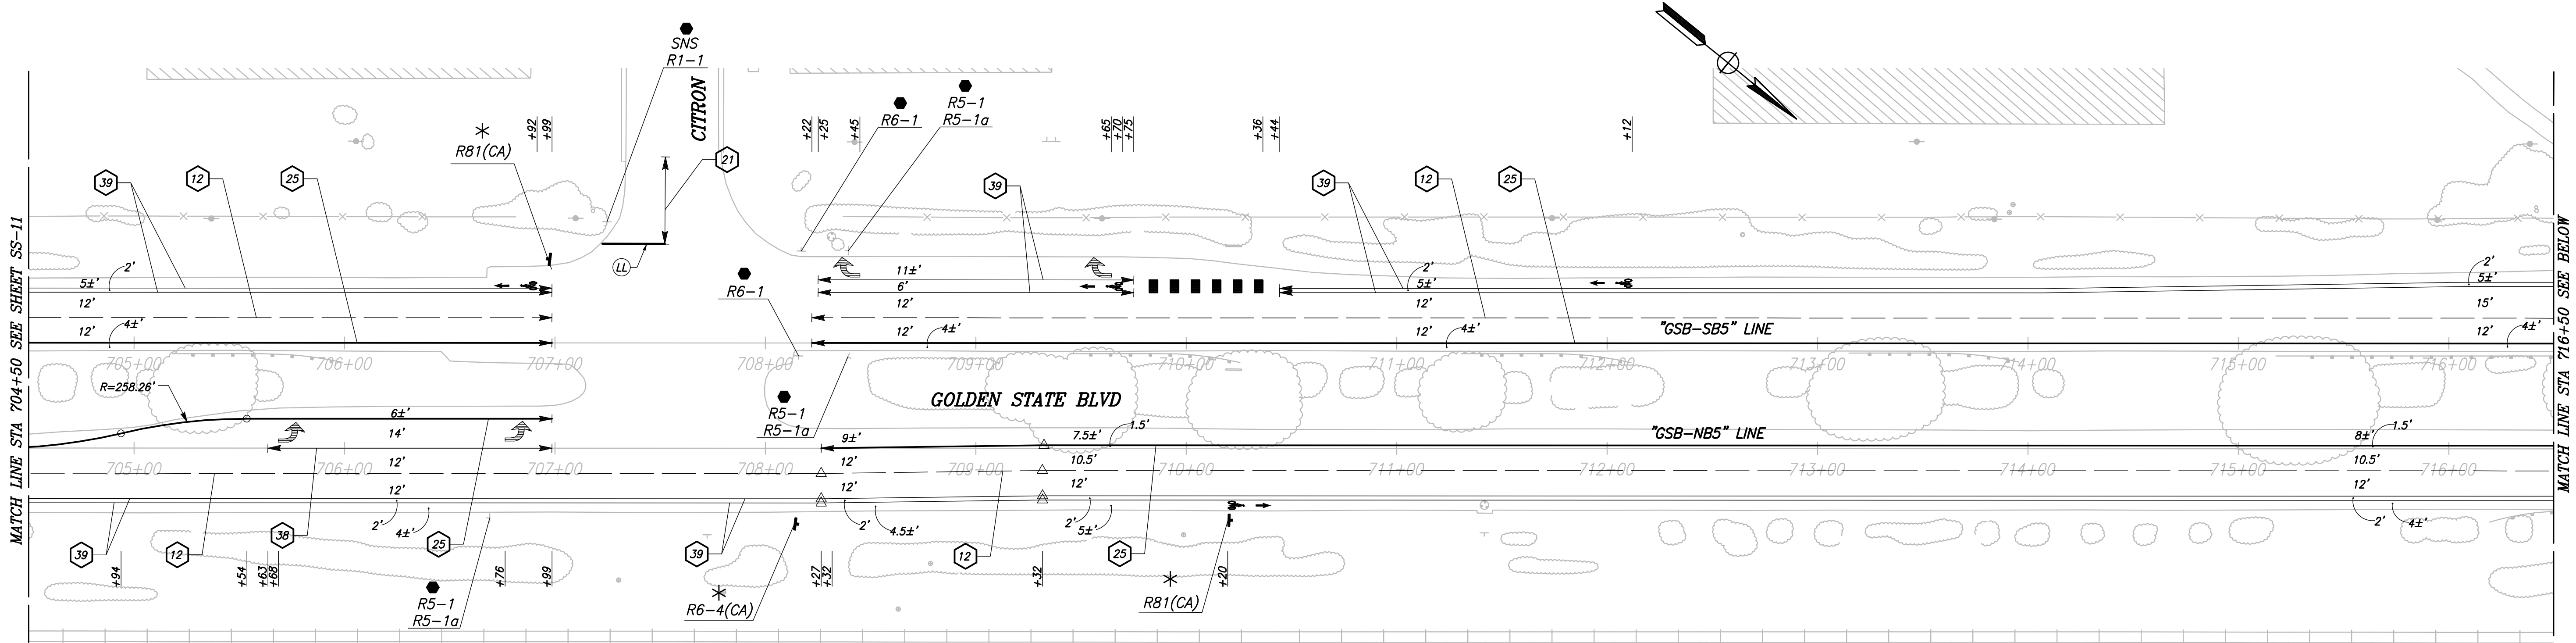

CITY OF FOWLER
GOLDEN STATE BLVD
SCALE: 1" = 40'

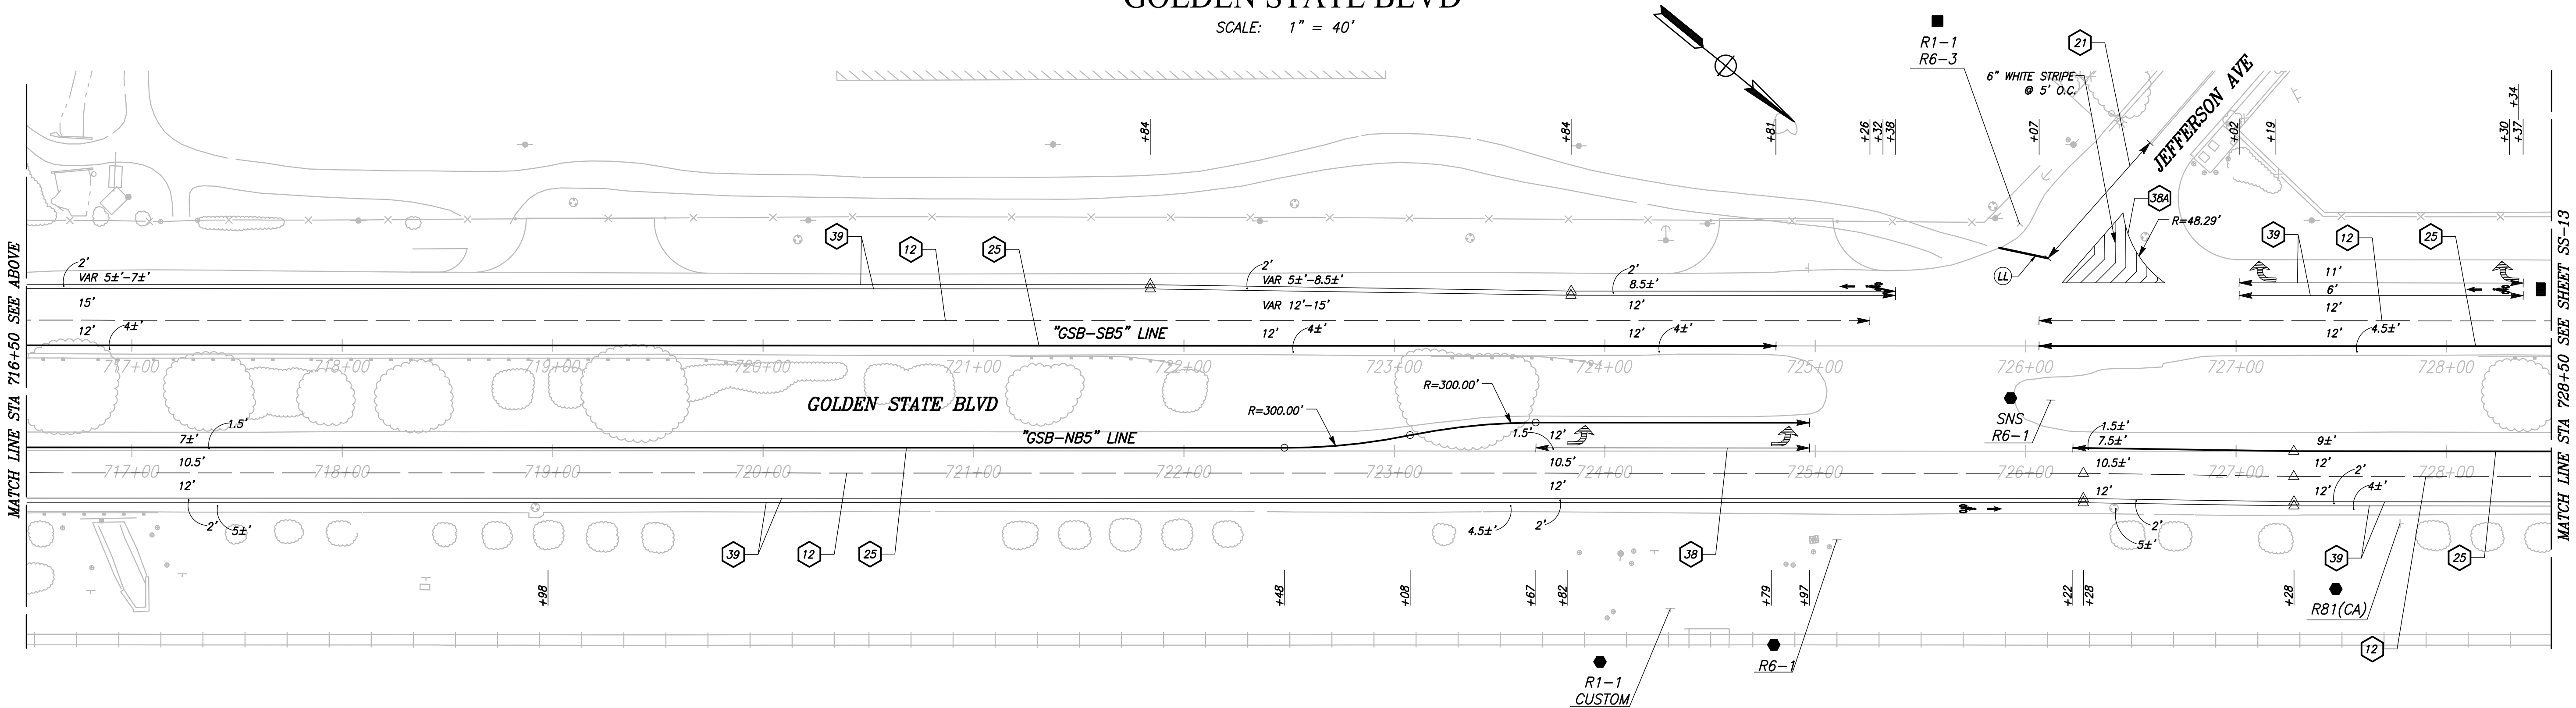

RECORD DRAWING	
DESIGNED: ERIK CHIN	DATE: ####
DRAWN: DILLON ALAMEDA	DATE: ####
CHECKED: ED NORIEGA	DATE: ####


FOR RIGHT OF WAY DATA AND ACCURATE ACCESS DETERMINATION, SEE DOCUMENTS IN THE DEPARTMENT OF PUBLIC WORKS AND PLANNING.




TENTATIVE PLANS FOR DESIGN	DATE: 03/20/21
SUPERVISING ENGINEER	DATE: 03/20/21




PROJECT
GOLDEN STATE CORRIDOR - ECONOMIC DEVELOPMENT AND INFRASTRUCTURE IMPROVEMENTS
FOWLER REGION

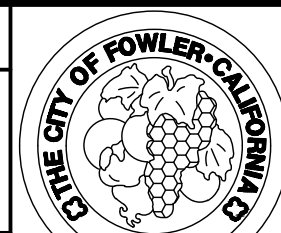

DEPARTMENT OF PUBLIC WORKS AND PLANNING		
SIGNING AND STRIPING		
DRAWING NO. SS-12	SHEET NO. 105	TOTAL 142

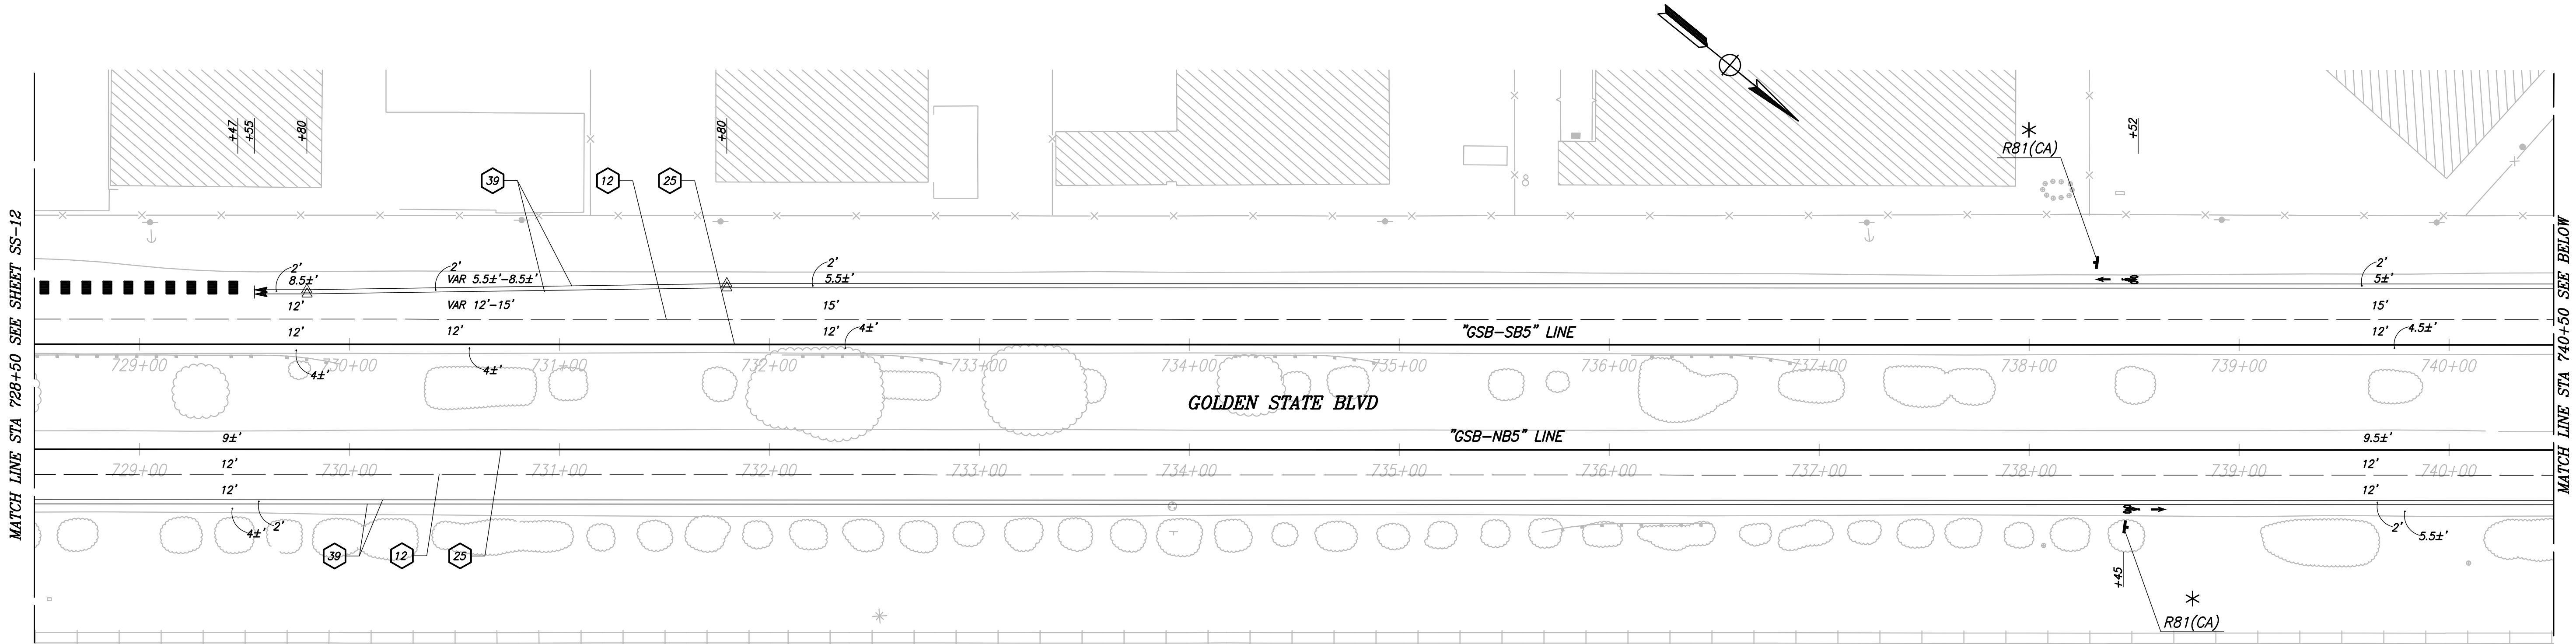


CITY OF FOWLER
GOLDEN STATE BLVD
SCALE: 1" = 40'

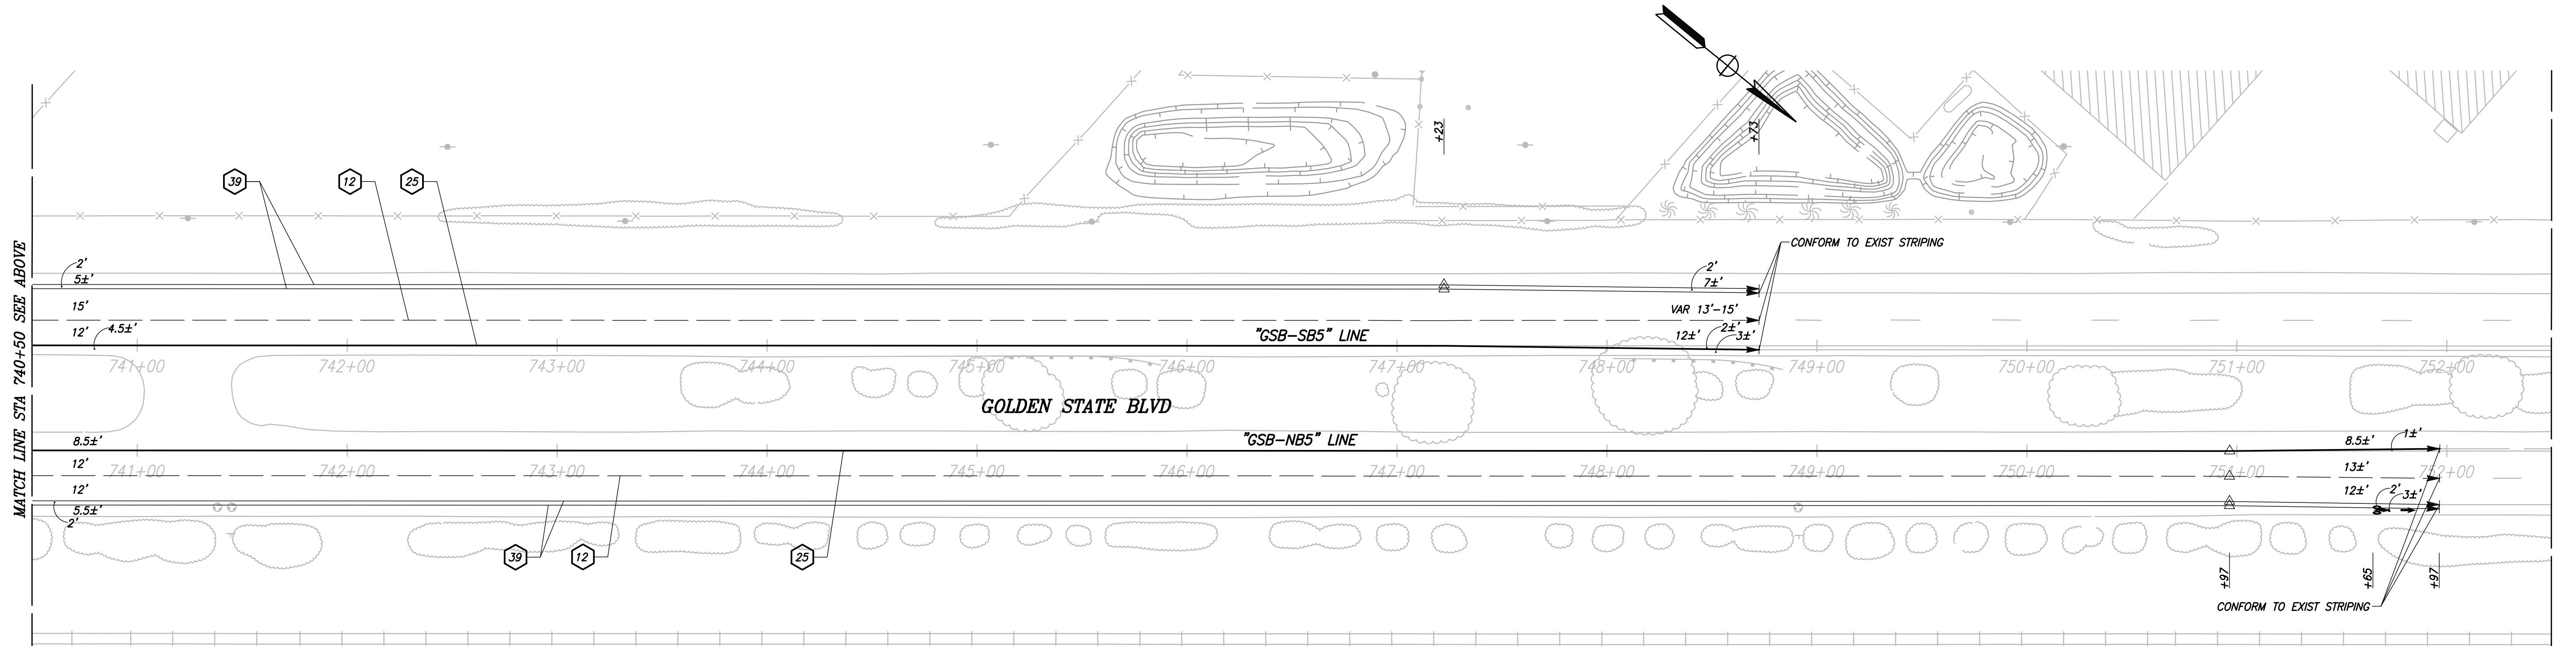

RECORD DRAWING		DATE
DESIGNED: ERIK CHIN	####	
DRAWN: DILLON ALAMEDA	####	
CHECKED: ED NORIEGA	####	


FOR RIGHT OF WAY DATA AND ACCURATE ACCESS DETERMINATION, SEE DOCUMENTS IN THE DEPARTMENT OF PUBLIC WORKS AND PLANNING.

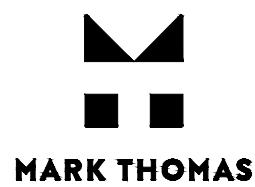

TENTATIVE PLANS FOR DESIGN	
SUPERVISING ENGINEER	DATE






PROJECT	
GOLDEN STATE CORRIDOR - ECONOMIC DEVELOPMENT AND INFRASTRUCTURE IMPROVEMENTS	
FOWLER REGION	

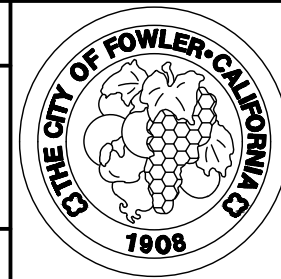

DEPARTMENT OF PUBLIC WORKS AND PLANNING		
SIGNING AND STRIPING		

DRAWING NO. SS-13 SHEET NO. 106 TOTAL 142

PATH: J:\Fresno COG-FN-16105-GSB Final Design\CADD\Sheets\Region 3 - Fowler\GSB_R3_SS8-SS13.dwg PLOT DATE: 4/2/2021 8:55:33 AM CAD USER: ECHIN

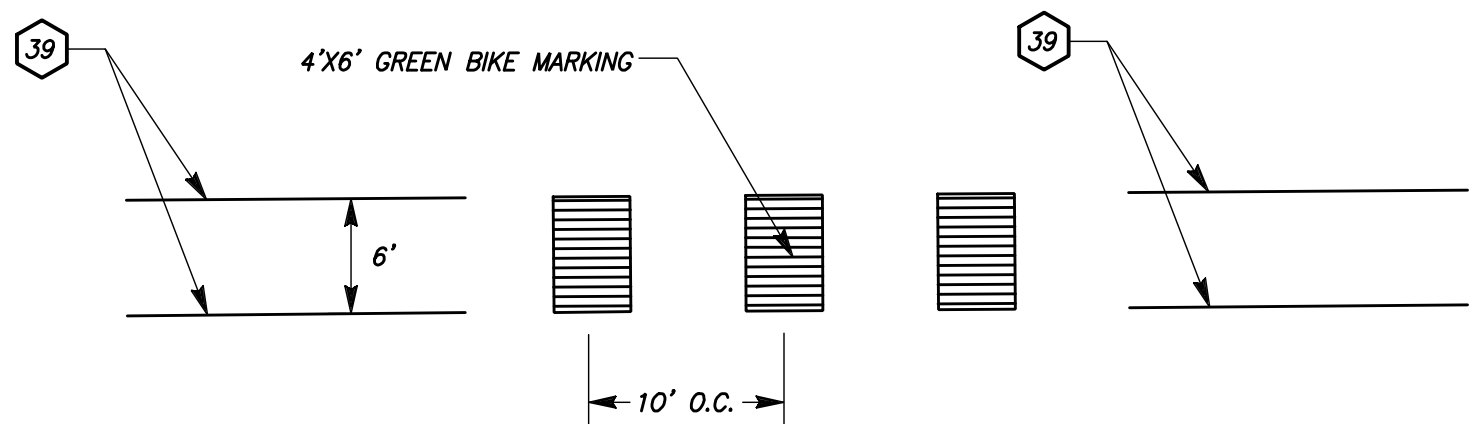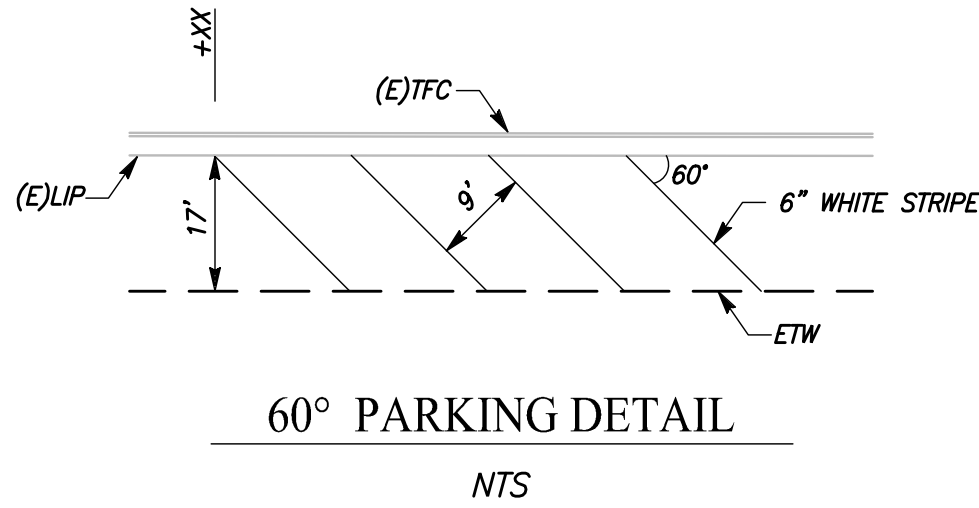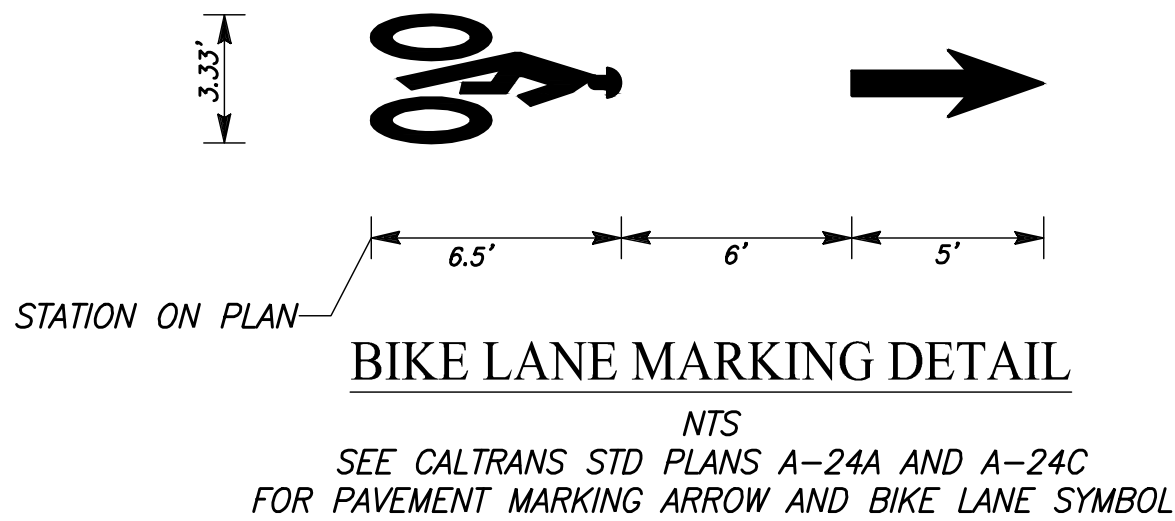

GREEN DASHED MARKINGS IN
MERGING AREAS DETAIL

SCALE: 1" = 10'

	DATE	RECORD DRAWING	
DESIGNED: ERIK CHIN	####	RESIDENT ENGINEER	DATE
DRAWN: DILLON ALAMEDA	####		
CHECKED: ED NORIEGA	####		


FOR RIGHT OF WAY DATA AND ACCURATE ACCESS DETERMINATION, SEE DOCUMENTS IN THE DEPARTMENT OF PUBLIC WORKS AND PLANNING.



TENTATIVE PLANS FOR DESIGN	DATE
SUPERVISING ENGINEER	




PROJECT
GOLDEN STATE CORRIDOR - ECONOMIC DEVELOPMENT AND INFRASTRUCTURE IMPROVEMENTS
FOWLER REGION

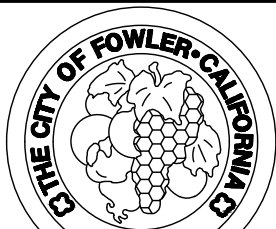

DEPARTMENT OF PUBLIC WORKS AND PLANNING		
SIGNING AND STRIPING		
DRAWING NO. SS-14	SHEET NO. 107	TOTAL 142

PATH: Z:\01 Projects\009 Fresno County\009-009 Golden State PS&E\Street Lighting Designs\Design\Fowler\009-009 Golden State PS&E - Fowler Lighting.dwg
PLOT DATE: 4/6/2021 11:15:32 AM
CAD USER: CAYALA

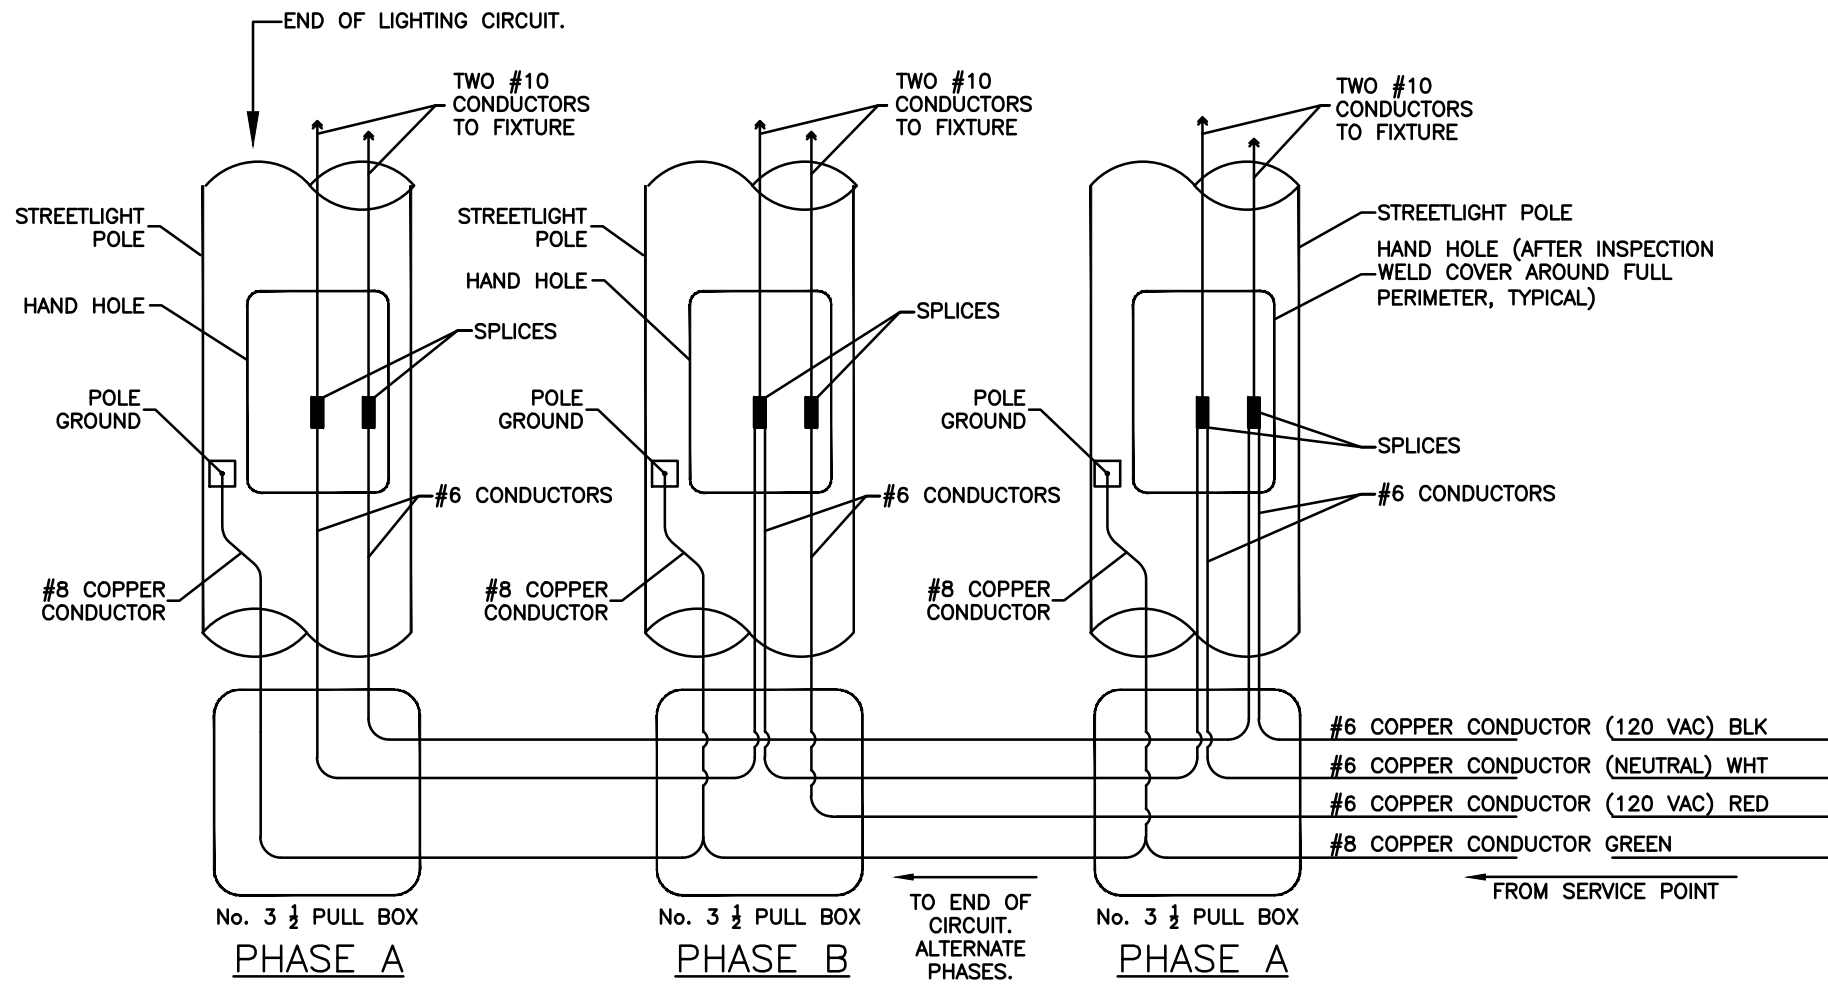


NOTES:
1. WITH EXCEPTION OF BONDING JUMPERS, NO SPLICES WILL BE ALLOWED IN PULL BOXES.

STREETLIGHT - CONNECTION DIAGRAM (SHEETS E-1 THROUGH E-9 ONLY)

STREET LIGHTING LEGEND (SHEETS E-1 THROUGH E-9 ONLY):

- EXISTING CONDUIT
- INSTALL 1 1/2" CONDUIT UNLESS OTHERWISE NOTED.
- o--o EXISTING STREET LIGHT.
- o--o--o EXISTING DUAL STREET LIGHT.
- FURNISH AND INSTALL STREET LIGHT WITH 15' LUMINAIRE MAST ARM PER CITY OF FRESNO STANDARD E-1. LUMINAIRE SHALL BE SELECTED FROM THE CITY OF FRESNO APPROVED LED STREET LIGHT FIXTURE LIST PER GENERAL NOTE 9. X IDENTIFIES CIRCUIT.
- FURNISH AND INSTALL STREET LIGHT WITH DUAL 15' LUMINAIRE MAST ARM PER CITY OF FRESNO STANDARD E-1. LUMINAIRE SHALL BE SELECTED FROM THE CITY OF FRESNO APPROVED LED STREET LIGHT FIXTURE LIST PER GENERAL NOTE 9. X IDENTIFIES CIRCUIT.
- FURNISH AND INSTALL ORNAMENTAL LIGHT (DUAL LUMINAIRE). STREET LIGHT SHALL BE AMERLUX SAN DIEGO SERIES AP1705-12-GRN-GFCI-TOP WITH BR08U CROSSARM 2BR08U-GRN AND DUAL UTILITY LED LUMINAIRE AP24 SERIES DUF4-AP24-PC-CL-AV12-AS-30-700M-GRN. X IDENTIFIES CIRCUIT.
- EXISTING SAFETY LIGHT.
- NEW SAFETY LIGHT. SEE TRAFFIC SIGNAL PLANS.
- INSTALL 3 1/2" PULL BOX UNLESS OTHERWISE NOTED.
- CONTRACTOR SHALL PROVIDE AN AS-BUILT WITH THE PG&E STREET LIGHT NUMBER.
- EXISTING CITY OWNED STREET LIGHT.
- EXISTING PG&E OWNED STREET LIGHT.
- INSTALL CONDUIT INTO EXISTING PULL BOX.
- ABANDON, IF APPLIED TO CONDUIT, REMOVE CONDUCTORS.
- REMOVE AND SALVAGE.
- EQUIPMENT OR MATERIAL TO BE REMOVED AND BECOME THE PROPERTY OF THE CONTRACTOR.
- FOUNDATION TO BE ABANDONED. REMOVE TOP OF FOUNDATION TO A POINT 36" BELOW THE ADJACENT GRADE.
- SPLICE NEW TO EXISTING CONDUCTORS.

USA
KNOW WHAT'S BELOW
BEFORE YOU DIG,
CALL
1-800-227-2600

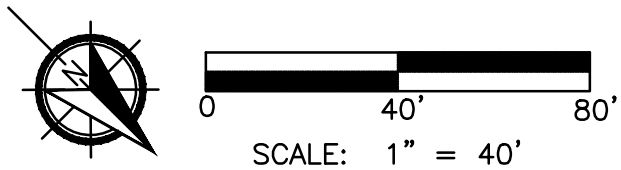

CONSTRUCTION NOTES (SHEETS E-1 THROUGH E-9 ONLY):

- NOT A PART OF STREET LIGHTING. SAFETY LIGHT TO BE INSTALLED AS A PART OF THE TRAFFIC SIGNAL MODIFICATION PLAN AT GOLDEN STATE BOULEVARD AND SAN ANTONIO DRIVE.
- NOT A PART OF STREET LIGHTING. SAFETY LIGHT TO BE INSTALLED AS A PART OF THE TRAFFIC SIGNAL MODIFICATION PLAN AT GOLDEN STATE BOULEVARD AND MANNING AVENUE.
- PROPOSED PG&E POINT OF SERVICE (No. 2 PULL BOX).
- NOT A PART OF STREET LIGHTING. SAFETY LIGHT TO BE INSTALLED AS A PART OF THE TRAFFIC SIGNAL PLAN AT GOLDEN STATE BOULEVARD AND TEMPERANCE AVENUE.
- EXISTING STREET LIGHT. EXISTING LIGHTING CIRCUIT SHALL REMAIN OPERATIONAL.
- CONTRACTOR TO COORDINATE WITH PG&E FOR THEM TO REMOVE AND SALVAGE THE EXISTING PG&E OWNED LIGHT, WOOD POLE AND OVER HEAD SERVICE WIRES.
- NOT A PART OF STREET LIGHTING. SAFETY LIGHT TO BE INSTALLED AS A PART OF THE TRAFFIC SIGNAL PLAN AT GOLDEN STATE BOULEVARD AND SOUTH AVENUE.
- LIGHT, WOOD POLE AND OVERHEAD SERVICE WIRE. CONTRACTOR TO COORDINATE WITH PG&E FOR SERVICE DISCONNECT.
- NOT A PART OF STREET LIGHTING. SAFETY LIGHT TO BE INSTALLED AS A PART OF THE TRAFFIC SIGNAL MODIFICATION PLAN AT GOLDEN STATE BOULEVARD AND MERCED STREET.
- NOT A PART OF STREET LIGHTING. SAFETY LIGHT TO BE INSTALLED AS A PART OF THE TRAFFIC SIGNAL MODIFICATION PLAN AT GOLDEN STATE BOULEVARD AND ADAMS AVENUE.
- EXISTING PG&E SERVICE POLE 120/240 V, TYPE B SERVICE. CONTRACTOR TO COORDINATE WITH PG&E TO REMOVE EXISTING TYPE B SERVICE AND INSTALL TYPE H SERVICE.
- DISCONNECT FROM EXISTING LIGHTING CIRCUIT AND CONNECT TO NEW SERVICE PEDESTAL ON TEMPERANCE AVENUE.
- CONTRACTOR TO COORDINATE WITH PG&E FOR THE REMOVAL OF THE EXISTING LUMINAIRE MAST ARM AND LUMINAIRE #1978.
- INSTALL 3" C FOR TYPE H PG&E SERVICE.
- INSTALL 1 1/2" C, 6 #6 LIGHTING, AND 1 #8 BOND.
- INSTALL 1 1/2" C, 3 #6 LIGHTING, AND 1 #8 BOND.
- INSTALL 1 1/2" C, 2 #6 LIGHTING, AND 1 #8 BOND.

CONSTRUCTION NOTES CONT. (SHEETS E-1 THROUGH E-9 ONLY):


- EXISTING 1 1/2" C, 3 #6 LIGHTING, AND 1 #8 BOND.
- INSTALL 2" C, 3 #2 (SERVICE).
- 3" C, SERVICE CONDUCTORS BY PG&E.
- INSTALL NEW TYPE III-AF SERVICE CABINET. CONTRACTOR SHALL COORDINATE WITH PG&E FOR POINT OF SERVICE CONNECTION AND SET METER.

GENERAL NOTES (SHEETS E-1 THROUGH E-9 ONLY):

- ALL WORK SHALL CONFORM TO APPLICABLE SECTIONS OF THE STATE OF CALIFORNIA "STANDARD SPECIFICATIONS", ISSUED BY THE CALIFORNIA DEPARTMENT OF TRANSPORTATION, THE NATIONAL ELECTRICAL CODE, AND THESE SPECIAL PROVISIONS:
- LUMINAIRE SHALL BE COBRA HEAD TYPE, 120V LIGHT EMITTING DIODE (LED) WITH QUICK ACTING PHOTOELECTRIC CELL AND SHALL BE SELECTED PURSUANT TO SECTION 23-3 OF THE CITY SPECIFICATIONS. INSTALL FUSE (KTK-5) AND FUSE HOLDER (BUS-HEB) IN LUMINAIRE. CONTRACTOR TO WELD HAND HOLD CLOSED AFTER FINAL INSPECTION.
- ALL STREETLIGHTS SHALL BE NUMBERED PER STD. DWG. E-25. NUMERICAL SEQUENCE TO BE OBTAINED FROM PG&E. NUMERALS SHALL BE 2-1/2" HIGH AND INSTALLED 10'-6" ABOVE FINISHED GRADE.
- ALL CONDUITS SHALL BE SCH. 80 P.V.C., OR SCH. 40 P.V.C., AS PER STD. DWG. NOS. E-1, E-2, AND E-6 (NOTE 1), EXCEPT THAT CONDUIT FOR MAJOR STREET CROSSINGS SHALL BE GALVANIZED RIGID CONDUIT. ALL PVC CONDUIT SHALL BE UNDER SIDEWALK. IF NOT UNDER SIDEWALK, GALVANIZED RIGID CONDUIT SHALL BE BACKFILLED IN A 4" WIDE TWO SACK CONCRETE SLURRY MIX.
- PULL BOX SPACING SHALL NOT EXCEED 200 FT. PULL BOXES SHALL BE REQUIRED AT ALL CONDUIT CHANGE OF DIRECTION AND ADJACENT TO EACH STREETLIGHT. INSTALL 6" 6 SACK CONCRETE CAP AND CLEAN PEA GRAVEL. STAMP THE LETTERS "SL" 2-1/2" TALL INTO THE FINISHED CONCRETE USING A STAMP DESIGNED FOR THAT PURPOSE. "POINT OF SERVICE" PULL BOX LID SHALL BE VANDAL RESISTANT LOCKING LIDS OR APPROVED EQUIVALENT WITH NO CONCRETE OR PEA GRAVEL. VANDAL RESISTANT LOCKING LIDS SHALL BE PROVIDED AND INSTALLED BY THE CONTRACTOR AT FINAL INSPECTION. CONTRACTOR SHALL PROVIDE TEMPORARY LID DURING CONSTRUCTION. LOCKING LIDS SHALL BE GALVANIZED STEEL DIAMOND PLATE, MINIMUM THICKNESS 3/16", WITH TWO (2) CLAMPING JAWS AND BE KEYED TO THE CITY OF FRESNO KEY. PULL BOXES IN NON-CONCRETE AREAS SHALL BE SURROUNDED BY A ONE-FOOT RING OF CONCRETE TO THE DEPTH OF THE PULL BOX AND EXTENSION, AND ALL CONDUITS SHALL ENTER THESE PULL BOXES THROUGH THE BOTTOM, USING 90 DEGREE ELBOWS, AND SHALL EXTEND 3 TO 5 INCHES ABOVE THE FINISHED GROUT. CONTRACTOR SHALL TIGHTEN DOWN ALL LOCKING LID(S) TO A MINIMUM TORQUE SPEC OF 25 FOOT POUNDS. UPON PROJECT COMPLETION CONTRACTOR SHALL INSTALL LOCKING LID PLUGS.
- IF THE SERVICE PEDESTAL IS EQUIPPED WITH A LIGHTING CONTACTOR AND NO MASTER PHOTO CONTROL IS INSTALLED, THE CONTRACTOR SHALL INSTALL A MASTER PHOTO CONTROL ATOP A 30' TALL SIGNAL POLE ADJACENT TO THE SERVICE PEDESTAL, OR ATOP THE NEAREST STREETLIGHT POLE. THE MASTER PHOTO CONTROL SHALL BE WIRED BACK TO THE SERVICE PEDESTAL USING THREE NO. 12 AWG STRANDED COPPER WIRES COLOR MATCHED TO THE PEC. THE PEC WILL BE MOUNTED USING HARDWARE MANUFACTURED FOR THAT PURPOSE, OR FABRICATED HARDWARE APPROVED BY THE TSSL SUPERVISOR. IF THE PEDESTAL IS NOT EQUIPPED WITH A LIGHTING CONTACTOR THE CONTRACTOR SHALL UPGRADE THE PEDESTAL TO MEET THE LATEST C.O.F. STANDARDS.
- ALL STREETLIGHTS AND SAFETY LIGHTS FED FROM A PEDESTAL EQUIPPED WITH A CONTACTOR SHALL BE SWITCHED BY THAT CONTACTOR, AND THEIR PEC'S REPLACED WITH SHORTING CAPS.
- ALL WORK SHALL COMPLY WITH CITY OF FRESNO STANDARD DRAWINGS NOS. E-1 THROUGH E-37, AND CITY OF FRESNO STANDARD SPECIFICATIONS.
- LUMINAIRE SHALL BE A "LOCAL STREETS AND MID-BLOCK OF MAJOR STREETS" LUMINAIRE SELECTED FROM THE CITY OF FRESNO APPROVED LED STREET LIGHT FIXTURE LIST AVAILABLE FOR DOWNLOAD AT [HTTPS://WWW.FRESNO.GOV/STANDARDS](https://www.fresno.gov/standards) IN THE TECHNICAL LIBRARY.

PROJECT NOTES (SHEETS E-1 THROUGH E-9 ONLY):


- ALL WORK SHALL CONFORM TO APPLICABLE SECTIONS OF THE CITY OF FOWLER STANDARDS, STATE OF CALIFORNIA "STRANDARD SPECIFICATIONS", ISSUED BY THE CALIFORNIA DEPARTMENT OF TRANSPORTATION, AND THE NATIONAL ELECTRICAL CODE.
- UPON COMPLETION OF CONSTRUCTION, CONTRACTOR SHALL PROVIDE AS-BUILT WITH THE PG&E STREET LIGHT NUMBERS.

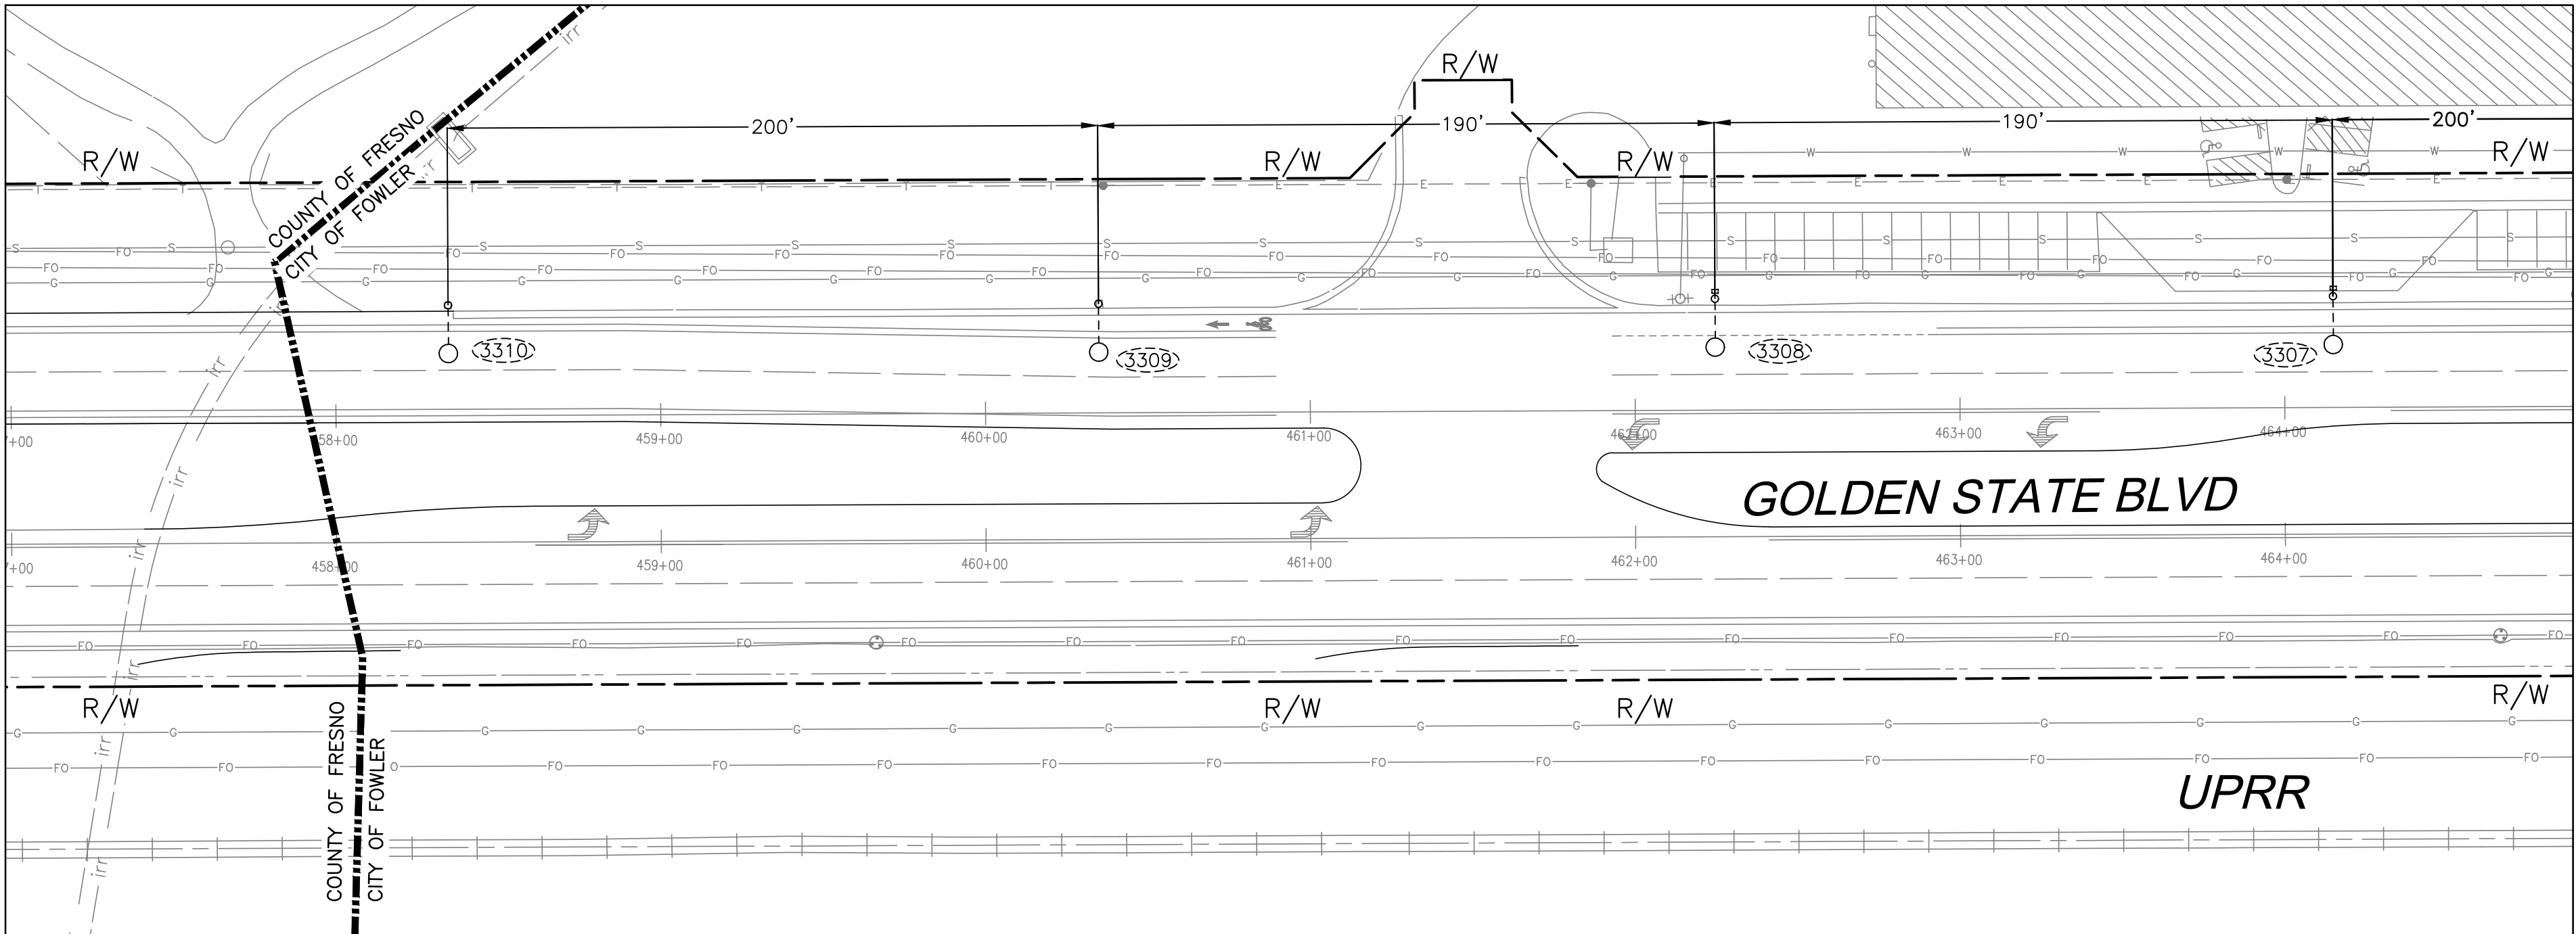


MATCH LINE A - SEE SHEET E-2

DATE		RECORD DRAWING	
DESIGNED:	J. BENAVIDES	04/06/2021	RESIDENT ENGINEER
DRAWN:	C. AYALA-MAGANA	04/06/2021	
CHECKED:	J. RIOS	04/06/2021	

FOR RIGHT OF WAY DATA AND ACCURATE ACCESS DETERMINATION, SEE DOCUMENTS IN THE DEPARTMENT OF PUBLIC WORKS AND PLANNING.


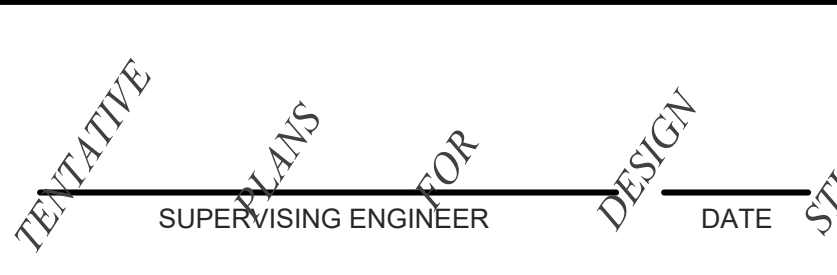


PROJECT	
GOLDEN STATE CORRIDOR - ECONOMIC DEVELOPMENT AND INFRASTRUCTURE IMPROVEMENTS	
FOWLER REGION	

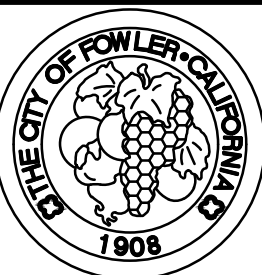


DEPARTMENT OF PUBLIC WORKS AND PLANNING		
GOLDEN STAVE BLVD STREET LIGHT PLAN		
DRAWING NO.	E-1	SHEET NO. 108 TOTAL 142

PATH: Z:\01 Projects\009 Fresno County\009-009 Golden State PS&E\Street Lighting Designs\Design\009-009 Golden State PS&E - Fowler Lighting.dwg
PLOT DATE: 4/6/2021 11:15:47 AM
CAD USER: CAYALA

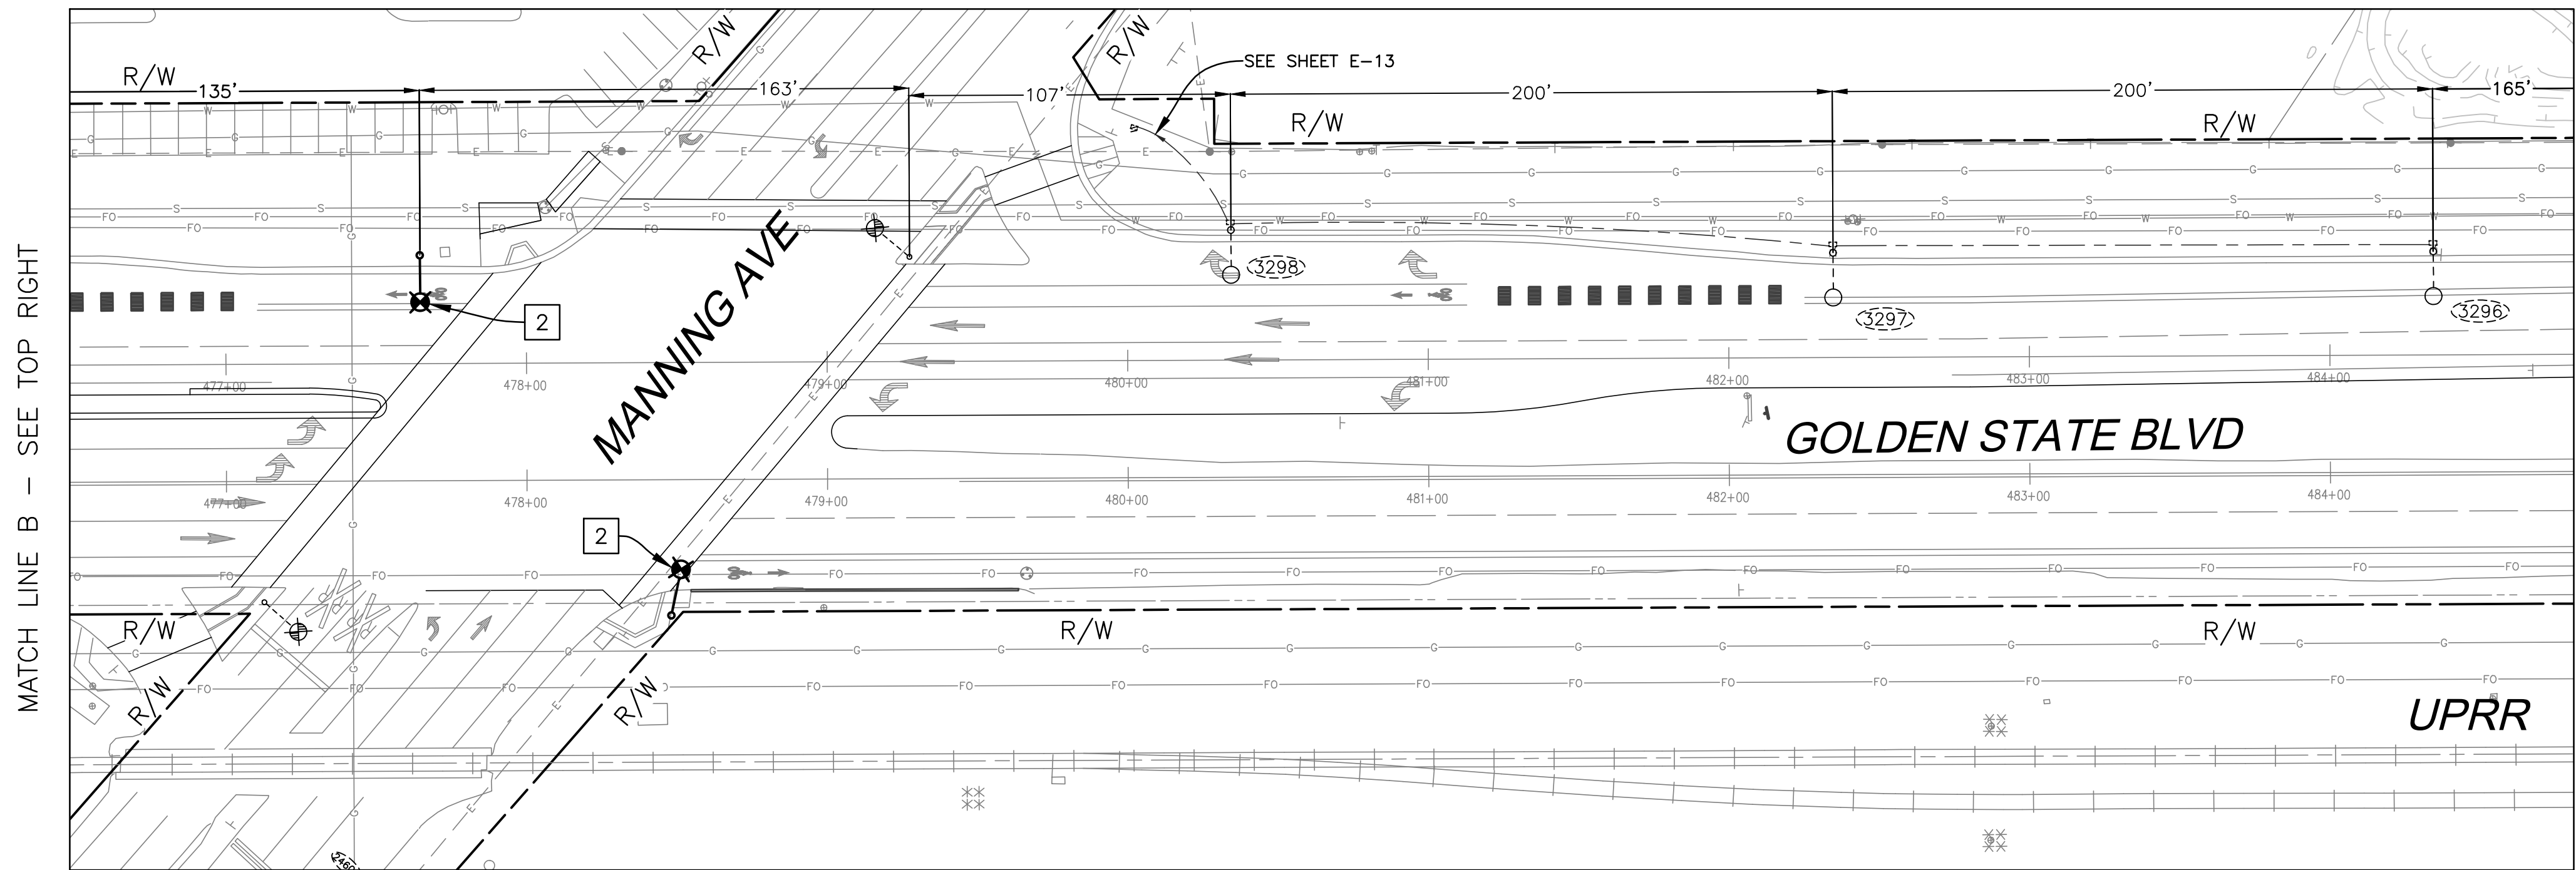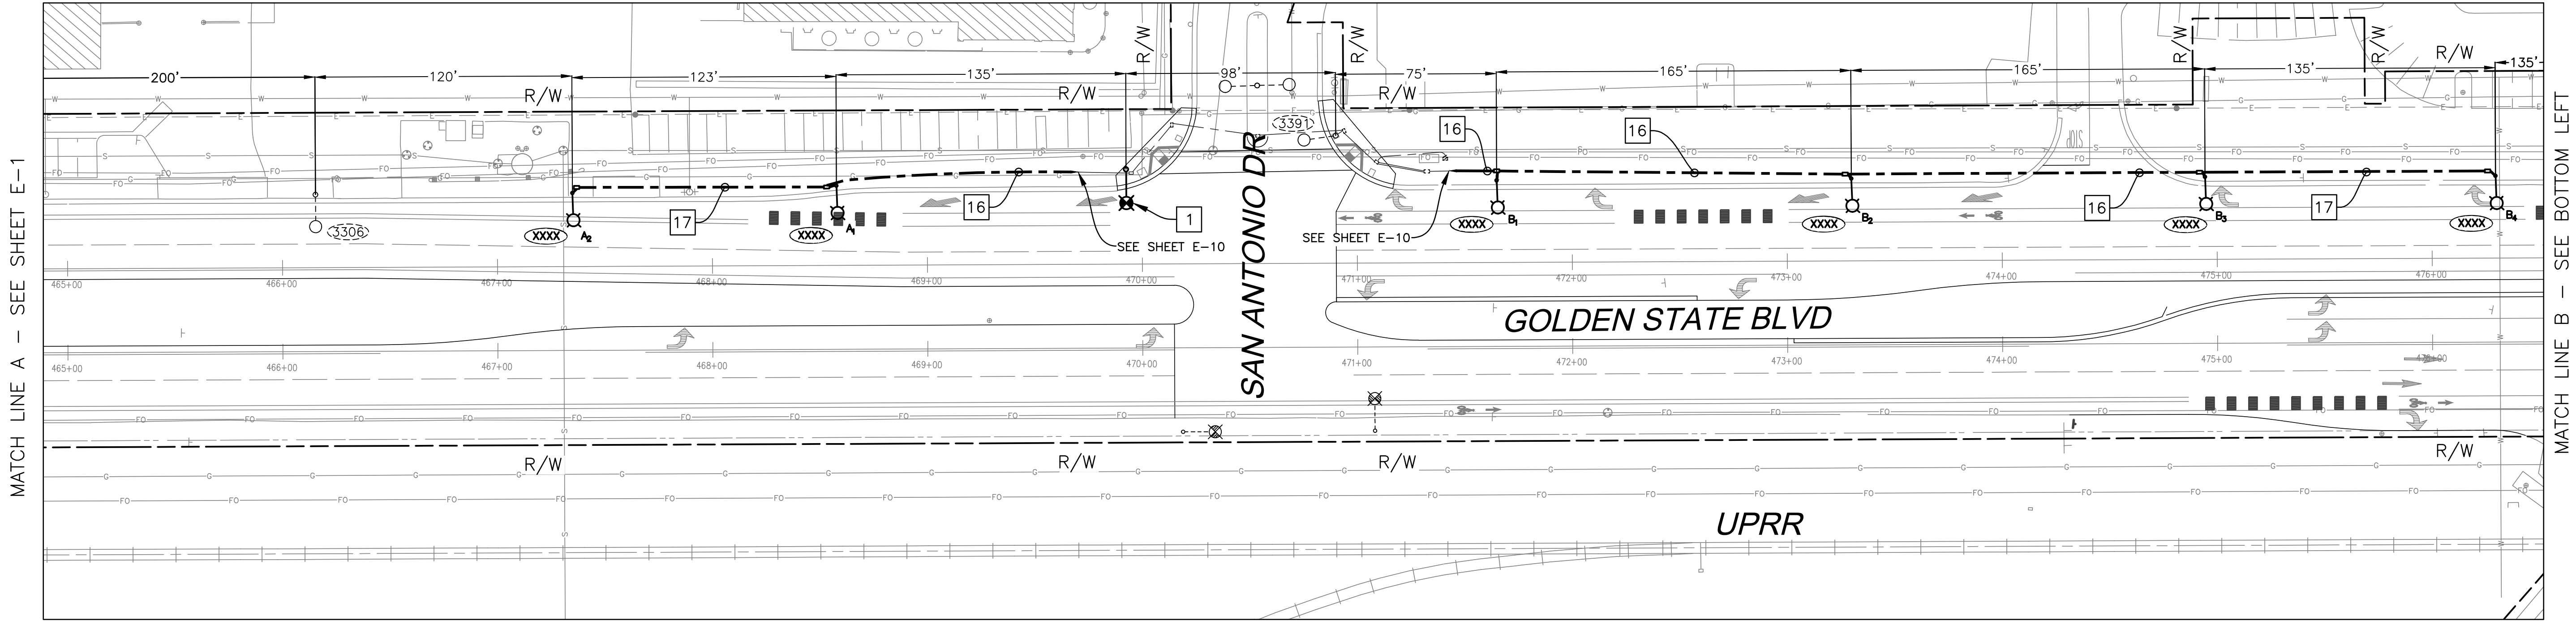

POLE PLACEMENT LOCATION			
POLE	LOCATION		DIRECTION
A ₁	GOLDEN STATE BLVD	STA 468 + 57.80, 36.99' L	SB
A ₂	GOLDEN STATE BLVD	STA 467 + 34.94, 34.14' L	SB
B ₁	GOLDEN STATE BLVD	STA 471 + 64.91, 38.17' L	SB
B ₂	GOLDEN STATE BLVD	STA 473 + 29.90, 38.28' L	SB
B ₃	GOLDEN STATE BLVD	STA 474 + 94.48, 38.38' L	SB
B ₄	GOLDEN STATE BLVD	STA 476 + 29.59, 38.24' L	SB

USA
KNOW WHAT'S BELOW
BEFORE YOU DIG,
CALL
1-800-227-2600

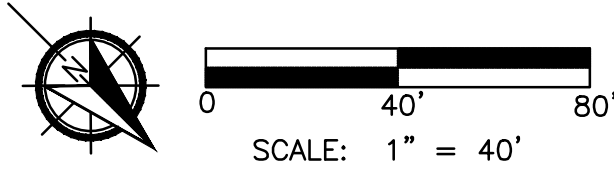


DESIGNED: J. BENAVIDES		DATE: 04/06/2021	RECORD DRAWING	
DRAWN: C. AYALA-MAGANA		DATE: 04/06/2021	RESIDENT ENGINEER	
CHECKED: J. RIOS		DATE: 04/06/2021	DATE	
FOR RIGHT OF WAY DATA AND ACCURATE ACCESS DETERMINATION, SEE DOCUMENTS IN THE DEPARTMENT OF PUBLIC WORKS AND PLANNING.				
TENTATIVE PLANS FOR DESIGN		SUPERVISING ENGINEER		DATE
PROJECT		GOLDEN STATE CORRIDOR - ECONOMIC DEVELOPMENT AND INFRASTRUCTURE IMPROVEMENTS		
FOWLER REGION				
		DEPARTMENT OF PUBLIC WORKS AND PLANNING		
		GOLDEN STATE BLVD STREET LIGHT PLAN		
DRAWING NO. E-2		SHEET NO. 109		TOTAL 142


PATH: Z:\01 Projects\009 Fresno County\009-009 Golden State PS&E\Street Lighting Designs\Golden State PS&E - Fowler Lighting.dwg PLOT DATE: 4/6/2021 11:16:06 AM CAD USER: CAYALA

MATCH LINE C - SEE SHEET E-2

BREAK LINE D - SEE TOP RIGHT

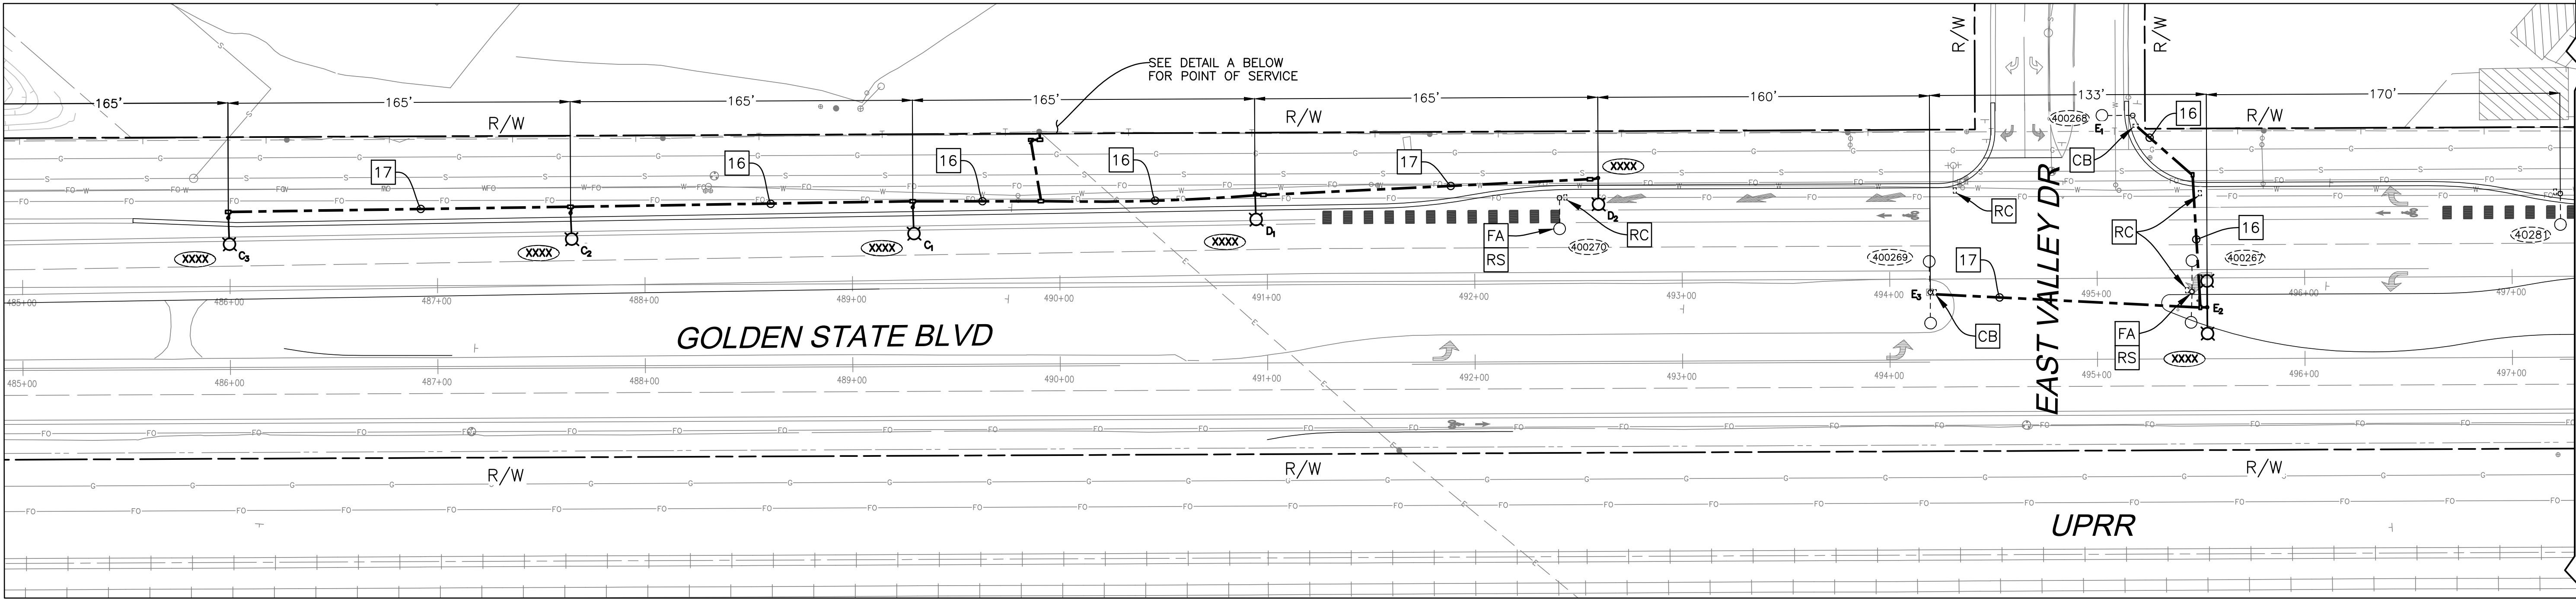


BREAK LINE D - SEE BOTTOM LEFT

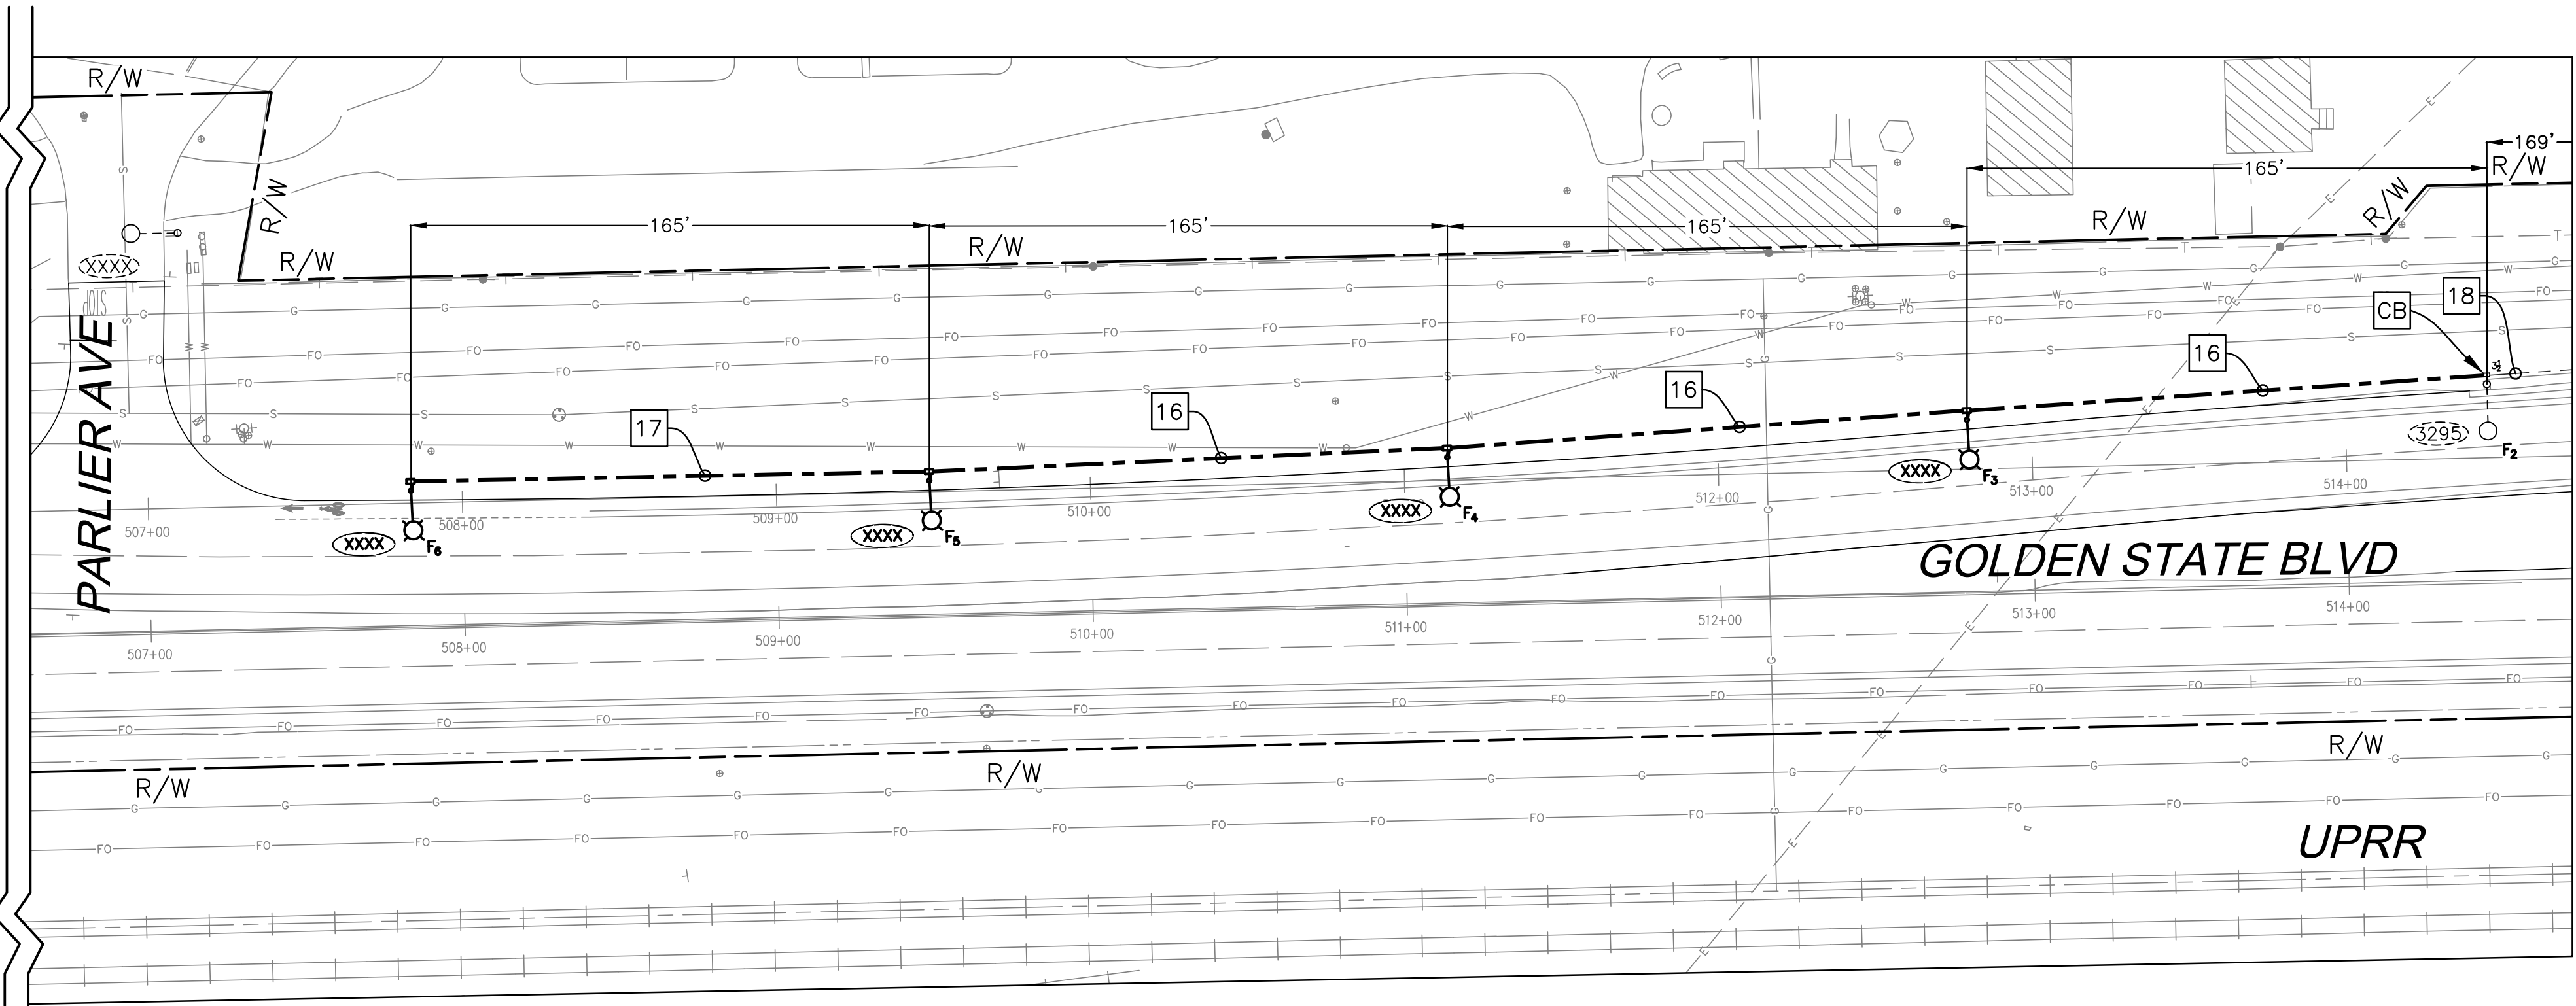


MATCH LINE E - SEE SHEET E-4

POLE PLACEMENT LOCATION			
POLE	LOCATION		DIRECTION
C ₁	GOLDEN STATE BLVD	STA 489 + 29.26, 36.70' L	SB
C ₂	GOLDEN STATE BLVD	STA 487 + 64.27, 34.74' L	SB
C ₃	GOLDEN STATE BLVD	STA 485 + 99.30, 33.01' L	SB
D ₁	GOLDEN STATE BLVD	STA 490 + 94.22, 42.76' L	SB
D ₂	GOLDEN STATE BLVD	STA 492 + 59.61, 49.41' L	SB
E ₂	GOLDEN STATE BLVD	STA 495 + 52.94, 14.18' R	SB
F ₃	GOLDEN STATE BLVD	STA 512 + 79.51, 15.68' L	SB
F ₄	GOLDEN STATE BLVD	STA 511 + 13.83, 7.39' L	SB
F ₅	GOLDEN STATE BLVD	STA 509 + 48.77, 3.48' X	SB
F ₆	GOLDEN STATE BLVD	STA 507 + 83.67, 3.92' X	SB

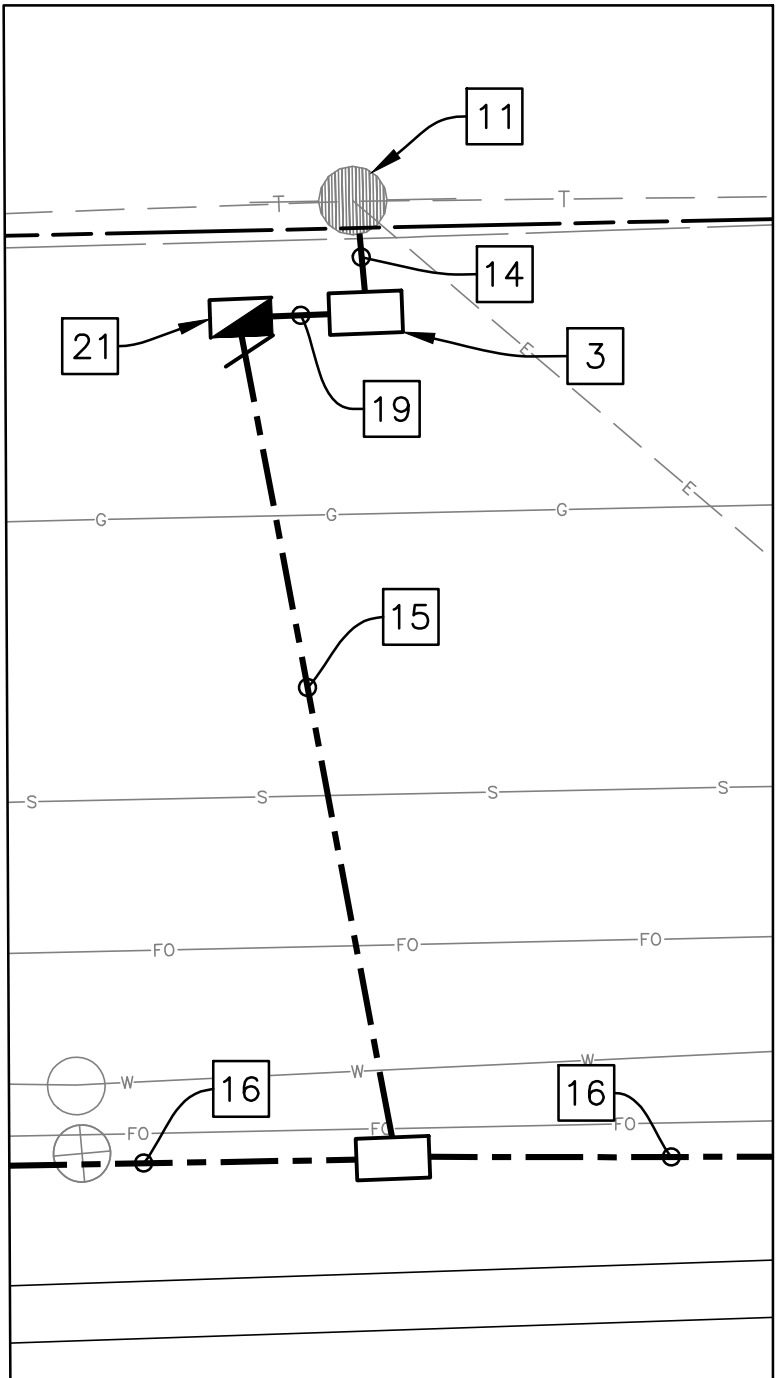


POINT OF SERVICE — DETAIL A
NO SCALE



USA
KNOW WHAT'S BELOW
BEFORE YOU DIG,
CALL
1-800-227-2600

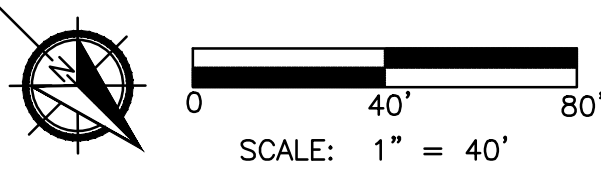


ALL EXISTING STREET LIGHTING PULL BOXES ARE CONCRETE FILLED AND CITY HAS INDICATED THAT THEY DO NOT HAVE ANY PLANS FOR THESE LIGHTING CURCUIITS. THEREFORE (ABSENT THE REMOVAL OF THE CONCRETE INSIDE THESE PULL BOXES) THE ONLY WAY TO DETERMINE THE EXISTING LAYOUT OF THE LIGHTING CONDUIT RUNS AND WIRING CIRCUIT IS TO HAVE A JOINT FIELD MEETING WITH CITY ELECTRICAL MAINTENANCE STAFF.

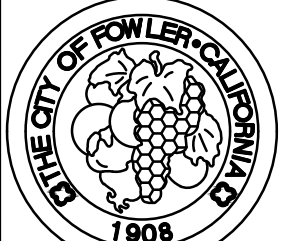DESIGNED: J. BENAVIDES		DATE: 04/06/2021	RECORD DRAWING	
DRAWN: C. AYALA-MAGANA		DATE: 04/06/2021	RESIDENT ENGINEER	
CHECKED: J. RIOS		DATE: 04/06/2021	DATE	
FOR RIGHT OF WAY DATA AND ACCURATE ACCESS DETERMINATION, SEE DOCUMENTS IN THE DEPARTMENT OF PUBLIC WORKS AND PLANNING.				
 CALL BEFORE YOU DIG		 516 W. SHAW AVE., STE. 103 FRESNO, CA 93704 PHONE: (559) 570-8991 EMAIL: info@JLBtraffic.com		
TENTATIVE PLANS FOR DESIGN		SUPERVISING ENGINEER		DATE
PROJECT: GOLDEN STATE CORRIDOR - ECONOMIC DEVELOPMENT AND INFRASTRUCTURE IMPROVEMENTS				
FOWLER REGION				
		DEPARTMENT OF PUBLIC WORKS AND PLANNING		
GOLDEN STAVE BLVD STREET LIGHT PLAN				
DRAWING NO. E-3		SHEET NO. 110		TOTAL 142

PATH: Z:\01 Projects\009 Fresno County\009-009 Golden State PS&E\Street Lighting Designs\Design\Fowler\009-009 Golden State PS&E - Fowler Lighting.dwg
PLOT DATE: 4/6/2021 11:17:45 AM
CAD USER: CAYALA

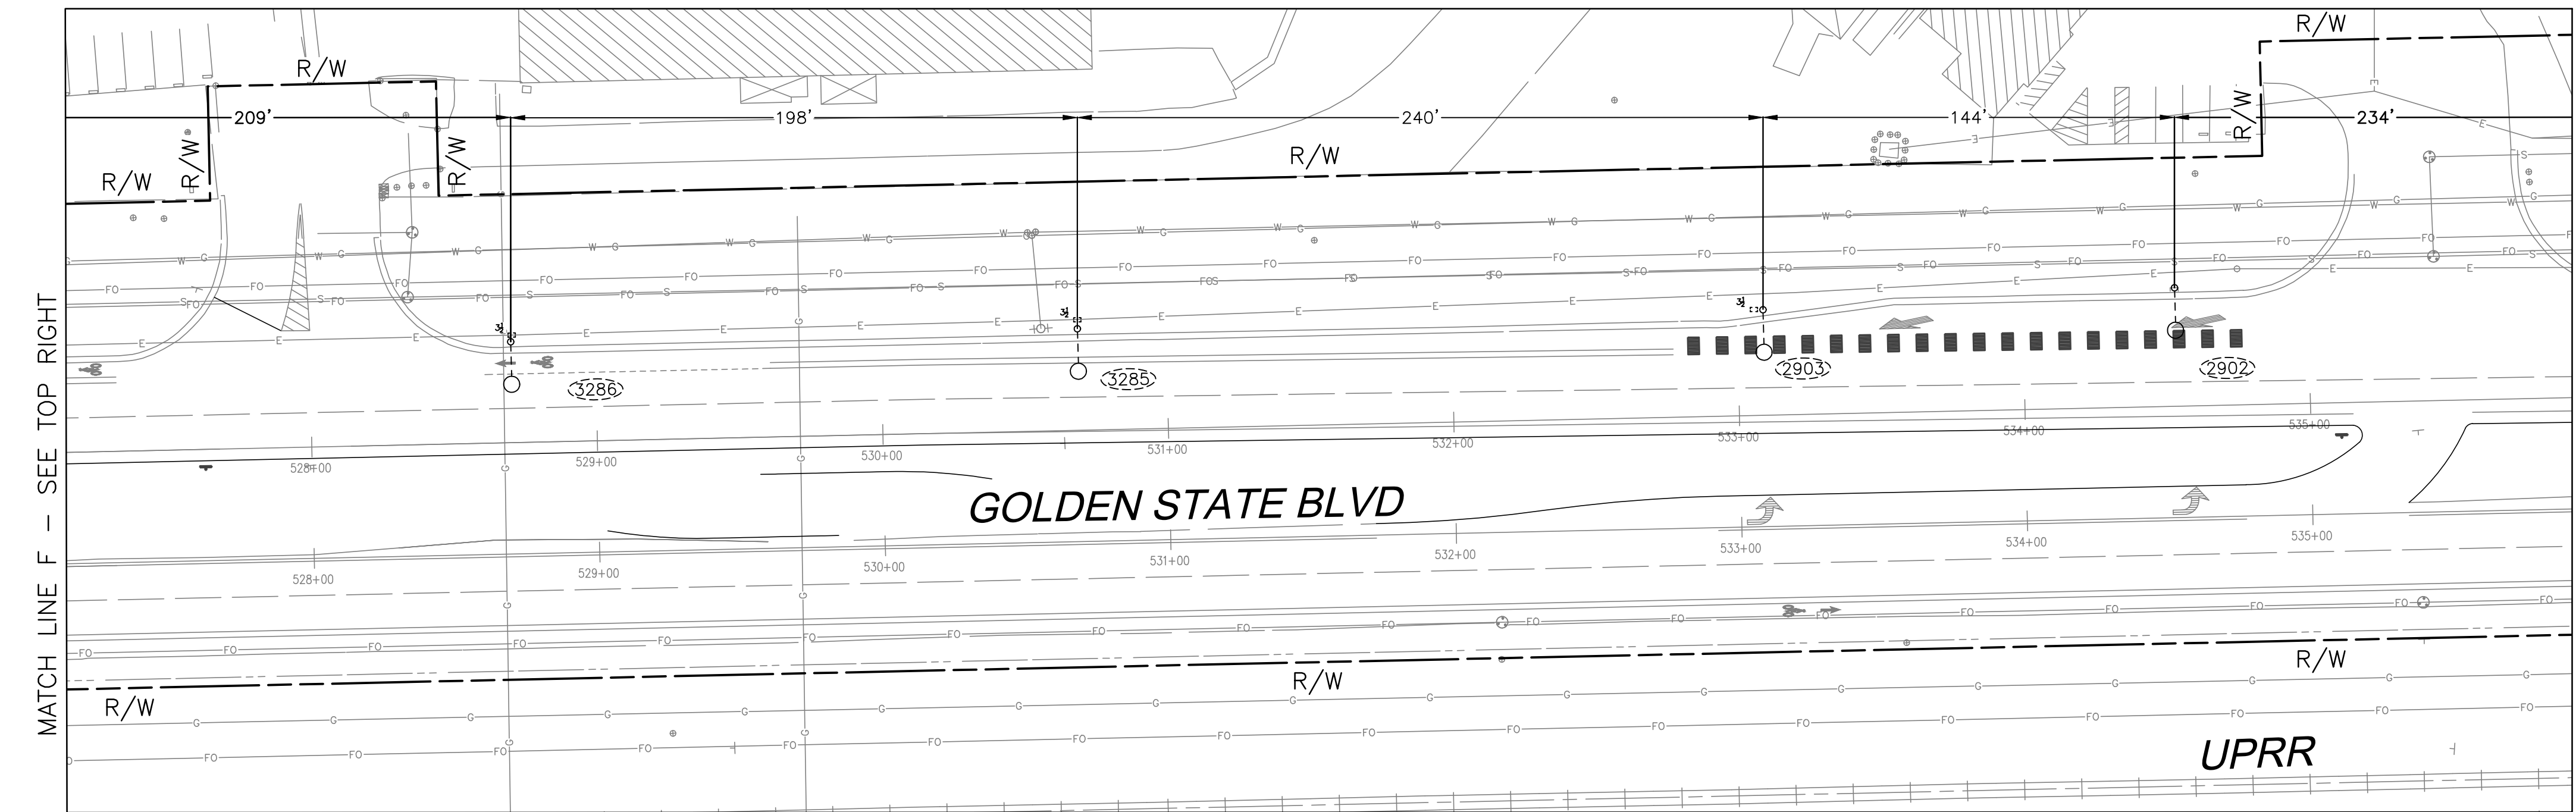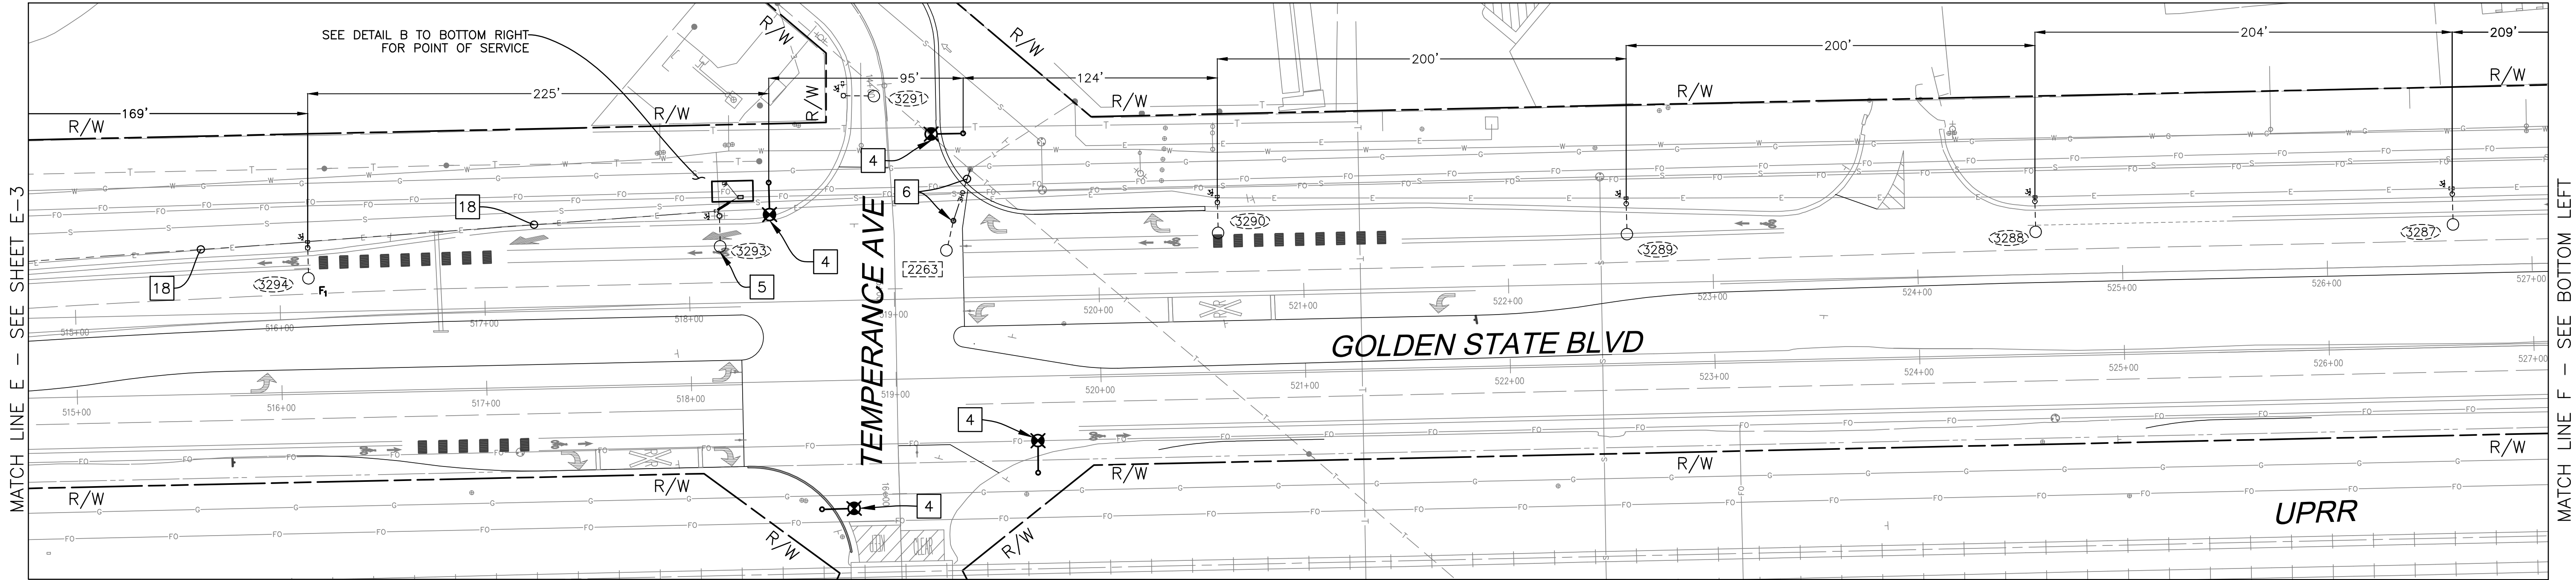


MATCH LINE G - SEE SHEET E-5

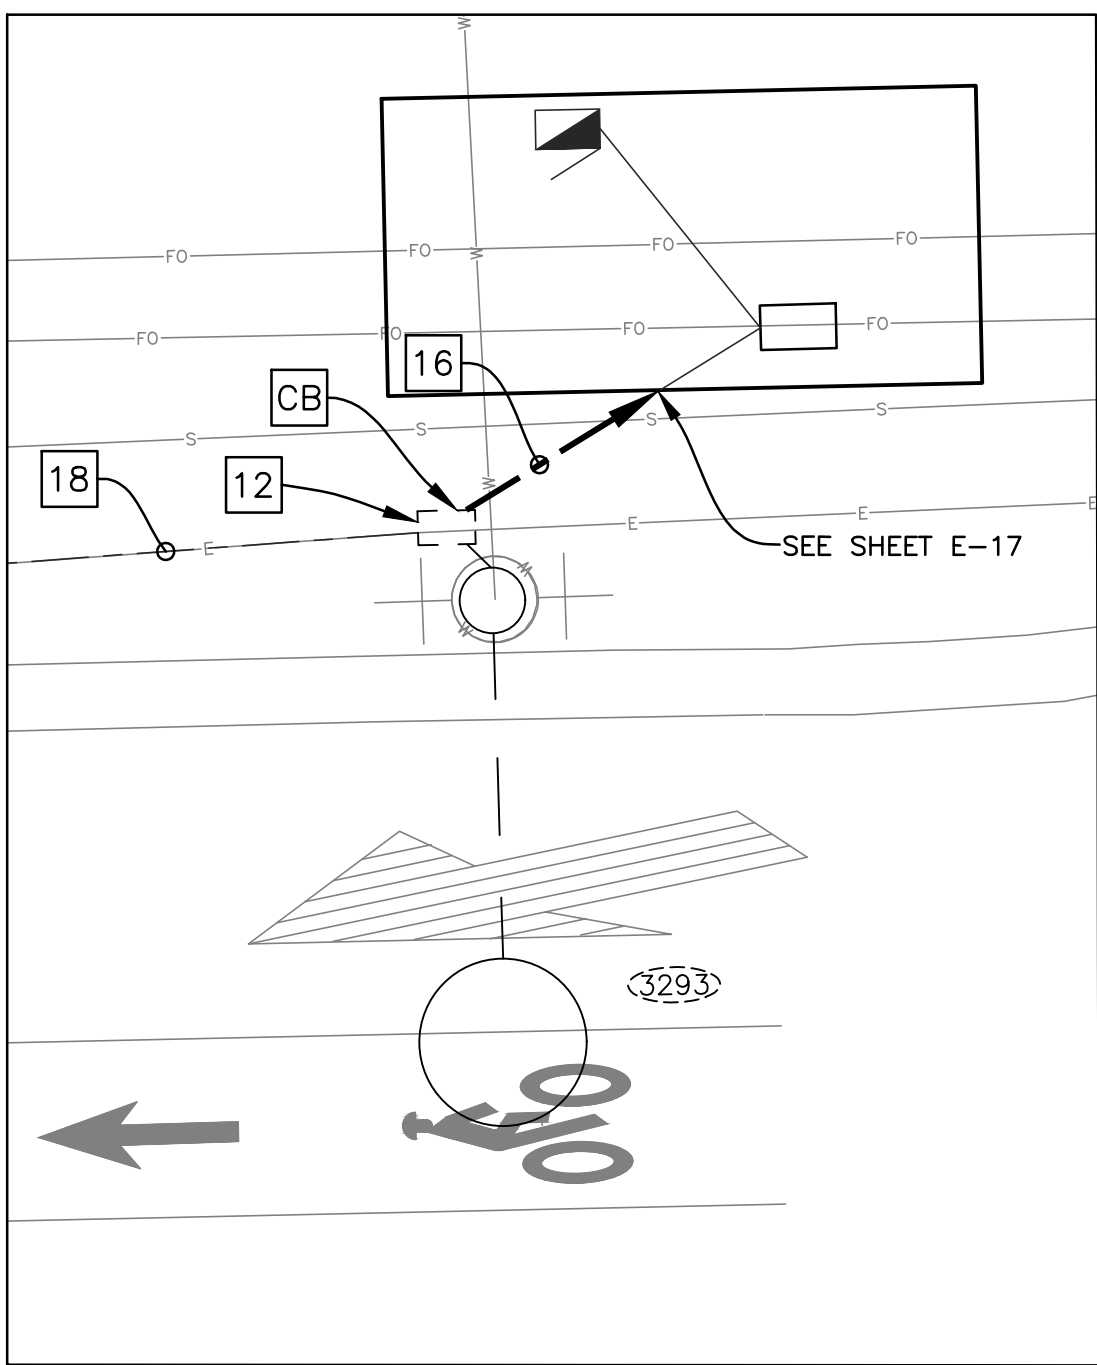



POINT OF SERVICE - DETAIL B
NO SCALE

ALL EXISTING STREET LIGHTING PULL BOXES ARE CONCRETE FILLED AND CITY HAS INDICATED THAT THEY DO NOT HAVE ANY PLANS FOR THESE LIGHTING CURCUIITS. THEREFORE (ABSENT THE REMOVAL OF THE CONCRETE INSIDE THESE PULL BOXES) THE ONLY WAY TO DETERMINE THE EXISTING LAYOUT OF THE LIGHTING CONDUIT RUNS AND WIRING CIRCUIT IS TO HAVE A JOINT FIELD MEETING WITH CITY ELECTRICAL MAINTENANCE STAFF.

USA
KNOW WHAT'S BELOW
BEFORE YOU DIG,
CALL
1-800-227-2600

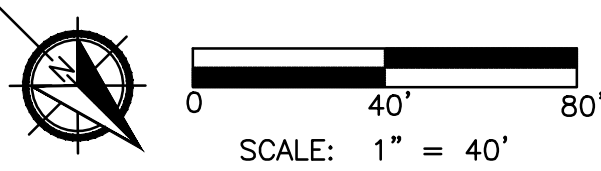

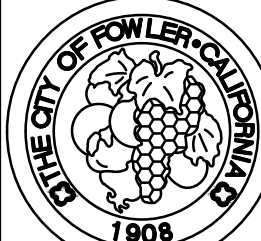DESIGNED: J. BENAVIDES		DATE	RECORD DRAWING	
DRAWN: C. AYALA-MAGANA		04/06/2021	RESIDENT ENGINEER	DATE
CHECKED: J. RIOS		04/06/2021		
FOR RIGHT OF WAY DATA AND ACCURATE ACCESS DETERMINATION, SEE DOCUMENTS IN THE DEPARTMENT OF PUBLIC WORKS AND PLANNING.				
 CALL BEFORE YOU DIG		 516 W. SHAW AVE., STE. 103 FRESNO, CA 93704 PHONE: (559) 570-8991 EMAIL: info@JLBtraffic.com		
TENTATIVE PLANS FOR DESIGN		SUPERVISING ENGINEER		DATE
PROJECT		GOLDEN STATE CORRIDOR - ECONOMIC DEVELOPMENT AND INFRASTRUCTURE IMPROVEMENTS		FOWLER REGION
		DEPARTMENT OF PUBLIC WORKS AND PLANNING		GOLDEN STAVE BLVD STREET LIGHT PLAN
DRAWING NO. E-4		SHEET NO. 111		TOTAL 142

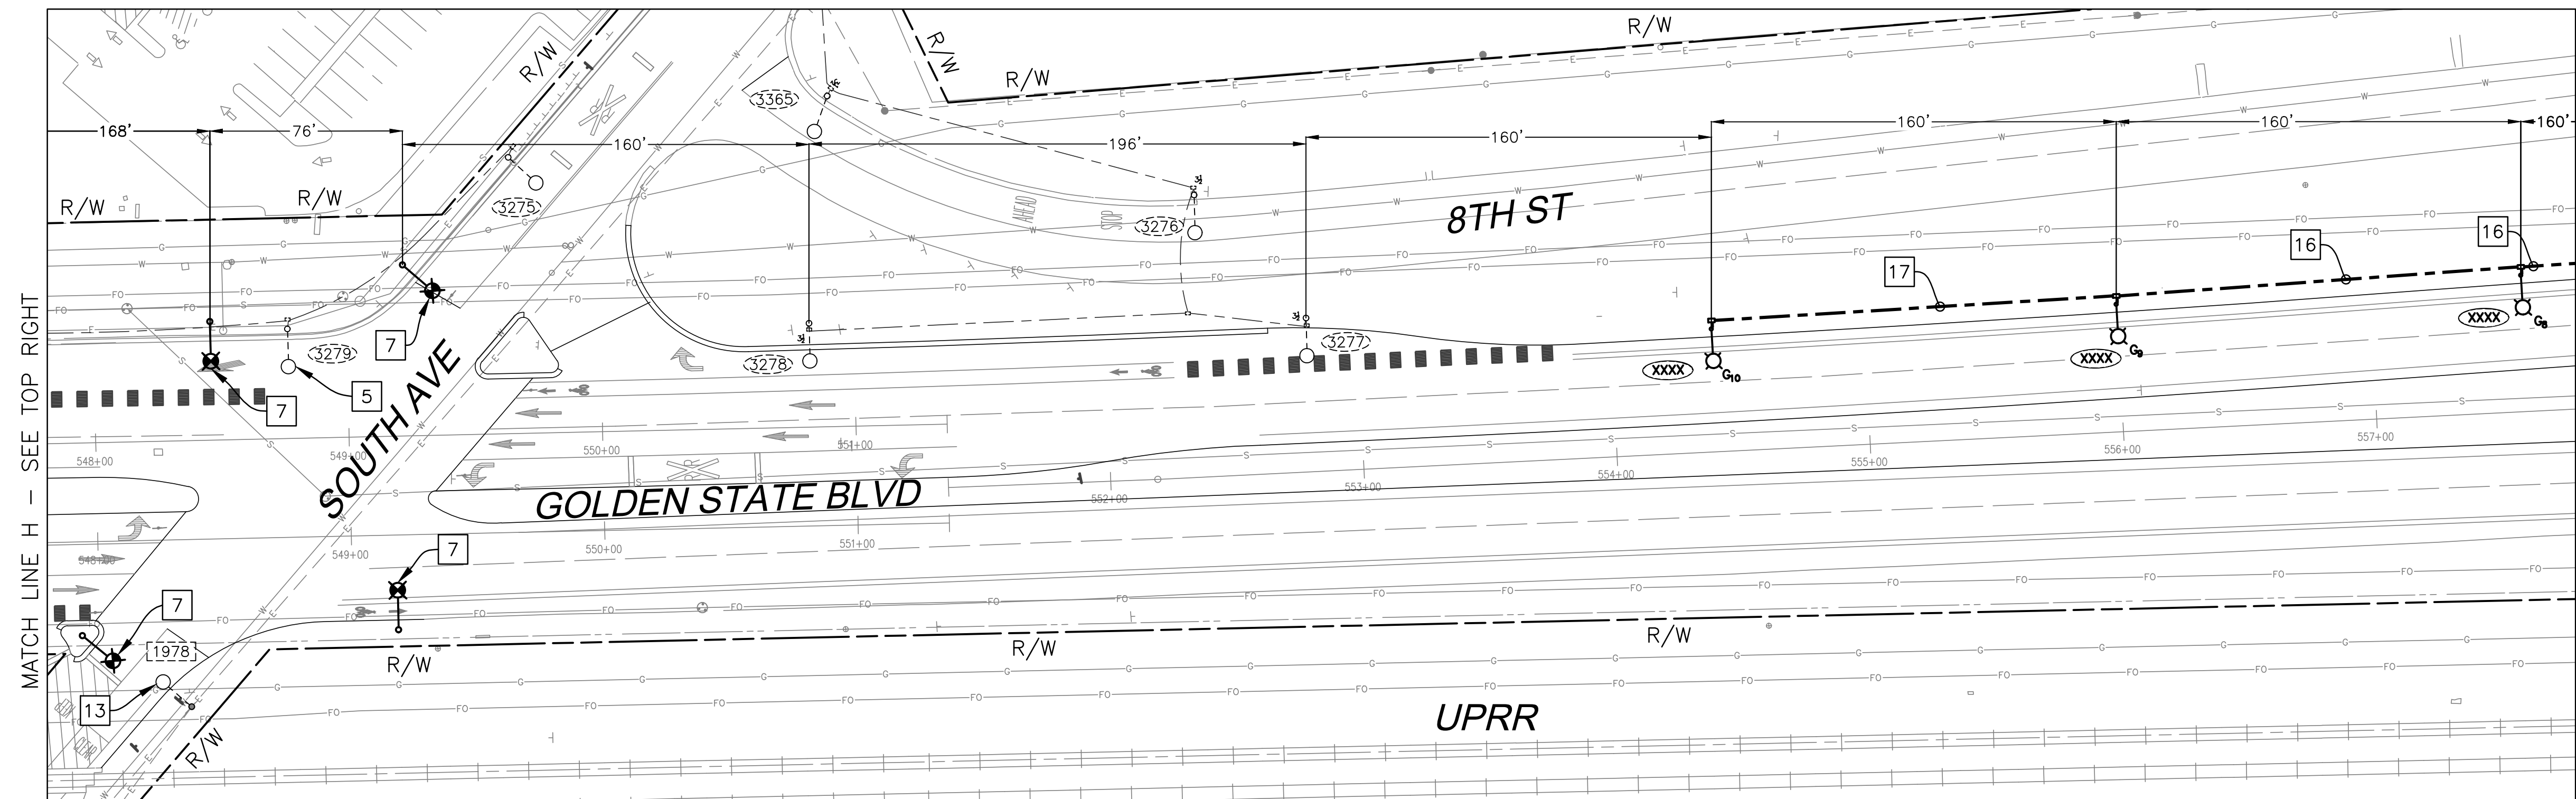

POLE PLACEMENT LOCATION			
POLE	LOCATION		DIRECTION
G ₈	GOLDEN STATE BLVD	STA 557 + 59.63, 53.81' L	SB
G ₉	GOLDEN STATE BLVD	STA 555 + 99.63, 50.34' L	SB
G ₁₀	GOLDEN STATE BLVD	STA 554 + 39.63, 48.54' L	SB



811
CALL BEFORE YOU DIG

JLB TRAFFIC
ENGINEERING, INC.

516 W. SHAW AVE., STE. 10
FRESNO, CA 93704
PHONE: (559) 570-8991
EMAIL: info@JLBtraffic.com

TENTATIVE PLANS FOR DESIGN STUDY

SUPERVISING ENGINEER DATE

PROJECT
GOLDEN STATE CORRIDOR - ECONOMIC DEVELOPMENT AND INFRASTRUCTURE IMPROVEMENTS
FOWLER REGION

DEPARTMENT OF PUBLIC WORKS AND PLANNING

**GOLDEN STAVE BLVD
STREET LIGHT PLAN**



DRAWING NO.	E-5	SHEET NO.	112	TOTAL	142
-------------	-----	-----------	-----	-------	-----

PATH: Z:\01 Projects\009 Fresno County\009-009 Golden State PS&E\Street Lighting Designs\Golden State PS&E - Fowler Lighting.dwg
PLOT DATE: 4/6/2021 11:38:51 AM
CAD USER: CAYALA

MATCH LINE K - SEE SHEET E-6


MATCH LINE L - SEE TOP RIGHT

MATCH LINE L - SEE BOTTOM LEFT

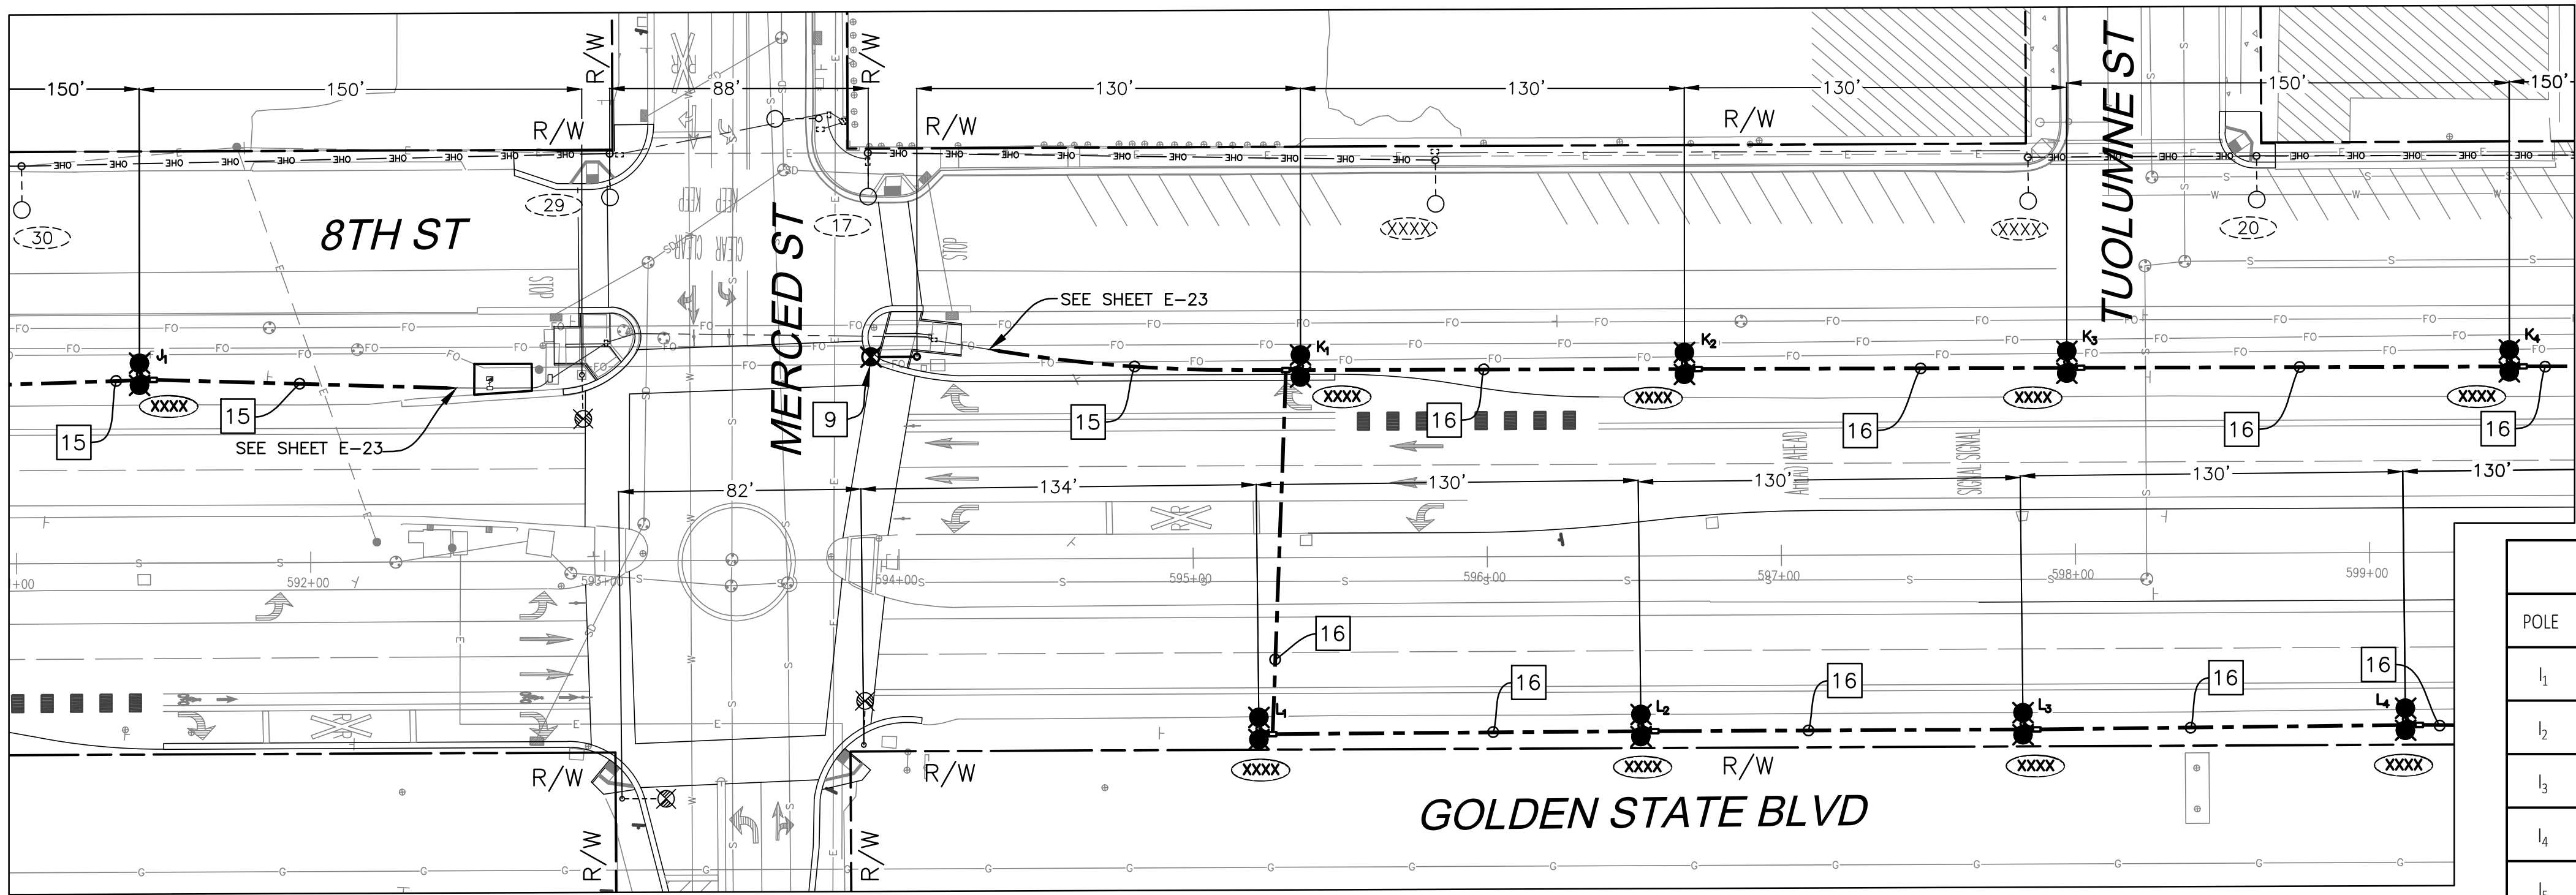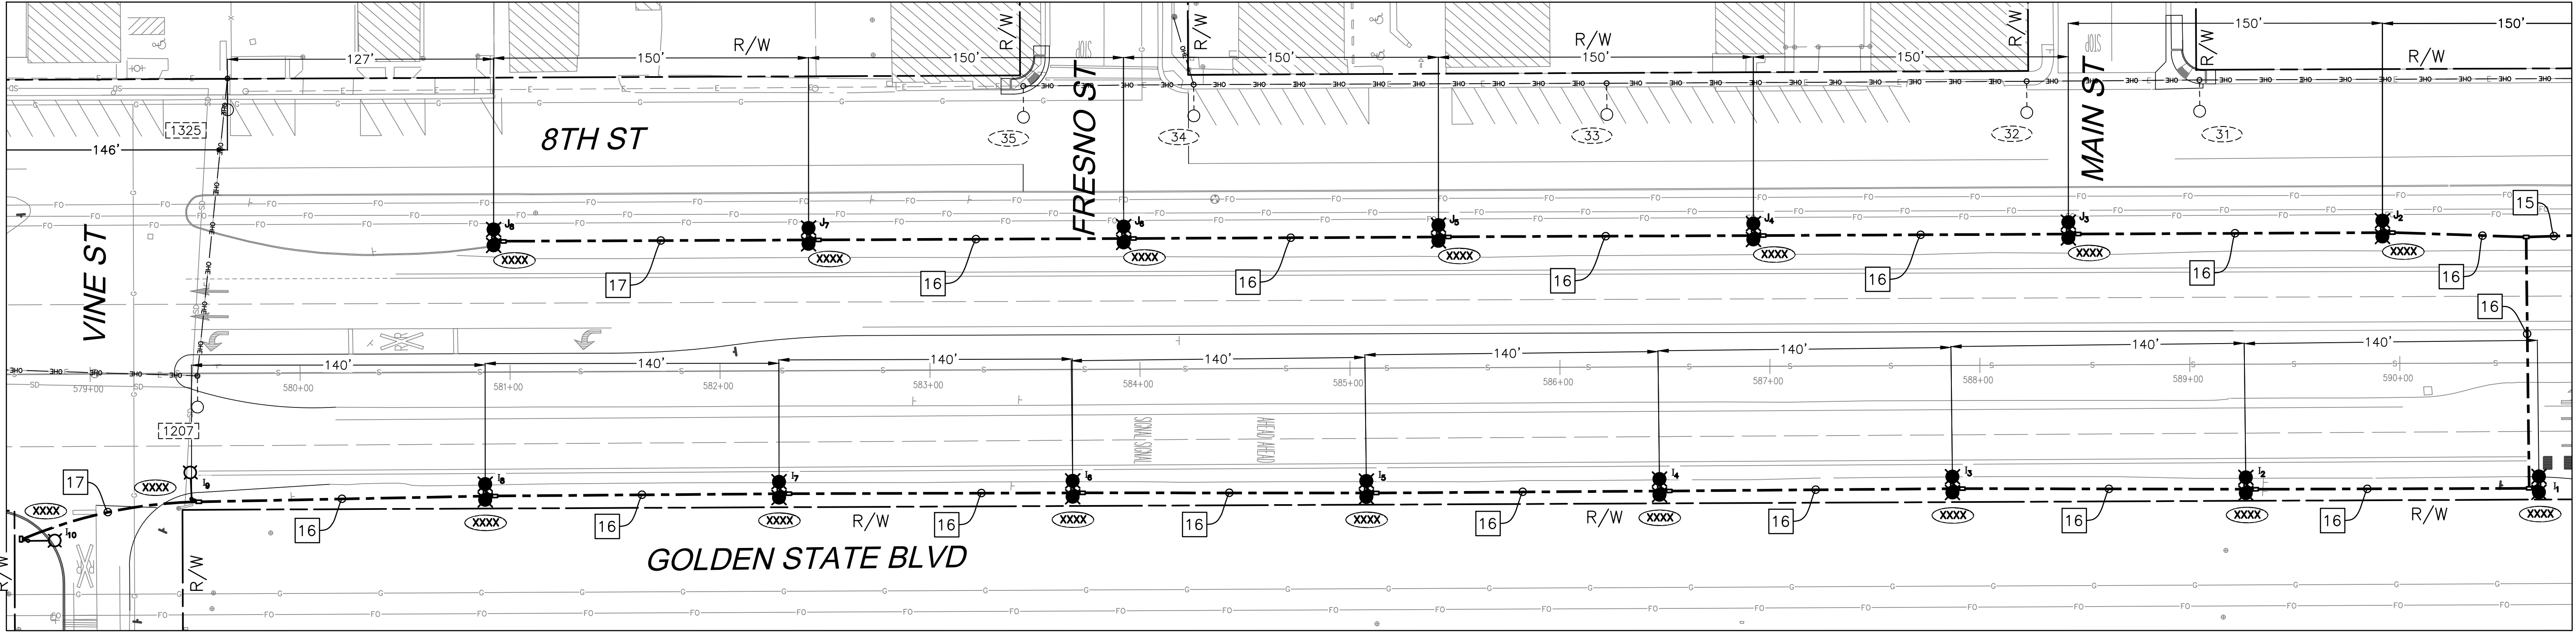

MATCH LINE M - SEE SHEET E-8

USA
KNOW WHAT'S BELOW
BEFORE YOU DIG,
CALL
1-800-227-2600

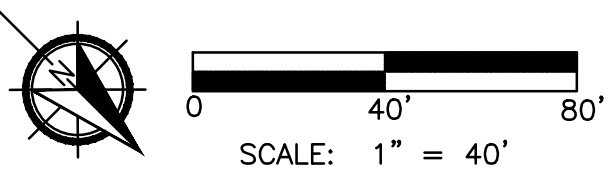

POLE PLACEMENT LOCATION			
POLE	LOCATION		DIRECTION
I ₁	GOLDEN STATE BLVD	STA 590 + 66.00, 57.85'	R NB
I ₂	GOLDEN STATE BLVD	STA 589 + 26.39, 57.63'	R NB
I ₃	GOLDEN STATE BLVD	STA 587 + 86.68, 56.66'	R NB
I ₄	GOLDEN STATE BLVD	STA 586 + 47.12, 57.11'	R NB
I ₅	GOLDEN STATE BLVD	STA 585 + 7.54, 57.42'	R NB
I ₆	GOLDEN STATE BLVD	STA 583 + 67.66, 56.69'	R NB
I ₇	GOLDEN STATE BLVD	STA 582 + 27.84, 56.43'	R NB
I ₈	GOLDEN STATE BLVD	STA 580 + 87.90, 56.85'	R NB

POLE PLACEMENT LOCATION			
POLE	LOCATION		DIRECTION
I ₉	GOLDEN STATE BLVD	STA 579 + 48.04, 59.55'	R NB
I ₁₀	GOLDEN STATE BLVD	STA 578 + 70.13, 79.10'	R NB
J ₁	GOLDEN STATE BLVD	STA 591 + 42.05, 64.19'	L SB
J ₂	GOLDEN STATE BLVD	STA 589 + 92.02, 64.20'	L SB
J ₃	GOLDEN STATE BLVD	STA 588 + 42.42, 64.21'	L SB
J ₄	GOLDEN STATE BLVD	STA 586 + 92.45, 64.22'	L SB
J ₅	GOLDEN STATE BLVD	STA 585 + 42.45, 64.23'	L SB
J ₆	GOLDEN STATE BLVD	STA 583 + 92.52, 64.24'	L SB
J ₇	GOLDEN STATE BLVD	STA 582 + 42.47, 64.25'	L SB
J ₈	GOLDEN STATE BLVD	STA 580 + 92.47, 64.26'	L SB
K ₁	GOLDEN STATE BLVD	STA 595 + 36.84, 65.14'	L SB
K ₂	GOLDEN STATE BLVD	STA 596 + 67.33, 65.42'	L SB
K ₃	GOLDEN STATE BLVD	STA 597 + 97.35, 65.21'	L SB
K ₄	GOLDEN STATE BLVD	STA 599 + 47.80, 64.97'	L SB
L ₁	GOLDEN STATE BLVD	STA 595 + 22.11, 58.03'	R NB
L ₂	GOLDEN STATE BLVD	STA 596 + 51.99, 57.65'	R NB
L ₃	GOLDEN STATE BLVD	STA 597 + 81.87, 57.66'	R NB
L ₄	GOLDEN STATE BLVD	STA 599 + 11.92, 56.74'	R NB

		DATE	RECORD DRAWING	
DESIGNED:	J. BENAVIDES	04/06/2021	RESIDENT ENGINEER	DATE
DRAWN:	C. AYALA-MAGANA	04/06/2021		
CHECKED:	J. RIOS	04/06/2021		
FOR RIGHT OF WAY DATA AND ACCURATE ACCESS DETERMINATION, SEE DOCUMENTS IN THE DEPARTMENT OF PUBLIC WORKS AND PLANNING.				

516 W. SHAW AVE., STE. 103
FRESNO, CA 93704
PHONE: (559) 570-8991
EMAIL: info@JLBtraffic.com

TENTATIVE PLANS FOR DESIGN

SUPERVISING ENGINEER

DATE

PROJECT

GOLDEN STATE CORRIDOR - ECONOMIC DEVELOPMENT AND INFRASTRUCTURE IMPROVEMENTS



FOWLER REGION

DEPARTMENT OF PUBLIC WORKS AND PLANNING

GOLDEN STAVE BLVD STREET LIGHT PLAN

DRAWING NO. E-7 SHEET NO. 114 TOTAL 142


PATH: Z:\01 Projects\009 Fresno County\009-009 Golden State PS&E\Street Lighting Designs\Design\009-009 Golden State PS&E - Fowler Lighting.dwg
PLOT DATE: 4/6/2021 11:39:18 AM
CAD USER: CAYALA

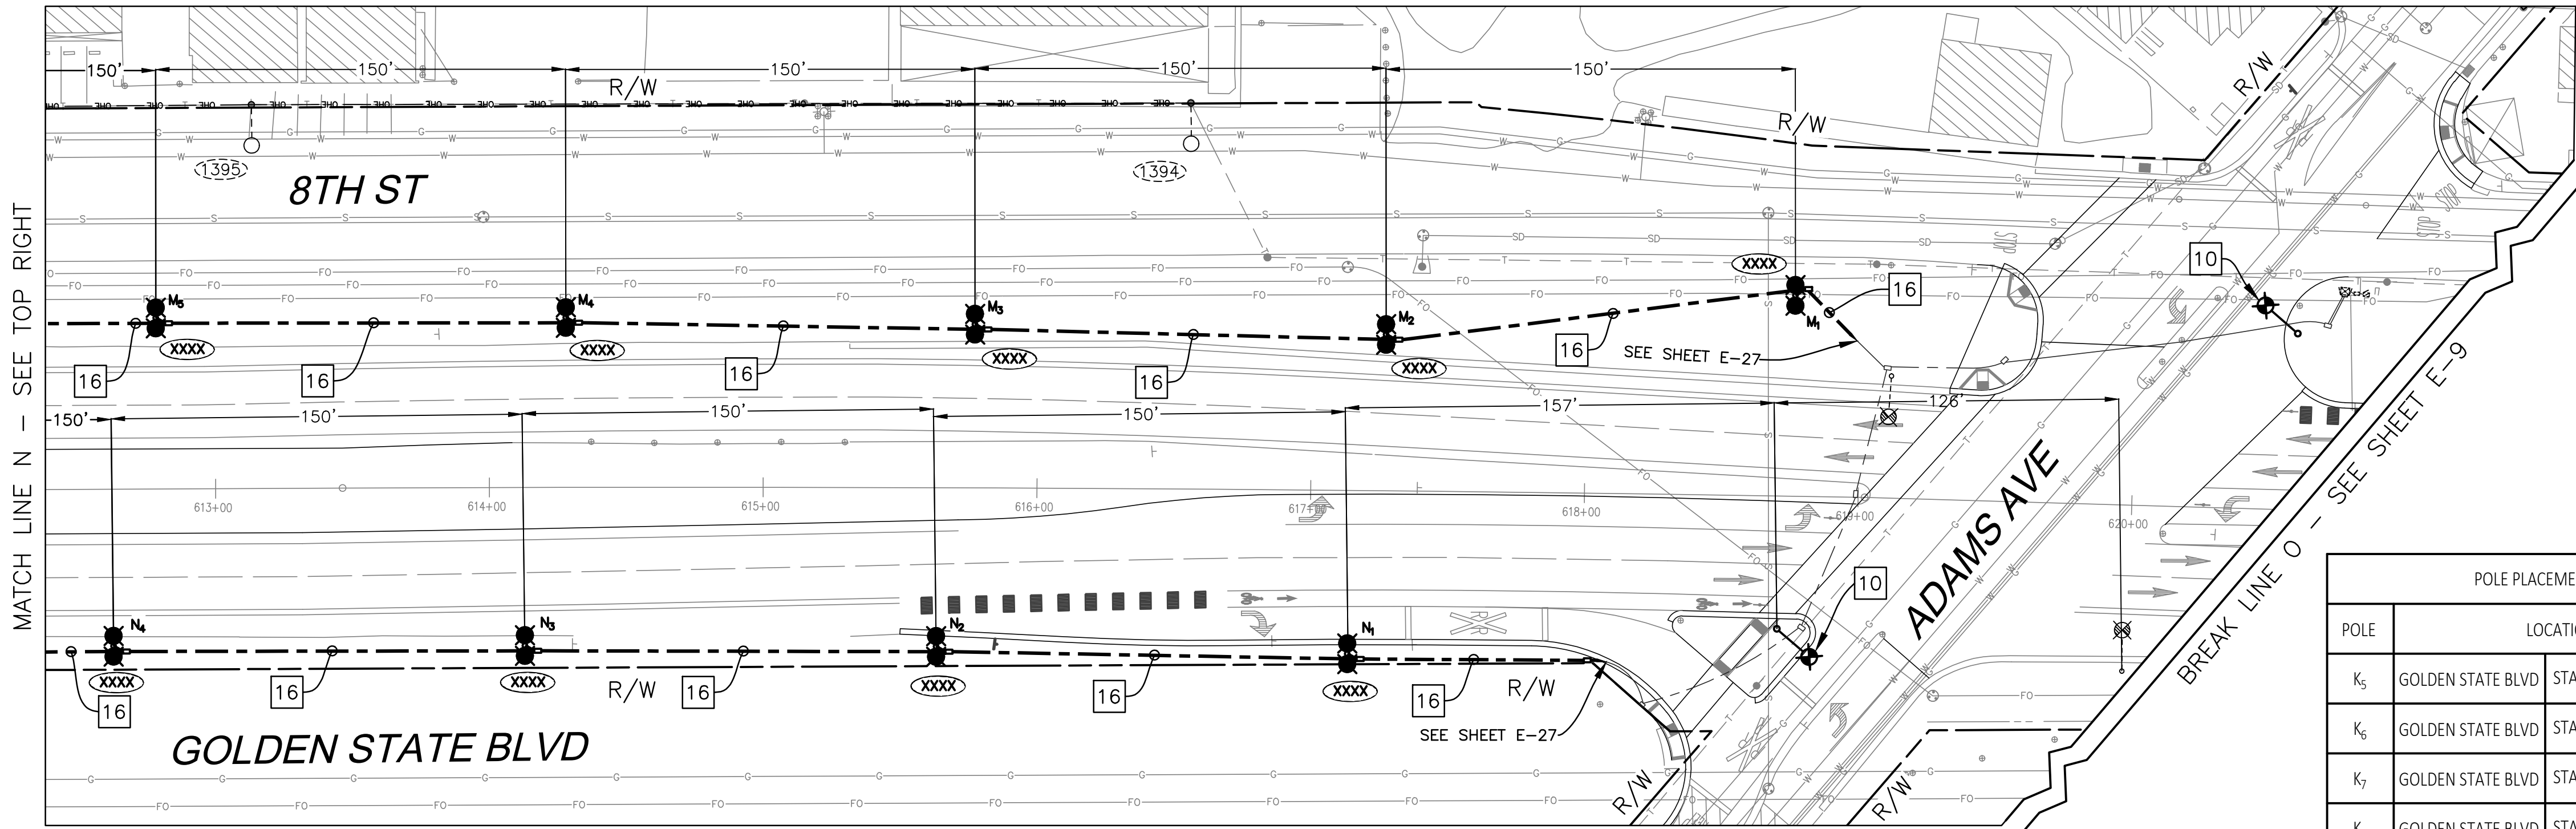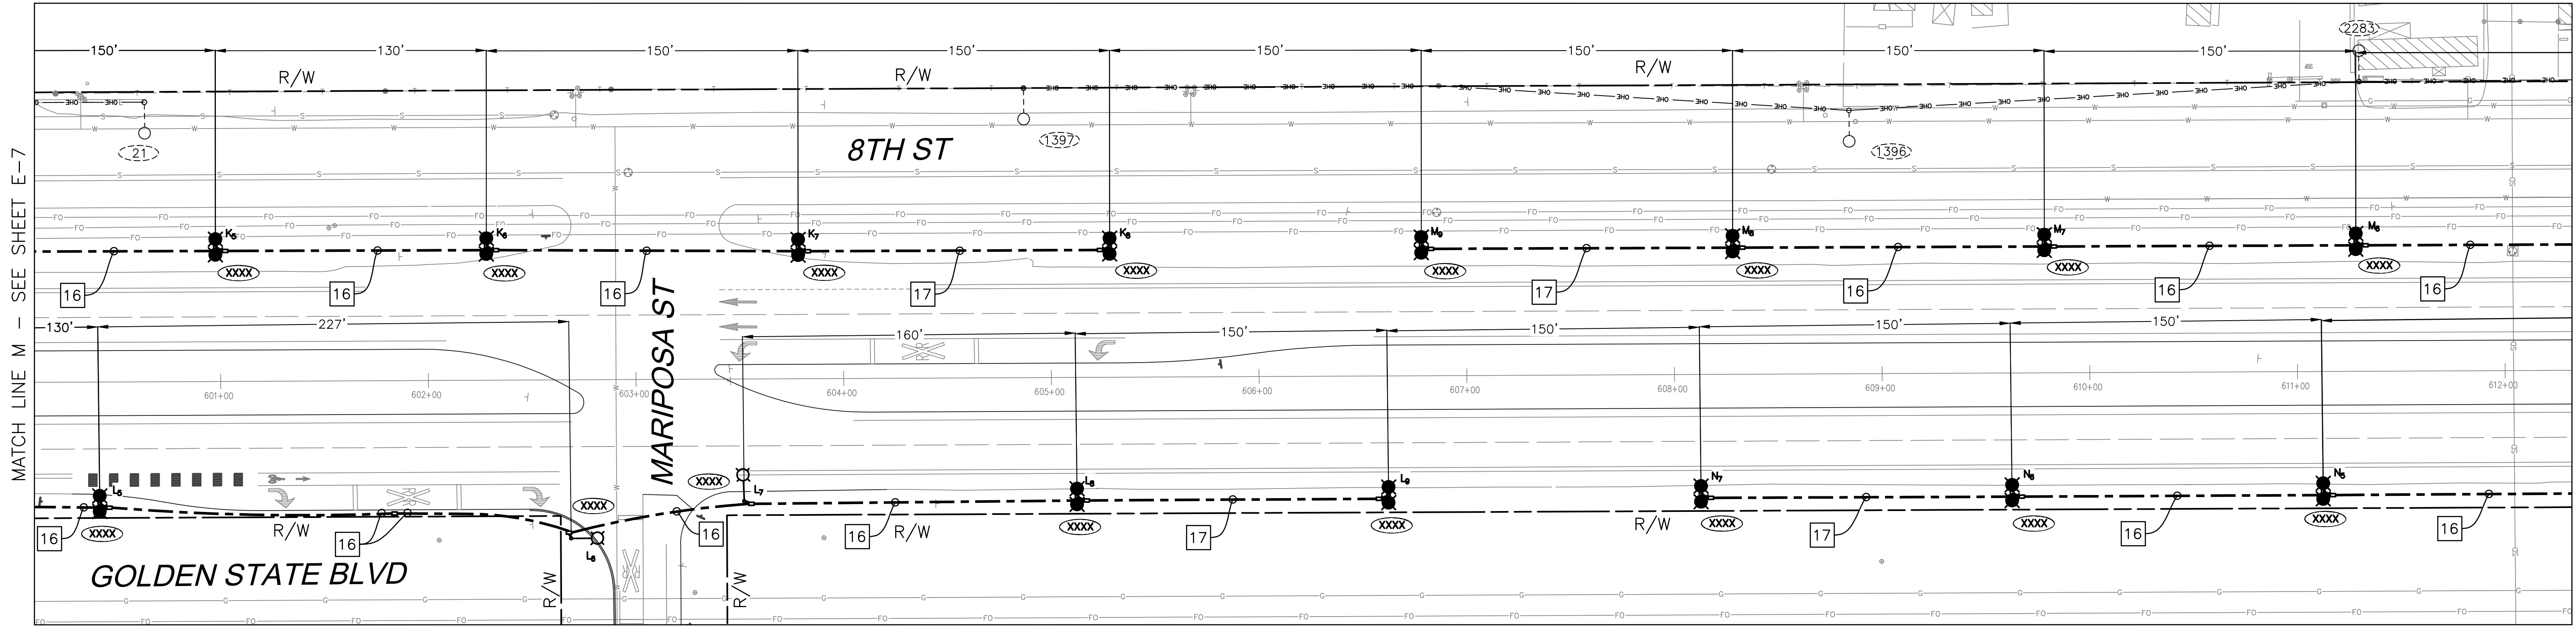

POLE PLACEMENT LOCATION			
POLE	LOCATION		DIRECTION
L ₈	GOLDEN STATE BLVD	STA 605 + 12.07, 57.34' R	NB
L ₉	GOLDEN STATE BLVD	STA 606 + 62.11, 57.26' R	NB
M ₁	GOLDEN STATE BLVD	STA 618 + 75.92, 73.30' L	SB
M ₂	GOLDEN STATE BLVD	STA 617 + 27.00, 57.06' L	SB
M ₃	GOLDEN STATE BLVD	STA 615 + 77.16, 59.73' L	SB
M ₄	GOLDEN STATE BLVD	STA 614 + 28.00, 62.00' L	SB
M ₅	GOLDEN STATE BLVD	STA 612 + 78.40, 62.43' L	SB
M ₆	GOLDEN STATE BLVD	STA 611 + 28.35, 62.57' L	SB
M ₇	GOLDEN STATE BLVD	STA 609 + 78.34, 62.71' L	SB
M ₈	GOLDEN STATE BLVD	STA 608 + 28.30, 62.85' L	SB
M ₉	GOLDEN STATE BLVD	STA 606 + 78.39, 62.99' L	SB
N ₁	GOLDEN STATE BLVD	STA 617 + 13.98, 59.64' R	NB
N ₂	GOLDEN STATE BLVD	STA 615 + 63.41, 57.97' R	NB
N ₃	GOLDEN STATE BLVD	STA 614 + 12.84, 57.74' R	NB
N ₄	GOLDEN STATE BLVD	STA 612 + 62.46, 57.35' R	NB
N ₅	GOLDEN STATE BLVD	STA 611 + 12.13, 57.57' R	NB
N ₆	GOLDEN STATE BLVD	STA 609 + 62.32, 57.63' R	NB
N ₇	GOLDEN STATE BLVD	STA 608 + 12.56, 57.51' R	NB



POLE PLACEMENT LOCATION			
POLE	LOCATION		DIRECTION
K ₅	GOLDEN STATE BLVD	STA 600 + 97.77, 64.72' L	SB
K ₆	GOLDEN STATE BLVD	STA 602 + 28.22, 64.51' L	SB
K ₇	GOLDEN STATE BLVD	STA 603 + 78.31, 63.27' L	SB
K ₈	GOLDEN STATE BLVD	STA 605 + 28.34, 63.13' L	SB
L ₅	GOLDEN STATE BLVD	STA 600 + 41.48, 58.56' R	NB
L ₆	GOLDEN STATE BLVD	STA 602 + 68.40, 76.37' R	NB
L ₇	GOLDEN STATE BLVD	STA 603 + 51.84, 58.80' R	NB

USA
KNOW WHAT'S BELOW
BEFORE YOU DIG,
CALL
1-800-227-2600

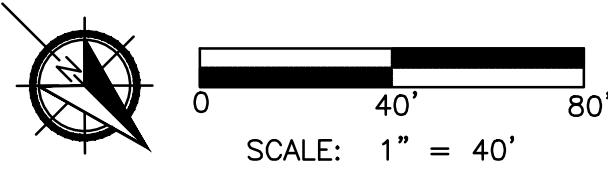


		DATE	RECORD DRAWING		 CALL BEFORE YOU DIG	 516 W. SHAW AVE., STE. 103 FRESNO, CA 93704 PHONE: (559) 570-8991 EMAIL: info@JLBtraffic.com		PROJECT			DEPARTMENT OF PUBLIC WORKS AND PLANNING		
DESIGNED:	J. BENAVIDES	04/06/2021	RESIDENT ENGINEER	DATE				GOLDEN STATE CORRIDOR - ECONOMIC DEVELOPMENT AND INFRASTRUCTURE IMPROVEMENTS			GOLDEN STAVE BLVD STREET LIGHT PLAN		
DRAWN:	C. AYALA-MAGANA	04/06/2021						FOWLER REGION			DRAWING NO. E-8		
CHECKED:	J. RIOS	04/06/2021									SHEET NO. 115		
FOR RIGHT OF WAY DATA AND ACCURATE ACCESS DETERMINATION, SEE DOCUMENTS IN THE DEPARTMENT OF PUBLIC WORKS AND PLANNING.												TOTAL 142	

PLOT DATE: 4/6/2021 11:19:15 AM
C:\Users\CAVALA\OneDrive\Documents\Projects\009-Fresno County\009-009 Golden State PS&E - Fowler Lighting.dwg
PATH: Z:\01 Projects\009 Fresno County\009-009 Golden State PS&E - Fowler Lighting Designs\Design\009-009 Golden State PS&E - Fowler Lighting.dwg

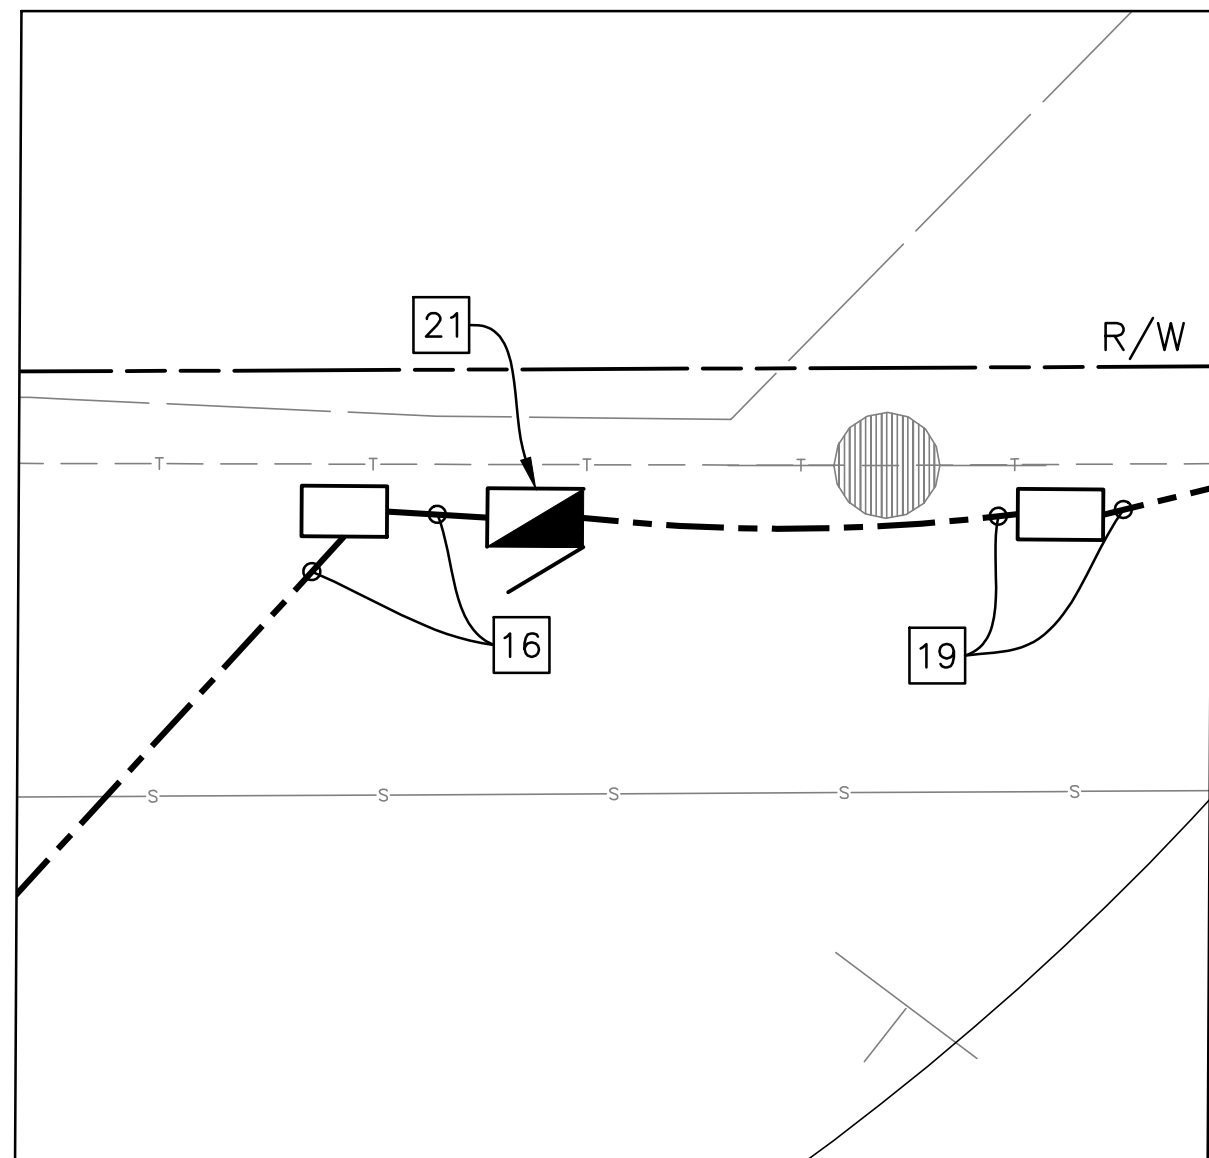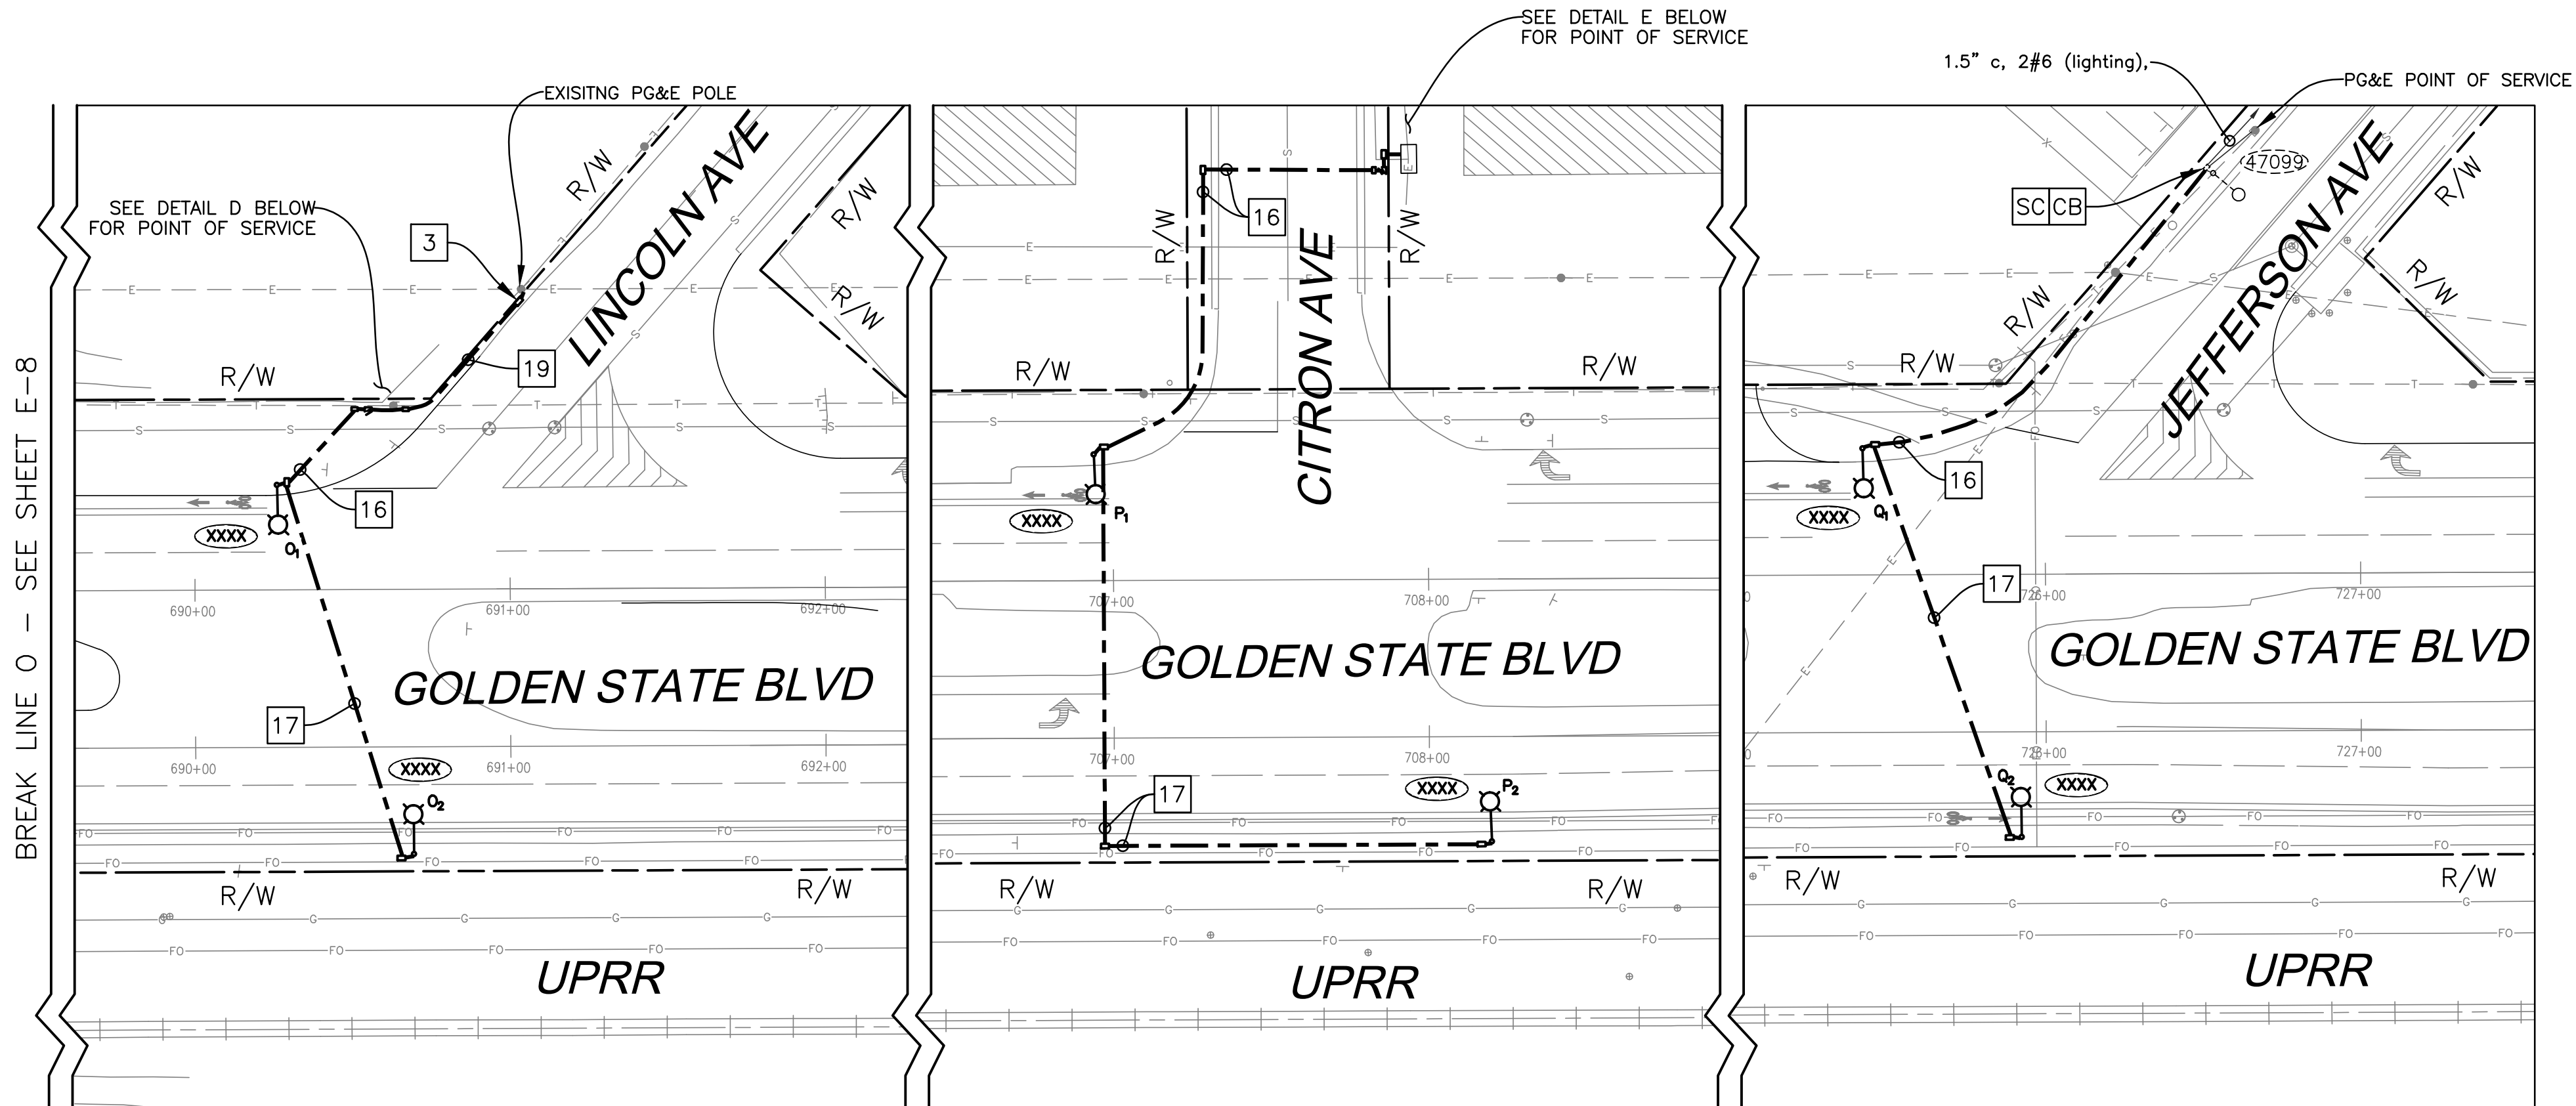


POINT OF SERVICE — DETAIL D
NO SCALE

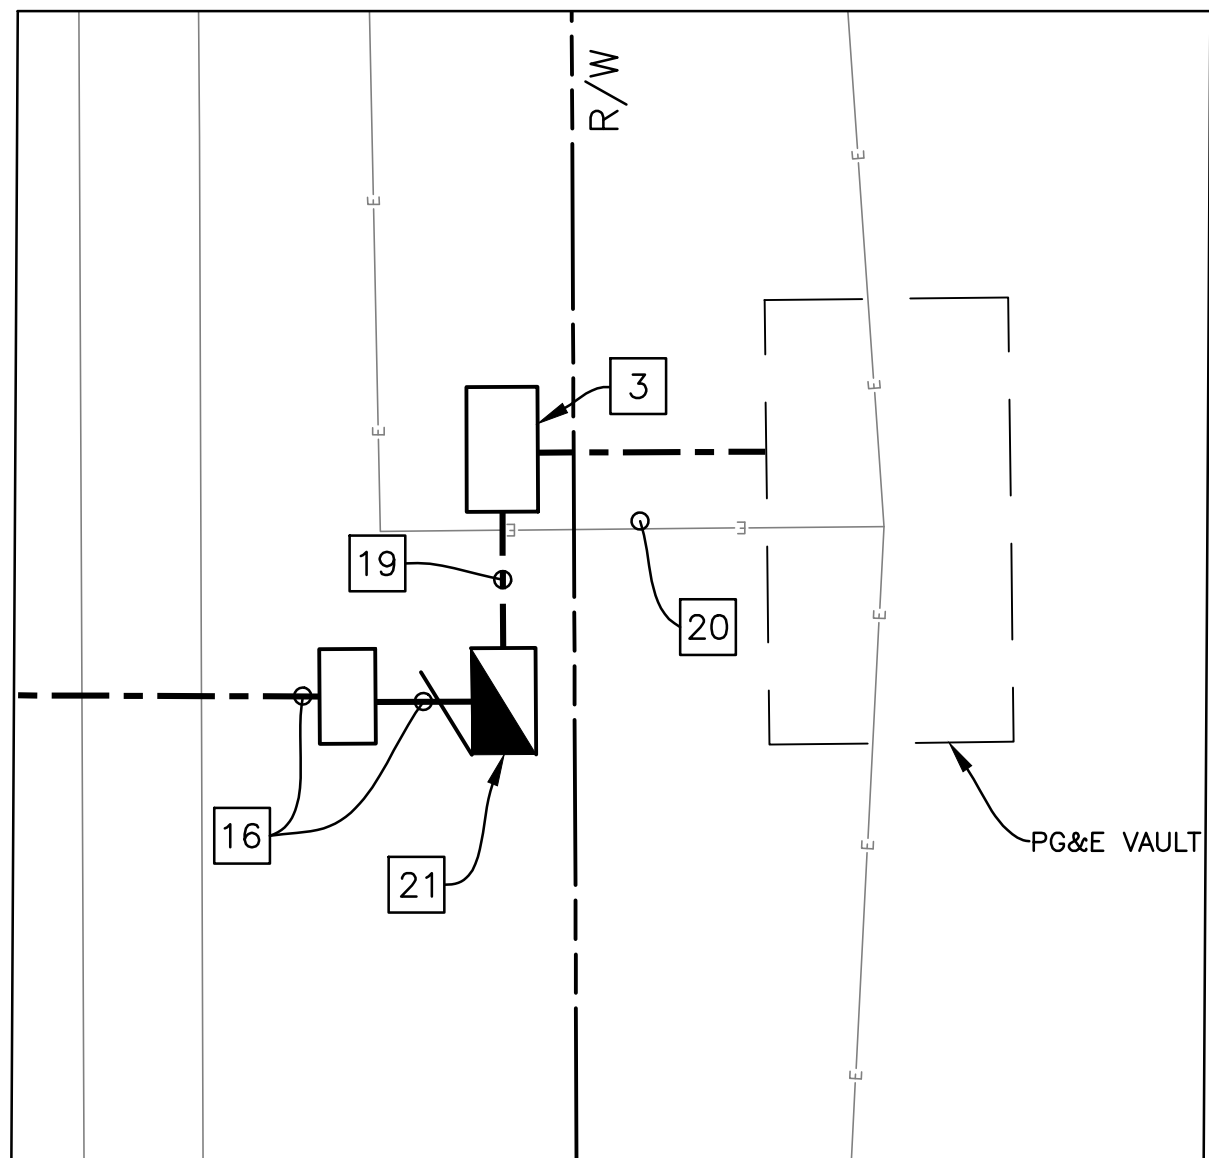


POINT OF SERVICE — DETAIL E
NO SCALE

POLE PLACEMENT LOCATION			
POLE	LOCATION		DIRECTION
O ₁	GOLDEN STATE BLVD	STA 690 + 26.14, 83.32' L	SB
O ₂	GOLDEN STATE BLVD	STA 690 + 69.14, 34.04' R	NB
P ₁	GOLDEN STATE BLVD	STA 706 + 93.90, 40.05' L	SB
P ₂	GOLDEN STATE BLVD	STA 708 + 19.74, 33.28' R	NB
Q ₁	GOLDEN STATE BLVD	STA 725 + 42.13, 40.17' L	SB
Q ₂	GOLDEN STATE BLVD	STA 725 + 92.16, 33.35' R	NB

USA
KNOW WHAT'S BELOW
BEFORE YOU DIG,
CALL
1-800-227-2600

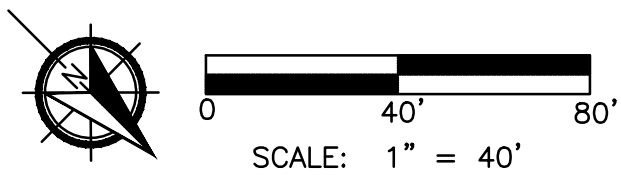

		DATE	RECORD DRAWING		 CALL BEFORE YOU DIG	 516 W. SHAW AVE., STE. 103 FRESNO, CA 93704 PHONE: (559) 570-8991 EMAIL: info@JLBtraffic.com		PROJECT			DEPARTMENT OF PUBLIC WORKS AND PLANNING			
DESIGNED:	J. BENAVIDES	04/06/2021	RESIDENT ENGINEER					DATE	GOLDEN STATE CORRIDOR - ECONOMIC DEVELOPMENT AND INFRASTRUCTURE IMPROVEMENTS		GOLDEN STAVE BLVD STREET LIGHT PLAN			
DRAWN:	C. AYALA-MAGANA	04/06/2021							FOWLER REGION		DRAWING NO. E-9 SHEET NO. 116 TOTAL 142			
CHECKED:	J. RIOS	04/06/2021												
FOR RIGHT OF WAY DATA AND ACCURATE ACCESS DETERMINATION, SEE DOCUMENTS IN THE DEPARTMENT OF PUBLIC WORKS AND PLANNING.														

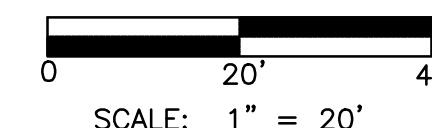

<i>DEPARTMENT OF PUBLIC WORKS AND PLANNING</i>				
GOLDEN STATE BLVD AT SAN ANTONIO DR TRAFFIC SIGNAL MODIFICATION PLAN				
DRAWING NO.	E-10	SHEET NO.	117	TOTAL 142

CONDUCTOR SCHEDULE														
AWG OR CABLE	POLE	Ø	CONDUIT RUN NUMBER AND SIZE											
														
			2-3"	2-3"	3"	3"	3"	3"	(4")	3"	3"	2"	1.5"	2"
CONDUIT FILL			22%	16%	22%	21%	21%	14%	1%	15%	20%	8%	43%	13%
7 COND. CABLE (VEH.) *		1,2 2P	1 1	1 1										
		1,6,8 -	2 -								2 -			
		5,6,8 -	2 -							2 -	2 -			
		2,5 2P	(1) (1)	(1) (1)	(1) (1)	(1) (1)	(1) (1)	(1) (1)						
		8 -	1 -	1 -	1 -	1 -	1 -							
5 COND. CABLE (PED) *														
TOTAL			6(1) 1(1)	2(1) 1(1)	1(1) (1)	1(1) (1)	1(1) (1)	1(1) (1)		2 -	4 -			
3 COND. CABLE (PPB)		2	1	1	1									
		2	1	1	1	1	1							
TOTAL			2	2	2	1	1							
TYPE B DETECTOR LEAD-IN CABLE	Ø1	2								2	2			
	Ø2	3(3)	3(3)											
	Ø5	2	2											
	Ø6	3(2)								3(2)	3(2)			
	Ø8	2(2)	2(2)	2(2)	2(2)	2(2)								
	TOTAL DLC	12(7)	7(5)	2(2)	2(2)	(2)2				5(2)	5(2)			
# 2	SERVICE													3
# 4	SIGNAL POWER											2		
# 6	STREET LIGHTING		(3)	(3)	(3)	(3)	(3)						(6)	
# 8	SAFETY LIGHTS		2	2	2	2	2		2	2			2	
# 8	FLASHING BEACON			(2)	(2)	(2)	(2)	(2)					(2)	
# 8	BONDING WIRE	1	1	1	1	1	1	(1)	1	1	1	1	1	
# 12	PEU CONTROL			(3)	(3)	(3)	(3)						(3)	
EVP CABLE 3 COND.	EVA (S/B)	(1)	(1)	(1)	(1)	(1)	(1)							
	EVC (N/B)	(1)								(1)				
	EVD (E/B)	(1)								(1)	(1)			

* NUMBER INDICATIONS ARE THE NUMBER OF CABLES WITHIN CONDUIT.
ALL CONDUCTORS ARE EXISTING UNLESS OTHERWISE INDICATED WITH "()".

EQUIPMENT SCHEDULE

No.	STANDARD			VEH SIG MTG		PED SIGNAL		PPB		LED LUMINAIRE WATTAGE	PG&E POLE #	SPECIAL REQUIREMENTS
	Type	Sig. M.A.	Lum.M.A.	Mast Arm	Pole	ø	MTG	ø	ARROW			
(A)	15TS	—	8'	—	—	—	—	2(N)	LEFT (N)	78W (N)	3391	REMOVE AND SALVAGE EXISTING PPB ASSEMBLY AND LUMINAIRE. FURNISH AND INSTALL NEW APS PPB ASSEMBLY AND LUMINAIRE.
(B)	1-A (10')	—	—	—	TV-2-T	2(N)	SP-1-T (N)	—	—	—	—	REMOVE AND SALVAGE EXISTING PEDESTRIAN HEAD. FURNISH AND INSTALL NEW PEDESTRIAN HEAD.
(C)	26-3-113	45' (N)	15'	(N) MAT (N) MAS F=19'	SV-2-TA	—	—	—	—	78W (N)	3392	REMOVE AND SALVAGE EXISTING SMA AND ALL EQUIPMENT ATTACHED TO IT. FURNISH AND INSTALL NEW SNS "SAN ANTONIO DR" COMPLETE WITH MOUNTING HARDWARE TO NEW SMA. FURNISH AND INSTALL VEHICLE HEADS AND EVC ON SMA COMPLETE WITH MOUNTING HARDWARE. REMOVE AND SALVAGE EXISTING LUMINAIRE. FURNISH AND INSTALL NEW LUMINAIRE.
(D)	19-1-70	25'	15'	MAS	SV-3-TB	—	—	—	—	78W (N)	3393	FURNISH AND INSTALL EVD AND SNS "GOLDEN STATE BLVD" ON SMA COMPLETE WITH MOUNTING HARDWARE. REMOVE AND SALVAGE EXISTING LUMINAIRE. FURNISH AND INSTALL NEW LUMINAIRE.
(E)	26-3-70	45'	15'	MAS MAS	SV-1-T	2	SP-1-T	—	—	61W	3394	REMOVE AND SALVAGE EXISTING SIGNAL POLE AND ALL EQUIPMENT ATTACHED TO IT.
(E')	61-5-129 (N)	60' (N)	15' (N)	(N) MAT (N) MAS F=22' (N) MAS F=34'	SV-1-T (N)	2 (N)	SP-1-T (N)	—	—	78W (N)	3394 (N)	FURNISH AND INSTALL SNS "SAN ANTONIO DR" AND EVA COMPLETE WITH MOUNTING HARDWARE ON SMA. FURNISH AND INSTALL PEC ON TOP OF SIGNAL POLE.
(F)	1-A (10')	—	—	—	TV-1-T	—	—	2 (N)	RIGHT (N)	—	—	REMOVE AND SALVAGE EXISTING PPB ASSEMBLY. FURNISH AND INSTALL NEW APS PPB ASSEMBLY.
(G)	1-A-FBS	—	—	—	TV-1-T	—	—	—	—	—	—	EXISTING FLASHING BEACON MOUNTED ON EXISTING 1-A POLE WITH W3-3 SIGN TO REMAIN.
(H)	1-A-FBS	—	—	—	TV-1-T	—	—	—	—	—	—	EXISTING FLASHING BEACON MOUNTED ON EXISTING 1-A POLE WITH W3-3 SIGN TO REMAIN.

NOTES:



1. ALL EQUIPMENT IS EXISTING UNLESS OTHERWISE NOTED WITH (N).
2. ALL INDICATIONS SHALL BE 12" LED MODULES.
3. STREET NAME SIGNS SHALL BE WHITE LETTERS ON GREEN BACKGROUND, 12" UPPERCASE, 9" LOWERCASE, 4" BLOCK NUMBERS, 4" WIDE ARROWS, SERIES "D" TEXT ON TYPE XI DIAMOND GRADE SHEETING AND 3M TYPE XI DG3 OR APPROVED EQUAL.
4. LED INTERSECTION SAFETY LIGHT LUMINAIRES INSTALLED AND SHALL BE CREE RSWS-A-HT-3ME-6L-40K7-UL-GY-N FULL POWER: 78W, 9325 LUMEN, 4000K, CR170-B1-U0-G2, RSWS9056&SP.

GENERAL NOTES (SHEETS E-10 TO E-12 ONLY):

- | | | | |
|-----|---|-----|--|
| 1. | WORK SHALL BE DONE IN ACCORDANCE WITH THE STATE OF CALIFORNIA DEPARTMENT OF TRANSPORTATION STANDARD PLANS AND SPECIFICATIONS, 2010 EDITION, THE LATEST CALTRANS ADOPTED EDITION OF THE CALIFORNIA MANUAL ON UNIFORM TRAFFIC CONTROL DEVICES (CA-MUTCD), AND THE LATEST EDITION OF THE CITY OF FRESNO STANDARD SPECIFICATIONS AND DRAWINGS. SIGNAL POLES/STANDARDS FOR 113KM/H WIND VELOCITY AND TYPE 1-A POLES SHALL BE PER THE STATE STANDARD PLANS AND SPECIFICATIONS, DATED JULY 1997. | 18. | PEDESTRIAN PUSH BUTTONS SHALL HAVE 2" DIAMETER ACTUATORS AND COMPLY WITH THE AMERICANS WITH DISABILITIES ACT (ADA). |
| 2. | THESE PLANS ARE ACCURATE FOR ELECTRICAL WORK ONLY. | 19. | ALL VEHICLE AND PEDESTRIAN SIGNAL SECTIONS SHALL UTILIZE LIGHT EMITTING DIODE (LED) SIGNAL MODULES IN ACCORDANCE WITH THE STANDARD SPECIFICATIONS. VEHICLE SIGNAL SECTIONS SHALL HAVE 12" (300 mm) DIAMETER LENSES WITH BACKPLATES AND TUNNEL VISORS. ALL VEHICLE AND PEDESTRIAN SIGNAL SECTIONS SHALL HAVE METAL AND RUBBER WASHERS INSTALLED ON THE INSIDE OF THE HEAD. |
| 3. | NO ABOVE GROUND WORK, EXCEPT SERVICE EQUIPMENT, SHALL BE PERFORMED UNTIL THE CONTRACTOR HAS ALL MATERIALS ON HAND TO COMPLETE THAT PARTICULAR SIGNAL LOCATION OR LIGHTING CIRCUIT. | 20. | SAFETY LUMINAIRE SHALL BE LED (EQUAL TO 150W HPS), SEE UPDATED CITY OF FRESNO SPECIFICATIONS FOR SAFETY LUMINAIRE REQUIREMENTS. |
| 4. | THE CONTRACTOR IS RESPONSIBLE FOR VERIFICATION OF ALL EXISTING UTILITIES WHETHER OR NOT THEY ARE SHOWN ON THESE PLANS, AND SHALL PROVIDE PROTECTION PRIOR TO, DURING AND AFTER TRENCHING, JACKING AND/ OR BORING. THE CONTRACTOR SHALL CONTACT UNDERGROUND SERVICE ALERT (USA), BY CALLING 1-800-227-2600 AT LEAST TWO (2) WORKING DAYS BEFORE BEGINNING WORK. | 21. | PEDESTRIAN SIGNAL UNITS SHALL BE FULL SYMBOL, MUTCD COMPLIANT, LED "COUNTDOWN" TYPE WITH 9 INCH NUMERALS; GELCORE MODEL P57-CFF1-01A-18, OR APPROVED EQUAL. SIGNAL ALIGNMENT SHALL BE AS DIRECTED BY THE ENGINEER. |
| 5. | CONDUIT INSTALLATION ACROSS ROADWAYS SHALL BE BY JACKING AND DIRECTIONAL DRILLING METHODS UNLESS OTHERWISE NOTED ON THE PLANS. | 22. | THE CONTRACTOR SHALL FURNISH AND INSTALL A COMPLETE OPTICOM (GTT) EMERGENCY VEHICLE PREEMPTION (EVP) SYSTEM (721 TWO DIRECTION DETECTION, SINGLE CHANNEL) IN ACCORDANCE WITH THE CITY STANDARD SPECIFICATIONS. EVP DETECTOR UNITS SHALL BE INSTALLED ON SIGNAL MAST ARMS AS SHOWN ON THE PLAN, CENTERED OVER THE NUMBER ONE THROUGH LANE, WITH BRACKETS APPROVED BY THE TRAFFIC SIGNAL SUPERVISOR. THE CONTRACTOR SHALL DELIVER THE MODEL 762 DISCRIMINATORS TO THE CITY CORPORATION YARD AT 2101 "G" STREET, FRESNO, AND NOTIFY THE CITY TRAFFIC SIGNAL SHOP, (559) 621-1312, AT LEAST TWO (2) WORKING DAYS PRIOR TO DELIVERY. |
| 6. | CONTRACTOR SHALL ARRANGE WITH UTILITY COMPANIES FOR ALL REQUIRED UTILITY RELOCATIONS, INCLUDING OVERHEAD CONFLICTS. | 23. | CONTRACTOR SHALL SCHEDULE WITH THE CITY OF FRESNO TSSL SHOP AT (559) 621-1312 ALL EQUIPMENT DELIVERIES WHICH REQUIRE TESTING BY THE CITY'S TSSL SHOP. EQUIPMENT SHALL BE DELIVERED BY THE CONTRACTOR ONLY AT A PREARRANGED TIME AND DAY. |
| 7. | ALL TRAFFIC SIGNAL AND LIGHTING FACILITIES, INCLUDING CABINETS, STANDARDS, PULL BOXES, CONDUITS AND LOOP DETECTORS, ARE SHOWN IN THEIR APPROXIMATE LOCATIONS. AFTER ALL UNDERGROUND UTILITIES ARE MARKED, THE CONTRACTOR SHALL MARK FINAL LOCATIONS IN THE FIELD AND NOTIFY THE ENGINEER AT LEAST TWO (2) WORKING DAYS PRIOR TO COMMENCING WORK TO OBSERVE THE MARKED LOCATIONS. | 24. | THE CONTRACTOR SHALL FURNISH AND INSTALL NEW STREET NAME SIGN ON SMA COMPLETE WITH VARIABLE LENGTH MOUNTING HARDWARE, AS SHOWN ON THE PLAN. FURNISH AND INSTALL NEW MOUNTING BRACKETS AS NECESSARY. SUBMITTALS SHALL BE APPROVED BY THE CITY PRIOR TO ORDERING. |
| 8. | ALL SALVAGED EQUIPMENT SHALL BE RETURNED TO THE CITY OF FOWLER PUBLIC WORKS DEPARTMENT. THE CONTRACTOR SHALL NOTIFY THE CITY, CONTACT AT LEAST TWO (2) WORKING DAYS PRIOR TO DELIVERY. CONTRACTOR SHALL PROVIDE ADEQUATE MEANS FOR SAFELY UNLOADING EQUIPMENT. | 25. | ALL SIGNS SHALL BE 3M-3930HIP TYPE III & IV SERIES REFLECTIVE SHEETING AND BE COVERED WITH 1160A PREMIUM OVERLAY ANTI-GRAFFITI FILM OR AVERY DENNISON T6500 SERIES REFLECTIVE SHEETING AND SHALL BE COVERED WITH AVERY DENNISON OL1000 ANTI-GRAFFITI OVERLAY FILM. |
| 9. | PULL BOXES SHALL BE NO. 5(E), UNLESS OTHERWISE NOTED ON THE PLANS. PULL BOXES SHALL NOT BE INSTALLED IN CURB RAMPS OR DRIVEWAYS. VANDAL RESISTANT LOCKING LIDS SHALL BE PROVIDED AND INSTALLED BY THE CONTRACTOR AT FINAL INSPECTION OF THE TRAFFIC SIGNAL. CONTRACTOR SHALL PROVIDE TEMPORARY LIDS DURING CONSTRUCTION. ALL PULL BOXES SHALL BE AT A MAXIMUM OF 200' APART. LIDS SHALL BE TORQUED TO 25 FT. LBS. | 26. | CONDUITS EXITING THE CONTROLLER FOUNDATION AND ENTERING INTO THE CONTROLLER CABINET SHALL BE ALIGNED TO ENTER WITHIN THE TEES SPECIFIED CABINETS WITHOUT ANY MODIFICATIONS TO THE CABINET BASE. |
| 10. | ALL PULL BOXES INSTALLED IN NON-CONCRETE AREAS SHALL BE SURROUNDED BY A ONE (1) FOOT WIDE CONCRETE COLLAR, TO A DEPTH EQUAL TO THE PULL BOX AND EXTENSION, PER CITY OF FRESNO SPECIFICATIONS, AND SHALL HAVE A VANDAL RESISTANT (SEE NOTE ABOVE) LOCKING LID INSTALLED. ALL CONDUIT ENTRIES INTO ADVANCE DETECTION, INTERMEDIATE DETECTION, AND STREET LIGHTING PULL BOXES INSTALLED IN NON-CONCRETE AREAS SHALL ENTER THE PULL BOX FROM THE BOTTOM, USING 90 DEGREE ELBOWS AND EXTENDING 3 TO 5 INCHES ABOVE THE FINISHED GROUT. | 27. | ALL RESURFACING SHALL MATCH EXISTING SURFACES AFTER SIGNAL FACILITIES ARE REMOVED AND/OR RELOCATED. |
| 11. | ALL CONDUITS SHALL HAVE BUSHINGS INSTALLED PRIOR TO INSTALLING CONDUCTORS. STEEL CONDUITS SHALL HAVE LAY IN STYLE LUGS THAT ARE CAST INTEGRAL WITH THE BUSHING. | 28. | THE EXISTING TRAFFIC SIGNAL SYSTEM, INCLUDING DETECTION, AND/OR STREET LIGHTING SHALL REMAIN OPERATIONAL DURING CONSTRUCTION, UNLESS OTHERWISE AUTHORIZED IN WRITING BY THE CITY ENGINEER. |
| 12. | CONDUIT BENDS OF 90 DEGREES ARE PROHIBITED UNLESS OTHERWISE NOTED OR WRITTEN PERMISSION IS GIVEN BY THE CITY OF FOWLER ENGINEER. | 29. | ALL LUMINAIRE CIRCUITS SHALL BE FUSED. THE FUSE SHALL BE LOCATED IN THE LUMINAIRE HEAD (5 AMP KTK FUSE IN TRON HEB TYPE FUSE HOLDER). |
| 13. | ALL NEUTRAL CONDUCTORS SHALL BE WHITE IN COLOR THROUGHOUT THEIR ENTIRE LENGTH. | 30. | THE CONTRACTOR SHALL FURNISH AND INSTALL POLE NUMBERS WHEN PG&E INDICATES THE NUMBER. POLE NUMBERS SHALL BE SHOWN ON THE AS BUILT DRAWINGS. |
| 14. | TRAFFIC SIGNAL CABLE SHALL NOT BE SPICED BETWEEN THE CONTROLLER CABINET AND THE TERMINAL COMPARTMENTS MOUNTED ON THE POLES. DETECTOR CABLES SHALL NOT BE SPICED BETWEEN THE CONTROLLER CABINET AND THE PULL BOX ADJACENT TO THE DETECTOR LEAD-IN. | 31. | THE CONTRACTOR SHALL FURNISH AND INSTALL A COMPLETE ACCESSIBLE (AUDIBLE) PEDESTRIAN SIGNAL (APS) SYSTEM (2-WIRE POLARA NAVIGATOR OR APPROVED EQUAL) IN CONFORMANCE WITH THE CITY OF FRESNO STANDARD SPECIFICATIONS. THE APS SHALL PROVIDE BOTH A VIBRATING ARROW BUTTON AND AUDIBLE SOUNDS DURING THE "WALK" INTERVAL, AS WELL AS A LOCATING TONE DURING THE PEDESTRIAN CLEARANCE AND DON'T WALK INTERVALS. THE APS SYSTEM SHALL MEET CURRENT ADA AND CA-MUTCD REQUIREMENTS. ALL PEDESTRIAN PUSH BUTTONS SHALL HAVE A FOUR FOOT ACCESSIBLE PATH IN FRONT OF THE BUTTON. THE APS CENTRAL CONTROL UNIT (CCU) SHALL BE MOUNTED WITH A CITY-APPROVED MANUFACTURED BRACKET, MCCAIN M49021 OR APPROVED EQUAL. CCU SHALL BE MOUNTED TO THE REAR RACK, IN THE UPPER LEFT CORNER WHEN VIEWED FROM THE FRONT OF THE CABINET. THE POWER SUPPLY PIGTAIL SHALL BE CUT TO LENGTH TO ELIMINATE EXCESS CABLE, WITH POWER OBTAINED FROM THE PDA T1 TERMINAL STRIP, TERMINALS 1, 3, & 5. CONTRACTOR SHALL PROVIDE CITY OF FRESNO TSSL THE LATEST MEANS OF PROGRAMMING THE APS SYSTEM AND DIGITAL COPIES OF THE CUSTOM AUDIO VIA EMAIL. |
| 15. | PEDESTRIAN MODULE SHALL BE INSTALLED ON THE LEFT SIDE, FACING THE FRONT, OF THE 332 CABINET. | | |
| 16. | SEAL CONDUIT WITH AN APPROVED DUCT SEAL AFTER ALL CONDUCTORS HAVE BEEN INSTALLED. | | |
| 17. | SEALANT FOR FILLING THE SAWCUT NOPTS SLOTS SHALL BE HOT-MELT RUBBERIZED ASPHALT SEALANT PER STATE OF CALIFORNIA SPECIFICATIONS, OR ELASTOMERIC SEALANT, 3M, BLACK 5000. | | |


		DATE	RECORD DRAWING		 CALL BEFORE YOU DIG	 JLB TRAFFIC TRAFFIC CONTROL INC. 516 W. SHAW AVE., STE. 103 FRESNO, CA 93704 PHONE: (559) 570-8991 EMAIL: info@JLBtraffic.com	 REGISTERED PROFESSIONAL ENGINEER CIVIL No. 60967 Exp. 12/31/2024 STATE OF CALIFORNIA	PROJECT		 THE CITY OF FOWLER - CALIFORNIA 1908	DEPARTMENT OF PUBLIC WORKS AND PLANNING		
DESIGNED:	J. BENAVIDES	03/25/2021	RESIDENT ENGINEER					DATE	GOLDEN STATE CORRIDOR - ECONOMIC DEVELOPMENT AND INFRASTRUCTURE IMPROVEMENTS		GOLDEN STATE BLVD AT SAN ANTONIO DR EQUIPMENT AND CONDUCTOR SCHEDULE		
DRAWN:	C. AYALA-MAGANA	03/25/2021											
CHECKED:	J. RIOS	03/25/2021											
FOR RIGHT OF WAY DATA AND ACCURATE ACCESS DETERMINATION, SEE DOCUMENTS IN THE DEPARTMENT OF PUBLIC WORKS AND PLANNING.								SUPERVISING ENGINEER			DATE	FOWLER REGION	

CAD USER: CAYALA
PLOT DATE: 3/25/2021 8:32:00 AM
PATH: Z:\01 Projects\009 Fresno County\009-009 Golden State PS&E\Traffic Signal Designs\2a Golden State Blvd at San Antonio Dr.dwg

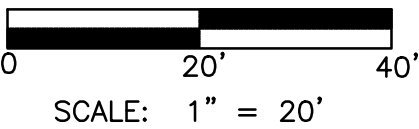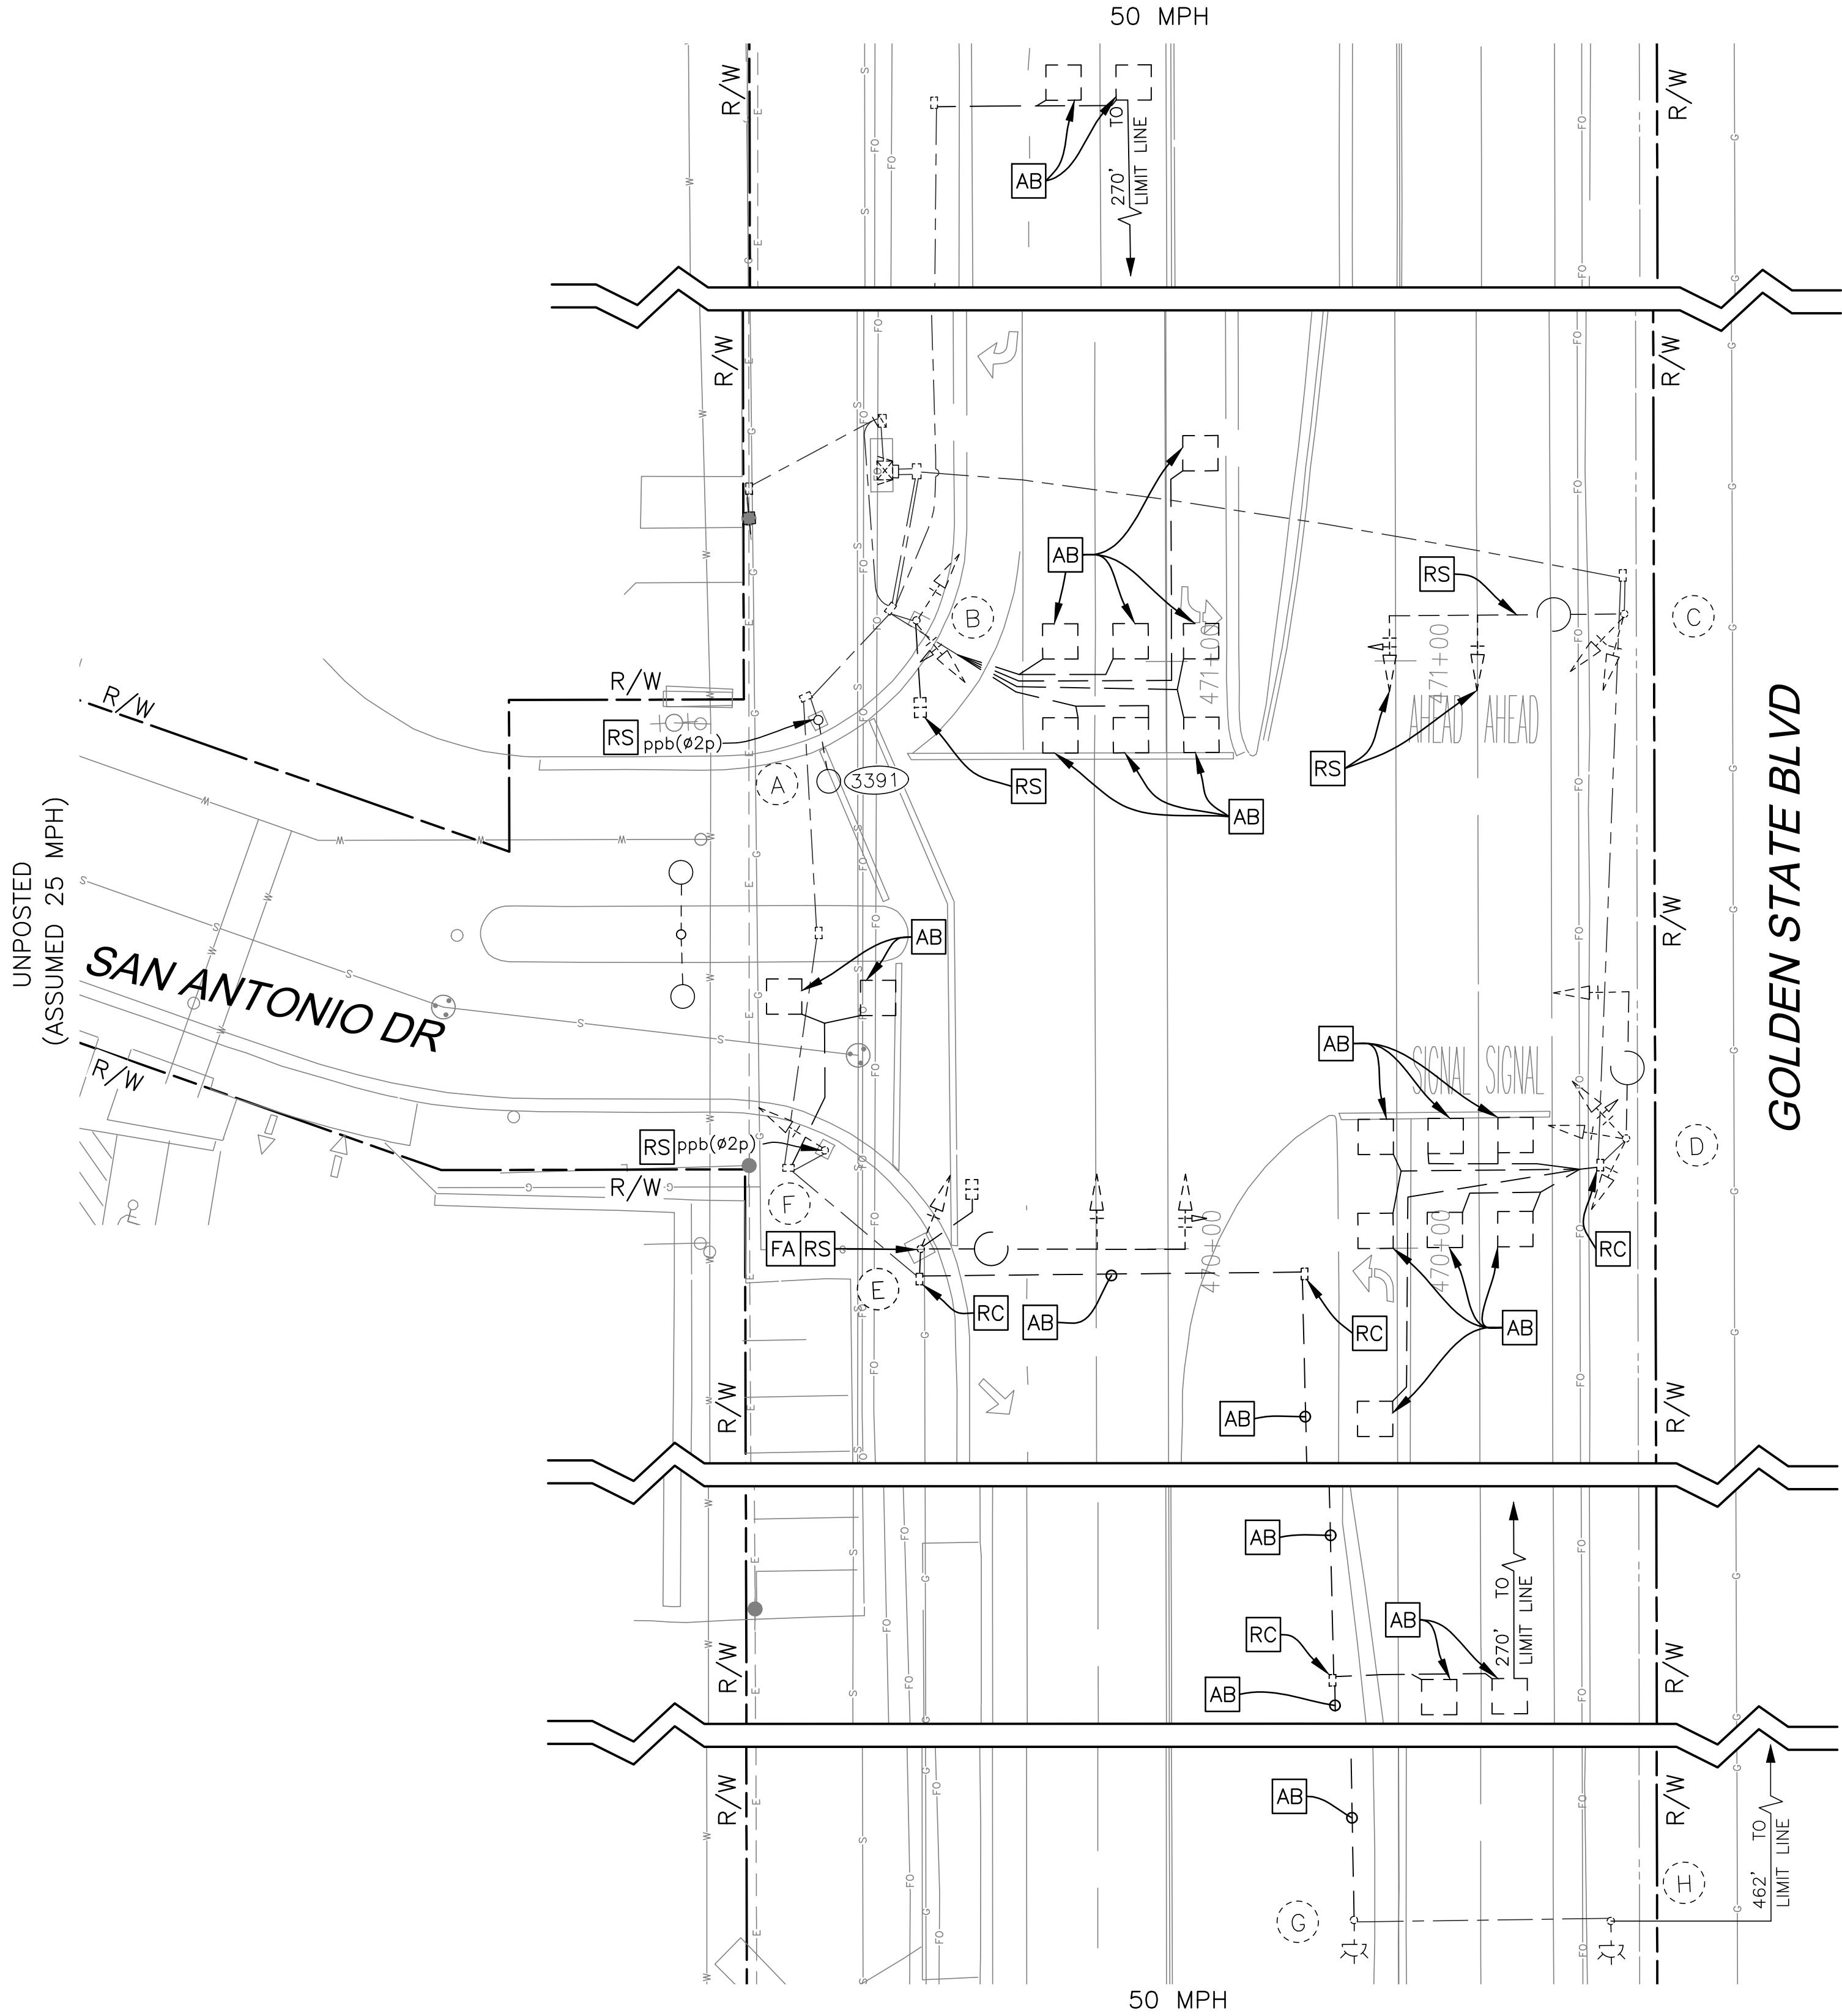

RECORD DRAWING		DATE
DESIGNED: J. BENAVIDES	RESIDENT ENGINEER	03/25/2021
DRAWN: C. AYALA-MAGANA		03/25/2021
CHECKED: J. RIOS		03/25/2021

FOR RIGHT OF WAY DATA AND ACCURATE ACCESS DETERMINATION, SEE DOCUMENTS IN THE DEPARTMENT OF PUBLIC WORKS AND PLANNING.

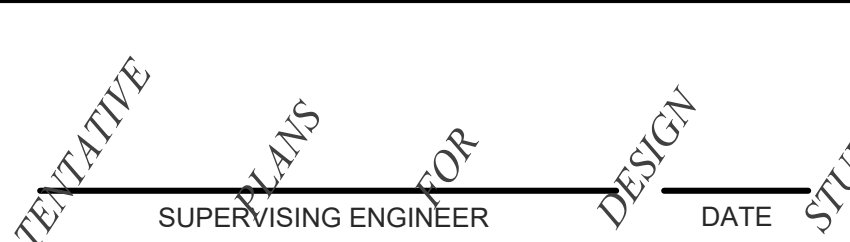


PROJECT
GOLDEN STATE CORRIDOR - ECONOMIC DEVELOPMENT AND INFRASTRUCTURE IMPROVEMENTS
FOWLER REGION



DEPARTMENT OF PUBLIC WORKS AND PLANNING			
GOLDEN STATE BLVD AT SAN ANTONIO DR TRAFFIC SIGNAL DEMOLITION PLAN			
DRAWING NO.	E-12	SHEET NO.	119
		TOTAL	142

PATH: Z:\01 Projects\009 Fresno County\009-009 Golden State Blvd at Manning Ave\Golden State Blvd at Manning Ave\Golden State Blvd at Manning Ave.dwg
PLOT DATE: 3/22/2021 3:47:45 PM
CAD USER: CAYALA

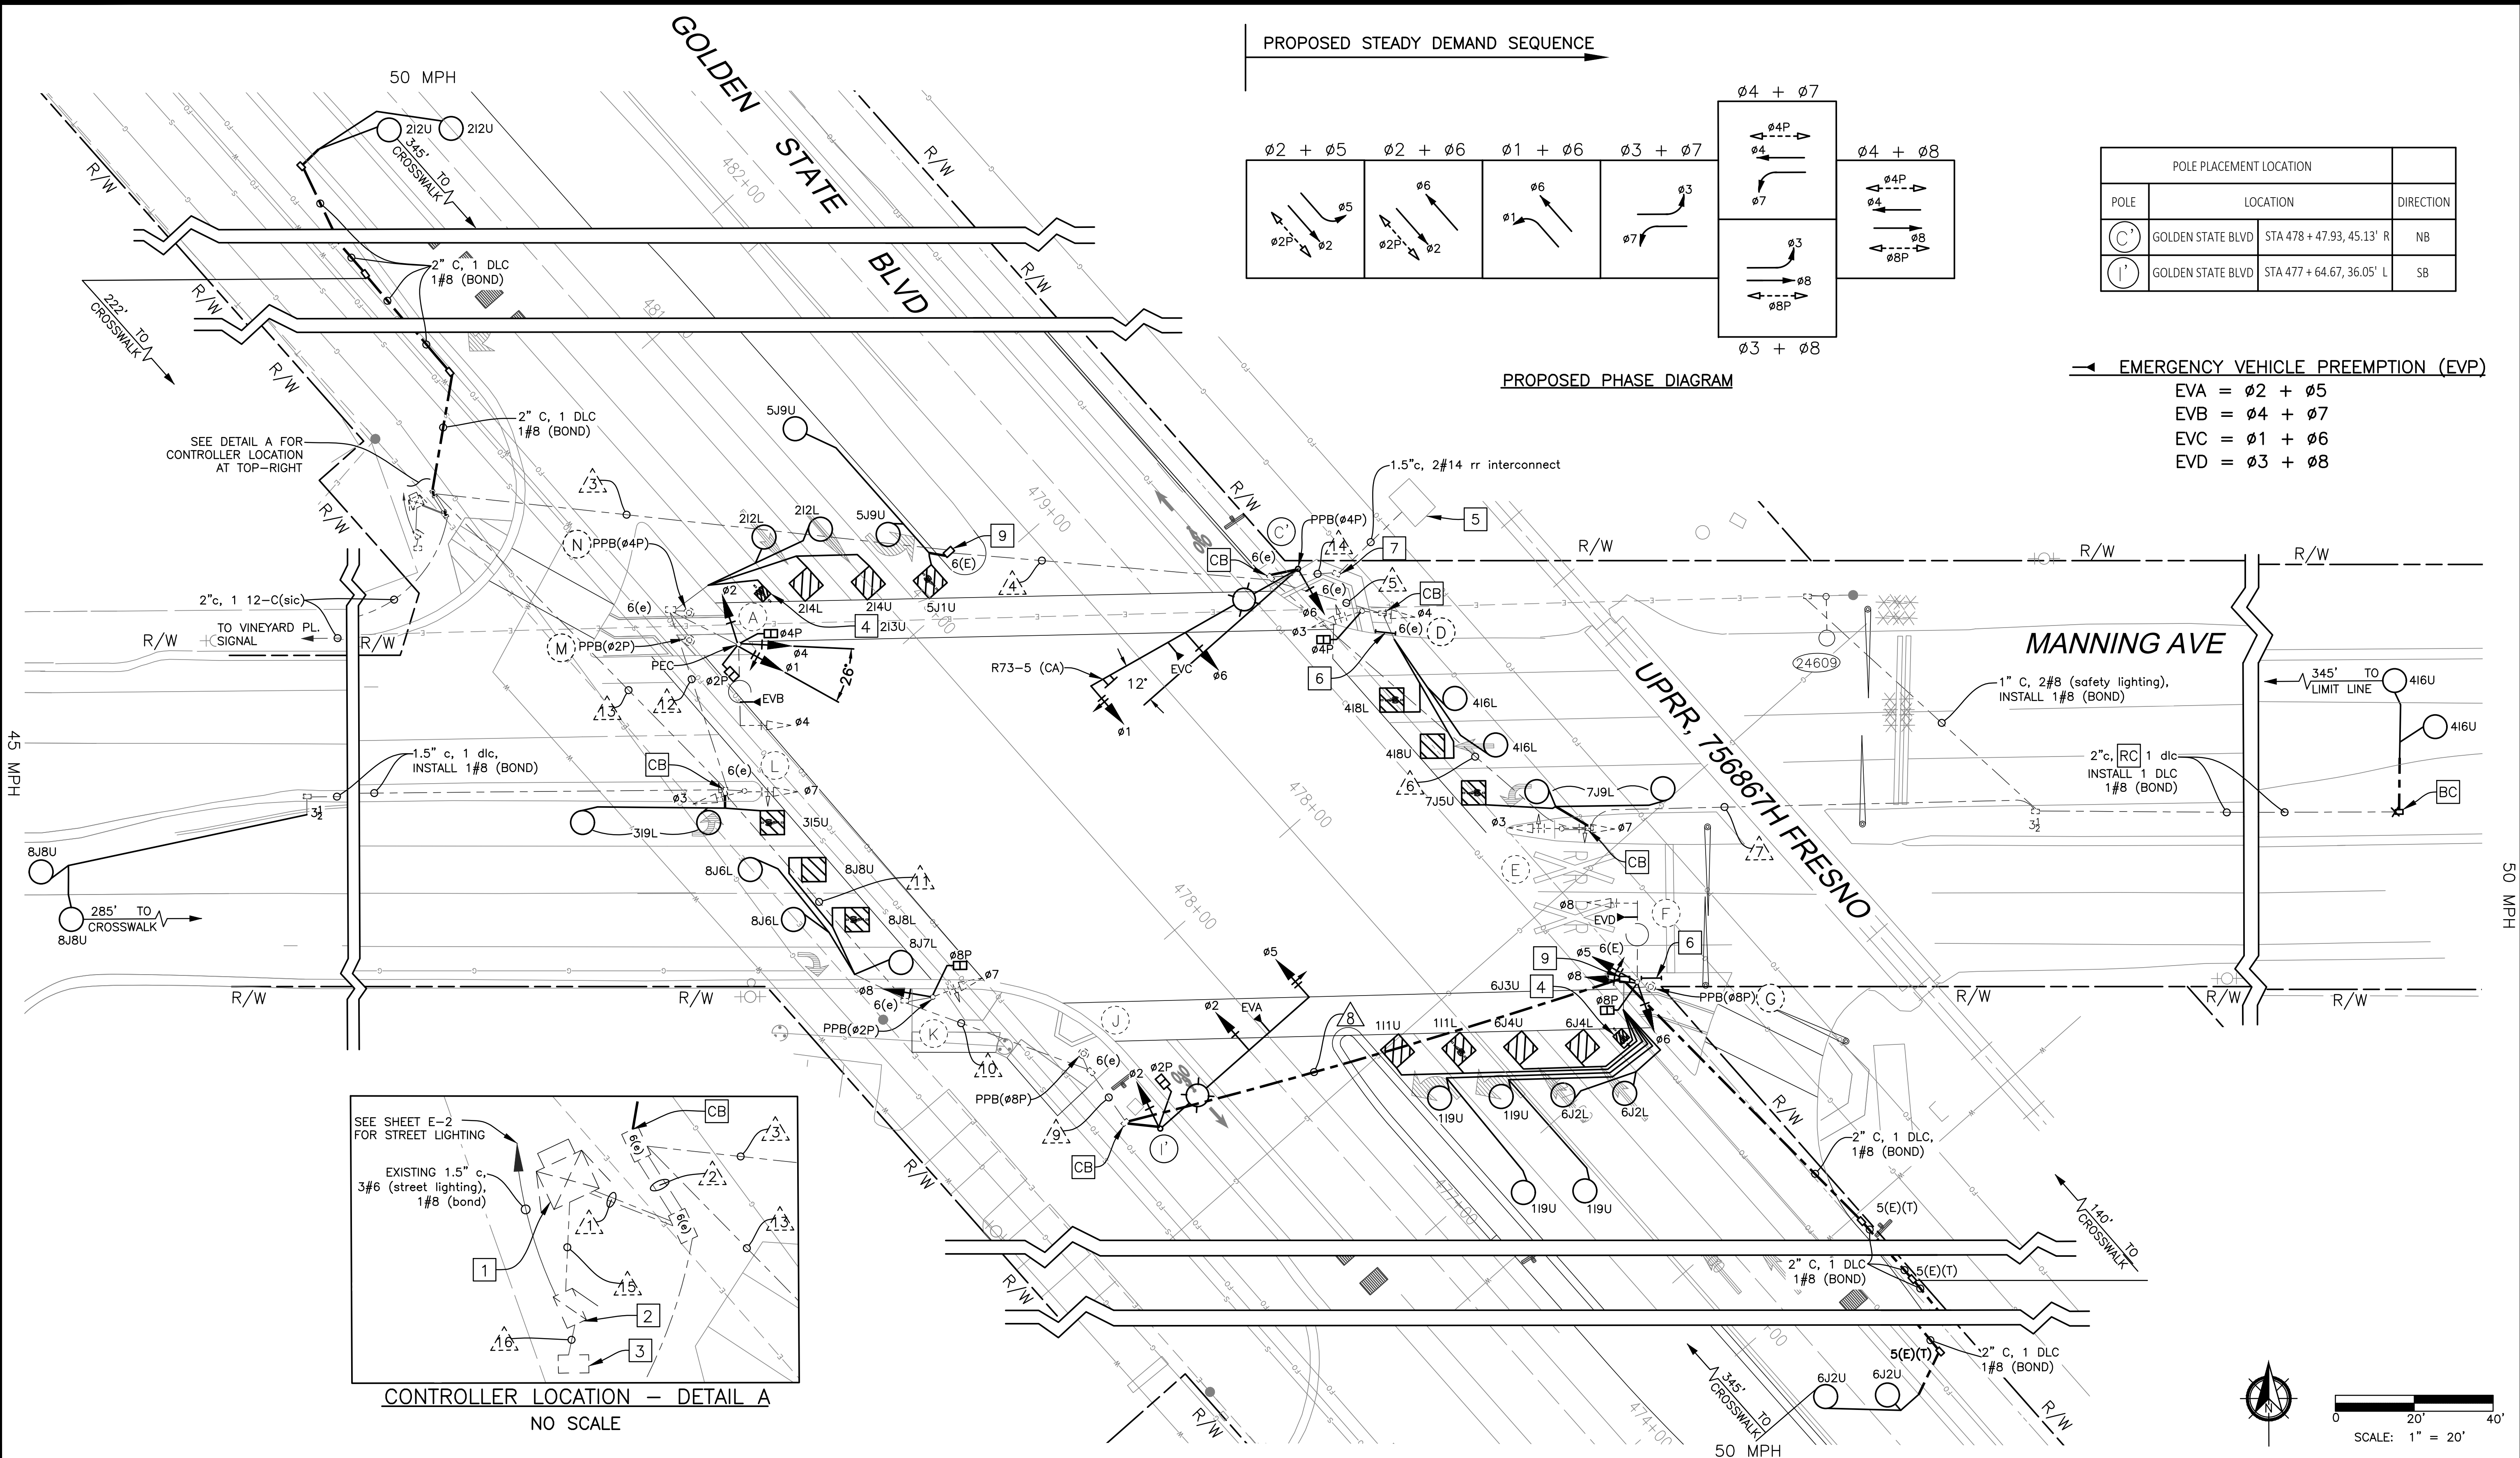

DESIGNED: J. BENAVIDES		DATE: 03/22/2021	RECORD DRAWING	
DRAWN: C. AYALA-MAGANA		DATE: 03/22/2021	RESIDENT ENGINEER	
CHECKED: J. RIOS		DATE: 03/22/2021	DATE	

FOR RIGHT OF WAY DATA AND ACCURATE ACCESS DETERMINATION, SEE DOCUMENTS IN THE DEPARTMENT OF PUBLIC WORKS AND PLANNING.

CALL BEFORE YOU DIG

JLB TRAFFIC
516 W. SHAW AVE., STE. 103
FRESNO, CA 93704
PHONE: (559) 570-8991
EMAIL: info@JLBtraffic.com

TENTATIVE PLANS FOR DESIGN

SUPERVISING ENGINEER

DATE

PROFESSIONAL ENGINEER
J. BENAVIDES
No. 00000000
Exp. 03/22/2022
STATE OF CALIFORNIA

PROJECT

GOLDEN STATE CORRIDOR - ECONOMIC DEVELOPMENT AND INFRASTRUCTURE IMPROVEMENTS

FOWLER REGION

CITY OF FOWLER

DEPARTMENT OF PUBLIC WORKS AND PLANNING

GOLDEN STATE BLVD AT MANNING AVE
TRAFFIC SIGNAL MODIFICATION PLAN

DRAWING NO. E-13 SHEET NO. 120 TOTAL 142

CAD USER: CAYALA
PLOT DATE: 3/22/2021 9:39:38 AM
PATH: Z:\01 Projects\009 Fresno County\009-Golden State Blvd at Manning Ave\Golden State Blvd at Manning Ave\Golden State Blvd at Manning Ave\Traffic Signal Designs\2d Golden State PS&E\Legend Legend and Notes.dwg

PROJECT NOTES (SHEETS E-13 TO E-16 ONLY):

- 1

EXISTING 332 CABINET WITH BATTERY BACK UP SYSTEM. FURNISH AND INSTALL APS CENTRAL CONTROL UNIT.
- 2

EXISTING SERVICE ENCLOSURE
- 3

EXISTING PG&E POINT OF SERVICE PULL BOX
- 4

INSTALL 3'X3' BIKE LOOP PER DETAIL D AS SHOWN ON ED-1.
- 5

EXISTING RAILROAD CONTROLLER TO REMAIN. EXISTING INTERCONNECTION TO THE RR SIGNAL SYSTEM SHALL BE MAINTAINED AT ALL TIMES DURING CONSTRUCTION.
- 6

FURNISH AND INSTALL TYPE I PED BARRICADE WITH R9-3.
- 7

EXISTING RAILROAD PREEMPTION CABLING TO REMAIN. CONTACT UPRR PRIOR TO ANY WORK WITHIN UPRR RIGHT-OF-WAY OR ANY WORK AFFECTING GRADE CROSSING OPERATIONS.
- 8

RS

ALL EXISTING PEDESTRIAN PUSH BUTTONS ON EXISTING POLE.
- 9

RC

EXISTING PULL BOX AND

BC

A NEW PULL BOX.

LEGEND (SHEETS E-13 TO E-16 ONLY):

- TYPE E CIRCULAR LOOP DETECTOR CONFIGURATION PER STATE STANDARD PLAN ES-5B. LOOP SEALANT SHALL BE STATE APPROVED ELASTOMERIC SEALANT OR HOT MELT RUBBERIZED.
- EXISTING TYPE E LOOP DETECTOR.
- TYPE D LOOP DETECTOR CONFIGURATION PER STATE STANDARD PLAN ES-5B. LOOP SEALANT SHALL BE STATE APPROVED ELASTOMERIC SEALANT OR HOT MELT RUBBERIZED. BICYCLE DETECTOR SYMBOL TO BE INSTALLED PER CALTRANS STANDARD PLAN A24-C ON CENTER OF THE DETECTOR. ARROW SIGNIFIES DIRECTION OF TRAVEL.
- EXISTING TYPE A LOOP DETECTOR.
- NEW EMERGENCY VEHICLE PREEMPTION (EVP) DETECTION UNIT. EVA (DENOTES CHANNEL).
- NEW CONDUIT.
- EXISTING CONDUIT.
- EXISTING LUMINAIRE.
- AB

ABANDON, IF APPLIED TO CONDUIT, REMOVE CONDUCTORS.
- RS

REMOVE AND SALVAGE EQUIPMENT.
- RC

EQUIPMENT OR MATERIAL TO BE REMOVED AND BECOME THE PROPERTY OF THE CONTRACTOR.
- FA

FOUNDATION TO BE ABANDONED. REMOVE TOP OF FOUNDATION TO A POINT 36" BELOW THE FINISH GRADE.
- CB

INSTALL NEW CONDUIT INTO EXISTING PULL BOX.
- BC

INSTALL PULL BOX IN EXISTING CONDUIT RUN.

GENERAL NOTES (SHEETS E-13 TO E-16 ONLY):

1.

WORK SHALL BE DONE IN ACCORDANCE WITH THE STATE OF CALIFORNIA DEPARTMENT OF TRANSPORTATION STANDARD PLANS AND SPECIFICATIONS, 2010 EDITION, THE LATEST CALTRANS ADOPTED EDITION OF THE CALIFORNIA MANUAL ON UNIFORM TRAFFIC CONTROL DEVICES (CA-MUTCD), AND THE LATEST EDITION OF THE CITY OF FRESNO STANDARD SPECIFICATIONS AND DRAWINGS. SIGNAL POLES/STANDARDS FOR 113KM/H WIND VELOCITY AND TYPE 1-A POLES SHALL BE PER THE STATE STANDARDPLANS AND SPECIFICATIONS, DATED JULY 1997.
2.

THESE PLANS ARE ACCURATE FOR ELECTRICAL WORK ONLY.
3.

NO ABOVE GROUND WORK, EXCEPT SERVICE EQUIPMENT, SHALL BE PERFORMED UNTIL THE CONTRACTOR HAS ALL MATERIALS ON HAND TO COMPLETE THAT PARTICULAR SIGNAL LOCATION OR LIGHTING CIRCUIT.
4.

THE CONTRACTOR IS RESPONSIBLE FOR VERIFICATION OF ALL EXISTING UTILITIES WHETHER OR NOT THEY ARE SHOWN ON THESE PLANS, AND SHALL PROVIDE PROTECTION PRIOR TO, DURING AND AFTER TRENCHING, JACKING AND/ OR BORING. THE CONTRACTOR SHALL CONTACT UNDERGROUND SERVICE ALERT (USA), BY CALLING 1-800-227-2600 AT LEAST TWO (2) WORKING DAYS BEFORE BEGINNING WORK.
5.

CONDUIT INSTALLATION ACROSS ROADWAYS SHALL BE BY JACKING AND DIRECTIONAL DRILLING METHODS UNLESS OTHERWISE NOTED ON THE PLANS.
6.

CONTRACTOR SHALL ARRANGE WITH UTILITY COMPANIES FOR ALL REQUIRED UTILITY RELOCATIONS, INCLUDING OVERHEAD CONFLICTS.
7.

ALL TRAFFIC SIGNAL AND LIGHTING FACILITIES, INCLUDING CABINETS, STANDARDS, PULL BOXES, CONDUITS AND LOOP DETECTORS, ARE SHOWN IN THEIR APPROXIMATE LOCATIONS. AFTER ALL UNDERGROUND UTILITIES ARE MARKED, THE CONTRACTOR SHALL MARK FINAL LOCATIONS IN THE FIELD AND NOTIFY THE ENGINEER AT LEAST TWO (2) WORKING DAYS PRIOR TO COMMENCING WORK TO OBSERVE THE MARKED LOCATIONS.
8.

ALL SALVAGED EQUIPMENT SHALL BE RETURNED TO THE CITY OF FOWLER PUBLIC WORKS DEPARTMENT. THE CONTRACTOR SHALL NOTIFY THE CITY, CONTACT AT LEAST TWO (2) WORKING DAYS PRIOR TO DELIVERY. CONTRACTOR SHALL PROVIDE ADEQUATE MEANS FOR SAFELY UNLOADING EQUIPMENT.
9.

PULL BOXES SHALL BE NO. 5(E), UNLESS OTHERWISE NOTED ON THE PLANS. PULL BOXES SHALL NOT BE INSTALLED IN CURB RAMPS OR DRIVEWAYS. VANDAL RESISTANT LOCKING LIDS SHALL BE PROVIDED AND INSTALLED BY THE CONTRACTOR AT FINAL INSPECTION OF THE TRAFFIC SIGNAL. CONTRACTOR SHALL PROVIDE TEMPORARY LIDS DURING CONSTRUCTION. ALL PULL BOXES SHALL BE AT A MAXIMUM OF 200' APART. LIDS SHALL BE TORQUED TO 25 FT. LBS.
10.

ALL PULL BOXES INSTALLED IN NON-CONCRETE AREAS SHALL BE SURROUNDED BY A ONE (1) FOOT WIDE CONCRETE COLLAR, TO A DEPTH EQUAL TO THE PULL BOX AND EXTENSION, PER CITY OF FRESNO SPECIFICATIONS, AND SHALL HAVE A VANDAL RESISTANT (SEE NOTE ABOVE) LOCKING LID INSTALLED. ALL CONDUIT ENTRIES INTO ADVANCE DETECTION, INTERMEDIATE DETECTION, AND STREET LIGHTING PULL BOXES INSTALLED IN NON-CONCRETE AREAS SHALL ENTER THE PULL BOX FROM THE BOTTOM, USING 90 DEGREE ELBOWS AND EXTENDING 3 TO 5 INCHES ABOVE THE FINISHED GROUT.
11.

ALL CONDUITS SHALL HAVE BUSHINGS INSTALLED PRIOR TO INSTALLING CONDUCTORS. STEEL CONDUITS SHALL HAVE LAY IN STYLE LUGS THAT ARE CAST INTEGRAL WITH THE BUSHING.
12.

CONDUIT BENDS OF 90 DEGREES ARE PROHIBITED UNLESS OTHERWISE NOTED OR WRITTEN PERMISSION IS GIVEN BY THE CITY OF FOWLER ENGINEER.
13.

ALL NEUTRAL CONDUCTORS SHALL BE WHITE IN COLOR THROUGHOUT THEIR ENTIRE LENGTH.
14.

TRAFFIC SIGNAL CABLE SHALL NOT BE SPLICED BETWEEN THE CONTROLLER CABINET AND THE TERMINAL COMPARTMENTS MOUNTED ON THE POLES. DETECTOR CABLES SHALL NOT BE SPLICED BETWEEN THE CONTROLLER CABINET AND THE PULL BOX ADJACENT TO THE DETECTOR LEAD-IN.
15.

PEDESTRIAN MODULE SHALL BE INSTALLED ON THE LEFT SIDE, FACING THE FRONT, OF THE 332 CABINET.
16.

SEAL CONDUIT WITH AN APPROVED DUCT SEAL AFTER ALL CONDUCTORS HAVE BEEN INSTALLED.
17.

SEALANT FOR FILLING THE SAWCUT LOOPS SLOTS SHALL BE HOT-MELT RUBBERIZED ASPHALT SEALANT PER STATE OF CALIFORNIA SPECIFICATIONS, OR ELASTOMERIC SEALENT, 3M, BLACK 5000.
18.

PEDESTRIAN PUSH BUTTONS SHALL HAVE 2" DIAMETER ACTUATORS AND COMPLY WITH THE AMERICANS WITH DISABILITIES ACT (ADA).
19.

ALL VEHICLE AND PEDESTRIAN SIGNAL SECTIONS SHALL UTILIZE LIGHT EMITTING DIODE (LED) SIGNAL MODULES IN ACCORDANCE WITH THE STANDARD SPECIFICATIONS. VEHICLE SIGNAL SECTIONS SHALL HAVE 12" (300 mm) DIAMETER LENSES WITH BACKPLATES AND TUNNEL VISORS. ALL VEHICLE AND PEDESTRIAN SIGNAL SECTIONS SHALL HAVE METAL AND RUBBER WASHERS INSTALLED ON THE INSIDE OF THE HEAD.
20.

SAFETY LUMINAIRE SHALL BE LED (EQUAL TO 150W HPS), SEE UPDATED CITY OF FRESNO SPECIFICATIONS FOR SAFETY LUMINAIRE REQUIREMENTS.
21.

PEDESTRIAN SIGNAL UNITS SHALL BE FULL SYMBOL, MUTCD COMPLIANT, LED "COUNTDOWN" TYPE WITH 9 INCH NUMERALS; GELCORE MODEL P57-CFF1-01A-18, OR APPROVED EQUAL. SIGNAL ALIGNMENT SHALL BE AS DIRECTED BY THE ENGINEER.
22.

THE CONTRACTOR SHALL FURNISH AND INSTALL A COMPLETE OPTICOM (GTT) EMERGENCY VEHICLE PREEMPTION (EVP) SYSTEM (721 TWO DIRECTION DETECTION, SINGLE CHANNEL) IN ACCORDANCE WITH THE CITY STANDARD SPECIFICATIONS. EVP DETECTOR UNITS SHALL BE INSTALLED ON SIGNAL MAST ARMS AS SHOWN ON THE PLAN, CENTERED OVER THE NUMBER ONE THROUGH LANE, WITH BRACKETS APPROVED BY THE TRAFFIC SIGNAL SUPERVISOR. THE CONTRACTOR SHALL DELIVER THE MODEL 762 DISCRIMINATORS TO THE CITY CORPORATION YARD AT 2101 "G" STREET, FRESNO, AND NOTIFY THE CITY TRAFFIC SIGNAL SHOP, (559) 621-1312, AT LEAST TWO (2) WORKING DAYS PRIOR TO DELIVERY.
23.

CONTRACTOR SHALL SCHEDULE WITH THE CITY OF FRESNO TSSL SHOP AT (559) 621-1312 ALL EQUIPMENT DELIVERIES WHICH REQUIRE TESTING BY THE CITY'S TSSL SHOP. EQUIPMENT SHALL BE DELIVERED BY THE CONTRACTOR ONLY AT A PREARRANGED TIME AND DAY.
24.

THE CONTRACTOR SHALL FURNISH AND INSTALL NEW STREET NAME SIGN ON SMA COMPLETE WITH VARIABLE LENGTH MOUNTING HARDWARE, AS SHOWN ON THE PLAN. FURNISH AND INSTALL NEW MOUNTING BRACKETS AS NECESSARY. SUBMITTALS SHALL BE APPROVED BY THE CITY PRIOR TO ORDERING.
25.

ALL SIGNS SHALL BE 3M-3930HIP TYPE III & IV SERIES REFLECTIVE SHEETING AND BE COVERED WITH 1160A PREMIUM OVERLAY ANTI-GRAFFITI FILM OR AVERY DENNISON T6500 SERIES REFLECTIVE SHEETING AND SHALL BE COVERED WITH AVERY DENNISON OL1000 ANTI-GRAFFITI OVERLAY FILM.
26.

CONDUITS EXITING THE CONTROLLER FOUNDATION AND ENTERING INTO THE CONTROLLER CABINET SHALL BE ALIGNED TO ENTER WITHIN THE TEES SPECIFIED CABINETS WITHOUT ANY MODIFICATIONS TO THE CABINET BASE.
27.

ALL RESURFACING SHALL MATCH EXISTING SURFACES AFTER SIGNAL FACILITIES ARE REMOVED AND/OR RELOCATED.
28.

THE EXISTING TRAFFIC SIGNAL SYSTEM, INCLUDING DETECTION, AND/OR STREET LIGHTING SHALL REMAIN OPERATIONAL DURING CONSTRUCTION, UNLESS OTHERWISE AUTHORIZED IN WRITING BY THE CITY ENGINEER.
29.

ALL LUMINAIRE CIRCUITS SHALL BE FUSED. THE FUSE SHALL BE LOCATED IN THE LUMINAIRE HEAD (5 AMP KTK FUSE IN TRON HEB TYPE FUSE HOLDER).
30.

THE CONTRACTOR SHALL FURNISH AND INSTALL POLE NUMBERS WHEN PG&E INDICATES THE NUMBER. POLE NUMBERS SHALL BE SHOWN ON THE AS BUILT DRAWINGS.
31.

THE CONTRACTOR SHALL FURNISH AND INSTALL A COMPLETE ACCESSIBLE (AUDIBLE) PEDESTRIAN SIGNAL (APS) SYSTEM (2-WIRE POLARA NAVIGATOR OR APPROVED EQUAL) IN CONFORMANCE WITH THE CITY OF FRESNO STANDARD SPECIFICATIONS. THE APS SHALL PROVIDE BOTH A VIBRATING ARROW BUTTON AND AUDIBLE SOUNDS DURING THE "WALK" INTERVAL, AS WELL AS A LOCATING TONE DURING THE PEDESTRIAN CLEARANCE AND DON'T WALK INTERVALS. THE APS SYSTEM SHALL MEET CURRENT ADA AND CA-MUTCD REQUIREMENTS. ALL PEDESTRIAN PUSH BUTTONS SHALL HAVE A FOUR FOOT ACCESSIBLE PATH IN FRONT OF THE BUTTON. THE APS CENTRAL CONTROL UNIT (CCU) SHALL BE MOUNTED WITH A CITY-APPROVED MANUFACTURED BRACKET, MCCAIN M49021 OR APPROVED EQUAL. CCU SHALL BE MOUNTED TO THE REAR RACK, IN THE UPPER LEFT CORNER WHEN VIEWED FROM THE FRONT OF THE CABINET. THE POWER SUPPLY PIGTAIL SHALL BE CUT TO LENGTH TO ELIMINATE EXCESS CABLE, WITH POWER OBTAINED FROM THE PDA T1 TERMINAL STRIP. TERMINALS 1, 3, & 5. CONTRACTOR SHALL PROVIDE CITY OF FRESNO TSSL THE LATEST MEANS OF PROGRAMMING THE APS SYSTEM AND DIGITAL COPIES OF THE CUSTOM AUDIO VIA EMAIL.

CONSTRUCTION NOTES (SHEETS E-13 TO E-16 ONLY):

1.

ALL PULL BOXES ACCESSED BY CONTRACTOR SHALL BE CLEANED OF ALL DIRT AND DEBRIS, ANY CRACKS GROUTED AND ALL CONDUITS DUCT SEALED.
2.

ALL PULLBOXES SHALL BE LEVELED TO FINISH GRADE (NEW AND EXISTING).
3.

ALL PULLBOXES IN DIRT AREAS SHALL HAVE 1' COLLAR PER GENERAL NOTE 10 (NEW).
4.

ANY PULLBOXES BROKEN/DAMAGED BY CONTRACTOR SHALL BE REPLACED.
5.

ALL PULLBOXES SHALL HAVE LOCKING LIDS. TRAFFIC RATED LIDS SHALL BE WELDED CLOSED AFTER FINAL INSPECTION.
6.

ALL UNUSED CONDUCTORS SHALL BE REMOVED.

		DATE	RECORD DRAWING		 CALL BEFORE YOU DIG	 516 W. SHAW AVE., STE. 103 FRESNO, CA 93704 PHONE: (559) 570-8991 EMAIL: info@JLBtraffic.com		PROJECT			DEPARTMENT OF PUBLIC WORKS AND PLANNING	
DESIGNED:	J. BENAVIDES	03/22/2021	RESIDENT ENGINEER	DATE				GOLDEN STATE CORRIDOR - ECONOMIC DEVELOPMENT AND INFRASTRUCTURE IMPROVEMENTS			GOLDEN STATE BLVD AT MANNING AVE LEGEND AND NOTES	
DRAWN:	C. AYALA-MAGANA	03/22/2021										
CHECKED:	J. RIOS	03/22/2021										
FOR RIGHT OF WAY DATA AND ACCURATE ACCESS DETERMINATION, SEE DOCUMENTS IN THE DEPARTMENT OF PUBLIC WORKS AND PLANNING.												
							FOWLER REGION		DRAWING NO. E-14 SHEET NO. 121 TOTAL 142			

CAD USER: CAYALA
 PLOT DATE: 3/22/2021 3:46:47 PM
 PATH: Z:\01 Projects\009-009 Golden State PS&E\Traffic Signal Designs\2d Golden State Blvd at Manning Ave\Golden State Blvd at Manning Ave.dwg

CONDUCTOR SCHEDULE																			
AWG OR CABLE	POLE	Ø	CONDUIT RUN NUMBER AND SIZE																
			1	2	3	4	5	6	7	8	9	10	11	12	13	14	15	16	
			2-4"	2-4"	4"	4"	3"	2.5"	2"	4"	3"	3"	4"	3"	4"	2"	2"	2"	
CONDUIT FILL			20%	20%	12%	11%	8%	11%	7%	11%	25%	25%	19%	16%	29%	4%	14%	13%	
7 COND. CABLE (VEH.) *	A	1,2,4 2P,4P	1(1) 1	1(1) 1										1(1) 1	1(1) 1				
	C'	1,6 -	(1) -	(1) -	(1) -	(1) -													
	D	3,4 4P	1 (1)	1 (1)	1 (1)	1 (1)	1 (1)												
	E	3,7 -	1 -	1 -	1 -	1 -	1 -												
	F	5,6,8 8P	(2) (1)	(2) (1)						(2) (1)	(2) (1)	(2) (1)	(2) (1)		(2) (1)				
	I'	2,5 2P	(1) (1)	(1) (1)							(1) (1)	(1) (1)	(1) (1)		(1) (1)				
	K	7,8 8P	1 1	1 1									1 1		1 1				
	L	3,7 -	1 -	1 -											1 -				
TOTAL			5(5) 2(3)	5(5) 2(3)	2(1) (1)	2(1) (1)	1 (1)	1 -			(2) (1)	(3) (2)	(3) (2)	1(3) 1(2)	1(1) 1	3(4) 2(2)			
3 COND. CABLE (PPB)	A	2P, 4P	1	1										1	1				
	C'	4P	(1)	(1)	(1)	(1)													
	F	8P	(1)	(1)						(1)	(1)	(1)	(1)		(1)				
	I'	2P, 8P	(1)	(1)							(1)	(1)	(1)		(1)				
TOTAL			1(3)	1(3)	(1)	(1)					(1)	(2)	(2)	(2)	1	1(2)			
TYPE C DETECTOR LEAD-IN CABLE	Ø1		(3)	(3)							(3)	(3)	(3)	(3)		(3)			
	Ø2		4(1)	4(1)											4	4			
	Ø3		2	2												2			
	Ø4		3(1)	3(1)	3(1)	3(1)	3	(1)	(1)										
	Ø5		(2)	(2)	(2)														
	Ø6		(5)	(5)							(5)	(5)	(5)	(5)		(5)			
	Ø7		(2)	(2)	(2)	(2)		(2)											
	Ø8		5	5										4		5			
	PED PUSH BUTTON											1	1						
	RR PRE-EMPTION		1	1	1	1											1		
TOTAL DLC			15(14)	15(14)	4(5)	4(3)	3	(3)	(1)	(8)	1(8)	1(8)	4(8)	4	11(8)	1			
# 2	SERVICE																		3
# 4	SIGNAL POWER																	2	
# 8	SAFETY LIGHTS		2	2	2	2		2	2	(2)	2	2	2	2	2		2		
# 8	BONDING WIRE		1	1	1	1	1	1	1	(1)	1	1	1	1	1	1	1		
# 12	PEU CONTROL		(3)	(3)										(3)	(3)		(3)		
EVP CABLE 3 COND.	EVA (S/B)		(1)	(1)							(1)	(1)	(1)		(1)				
	EVV (W/B)		(1)	(1)										(1)	(1)				
	EVC (N/B)		(1)	(1)	(1)	(1)													
	EVD (E/B)		(1)	(1)							(1)	(1)	(1)	(1)		(1)			

* NUMBER INDICATIONS ARE THE NUMBER OF CABLES WITHIN CONDUIT.
 ALL CONDUITS AND CONDUCTORS ARE EXISTING UNLESS OTHERWISE INDICATED WITH "()".


EQUIPMENT SCHEDULE														
No.	STANDARD			VEH SIG MTG		PED SIGNAL		PPB		LED LUMINAIRE WATTAGE	PG&E POLE #	SPECIAL REQUIREMENTS		
	Type	Sig.	M.A.	Lum.M.A.	Mast Arm	Pole	Ø	MTG	Ø	ARROW				
A	17-1-70	20'	12'	MAS	SV-3-TB (N)	2 (N) 4 (N)	SP-2-T (N)	-	-	168W	44163	EXISTING SIGNAL STANDARD WITH SNS "GOLDEN STATE BLVD" TO REMAIN. REMOVE AND SALVAGE ALL EXISTING VEHICLE HEADS AND PEDESTRIAN HEADS ATTACHED TO POLE. FURNISH AND INSTALL NEW VEHICLE HEADS AND PEDESTRIAN HEADS ON POLE COMPLETE WITH MOUNTING HARDWARE. FURNISH AND INSTALL EVB ON SMA COMPLETE WITH MOUNTING HARDWARE. FURNISH AND INSTALL PEC ON TOP OF POLE REMOVE AND SALVAGE EXISTING 1-A POLE AND ALL EQUIPMENT ATTACHED TO IT.		
B	1-A (10')	-	-	-	LT-2-T	-	-	-	-	-	-			
C	17D-1-113	18'	12'	MAS	SV-1-T	-	-	4	LEFT	149W	24611	REMOVE AND SALVAGE EXISTING POLE AND ALL EQUIPMENT ATTACHED TO IT. POLE TYPE LISTED IS AN ESTIMATION.		
C'	61-5-129 (N)	60' (N)	15' (N)	(N) MAT (N) MAS _{F=27'}	SV-1-T (N)	-	-	4 (N)	LEFT (N)	78W (N)	24611 (N)	POLE SHALL BE INSTALLED 12 DEGREES CLOCKWISE AS SHOWN ON PLANS. FURNISH AND INSTALL EVC AND R73-5 (CA) SIGN ON SMA COMPLETE WITH MOUNTING HARDWARE. FURNISH AND INSTALL SNS "MANNING AVE" ON POLE COMPLETE WITH MOUNTING HARDWARE.		
D	1-A (10')	-	-	-	TV-2-T	4 (N)	SP-1-T (N)	-	-	-	-	REMOVE AND SALVAGE EXISTING PEDESTRIAN SIGNAL HEAD. FURNISH AND INSTALL NEW PEDESTRIAN SIGNAL HEAD COMPLETE WITH MOUNTING HARDWARE.		
E	1-A (10')	-	-	-	LT-2-T	-	-	-	-	-	-			
F	17B-1-113	20'	12'	MAS	SV-3-TA (N)	8 (N)	SP-1-T (N)	-	-	168W	24615 44164	EXISTING SIGNAL STANDARD WITH SNS "GOLDEN STATE BLVD" TO REMAIN. REMOVE AND SALVAGE ALL EXISTING VEHICLE HEADS AND PEDESTRIAN HEAD ATTACHED TO POLE. FURNISH AND INSTALL NEW VEHICLE HEADS AND PEDESTRIAN HEAD ON POLE COMPLETE WITH MOUNTING HARDWARE. FURNISH AND INSTALL EVD ON SMA COMPLETE WITH MOUNTING HARDWARE. POLE TYPE LISTED IS AN ESTIMATION.		
G	PPB POST (2 1/2")	-	-	-	-	-	-	8 (N)	LEFT (N)	-	-	EXISTING PPB POST TO REMAIN. REMOVE AND SALVAGE PPB ASSEMBLY. FURNISH AND INSTALL APS PPB ASSEMBLY.		
H	1-A (10')	-	-	-	LT-2-T	-	-	-	-	-	-	REMOVE AND SALVAGE EXISTING 1-A POLE AND ALL EQUIPMENT ATTACHED TO IT.		
I	16-1-113	15'	12'	MAS	SV-1-T	2	SP-1-T		-	149W	XXXXX	REMOVE AND SALVAGE EXISTING POLE AND ALL EQUIPMENT ATTACHED TO IT. POLE TYPE LISTED IS AN ESTIMATION.		
I'	29-5-113 (N)	50' (N)	15' (N)	(N) MAT (N) MAS _{F=20'}	SV-1-T (N)	2 (N)	SP-1-T (N)	-	-	78W (N)	XXXXX (N)	FURNISH AND INSTALL EVA ON SMA COMPLETE WITH MOUNTING HARDWARE. FURNISH AND INSTALL SNS "MANNING AVE" ON SIGNAL POLE COMPLETE WITH MOUNTING HARDWARE.		
J	PPB POST (2 1/2")	-	-	-	-	-	-	8 (N)	LEFT (N)	-	-	EXISTING PPB POST TO REMAIN. REMOVE AND SALVAGE PPB ASSEMBLY. FURNISH AND INSTALL APS PPB ASSEMBLY.		
K	1-A (10')	-	-	-	TV-2-T	8 (N)	SP-1-T (N)	2 (N)	RIGHT (N)	-	-	REMOVE AND SALVAGE EXISTING Ø8 VEHICLE HEAD, PEDESTRIAN SIGNAL HEAD, AND PPB ASSEMBLY. FURNISH AND INSTALL NEW Ø8 VEHICLE HEAD, PEDESTRIAN SIGNAL HEAD AND APS PPB ASSEMBLY COMPLETE WITH MOUNTING HARDWARE.		
L	1-A (10')	-	-	-	LT-2-T	-	-	-	-	-	-			
M	PPB POST (2 1/2")	-	-	-	-	-	-	2 (N)	RIGHT (N)	-	-	EXISTING PPB POST TO REMAIN. REMOVE AND SALVAGE PPB ASSEMBLY. FURNISH AND INSTALL APS PPB ASSEMBLY.		
N	PPB POST (2 1/2")	-	-	-	-	-	-	4 (N)	RIGHT (N)	-	-	EXISTING PPB POST TO REMAIN. REMOVE AND SALVAGE PPB ASSEMBLY. FURNISH AND INSTALL APS PPB ASSEMBLY.		
O	1-A-FBS	-	-	-	-	-	-	-	-	-	-	REMOVE AND SALVAGE EXISTING FBS AND ALL EQUIPMENT ATTACHED TO IT.		
P	1-A-FBS	-	-	-	-	-	-	-	-	-	-	REMOVE AND SALVAGE EXISTING FBS AND ALL EQUIPMENT ATTACHED TO IT.		

NOTES:


- ALL EQUIPMENT IS EXISTING UNLESS OTHERWISE NOTED WITH (N).
- ALL INDICATIONS SHALL BE 12" LED MODULES.
- STREET NAME SIGNS SHALL BE WHITE LETTERS ON GREEN BACKGROUND, 12" UPPERCASE, 9" LOWERCASE, 4" BLOCK NUMBERS, 4" WIDE ARROWS, SERIES "D" TEXT ON TYPE XI DIAMOND GRADE SHEETING AND 3M TYPE XI DG3 OR APPROVED EQUAL.
- LED INTERSECTION SAFETY LIGHT LUMINAIRES INSTALLED AND SHALL BE CREE RSW5-A-HT-3ME-6L-40K7-UL-GY-N FULL POWER: 78W, 9325 LUMEN, 4000K, CRI70-B1-U0-G2, RSW59056&SP.

DESIGNED: J. BENAVIDES		DATE: 03/22/2021	RECORD DRAWING	
DRAWN: C. AYALA-MAGANA		DATE: 03/22/2021	RESIDENT ENGINEER	DATE
CHECKED: J. RIOS		DATE: 03/22/2021		
FOR RIGHT OF WAY DATA AND ACCURATE ACCESS DETERMINATION, SEE DOCUMENTS IN THE DEPARTMENT OF PUBLIC WORKS AND PLANNING.				



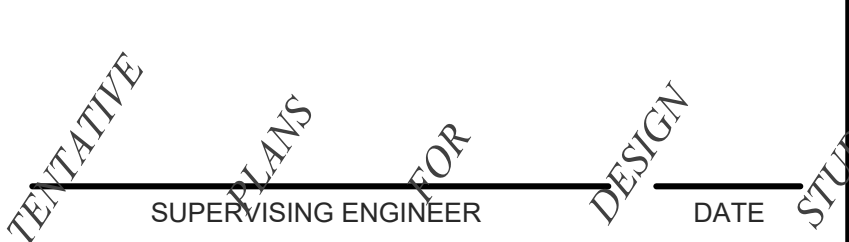


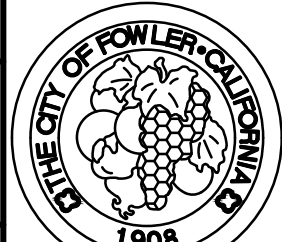

PROJECT	
GOLDEN STATE CORRIDOR - ECONOMIC DEVELOPMENT AND INFRASTRUCTURE IMPROVEMENTS	
FOWLER REGION	




DEPARTMENT OF PUBLIC WORKS AND PLANNING			
GOLDEN STATE BLVD AT MANNING AVE EQUIPMENT AND CONDUCTOR SCHEDULE			
DRAWING NO.	E-15	SHEET NO.	122
TOTAL		142	

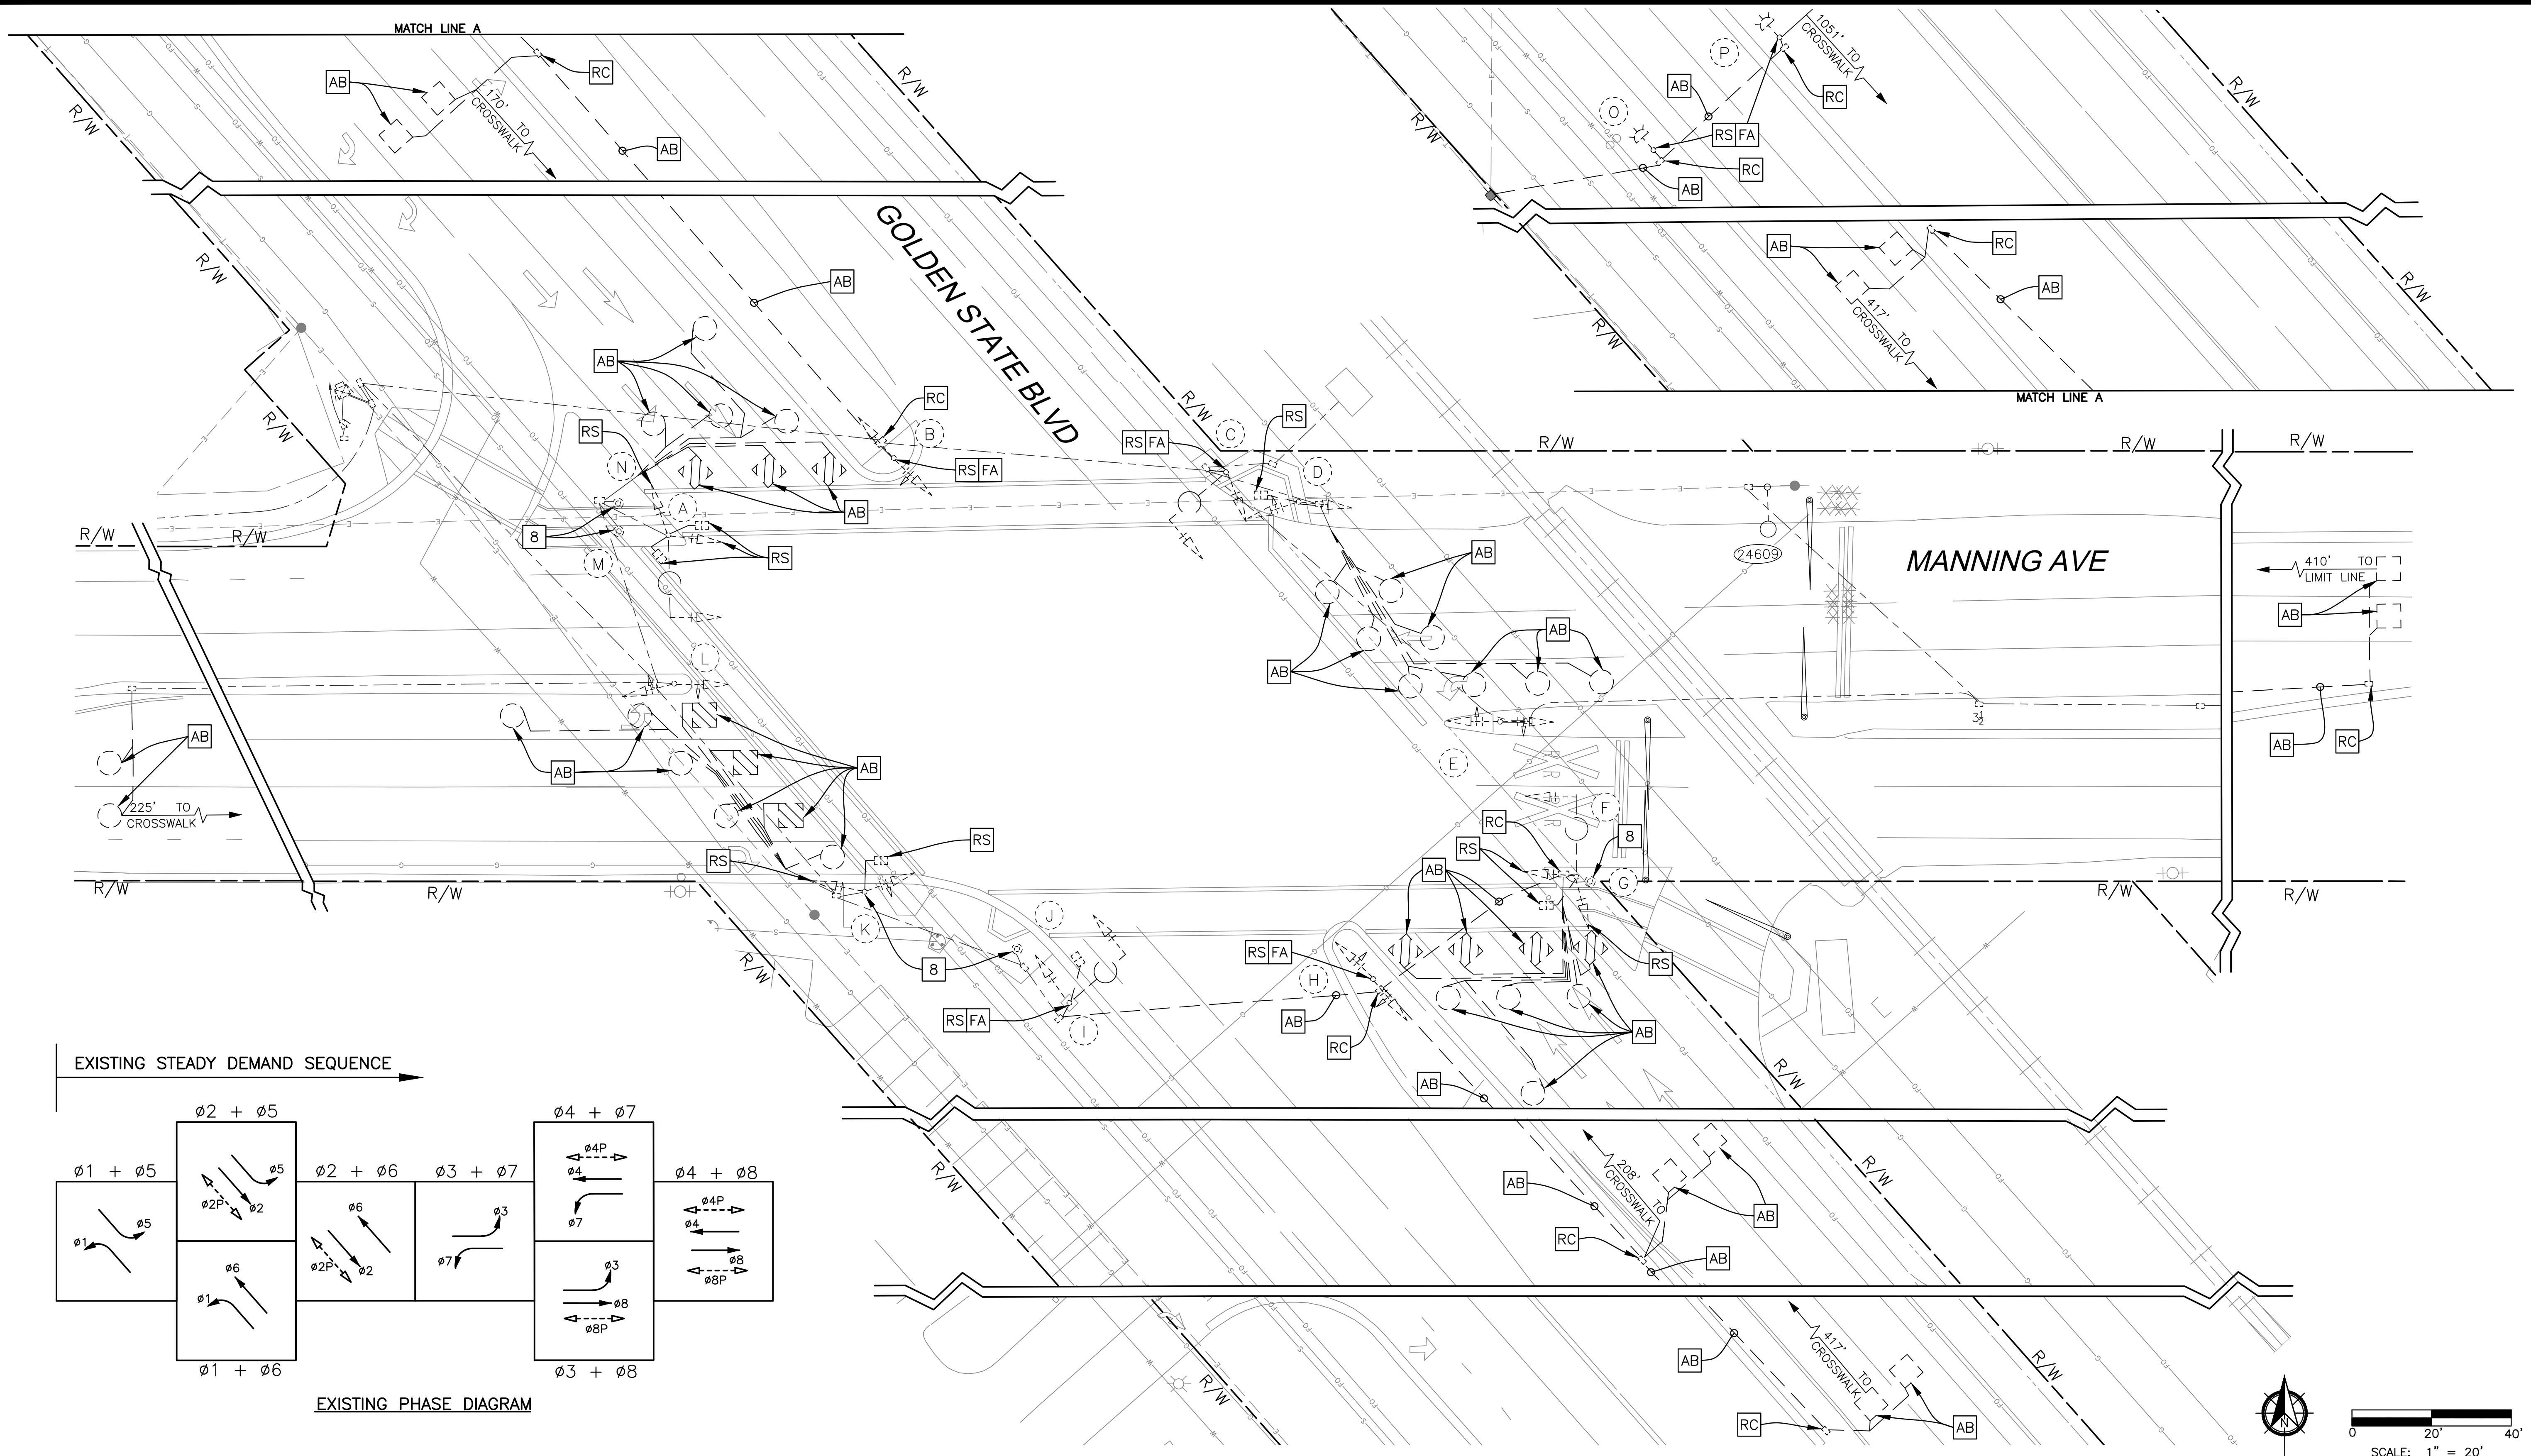CAD USER: CAYALA
PLOT DATE: 3/22/2021 9:40:16 AM
PATH: Z:\01 Projects\009 Golden State Blvd at Manning Ave\Golden State Blvd at Manning Ave\Golden State Blvd at Manning Ave.dwg



EXISTING STEADY DEMAND SEQUENCE

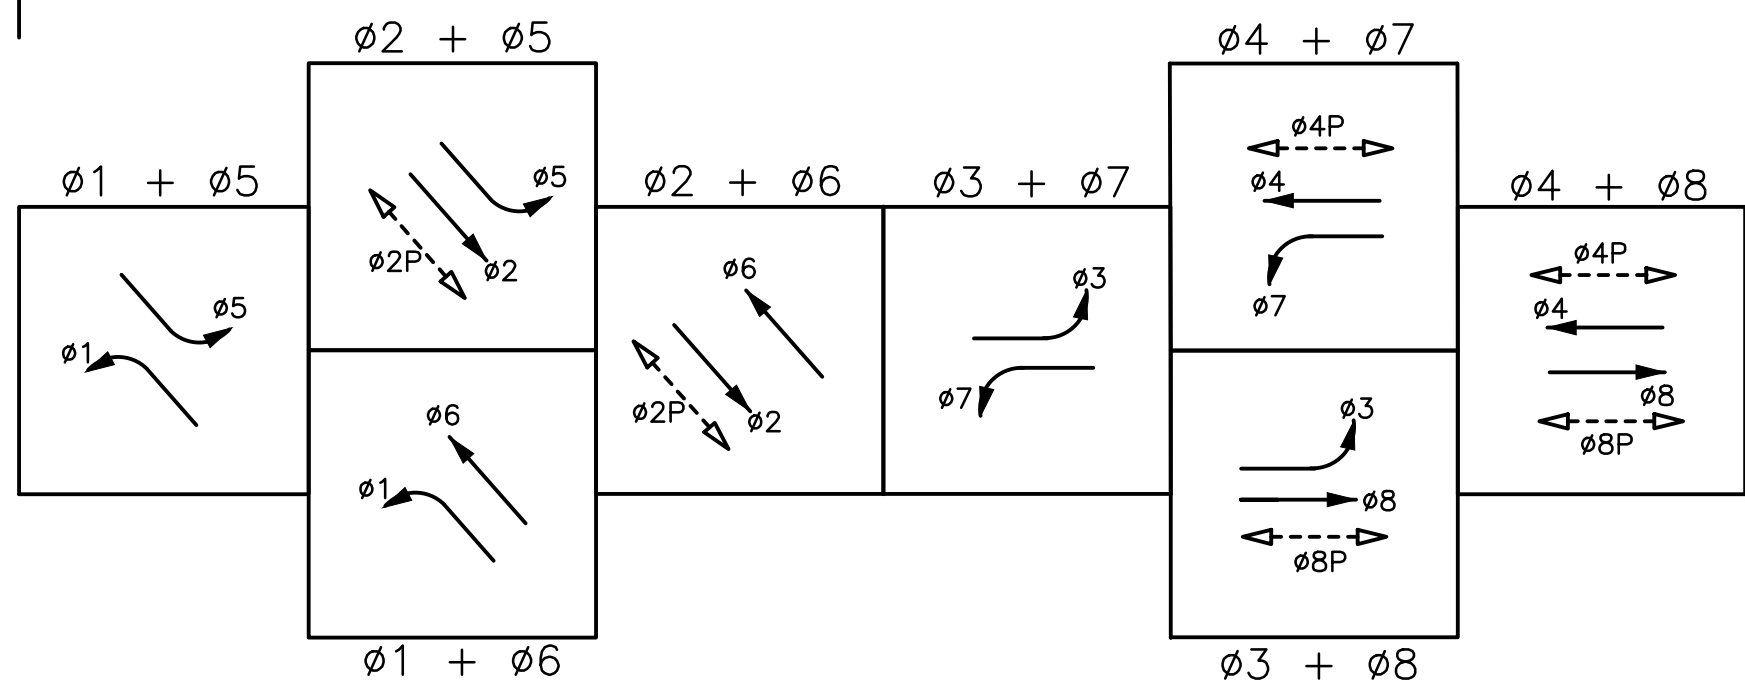

EXISTING PHASE DIAGRAM

DESIGNED:	DATE	RECORD DRAWING	
J. BENAVIDES	03/22/2021	RESIDENT ENGINEER	DATE
DRAWN:	03/22/2021		
C. AYALA-MAGANA	03/22/2021		
CHECKED:	03/22/2021		
J. RIOS	03/22/2021		

FOR RIGHT OF WAY DATA AND ACCURATE ACCESS DETERMINATION, SEE DOCUMENTS IN THE DEPARTMENT OF PUBLIC WORKS AND PLANNING.




JLB TRAFFIC
ENGINEERING, INC.
516 W. SHAW AVE., STE. 103
FRESNO, CA 93704
PHONE: (559) 570-8991
EMAIL: info@JLBtraffic.com

TENTATIVE PLANS FOR DESIGN
SUPERVISING ENGINEER
DATE




PROJECT
GOLDEN STATE CORRIDOR - ECONOMIC DEVELOPMENT
AND INFRASTRUCTURE IMPROVEMENTS
FOWLER REGION

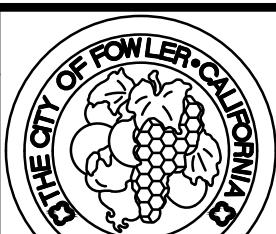

DEPARTMENT OF PUBLIC WORKS AND PLANNING
GOLDEN STATE BLVD AT MANNING AVE
TRAFFIC SIGNAL DEMOLITION PLAN

DRAWING NO. E-16 SHEET NO. 123 TOTAL 142




PATH: Z:\01 Projects\009-Fresno County\009-009 Golden State Blvd at Temperance Ave\Golden State Blvd at Temperance Ave.dwg PLOT DATE: 3/19/2021 3:06:15 PM CAD USER: CAYALA

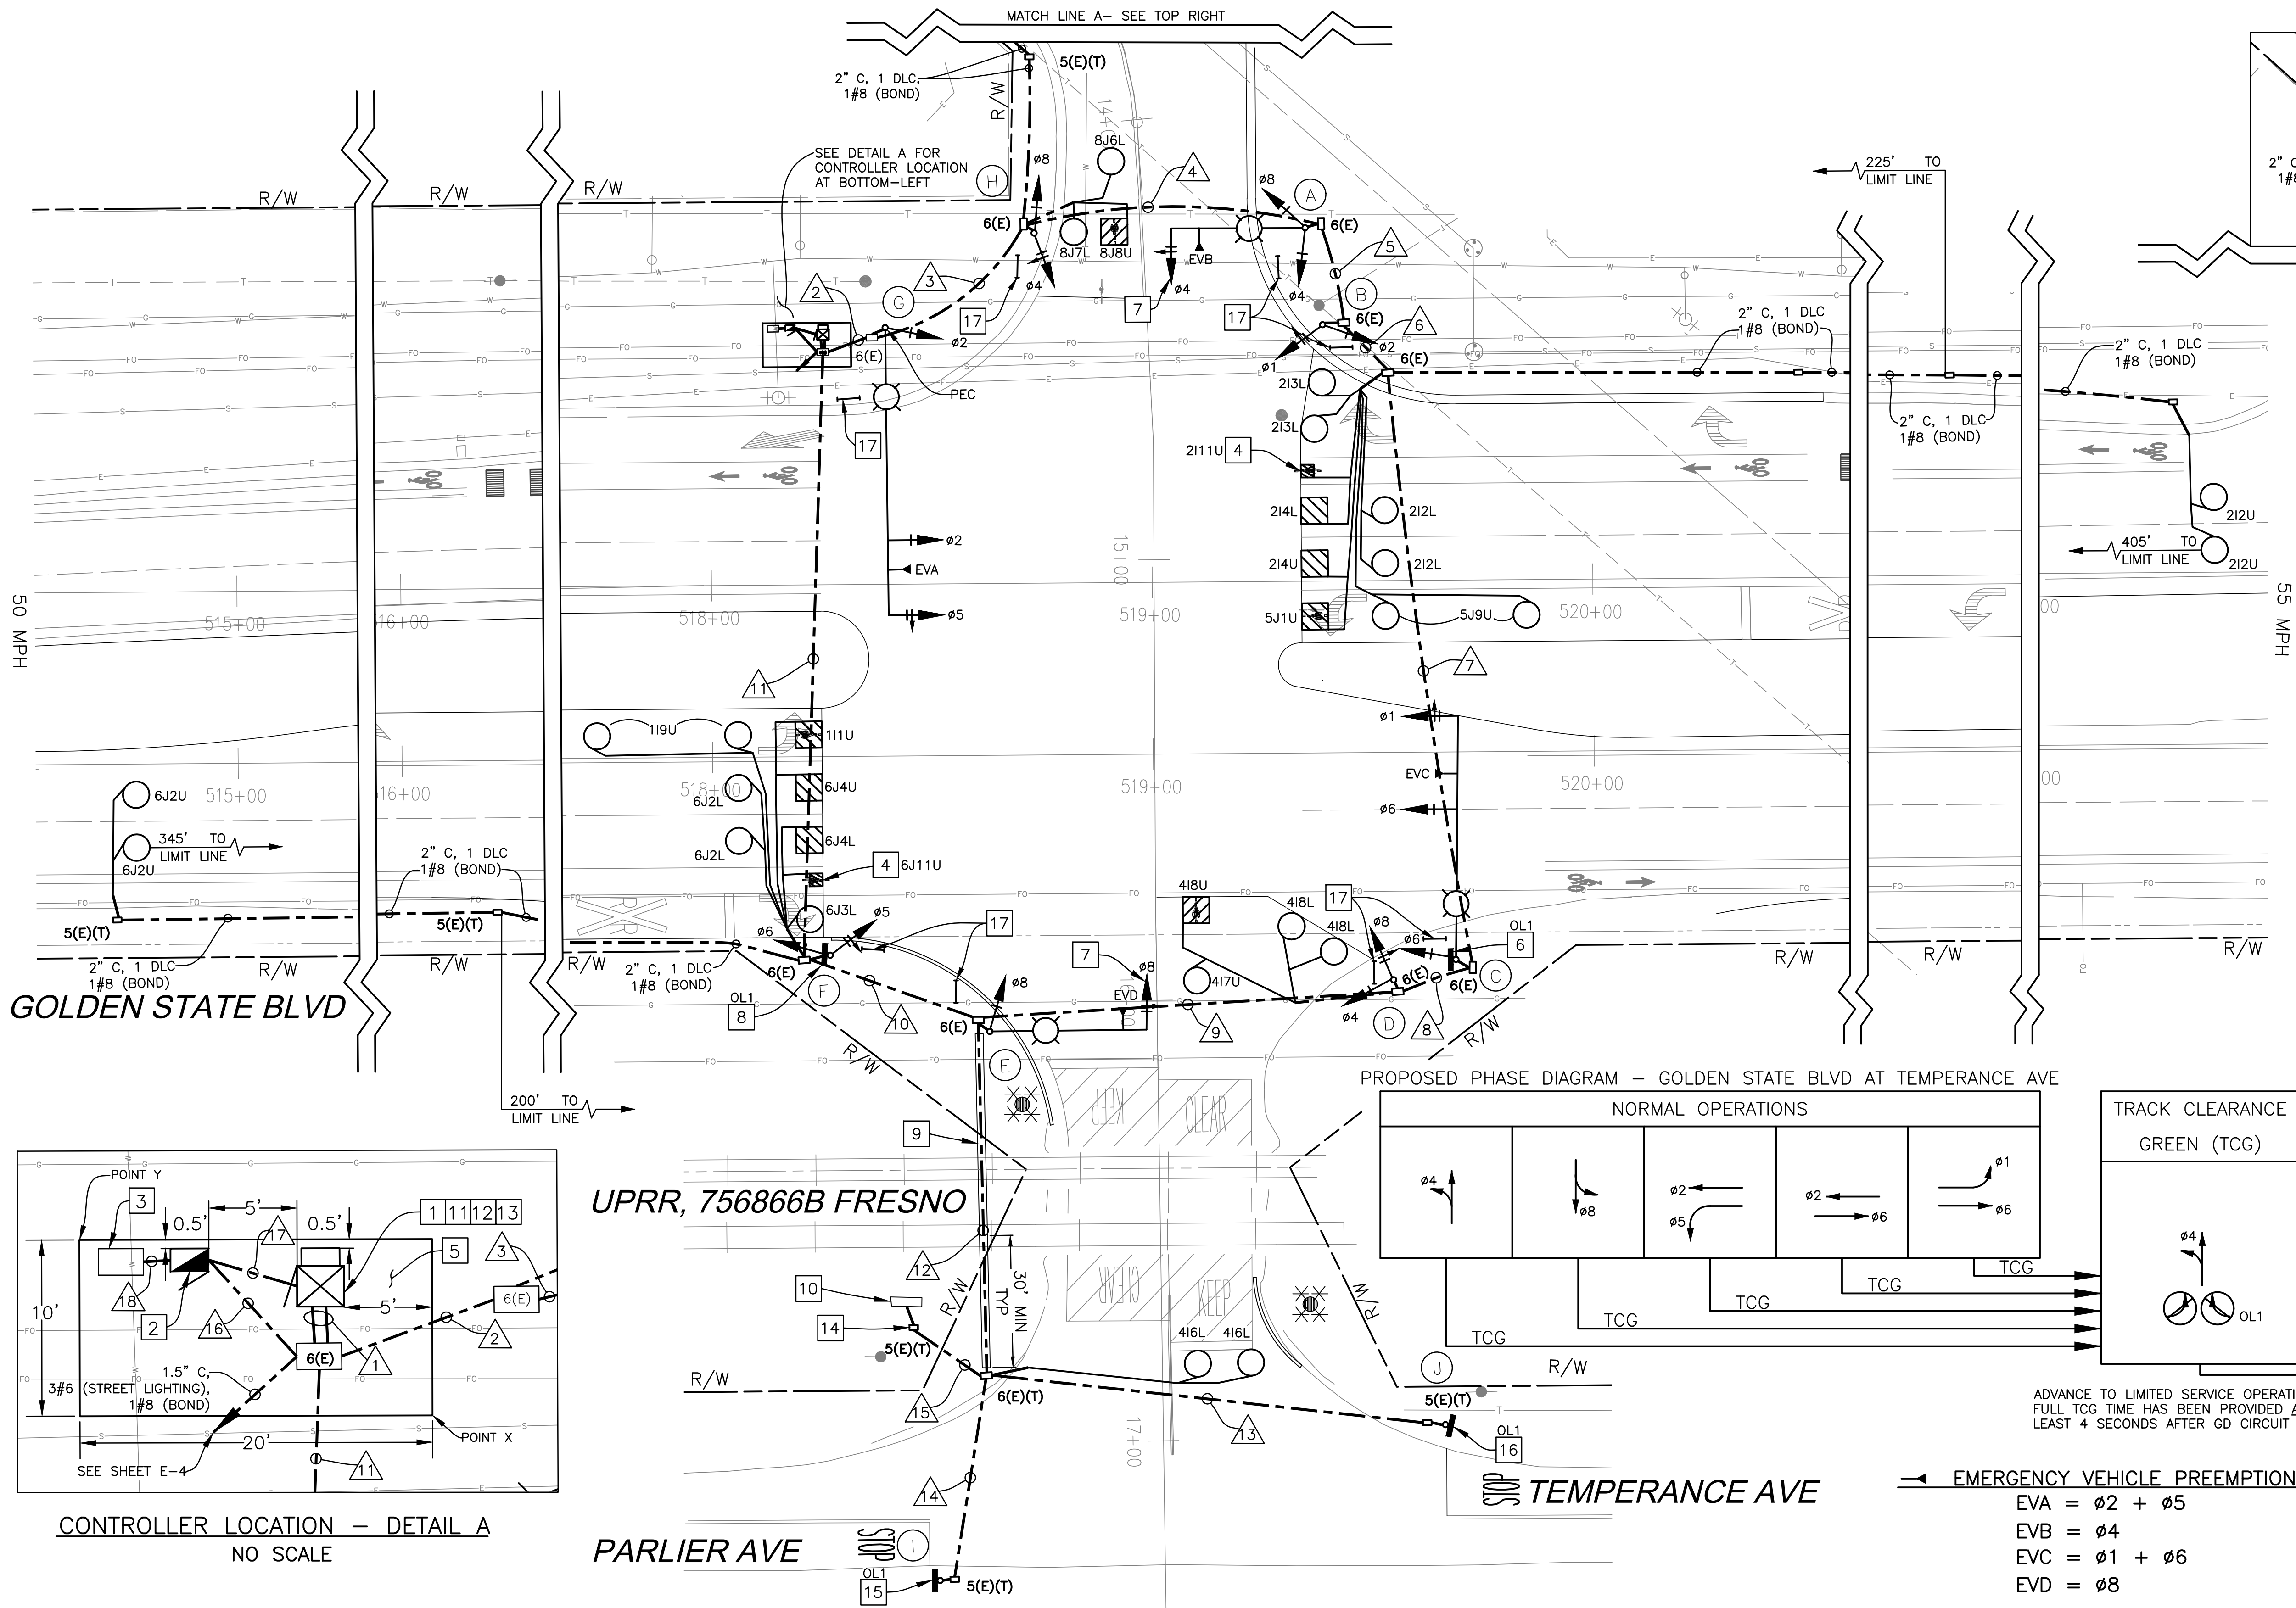

POLE PLACEMENT LOCATION			
POLE	LOCATION		DIRECTION
(A)	GOLDEN STATE BLVD	STA 519 + 35.31, 80.21' L	SB
(B)	GOLDEN STATE BLVD	STA 519 + 39.12, 58.20' L	SB
(C)	GOLDEN STATE BLVD	STA 519 + 68.32, 47.11' R	NB
(D)	GOLDEN STATE BLVD	STA 519 + 54.15, 51.62' R	NB
(E)	GOLDEN STATE BLVD	STA 518 + 62.46, 62.69' R	NB
(F)	GOLDEN STATE BLVD	STA 518 + 26.34, 45.11' R	NB
(G)	GOLDEN STATE BLVD	STA 518 + 39.86, 58.27' L	SB
(H)	GOLDEN STATE BLVD	STA 518 + 73.83, 79.46' L	SB
(I)	***		
(J)	GOLDEN STATE BLVD	STA 519 + 65.17, 152.66' R	NB
POINT X	GOLDEN STATE BLVD	STA 518 + 32.05, 49.47' L	SB
POINT Y	GOLDEN STATE BLVD	STA 518 + 12.05, 59.47' L	SB

*** = POLE TO BE PLACED A MINIMUM OF 3 FEET FROM THE EDGE OF PAVEMENT AND ALIGNED WITH THE EXISTING ROW OF CROP IN ORDER TO MINIMIZE THE LIKELIHOOD OF IT BEING ACCIDENTALLY DAMAGED.

PROPOSED PHASE DIAGRAM - GOLDEN STATE BLVD AT TEMPERANCE AVE

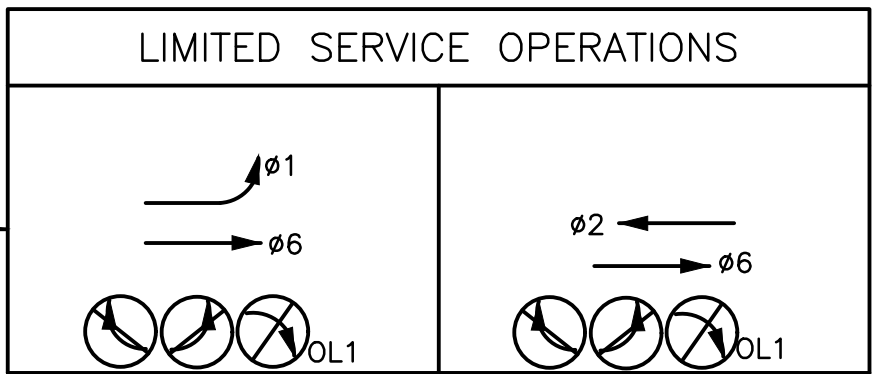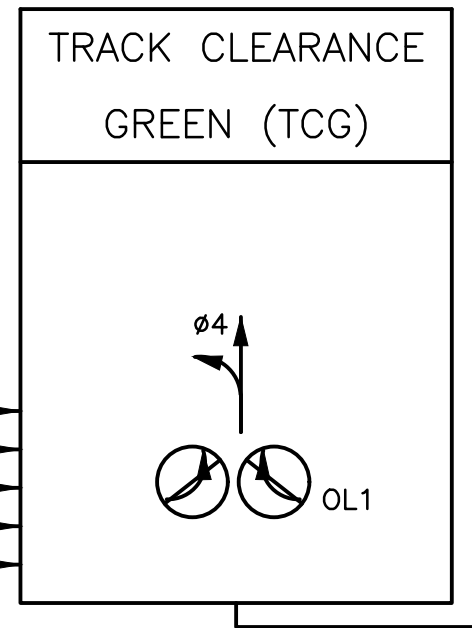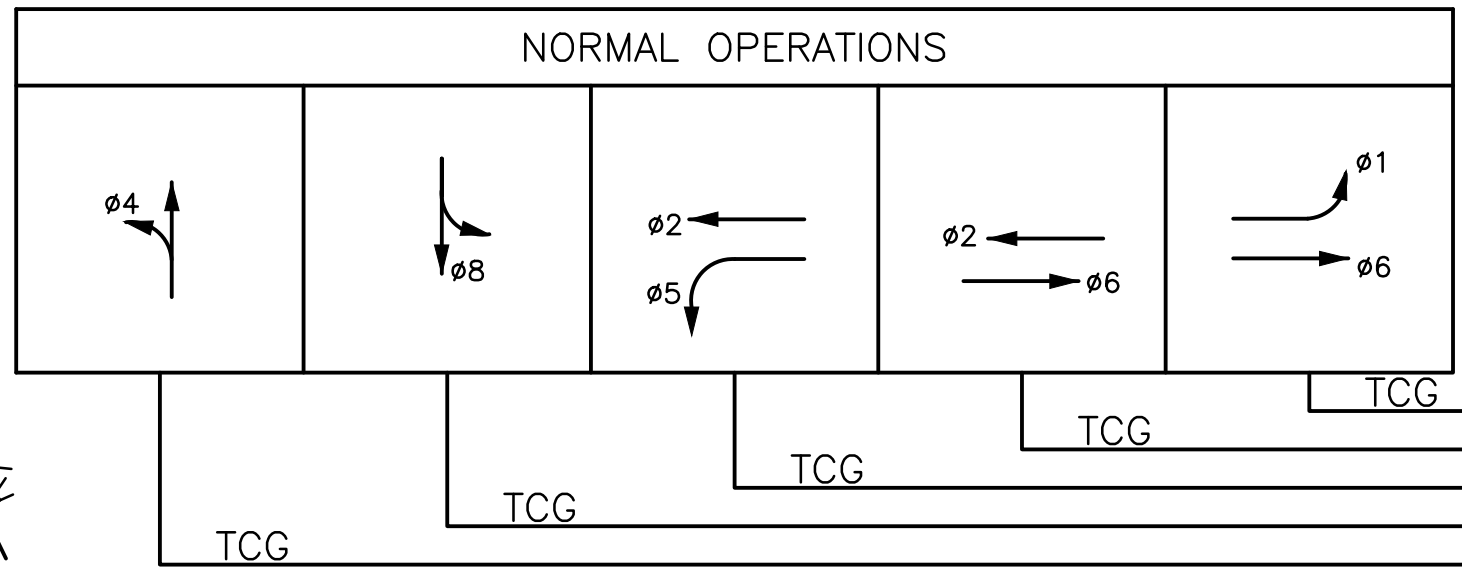


TCR = TRAFFIC CONTROL RELAY. PROVIDES ADVANCED PREEMPTION NOTIFICATION.
XR = CROSSING RELAY. PROVIDES NOTIFICATION THAT GRADE CROSSING WARNING DEVICES HAVE BEEN ACTIVATED.
GD = GATE DOWN RELAY. PROVIDES NOTIFICATION THAT RR ENTRANCE GATE DESCENT IS ALMOST COMPLETE.

* = "NO LEFT-TURN" BLANKOUT SIGN IS ILLUMINATED WHILE XR CIRCUIT IS ACTIVE.
= "NO RIGHT-TURN" BLANKOUT SIGN IS ILLUMINATED WHILE XR CIRCUIT IS ACTIVE.

ADVANCE TO LIMITED SERVICE OPERATIONS WHEN FULL TCG TIME HAS BEEN PROVIDED AND AT LEAST 4 SECONDS AFTER GD CIRCUIT CLOSURES.

EMERGENCY VEHICLE PREEMPTION (EVP)

EVA = ø2 + ø5
EVB = ø4
EVC = ø1 + ø6
EVD = ø8

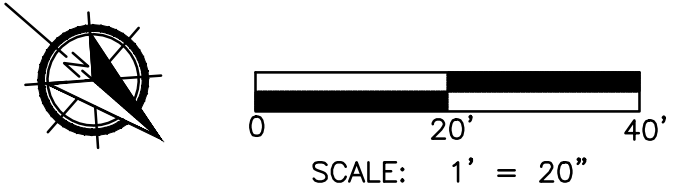

CONTROLLER LOCATION - DETAIL A
NO SCALE

UPRR, 756866B FRESNO

PARLIER AVE

TEMPERANCE AVE

DESIGNED:	DATE	RECORD DRAWING	
J. BENAVIDES	03/19/2021	RESIDENT ENGINEER	DATE
DRAWN:	03/19/2021		
C. AYALA-MAGANA	03/19/2021		
CHECKED:	03/19/2021		
J. RIOS	03/19/2021		

FOR RIGHT OF WAY DATA AND ACCURATE ACCESS DETERMINATION, SEE DOCUMENTS IN THE DEPARTMENT OF PUBLIC WORKS AND PLANNING.




JLB TRAFFIC
ENGINEERING, INC.
516 W. SHAW AVE. STE. 103
FRESNO, CA 93704
PHONE: (559) 570-8991
EMAIL: info@JLBTraffic.com

TENTATIVE PLANS FOR DESIGN
SUPERVISING ENGINEER
DATE



PROJECT
GOLDEN STATE CORRIDOR - ECONOMIC DEVELOPMENT AND INFRASTRUCTURE IMPROVEMENTS
FOWLER REGION

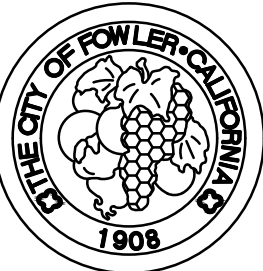

DEPARTMENT OF PUBLIC WORKS AND PLANNING
GOLDEN STATE BLVD AT TEMPERANCE AVE
TRAFFIC SIGNAL PLAN
DRAWING NO. E-17
SHEET NO. 124
TOTAL 142

CAD USER: CAYALA
 PLOT DATE: 3/19/2021 3:06:39 PM
 PATH: Z:\01 Projects\009 Fresno County\009 Golden State Blvd at Temperance Ave.dwg
 PROJECT: 009 Golden State PS&E\Traffic Signal Designs\Tb_Golden State Blvd at Temperance Ave.dwg

CONDUCTOR SCHEDULE																					
AWG OR CABLE	POLE	Ø	CONDUIT RUN NUMBER AND SIZE																		
			1	2	3	4	5	6	7	8	9	10	11	12	13	14	15	16	17	18	
			2-4"	4"	4"	4"	4"	4"	4"	3"	3"	4"	4"	3"	3"	3"	2"	2"	1.5"	2"	
CONDUIT FILL			16%	20%	18%	14%	12%	11%	6%	7%	1%	8%	14%	8%	1%	1%	13%	15%	14%	13%	
7 COND. CABLE (VEH.) *	A	4,8 -	1 -	1 -	1 -	1 -															
	B	1,2 -	1 -	1 -	1 -	1 -															
	C	1,6 -	1 -	1 -	1 -	1 -	1 -	1 -													
	D	4,8 -	1 -	1 -	1 -	1 -	1 -	1 -	1 -												
	E	8 -	1 -								1 -	1 -									
	F	5,6 -	1 -									1 -									
	G	2,5 -	1 -	1 -																	
	H	4,8 -	1 -	1 -	1 -																
TOTAL			8 -	6 -	5 -	4 -	3 -	2 -	2 -	1 -		1 -	2 -								
TYPE C DETECTOR LEAD-IN CABLE	Ø1		2										2								
	Ø2		6	6	6	6	6														
	Ø4		4	3	3	3	3	3	3		1	1	1								
	Ø5		2	2	2	2	2	2													
	Ø6		6									6									
	Ø8		4	4	4																
	TOTAL DLC		24	15	15	11	11	11	3	3		1	9	1							
# 2	SERVICE																		3		
# 4	SIGNAL POWER																	2			
# 6	STREET LIGHTING																3				
# 8	SAFETY LIGHTS		2	2	2	2	2	2			2	2					2				
# 8	BONDING WIRE	1	1	1	1	1	1	1	1	1	1	1	1	1	1	1	1	1			
#12	PEU CONTROL		3														3				
#14	BLANK OUT SIGN	8							2	2	6	8	4	2	2						
12 COND. CABLE (#14 AWG)	RR PRE-EMPTION	1									1	1	1			1					
EVP CABLE 3 COND.	EVA (S/B)	1	1																		
	EVb (W/B)	1	1	1	1																
	EVC (N/B)	1	1	1	1	1	1	1			1	1									
	EVD (E/B)	1										1	1								



* NUMBER INDICATIONS ARE THE NUMBER OF CABLES WITHIN CONDUIT.
 ALL CONDUCTORS ARE NEW UNLESS OTHERWISE INDICATED WITH "()".

EQUIPMENT SCHEDULE												
No.	STANDARD			VEH SIG MTG		PED SIGNAL		PPB		LED LUMINAIRE WATTAGE	PG&E POLE #	SPECIAL REQUIREMENTS
	Type	Sig. M.A.	Lum.M.A.	Mast Arm	Pole	Ø	MTG	Ø	ARROW			
(A)	19-3-113	30'	15'	MAT	SV-2-T	-	-	-	-	78W	XXXXX	FURNISH AND INSTALL EVB ON SMA COMPLETE WITH MOUNTING HARDWARE. FURNISH AND INSTALL SNS "GOLDEN STATE BLVD" ON SMA COMPLETE WITH MOUNTING HARDWARE.
(B)	1-A (10')	-	-	-	TV-2-T	-	-	-	-	-		
(C)	29-5-113	55'	15'	MAT MAS F=21'	SV-1-T SV-1-T	-	-	-	-	78W	XXXXX	FURNISH AND INSTALL EVC ON SMA AND R3-1 INTERNALLY ILLUMINATED BLANK OUT SIGN ON POLE COMPLETE WITH MOUNTING HARDWARE. FURNISH AND INSTALL SNS "TEMPERANCE AVE" ON SMA COMPLETE WITH MOUNTING HARDWARE.
(D)	1-A (10')	-	-	-	TV-2-T	-	-	-	-	-		
(E)	24-3-113	35'	15'	MAT	SV-1-T	-	-	-	-	78W	XXXXX	FURNISH AND INSTALL EVD ON SMA COMPLETE WITH MOUNTING HARDWARE. FURNISH AND INSTALL SNS "GOLDEN STATE BLVD" ON SMA COMPLETE WITH MOUNTING HARDWARE.
(F)	1-A (10')	-	-	-	SV-1-T TV-2-T	-	-	-	-	-		FURNISH AND INSTALL R3-1 INTERNALLY ILLUMINATED BLANK OUT SIGN ON POLE COMPLETE WITH MOUNTING HARDWARE.
(G)	61-5-129	65'	15'	MAT MAS F=17'	SV-1-T	-	-	-	-	78W	XXXXX	FURNISH AND INSTALL PEC ON TOP OF POLE. FURNISH AND INSTALL EVA ON SMA COMPLETE WITH MOUNTING HARDWARE. FURNISH AND INSTALL SNS "TEMPERANCE AVE" ON SMA COMPLETE WITH MOUNTING HARDWARE.
(H)	1-A (10')	-	-	-	TV-2-T	-	-	-	-	-		
(I)	1-A (10')	-	-	-	TV-1-T	-	-	-	-	-		FURNISH AND INSTALL R3-2 INTERNALLY ILLUMINATED BLANK OUT SIGN ON POLE COMPLETE WITH MOUNTING HARDWARE.
(J)	1-A (10')	-	-	-	TV-1-T	-	-	-	-	-		FURNISH AND INSTALL R3-1 INTERNALLY ILLUMINATED BLANK OUT SIGN ON POLE COMPLETE WITH MOUNTING HARDWARE.


- NOTES:
1. ALL EQUIPMENT IS NEW UNLESS NOTED.
 2. ALL INDICATIONS SHALL BE 12" LED MODULES.
 3. STREET NAME SIGNS SHALL BE WHITE LETTERS ON GREEN BACKGROUND 12" UPPERCASE 9" LOWERCASE, 4" BLOCK NUMBERS, 4" WIDE ARROWS, WITH SERIES "D" TEXT.
 4. LED INTERSECTION SAFETY LIGHT LUMINAIRES INSTALLED AND SHALL BE CREE RSWs-A-HT-3ME-6L-4OK7-UL-GY-N FULL POWER: 78W, 9325 LUMEN, 4000K, CRI70-B1-U0-G2, RSWs9056&SP.
 5. PG&E POLE NUMBERS SHALL BE INCLUDED ON THE AS-BUILT PLANS.

	DATE	RECORD DRAWING	
DESIGNED: J. BENAVIDES	03/19/2021	RESIDENT ENGINEER	DATE
DRAWN: C. AYALA-MAGANA	03/19/2021		
CHECKED: J. RIOS	03/19/2021		

FOR RIGHT OF WAY DATA AND ACCURATE ACCESS DETERMINATION, SEE DOCUMENTS IN THE DEPARTMENT OF PUBLIC WORKS AND PLANNING.

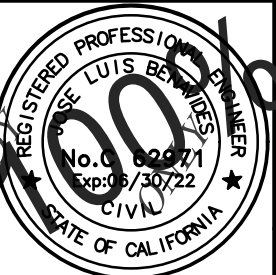
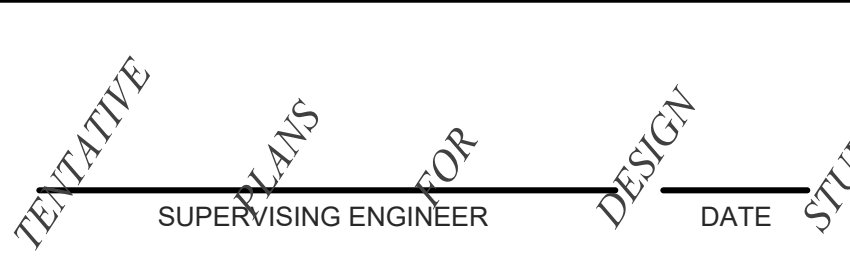


PROJECT	
GOLDEN STATE CORRIDOR - ECONOMIC DEVELOPMENT AND INFRASTRUCTURE IMPROVEMENTS	
FOWLER REGION	

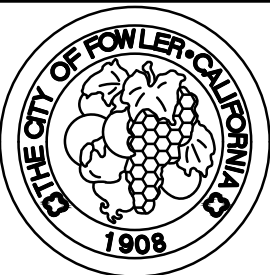

DEPARTMENT OF PUBLIC WORKS AND PLANNING			
GOLDEN STATE BLVD AT TEMPERANCE AVE CONDUCTOR AND EQUIPMENT SCHEDLUE			
DRAWING NO.	E-19	SHEET NO.	126
TOTAL		142	


PATH: Z:\01 Projects\009 Fresno County\009-009 Golden State PS&E\Traffic Signal Designs\Ta. Golden State Blvd at South Ave.dwg
PLOT DATE: 3/19/2021 3:07:13 PM
CAD USER: CAYALA

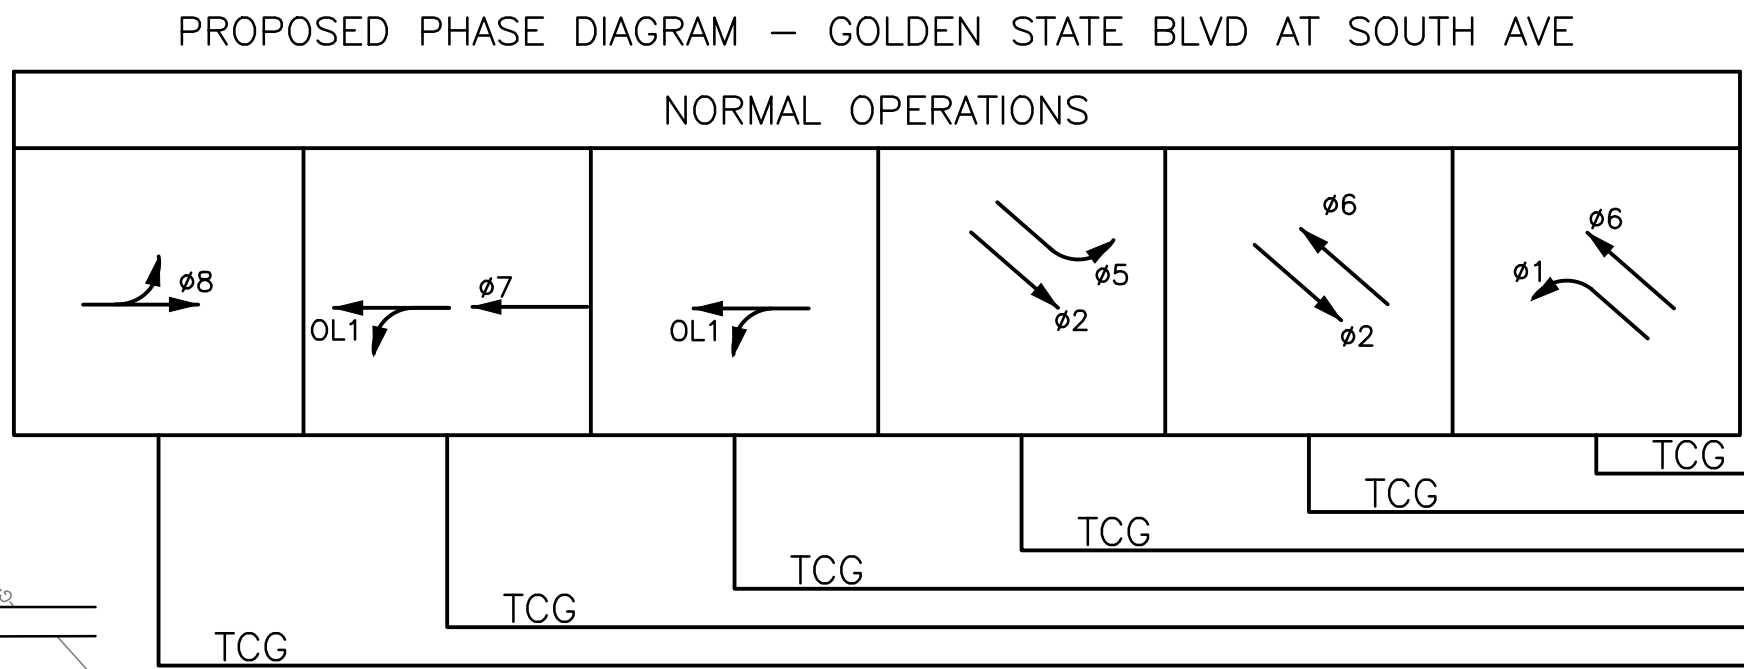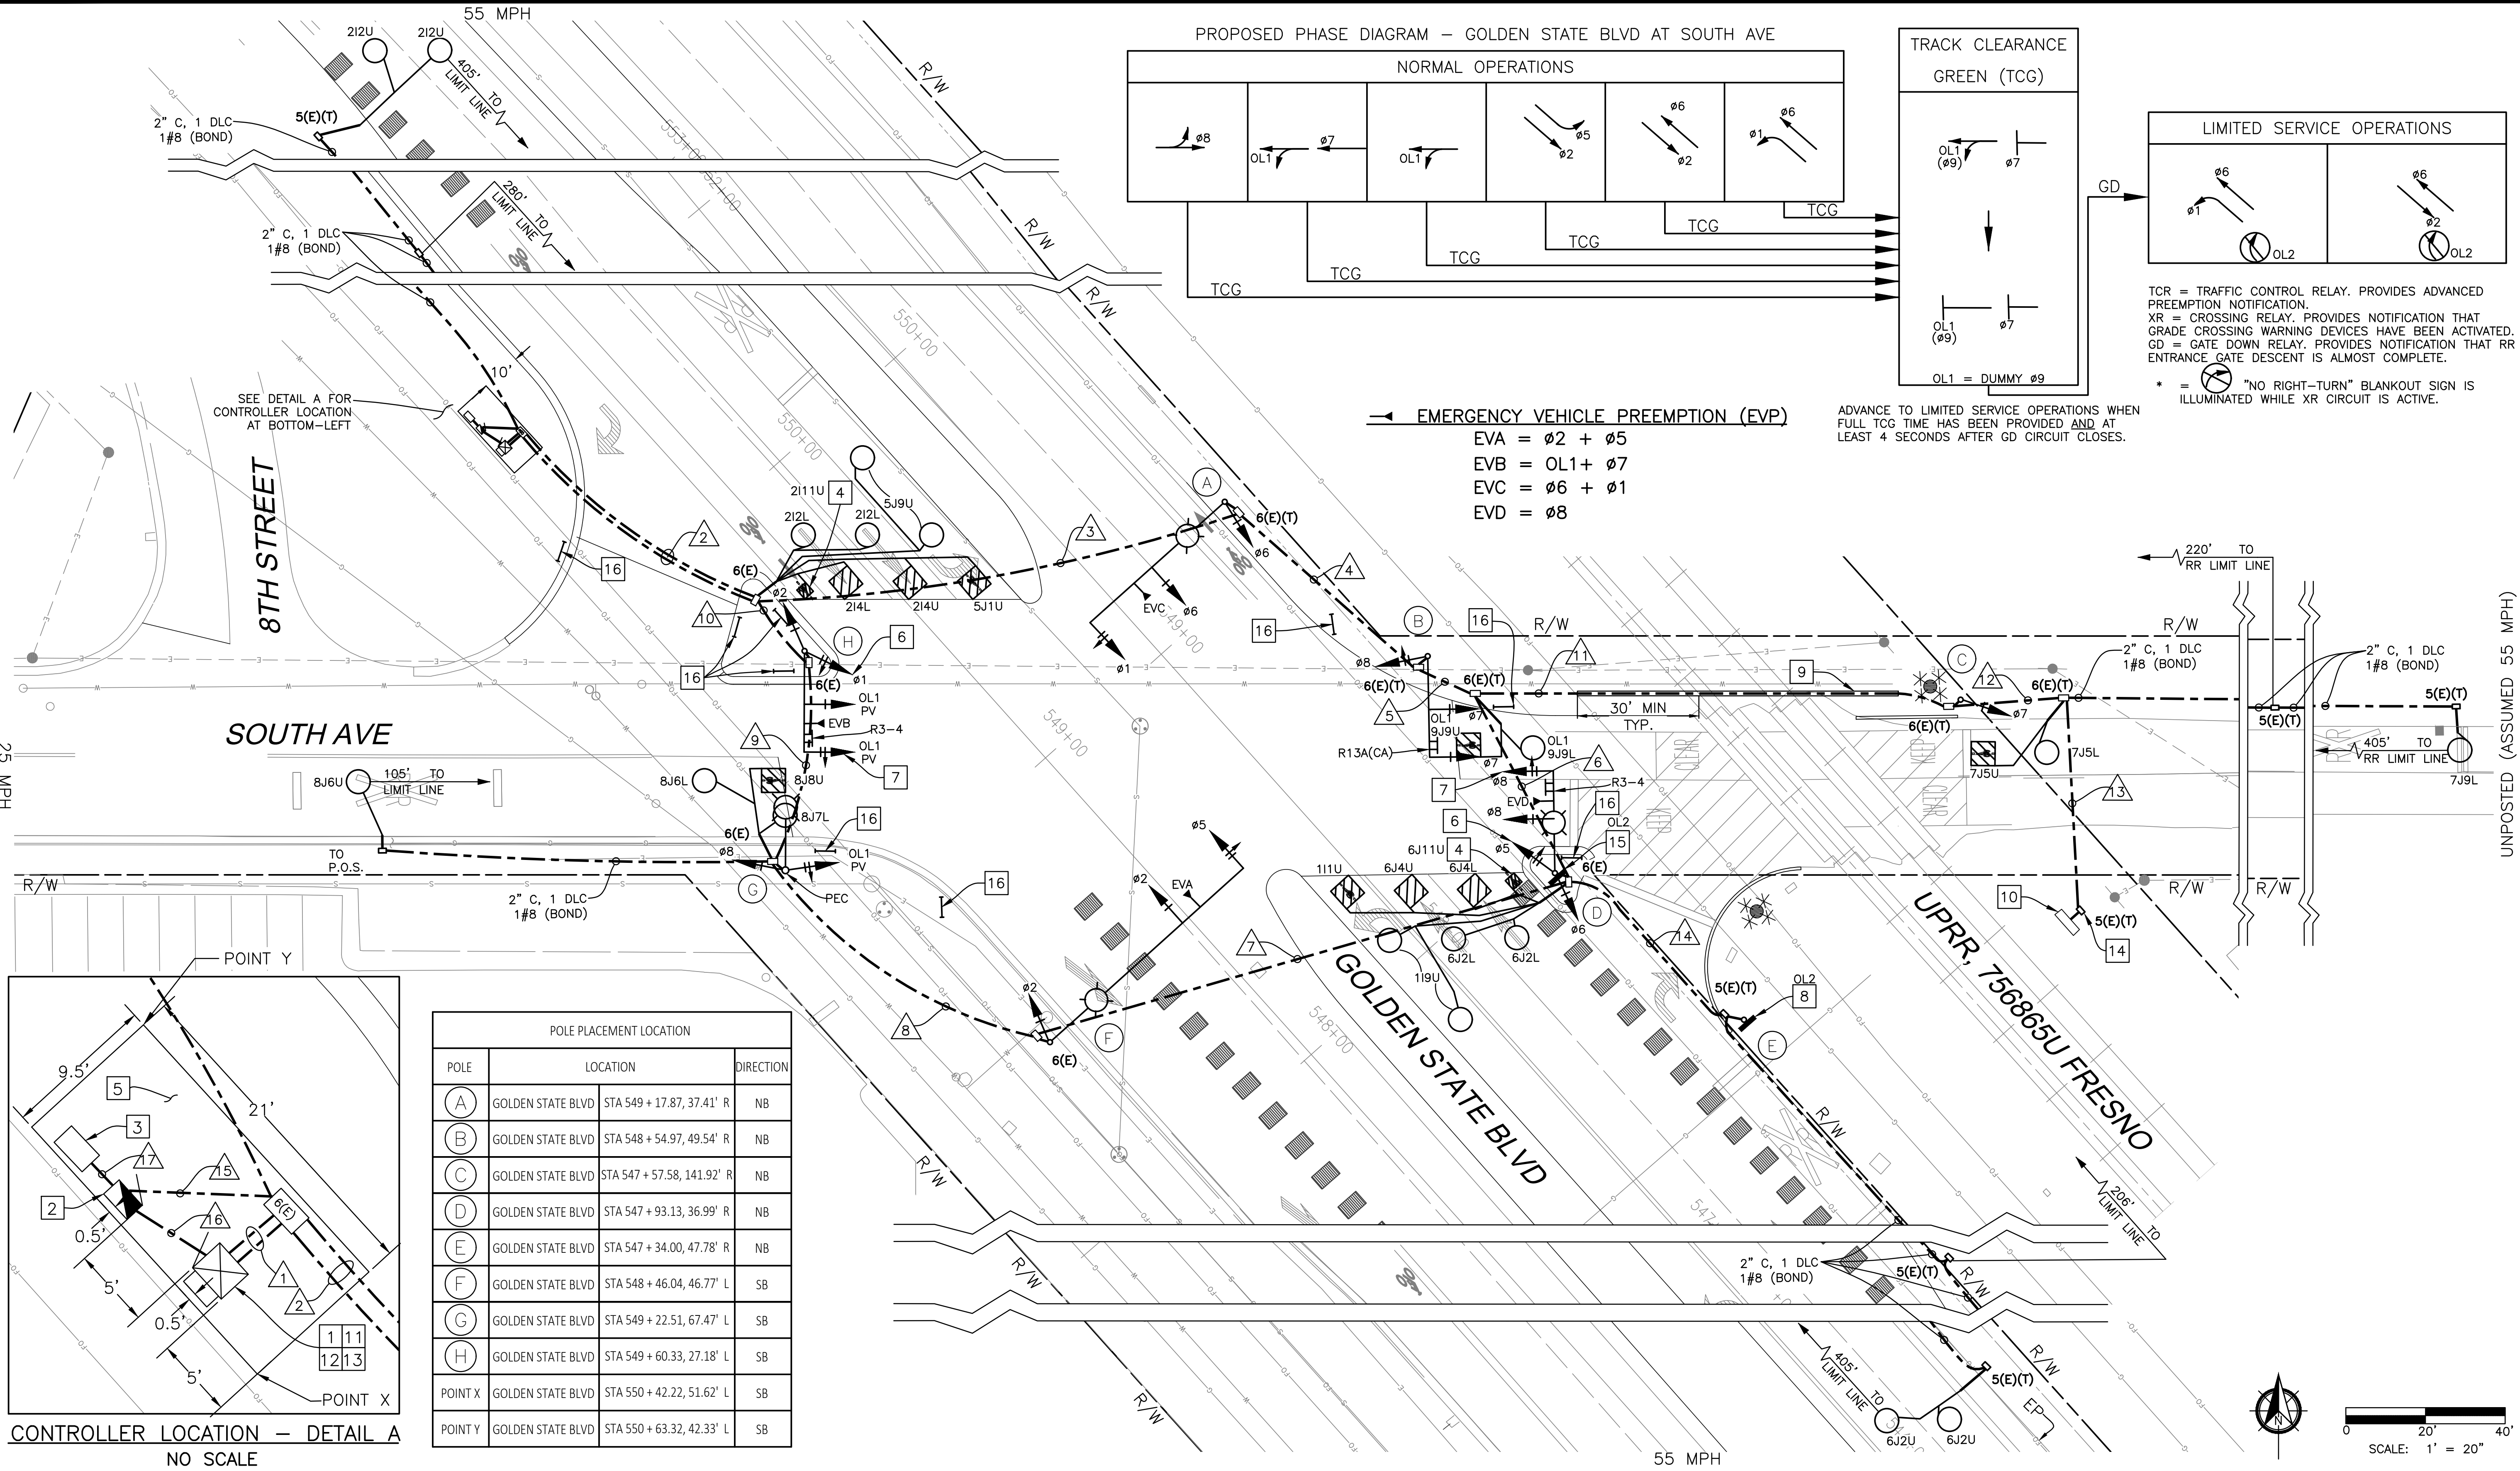

EMERGENCY VEHICLE PREEMPTION (EVP)

EVA = Ø2 + Ø5
EVB = OL1 + Ø7
EVC = Ø6 + Ø1
EVD = Ø8

ADVANCE TO LIMITED SERVICE OPERATIONS WHEN FULL TCG TIME HAS BEEN PROVIDED AND AT LEAST 4 SECONDS AFTER GD CIRCUIT CLOSES.

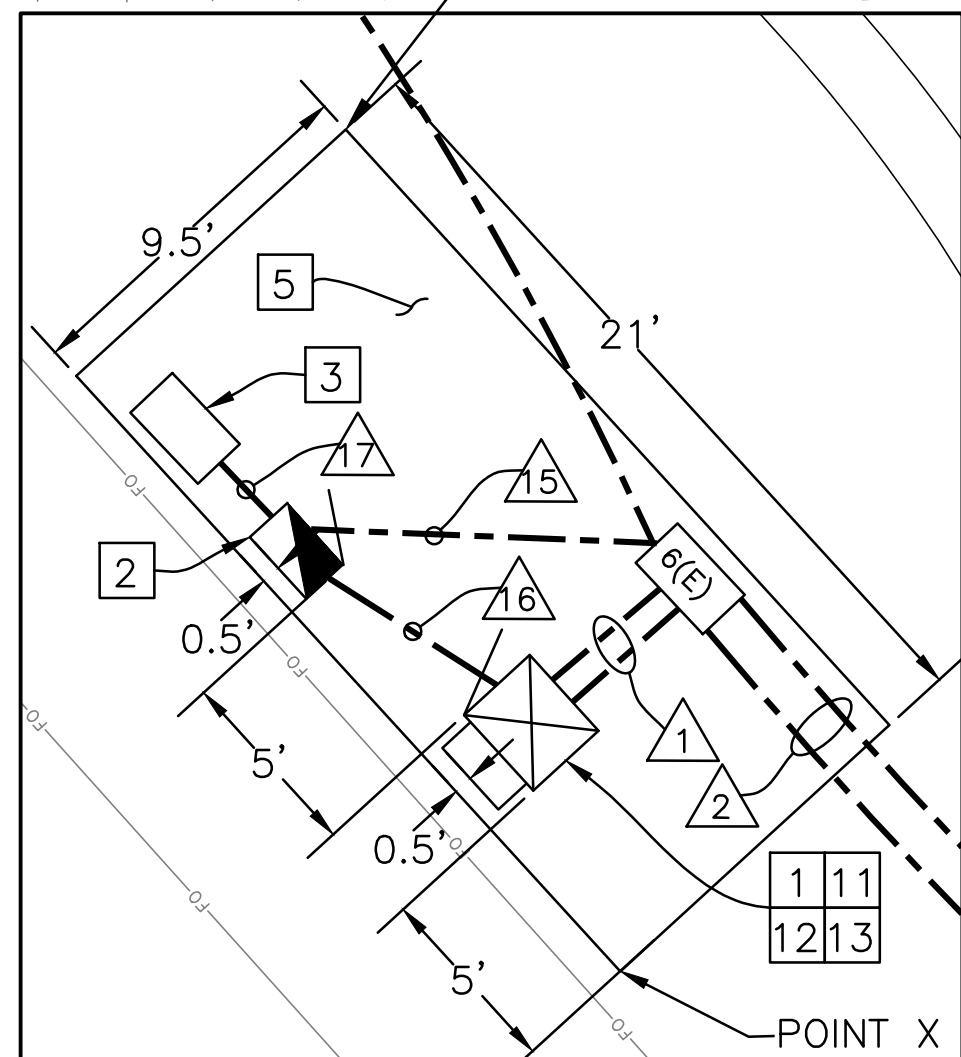

POLE PLACEMENT LOCATION			
POLE	LOCATION		DIRECTION
(A)	GOLDEN STATE BLVD	STA 549 + 17.87, 37.41' R	NB
(B)	GOLDEN STATE BLVD	STA 548 + 54.97, 49.54' R	NB
(C)	GOLDEN STATE BLVD	STA 547 + 57.58, 141.92' R	NB
(D)	GOLDEN STATE BLVD	STA 547 + 93.13, 36.99' R	NB
(E)	GOLDEN STATE BLVD	STA 547 + 34.00, 47.78' R	NB
(F)	GOLDEN STATE BLVD	STA 548 + 46.04, 46.77' L	SB
(G)	GOLDEN STATE BLVD	STA 549 + 22.51, 67.47' L	SB
(H)	GOLDEN STATE BLVD	STA 549 + 60.33, 27.18' L	SB
POINT X	GOLDEN STATE BLVD	STA 550 + 42.22, 51.62' L	SB
POINT Y	GOLDEN STATE BLVD	STA 550 + 63.32, 42.33' L	SB

DESIGNED: J. BENAVIDES		DATE: 03/19/2021		RECORD DRAWING	
DRAWN: C. AYALA-MAGANA		DATE: 03/19/2021		RESIDENT ENGINEER	
CHECKED: J. RIOS		DATE: 03/19/2021		DATE	

CALL BEFORE YOU DIG

516 W. SHAW AVE., STE. 103
FRESNO, CA 93704
PHONE: (559) 570-8991
EMAIL: info@JLBtraffic.com

TENTATIVE PLANS FOR DESIGN

SUPERVISING ENGINEER

DATE

PROJECT

GOLDEN STATE CORRIDOR - ECONOMIC DEVELOPMENT AND INFRASTRUCTURE IMPROVEMENTS

FOWLER REGION

DEPARTMENT OF PUBLIC WORKS AND PLANNING

GOLDEN STATE BLVD AT SOUTH AVE

TRAFFIC SIGNAL PLAN

DRAWING NO. E-20 SHEET NO. 127 TOTAL 142

CAD USER: CAYALA
PLOT DATE: 3/19/2021 3:07:25 PM
PATH: Z:\01 Projects\009 Fresno County\009-Golden State Blvd at South Ave\Golden State Blvd at South Ave.dwg

PROJECT NOTES (SHEETS E-20 TO E-22 ONLY):

- 1

FURNISH AND INSTALL TYPE 2070L CONTROLLER, NEW TYPE 332L CABINET WITH ALL ANCILLARY DEVICES FOR A FULL EIGHT PHASE OPERATION AS SPECIFIED IN THE SPECIFICATIONS. TYPE 332L CABINET SHALL INCLUDE TWO AUXILIARY BAYS. FURNISH AND INSTALL NEW BATTERY BACK-UP SYSTEM PER THE SPECIAL PROVISIONS. NEW MODEL 332L SHALL BE MODIFIED FOR RAILROAD PREEMPTION. FRONT DOOR OF ASSEMBLY SHALL FACE NORTHWEST. BATTERY BACK-UP EXTERNAL CABINET SHALL BE ON THE SOUTHWEST SIDE OF THE CONTROLLER ASSEMBLY.
- 2

INSTALL NEW TYPE III-AF SERVICE CABINET. CONTRACTOR SHALL COORDINATE WITH PG&E FOR POINT OF SERVICE CONNECTION.
- 3

POINT OF SERVICE LOCATION BOX. CONTRACTOR TO COORDINATE WITH PG&E TO CONNECT AND SET METER.
- 4

INSTALL 3'X3' BIKE LOOP PER DETAIL D AS SHOWN ON SHEET ED-1.
- 5

INSTALL 9 ½" X 21" X 3 ½" PCC PAD.
- 6

INSTALL PROGRAMMABLE VISIBILITY SIGNAL HEAD TO ENSURE THAT VEHICLE SIGNAL HEAD IS ONLY VISIBLE TO THE TRAFFIC IT IS INTENDED FOR.
- 7

INSTALL 4-SECTION SIGNAL HEAD PER DETAIL H AS SHOWN ON SHEET ED-1.
- 8

FURNISH AND INSTALL R3-1 (24" x 24") INTERNALLY ILLUMINATED BLANK OUT SIGN PER DETAIL B AND DETAIL K AS SHOWN ON SHEET ED-1.
- 9

FURNISH AND INSTALL 3" TYPE I CONDUIT IN 4" GALVANIZED STEEL CASING PER UPRR STANDARDS AND SPECIFICATIONS. 4" GALVANIZED STEEL CASING SHALL BE A MINIMUM OF 30 FEET FROM THE CENTERLINE OF THE TRACK IN A CROSS SECTION VIEW OF THE TRACKS. 4" GALVANIZED STEEL CASING SHALL BE INSTALLED NO LESS THAN 4.5 FEET BELOW THE TIE OF THE RAIL AND SHALL BE INSTALLED USING JACKING OR DRILLING METHODS ONLY. CONTRACTOR SHALL OBTAIN A PERMIT FROM THE RAILROAD AND FOLLOW RAILROAD REQUIREMENTS.
- 10

EXISTING RAILROAD CABINET TO REMAIN.
- 11

THE ADVANCED PREEMPTION INTERCONNECTION SHALL BE CONFIGURED AS A "SUPERVISED" CIRCUIT. A PREEMPTION INTERCONNECTION CIRCUIT SHALL BE IMPLEMENTED IN THE TRAFFIC SIGNAL CONTROLLER. CONTRACTOR SHALL WORK WITH RAILROAD, AND BE RESPONSIBLE FOR APPROVAL, TO CONNECT TO THE ADVANCED PREEMPTION CIRCUIT. A "GATE-DOWN" CIRCUIT SHALL BE IMPLEMENTED IN THE TRAFFIC SIGNAL CONTROLLER. THE RAILROAD WILL PROVIDE THE GATE DOWN CIRCUIT FOR CONNECTION TO THE TRAFFIC SIGNAL CONTROLLER AS PART OF THE RAILROAD'S STANDARD DESIGN. A TRAFFIC SIGNAL HEALTH CIRCUIT SHALL BE IMPLEMENTED INTO THE SIGNAL CONTROLLER. THE TRAFFIC SIGNAL CONTROLLER SHALL BE PROGRAMMED WITH SECOND TRAIN LOGIC.
- 12

CONTRACTOR SHALL INSTALL THE FOLLOWING WARNING LABEL WITHIN THE TRAFFIC SIGNAL CONTROLLER CABINET:

- IF THE TRAFFIC SIGNAL ENTERS FLASHING MODE, NOTIFY THE RAILROAD AND PROVIDE FOR THE SAFE MOVEMENT OF ROADWAY USERS OVER THE GRADE CROSSING.

- IF THE TRAFFIC SIGNAL LOSES POWER OR ALL OF THE SIGNALS ARE DARK, NOTIFY THE RAILROAD AND PROVIDE FOR THE SAFE MOVEMENT OF THE ROADWAY USERS OVER THE GRADE CROSSING.

- NOTIFY THE RAILROAD ONCE THE SIGNAL SYSTEM HAS BEEN RESTORED TO NORMAL OPERATION.

- IF SIGNAL MAINTENANCE IS REQUIRED TO PERFORM A JOINT TEST OF THE PREEMPTION SYSTEM, NOTIFY THE RAILROAD.
- 13

CONTRACTOR SHALL INSTALL WARNING LABEL WITHIN CONTROLLER CABINET AS RECOMMENDED IN THE USDOT HIGHWAY RAIL GRADE CROSSING TECHNICAL WORKING GROUP RECOMMENDATIONS TO ALERT TRAFFIC SIGNAL TECHNICIANS TO THE PRESENCE OF THE INTERCONNECTION WITH THE RAILROAD. SEE SAMPLE PER DETAIL I AS SHOWN ON SHEET ED-1.
- 14

COORDINATE WITH UPRR FOR THE INSTALLATION OF RAILROAD PREEMPTION CABLING AND TESTING OF THE REQUIRED RAILROAD PREEMPTION CIRCUITS. CONTACT UPRR PRIOR TO ANY WORK WITHIN UPRR RIGHT-OF-WAY OR ANY WORK AFFECTING GRADE CROSSING OPERATIONS.
- 15

FURNISH AND INSTALL R3-1 (24" x 24") INTERNALLY ILLUMINATED BLANK OUT SIGN PER DETAIL B AND DETAIL L AS SHOWN ON SHEET ED-1.
- 16

FURNISH AND INSTALL TYPE I PED BARRICADE WITH R9-3.

GENERAL NOTES (SHEETS E-20 TO E-22 ONLY):

1.

WORK SHALL BE DONE IN ACCORDANCE WITH THE STATE OF CALIFORNIA DEPARTMENT OF TRANSPORTATION STANDARD PLANS AND SPECIFICATIONS, 2010 EDITION, THE LATEST CALTRANS ADOPTED EDITION OF THE CALIFORNIA MANUAL ON UNIFORM TRAFFIC CONTROL DEVICES (CA-MUTCD), AND THE LATEST EDITION OF THE CITY OF FRESNO STANDARD SPECIFICATIONS AND DRAWINGS. SIGNAL POLES/STANDARDS FOR 113KM/H WIND VELOCITY AND TYPE 1-A POLES SHALL BE PER THE STATE STANDARD PLANS AND SPECIFICATIONS, DATED JULY 1997.
2.

THESE PLANS ARE ACCURATE FOR ELECTRICAL WORK ONLY.
3.

NO ABOVE GROUND WORK, EXCEPT SERVICE EQUIPMENT, SHALL BE PERFORMED UNTIL THE CONTRACTOR HAS ALL MATERIALS ON HAND TO COMPLETE THAT PARTICULAR SIGNAL LOCATION OR LIGHTING CIRCUIT.
4.

THE CONTRACTOR IS RESPONSIBLE FOR VERIFICATION OF ALL EXISTING UTILITIES WHETHER OR NOT THEY ARE SHOWN ON THESE PLANS, AND SHALL PROVIDE PROTECTION PRIOR TO, DURING AND AFTER TRENCHING, JACKING AND/ OR BORING. THE CONTRACTOR SHALL CONTACT UNDERGROUND SERVICE ALERT (USA), BY CALLING 1-800-227-2600 AT LEAST TWO (2) WORKING DAYS BEFORE BEGINNING WORK.
5.

CONDUIT INSTALLATION ACROSS ROADWAYS SHALL BE BY JACKING AND DIRECTIONAL DRILLING METHODS UNLESS OTHERWISE NOTED ON THE PLANS.
6.

CONTRACTOR SHALL ARRANGE WITH UTILITY COMPANIES FOR ALL REQUIRED UTILITY RELOCATIONS, INCLUDING OVERHEAD CONFLICTS.
7.

ALL TRAFFIC SIGNAL AND LIGHTING FACILITIES, INCLUDING CABINETS, STANDARDS, PULL BOXES, CONDUITS AND LOOP DETECTORS, ARE SHOWN IN THEIR APPROXIMATE LOCATIONS. AFTER ALL UNDERGROUND UTILITIES ARE MARKED, THE CONTRACTOR SHALL MARK FINAL LOCATIONS IN THE FIELD AND NOTIFY THE ENGINEER AT LEAST TWO (2) WORKING DAYS PRIOR TO COMMENCING WORK TO OBSERVE THE MARKED LOCATIONS.
8.

ALL SALVAGED EQUIPMENT SHALL BE RETURNED TO THE CITY OF FOWLER PUBLIC WORKS DEPARTMENT. THE CONTRACTOR SHALL NOTIFY THE CITY, CONTACT AT LEAST TWO (2) WORKING DAYS PRIOR TO DELIVERY. CONTRACTOR SHALL PROVIDE ADEQUATE MEANS FOR SAFELY UNLOADING EQUIPMENT.
9.

PULL BOXES SHALL BE NO. 5(E), UNLESS OTHERWISE NOTED ON THE PLANS. PULL BOXES SHALL NOT BE INSTALLED IN CURB RAMPS OR DRIVEWAYS. VANDAL RESISTANT LOCKING LIDS SHALL BE PROVIDED AND INSTALLED BY THE CONTRACTOR AT FINAL INSPECTION OF THE TRAFFIC SIGNAL. CONTRACTOR SHALL PROVIDE TEMPORARY LIDS DURING CONSTRUCTION. ALL PULL BOXES SHALL BE AT A MAXIMUM OF 200' APART. LIDS SHALL BE TORQUED TO 25 FT. LBS.
10.

ALL PULL BOXES INSTALLED IN NON-CONCRETE AREAS SHALL BE SURROUNDED BY A ONE (1) FOOT WIDE CONCRETE COLLAR, TO A DEPTH EQUAL TO THE PULL BOX AND EXTENSION, PER CITY OF FRESNO SPECIFICATIONS, AND SHALL HAVE A VANDAL RESISTANT (SEE NOTE ABOVE) LOCKING LID INSTALLED. ALL CONDUIT ENTRIES INTO ADVANCE DETECTION, INTERMEDIATE DETECTION, AND STREET LIGHTING PULL BOXES INSTALLED IN NON-CONCRETE AREAS SHALL ENTER THE PULL BOX FROM THE BOTTOM, USING 90 DEGREE ELBOWS AND EXTENDING 3 TO 5 INCHES ABOVE THE FINISHED GROUT.
11.

ALL CONDUITS SHALL HAVE BUSHINGS INSTALLED PRIOR TO INSTALLING CONDUCTORS. STEEL CONDUITS SHALL HAVE LAY IN STYLE LUGS THAT ARE CAST INTEGRAL WITH THE BUSHING.
12.

CONDUIT BENDS OF 90 DEGREES ARE PROHIBITED UNLESS OTHERWISE NOTED OR WRITTEN PERMISSION IS GIVEN BY THE CITY OF FOWLER ENGINEER.
13.

ALL NEUTRAL CONDUCTORS SHALL BE WHITE IN COLOR THROUGHOUT THEIR ENTIRE LENGTH.
14.

TRAFFIC SIGNAL CABLE SHALL NOT BE SPLICED BETWEEN THE CONTROLLER CABINET AND THE TERMINAL COMPARTMENTS MOUNTED ON THE POLES. DETECTOR CABLES SHALL NOT BE SPLICED BETWEEN THE CONTROLLER CABINET AND THE PULL BOX ADJACENT TO THE DETECTOR LEAD-IN.
15.

PEDESTRIAN MODULE SHALL BE INSTALLED ON THE LEFT SIDE, FACING THE FRONT, OF THE 332 CABINET.
16.

SEAL CONDUIT WITH AN APPROVED DUCT SEAL AFTER ALL CONDUCTORS HAVE BEEN INSTALLED.
17.

SEALANT FOR FILLING THE SAWCUT LOOPS SLOTS SHALL BE HOT-MELT RUBBERIZED ASPHALT SEALANT PER STATE OF CALIFORNIA SPECIFICATIONS, OR ELASTOMERIC SEALANT, 3M, BLACK 5000.
18.

PEDESTRIAN PUSH BUTTONS SHALL HAVE 2" DIAMETER ACTUATORS AND COMPLY WITH THE AMERICANS WITH DISABILITIES ACT (ADA).
19.

ALL VEHICLE AND PEDESTRIAN SIGNAL SECTIONS SHALL UTILIZE LIGHT EMITTING DIODE (LED) SIGNAL MODULES IN ACCORDANCE WITH THE STANDARD SPECIFICATIONS. VEHICLE SIGNAL SECTIONS SHALL HAVE 12" (300 mm) DIAMETER LENSES WITH BACKPLATES AND TUNNEL VISORS. ALL VEHICLE AND PEDESTRIAN SIGNAL SECTIONS SHALL HAVE METAL AND RUBBER WASHERS INSTALLED ON THE INSIDE OF THE HEAD.
20.

SAFETY LUMINAIRE SHALL BE LED (EQUAL TO 150W HPS), SEE UPDATED CITY OF FRESNO SPECIFICATIONS FOR SAFETY LUMINAIRE REQUIREMENTS.
21.

PEDESTRIAN SIGNAL UNITS SHALL BE FULL SYMBOL, MUTCD COMPLIANT, LED "COUNTDOWN" TYPE WITH 9 INCH NUMERALS; GELCORE MODEL PS7-CFF1-01A-18, OR APPROVED EQUAL. SIGNAL ALIGNMENT SHALL BE AS DIRECTED BY THE ENGINEER.
22.

THE CONTRACTOR SHALL FURNISH AND INSTALL A COMPLETE OPTICOM (GTT) EMERGENCY VEHICLE PREEMPTION (EVP) SYSTEM (721 TWO DIRECTION DETECTION, SINGLE CHANNEL) IN ACCORDANCE WITH THE CITY STANDARD SPECIFICATIONS. EVP DETECTOR UNITS SHALL BE INSTALLED ON SIGNAL MAST ARMS AS SHOWN ON THE PLAN, CENTERED OVER THE NUMBER ONE THROUGH LANE, WITH BRACKETS APPROVED BY THE TRAFFIC SIGNAL SUPERVISOR. THE CONTRACTOR SHALL DELIVER THE MODEL 762 DISCRIMINATORS TO THE CITY CORPORATION YARD AT 2101 "G" STREET, FRESNO, AND NOTIFY THE CITY TRAFFIC SIGNAL SHOP, (559) 621-1312, AT LEAST TWO (2) WORKING DAYS PRIOR TO DELIVERY.
23.

CONTRACTOR SHALL SCHEDULE WITH THE CITY OF FRESNO TSSL SHOP AT (559) 621-1312 ALL EQUIPMENT DELIVERIES WHICH REQUIRE TESTING BY THE CITY'S TSSL SHOP. EQUIPMENT SHALL BE DELIVERED BY THE CONTRACTOR ONLY AT A PREARRANGED TIME AND DAY.
24.

THE CONTRACTOR SHALL FURNISH AND INSTALL NEW STREET NAME SIGN ON SMA COMPLETE WITH VARIABLE LENGTH MOUNTING HARDWARE, AS SHOWN ON THE PLAN. FURNISH AND INSTALL NEW MOUNTING BRACKETS AS NECESSARY. SUBMITTALS SHALL BE APPROVED BY THE CITY PRIOR TO ORDERING.
25.

ALL SIGNS SHALL BE 3M-3930HIP TYPE III & IV SERIES REFLECTIVE SHEETING AND BE COVERED WITH 1160A PREMIUM OVERLAY ANTI-GRAFFITI FILM OR AVERY DENNISON T6500 SERIES REFLECTIVE SHEETING AND SHALL BE COVERED WITH AVERY DENNISON OL1000 ANTI-GRAFFITI OVERLAY FILM.
26.

CONDUITS EXITING THE CONTROLLER FOUNDATION AND ENTERING INTO THE CONTROLLER CABINET SHALL BE ALIGNED TO ENTER WITHIN THE TEES SPECIFIED CABINETS WITHOUT ANY MODIFICATIONS TO THE CABINET BASE.
27.

ALL RESURFACING SHALL MATCH EXISTING SURFACES AFTER SIGNAL FACILITIES ARE REMOVED AND/OR RELOCATED.
28.

THE EXISTING TRAFFIC SIGNAL SYSTEM, INCLUDING DETECTION, AND/OR STREET LIGHTING SHALL REMAIN OPERATIONAL DURING CONSTRUCTION, UNLESS OTHERWISE AUTHORIZED IN WRITING BY THE CITY ENGINEER.
29.

ALL LUMINAIRE CIRCUITS SHALL BE FUSED. THE FUSE SHALL BE LOCATED IN THE LUMINAIRE HEAD (5 AMP KTK FUSE IN TRON HEB TYPE FUSE HOLDER).
30.

THE CONTRACTOR SHALL FURNISH AND INSTALL POLE NUMBERS WHEN PG&E INDICATES THE NUMBER. POLE NUMBERS SHALL BE SHOWN ON THE AS BUILT DRAWINGS.
31.

THE CONTRACTOR SHALL FURNISH AND INSTALL A COMPLETE ACCESSIBLE (AUDIBLE) PEDESTRIAN SIGNAL (APS) SYSTEM (2-WIRE POLARA NAVIGATOR OR APPROVED EQUAL) IN CONFORMANCE WITH THE CITY OF FRESNO STANDARD SPECIFICATIONS. THE APS SHALL PROVIDE BOTH A VIBRATING ARROW BUTTON AND AUDIBLE SOUNDS DURING THE "WALK" INTERVAL, AS WELL AS A LOCATING TONE DURING THE PEDESTRIAN CLEARANCE AND DON'T WALK INTERVALS. THE APS SYSTEM SHALL MEET CURRENT ADA AND CA-MUTCD REQUIREMENTS. ALL PEDESTRIAN PUSH BUTTONS SHALL HAVE A FOUR FOOT ACCESSIBLE PATH IN FRONT OF THE BUTTON. THE APS CENTRAL CONTROL UNIT (CCU) SHALL BE MOUNTED WITH A CITY-APPROVED MANUFACTURED BRACKET, McCain M49021 OR APPROVED EQUAL. CCU SHALL BE MOUNTED TO THE REAR RACK, IN THE UPPER LEFT CORNER WHEN VIEWED FROM THE FRONT OF THE CABINET. THE POWER SUPPLY PIGTAIL SHALL BE CUT TO LENGTH TO ELIMINATE EXCESS CABLE, WITH POWER OBTAINED FROM THE PDA T1 TERMINAL STRIP. TERMINALS 1, 3, & 5. CONTRACTOR SHALL PROVIDE CITY OF FRESNO TSSL THE LATEST MEANS OF PROGRAMMING THE APS SYSTEM AND DIGITAL COPIES OF THE CUSTOM AUDIO VIA EMAIL.

LEGEND (SHEETS E-20 TO E-22 ONLY):

- TYPE E CIRCULAR LOOP DETECTOR CONFIGURATION PER STATE STANDARD PLAN ES-5B. LOOP SEALANT SHALL BE STATE APPROVED ELASTOMERIC SEALANT OR HOT MELT RUBBERIZED.
- TYPE D LOOP DETECTOR CONFIGURATION PER STATE STANDARD PLAN ES-5B. LOOP SEALANT SHALL BE STATE APPROVED ELASTOMERIC SEALANT OR HOT MELT RUBBERIZED. BICYCLE DETECTOR SYMBOL TO BE INSTALLED PER CALTRANS STANDARD PLAN A24-C ON CENTER OF THE DETECTOR WHERE SHOWN ON PLAN. ARROW SIGNIFIES DIRECTION OF VEHICULAR TRAVEL.
- EMERGENCY VEHICLE PREEMPTION (EVP) DETECTION UNIT
EVX (DENOTES CHANNEL).
- NEW CONDUIT
- EXISTING CONDUIT
- EXISTING LUMINAIRE
- PROGRAMMABLE VISIBILITY VEHICLE SIGNAL HEAD

CONSTRUCTION NOTES (SHEETS E-20 TO E-22 ONLY):

1.

ALL PULL BOXES ACCESSED BY CONTRACTOR SHALL BE CLEANED OF ALL DIRT AND DEBRIS, ANY CRACKS GROUTED AND ALL CONDUITS DUCT SEALED.
2.

ALL PULLBOXES SHALL BE LEVELED TO FINISH GRADE (NEW AND EXISTING).
3.

ALL PULLBOXES IN DIRT AREAS SHALL HAVE 1' COLLAR PER GENERAL NOTE 10 (NEW).
4.

ANY PULLBOXES BROKEN/DAMAGED BY CONTRACTOR SHALL BE REPLACED.
5.

ALL PULLBOXES SHALL HAVE LOCKING LIDS. TRAFFIC RATED LIDS SHALL BE WELDED CLOSED AFTER FINAL INSPECTION.
6.

ALL UNUSED CONDUCTORS SHALL BE REMOVED.

		DATE	RECORD DRAWING				PROJECT				DEPARTMENT OF PUBLIC WORKS AND PLANNING	
DESIGNED:	J. BENAVIDES	03/19/2021	RESIDENT ENGINEER	DATE			GOLDEN STATE CORRIDOR - ECONOMIC DEVELOPMENT AND INFRASTRUCTURE IMPROVEMENTS				GOLDEN STATE BLVD AT SOUTH AVE LEGEND AND NOTES	
DRAWN:	C. AYALA-MAGANA	03/19/2021										
CHECKED:	J. RIOS	03/19/2021										
FOR RIGHT OF WAY DATA AND ACCURATE ACCESS DETERMINATION, SEE DOCUMENTS IN THE DEPARTMENT OF PUBLIC WORKS AND PLANNING.							FOWLER REGION				DRAWING NO. E-21 SHEET NO. 128 TOTAL 142	

CAD USER: CAYALA
PLOT DATE: 3/19/2021 3:07:36 PM
PATH: Z:\01 Projects\009 Fresno County\009-009 Golden State PS&E\Traffic Signal Designs\Ta. Golden State Blvd at South Ave\Golden State Blvd at South Avenue.dwg

CONDUCTOR SCHEDULE																			
AWG OR CABLE	POLE	Ø	CONDUIT RUN NUMBER AND SIZE																
			1	2	3	4	5	6	7	8	9	10	11	12	13	14	15	16	17
			2-4"	2-4"	4"	4"	4"	4"	4"	4"	4"	4"	3"	3"	3"	3"	2"	1.5"	2"
CONDUIT FILL			16%	16%	20%	18%	16%	9%	1%	3%	7%	11%	11%	9%	6%	2%	8%	14%	13%
7 COND. CABLE (VEH.) *	A	1,6 -	1 -	1 -	1 -	/	/	/	/	/	/	/	/	/	/	/	/	/	/
	B	7,8 -	1 -	1 -	1 -	1 -	/	/	/	/	/	/	/	/	/	/	/	/	/
	C	7 -	1 -	1 -	1 -	1 -	1 -	/	/	/	/	1 -	/	/	/	/	/	/	/
	D	5,6,8 -	2 -	2 -	2 -	2 -	2 -	2 -	/	/	/	/	/	/	/	/	/	/	/
	F	2,5 -	1 -	1 -	/	/	/	/	1 -	1 -	1 -	/	/	/	/	/	/	/	/
	G	0,1,8 -	1 -	1 -	/	/	/	/	/	1 -	1 -	1 -	/	/	/	/	/	/	/
	H	0,1,1,2 -	2 -	2 -	/	/	/	/	/	/	2 -	/	/	/	/	/	/	/	/
TOTAL			9 -	9 -	5 -	4 -	3 -	2 -	/	1 -	2 -	4 -	1 -	/	/	/	/	/	/
TYPE C DETECTOR LEAD-IN CABLE	Ø1		2	2	2	2	2	2											
	Ø2		5	4															
	Ø5		2	2															
	Ø6		5	5	5	5	5	5							1				
	Ø7		3	3	3	3	3					3	3						
	Ø8		4	4							4	4							
	OL1		2	2	2	2	2												
TOTAL DLC			23	22	12	12	12	7			4	4	3	3		1			
# 2	SERVICE																	3	
# 4	SIGNAL POWER																2		
# 8	SAFETY LIGHTS			2	2	2	2	2		2	2	2					2		
# 8	BONDING WIRE		1	1	1	1	1	1	1	1	1	1	1	1	1	1	1	1	
#12	PEU CONTROL			3							3	3					3		
#14	BLANK OUT SIGN		4	4	4	4	4	4								2			
12 COND. CABLE (#14 AWG)	RR PRE-EMPTION		1	1	1	1	1					1	1	1					
EVP CABLE 3 COND.	EVA (S/B)		1	1						1	1	1							
	EVV (W/B)		1	1								1							
	EVC (N/B)		1	1	1														
	EVD (E/B)		1	1	1	1	1	1											

* NUMBER INDICATIONS ARE THE NUMBER OF CABLES WITHIN CONDUIT.
ALL CONDUCTORS ARE NEW UNLESS OTHERWISE INDICATED WITH "()".


EQUIPMENT SCHEDULE												
No.	STANDARD			VEH SIG MTG		PED SIGNAL		PPB		LED LUMINAIRE WATTAGE	PG&E POLE #	SPECIAL REQUIREMENTS
	Type	Sig. M.A.	Lum.M.A.	Mast Arm	Pole	ø	MTG	ø	ARROW			
(A)	26-4-113	45'	15'	MAT MAS _{F=21'}	SV-1-T	-	-	-	-	78W	XXXX	FURNISH AND INSTALL EVC ON SMA COMPLETE WITH MOUNTING HARDWARE. FURNISH AND INSTALL SNS "SOUTH AVE" ON SMA COMPLETE WITH MOUNTING HARDWARE.
(B)	18-3-113	25'	-	MAT MAS _{F=12'}	SV-1-T	-	-	-	-	-	-	FURNISH AND INSTALL R13A ON SMA COMPLETE WITH MOUNTING HARDWARE.
(C)	1-A (10')	-	-	-	TV-1-T	-	-	-	-	-	-	
(D)	19-3-113	25'	15'	MAT MAS _{F=12'}	SV-2-TA SV-1-T	-	-	-	-	78W	XXXX	FURNISH AND INSTALL R3-1 INTERNALLY ILLUMINATED BLANK OUT SIGN ON POLE COMPLETE WITH MOUNTING HARDWARE. FURNISH AND INSTALL EVD AND R3-4 ON SMA COMPLETE WITH MOUNTING HARDWARE. FURNISH AND INSTALL SNS "GOLDEN STATE BLVD" ON SMA COMPLETE WITH MOUNTING HARDWARE.
(E)	1-A (10')	-	-	-	TV-1-T	-	-	-	-	-	-	FURNISH AND INSTALL R3-1 INTERNALLY ILLUMINATED BLANK OUT SIGN ON POLE COMPLETE WITH MOUNTING HARDWARE.
(F)	61-5-129	65'	15'	MAT MAS _{F=21'}	SV-1-T	-	-	-	-	78W	XXXX	FURNISH AND INSTALL EVA ON SMA COMPLETE WITH MOUNTING HARDWARE. FURNISH AND INSTALL SNS "SOUTH AVE" ON SMA COMPLETE WITH MOUNTING HARDWARE.
(G)	15-TS	-	15'	-	SV-2-TA	-	-	-	-	78W	XXXX	FURNISH AND INSTALL PEC ON TOP OF POLE.
(H)	18-3-113	25'	-	MAT MAS _{F=12'}	SV-2-TA	-	-	-	-	-	-	FURNISH AND INSTALL EVB AND R3-4 ON SMA COMPLETE WITH MOUNTING HARDWARE. FURNISH AND INSTALL SNS "GOLDEN STATE BLVD" ON SMA COMPLETE WITH MOUNTING HARDWARE.

NOTES:


- ALL EQUIPMENT IS NEW UNLESS NOTED.
- ALL INDICATIONS SHALL BE 12" LED MODULES.
- STREET NAME SIGNS SHALL BE WHITE LETTERS ON GREEN BACKGROUND 12" UPPERCASE 9" LOWERCASE, 4" BLOCK NUMBERS, 4" WIDE ARROWS, WITH SERIES "D" TEXT.
- LED INTERSECTION SAFETY LIGHT LUMINAIRES INSTALLED AND SHALL BE CREE RSW5-A-HT-3ME-6L-4OK7-UL-GY-N FULL POWER: 78W, 9325 LUMEN, 4000K, CRI70-B1-U0-G2, RSW59056&SP.
- PG&E POLE NUMBERS SHALL BE INCLUDED ON THE AS-BUILT PLANS.

		DATE	RECORD DRAWING	
DESIGNED:	J. BENAVIDES	03/19/2021	RESIDENT ENGINEER	DATE
DRAWN:	C. AYALA-MAGANA	03/19/2021		
CHECKED:	J. RIOS	03/19/2021		

FOR RIGHT OF WAY DATA AND ACCURATE ACCESS DETERMINATION, SEE DOCUMENTS IN THE DEPARTMENT OF PUBLIC WORKS AND PLANNING.




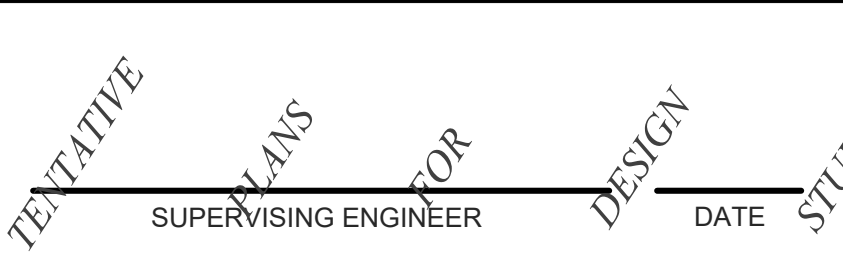


PROJECT	
GOLDEN STATE CORRIDOR - ECONOMIC DEVELOPMENT AND INFRASTRUCTURE IMPROVEMENTS	
FOWLER REGION	

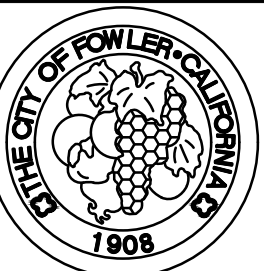

DEPARTMENT OF PUBLIC WORKS AND PLANNING			
GOLDEN STATE BLVD AT SOUTH AVE EQUIPMENT AND CONDUCTOR SCHEDULE			
DRAWING NO.	E-22	SHEET NO.	129
		TOTAL	142

CAD USER: CAYALA
PLOT DATE: 3/24/2021 2:33:38 PM
PATH: Z:\01 Projects\009 Fresno County\009-009 Golden State Blvd at Merced St\Traffic Signal Designs\2a Golden State Blvd at Merced St.dwg

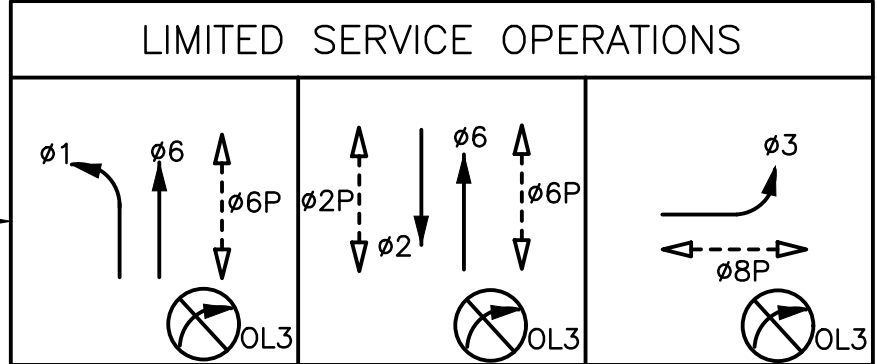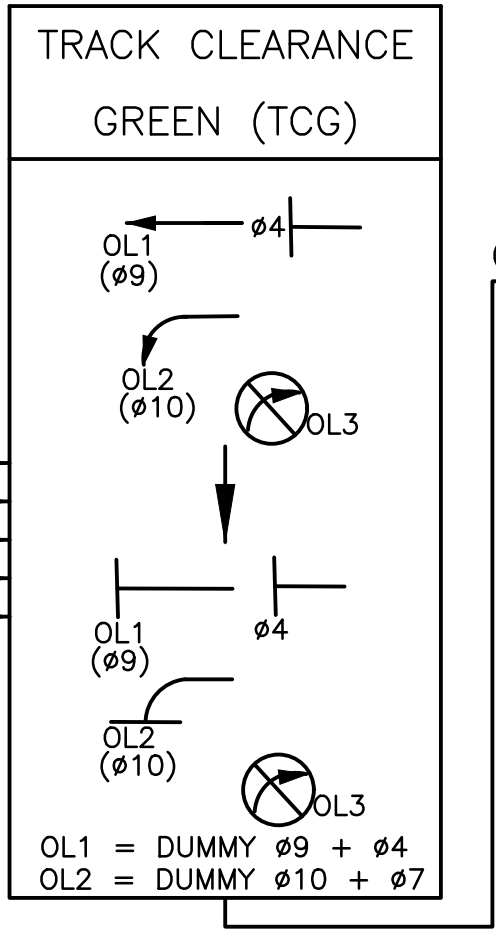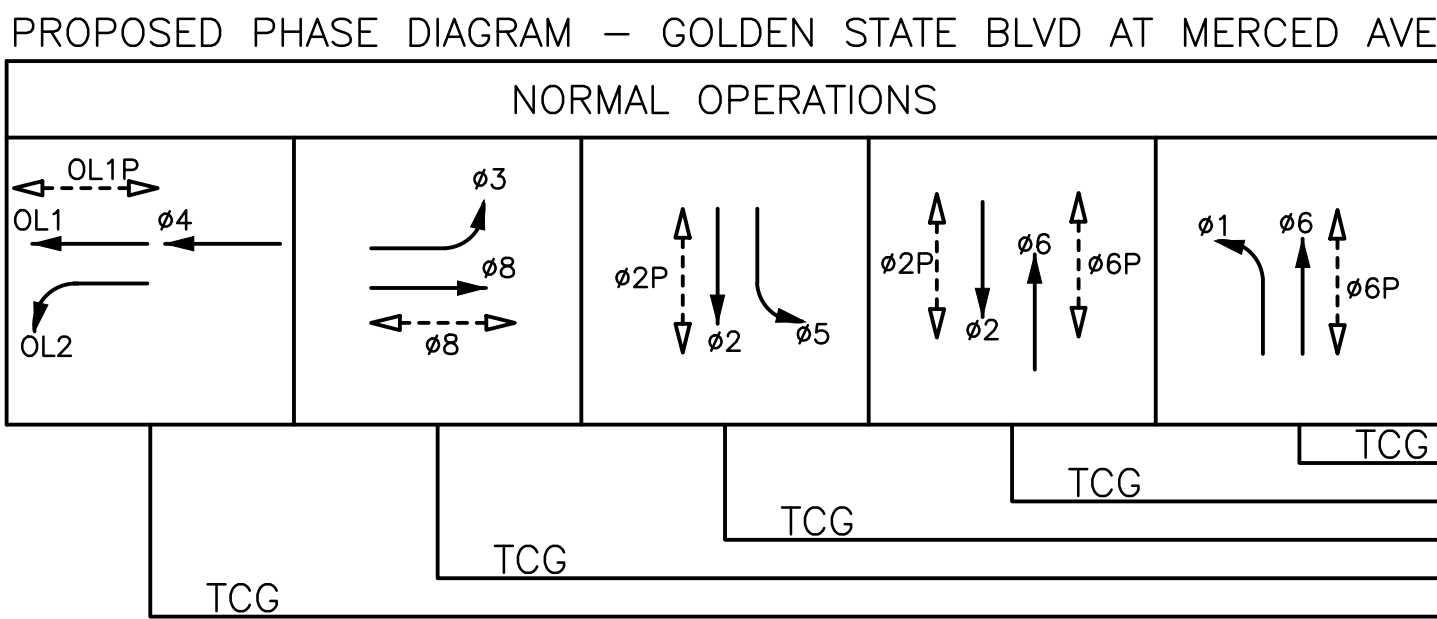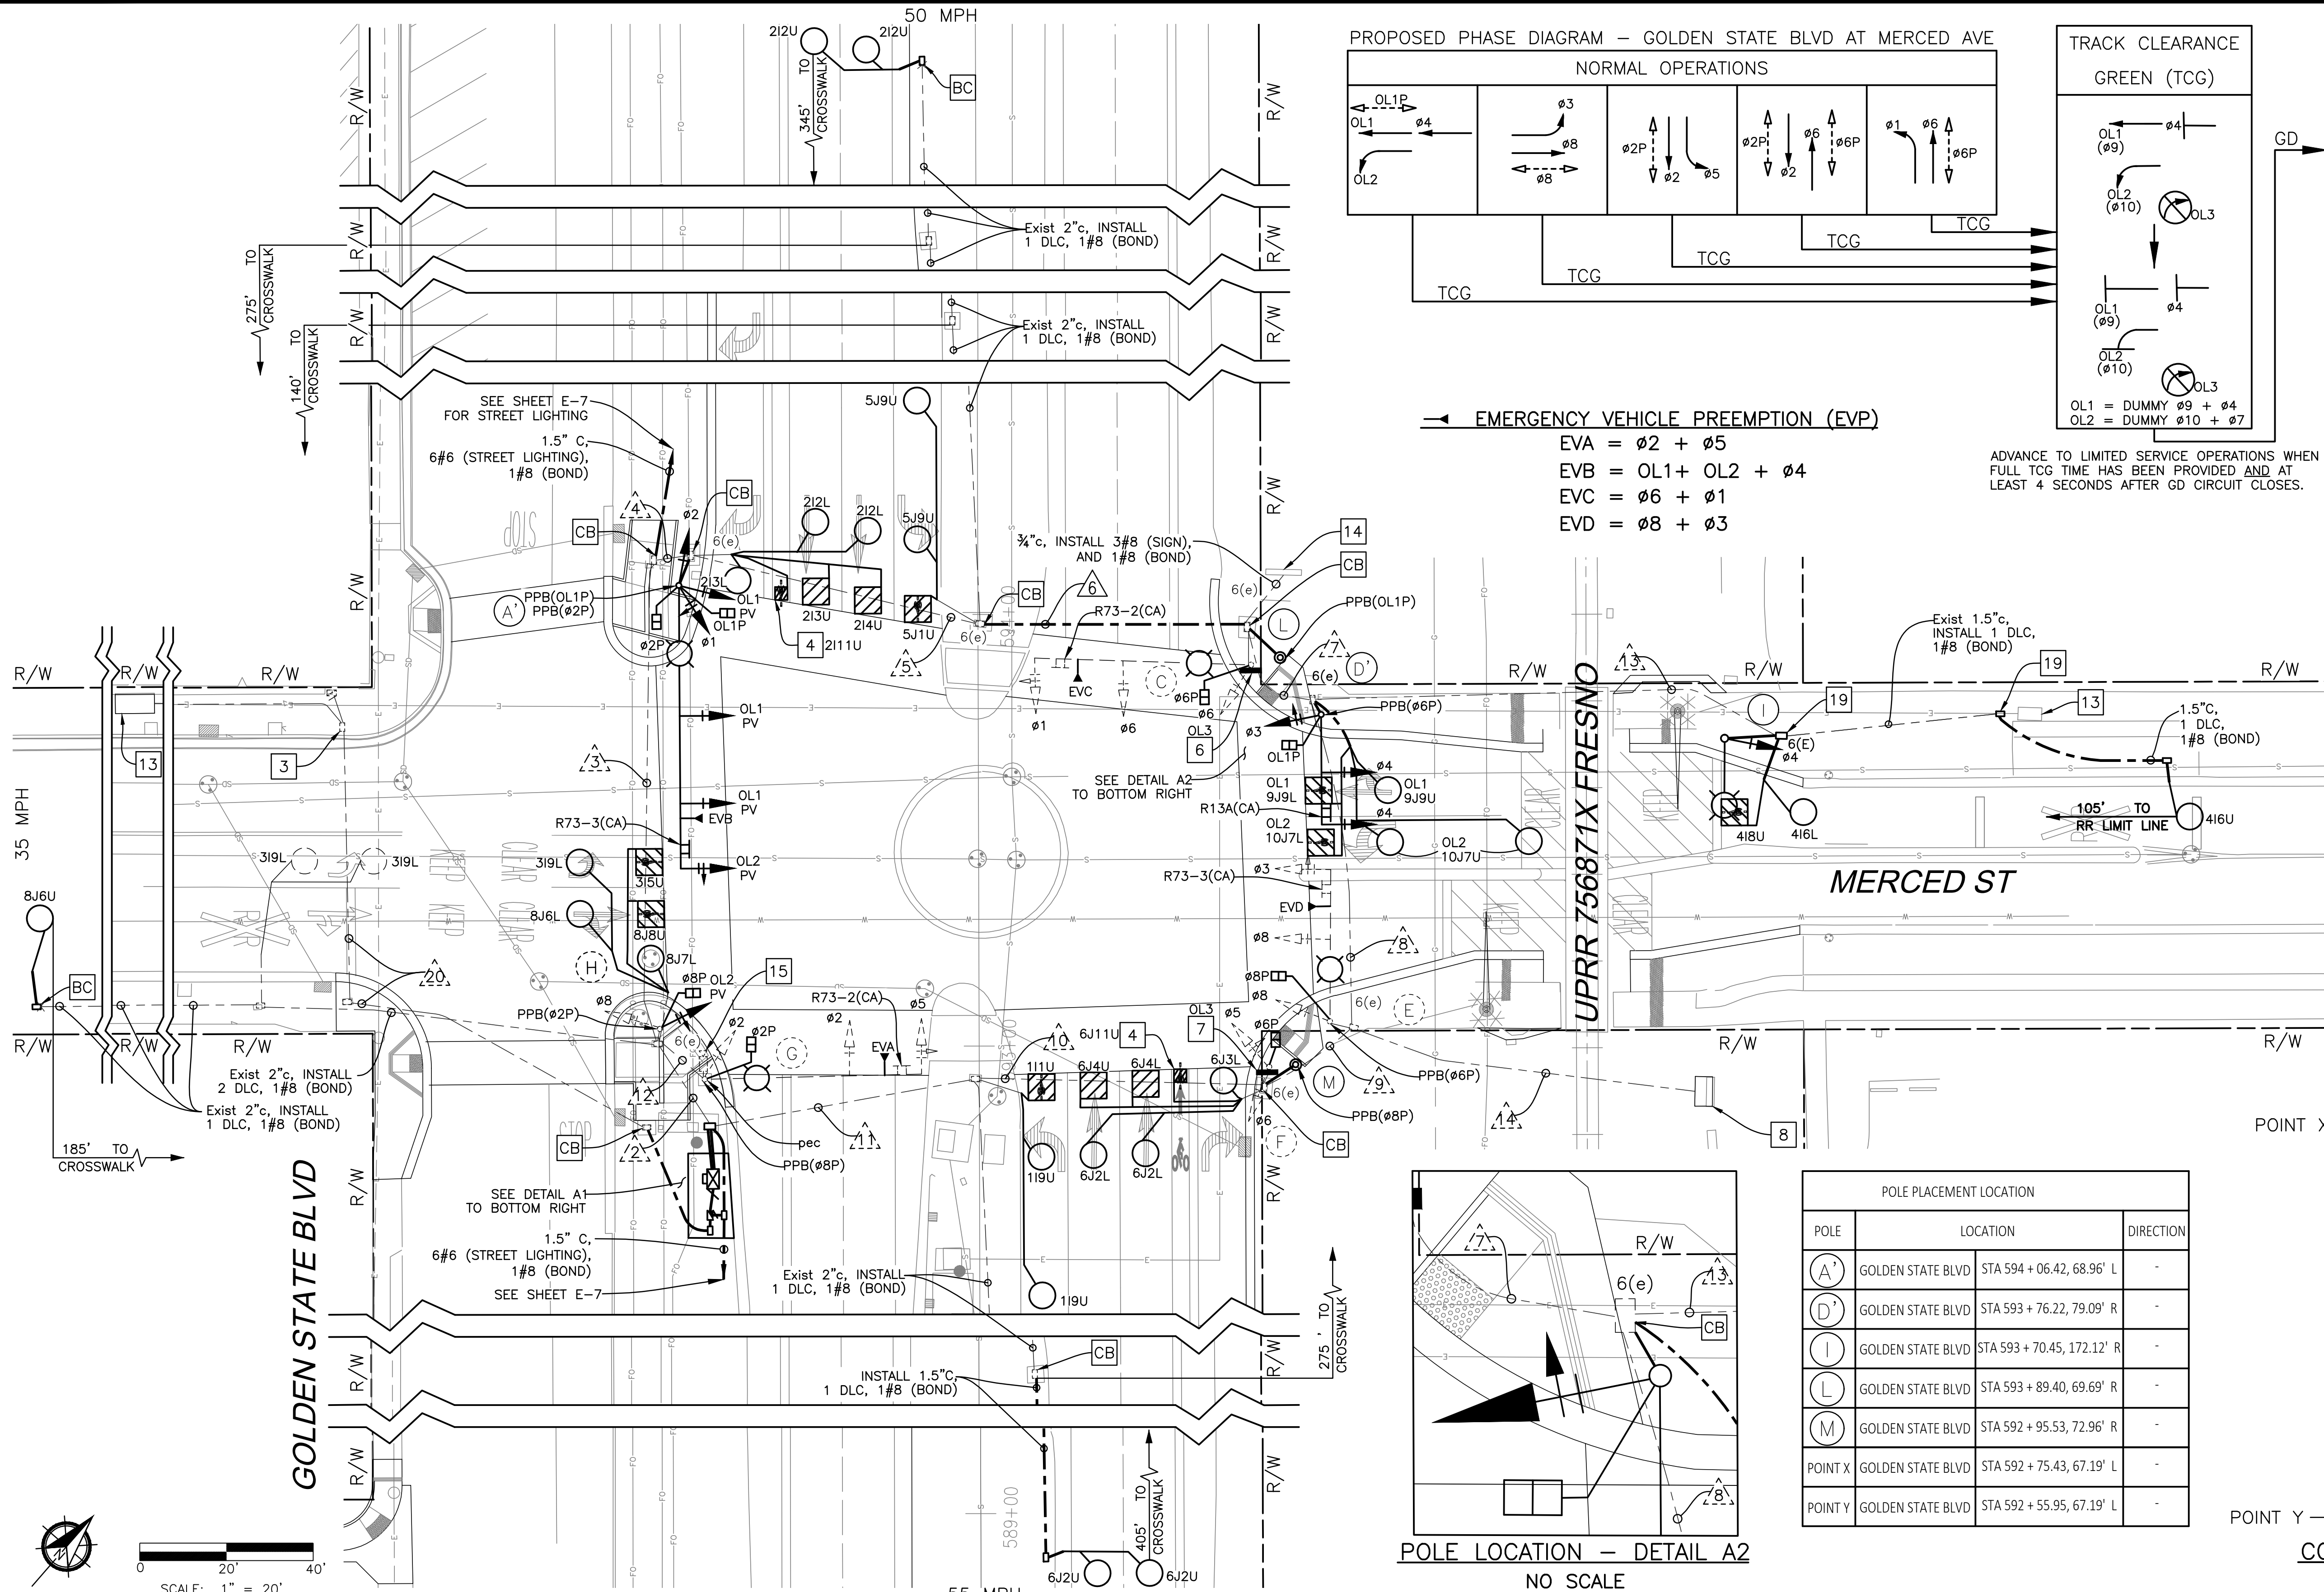


TCR = TRAFFIC CONTROL RELAY. PROVIDES ADVANCED PREEMPTION NOTIFICATION.
XR = CROSSING RELAY. PROVIDES NOTIFICATION THAT GRADE CROSSING WARNING DEVICES HAVE BEEN ACTIVATED.
GD = GATE DOWN RELAY. PROVIDES NOTIFICATION THAT RR ENTRANCE GATE DESCENT IS ALMOST COMPLETE.
* = "NO RIGHT-TURN" BLANKOUT SIGN IS ILLUMINATED WHILE XR CIRCUIT IS ACTIVE.


EMERGENCY VEHICLE PREEMPTION (EVP)

EVA = ø2 + ø5
EVB = OL1+ OL2 + ø4
EVC = ø6 + ø1
EVD = ø8 + ø3

ADVANCE TO LIMITED SERVICE OPERATIONS WHEN FULL TCG TIME HAS BEEN PROVIDED AND AT LEAST 4 SECONDS AFTER GD CIRCUIT CLOSES.

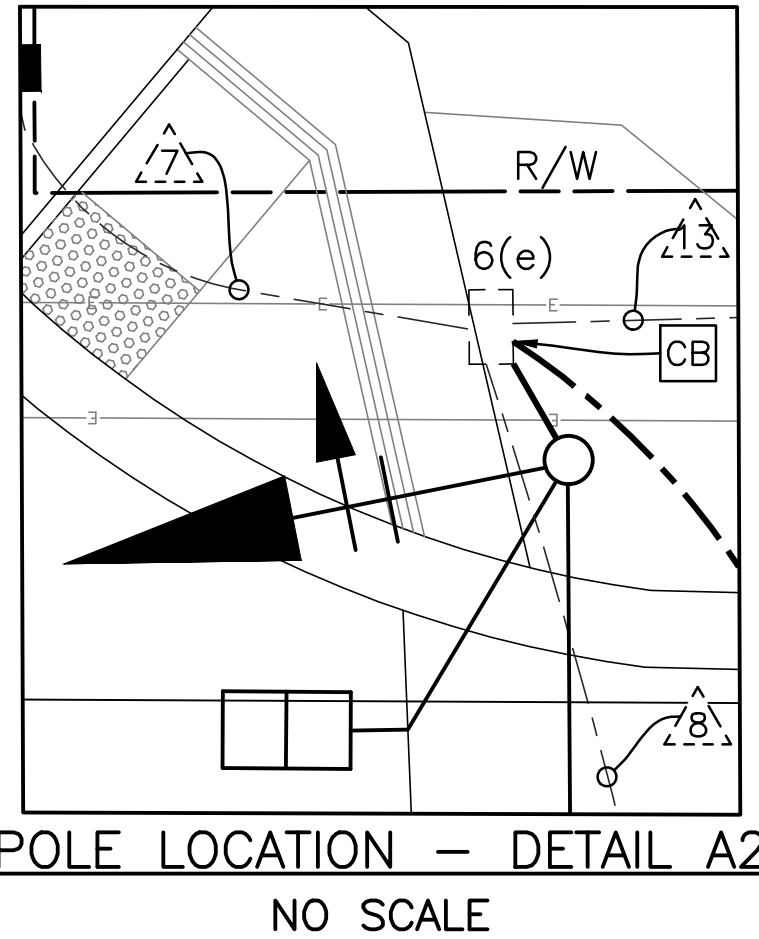

POLE PLACEMENT LOCATION		
POLE	LOCATION	DIRECTION
(A)	GOLDEN STATE BLVD STA 594 + 06.42, 68.96' L	-
(D)	GOLDEN STATE BLVD STA 593 + 76.22, 79.09' R	-
(I)	GOLDEN STATE BLVD STA 593 + 70.45, 172.12' R	-
(L)	GOLDEN STATE BLVD STA 593 + 89.40, 69.69' R	-
(M)	GOLDEN STATE BLVD STA 592 + 95.53, 72.96' R	-
POINT X	GOLDEN STATE BLVD STA 592 + 75.43, 67.19' L	-
POINT Y	GOLDEN STATE BLVD STA 592 + 55.95, 67.19' L	-

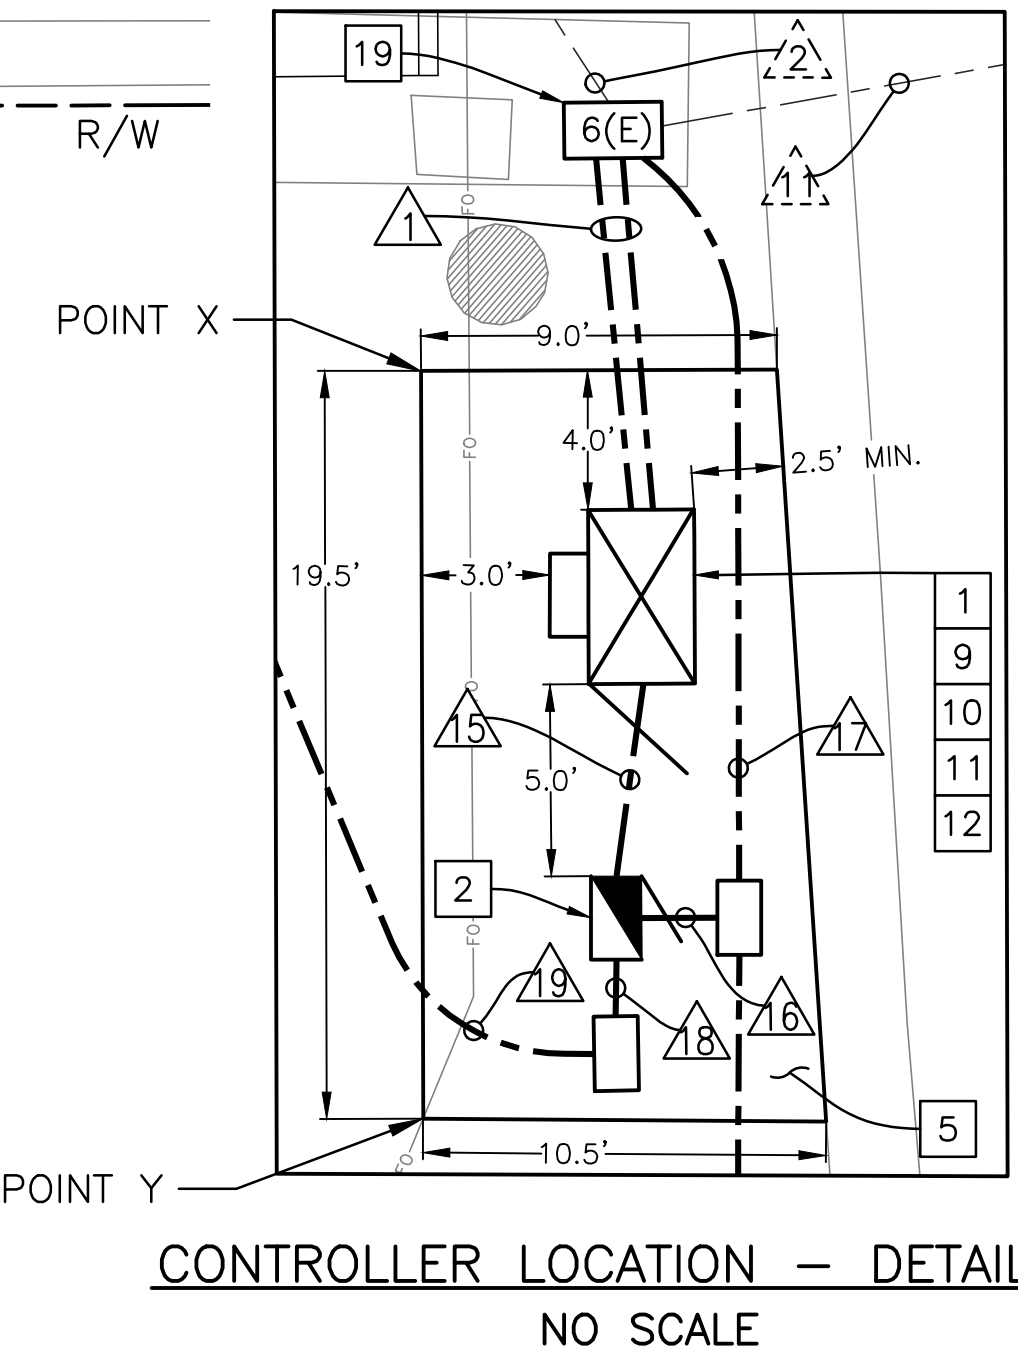

RECORD DRAWING	
DESIGNED: J. BENAVIDES	DATE: 03/24/2021
DRAWN: C. AYALA-MAGANA	DATE: 03/24/2021
CHECKED: J. RIOS	DATE: 03/24/2021

FOR RIGHT OF WAY DATA AND ACCURATE ACCESS DETERMINATION, SEE DOCUMENTS IN THE DEPARTMENT OF PUBLIC WORKS AND PLANNING.




JLB TRAFFIC
ENGINEERING, INC.
516 W. SHAW AVE., STE. 103
FRESNO, CA 93704
PHONE: (559) 570-8991
EMAIL: info@JLBTraffic.com

TENTATIVE PLANS FOR DESIGN
SUPERVISING ENGINEER
DATE



PROJECT
GOLDEN STATE CORRIDOR - ECONOMIC DEVELOPMENT AND INFRASTRUCTURE IMPROVEMENTS
FOWLER REGION

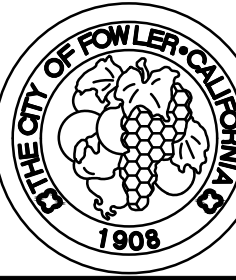

DEPARTMENT OF PUBLIC WORKS AND PLANNING
GOLDEN STATE BLVD AT MERCED ST
TRAFFIC SIGNAL MODIFICATION PLAN
DRAWING NO. E-23 SHEET NO. 130 TOTAL 142

CAD USER: CAYALA
PLOT DATE: 3/24/2021 2:34:13 PM
PATH: I:\01 Projects\009 Fresno County\009-009 Golden State Blvd at Merced St\Golden State Blvd at Merced St.dwg

PROJECT NOTES (SHEETS E-23 TO E-26 ONLY):

- 1

FURNISH AND INSTALL TYPE 2070L CONTROLLER, NEW TYPE 332L CABINET WITH ALL ANCILLARY DEVICES FOR A FULL EIGHT PHASE OPERATION AS SPECIFIED IN THE SPECIFICATIONS. TYPE 332L CABINET SHALL INCLUDE TWO AUXILIARY BAYS. FURNISH AND INSTALL NEW BATTERY BACK-UP SYSTEM PER THE SPECIAL PROVISIONS AND SHALL BE LOCATED ON THE WEST SIDE OF THE CABINET. NEW MODEL 332L SHALL BE MODIFIED FOR RAILROAD PREEMPTION. FRONT DOOR OF ASSEMBLY SHALL FACE SOUTHEAST. ADD POWER OVER ETHERNET INJECTOR FOR EACH OF THE CAMERAS.
- 2

INSTALL NEW TYPE III-AF SERVICE CABINET. CONTRACTOR SHALL COORDINATE WITH PG&E FOR DISCONNECT AND RECONNECT TO THE EXISTING POINT OF SERVICE.
- 3

EXISTING POINT OF SERVICE LOCATION BOX.
- 4

INSTALL 3'X3' BIKE LOOP PER DETAIL D AS SHOWN ON ED-1.
- 5

INSTALL 193 SQUARE FEET OF 3.5" PCC PAD.
- 6

FURNISH AND INSTALL R3-1 (24" x 24") INTERNALLY ILLUMINATED BLANK OUT SIGN PER DETAIL B AND DETAIL G AS SHOWN ON SHEET ED-1.
- 7

FURNISH AND INSTALL R3-1 (24" x 24") INTERNALLY ILLUMINATED BLANK OUT SIGN PER DETAIL B AND DETAIL F AS SHOWN ON SHEET ED-1.
- 8

EXISTING RAILROAD CONTROLLER TO REMAIN.
- 9

THE ADVANCED PREEMPTION INTERCONNECTION SHALL BE CONFIGURED AS A "SUPERVISED" CIRCUIT. A PREEMPTION INTERCONNECTION CIRCUIT SHALL BE IMPLEMENTED IN THE TRAFFIC SIGNAL CONTROLLER. CONTRACTOR SHALL WORK WITH RAILROAD, AND BE RESPONSIBLE FOR APPROVAL, TO CONNECT TO THE ADVANCED PREEMPTION CIRCUIT. A "GATE-DOWN" CIRCUIT SHALL BE IMPLEMENTED IN THE TRAFFIC SIGNAL CONTROLLER. THE RAILROAD WILL PROVIDE THE GATE DOWN CIRCUIT FOR CONNECTION TO THE TRAFFIC SIGNAL CONTROLLER AS PART OF THE RAILROAD'S STANDARD DESIGN. A TRAFFIC SIGNAL HEALTH CIRCUIT SHALL BE IMPLEMENTED INTO THE SIGNAL CONTROLLER. THE TRAFFIC SIGNAL CONTROLLER SHALL BE PROGRAMMED WITH SECOND TRAIN LOGIC.
- 10

CONTRACTOR SHALL INSTALL THE FOLLOWING WARNING LABEL WITHIN THE TRAFFIC SIGNAL CONTROLLER CABINET:
 - IF THE TRAFFIC SIGNAL ENTERS FLASHING MODE, NOTIFY THE RAILROAD AND PROVIDE FOR THE SAFE MOVEMENT OF ROADWAY USERS OVER THE GRADE CROSSING.
 - IF THE TRAFFIC SIGNAL LOSES POWER OR ALL OF THE SIGNALS ARE DARK, NOTIFY THE RAILROAD AND PROVIDE FOR THE SAFE MOVEMENT OF THE ROADWAY USERS OVER THE GRADE CROSSING.
 - NOTIFY THE RAILROAD ONCE THE SIGNAL SYSTEM HAS BEEN RESTORED TO NORMAL OPERATION.
 - IF SIGNAL MAINTENANCE IS REQUIRED TO PERFORM A JOINT TEST OF THE PREEMPTION SYSTEM, NOTIFY THE RAILROAD.
- 11

CONTRACTOR SHALL INSTALL WARNING LABEL WITHIN CONTROLLER CABINET AS RECOMMENDED IN THE USDOT HIGHWAY RAIL GRADE CROSSING TECHNICAL WORKING GROUP RECOMMENDATIONS TO ALERT TRAFFIC SIGNAL TECHNICIANS TO THE PRESENCE OF THE INTERCONNECTION WITH THE RAILROAD. SEE SAMPLE PER DETAIL I AS SHOWN ON SHEET ED-1.
- 12

COORDINATE WITH UPRR FOR THE INSTALLATION OF RAILROAD PREEMPTION CABLING AND TESTING OF THE REQUIRED RAILROAD PREEMPTION CIRCUITS. CONTACT UPRR PRIOR TO ANY WORK WITHIN UPRR RIGHT-OF-WAY OR ANY WORK AFFECTING GRADE CROSSING OPERATIONS.
- 13

EXISTING PG&E VAULT.
- 14

EXISTING FOWLER ILLUMINATED SIGN TO REMAIN.
- 15

EXISTING 4 CCTV MOUNTED ON SMA POLE.
- 16

COMPLETELY REMOVE AND DISPOSE OF CONTROLLER CABINET AND SERVICE PEDESTAL FOUNDATION AND FLAT WORK.
- 17

RL

EXISTING 1-A POLE AND ALL EQUIPMENT ATTACHED TO IT, SHALL BE PLACED IN TEMPORARY CONCRETE FOUNDATION AND REMAIN OPERATIONAL UNTIL CONSTRUCTION OF NEW MAST ARM POLE CONCLUDES. COMPLETELY REMOVE AND DISPOSE OF EXISTING 1-A POLE FOUNDATION.

RS

EXISTING 1-A POLE AFTER CONSTRUCTION CONCLUDES. PHASE 3 OF THE NEW MAST ARM POLE SHALL BE OPERATIONAL PRIOR TO REMOVAL OF THE TEMPORARY 1-A POLE.
- 18

RS

ALL EXISTING PEDESTRIAN PUSH BUTTON ASSEMBLIES ON EXISTING POLES.
- 19

RS

EXISTING PULL BOX AND

BC

A NEW PULL BOX.

LEGEND (SHEETS E-23 TO E-26 ONLY):

- TYPE E CIRCULAR LOOP DETECTOR CONFIGURATION PER STATE STANDARD PLAN ES-5B. LOOP SEALANT SHALL BE STATE APPROVED ELASTOMERIC SEALANT OR HOT MELT RUBBERIZED.
- EXISTING TYPE E LOOP DETECTOR.
- TYPE D LOOP DETECTOR CONFIGURATION PER STATE STANDARD PLAN ES-5B. LOOP SEALANT SHALL BE STATE APPROVED ELASTOMERIC SEALANT OR HOT MELT RUBBERIZED. BICYCLE DETECTOR SYMBOL TO BE INSTALLED PER CALTRANS STANDARD PLAN A24-C ON CENTER OF THE DETECTOR WHERE SHOWN ON PLAN. ARROW SIGNIFIES DIRECTION OF TRAVEL.
- EXISTING TYPE A LOOP DETECTOR.
- EMERGENCY VEHICLE PREEMPTION (EVP) DETECTION UNIT
EVX (DENOTES CHANNEL).
- NEW CONDUIT
- EXISTING CONDUIT
- PV PROGRAMMABLE VISIBILITY VEHICLE SIGNAL HEAD
- EXISTING CCTV
- ABANDON, IF APPLIED TO CONDUIT, REMOVE CONDUCTORS.
- REMOVE AND SALVAGE EQUIPMENT.
- EQUIPMENT OR MATERIAL TO BE REMOVED AND BECOME THE PROPERTY OF THE CONTRACTOR.
- FOUNDATION TO BE ABANDONED. REMOVE TOP OF FOUNDATION TO A POINT 36" BELOW THE FINISH GRADE.
- CONNECT NEW AND EXISTING CONDUIT. REMOVE EXISTING CONDUCTORS AND INSTALL CONDUCTORS AS INDICATED.
- INSTALL NEW CONDUIT INTO EXISTING PULL BOX.
- INSTALL PULL BOX IN EXISTING CONDUIT RUN.
- RELOCATE EQUIPMENT.

GENERAL NOTES (SHEETS E-23 TO E-26 ONLY):

1.

WORK SHALL BE DONE IN ACCORDANCE WITH THE STATE OF CALIFORNIA DEPARTMENT OF TRANSPORTATION STANDARD PLANS AND SPECIFICATIONS, 2010 EDITION, THE LATEST CALTRANS ADOPTED EDITION OF THE CALIFORNIA MANUAL ON UNIFORM TRAFFIC CONTROL DEVICES (CA-MUTCD), AND THE LATEST EDITION OF THE CITY OF FRESNO STANDARD SPECIFICATIONS AND DRAWINGS. SIGNAL POLES/STANDARDS FOR 113KM/H WIND VELOCITY AND TYPE 1-A POLES SHALL BE PER THE STATE STANDARD PLANS AND SPECIFICATIONS, DATED JULY 1997.
2.

THESE PLANS ARE ACCURATE FOR ELECTRICAL WORK ONLY.
3.

NO ABOVE GROUND WORK, EXCEPT SERVICE EQUIPMENT, SHALL BE PERFORMED UNTIL THE CONTRACTOR HAS ALL MATERIALS ON HAND TO COMPLETE THAT PARTICULAR SIGNAL LOCATION OR LIGHTING CIRCUIT.
4.

THE CONTRACTOR IS RESPONSIBLE FOR VERIFICATION OF ALL EXISTING UTILITIES WHETHER OR NOT THEY ARE SHOWN ON THESE PLANS, AND SHALL PROVIDE PROTECTION PRIOR TO, DURING AND AFTER TRENCHING, JACKING AND/ OR BORING. THE CONTRACTOR SHALL CONTACT UNDERGROUND SERVICE ALERT (USA), BY CALLING 1-800-227-2600 AT LEAST TWO (2) WORKING DAYS BEFORE BEGINNING WORK.
5.

CONDUIT INSTALLATION ACROSS ROADWAYS SHALL BE BY JACKING AND DIRECTIONAL DRILLING METHODS UNLESS OTHERWISE NOTED ON THE PLANS.
6.

CONTRACTOR SHALL ARRANGE WITH UTILITY COMPANIES FOR ALL REQUIRED UTILITY RELOCATIONS, INCLUDING OVERHEAD CONFLICTS.
7.

ALL TRAFFIC SIGNAL AND LIGHTING FACILITIES, INCLUDING CABINETS, STANDARDS, PULL BOXES, CONDUITS AND LOOP DETECTORS, ARE SHOWN IN THEIR APPROXIMATE LOCATIONS. AFTER ALL UNDERGROUND UTILITIES ARE MARKED, THE CONTRACTOR SHALL MARK FINAL LOCATIONS IN THE FIELD AND NOTIFY THE ENGINEER AT LEAST TWO (2) WORKING DAYS PRIOR TO COMMENCING WORK TO OBSERVE THE MARKED LOCATIONS.
8.

ALL SALVAGED EQUIPMENT SHALL BE RETURNED TO THE CITY OF FOWLER PUBLIC WORKS DEPARTMENT. THE CONTRACTOR SHALL NOTIFY THE CITY, CONTACT AT LEAST TWO (2) WORKING DAYS PRIOR TO DELIVERY. CONTRACTOR SHALL PROVIDE ADEQUATE MEANS FOR SAFELY UNLOADING EQUIPMENT.
9.

PULL BOXES SHALL BE NO. 5(E), UNLESS OTHERWISE NOTED ON THE PLANS. PULL BOXES SHALL NOT BE INSTALLED IN CURB RAMPS OR DRIVEWAYS. VANDAL RESISTANT LOCKING LIDS SHALL BE PROVIDED AND INSTALLED BY THE CONTRACTOR AT FINAL INSPECTION OF THE TRAFFIC SIGNAL. CONTRACTOR SHALL PROVIDE TEMPORARY LIDS DURING CONSTRUCTION. ALL PULL BOXES SHALL BE AT A MAXIMUM OF 200' APART. LIDS SHALL BE TORQUED TO 25 FT. LBS.
10.

ALL PULL BOXES INSTALLED IN NON-CONCRETE AREAS SHALL BE SURROUNDED BY A ONE (1) FOOT WIDE CONCRETE COLLAR, TO A DEPTH EQUAL TO THE PULL BOX AND EXTENSION, PER CITY OF FRESNO SPECIFICATIONS, AND SHALL HAVE A VANDAL RESISTANT (SEE NOTE ABOVE) LOCKING LID INSTALLED. ALL CONDUIT ENTRIES INTO ADVANCE DETECTION, INTERMEDIATE DETECTION, AND STREET LIGHTING PULL BOXES INSTALLED IN NON-CONCRETE AREAS SHALL ENTER THE PULL BOX FROM THE BOTTOM, USING 90 DEGREE ELBOWS AND EXTENDING 3 TO 5 INCHES ABOVE THE FINISHED GROUT.
11.

ALL CONDUITS SHALL HAVE BUSHINGS INSTALLED PRIOR TO INSTALLING CONDUCTORS. STEEL CONDUITS SHALL HAVE LAY IN STYLE LUGS THAT ARE CAST INTEGRAL WITH THE BUSHING.
12.

CONDUIT BENDS OF 90 DEGREES ARE PROHIBITED UNLESS OTHERWISE NOTED OR WRITTEN PERMISSION IS GIVEN BY THE CITY OF FOWLER ENGINEER.
13.

ALL NEUTRAL CONDUCTORS SHALL BE WHITE IN COLOR THROUGHOUT THEIR ENTIRE LENGTH.
14.

TRAFFIC SIGNAL CABLE SHALL NOT BE SPLICED BETWEEN THE CONTROLLER CABINET AND THE TERMINAL COMPARTMENTS MOUNTED ON THE POLES. DETECTOR CABLES SHALL NOT BE SPLICED BETWEEN THE CONTROLLER CABINET AND THE PULL BOX ADJACENT TO THE DETECTOR LEAD-IN.
15.

PEDESTRIAN MODULE SHALL BE INSTALLED ON THE LEFT SIDE, FACING THE FRONT, OF THE 332 CABINET.
16.

SEAL CONDUIT WITH AN APPROVED DUCT SEAL AFTER ALL CONDUCTORS HAVE BEEN INSTALLED.
17.

SEALANT FOR FILLING THE SAWCUT LOOPS SLOTS SHALL BE HOT-MELT RUBBERIZED ASPHALT SEALANT PER STATE OF CALIFORNIA SPECIFICATIONS, OR ELASTOMERIC SEALANT, 3M, BLACK 5000.
18.

PEDESTRIAN PUSH BUTTONS SHALL HAVE 2" DIAMETER ACTUATORS AND COMPLY WITH THE AMERICANS WITH DISABILITIES ACT (ADA).
19.

ALL VEHICLE AND PEDESTRIAN SIGNAL SECTIONS SHALL UTILIZE LIGHT EMITTING DIODE (LED) SIGNAL MODULES IN ACCORDANCE WITH THE STANDARD SPECIFICATIONS. VEHICLE SIGNAL SECTIONS SHALL HAVE 12" (300 mm) DIAMETER LENSES WITH BACKPLATES AND TUNNEL VISORS. ALL VEHICLE AND PEDESTRIAN SIGNAL SECTIONS SHALL HAVE METAL AND RUBBER WASHERS INSTALLED ON THE INSIDE OF THE HEAD.
20.

SAFETY LUMINAIRE SHALL BE LED (EQUAL TO 150W HPS), SEE UPDATED CITY OF FRESNO SPECIFICATIONS FOR SAFETY LUMINAIRE REQUIREMENTS.
21.

PEDESTRIAN SIGNAL UNITS SHALL BE FULL SYMBOL, MUTCD COMPLIANT, LED "COUNTDOWN" TYPE WITH 9 INCH NUMERALS; GELCORE MODEL PS7-CFF1-01A-18, OR APPROVED EQUAL. SIGNAL ALIGNMENT SHALL BE AS DIRECTED BY THE ENGINEER.
22.

THE CONTRACTOR SHALL FURNISH AND INSTALL A COMPLETE OPTICOM (GTT) EMERGENCY VEHICLE PREEMPTION (EVP) SYSTEM (721 TWO DIRECTION DETECTION, SINGLE CHANNEL) IN ACCORDANCE WITH THE CITY STANDARD SPECIFICATIONS. EVP DETECTOR UNITS SHALL BE INSTALLED ON SIGNAL MAST ARMS AS SHOWN ON THE PLAN, CENTERED OVER THE NUMBER ONE THROUGH LANE, WITH BRACKETS APPROVED BY THE TRAFFIC SIGNAL SUPERVISOR. THE CONTRACTOR SHALL DELIVER THE MODEL 762 DISCRIMINATORS TO THE CITY CORPORATION YARD AT 2101 "G" STREET, FRESNO, AND NOTIFY THE CITY TRAFFIC SIGNAL SHOP, (559) 621-1312, AT LEAST TWO (2) WORKING DAYS PRIOR TO DELIVERY.
23.

CONTRACTOR SHALL SCHEDULE WITH THE CITY OF FRESNO TSSL SHOP AT (559) 621-1312 ALL EQUIPMENT DELIVERIES WHICH REQUIRE TESTING BY THE CITY'S TSSL SHOP. EQUIPMENT SHALL BE DELIVERED BY THE CONTRACTOR ONLY AT A PREARRANGED TIME AND DAY.
24.

THE CONTRACTOR SHALL FURNISH AND INSTALL NEW STREET NAME SIGN ON SMA COMPLETE WITH VARIABLE LENGTH MOUNTING HARDWARE, AS SHOWN ON THE PLAN. FURNISH AND INSTALL NEW MOUNTING BRACKETS AS NECESSARY. SUBMITTALS SHALL BE APPROVED BY THE CITY PRIOR TO ORDERING.
25.

ALL SIGNS SHALL BE 3M-3930HIP TYPE III & IV SERIES REFLECTIVE SHEETING AND BE COVERED WITH 1160A PREMIUM OVERLAY ANTI-GRAFFITI FILM OR AVERY DENNISON T6500 SERIES REFLECTIVE SHEETING AND SHALL BE COVERED WITH AVERY DENNISON OL1000 ANTI-GRAFFITI OVERLAY FILM.
26.

CONDUITS EXITING THE CONTROLLER FOUNDATION AND ENTERING INTO THE CONTROLLER CABINET SHALL BE ALIGNED TO ENTER WITHIN THE TEES SPECIFIED CABINETS WITHOUT ANY MODIFICATIONS TO THE CABINET BASE.
27.

ALL RESURFACING SHALL MATCH EXISTING SURFACES AFTER SIGNAL FACILITIES ARE REMOVED AND/OR RELOCATED.
28.

THE EXISTING TRAFFIC SIGNAL SYSTEM, INCLUDING DETECTION, AND/OR STREET LIGHTING SHALL REMAIN OPERATIONAL DURING CONSTRUCTION, UNLESS OTHERWISE AUTHORIZED IN WRITING BY THE CITY ENGINEER.
29.

ALL LUMINAIRE CIRCUITS SHALL BE FUSED. THE FUSE SHALL BE LOCATED IN THE LUMINAIRE HEAD (5 AMP KTK FUSE IN TRON HEB TYPE FUSE HOLDER).
30.

THE CONTRACTOR SHALL FURNISH AND INSTALL POLE NUMBERS WHEN PG&E INDICATES THE NUMBER. POLE NUMBERS SHALL BE SHOWN ON THE AS BUILT DRAWINGS.
31.

THE CONTRACTOR SHALL FURNISH AND INSTALL A COMPLETE ACCESSIBLE (AUDIBLE) PEDESTRIAN SIGNAL (APS) SYSTEM (2-WIRE POLARA NAVIGATOR OR APPROVED EQUAL) IN CONFORMANCE WITH THE CITY OF FRESNO STANDARD SPECIFICATIONS. THE APS SHALL PROVIDE BOTH A VIBRATING ARROW BUTTON AND AUDIBLE SOUNDS DURING THE "WALK" INTERVAL, AS WELL AS A LOCATING TONE DURING THE PEDESTRIAN CLEARANCE AND DON'T WALK INTERVALS. THE APS SYSTEM SHALL MEET CURRENT ADA AND CA-MUTCD REQUIREMENTS. ALL PEDESTRIAN PUSH BUTTONS SHALL HAVE A FOUR FOOT ACCESSIBLE PATH IN FRONT OF THE BUTTON. THE APS CENTRAL CONTROL UNIT (CCU) SHALL BE MOUNTED WITH A CITY-APPROVED MANUFACTURED BRACKET, McCain M49021 OR APPROVED EQUAL. CCU SHALL BE MOUNTED TO THE REAR RACK, IN THE UPPER LEFT CORNER WHEN VIEWED FROM THE FRONT OF THE CABINET. THE POWER SUPPLY PIGTAIL SHALL BE CUT TO LENGTH TO ELIMINATE EXCESS CABLE, WITH POWER OBTAINED FROM THE PDA T1 TERMINAL STRIP. TERMINALS 1, 3, & 5. CONTRACTOR SHALL PROVIDE CITY OF FRESNO TSSL THE LATEST MEANS OF PROGRAMMING THE APS SYSTEM AND DIGITAL COPIES OF THE CUSTOM AUDIO VIA EMAIL.

CONSTRUCTION NOTES (SHEETS E-23 TO E-26 ONLY):

1.

ALL PULL BOXES ACCESSED BY CONTRACTOR SHALL BE CLEANED OF ALL DIRT AND DEBRIS, ANY CRACKS GROUTED AND ALL CONDUITS DUCT SEALED.
2.

ALL PULLBOXES SHALL BE LEVELED TO FINISH GRADE (NEW AND EXISTING).
3.

ALL PULLBOXES IN DIRT AREAS SHALL HAVE 1' COLLAR PER GENERAL NOTE 10 (NEW).
4.

ANY PULLBOXES BROKEN/DAMAGED BY CONTRACTOR SHALL BE REPLACED.
5.

ALL PULLBOXES SHALL HAVE LOCKING LIDS. TRAFFIC RATED LIDS SHALL BE WELDED CLOSED AFTER FINAL INSPECTION.
6.

ALL UNUSED CONDUCTORS SHALL BE REMOVED.

		DATE	RECORD DRAWING		PROJECT		DEPARTMENT OF PUBLIC WORKS AND PLANNING	
DESIGNED:	J. BENAVIDES	03/24/2021	RESIDENT ENGINEER	DATE	GOLDEN STATE CORRIDOR - ECONOMIC DEVELOPMENT AND INFRASTRUCTURE IMPROVEMENTS		GOLDEN STATE BLVD AT MERCED ST LEGEND AND NOTES	
DRAWN:	C. AYALA-MAGANA	03/24/2021						
CHECKED:	J. RIOS	03/24/2021						
FOR RIGHT OF WAY DATA AND ACCURATE ACCESS DETERMINATION, SEE DOCUMENTS IN THE DEPARTMENT OF PUBLIC WORKS AND PLANNING.					FOWLER REGION		DRAWING NO.	E-24
							SHEET NO.	131
							TOTAL	142

PATH: Z:\01 Projects\009 Fresno County\009-009 Golden State PS&E\Traffic Signal Designs\2a Golden State Blvd at Merced St\Golden State Blvd at Merced St.dwg
 PLOT DATE: 3/24/2021 2:34:55 PM
 CAD USER: CAYALA

CONDUCTOR SCHEDULE																							
AWG OR CABLE	POLE	Ø	CONDUIT RUN NUMBER AND SIZE																				
			1	2	3	4	5	6	7	8	9	10	11	12	13	14	15	16	17	18	19	20	
			2.4"	6"	3"	3"	3"	3"	3"	3"	3"	3"	3"	3"	3"	3"	3"	3"	3"	3"	3"	3"	3"
CONDUIT FILL			23%	29%	39%	33%	17%	14%	15%	12%	24%	33%	21%	25%	28%	22%	14%	30%	28%	13%	13%	2"	1 1/2"
7 COND. CABLE (VEH.) *	A'	1/2 OL1P	2	2	2	2																	
	C	1,6 6P	1	1	1	1	1	1															
	D'	3,4 OL1P	1	1	1	1	1	1	1														
	E	3,8 8P	1	1							1	1	1	1									
	F	5,6 6P	1	1								1	1	1									
	G	2,5 2P	1	1	1									1	1								
	H	8,OL2 8P	1	1	1																		
	I	4 -	1	-							1	-	1	-	1	-							
TOTAL			9	7	6	5	4	3	4	3	2	2	1	2	2	1	1	2	3	2	1	1	
3 COND. CABLE (PPB)	A'	2P,OL1P	1	1	1	1																	
	C	6P,OL1P	1	1	1	1	1	1															
	E	6P,8P	1								1	1	1										
	G	2P,8P	1	1										1									
TOTAL			4	3	2	2	1	1			1	1	1	1									
TYPE C DETECTOR LEAD-IN CABLE	Ø1		2										2										
	Ø2		6	6	6	6	1																
	Ø3		2	2																			
	Ø4		3								3	3	3	3		3							
	Ø5		2	2	2	2	2																
	Ø6		6										5	6									
	Ø8		4	4																			
	OL1		2	2	2	2	2	2	2														
	OL2		2	2	2	2	2	2	2														
	PED PUSH BUTTON								1		1				1								
TOTAL DLC			29	18	12	12	7	4	5	3	4	8	11	1	3								
# 2	SERVICE																			3	3	3	
# 4	SIGNAL POWER																2						
# 6	STREET LIGHTING			6	6													12	6				
# 8	SIGN								3	3	3	3	3						3	3			
# 8	SAFETY LIGHTS			2	2	2			2	2	2	2	2	2	2				2	2			
# 8	BONDING WIRE	1	1	1	1	1	1	1	1	1	1	1	1	1	1	1	1	1	1				
# 12	PEU CONTROL			3											3				3	3			
#14	BLANK OUT SIGN	4							2	2	2	4	4										
12 COND. CABLE (#14 AWG)	R,R INTERCONNECT	1										1	1	1			1						
CAT5E	CAMERA	1	1												1								
EVP CABLE 3 COND.	EVA (S/B)	1	1												1								
	EVB (W/B)	1	1	1	1																		
	EVC (N/B)	1							1	1	1	1	1										
	EVD (E/B)	1										1	1	1									

NUMBER INDICATIONS ARE THE NUMBER OF CABLES WITHIN CONDUIT.
 * ALL CONDUCTORS ARE NEW UNLESS OTHERWISE INDICATED WITH "()".

EQUIPMENT SCHEDULE

EQUIPMENT SCHEDULE												
No.	STANDARD			VEH SIG MTG		PED SIGNAL		PPB		LED LUMINAIRE WATTAGE	PG&E POLE #	SPECIAL REQUIREMENTS
	Type	Sig. M.A.	Lum.M.A.	Mast Arm	Pole	ø	MTG	ø	ARROW			
(A)	61-5-129	60'	15'	MAT MAS MAS	SV-1-T	2	SP-1-T	2	LEFT	101W	2171	REMOVE AND SALVAGE EXISTING SIGNAL STANDARD AND ALL EQUIPMENT ATTACHED TO IT.
(A')	61-5-129 (N)	65' (N)	15' (N)	(N) MAT (N) MAS _{F=15'} (N) MAS _{F=35'}	SV-3-TB (N)	2 (N) OL1 (N)	SP-2-T (N)	2 (N) OL1 (N)	RIGHT (N) RIGHT (N)	78W (N)	2171 (N)	FURNISH AND INSTALL EVB AND R73-3(CA) SIGN ON SMA COMPLETE WITH MOUNTING HARDWARE. FURNISH AND INSTALL PV ON VEHICLE SIGNAL HEADS. FURNISH AND INSTALL SNS "GOLDEN STATE BLVD" ON SMA COMPLETE WITH MOUNTING HARDWARE.
(B)	1-A (10')	-	-	-	TV-2-T	4	SP-1-T	-	-	-	-	REMOVE AND SALVAGE EXISTING 1-A POLE AND ALL EQUIPMENT ATTACHED TO IT.
(C)	29-5-129	50'	15'	MAT MAS	SV-1-T	6 (N)	SP-1-T (N)	OL1	LEFT	78W (N)	2169	EXISTING SIGNAL STANDARD WITH R73-2(CA) AND SNS "MERCED ST" SIGNS TO REMAIN. FURNISH AND INSTALL EVC ON SMA COMPLETE WITH MOUNTING HARDWARE. FURNISH AND INSTALL R3-1 INTERNALLY ILLUMINATED BLANK OUT SIGN ON POLE COMPLETE WITH MOUNTING HARDWARE. REMOVE AND SALVAGE EXISTING PEDESTRIAN HEAD AND MOUNTING HARDWARE, PPB ASSEMBLY AND LUMINAIRE. FURNISH AND INSTALL NEW PEDESTRIAN SIGNAL HEAD AND LUMINAIRE.
(D)	1-A (10')	-	-	-	TV-2-T	4	SP-1-T	6	RIGHT	-	-	RELOCATE EXISTING 1-A POLE AND ALL EQUIPMENT ATTACHED TO IT, SHALL BE PLACED IN TEMPORARY CONCRETE FOUNDATION AND REMAIN OPERATIONAL UNTIL CONSTRUCTION OF NEW MAST ARM POLE CONCLUDES. COMPLETELY REMOVE AND DISPOSE OF EXISTING 1-A POLE FOUNDATION. REMOVE AND SALVAGE EXISTING 1-A POLE AFTER CONSTRUCTION CONCLUDES. PHASE 3 OF THE NEW MAST ARM POLE SHALL BE OPERATIONAL PRIOR TO REMOVAL OF THE TEMPORARY 1-A POLE.
(D')	18-3-113 (N)	25' (N)	-	(N) MAT (N) MAS _{F=12'}	SV-1-T (N)	OL1 (N)	SP-1-T (N)	6 (N)	RIGHT (N)	-	-	FURNISH AND INSTALL R13A (CA) SIGN ON SMA COMPLETE WITH MOUNTING HARDWARE.
(E)	24-4-129	35'	15'	MAT MAS	SV-1-T	8 (N)	SP-1-T (N)	6 (N)	LEFT (N)	78W (N)	2172	EXISTING SIGNAL STANDARD WITH R73-3(CA) AND SNS "GOLDEN STATE BLVD" SIGNS TO REMAIN. FURNISH AND INSTALL EVD ON SMA COMPLETE WITH MOUNTING HARDWARE. REMOVE AND SALVAGE EXISTING PEDESTRIAN HEAD AND MOUNTING HARDWARE, PPB ASSEMBLY AND LUMINAIRE. FURNISH AND INSTALL NEW PEDESTRIAN SIGNAL HEAD, APS PPB ASSEMBLY AND LUMINAIRE.
(F)	1-A (10')	-	-	-	TV-2-T	6 (N)	SP-1-T (N)	8	RIGHT	-	-	FURNISH AND INSTALL R3-1 INTERNALLY ILLUMINATED BLANK OUT SIGN ON POLE COMPLETE WITH MOUNTING HARDWARE. REMOVE AND SALVAGE EXISTING PEDESTRIAN HEAD AND MOUNTING HARDWARE AND PPB ASSEMBLY. FURNISH AND INSTALL NEW PEDESTRIAN SIGNAL HEAD.
(G)	29-5-129	50'	15'	MAT MAS	SV-1-T	2 (N)	SP-1-T (N)	8 (N)	LEFT (N)	78W (N)	2170	EXISTING SIGNAL STANDARD WITH R73-2(CA) AND SNS "MERCED ST" SIGNS TO REMAIN. FURNISH AND INSTALL EVC ON SMA COMPLETE WITH MOUNTING HARDWARE. REMOVE AND SALVAGE EXISTING PEDESTRIAN HEAD AND MOUNTING HARDWARE, PPB ASSEMBLY AND LUMINAIRE. FURNISH AND INSTALL NEW PEDESTRIAN SIGNAL HEAD, APS PPB ASSEMBLY AND LUMINAIRE.
(H)	1-A (10')	-	-	-	TV-2-T	8 (N)	SP-1-T (N)	2 (N)	RIGHT (N)	-	-	EXISTING 1-A POLE TO REMAIN. FURNISH AND INSTALL PV ON OL2 VEHICLE HEAD. REMOVE AND SALVAGE EXISTING PEDESTRIAN HEAD AND MOUNTING HARDWARE AND PPB ASSEMBLY. FURNISH AND INSTALL NEW PEDESTRIAN SIGNAL HEAD AND APS PPB ASSEMBLY.
(I)	15-TS (N)	-	15' (N)	-	SV-1-T (N)	-	-	-	-	78W (N)	XXXX	FURNISH AND INSTALL R13(CA) AND R10-6(LT) SIGNS ON POLE COMPLETE WITH MOUNTING HARDWARE.
(J)	PPB POST (2 ½")	-	-	-	-	-	-	4	RIGHT LEFT	-	-	REMOVE AND SALVAGE EXISTING PPB POST AND ALL EQUIPMENT ATTACHED TO IT.
(K)	PPB POST (2 ½")	-	-	-	-	-	-	8	RIGHT LEFT	-	-	REMOVE AND SALVAGE EXISTING PPB POST AND ALL EQUIPMENT ATTACHED TO IT.
(L)	PPB POST (2 ½")(N)	-	-	-	-	-	-	OL1 (N)	LEFT (N)	-	-	PPB POST SHALL BE 5'7" IN HEIGHT.
(M)	PPB POST (2 ½")(N)	-	-	-	-	-	-	8 (N)	RIGHT (N)	-	-	PPB POST SHALL BE 5'7" IN HEIGHT.


- NOTES:
- ALL EQUIPMENT IS EXISTING UNLESS OTHERWISE NOTED WITH (N).
 - ALL INDICATIONS SHALL BE 12" LED MODULES.
 - STREET NAME SIGNS SHALL BE WHITE LETTERS ON GREEN BACKGROUND, 12" UPPERCASE, 9" LOWERCASE, 4" BLOCK NUMBERS, 4" WIDE ARROWS, SERIES "D" TEXT ON TYPE XI DIAMOND GRADE SHEETING AND 3M TYPE XI DG3 OR APPROVED EQUAL.
 - LED INTERSECTION SAFETY LIGHT LUMINAIRES INSTALLED AND SHALL BE CREE RSW5-A-HT-3ME-6L-40K7-UL-GY-N FULL POWER: 78W, 9325 LUMEN, 4000K, CRI70-B1-U0-G2, RSW59056&SP.

DESIGNED: J. BENAVIDES		DATE: 03/24/2021	RECORD DRAWING	
DRAWN: C. AYALA-MAGANA		DATE: 03/24/2021	RESIDENT ENGINEER	DATE
CHECKED: J. RIOS		DATE: 03/24/2021		
FOR RIGHT OF WAY DATA AND ACCURATE ACCESS DETERMINATION, SEE DOCUMENTS IN THE DEPARTMENT OF PUBLIC WORKS AND PLANNING.				






PROJECT	
GOLDEN STATE CORRIDOR - ECONOMIC DEVELOPMENT AND INFRASTRUCTURE IMPROVEMENTS	
FOWLER REGION	

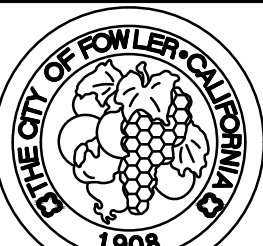


DEPARTMENT OF PUBLIC WORKS AND PLANNING			
GOLDEN STATE BLVD AT MERCED ST CONDUCTOR AND EQUIPMENT SCHEDLUE			
DRAWING NO.	E-25	SHEET NO.	132
TOTAL		142	

CAD USER: CAYALA
PLOT DATE: 3/24/2021 2:35:41 PM
PATH: Z:\01 Projects\009 Fresno County\009-009 Golden State PS&E\Traffic Signal Designs\2a Golden State Blvd at Merced St.dwg



0 20' 40'
SCALE: 1" = 20'

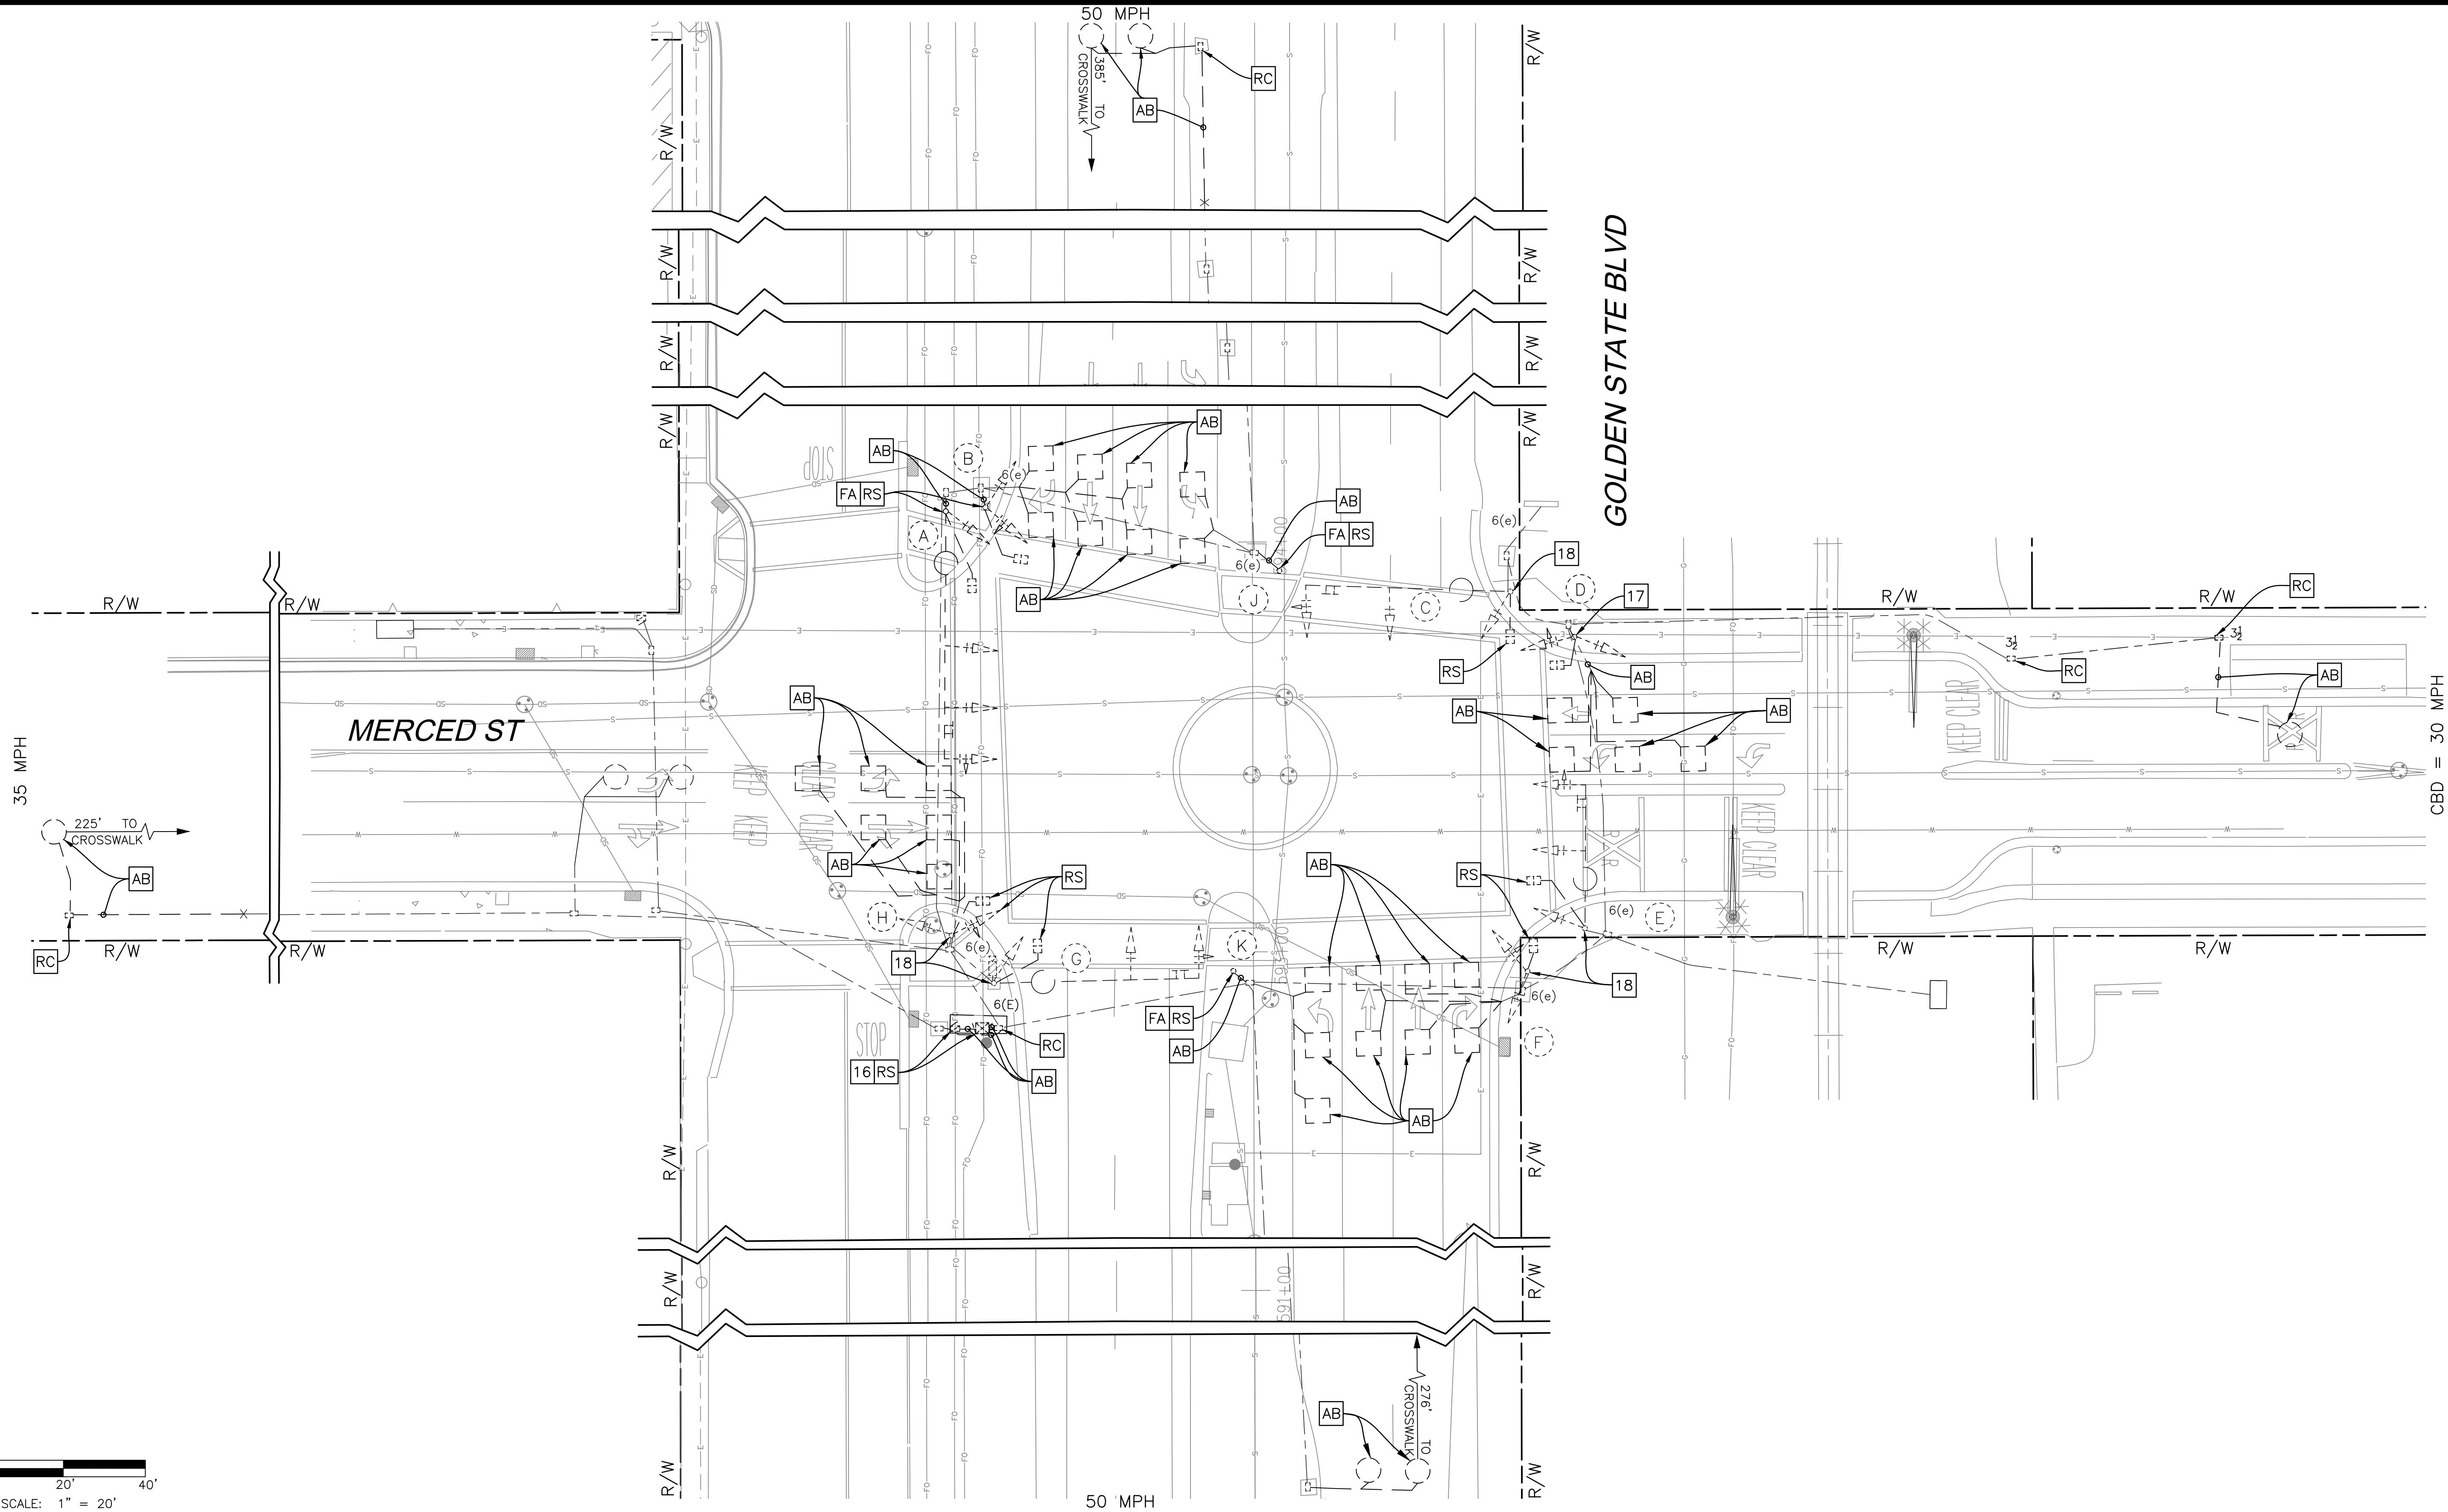

RECORD DRAWING		DATE
DESIGNED: J. BENAVIDES	RESIDENT ENGINEER	03/24/2021
DRAWN: C. AYALA-MAGANA		03/24/2021
CHECKED: J. RIOS		03/24/2021

FOR RIGHT OF WAY DATA AND ACCURATE ACCESS DETERMINATION, SEE DOCUMENTS IN THE DEPARTMENT OF PUBLIC WORKS AND PLANNING.




JLB TRAFFIC
ENGINEERING, INC.
516 W. SHAW AVE., STE. 103
FRESNO, CA 93704
PHONE: (559) 570-8991
EMAIL: info@JLBtraffic.com

TENTATIVE PLANS FOR DESIGN
SUPERVISING ENGINEER
DATE




PROJECT
GOLDEN STATE CORRIDOR - ECONOMIC DEVELOPMENT
AND INFRASTRUCTURE IMPROVEMENTS
FOWLER REGION

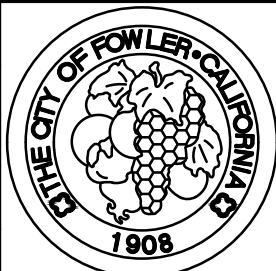




DEPARTMENT OF PUBLIC WORKS AND PLANNING
GOLDEN STATE BLVD AT MERCED ST
TRAFFIC SIGNAL DEMOLITION PLAN
DRAWING NO. E-26 SHEET NO. 133 TOTAL 142

CAD USER: CAYALA
PLOT DATE: 3/19/2021 3:10:40 PM
PATH: I:\01 Projects\009 Fresno County\009-009 Golden State PS&E\Traffic Signal Designs\2b Golden State Blvd at Adams Ave.dwg

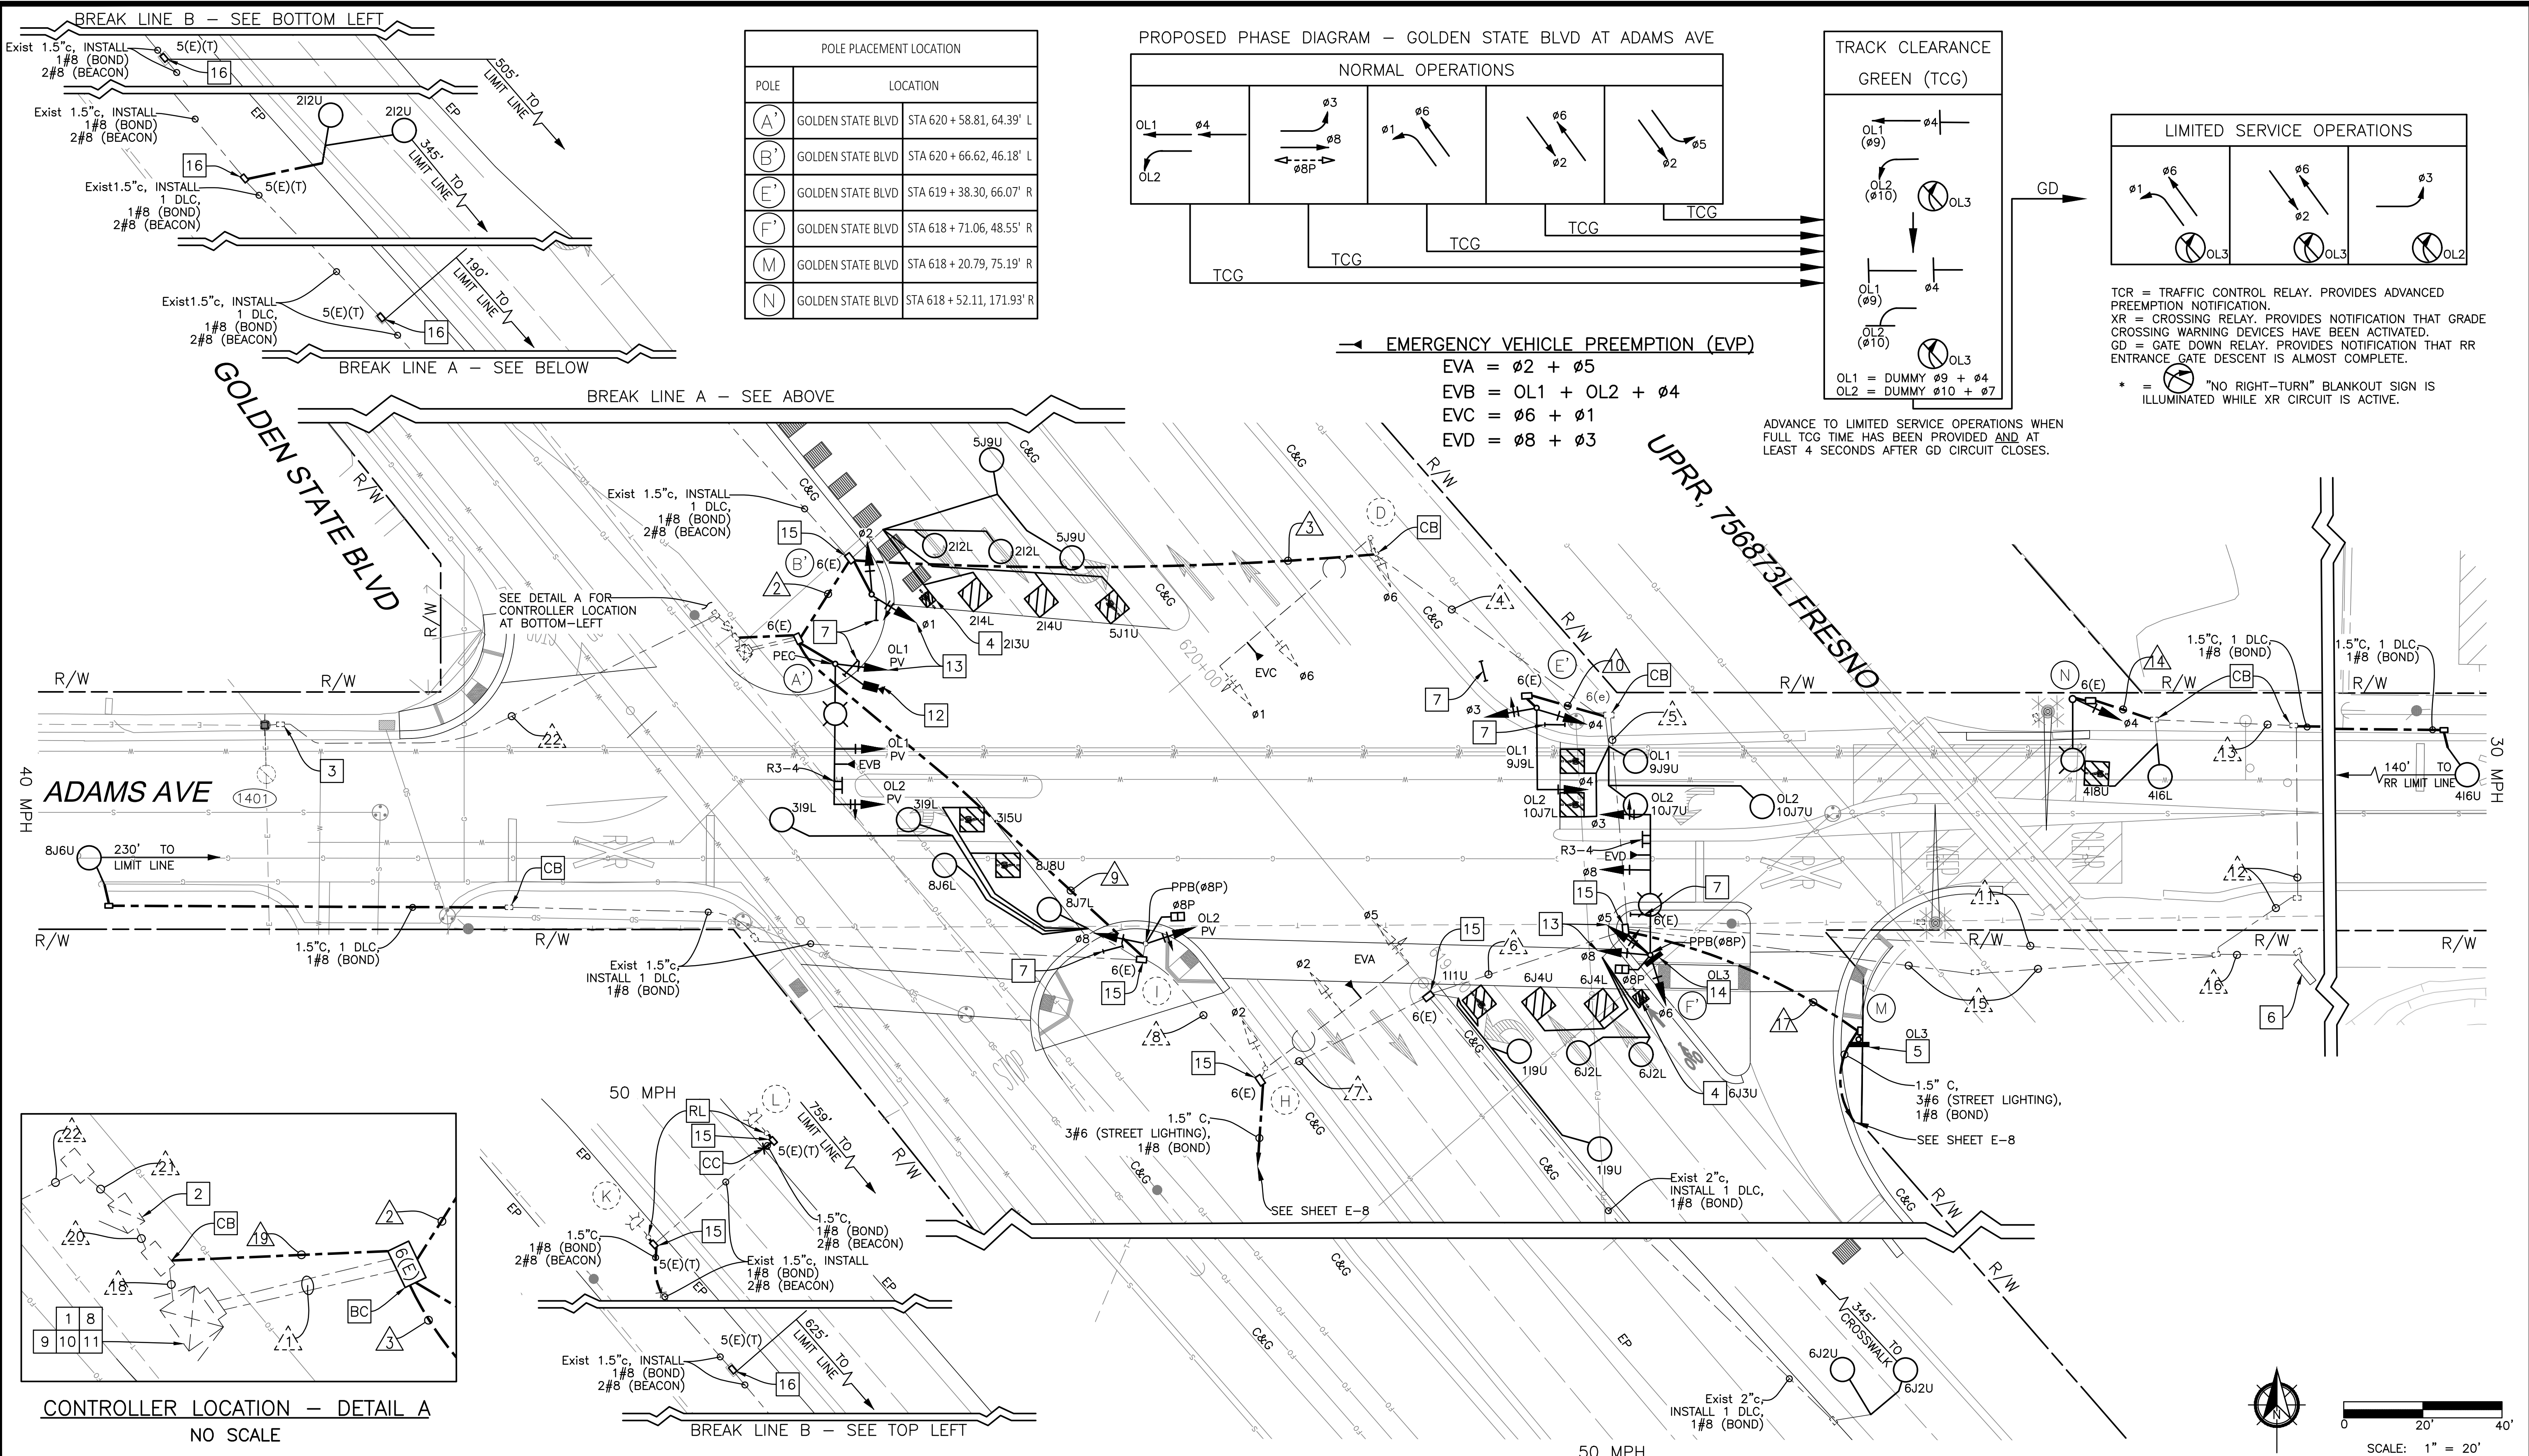

POLE PLACEMENT LOCATION		
POLE	LOCATION	
(A')	GOLDEN STATE BLVD	STA 620 + 58.81, 64.39' L
(B')	GOLDEN STATE BLVD	STA 620 + 66.62, 46.18' L
(E')	GOLDEN STATE BLVD	STA 619 + 38.30, 66.07' R
(F')	GOLDEN STATE BLVD	STA 618 + 71.06, 48.55' R
(M)	GOLDEN STATE BLVD	STA 618 + 20.79, 75.19' R
(N)	GOLDEN STATE BLVD	STA 618 + 52.11, 171.93' R

PROPOSED PHASE DIAGRAM - GOLDEN STATE BLVD AT ADAMS AVE

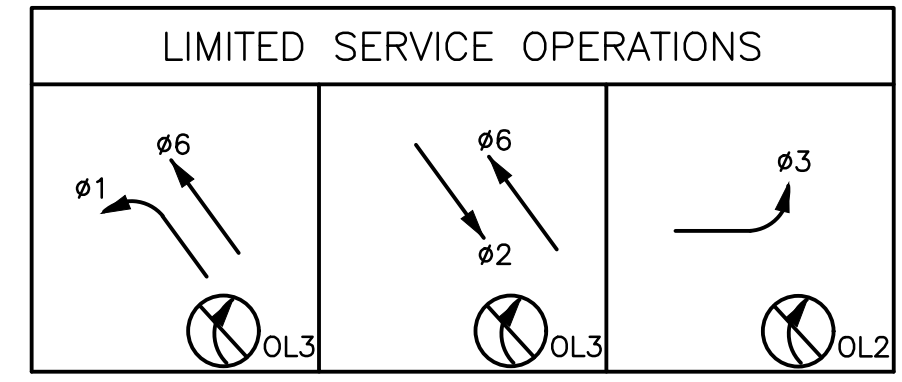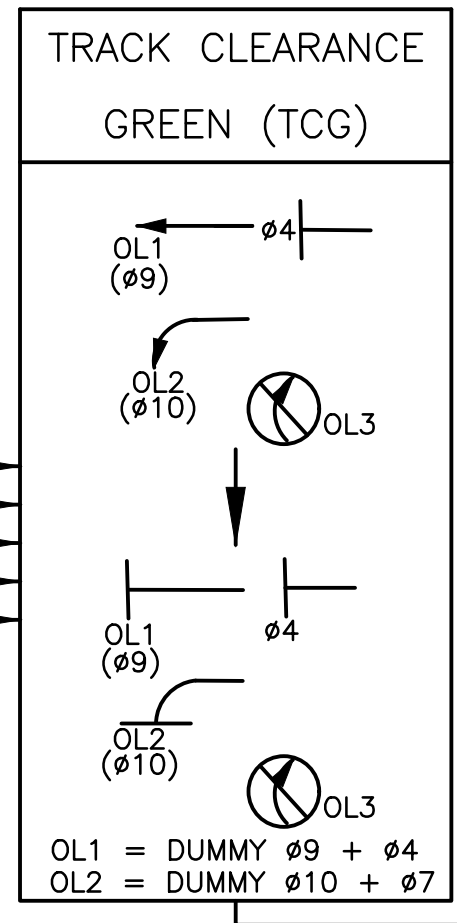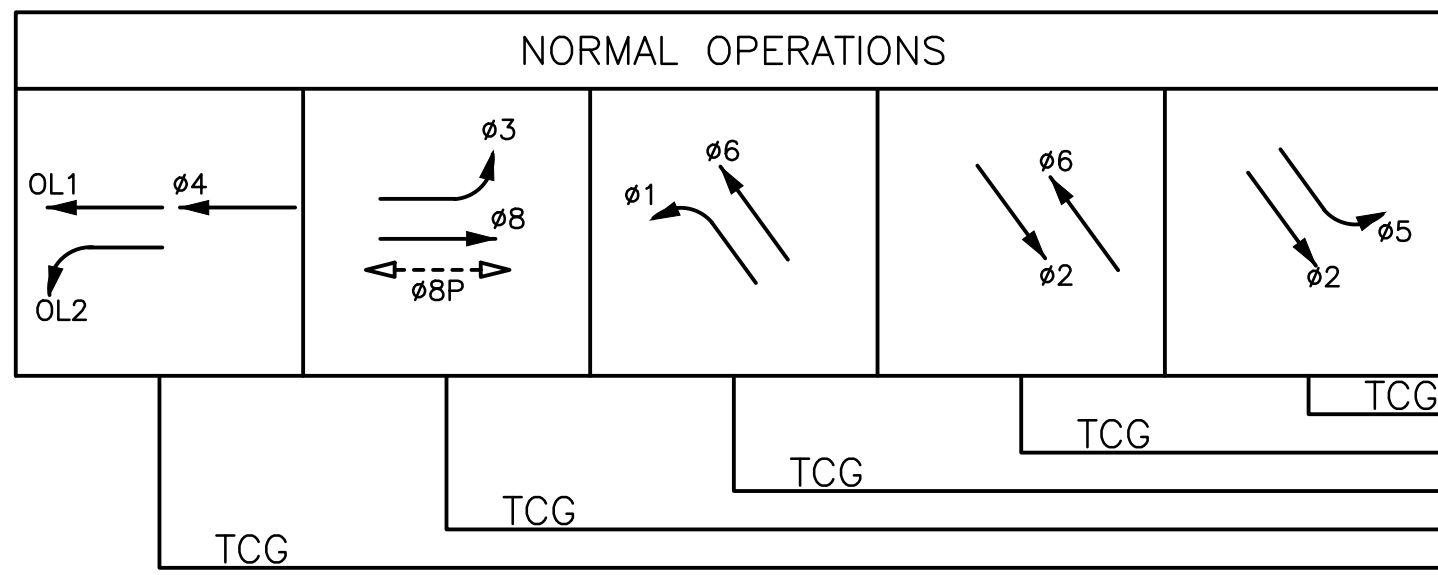


TCR = TRAFFIC CONTROL RELAY. PROVIDES ADVANCED PREEMPTION NOTIFICATION.
XR = CROSSING RELAY. PROVIDES NOTIFICATION THAT GRADE CROSSING WARNING DEVICES HAVE BEEN ACTIVATED.
GD = GATE DOWN RELAY. PROVIDES NOTIFICATION THAT RR ENTRANCE GATE DESCENT IS ALMOST COMPLETE.
* = "NO RIGHT-TURN" BLANKOUT SIGN IS ILLUMINATED WHILE XR CIRCUIT IS ACTIVE.

EMERGENCY VEHICLE PREEMPTION (EVP)

- EVA = $\phi 2 + \phi 5$
- EVB = $OL1 + OL2 + \phi 4$
- EVC = $\phi 6 + \phi 1$
- EVD = $\phi 8 + \phi 3$

ADVANCE TO LIMITED SERVICE OPERATIONS WHEN FULL TCG TIME HAS BEEN PROVIDED AND AT LEAST 4 SECONDS AFTER GD CIRCUIT CLOSURES.

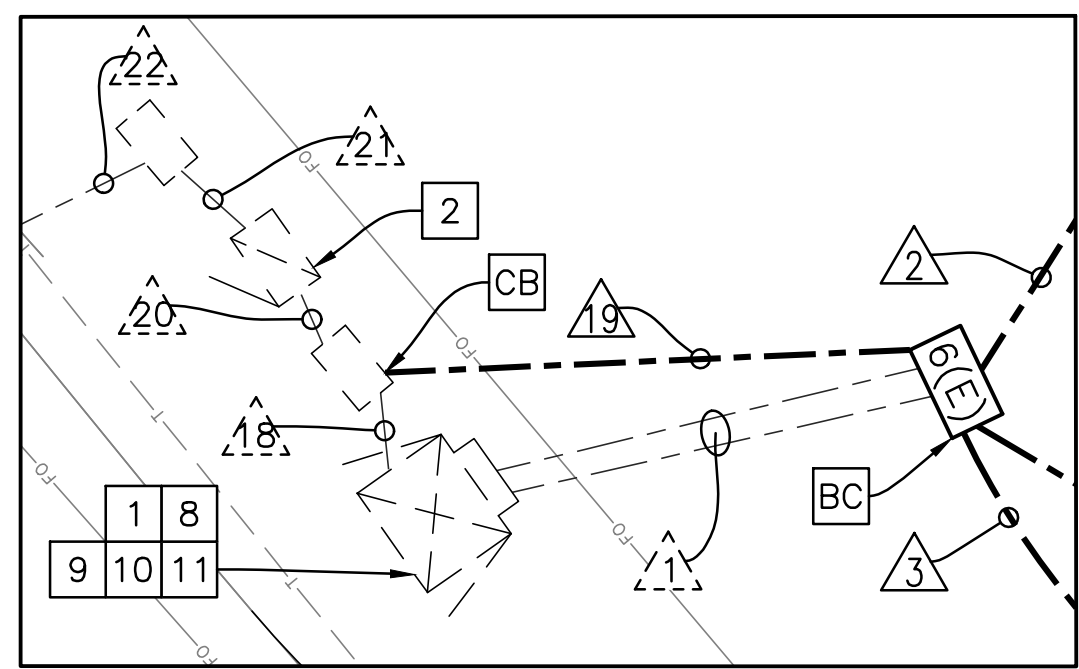

CONTROLLER LOCATION - DETAIL A
NO SCALE

DESIGNED: J. BENAVIDES		DATE: 03/19/2021	RECORD DRAWING		DATE
DRAWN: C. AYALA-MAGANA		03/19/2021	RESIDENT ENGINEER		
CHECKED: J. RIOS		03/19/2021			

FOR RIGHT OF WAY DATA AND ACCURATE ACCESS DETERMINATION, SEE DOCUMENTS IN THE DEPARTMENT OF PUBLIC WORKS AND PLANNING.

CALL BEFORE YOU DIG

JLB TRAFFIC
ENGINEERING, INC.
516 W. SHAW AVE., STE. 103
FRESNO, CA 93704
PHONE: (559) 570-8991
EMAIL: info@JLBtraffic.com

TENTATIVE PLANS FOR DESIGN

SUPERVISING ENGINEER

DATE

PROJECT

GOLDEN STATE CORRIDOR - ECONOMIC DEVELOPMENT AND INFRASTRUCTURE IMPROVEMENTS

FOWLER REGION

DEPARTMENT OF PUBLIC WORKS AND PLANNING

GOLDEN STATE BLVD AT ADAMS AVE
TRAFFIC SIGNAL MODIFICATION PLAN

DRAWING NO. E-27 SHEET NO. 134 TOTAL 142

PROJECT NOTES (SHEETS E-27 TO E-30 ONLY):

- | | |
|----|--|
| 1 | EXISTING 132Z CABINET WITH BBS SYSTEM AND POWER OVER ETHERNET INJECTOR. |
| 2 | EXISTING TESCO SERVICE CABINET. |
| 3 | EXISTING POINT OF SERVICE LOCATION BOX. |
| 4 | INSTALL 3'X3' BIKE LOOP PER DETAIL D AS SHOWN ON SHEET ED-1. |
| 5 | FURNISH AND INSTALL R3-1 (24" x 24") INTERNALLY ILLUMINATED BLANK OUT SIGN PER DETAIL B AND DETAIL K AS SHOWN ON SHEET ED-1. |
| 6 | EXISTING RAILROAD CONTROLLER TO REMAIN. |
| 7 | FURNISH AND INSTALL TYPE I PED BARRICADE WITH R9-3. |
| 8 | THE ADVANCED PREEMPTION INTERCONNECTION SHALL BE CONFIGURED AS A "SUPERVISED" CIRCUIT. A PREEMPTION INTERCONNECTION CIRCUIT SHALL BE IMPLEMENTED IN THE TRAFFIC SIGNAL CONTROLLER. CONTRACTOR SHALL WORK WITH RAILROAD, AND BE RESPONSIBLE FOR APPROVAL, TO CONNECT TO THE ADVANCED PREEMPTION CIRCUIT. A "GATE-DOWN" CIRCUIT SHALL BE IMPLEMENTED IN THE TRAFFIC SIGNAL CONTROLLER. THE RAILROAD WILL PROVIDE THE GATE DOWN CIRCUIT FOR CONNECTION TO THE TRAFFIC SIGNAL CONTROLLER AS PART OF THE RAILROAD'S STANDARD DESIGN. A TRAFFIC SIGNAL HEALTH CIRCUIT SHALL BE IMPLEMENTED INTO THE SIGNAL CONTROLLER. THE TRAFFIC SIGNAL CONTROLLER SHALL BE PROGRAMMED WITH SECOND TRAIN LOGIC. |
| 9 | CONTRACTOR SHALL INSTALL THE FOLLOWING WARNING LABEL WITHIN THE TRAFFIC SIGNAL CONTROLLER CABINET: <ul style="list-style-type: none"> - IF THE TRAFFIC SIGNAL ENTERS FLASHING MODE, NOTIFY THE RAILROAD AND PROVIDE FOR THE SAFE MOVEMENT OF ROADWAY USERS OVER THE GRADE CROSSING. - IF THE TRAFFIC SIGNAL LOSES POWER OR ALL OF THE SIGNALS ARE DARK, NOTIFY THE RAILROAD AND PROVIDE FOR THE SAFE MOVEMENT OF THE ROADWAY USERS OVER THE GRADE CROSSING. - NOTIFY THE RAILROAD ONCE THE SIGNAL SYSTEM HAS BEEN RESTORED TO NORMAL OPERATION. - IF SIGNAL MAINTENANCE IS REQUIRED TO PERFORM A JOINT TEST OF THE PREEMPTION SYSTEM, NOTIFY THE RAILROAD. |
| 10 | CONTRACTOR SHALL INSTALL WARNING LABEL WITHIN CONTROLLER CABINET AS RECOMMENDED IN THE USDOT HIGHWAY RAIL GRADE CROSSING TECHNICAL WORKING GROUP RECOMMENDATIONS TO ALERT TRAFFIC SIGNAL TECHNICIANS TO THE PRESENCE OF THE INTERCONNECTION WITH THE RAILROAD. SEE SAMPLE PER DETAIL I AS SHOWN ON SHEET ED-1. |
| 11 | COORDINATE WITH UPRR FOR THE INSTALLATION OF RAILROAD PREEMPTION CABLING AND TESTING OF THE REQUIRED RAILROAD PREEMPTION CIRCUITS. CONTACT UPRR PRIOR TO ANY WORK WITHIN UPRR RIGHT-OF-WAY OR ANY WORK AFFECTING GRADE CROSSING OPERATIONS. |
| 12 | EXISTING 4 CCTV MOUNTED ON EXISTING TYPE 15 POLE SHALL BE RELOCATED TO NEW POLE A'. |
| 13 | INSTALL PROGRAMMABLE VISIBILITY SIGNAL HEAD TO ENSURE THAT VEHICLE SIGNAL HEAD IS ONLY VISIBLE TO THE TRAFFIC IT'S INTENDED FOR. |
| 14 | FURNISH AND INSTALL R3-1 (24" X 24") INTERNALLY ILLUMINATED BLANK OUT SIGN PER DETAIL B AND DETAIL L AS SHOWN ON SHEET ED-1. |
| 15 | RC EXISTING PULL BOX AND BC A NEW PULL BOX. |
| 16 | RC EXISTING PULL BOX AND BC A NEW 5(E)(T) PULL BOX AT THE PROPOSED TRAIL FINISH GRADE. |

LEGEND (SHEETS E-27 TO E-30 ONLY):

- | | |
|--|---|
| | TYPE E CIRCULAR LOOP DETECTOR CONFIGURATION PER STATE STANDARD PLAN ES-5B. LOOP SEALANT SHALL BE STATE APPROVED ELASTOMERIC SEALANT OR HOT MELT RUBBERIZED. |
| | TYPE D LOOP DETECTOR CONFIGURATION PER STATE STANDARD PLAN ES-5B. LOOP SEALANT SHALL BE STATE APPROVED ELASTOMERIC SEALANT OR HOT MELT RUBBERIZED. BICYCLE DETECTOR SYMBOL TO BE INSTALLED PER CALTRANS STANDARD PLAN A24-C ON CENTER OF THE DETECTOR WHERE SHOWN ON PLAN. ARROW SIGNIFIES DIRECTION OF TRAVEL. |
| | EXISTING TYPE A LOOP DETECTOR. |
| | NEW EMERGENCY VEHICLE PREEMPTION (EVP) DETECTION UNIT EVX (DENOTES CHANNEL). |
| | NEW CONDUIT |
| | EXISTING CONDUIT |
| | EXISTING LUMINAIRE ON WOODEN POLE |
| | EXISTING LUMINAIRE |
| | PROGRAMMABLE VISIBILITY VEHICLE SIGNAL HEAD |
| | EXISTING CCTV |
| | ABANDON, IF APPLIED TO CONDUIT, REMOVE CONDUCTORS. |
| | REMOVE AND SALVAGE EQUIPMENT. |
| | EQUIPMENT OR MATERIAL TO BE REMOVED AND BECOME THE PROPERTY OF THE CONTRACTOR. |
| | FOUNDATION TO BE ABANDONED. REMOVE TOP OF FOUNDATION TO A POINT 36" BELOW THE FINISH GRADE. |
| | CONNECT NEW AND EXISTING CONDUIT. REMOVE EXISTING CONDUCTORS AND INSTALL CONDUCTORS AS INDICATED. |
| | INSTALL NEW CONDUIT INTO EXISTING PULL BOX. |
| | INSTALL PULL BOX IN EXISTING CONDUIT RUN. |
| | RELOCATE EQUIPMENT. |

GENERAL NOTES (SHEETS E-27 TO E-30 ONLY):

- | | | | |
|-----|---|-----|---|
| 1. | WORK SHALL BE DONE IN ACCORDANCE WITH THE STATE OF CALIFORNIA DEPARTMENT OF TRANSPORTATION STANDARD PLANS AND SPECIFICATIONS, 2010 EDITION, THE LATEST CALTRANS ADOPTED EDITION OF THE CALIFORNIA MANUAL ON UNIFORM TRAFFIC CONTROL DEVICES (CA-MUTCD), AND THE LATEST EDITION OF THE CITY OF FRESNO STANDARD SPECIFICATIONS AND DRAWINGS. SIGNAL POLES/STANDARDS FOR 113KM/H WIND VELOCITY AND TYPE 1-A POLES SHALL BE PER THE STATE STANDARD PLANS AND SPECIFICATIONS, DATED JULY 1997. | 17. | SEALANT FOR FILLING THE SAWCUT LOOPS SLOTS SHALL BE HOT-MOLT RUBBERIZED ASPHALT SEALANT PER STATE OF CALIFORNIA SPECIFICATIONS, OR ELASTOMERIC SEALANT, 3M, BLACK 5000. |
| 2. | THESE PLANS ARE ACCURATE FOR ELECTRICAL WORK ONLY. | 18. | PEDESTRIAN PUSH BUTTONS SHALL HAVE 2" DIAMETER ACTUATORS AND COMPLY WITH THE AMERICANS WITH DISABILITIES ACT (ADA). |
| 3. | NO ABOVE GROUND WORK, EXCEPT SERVICE EQUIPMENT, SHALL BE PERFORMED UNTIL THE CONTRACTOR HAS ALL MATERIALS ON HAND TO COMPLETE THAT PARTICULAR SIGNAL LOCATION OR LIGHTING CIRCUIT. | 19. | ALL VEHICLE AND PEDESTRIAN SIGNAL SECTIONS SHALL UTILIZE LIGHT EMITTING DIODE (LED) SIGNAL MODULES IN ACCORDANCE WITH THE STANDARD SPECIFICATIONS. VEHICLE SIGNAL SECTIONS SHALL HAVE 12" (300 mm) DIAMETER LENSES WITH BACKPLATES AND TUNNEL VISORS. ALL VEHICLE AND PEDESTRIAN SIGNAL SECTIONS SHALL HAVE METAL AND RUBBER WASHERS INSTALLED ON THE INSIDE OF THE HEAD. |
| 4. | THE CONTRACTOR IS RESPONSIBLE FOR VERIFICATION OF ALL EXISTING UTILITIES WHETHER OR NOT THEY ARE SHOWN ON THESE PLANS, AND SHALL PROVIDE PROTECTION PRIOR TO, DURING AND AFTER TRENCHING, JACKING AND/OR BORING. THE CONTRACTOR SHALL CONTACT UNDERGROUND SERVICE ALERT (USA), BY CALLING 1-800-227-2600 AT LEAST TWO (2) WORKING DAYS BEFORE BEGINNING WORK. | 20. | SAFETY LUMINAIRE SHALL BE LED (EQUAL TO 150W HPS), SEE UPDATED CITY OF FRESNO SPECIFICATIONS FOR SAFETY LUMINAIRE REQUIREMENTS. |
| 5. | CONDUIT INSTALLATION ACROSS ROADWAYS SHALL BE BY JACKING AND DIRECTIONAL DRILLING METHODS UNLESS OTHERWISE NOTED ON THE PLANS. | 21. | PEDESTRIAN SIGNAL UNITS SHALL BE FULL SYMBOL, MUTCD COMPLIANT, LED "COUNTDOWN" TYPE WITH 9 INCH NUMERALS; GELCORE MODEL PS7-CFF1-01A-18, OR APPROVED EQUAL. SIGNAL ALIGNMENT SHALL BE AS DIRECTED BY THE ENGINEER. |
| 6. | CONTRACTOR SHALL ARRANGE WITH UTILITY COMPANIES FOR ALL REQUIRED UTILITY RELOCATIONS, INCLUDING OVERHEAD CONFLICTS. | 22. | THE CONTRACTOR SHALL FURNISH AND INSTALL A COMPLETE OPTICOM (GTT) EMERGENCY VEHICLE PREEMPTION (EVP) SYSTEM (721 TWO DIRECTION DETECTION, SINGLE CHANNEL) IN ACCORDANCE WITH THE CITY STANDARD SPECIFICATIONS. EVP DETECTOR UNITS SHALL BE INSTALLED ON SIGNAL MAST ARMS AS SHOWN ON THE PLAN, CENTERED OVER THE NUMBER ONE THROUGH LANE, WITH BRACKETS APPROVED BY THE TRAFFIC SIGNAL SUPERVISOR. THE CONTRACTOR SHALL DELIVER THE MODEL 762 DISCRIMINATORS TO THE CITY CORPORATION YARD AT 2101 "G" STREET, FRESNO, AND NOTIFY THE CITY TRAFFIC SIGNAL SHOP, (559) 621-1312, AT LEAST TWO (2) WORKING DAYS PRIOR TO DELIVERY. |
| 7. | ALL TRAFFIC SIGNAL AND LIGHTING FACILITIES, INCLUDING CABINETS, STANDARDS, PULL BOXES, CONDUITS AND LOOP DETECTORS, ARE SHOWN IN THEIR APPROXIMATE LOCATIONS. AFTER ALL UNDERGROUND UTILITIES ARE MARKED, THE CONTRACTOR SHALL MARK FINAL LOCATIONS IN THE FIELD AND NOTIFY THE ENGINEER AT LEAST TWO (2) WORKING DAYS PRIOR TO COMMENCING WORK TO OBSERVE THE MARKED LOCATIONS. | 23. | CONTRACTOR SHALL SCHEDULE WITH THE CITY OF FRESNO TSSL SHOP AT (559) 621-1312 ALL EQUIPMENT DELIVERIES WHICH REQUIRE TESTING BY THE CITY'S TSSL SHOP. EQUIPMENT SHALL BE DELIVERED BY THE CONTRACTOR ONLY AT A PREARRANGED TIME AND DAY. |
| 8. | ALL SALVAGED EQUIPMENT SHALL BE RETURNED TO THE CITY OF FOWLER PUBLIC WORKS DEPARTMENT. THE CONTRACTOR SHALL NOTIFY THE CITY, CONTACT AT LEAST TWO (2) WORKING DAYS PRIOR TO DELIVERY. CONTRACTOR SHALL PROVIDE ADEQUATE MEANS FOR SAFELY UNLOADING EQUIPMENT. | 24. | THE CONTRACTOR SHALL FURNISH AND INSTALL NEW STREET NAME SIGN ON SMA COMPLETE WITH VARIABLE LENGTH MOUNTING HARDWARE, AS SHOWN ON THE PLAN. FURNISH AND INSTALL NEW MOUNTING BRACKETS AS NECESSARY. SUBMITTALS SHALL BE APPROVED BY THE CITY PRIOR TO ORDERING. |
| 9. | PULL BOXES SHALL BE NO. 5(E), UNLESS OTHERWISE NOTED ON THE PLANS. PULL BOXES SHALL NOT BE INSTALLED IN CURB RAMPS OR DRIVEWAYS. VANDAL RESISTANT LOCKING LIDS SHALL BE PROVIDED AND INSTALLED BY THE CONTRACTOR AT FINAL INSPECTION OF THE TRAFFIC SIGNAL. CONTRACTOR SHALL PROVIDE TEMPORARY LIDS DURING CONSTRUCTION. ALL PULL BOXES SHALL BE AT A MAXIMUM OF 200' APART. LIDS SHALL BE TORQUED TO 25 FT. LBS. | 25. | ALL SIGNS SHALL BE 3M-3930SHIP TYPE III & IV SERIES REFLECTIVE SHEETING AND BE COVERED WITH 1160A PREMIUM OVERLAY ANTI-GRAFFITI FILM OR AVERY DENNISON T6500 SERIES REFLECTIVE SHEETING AND SHALL BE COVERED WITH AVERY DENNISON OL1000 ANTI-GRAFFITI OVERLAY FILM. |
| 10. | ALL PULL BOXES INSTALLED IN NON-CONCRETE AREAS SHALL BE SURROUNDED BY A ONE (1) FOOT WIDE CONCRETE COLLAR, TO A DEPTH EQUAL TO THE PULL BOX AND EXTENSION, PER CITY OF FRESNO SPECIFICATIONS, AND SHALL HAVE A VANDAL RESISTANT (SEE NOTE ABOVE) LOCKING LID INSTALLED. ALL CONDUIT ENTRIES INTO ADVANCE DETECTION, INTERMEDIATE DETECTION, AND STREET LIGHTING PULL BOXES INSTALLED IN NON-CONCRETE AREAS SHALL ENTER THE PULL BOX FROM THE BOTTOM, USING 90 DEGREE ELBOWS AND EXTENDING 3 TO 5 INCHES ABOVE THE FINISHED GROUT. | 26. | CONDUITS EXITING THE CONTROLLER FOUNDATION AND ENTERING INTO THE CONTROLLER CABINET SHALL BE ALIGNED TO ENTER WITHIN THE TEES SPECIFIED CABINETS WITHOUT ANY MODIFICATIONS TO THE CABINET BASE. |
| 11. | ALL CONDUITS SHALL HAVE BUSHINGS INSTALLED PRIOR TO INSTALLING CONDUCTORS. STEEL CONDUITS SHALL HAVE LAY IN STYLE LUGS THAT ARE CAST INTEGRAL WITH THE BUSHING. | 27. | ALL RESURFACING SHALL MATCH EXISTING SURFACES AFTER SIGNAL FACILITIES ARE REMOVED AND/OR RELOCATED. |
| 12. | CONDUIT BENDS OF 90 DEGREES ARE PROHIBITED UNLESS OTHERWISE NOTED OR WRITTEN PERMISSION IS GIVEN BY THE CITY OF FOWLER ENGINEER. | 28. | THE EXISTING TRAFFIC SIGNAL SYSTEM, INCLUDING DETECTION, AND/OR STREET LIGHTING SHALL REMAIN OPERATIONAL DURING CONSTRUCTION, UNLESS OTHERWISE AUTHORIZED IN WRITING BY THE CITY ENGINEER. |
| 13. | ALL NEUTRAL CONDUCTORS SHALL BE WHITE IN COLOR THROUGHOUT THEIR ENTIRE LENGTH. | 29. | ALL LUMINAIRE CIRCUITS SHALL BE FUSED. THE FUSE SHALL BE LOCATED IN THE LUMINAIRE HEAD (5 AMP KTK FUSE IN TRON HEB TYPE FUSE HOLDER). |
| 14. | TRAFFIC SIGNAL CABLE SHALL NOT BE SPLICED BETWEEN THE CONTROLLER CABINET AND THE TERMINAL COMPARTMENTS MOUNTED ON THE POLES. DETECTOR CABLES SHALL NOT BE SPLICED BETWEEN THE CONTROLLER CABINET AND THE PULL BOX ADJACENT TO THE DETECTOR LEAD-IN. | 30. | THE CONTRACTOR SHALL FURNISH AND INSTALL POLE NUMBERS WHEN PG&E INDICATES THE NUMBER. POLE NUMBERS SHALL BE SHOWN ON THE AS BUILT DRAWINGS. |
| 15. | PEDESTRIAN MODULE SHALL BE INSTALLED ON THE LEFT SIDE, FACING THE FRONT, OF THE 332 CABINET. | 31. | THE CONTRACTOR SHALL FURNISH AND INSTALL A COMPLETE ACCESSIBLE (AUDIBLE) PEDESTRIAN SIGNAL (APS) SYSTEM (2-WIRE POLARA NAVIGATOR OR APPROVED EQUAL) IN CONFORMANCE WITH THE CITY OF FRESNO STANDARD SPECIFICATIONS. THE APS SHALL PROVIDE BOTH A VIBRATING ARROW BUTTON AND AUDIBLE SOUNDS DURING THE "WALK" INTERVAL, AS WELL AS A LOCATING TONE DURING THE PEDESTRIAN CLEARANCE AND DON'T WALK INTERVALS. THE APS SYSTEM SHALL MEET CURRENT ADA AND CA-MUTCD REQUIREMENTS. ALL PEDESTRIAN PUSH BUTTONS SHALL HAVE A FOUR FOOT ACCESSIBLE PATH IN FRONT OF THE BUTTON. THE APS CENTRAL CONTROL UNIT (CCU) SHALL BE MOUNTED WITH A CITY-APPROVED MANUFACTURED BRACKET, McCain M49021 OR APPROVED EQUAL. CCU SHALL BE MOUNTED TO THE REAR RACK, IN THE UPPER LEFT CORNER WHEN VIEWED FROM THE FRONT OF THE CABINET. THE POWER SUPPLY PIGTAIL SHALL BE CUT TO LENGTH TO ELIMINATE EXCESS CABLE. WITH POWER OBTAINED FROM THE PDA T1 TERMINAL STRIP. TERMINALS 1, 3, & |
| 16. | SEAL CONDUIT WITH AN APPROVED DUCT SEAL AFTER ALL CONDUCTORS HAVE BEEN INSTALLED. | | |

CONSTRUCTION NOTES (SHEETS E-27 TO E-30 ONLY):

1. ALL PULL BOXES ACCESSED BY CONTRACTOR SHALL BE CLEANED OF ALL DIRT AND DEBRIS, ANY CRACKS GROUTED AND ALL CONDUITS DUCT SEALED.
2. ALL PULLBOXES SHALL BE LEVELED TO FINISH GRADE (NEW AND EXISTING).
3. ALL PULLBOXES IN DIRT AREAS SHALL HAVE 1" COLLAR PER GENERAL NOTE 10 (NEW).
4. ANY PULLBOXES BROKEN/DAMAGED BY CONTRACTOR SHALL BE REPLACED.
5. ALL PULLBOXES SHALL HAVE LOCKING LIDS. TRAFFIC RATED LIDS SHALL BE WELDED CLOSED AFTER FINAL INSPECTION.
6. ALL UNUSED CONDUCTORS SHALL BE REMOVED.

	DATE	RECORD DRAWING		 CALL BEFORE YOU DIG	 515 W. SHAW AVE., STE. 103 FRESNO, CA 93704 PHONE: (559) 570-8991 EMAIL: info@JLBtraffic.com	 TENTATIVE PLANS FOR DESIGN	PROJECT		 THE CITY OF FOWLER-CALIFORNIA 1908	DEPARTMENT OF PUBLIC WORKS AND PLANNING		
DESIGNED: J. BENAVIDES	03/19/2021	RESIDENT ENGINEER	DATE				GOLDEN STATE CORRIDOR - ECONOMIC DEVELOPMENT AND INFRASTRUCTURE IMPROVEMENTS			GOLDEN STATE BLVD AT ADAMS AVE LEGEND AND NOTES		
DRAWN: C. AYALA-MAGANA	03/19/2021											
CHECKED: J. RIOS	03/19/2021											
FOR RIGHT OF WAY DATA AND ACCURATE ACCESS DETERMINATION, SEE DOCUMENTS IN THE DEPARTMENT OF PUBLIC WORKS AND PLANNING.								FOWLER REGION		DRAWING NO. E-28	SHEET NO. 135	TOTAL 142

CAD USER: CAYALA
 PLOT DATE: 3/19/2021 3:11:07 PM
 PATH: Z:\01 Projects\009-009 Golden State PS&E\Traffic Signal Designs\2b Golden State Blvd at Adams Ave.dwg

			CONDUIT RUN NUMBER AND SIZE																							
AWG OR CABLE	POLE	Ø	△1 (2-3")	△2 4"	△3 4"	△4 (3")	△5 (3")	△6 (3")	△7 (3")	△8 (3")	△9 4"	△10 3"	△11 (1.5")	△12 (1.5")	△13 (1.5")	△14 3"	△15 (1.5")	△16 (1.5")	△17 3"	△18 (3")	△19 3"	△20 (3")	△21 (2")	△22 (3")		
CONDUIT FILL			33%	16%	11%	13%	7%	24%	27%	33%	26%	1%	28%	28%	24%	5%	22%	22%	5%	4%	10%	13%	13%	6%		
7 COND. CABLE (VEH.) *	(A')	OL1,OL2	1	-	-	-	-	-	-	-	-	-	-	-	-	-	-	-	-	-	-	-	-	-	-	
	(B')	1,2	1	1	-	-	-	-	-	-	-	-	-	-	-	-	-	-	-	-	-	-	-	-	-	
	(D)	1,6	1	1	1	-	-	-	-	-	-	-	-	-	-	-	-	-	-	-	-	-	-	-	-	
	(E')	3,4	1	1	1	1	-	-	-	-	-	-	-	-	-	-	-	-	-	-	-	-	-	-	-	
	(F')	3,5,6,8	2	-	-	-	-	2	2	2	2	-	-	-	-	-	-	-	-	-	-	-	-	-	-	
		8P	1	-	-	-	-	1	1	1	1	-	-	-	-	-	-	-	-	-	-	-	-	-	-	-
	(H)	2,5	1	-	-	-	-	-	-	1	1	-	-	-	-	-	-	-	-	-	-	-	-	-	-	
5 COND. CABLE (PED) *	(I)	8,OL2	1	-	-	-	-	-	-	-	1	-	-	-	-	-	-	-	-	-	-	-	-	-	-	
		8P	1	-	-	-	-	-	-	-	1	-	-	-	-	-	-	-	-	-	-	-	-	-	-	
	(N)	4	1	-	-	-	-	1	1	1	1	-	1	1	1	1	-	-	-	-	-	-	-	-	-	
TOTAL			9	3	2	1	-	3	3	4	5	1	1	1	1	1	-	1	1	-	-	-	-	-	-	
3 COND. CABLE (PPB)	(F')	8P	1	-	-	-	-	1	1	1	1	-	-	-	-	-	-	-	-	-	-	-	-	-	-	
	(I)	8P	1	-	-	-	-	-	-	-	1	-	-	-	-	-	-	-	-	-	-	-	-	-	-	
TOTAL			2	-	-	-	1	1	1	2	-	-	-	-	-	-	-	-	-	-	-	-	-	-	-	
TYPE C DETECTOR LEAD-IN CABLE	Ø1	2	-	-	-	-	-	-	2	2	2	-	-	-	-	-	-	-	-	-	-	-	-	-	-	
	Ø2	5	5	-	-	-	-	-	-	-	-	-	-	-	-	-	-	-	-	-	-	-	-	-	-	
	Ø3	2	-	-	-	-	-	-	-	-	2	-	-	-	-	-	-	-	-	-	-	-	-	-	-	
	Ø4	3	-	-	-	-	3	3	3	3	-	3	3	2	-	-	-	-	-	-	-	-	-	-	-	
	Ø5	2	2	-	-	-	-	-	-	-	-	-	-	-	-	-	-	-	-	-	-	-	-	-	-	
	Ø6	5	-	-	-	-	4	5	5	5	-	-	-	-	-	-	-	-	-	-	-	-	-	-	-	
	Ø8	4	-	-	-	-	-	-	-	-	4	-	-	-	-	-	-	-	-	-	-	-	-	-	-	
	OL1	2	2	2	2	-	-	-	-	-	-	-	-	-	-	-	-	-	-	-	-	-	-	-	-	
OL2	2	2	2	2	-	-	-	-	-	-	-	-	-	-	-	-	-	-	-	-	-	-	-	-		
TOTAL DLC			27	11	4	4	-	7	10	10	16	-	3	3	2	-	-	-	-	-	-	-	-	-	-	
# 2	SERVICE	-	-	-	-	-	-	-	-	-	-	-	-	-	-	-	-	-	-	-	-	3	3	-		
# 4	SIGNAL POWER	-	-	-	-	-	-	-	-	-	-	-	-	-	-	-	-	2	-	2	-	-	-	-	-	
# 6	STREET LIGHTING	-	-	-	-	-	3	3	6	6	-	-	-	-	-	-	-	-	3	-	6	6	-	-	-	
# 8	SAFETY LIGHTS	-	2	2	-	-	2	2	2	2	-	2	2	2	2	-	-	-	-	2	2	-	-	-	-	
# 8	BONDING WIRE	1	1	1	1	1	1	1	1	1	1	1	1	1	1	1	1	1	1	1	1	1	1	1	1	
#12	PEU CONTROL	-	-	-	-	-	-	-	-	-	-	-	-	-	-	-	-	-	-	-	2	2	-	-	-	
#14	BLANK OUT SIGN	4	4	4	4	4	-	-	-	-	-	-	-	-	-	-	-	2	-	-	-	-	-	-	-	
CAT5e	IP CAMERA	4	-	-	-	-	-	-	-	-	-	-	-	-	-	-	-	-	-	-	-	-	-	-	-	
12 COND. CABLE (#14 AWG)	RR PRE-EMPTION	1	1	1	1	1	-	-	-	-	-	-	-	-	-	1	1	-	-	-	-	-	-	-	-	
EVP CABLE 3 COND.	EVA (S/B)	1	-	-	-	-	-	-	-	1	1	-	-	-	-	-	-	-	-	-	-	-	-	-	-	
	EV8 (W/B)	1	-	-	-	-	-	-	-	-	-	-	-	-	-	-	-	-	-	-	-	-	-	-	-	
	EVC (N/B)	1	1	1	-	-	-	-	-	-	-	-	-	-	-	-	-	-	-	-	-	-	-	-	-	
	EVD (E/B)	1	-	-	-	-	1	1	1	1	-	-	-	-	-	-	-	-	-	-	-	-	-	-	-	


* NUMBER INDICATIONS ARE THE NUMBER OF CABLES WITHIN CONDUIT.
 ALL CONDUCTORS ARE NEW UNLESS OTHERWISE INDICATED WITH "()".


EQUIPMENT SCHEDULE													
No.	Type	STANDARD		VEH SIG MTG		PED SIGNAL		PPB		LED LUMINAIRE WATTAGE	PG&E POLE #	SPECIAL REQUIREMENTS	
		Sig.	M.A.	Mast	Arm	Pole	Ø	MTG	Ø	ARROW			
(A)	TYPE 15	-	15'	-	-	SV-1-T	-	-	-	-	101W	4027	REMOVE AND SALVAGE EXISTING POLE AND ALL EQUIPMENT ATTACHED TO IT. 4 EXISTING CCTV MOUNTED ON TYPE 15 POLE SHALL BE PROTECTED AND RELOCATED TO NEW POLE A'.
(A')	24-4-113 (N)	35' (N)	15' (N)	(N) MAT	(N) MAS _{F=14'}	SV-1-T (N)	-	-	-	-	78W (N)	4027 (N)	INSTALL 4 EXISTING CCTV FROM POLE A. FURNISH AND INSTALL R3-4 SIGN AND EVB ON SMA COMPLETE WITH MOUNTING HARDWARE. FURNISH AND INSTALL PV ON ALL VEHICLE SIGNAL HEADS. FURNISH AND INSTALL PEC ON TOP OF POLE. FURNISH AND INSTALL SNS "GOLDEN STATE BLVD" ON SMA COMPLETE WITH MOUNTING HARDWARE.
(B)	1-A (10')	-	-	-	-	TV-1-T	-	-	-	-	-	-	REMOVE AND SALVAGE EXISTING 1-A POLE AND ALL EQUIPMENT ATTACHED TO IT.
(B')	1-A (10')(N)	-	-	-	-	TV-2-T (N)	-	-	-	-	-	-	
(C)	1-A (10')	-	-	-	-	SV-1-T	-	-	-	-	-	-	REMOVE AND SALVAGE EXISTING 1-A POLE AND ALL EQUIPMENT ATTACHED TO IT.
(D)	29-5-70	50'	15'	MAT	MAS	SV-1-T	-	-	-	-	101W	4028	EXISTING SMA SNS "ADAMS AVE" TO REMAIN. FURNISH AND INSTALL EVC ON SMA COMPLETE WITH MOUNTING HARDWARE.
(E)	1-A (10')	-	-	-	-	TV-2-T	-	-	-	-	-	-	REMOVE AND SALVAGE EXISTING 1-A POLE AND ALL EQUIPMENT ATTACHED TO IT.
(E')	16-2-113 (N)	20' (N)	-	MAT (N)	-	SV-2-TA (N)	-	-	-	-	-	-	
(F)	17-2-70	20'	15'	MAT	-	SV-3-TB	8	SP-1-T	8	RIGHT	101W	4029	REMOVE AND SALVAGE EXISTING POLE AND ALL EQUIPMENT ATTACHED TO IT.
(F')	24-4-113 (N)	35' (N)	15' (N)	(N) MAT	(N) MAS _{F=14'}	SV-1-T (N)	8 (N)	SP-1-T (N)	8 (N)	LEFT (N)	78W (N)	4029 (N)	FURNISH AND INSTALL R3-4 SIGN AND EVD ON SMA COMPLETE WITH MOUNTING HARDWARE. FURNISH AND INSTALL SNS "GOLDEN STATE BLVD" ON SMA COMPLETE WITH MOUNTING HARDWARE. FURNISH AND INSTALL R3-1 INTERNALLY ILLUMINATED BLANK OUT SIGN ON POLE COMPLETE WITH MOUNTING HARDWARE.
(G)	1-A (10')	-	-	-	-	SV-1-T	-	-	4	LEFT RIGHT	-	-	REMOVE AND SALVAGE EXISTING 1-A POLE AND ALL EQUIPMENT ATTACHED TO IT.
(H)	26-3-70	45'	15'	MAT	MAS	SV-1-T	-	-	-	-	101W	4030	EXISTING SMA SNS "ADAMS AVE" TO REMAIN. FURNISH AND INSTALL EVA ON SMA COMPLETE WITH MOUNTING HARDWARE.
(I)	1-A (10')	-	-	-	-	TV-2-T (N)	8 (N)	SP-1-T (N)	8 (N)	RIGHT (N)	-	-	REMOVE AND SALVAGE EXISTING VEHICLE SIGNAL HEADS, PEDESTRIAN HEAD AND PPB ASSEMBLY. FURNISH AND INSTALL NEW VEHICLE SIGNAL HEADS COMPLETE WITH MOUNTING HARDWARE. FURNISH AND INSTALL NEW PEDESTRIAN HEAD AND APS PPB ASSEMBLY.
(J)	33-2-60	15'	-	MAT	-	SV-1-T	-	-	-	-	-	-	REMOVE AND SALVAGE EXISTING POLE AND ALL EQUIPMENT ATTACHED TO IT.
(K)	1-A-FBS	-	-	-	-	TV-1-T	-	-	-	-	-	-	INSTALL NEW FOUNDATION AND RELOCATE EXISTING FLASHING BEACON, POLE, AND ALL ASSOCIATED EQUIPMENT A MINIMUM OF 3' BEHIND THE PROPOSED EDGE OF PAVEMENT.
(L)	1-A-FBS	-	-	-	-	TV-1-T	-	-	-	-	-	-	INSTALL NEW FOUNDATION AND RELOCATE EXISTING FLASHING BEACON, POLE, AND ALL ASSOCIATED EQUIPMENT A MINIMUM OF 3' BEHIND THE PROPOSED EDGE OF PAVEMENT.
(M)	1-A (N)(10')	-	-	-	-	TV-1-T (N)	-	-	-	-	-	-	FURNISH AND INSTALL R3-1 BLANK OUT SIGN ON TOP OF POLE.
(N)	15-TS (N)	-	15' (N)	-	-	SV-1-T (N)	-	-	-	-	78W (N)	XXXX (N)	FURNISH AND INSTALL R13A(CA) AND R10-6(LT) SIGNS ON STANDARD COMPLETE WITH MOUNTING HARDWARE.

- NOTES:
- ALL EQUIPMENT IS EXISTING UNLESS OTHERWISE NOTED WITH (N).
 - ALL INDICATIONS SHALL BE 12" LED MODULES.
 - STREET NAME SIGNS SHALL BE WHITE LETTERS ON GREEN BACKGROUND 12" UPPERCASE 9" LOWERCASE, 4" BLOCK NUMBERS, 4" WIDE ARROWS, SERIES "D" TEXT ON TYPE XI DIAMOND GRADE SHEETING AND 3M TYPE XI DG3 OR APPROVED EQUAL.
 - LED INTERSECTION SAFETY LIGHT LUMINAIRES INSTALLED AND SHALL BE CREE RSW5-A-HT-3ME-6L-40K7-UL-GY-N FULL POWER: 78W, 9325 LUMEN, 4000K, CR170-B1-UO-G2, RSW59056&SP.

		DATE	RECORD DRAWING								PROJECT				DEPARTMENT OF PUBLIC WORKS AND PLANNING		
DESIGNED:	J. BENAVIDES	03/19/2021	RESIDENT ENGINEER		DATE		516 W. SHAW AVE., STE. 103 FRESNO, CA 93704 PHONE: (559) 570-8991 EMAIL: info@JLBtraffic.com		TENTATIVE PLANS FOR DESIGN		GOLDEN STATE CORRIDOR - ECONOMIC DEVELOPMENT AND INFRASTRUCTURE IMPROVEMENTS		GOLDEN STATE BLVD AT ADAMS AVE EQUIPMENT AND CONDUCTOR SCHEDULE				
DRAWN:	C. AYALA-MAGANA	03/19/2021							SUPERVISING ENGINEER		DATE		FOWLER REGION				
CHECKED:	J. RIOS	03/19/2021															
FOR RIGHT OF WAY DATA AND ACCURATE ACCESS DETERMINATION, SEE DOCUMENTS IN THE DEPARTMENT OF PUBLIC WORKS AND PLANNING.												CALL BEFORE YOU DIG					

PATH: Z:\01 Projects\009 Fresno County\009 Golden State PS&E\Traffic Signal Designs\2b Golden State Blvd at Adams Ave.dwg
PLOT DATE: 3/19/2021 3:11:31 PM
CAD USER: CAYALA

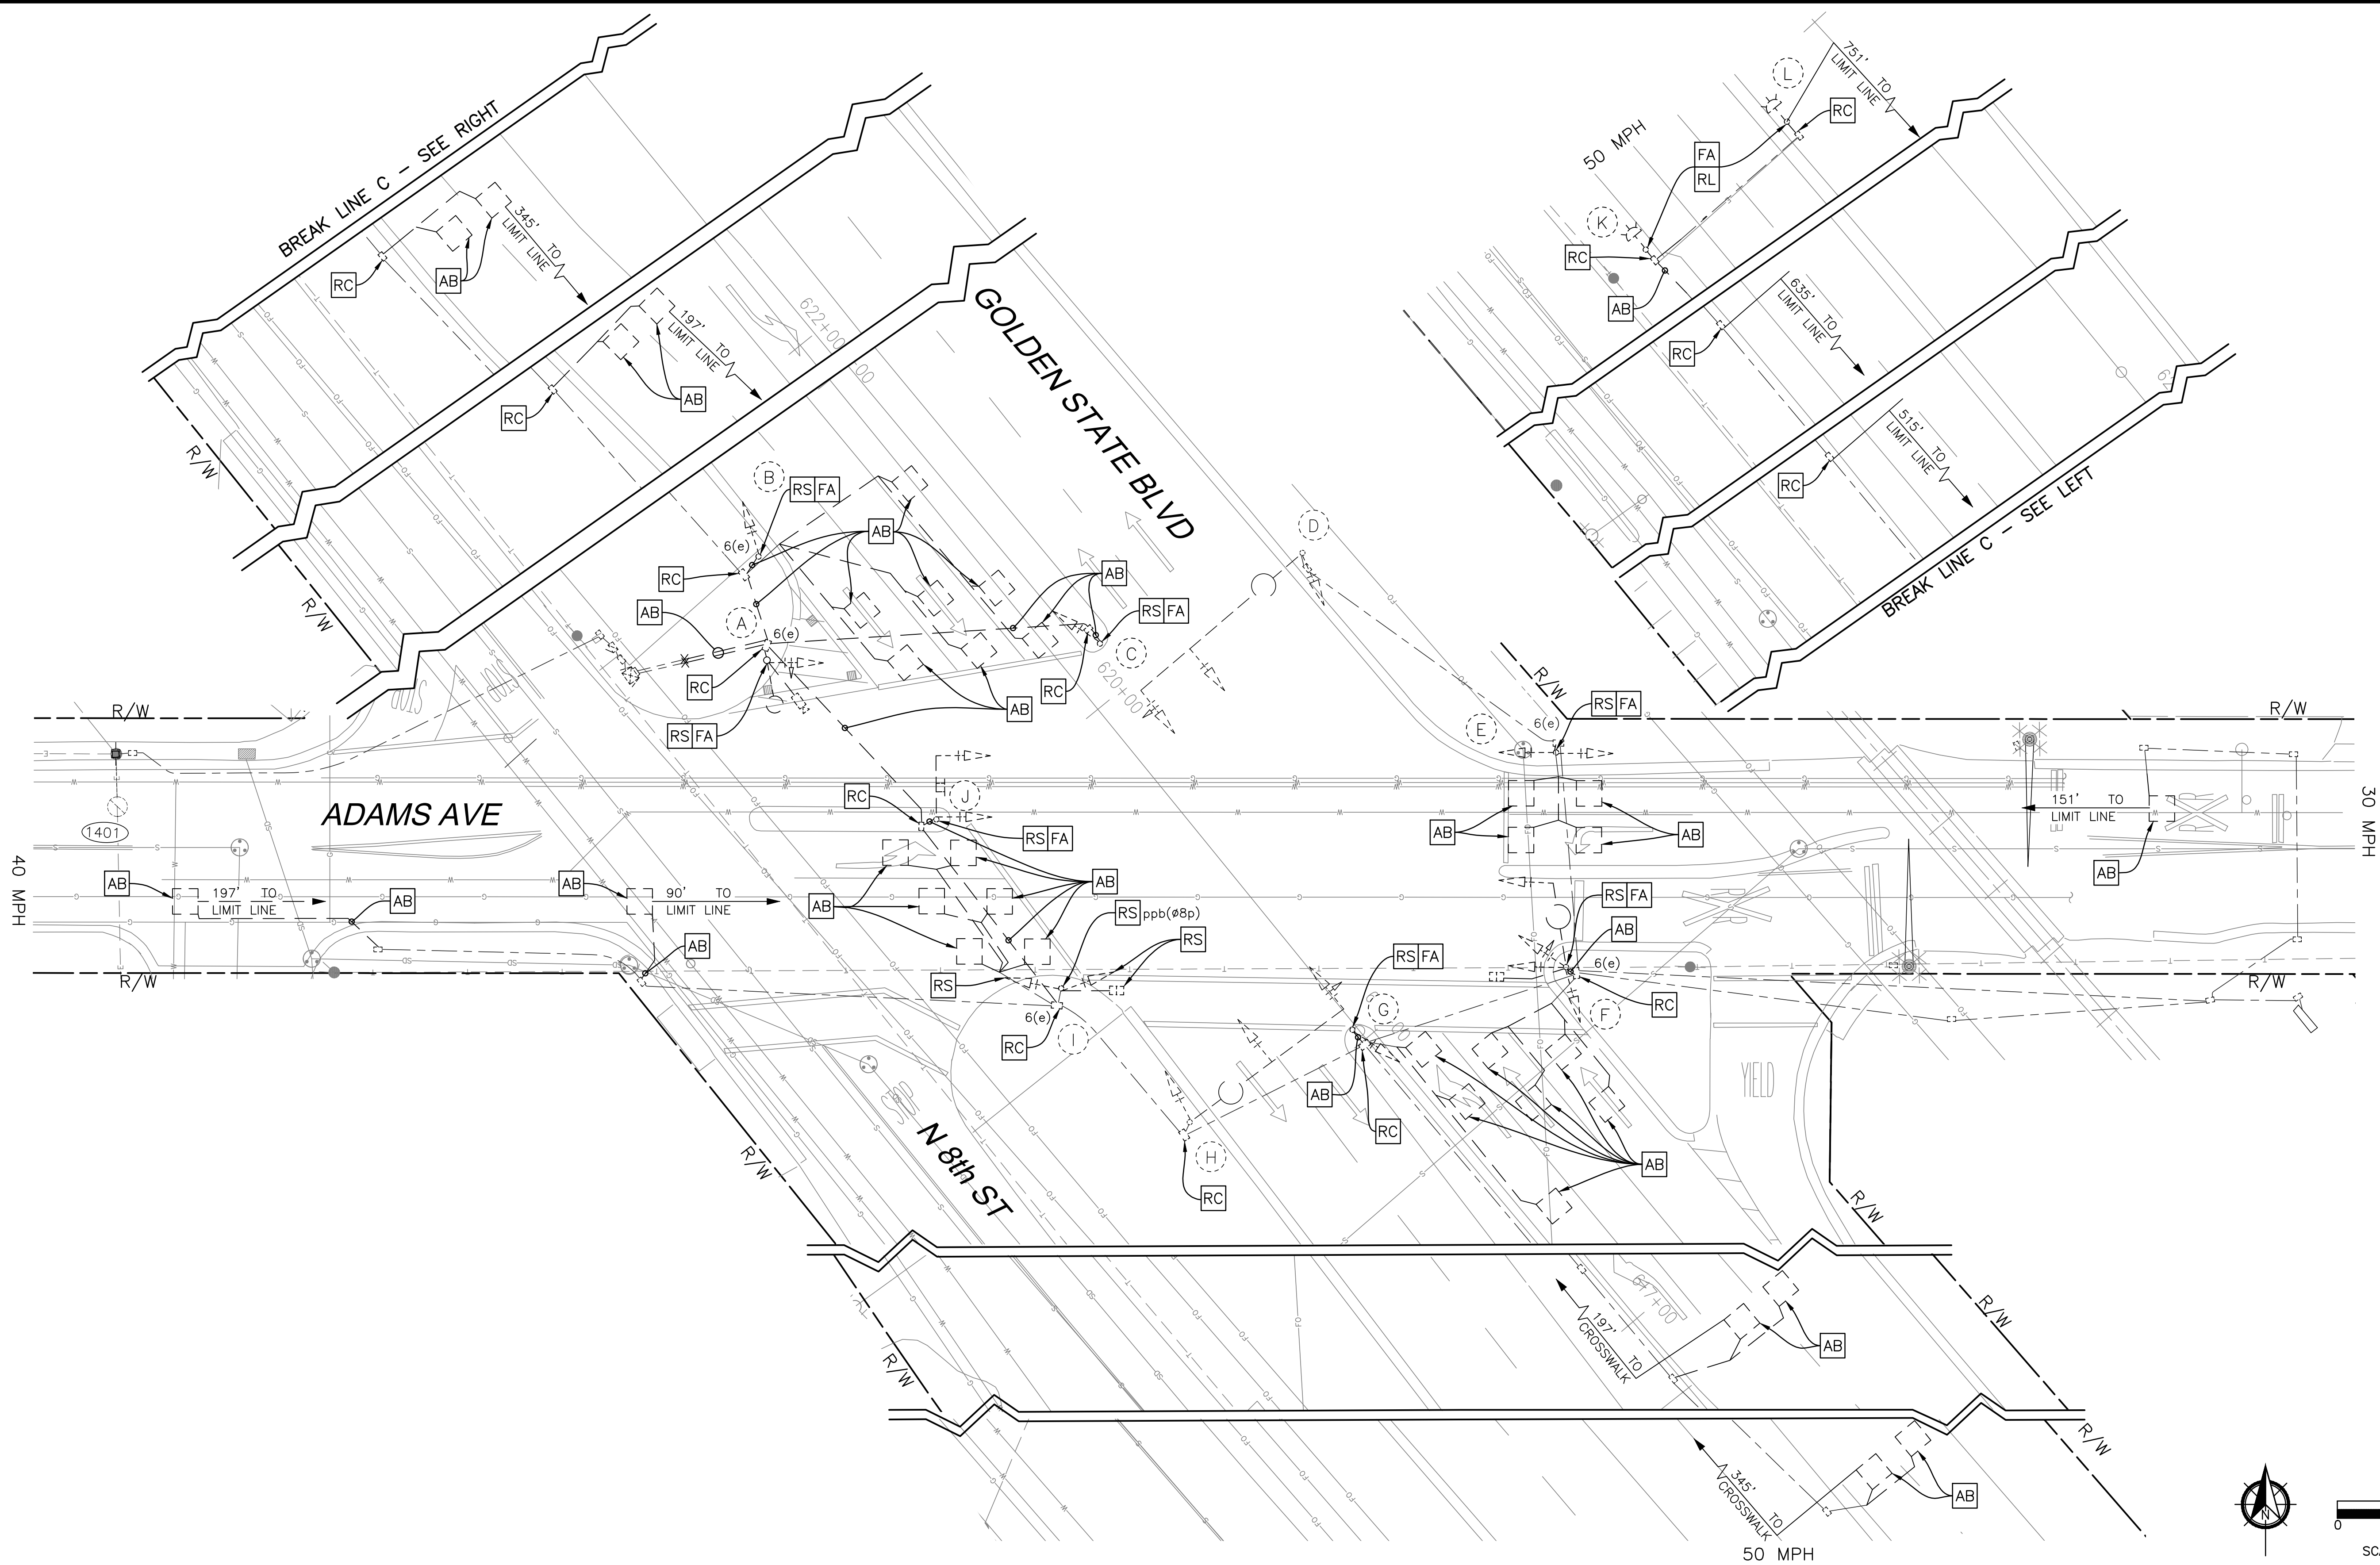

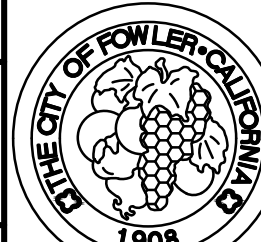DESIGNED: J. BENAVIDES		DATE	RECORD DRAWING	
DRAWN: C. AYALA-MAGANA		03/19/2021	RESIDENT ENGINEER	DATE
CHECKED: J. RIOS		03/19/2021		
FOR RIGHT OF WAY DATA AND ACCURATE ACCESS DETERMINATION, SEE DOCUMENTS IN THE DEPARTMENT OF PUBLIC WORKS AND PLANNING.				
				
CALL BEFORE YOU DIG		516 W. SHAW AVE., STE. 103 FRESNO, CA 93704 PHONE: (559) 570-8991 EMAIL: info@JLBtraffic.com		
TENTATIVE PLANS FOR DESIGN				
SUPERVISING ENGINEER		DATE		
PROJECT		GOLDEN STATE CORRIDOR - ECONOMIC DEVELOPMENT AND INFRASTRUCTURE IMPROVEMENTS		
FOWLER REGION				
DEPARTMENT OF PUBLIC WORKS AND PLANNING		GOLDEN STATE BLVD AT ADAMS AVE TRAFFIC SIGNAL DEMOLITION PLAN		
DRAWING NO. E-30		SHEET NO. 137		TOTAL 142

PATH: Z:\01 Projects\009 Fresno County\009-009 Golden State PS&E\Traffic Signal Designs\2a Golden State Blvd at Jug Handle to Clovis Ave\Golden State Blvd at Jug Handle to Clovis Ave.dwg PLOT DATE: 3/30/2021 10:58:18 AM CAD USER: CAYALA

PROJECT NOTES (FOR SHEET E-31 TO E-34 ONLY):

- 1

FURNISH AND INSTALL 2070LX CONTROLLER WITH THE MOST CURRENT NAZTEC FIRMWARE AND 2070-7A CARD. CONTROLLER AND MODULES SHALL BE FULLY COMPATIBLE WITH EXISTING CITY OF FRESNO TRAFFIC OPERATIONS CENTER SYSTEM & SOFTWARE WITHOUT ANY ADDITIONAL COST OR UPGRADES TO THE CITY. NEW TYPE 332L CABINET WITH ALL ANCILLARY DEVICES FOR A FULL EIGHT PHASE OPERATION AS SPECIFIED IN THE SPECIFICATIONS. NEW MODEL 332L SHALL BE MODIFIED TO CITY STD. DWG. E-34A AND E-34B FOR PREEMPTION AND C11S CABLE WIRING. FRONT DOOR SHALL FACE WEST. FURNISH AND INSTALL GPS CLOCK.
- 2

FURNISH AND INSTALL MODEL 336 ITS CABINET AND ITS EQUIPMENT. SEE CITY STANDARD DRAWINGS ITS-20A, ITS-21B, ITS-21C, AND ITS -21D COMPLETE TO CITY OF FRESNO SPECIFICATIONS AND REQUIREMENTS.
- 3

FURNISH AND INSTALL 26-100 SERVICE ENCLOSURE. CONTRACTOR SHALL COORDINATE WITH PG&E FOR POINT OF SERVICE CONNECTION AND METER SET.
- 4

EXISTING PG&E POINT OF SERVICE.
- 5

EXISTING 3" c, PG&E CONDUCTORS. CONTRACTOR TO COORDINATE WITH PG&E FOR THE DISCONNECT AND REMOVAL OF EXISTING CONDUCTORS ONCE THE NEW SERVICE ENCLOSURE AND CABINETS ARE OPERATIONAL.
- 6

PROPOSED PG&E POINT OF SERVICE LOCATION BOX (#2 PG&E BOX).
- 7

INSTALL 8' X 23' X 3.5" PCC PAD PER CITY OF FRESNO STANDARD P-5.
- 8

FURNISH AND INSTALL ITS WIRELESS EQUIPMENT PER CITY OF FRESNO DRAWING ITS-27A AND ITS-27B.
- 9

FURNISH AND INSTALL IP CAMERA PER CITY OF FRESNO STANDARD DRAWING ITS-18B.
- 10

FURNISH AND INSTALL TYPE I PED BARRICADE WITH AN R9-3.
- 11

FURNISH AND INSTALL R73-2 (MOD) "U-TURN ONLY" PER DETAIL J ON SHEET ED-1.
- 12

INSTALL 3x3 BIKE LOOP PER DETAIL D AS SHOWN ON SHEET ED-1.
- 13

EXISTING 1.5" c, ADD 2#8 (AFB), AND 1#8 (BOND).
- 14

EXISTING 1.5" c, 3#14 (AFB), ADD 1#8 (BOND).
- 15

RS

CONTROLLER CABINET AND SERVICE CABINET. COMPLETELY REMOVE AND DISPOSE OF CONTROLLER CABINET AND SERVICE PEDESTAL FOUNDATIONS AND CONCRETE FLAT WORK.
- 16

RS

ALL EXISTING PEDESTRIAN PUSH BUTTONS ON EXISTING POLE.
- 17

 
RS

EXISTING PULL BOX LID AND INSTALL VANDAL RESISTANT PULL BOX LID.
- 18

NO .5(E) PULLBOX INSCRIBED "ELECTRICAL".

LEGEND (SHEETS E-31 TO E-34 ONLY):

- 

TYPE E CIRCULAR LOOP DETECTOR CONFIGURATION PER STATE STANDARD PLAN ES-5B. LOOP SEALANT SHALL BE STATE APPROVED ELASTOMERIC SEALANT OR HOT MELT RUBBERIZED.
- 

TYPE D LOOP DETECTOR CONFIGURATION PER STATE STANDARD PLAN ES-5B. LOOP SEALANT SHALL BE STATE APPROVED ELASTOMERIC SEALANT OR HOT MELT RUBBERIZED. BICYCLE DETECTOR SYMBOL TO BE INSTALLED PER CALTRANS STANDARD PLAN A24-C ON CENTER OF THE DETECTOR WHERE SHOWN ON PLAN. ARROW SIGNIFIES DIRECTION OF TRAVEL.
- 

WIRELESS RADIO ANTENNA
- 

FURNISH AND INSTALL NEW IP VIEWING DEVICE
- 

NEW CONDUIT
- 

EXISTING CONDUIT
- RS

REMOVE AND SALVAGE EQUIPMENT.
- CB

INSTALL NEW CONDUIT INTO EXISTING PULL BOX.
- BC

INSTALL PULL BOX IN EXISTING CONDUIT RUN.
- AB

ABANDON. IF APPLIED TO CONDUIT, REMOVE CONDUCTORS.
- RC

EQUIPMENT OR MATERIAL TO BE REMOVED AND BECOME THE PROPERTY OF THE CONTRACTOR.
- FA

FOUNDATION TO BE ABANDONED. REMOVE TOP OF FOUNDATION TO A POINT 36" BELOW THE FINISH GRADE.

CONSTRUCTION NOTES (SHEETS E-31 TO E-34 ONLY):

- ALL PULL BOXES ACCESSED BY CONTRACTOR SHALL BE CLEANED OF ALL DIRT AND DEBRIS, ANY CRACKS GROUTED AND ALL CONDUITS DUCT SEALED.
- ALL PULLBOXES SHALL BE LEVELED TO FINISH GRADE (NEW AND EXISTING).
- ALL PULLBOXES IN DIRT AREAS SHALL HAVE 1' COLLAR PER GENERAL NOTE 10 (NEW AND EXISTING).
- ANY BROKEN/DAMAGED PULLBOXES SHALL BE REPLACED.
- ALL PULLBOXES SHALL HAVE LOCKING LIDS. TRAFFIC RATED LIDS SHALL BE WELDED CLOSED AFTER FINAL INSPECTION.
- ALL UNUSED CONDUCTORS SHALL BE REMOVED.

GENERAL NOTES (FOR SHEETS E-31 TO E-34 ONLY):

- WORK SHALL BE DONE IN ACCORDANCE WITH THE STATE OF CALIFORNIA DEPARTMENT OF TRANSPORTATION STANDARD PLANS AND SPECIFICATIONS, 2010 EDITION, THE LATEST CALTRANS ADOPTED EDITION OF THE CALIFORNIA MANUAL ON UNIFORM TRAFFIC CONTROL DEVICES (CA-MUTCD), AND THE LATEST EDITION OF THE CITY OF FRESNO STANDARD SPECIFICATIONS AND DRAWINGS. SIGNAL POLES/STANDARDS FOR 113KM/H WIND VELOCITY AND TYPE 1-A POLES SHALL BE PER THE STATE STANDARD PLANS AND SPECIFICATIONS, DATED JULY 1997.
- THESE PLANS ARE ACCURATE FOR ELECTRICAL WORK ONLY.
- NO ABOVE GROUND WORK, EXCEPT SERVICE EQUIPMENT, SHALL BE PERFORMED UNTIL THE CONTRACTOR HAS ALL MATERIALS ON HAND TO COMPLETE THAT PARTICULAR SIGNAL LOCATION OR LIGHTING CIRCUIT.
- THE CONTRACTOR IS RESPONSIBLE FOR VERIFICATION OF ALL EXISTING UTILITIES WHETHER OR NOT THEY ARE SHOWN ON THESE PLANS, AND SHALL PROVIDE PROTECTION PRIOR TO, DURING AND AFTER TRENCHING, JACKING AND/ OR BORING. THE CONTRACTOR SHALL CONTACT UNDERGROUND SERVICE ALERT (USA), BY CALLING 1-800-227-2600 AT LEAST TWO (2) WORKING DAYS BEFORE BEGINNING WORK.
- CONDUIT INSTALLATION ACROSS ROADWAYS SHALL BE BY JACKING AND DIRECTIONAL DRILLING METHODS UNLESS OTHERWISE NOTED ON THE PLANS.
- CONTRACTOR SHALL ARRANGE WITH UTILITY COMPANIES FOR ALL REQUIRED UTILITY RELOCATIONS, INCLUDING OVERHEAD CONFLICTS.
- ALL TRAFFIC SIGNAL AND LIGHTING FACILITIES, INCLUDING CABINETS, STANDARDS, PULL BOXES, CONDUITS AND LOOP DETECTORS, ARE SHOWN IN THEIR APPROXIMATE LOCATIONS. AFTER ALL UNDERGROUND UTILITIES ARE MARKED, THE CONTRACTOR SHALL MARK FINAL LOCATIONS IN THE FIELD AND NOTIFY THE ENGINEER AT LEAST TWO (2) WORKING DAYS PRIOR TO COMMENCING WORK TO OBSERVE THE MARKED LOCATIONS.
- ALL SALVAGED EQUIPMENT SHALL BE RETURNED TO THE COUNTY OF FRESNO PUBLIC WORKS DEPARTMENT. THE CONTRACTOR SHALL NOTIFY THE COUNTY, CONTACT AT LEAST TWO (2) WORKING DAYS PRIOR TO DELIVERY. CONTRACTOR SHALL PROVIDE ADEQUATE MEANS FOR SAFELY UNLOADING EQUIPMENT.
- PULL BOXES SHALL BE NO. 5(E), UNLESS OTHERWISE NOTED ON THE PLANS. PULL BOXES SHALL NOT BE INSTALLED IN CURB RAMPS OR DRIVEWAYS. VANDAL RESISTANT LOCKING LIDS SHALL BE PROVIDED AND INSTALLED BY THE CONTRACTOR AT FINAL INSPECTION OF THE TRAFFIC SIGNAL. CONTRACTOR SHALL PROVIDE TEMPORARY LIDS DURING CONSTRUCTION. ALL PULL BOXES SHALL BE AT A MAXIMUM OF 200' APART. LIDS SHALL BE TORQUED TO 25 FT. LB.
- ALL PULL BOXES INSTALLED IN NON-CONCRETE AREAS SHALL BE SURROUNDED BY A ONE (1) FOOT WIDE CONCRETE COLLAR, TO A DEPTH EQUAL TO THE PULL BOX AND EXTENSION, PER CITY OF FRESNO SPECIFICATIONS, AND SHALL HAVE A VANDAL RESISTANT (SEE NOTE ABOVE) LOCKING LID INSTALLED. ALL CONDUIT ENTRIES INTO ADVANCE DETECTION, INTERMEDIATE DETECTION, AND STREET LIGHTING PULL BOXES INSTALLED IN NON-CONCRETE AREAS SHALL ENTER THE PULL BOX FROM THE BOTTOM, USING 90 DEGREE ELBOWS AND EXTENDING 3 TO 5 INCHES ABOVE THE FINISHED GROUT.
- ALL CONDUITS SHALL HAVE BUSHINGS INSTALLED PRIOR TO INSTALLING CONDUCTORS. STEEL CONDUITS SHALL HAVE LAY IN STYLE LUGS THAT ARE CAST INTEGRAL WITH THE BUSHING.
- CONDUIT BENDS OF 90 DEGREES ARE PROHIBITED UNLESS OTHERWISE NOTED OR WRITTEN PERMISSION IS GIVEN BY THE CITY OF FOWLER ENGINEER.
- ALL NEUTRAL CONDUCTORS SHALL BE WHITE IN COLOR THROUGHOUT THEIR ENTIRE LENGTH.
- TRAFFIC SIGNAL CABLE SHALL NOT BE SPLICED BETWEEN THE CONTROLLER CABINET AND THE TERMINAL COMPARTMENTS MOUNTED ON THE POLES. DETECTOR CABLES SHALL NOT BE SPLICED BETWEEN THE CONTROLLER CABINET AND THE PULL BOX ADJACENT TO THE DETECTOR LEAD-IN.
- PEDESTRIAN MODULE SHALL BE INSTALLED ON THE LEFT SIDE, FACING THE FRONT, OF THE 332 CABINET.
- SEAL CONDUIT WITH AN APPROVED DUCT SEAL AFTER ALL CONDUCTORS HAVE BEEN INSTALLED.
- SEALANT FOR FILLING THE SAWCUT LOOPS SLOTS SHALL BE HOT-MELT RUBBERIZED ASPHALT SEALANT PER STATE OF CALIFORNIA SPECIFICATIONS, OR ELASTOMERIC SEALENT, 3M, BLACK 5000.
- PEDESTRIAN PUSH BUTTONS SHALL HAVE 2" DIAMETER ACTUATORS AND COMPLY WITH THE AMERICANS WITH DISABILITIES ACT (ADA).
- ALL VEHICLE AND PEDESTRIAN SIGNAL SECTIONS SHALL UTILIZE LIGHT EMITTING DIODE (LED) SIGNAL MODULES IN ACCORDANCE WITH THE STANDARD SPECIFICATIONS. VEHICLE SIGNAL SECTIONS SHALL HAVE 12" (300 mm) DIAMETER LENSES WITH BACKPLATES AND TUNNEL VISORS. ALL VEHICLE AND PEDESTRIAN SIGNAL SECTIONS SHALL HAVE METAL AND RUBBER WASHERS INSTALLED ON THE INSIDE OF THE HEAD.
- PEDESTRIAN SIGNAL UNITS SHALL BE FULL SYMBOL, MUTCD COMPLIANT, LED "COUNTDOWN" TYPE WITH 9 INCH NUMERALS; GELCORE MODEL PS7-CFF1-01A-18, OR APPROVED EQUAL. SIGNAL ALIGNMENT SHALL BE AS DIRECTED BY THE ENGINEER.
- CONTRACTOR SHALL SCHEDULE WITH THE CITY OF FRESNO TSSL SHOP AT (559) 621-1312 ALL EQUIPMENT DELIVERIES WHICH REQUIRE TESTING BY THE CITY'S TSSL SHOP. EQUIPMENT SHALL BE DELIVERED BY THE CONTRACTOR ONLY AT A PREARRANGED TIME AND DAY.
- THE CONTRACTOR SHALL FURNISH AND INSTALL NEW OVERSIZED STREET NAME SIGNS ON SIGNAL STANDARDS, AS SHOWN ON THE PLAN. FURNISH AND INSTALL NEW MOUNTING BRACKETS AS NECESSARY. SUBMITTALS SHALL BE APPROVED BY THE CITY PRIOR TO ORDERING.
- ALL SIGNS SHALL BE 3M-3930HIP TYPE III & IV SERIES REFLECTIVE SHEETING AND BE COVERED WITH 1160A PREMIUM OVERLAY ANTI-GRAFFITI FILM OR AVERY DENNISON T6500 SERIES REFLECTIVE SHEETING AND SHALL BE COVERED WITH AVERY DENNISON OL1000 ANTI-GRAFFITI OVERLAY FILM.
- CONDUITS EXITING THE CONTROLLER FOUNDATION AND ENTERING INTO THE CONTROLLER CABINET SHALL BE ALIGNED TO ENTER WITHIN THE TEES SPECIFIED CABINETS WITHOUT ANY MODIFICATIONS TO THE CABINET BASE.
- ALL RESURFACING SHALL MATCH EXISTING SURFACES AFTER SIGNAL FACILITIES ARE REMOVED AND/OR RELOCATED.
- THE EXISTING TRAFFIC SIGNAL SYSTEM, INCLUDING DETECTION, AND/OR STREET LIGHTING SHALL REMAIN OPERATIONAL DURING CONSTRUCTION, UNLESS OTHERWISE AUTHORIZED IN WRITING BY THE CITY ENGINEER.
- ALL LUMINAIRE CIRCUITS SHALL BE FUSED. THE FUSE SHALL BE LOCATED IN THE LUMINAIRE HEAD (5 AMP KTK FUSE IN TRON HEB TYPE FUSE HOLDER).
- THE CONTRACTOR SHALL FURNISH AND INSTALL POLE NUMBERS WHEN PG&E INDICATES THE NUMBER. POLE NUMBERS SHALL BE SHOWN ON THE AS BUILT DRAWINGS.
- THE CONTRACTOR SHALL FURNISH AND INSTALL A COMPLETE ACCESSIBLE (AUDIBLE) PEDESTRIAN SIGNAL (APS) SYSTEM (2-WIRE POLARA NAVIGATOR OR APPROVED EQUAL) IN CONFORMANCE WITH THE CITY OF FRESNO STANDARD SPECIFICATIONS. THE APS SHALL PROVIDE BOTH A VIBRATING ARROW BUTTON AND AUDIBLE SOUNDS DURING THE "WALK" INTERVAL, AS WELL AS A LOCATING TONE DURING THE PEDESTRIAN CLEARANCE AND DON'T WALK INTERVALS. THE APS SYSTEM SHALL MEET CURRENT ADA AND CA-MUTCD REQUIREMENTS. ALL PEDESTRIAN PUSH BUTTONS SHALL HAVE A FOUR FOOT ACCESSIBLE PATH IN FRONT OF THE BUTTON. THE APS CENTRAL CONTROL UNIT (CCU) SHALL BE MOUNTED WITH A CITY-APPROVED MANUFACTURED BRACKET, MCCAIN M49021 OR APPROVED EQUAL. CCU SHALL BE MOUNTED TO THE REAR RACK, IN THE UPPER LEFT CORNER WHEN VIEWED FROM THE FRONT OF THE CABINET. THE POWER SUPPLY PIGTAIL SHALL BE CUT TO LENGTH TO ELIMINATE EXCESS CABLE, WITH POWER OBTAINED FROM THE PDA T1 TERMINAL STRIP, TERMINALS 1, 3, & 5. CONTRACTOR SHALL PROVIDE THE COUNTY THE LATEST MEANS OF PROGRAMMING THE APS SYSTEM AND DIGITAL COPIES OF THE CUSTOM AUDIO VIA EMAIL.

ITS GENERAL NOTES (FOR SHEETS E-31 TO E-34 ONLY):

- WORK SHALL BE DONE IN ACCORDANCE WITH THE CITY OF FRESNO STANDARD SPECIFICATIONS, DRAWINGS, TECHNICAL SPECIFICATIONS AND THE SPECIAL PROVISIONS.
- ALL ITS FACILITIES, INCLUDING THE CABINETS, CAMERA STANDARDS, VAULTS, CONDUITS, ARE SHOWN IN THEIR APPROXIMATE LOCATION. THE CONTRACTOR SHALL MARK FINAL LOCATIONS IN THE FIELD AND NOTIFY THE ENGINEER AT LEAST 2 WORKING DAYS PRIOR TO COMMUNING TO WORK TO VERIFY MARKED LOCATIONS.
- CONTRACTOR SHALL ARRANGE WITH UTILITY COMPANIES FOR ALL REQUIRED UTILITY RELOCATIONS, INCLUDING OVERHEAD CONFLICTS.
- CONTRACTOR SHALL FURNISH AND INSTALL C11S CABLE IN 332 CABINET PER CITY OF FRESNO STANDARD E-34B AS NOTED ON THE PLANS.
- INTELLIGENT TRANSPORTATION SYSTEM SHALL BE OPERATIONAL AND RESTORED IN KIND, UNLESS OTHERWISE NOTED.
- CONTRACTOR SHALL MAINTAIN 2 FEET LOOP MINIMUM EXCESS OF IP CAMERA CABLES IN THE #6 PULL BOX.
- CONTRACTOR SHALL UTILIZE RED TAPE FOR IP CAMERA AND BLUE TAPE FOR WIRELESS ANTENNA CAT5E.
- PRIOR TO ANY EXCAVATION AND/OR BORING, CONTRACTOR SHALL POTHOLE ALL UTILITY CROSSINGS TO VERIFY SIZE, DEPTH AND TYPE OF PIPE. MAINTAIN MINIMUM CLEARANCES AND EXISTING UTILITIES PER APPLICABLE CITY OF FRESNO STANDARD DRAWINGS ITS-6, ITS-7, ITS-8, ITS-9 AND ITS-10.
- SURFACE INTERIOR AND EXTERIOR FINISH OF ALUMINUM COMMUNICATION CABINET MUST COMPLY WITH MIL-A-8625 FOR TYPE II, CLASS 1 COATING (REF: SECTION 86-3.01 OF THE 2010 STATE STANDARD SPECIFICATIONS).
- POLE HANDHOLE SHALL BE WELDED IN PLACE AFTER ALL PROVIDED WORK ON EXISTING POLE IS COMPLETED AND INSPECTED. CONTRACTOR SHALL PROTECT CONDUCTORS FROM DAMAGE DURING WELDING.
- ALL EXISTING DATA CABLES FROM THE 2070 CONTROLLER TO THE NETWORK SWITCH IN THE COMMUNICATION CABINET SHALL BE REPLACED WITH NEW OUTDOOR SHIELDED CAT5E CABLE, UNLESS OTHERWISE NOTED ON THE INTERSECTION PLANS.
- ANY DEFECTIVE EXISTING LOOP MODULES SHALL BE REMOVED AND BECOME PROPERTY OF THE CONTRACTOR. ALL PROPOSED LOOP MODULES (222 TWO CHANNEL) AS NOTED ON THE PLANS SHALL BE INSTALLED PER CITY STANDARDS AND SPECIFICATIONS.
- ALL IP CAMERAS SHALL BE PANORAMIC, UNLESS OTHERWISE NOTED ON PLANS.
- REMOVE UNUSED ITS EQUIPMENT IN TRAFFIC SIGNAL (332) CABINET AS DIRECTED BY THE ENGINEER.

ITS WIRELESS NOTES (FOR SHEETS E-31 TO E-34 ONLY):


- THE CONTRACTOR SHALL BE OBLIGATED TO FAMILIARIZE THEMSELVES WITH CURRENT SIGNAL POLES IN FIELD PRIOR TO CONSTRUCTION.
- RADIO AND ONE ANTENNA SHALL BE MOUNTED BEHIND SIGNAL HEAD FOR THE LEAST AMOUNT OF WIND LOADING.
- SHIELDED, OUTDOOR RATED CAT5E CABLE LENGTH SHALL NOT EXCEED 300 FEET. SEE CITY OF FRESNO STANDARD ITS-27A AND ITS-27B FOR FURTHER DETAILS.
- A LOW LOSS 50 OHM COAX CABLE SHALL BE USED TO CONNECT THE ANTENNA TO THE ACCESS POINT UNIT.
- THE CONTRACTOR SHALL NOTIFY THE ENGINEER OF ANY VISUAL OBSTACLES THAT MAY OBSTRUCT THE LINE OF SIGHT PRIOR TO INSTALLATION, SUCH AS TREES, GRADE SEPARATIONS, ETC.
- A SEPARATION OF AT LEAST 2 FEET BETWEEN ANTENNAS IS REQUIRED.
- TERMINATIONS OF OUTDOOR RATED SHIELDED CAT5E WITH SHIELDED GROUNDING, CONTRACTOR SHALL USE RJ-45 SHIELDED MODULAR CONNECTOR WITH INTERNAL GROUND.
- CAT5E CONNECTION TO ACCESS POINT SHALL BE MADE USING THE WATERPROOF CONNECTOR SUPPLIED WITH THE ACCESS POINT.
- ALL ANTENNAS SHALL BE ORIENTED IN THE VERTICAL POLARIZATION POSITION WHEN INSTALLED.
- CONTRACTOR SHALL TRIM AND DISPOSE OF BRANCHES FROM ALL TREES THAT MAY OBSTRUCT LINE OF SIGHT OF WIRELESS ITS PRIOR TO INSTALLATION AS DIRECTED BY THE ENGINEER.
- RADIO RSSI BETWEEN ADJACENT INTERSECTIONS SHALL BE BETWEEN -60DBM AND -40DBM FOR ALL RADIOS INSTALLED ON THIS PROJECT. OPTIMAL RSSI IS -55DBM. CONTRACTOR SHALL BE RESPONSIBLE FOR MAKING ADJUSTMENTS AT ADJACENT INTERSECTIONS IF NECESSARY.
- RADIO CCQ VALUES SHALL BE A MINIMUM OF 75% PER MANUFACTURER RECOMMENDATION. CONTRACTOR SHALL BE RESPONSIBLE FOR MAKING ADJUSTMENTS AT ADJACENT INTERSECTIONS IF NECESSARY.

		DATE	RECORD DRAWING	
DESIGNED:	J. BENAVIDES	03/30/2021	RESIDENT ENGINEER	DATE
DRAWN:	C. AYALA-MAGANA	03/30/2021		
CHECKED:	J. RIOS	03/30/2021		
FOR RIGHT OF WAY DATA AND ACCURATE ACCESS DETERMINATION, SEE DOCUMENTS IN THE DEPARTMENT OF PUBLIC WORKS AND PLANNING.				
			811 CALL BEFORE YOU DIG	JLB TRAFFIC ENGINEERING, INC. 516 W. SHAW AVE., STE. 103 FRESNO, CA 93704 PHONE: (559) 570-8991 EMAIL: info@JLBTraffic.com
			TENTATIVE PLANS FOR DESIGN DATE STAMP	PROFESSIONAL ENGINEER DATE NO. 03/30/21 STATE OF CALIFORNIA
			PROJECT	
			GOLDEN STATE CORRIDOR - ECONOMIC DEVELOPMENT AND INFRASTRUCTURE IMPROVEMENTS	
			FOWLER REGION	
			CITY OF FOWLER CLAYTON 1908	DEPARTMENT OF PUBLIC WORKS AND PLANNING GOLDEN STATE BLVD AT JUG HANDLE TO CLOVIS AVE LEGEND AND NOTES
DRAWING NO.		E-32	SHEET NO.	139
TOTAL		142		

	DATE	RECORD DRAWING		 CALL BEFORE YOU DIG	 516 W. SHAW AVE., STE. 103 FRESNO, CA 93704 PHONE: (559) 570-8991 EMAIL: info@JLBtraffic.com
J. BENAVIDES	03/30/2021	RESIDENT ENGINEER	DATE		
C. AYALA-MAGANA	03/30/2021				
J. RIOS	03/30/2021				
RIGHT OF WAY DATA AND ACCURATE ACCESS DETERMINATION. SEE DOCUMENTS IN THE DEPARTMENT OF PUBLIC WORKS AND PLANNING.					

EQUIPMENT SCHEDULE													
No.	STANDARD			VEH SIG MTG		PED SIGNAL		PPB		HPS EQUIV. LUMINAIRE WATTAGE	PG&E POLE No.	SPECIAL REQUIREMENTS	
	Type	Sig. M.A.	Lum.M.A.	Mast Arm	Pole	Ø	MTG	Ø	ARROW				
(A)	26-4-129	45'	15'	MAS MAS	SV-2-T	-	-	-	-	78W LED (N)	XXXX	REMOVE AND SALVAGE EXISTING Ø8 VEHICLE SIGNAL HEAD, PEDESTRIAN HEAD, PPB ASSEMBLY AND LUMINAIRE. FURNISH AND INSTALL NEW Ø8 VEHICLE SIGNAL HEAD ON POLE AND LUMINAIRE ON LMA FURNISH AND INSTALL SNS "CLOVIS AVE" COMPLETE WITH MOUNTING HARDWARE ON POLE.	
(B)	1-A (10')	-	-	-	TV-1-T	-	-	-	-	-	-	REMOVE AND SALVAGE EXISTING VEHICLE SIGNAL HEAD. FURNISH AND INSTALL NEW Ø8 VEHICLE SIGNAL HEAD.	
(C)	1-A (10')	-	-	-	TV-3-T	-	-	-	-	-	-	REMOVE AND SALVAGE EXISTING PPB ASSEMBLY AND PEDESTRIAN HEAD.	
(D)	26-4-113	45'	15'	MAS MAS	SV-1-T	6	SP-1-T	8	LEFT	150W	XXXX	REMOVE AND SALVAGE EXISTING POLE AND ALL EQUIPMENT ATTACHED TO IT.	
(D')	29-5-113 (N)	50' (N)	15' (N)	(N) MAT (N) MAS _{F=17'}	SV-1-T (N)	-	-	-	-	78W LED (N)	XXXX	FURNISH AND INSTALL SNS "CLOVIS AVE" COMPLETE WITH MOUNTING HARDWARE ON POLE. FURNISH AND INSTALL PEC ON TOP OF POLE. FURNISH AND INSTALL R73-2 (MOD) "U-TURN ONLY" SIGN AND WIRELESS ANTENNA ON SMA COMPLETE WITH MOUNTING HARDWARE.	
(E)	1-A (10')	-	-	-	TV-1-T	8	SP-1-T	6	RIGHT	-	-	REMOVE AND SALVAGE EXISTING POLE AND ALL EQUIPMENT ATTACHED TO IT.	
(E')	1-A (10')(N)	-	-	-	TV-1-T (N)	2 (N)	SP-1-T (N)	2 (N)	LEFT (N)	-	-		
(F)	19-4-113	-	15'	-	SV-2-TA	8 6	SP-2-T	8 6	RIGHT LEFT	150W	XXXX	REMOVE AND SALVAGE EXISTING POLE AND ALL EQUIPMENT ATTACHED TO IT.	
(F')	15TS (N)	-	15' (N)	-	SV-2-TA (N)	2 (N)	SP-1-T (N)	2 (N)	RIGHT (N)	78W LED (N)	XXXX		


PROJECT
GOLDEN STATE CORRIDOR - ECONOMIC DEVELOPMENT AND INFRASTRUCTURE IMPROVEMENTS
FOWLER REGION

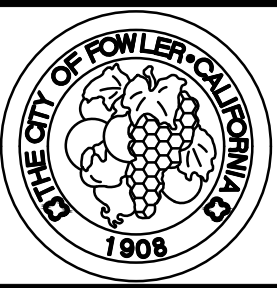


DEPARTMENT OF PUBLIC WORKS AND PLANNING					
GOLDEN STATE BLVD AT JUG HANDLE TO CLOVIS AVE COND. AND EQUIP. SCHEDULE					
DRAWING NO.	E-33	SHEET NO.	140	TOTAL	142

PATH: Z:\01 Projects\009 Fresno County\009-Golden State PS&E\Traffic Signal Designs\2a-Golden State Blvd at Jug Handle to Clovis Ave\Golden State Blvd at Jug Handle to Clovis Ave.dwg PLOT DATE: 3/30/2021 10:58:51 AM CAD USER: CAYALA


EXISTING STEADY DEMAND SEQUENCE

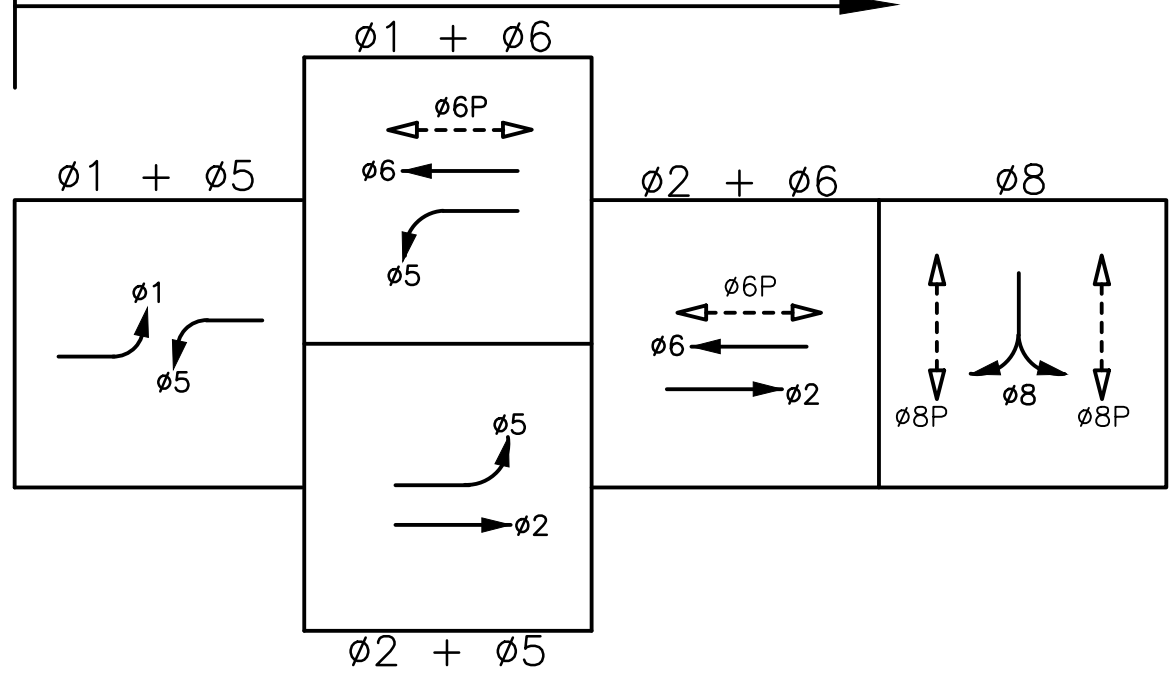

EXISTING PHASE DIAGRAM

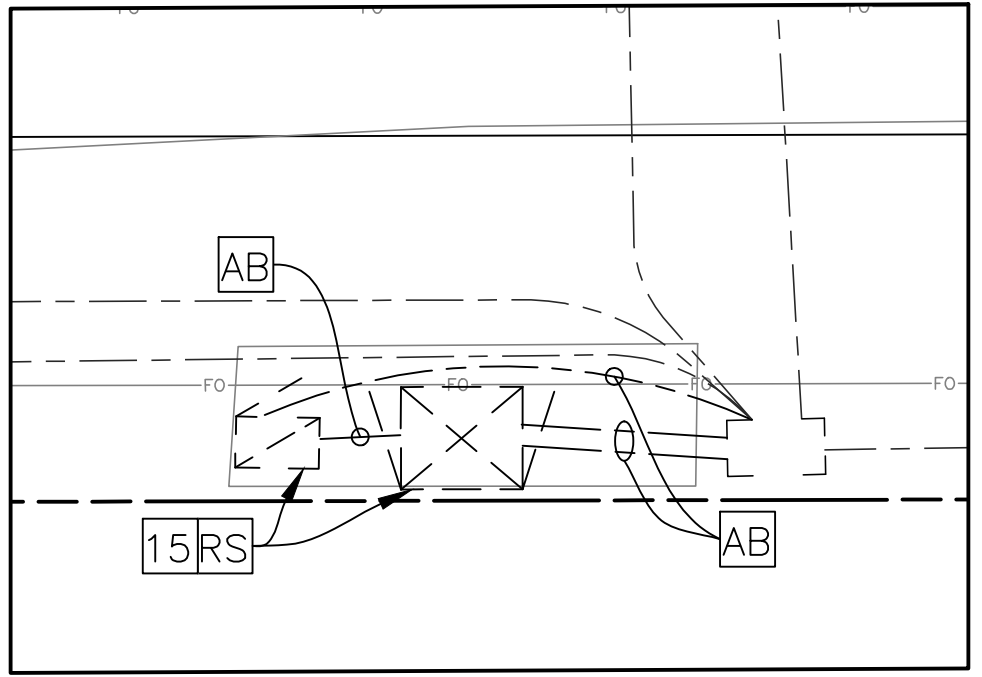

EXISTING CONTROLLER LOCATION – DETAIL A2
NO SCALE

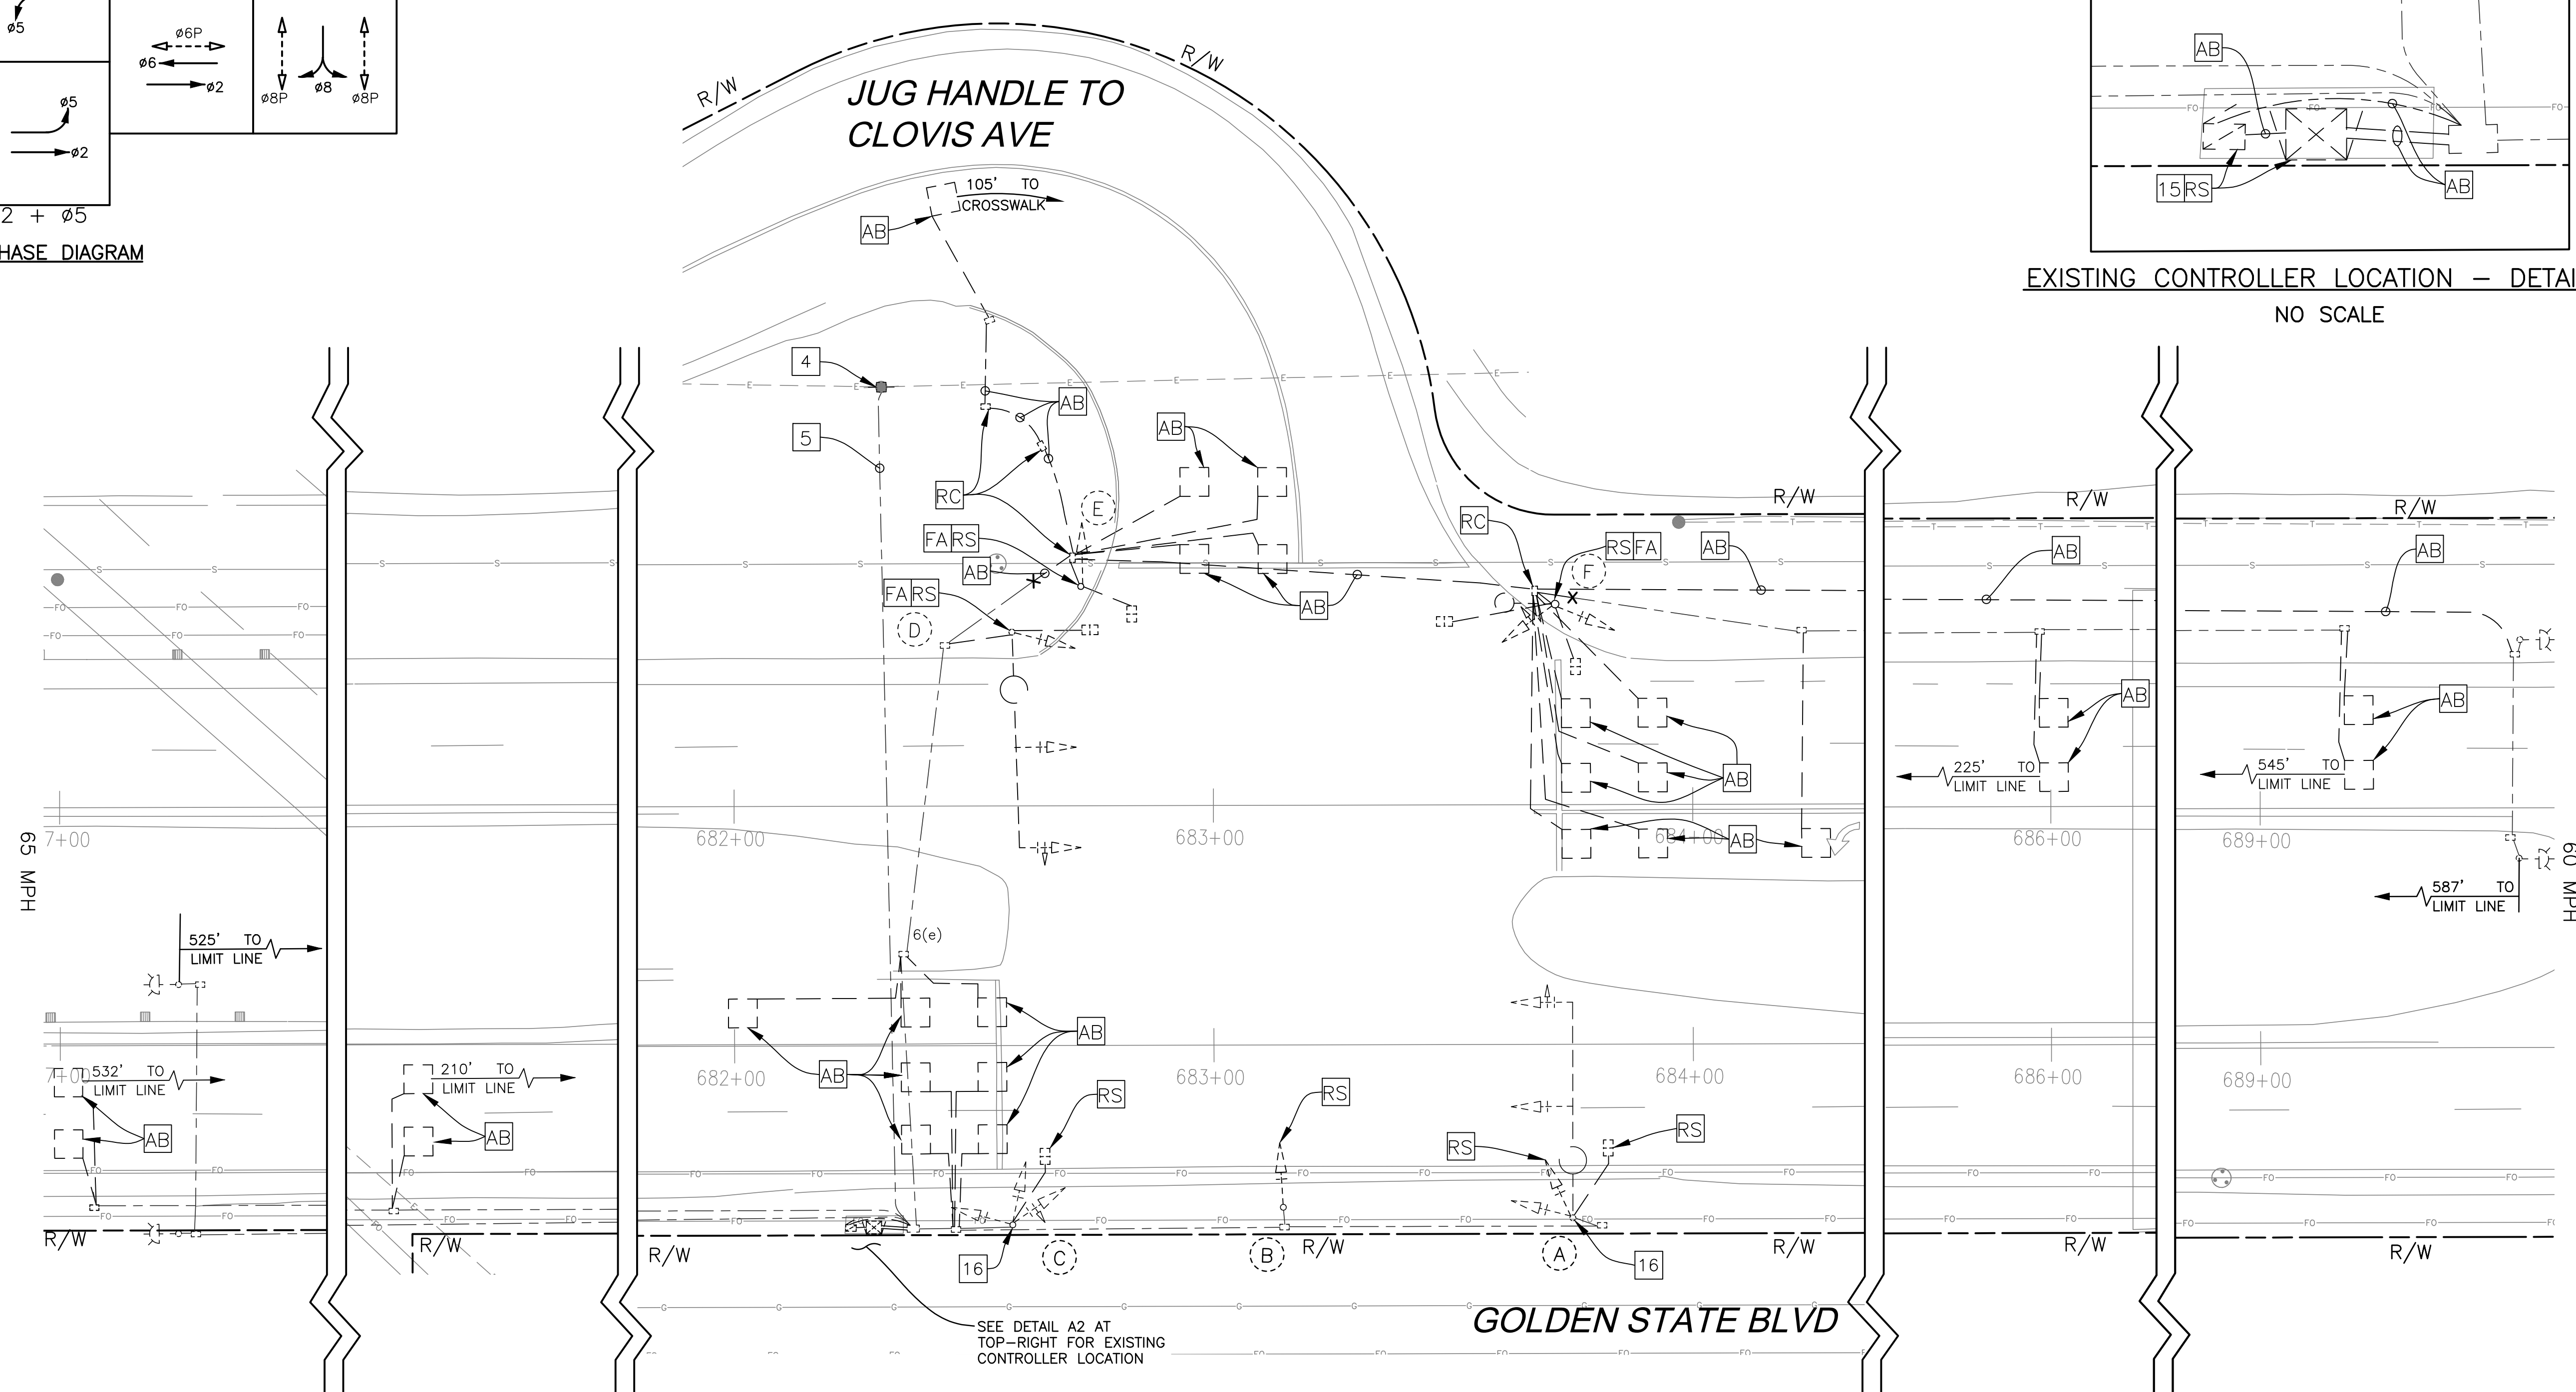

DESIGNED:	DATE	RECORD DRAWING	
J. BENAVIDES	03/30/2021	RESIDENT ENGINEER	DATE
DRAWN:	03/30/2021		
C. AYALA-MAGANA	03/30/2021		
CHECKED:	03/30/2021		
J. RIOS	03/30/2021		




JLB TRAFFIC
ENGINEERING, INC.
516 W. SHAW AVE., STE. 103
FRESNO, CA 93704
PHONE: (559) 570-8991
EMAIL: info@JLBtraffic.com

TENTATIVE PLANS FOR DESIGN
SUPERVISING ENGINEER
DATE




PROJECT
GOLDEN STATE CORRIDOR - ECONOMIC DEVELOPMENT
AND INFRASTRUCTURE IMPROVEMENTS
FOWLER REGION

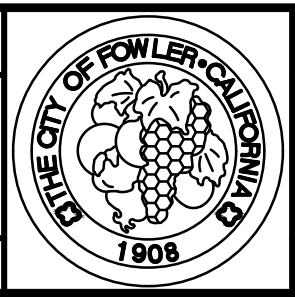


DEPARTMENT OF PUBLIC WORKS AND PLANNING
GOLDEN STATE BLVD AT JUG HANDLE TO
CLOVIS AVE TRAFFIC SIGNAL DEMOLITION PLAN
DRAWING NO. E-34 SHEET NO. 141 TOTAL 142

CAD USER: CAYALA
PLOT DATE: 4/6/2021 4:30:57 PM
PATH: Z:\01 Projects\009 Fresno County\009-009 Golden State PS&E\Traffic Signal Designs\General Details and Notes\CSB Detail - Fowler Region.dwg

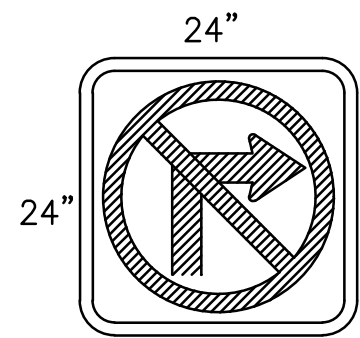

R3-1 BLANK OUT SIGN (24" x 24") - DETAIL B

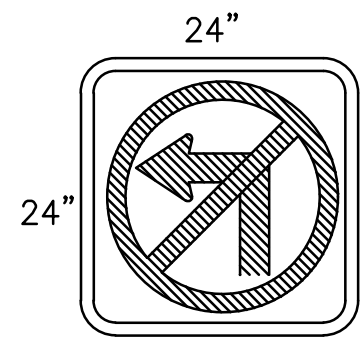


R3-2 BLANK OUT SIGN (24" x 24") - DETAIL C




R73-2 (MOD) - DETAIL J

DETAIL D NOTES


- 1 ROUND CORNERS OF ACUTE ANGLE SAWCUTS TO PREVENT DAMAGE TO CONDUCTORS.
- 2 INSTALL 3 TURNS WHEN ONLY ONE BIKE LOOP IS ON A SENSOR UNIT CHANNEL.
INSTALL 5 TURNS WHEN ONE BIKE LOOP IS CONNECTED IN SERIES WITH 3 ADDITIONAL 6' X6' LOOPS ON A SENSOR UNIT CHANNEL.

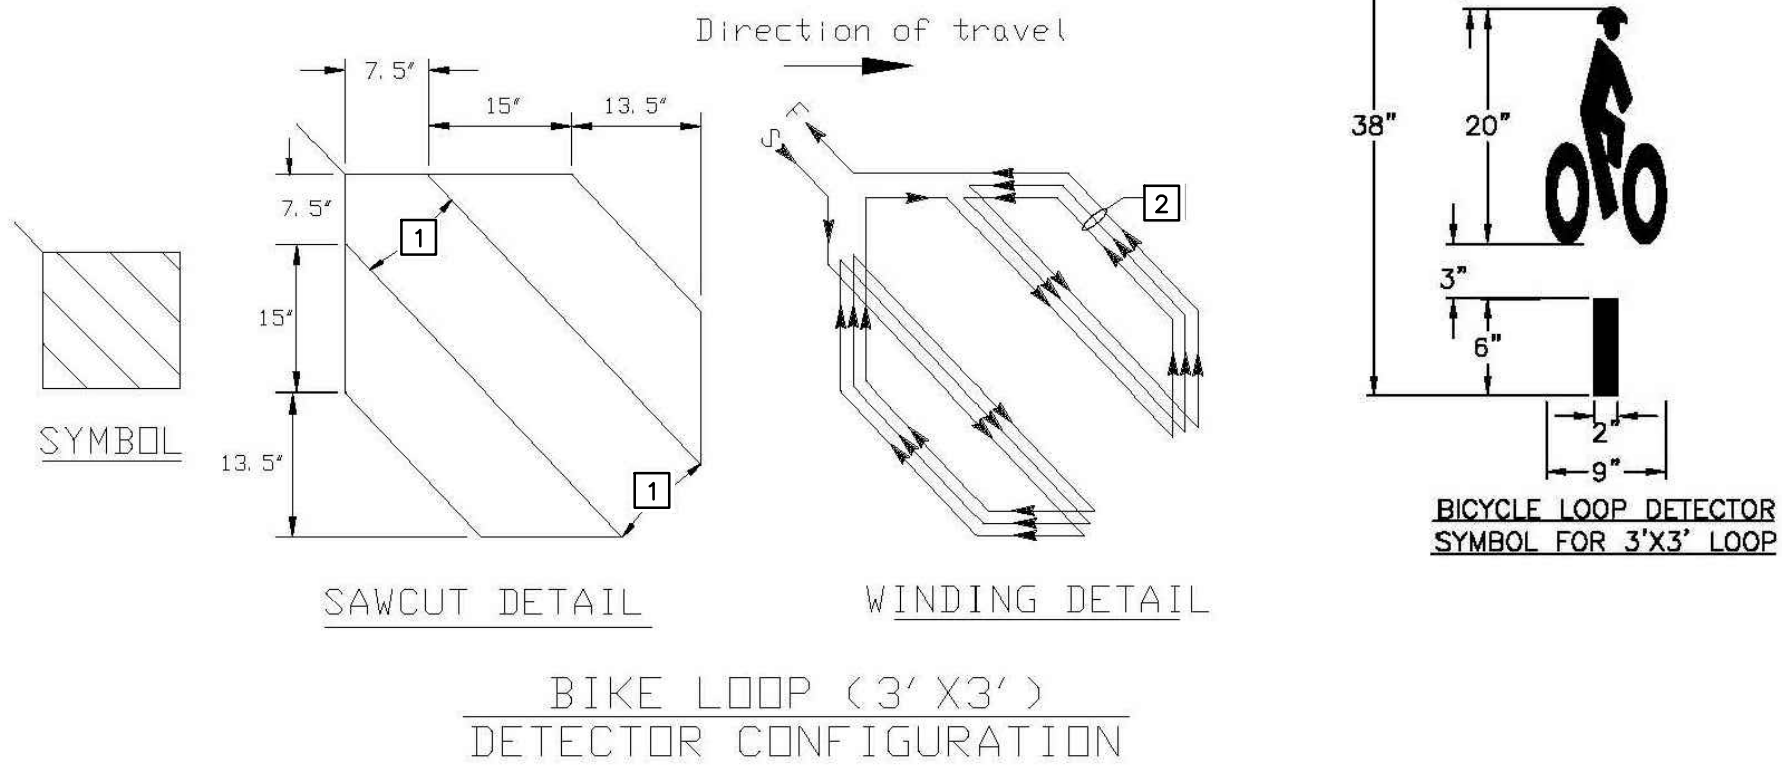


TYPE D 3'X3' BIKE LOOP - DETAIL D
NO SCALE

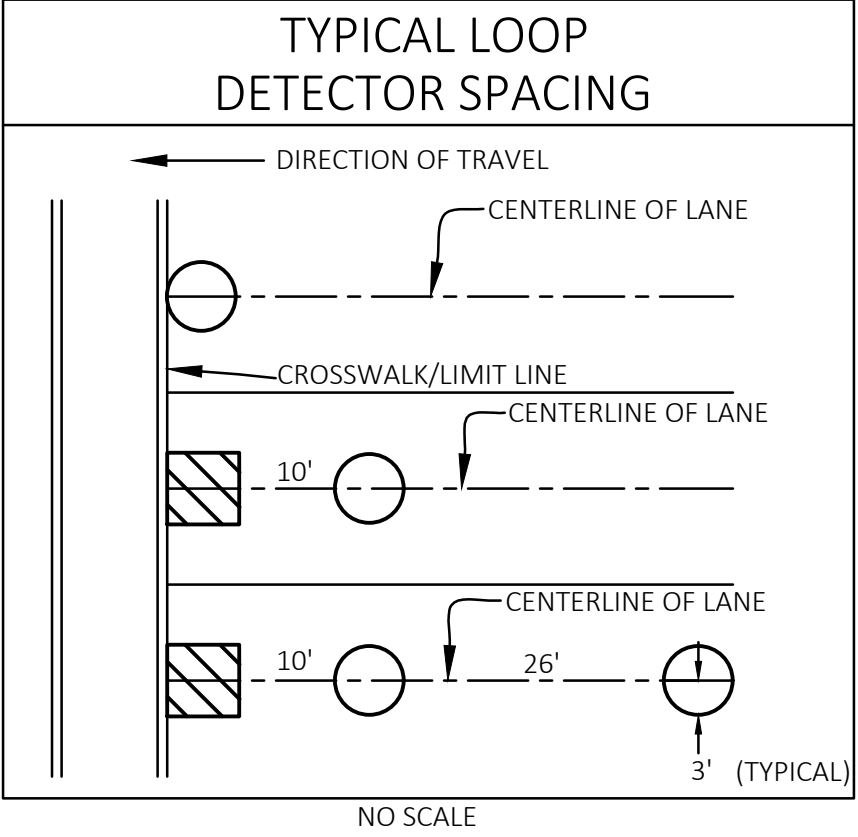

TYPICAL LOOP DETECTOR PLACEMENT - DETAIL E

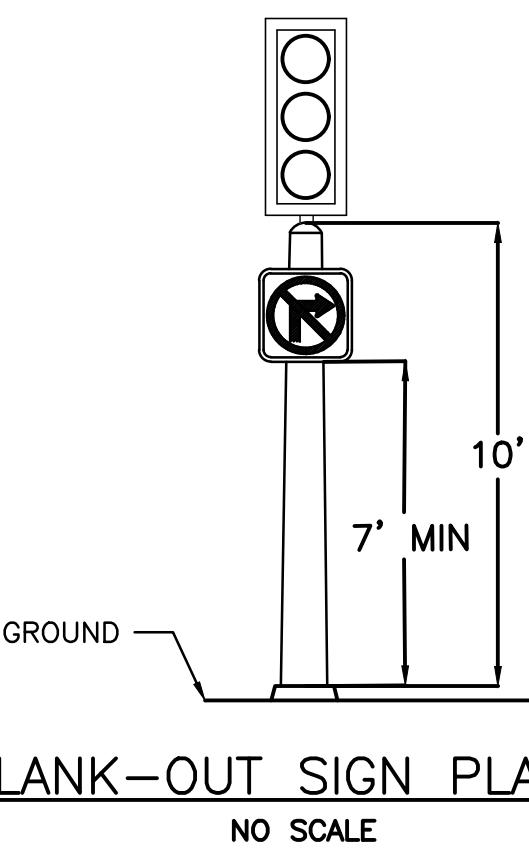


1-A (10') BLANK-OUT SIGN PLACEMENT - DETAIL F
NO SCALE

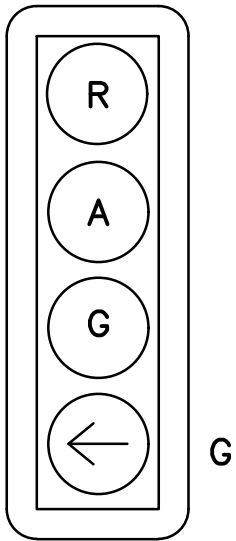


4-SECTION SIGNAL HEAD - DETAIL H




WARNING LABEL - DETAIL I

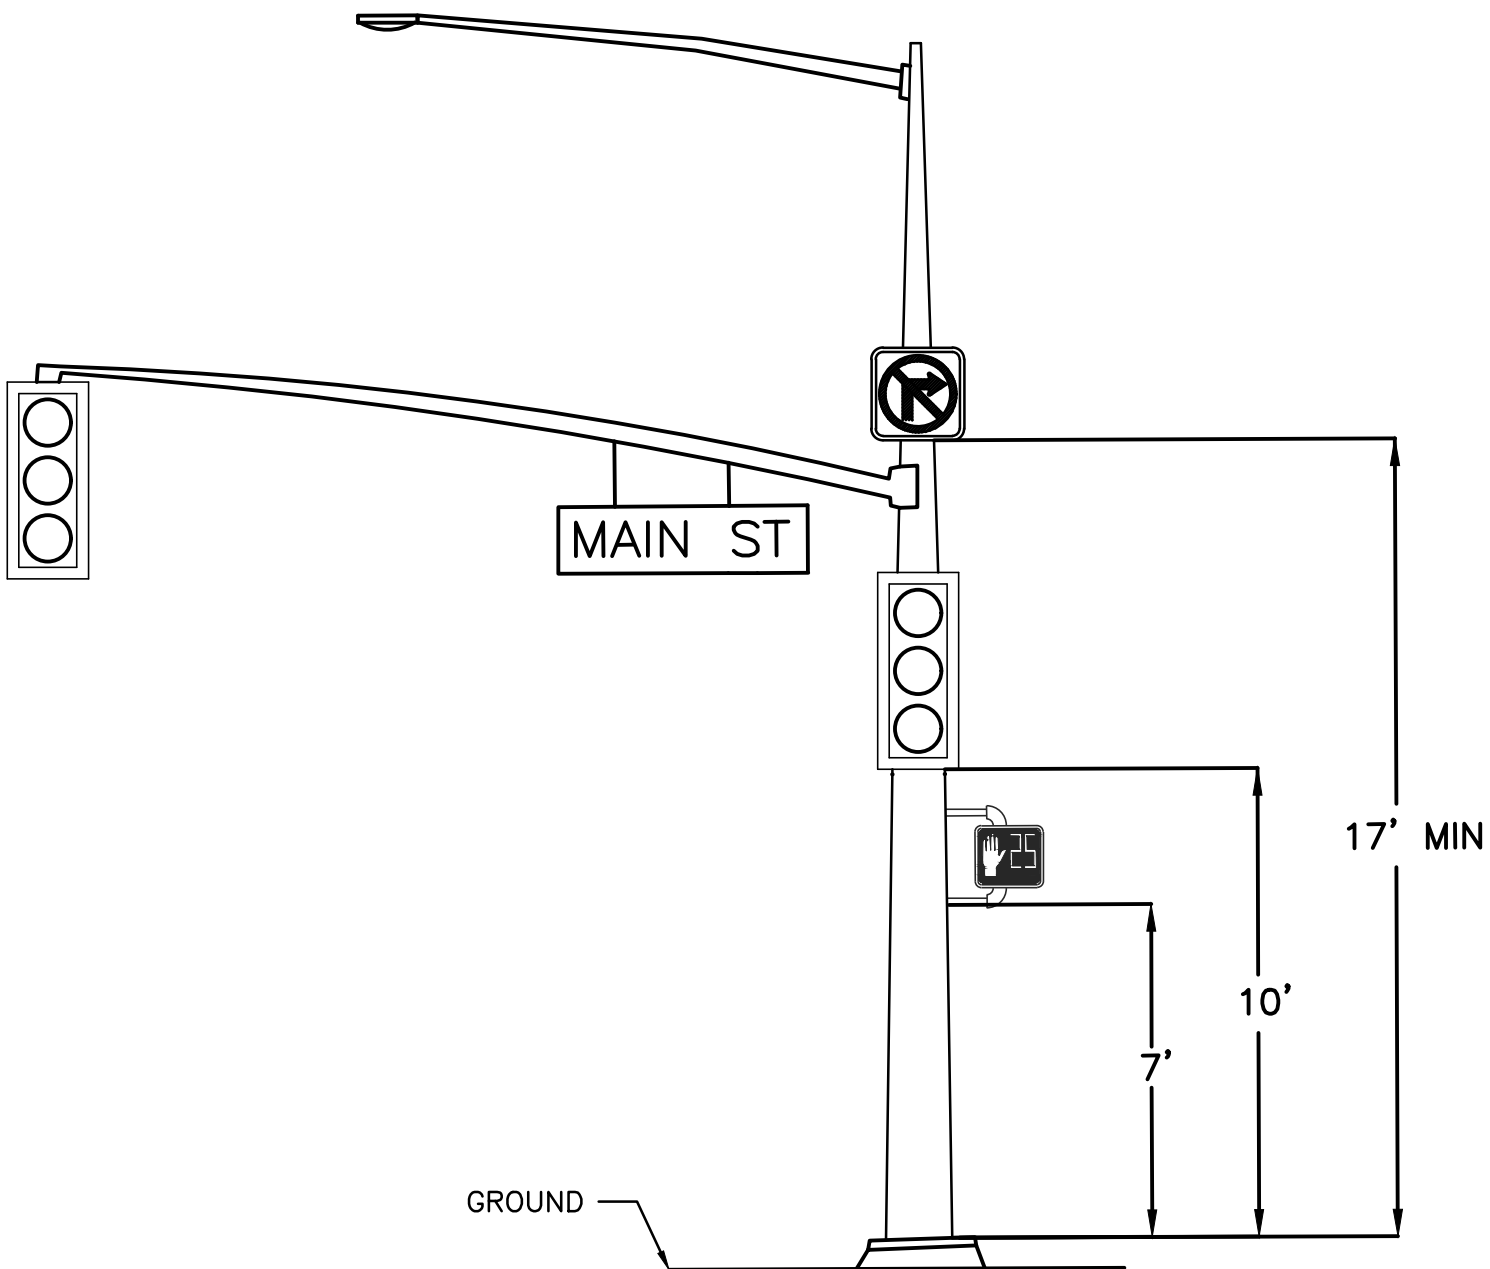


BLANK-OUT SIGN PLACEMENT - DETAIL G
NO SCALE

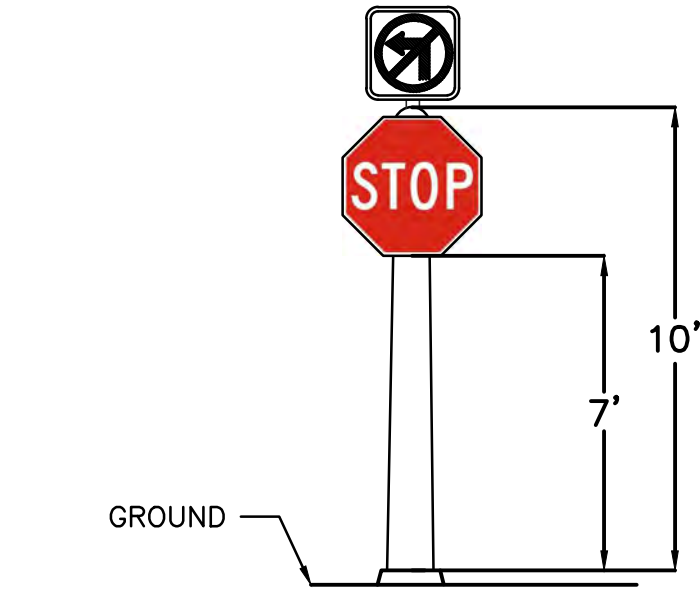


1-A (10') BLANK-OUT SIGN PLACEMENT - DETAIL M
NO SCALE

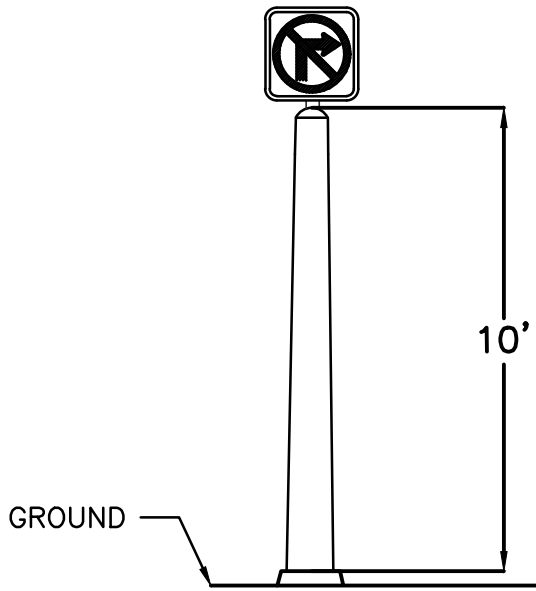

1-A (10') BLANK-OUT SIGN PLACEMENT - DETAIL K
NO SCALE

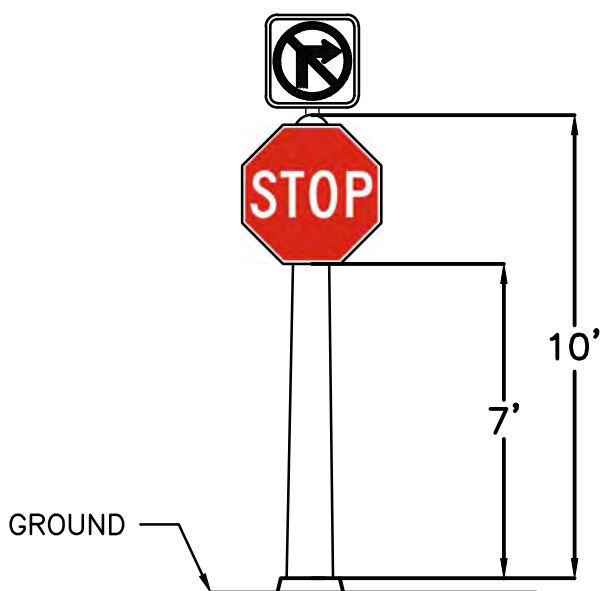

1-A (10') BLANK-OUT SIGN PLACEMENT - DETAIL N
NO SCALE

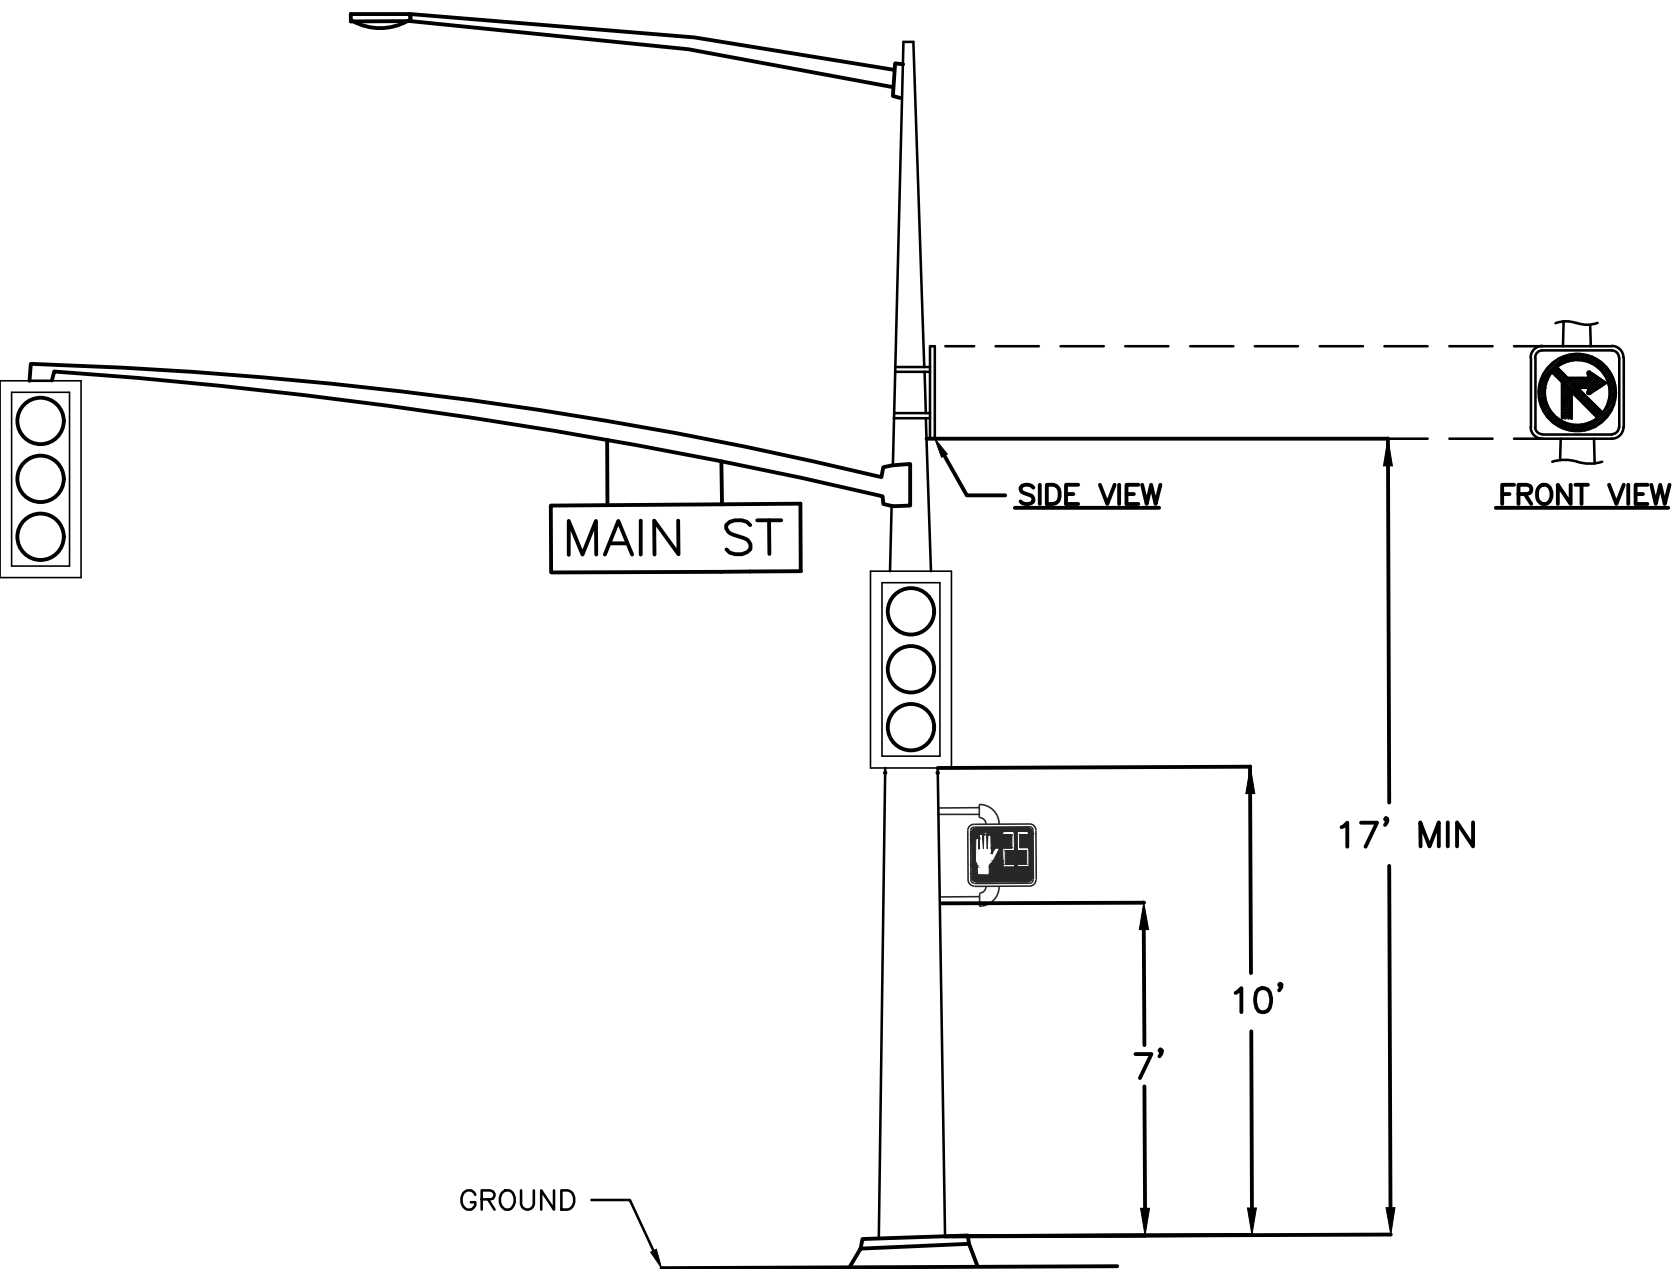

BLANK-OUT SIGN PLACEMENT - DETAIL L
NO SCALE

	DATE	RECORD DRAWING		 CALL BEFORE YOU DIG	 516 W. SHAW AVE., STE. 103 FRESNO, CA 93704 PHONE: (559) 570-8991 EMAIL: info@JLBtraffic.com		PROJECT			DEPARTMENT OF PUBLIC WORKS AND PLANNING	
DESIGNED: J. BENAVIDES	04/06/2021	RESIDENT ENGINEER	DATE				GOLDEN STATE CORRIDOR - ECONOMIC DEVELOPMENT AND INFRASTRUCTURE IMPROVEMENTS			GOLDEN STATE BLVD DETAILS FOWLER REGION	
DRAWN: C. AYALA-MAGANA	04/06/2021										
CHECKED: J. RIOS	04/06/2021										
FOR RIGHT OF WAY DATA AND ACCURATE ACCESS DETERMINATION, SEE DOCUMENTS IN THE DEPARTMENT OF PUBLIC WORKS AND PLANNING.							TENTATIVE PLANS FOR DESIGN			FOWLER REGION	