

CAD USER: THARDY
PLOT DATE: 3/12/2021 11:45:50 AM
PATH: J:\Fresno COG-FN-16105-GSB Final Design\CADD\Sheets\Region 2 - Selma\GSB_R2_U1-U7.dwg

ABBREVIATIONS

AT&T	AMERICAN TELEPHONE AND TELEGRAPH
COS	CITY OF SELMA
(E)	EXISTING
ELEC	ELECTRICAL
FO	FIBER OPTICS
IRR	IRRIGATION
NATGAS	NATURAL GAS
OH	OVER HEAD
(P)	PROPOSED
PG&E	PACIFIC GAS AND ELECTRIC
SD	STORM DRAIN
SKFCSD	SELMA-KINGSBURG-FOWLER COUNTY SANITATION DISTRICT
STA	STATION
TELECOM	TELEPHONE COMMUNICATION
UG	UNDERGROUND

UTILITY NOTES:


1	ADJUST (E) WATER VALVE TO GRADE	3	ADJUST (E) SEWER MH TO GRADE
2	ADJUST (E) STORM DRAIN MH TO GRADE	4	ADJUST (E) COMM MH TO GRADE

LEGEND

---	e---	(E)ELEC UG
---	g---	(E)GAS
---	s---	(E)SEWER
---	sd---	(E)SD
---	w---	(E)WATER
---	t---	(E)TELECOM UG
---	fo---	(E)FIBER OPTIC UG
---	irr---	(E)IRRIGATION
---	j+t---	(E)JOINT OH
---	t---	(E)TELECOM OH
---	e---	(E)ELEC OH

NOTES

1. THE CONTRACTOR SHALL BE RESPONSIBLE FOR CONTACTING THE RESPECTIVE UTILITY COMPANIES 48 HOURS PRIOR TO WORKING AROUND ANY OF THEIR UNDERGROUND UTILITIES FOR VERIFICATION AT THE SITE OF ANY POSSIBLE CONFLICTS WITH THE PROPOSED IMPROVEMENTS SHOWN ON THESE PLANS.
2. THE TYPES, LOCATIONS, SIZES, AND DEPTHS OF EXISTING UNDERGROUND UTILITIES SHOWN ON THESE PLANS WERE OBTAINED FROM SOURCES OF VARYING RELIABILITY. THE CONTRACTOR IS CAUTIONED THAT ONLY ACTUAL EXCAVATION WILL REVEAL THE TYPES, EXTENT, SIZES, LOCATIONS, AND DEPTHS OF SUCH UNDERGROUND UTILITIES. THE CITY OF SELMA AND ITS CONSULTANT, MARK THOMAS & COMPANY INC., CAN NOT ASSUME THE RESPONSIBILITY FOR THE COMPLETENESS OR ACCURACY OF THE DELINEATION OF SUCH UTILITIES NOR THE EXISTENCE OF OTHER BURIED OBJECTS OF SUCH UNDERGROUND UTILITIES WHICH MAY BE ENCOUNTERED BUT WHICH ARE NOT SHOWN ON THESE PLANS.
3. FOR UTILITY CONTACT INFORMATION SEE SHEET G-1.
4. ALL UTILITY MANHOLE AND VAULT COVERS THAT REQUIRE ADJUSTMENT DUE TO CHANGES IN GRADE DURING CONSTRUCTION SHALL BE DONE IN COMPLIANCE OF THE CITY OF SELMA STANDARDS AND REQUIREMENTS.
5. ALL UTILITIES, UTILITY POLES, UTILITY MANHOLES, OR ANY OTHER FACILITIES ASSOCIATED WITH A PUBLIC OR PRIVATE UTILITY OWNER REPRESENTED ON THESE PLANS SHALL BE CONSIDERED "TO REMAIN" UNLESS INDICATED OTHERWISE.

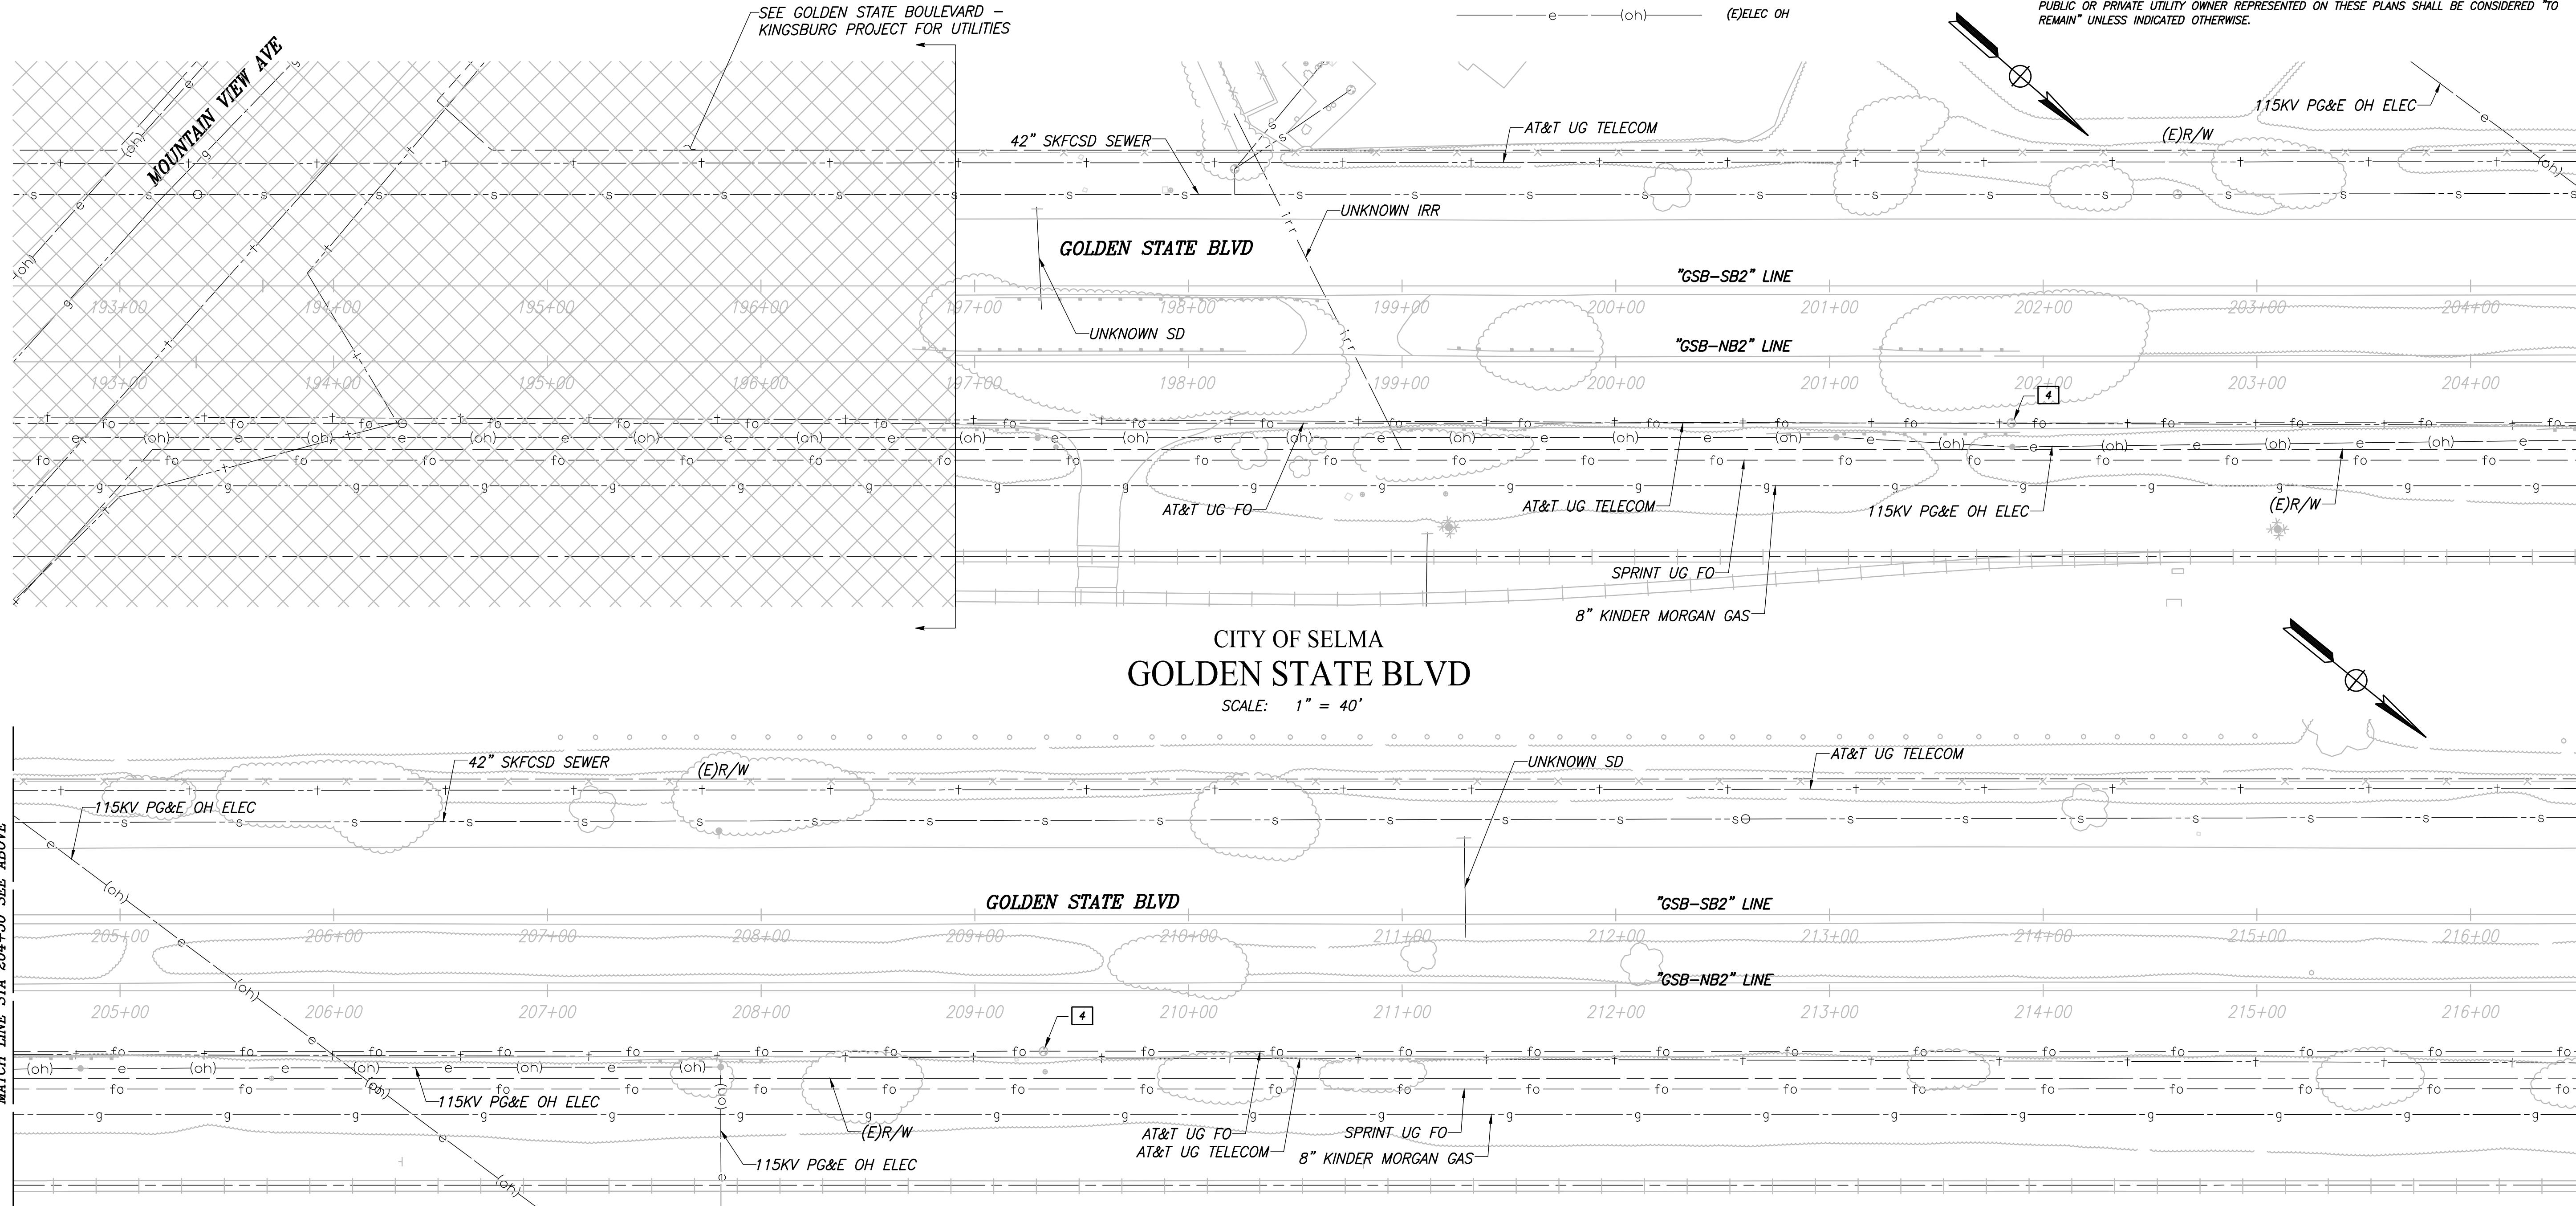

DESIGNED:	DATE	RECORD DRAWING	
CYNTHIA HORNER	3/12/2021	RESIDENT ENGINEER	DATE
DILLON ALAMEDA	3/12/2021		
CHECKED:	3/12/2021		
JAMES POLFER			


FOR RIGHT OF WAY DATA AND ACCURATE ACCESS DETERMINATION, SEE DOCUMENTS IN THE DEPARTMENT OF PUBLIC WORKS AND PLANNING.



TENTATIVE PLANS FOR DESIGN	
SUPERVISING ENGINEER	DATE




PROJECT	
GOLDEN STATE CORRIDOR - ECONOMIC DEVELOPMENT AND INFRASTRUCTURE IMPROVEMENTS	
SELMA REGION	

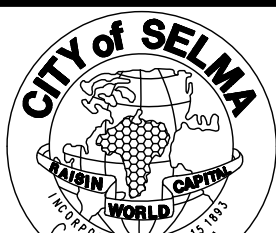


DEPARTMENT OF PUBLIC WORKS AND PLANNING		
UTILITY PLAN		
DRAWING NO. U-1	SHEET NO. 79	TOTAL 154

PLOT DATE: 3/12/2021 11:46:07 AM
 CAD USER: THARDY

PATH: J:\Fresno COG-FN-16105-GSB Final Design\CADD\Sheets\Region 2 - Selma\GSB_R2_U1-U7.dwg

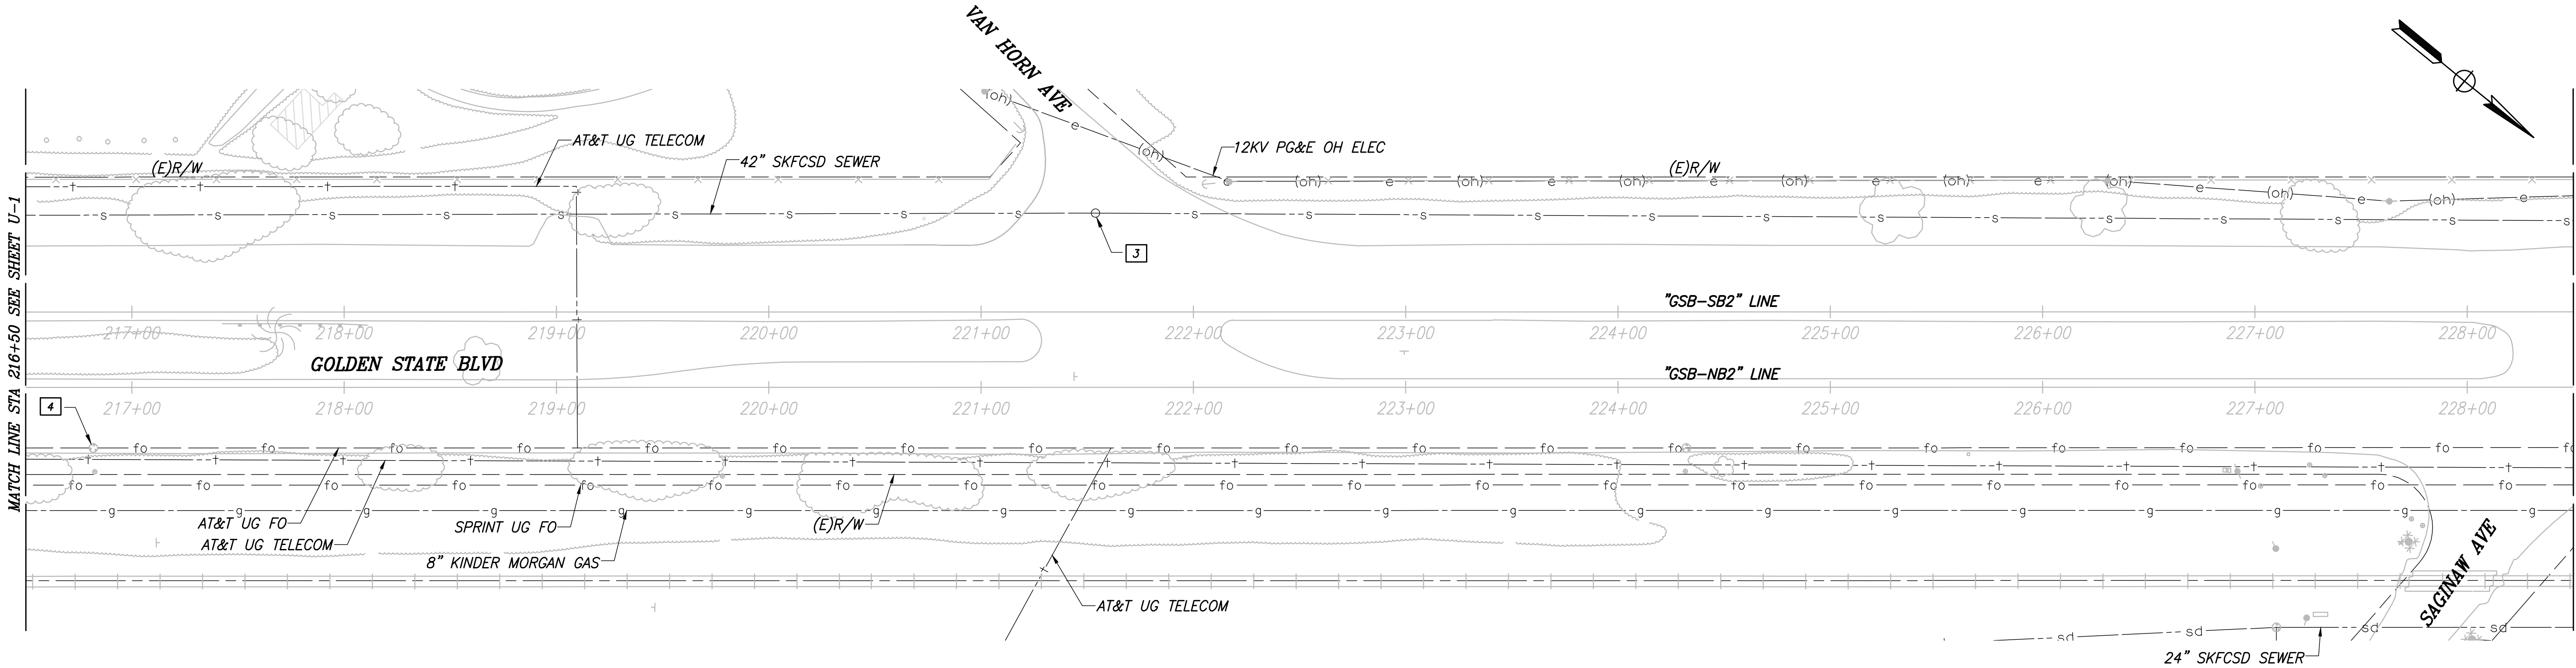

CITY OF SELMA
 GOLDEN STATE BLVD
 SCALE: 1" = 40'

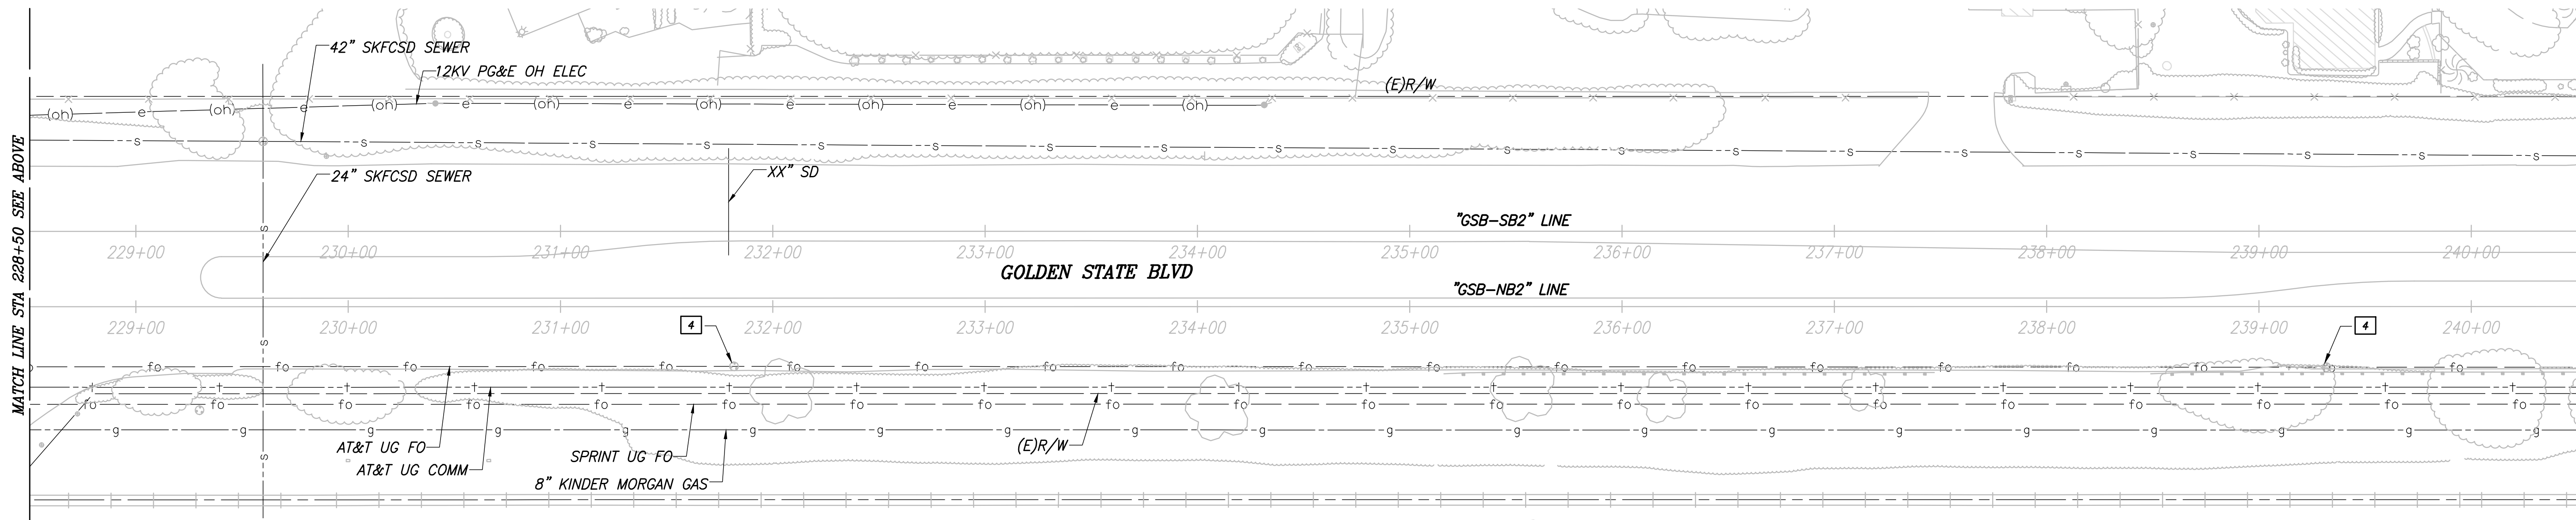

RECORD DRAWING	
DESIGNED: CYNTHIA HORNER	DATE: 3/12/2021
DRAWN: DILLON ALAMEDA	DATE: 3/12/2021
CHECKED: JAMES POLFER	DATE: 3/12/2021


FOR RIGHT OF WAY DATA AND ACCURATE ACCESS DETERMINATION, SEE DOCUMENTS IN THE DEPARTMENT OF PUBLIC WORKS AND PLANNING.



TENTATIVE PLANS FOR DESIGN



PROJECT
 GOLDEN STATE CORRIDOR - ECONOMIC DEVELOPMENT AND INFRASTRUCTURE IMPROVEMENTS
 SELMA REGION

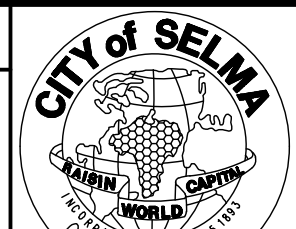


DEPARTMENT OF PUBLIC WORKS AND PLANNING
 UTILITY PLAN


DRAWING NO. U-2 SHEET NO. 80 TOTAL 154

PATH: J:\Fresno COG-FN-16105-GSB Final Design\CADD\Sheets\Region 2 - Selma\GSB_R2_U1-U7.dwg
PLOT DATE: 3/12/2021 11:46:25 AM CAD USER: THARDY

PATH: J:\Fresno COG-FN-16105-GSB Final Design\CADD\Sheets\Region 2 - Selma\GSB_R2_U1-U7.dwg
PLOT DATE: 3/12/2021 11:46:25 AM CAD USER: THARDY

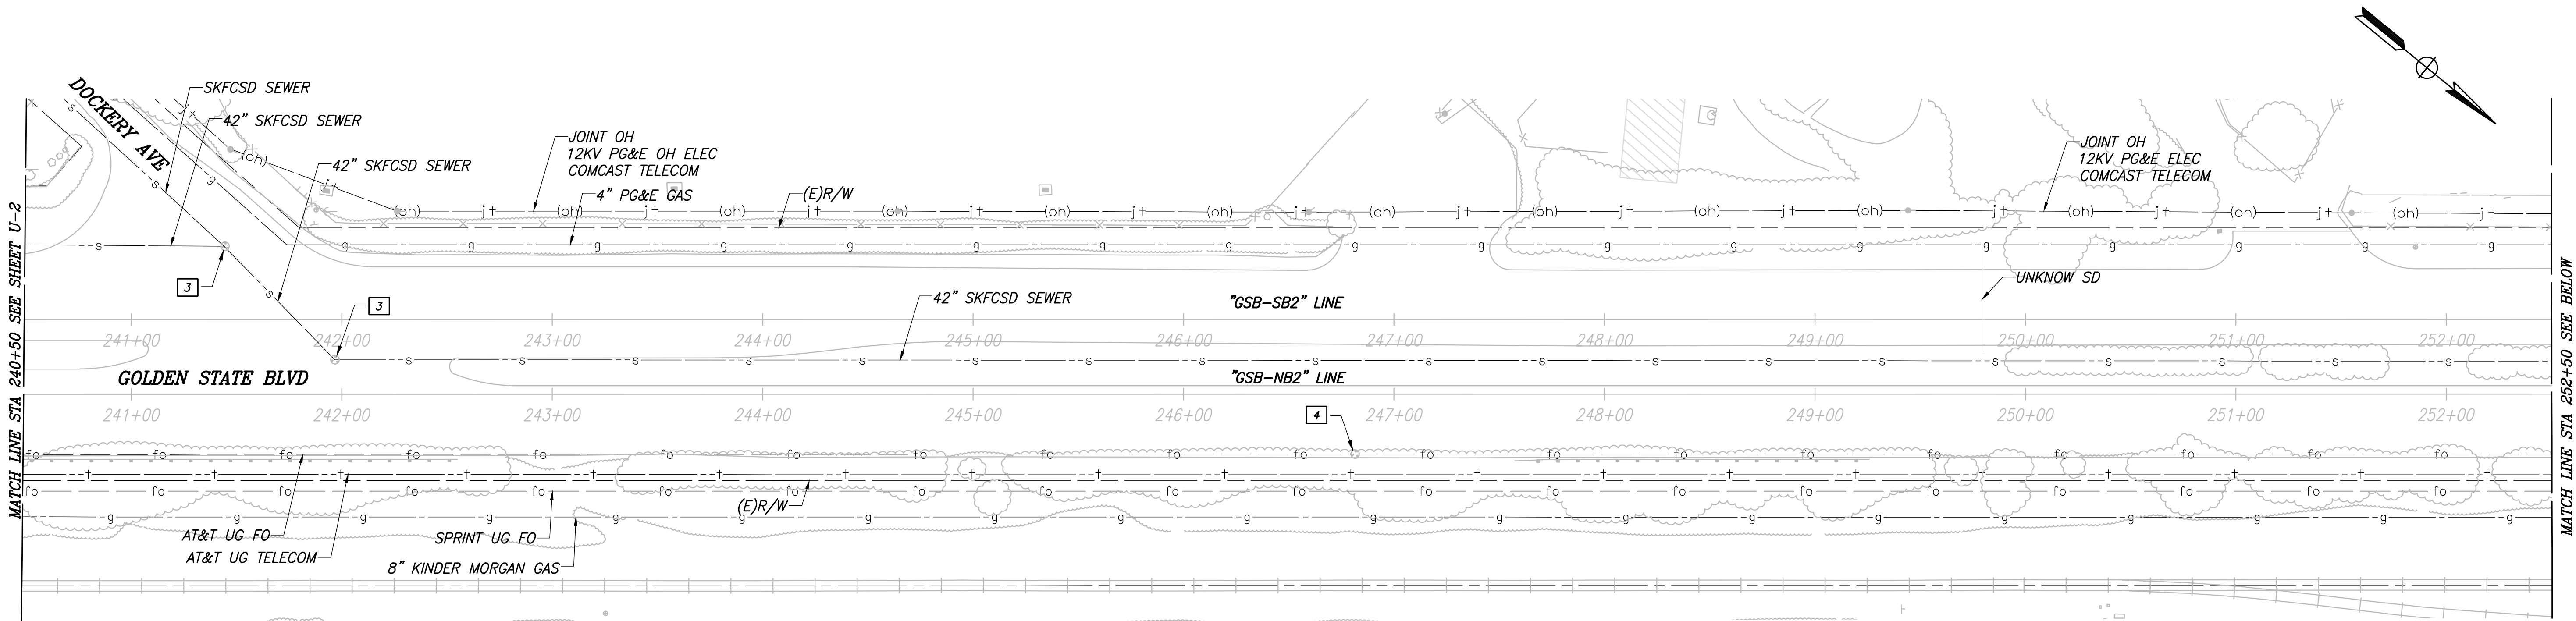

CITY OF SELMA
GOLDEN STATE BLVD
SCALE: 1" = 40'

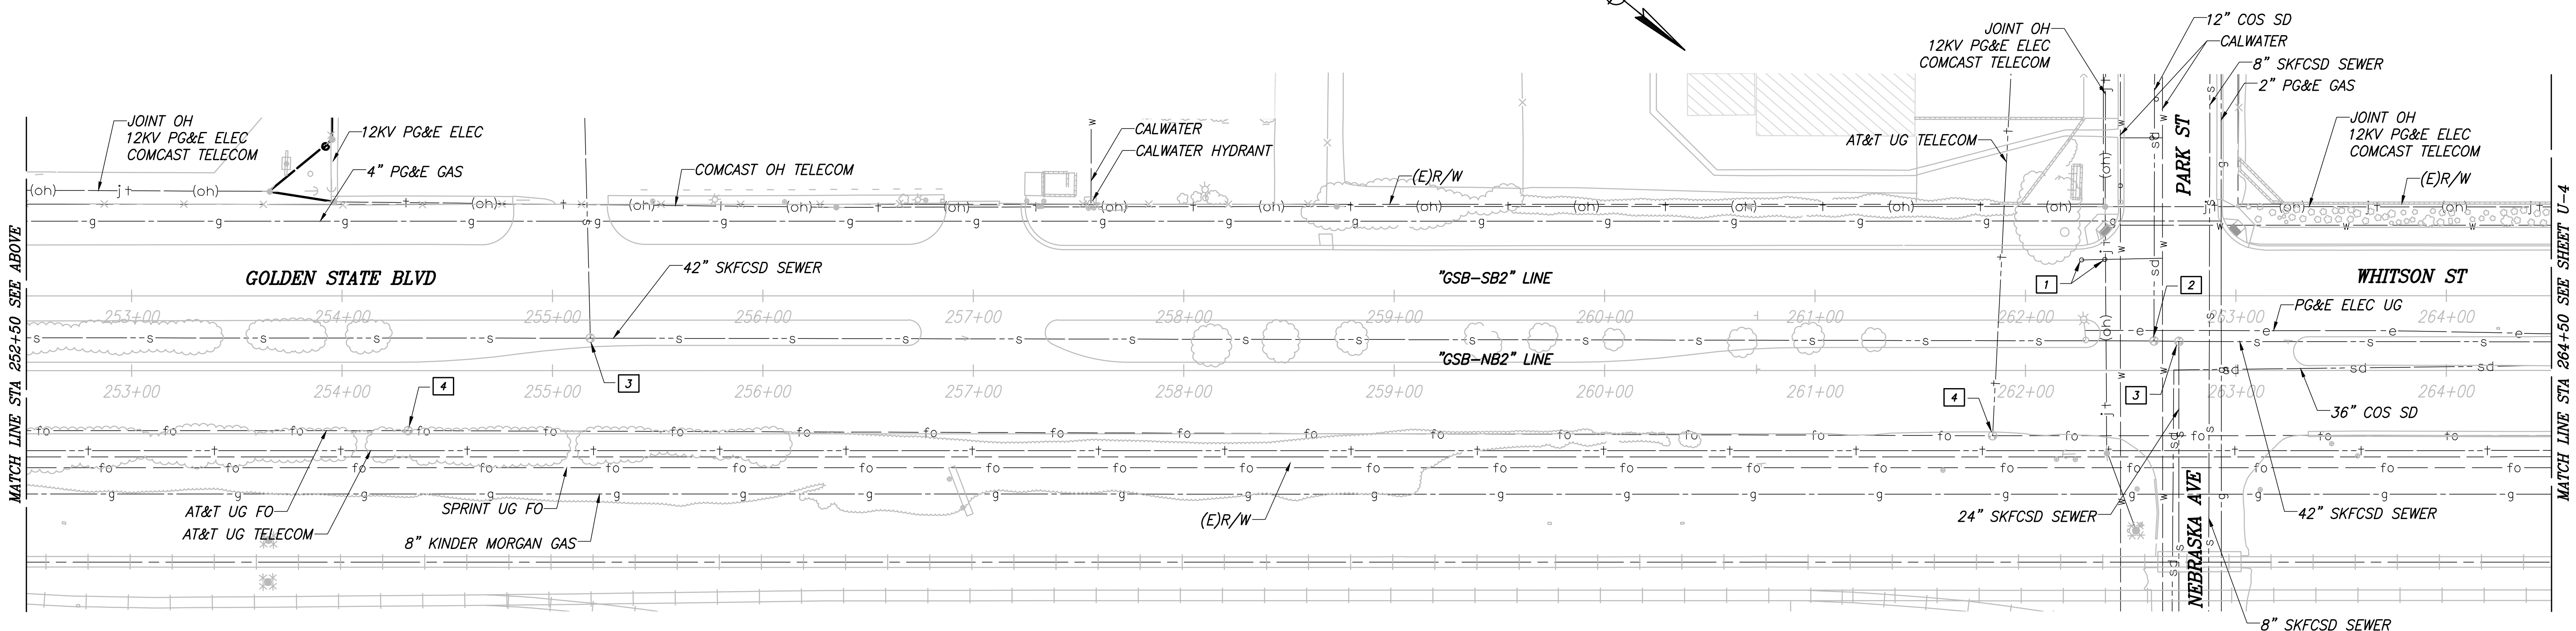

RECORD DRAWING	
DESIGNED: CYNTHIA HORNER	DATE: 3/12/2021
DRAWN: DILLON ALAMEDA	DATE: 3/12/2021
CHECKED: JAMES POLFER	DATE: 3/12/2021


FOR RIGHT OF WAY DATA AND ACCURATE ACCESS DETERMINATION, SEE DOCUMENTS IN THE DEPARTMENT OF PUBLIC WORKS AND PLANNING.




TENTATIVE PLANS FOR DESIGN	DATE: 3/30/21
SUPERVISING ENGINEER	DATE: 3/30/21




PROJECT
GOLDEN STATE CORRIDOR - ECONOMIC DEVELOPMENT AND INFRASTRUCTURE IMPROVEMENTS
SELMA REGION

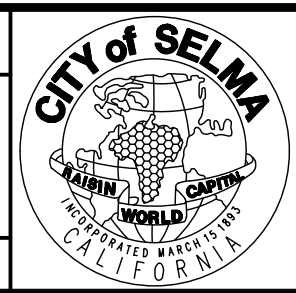

DEPARTMENT OF PUBLIC WORKS AND PLANNING		
UTILITY PLAN		
DRAWING NO. U-3	SHEET NO. 81	TOTAL 154

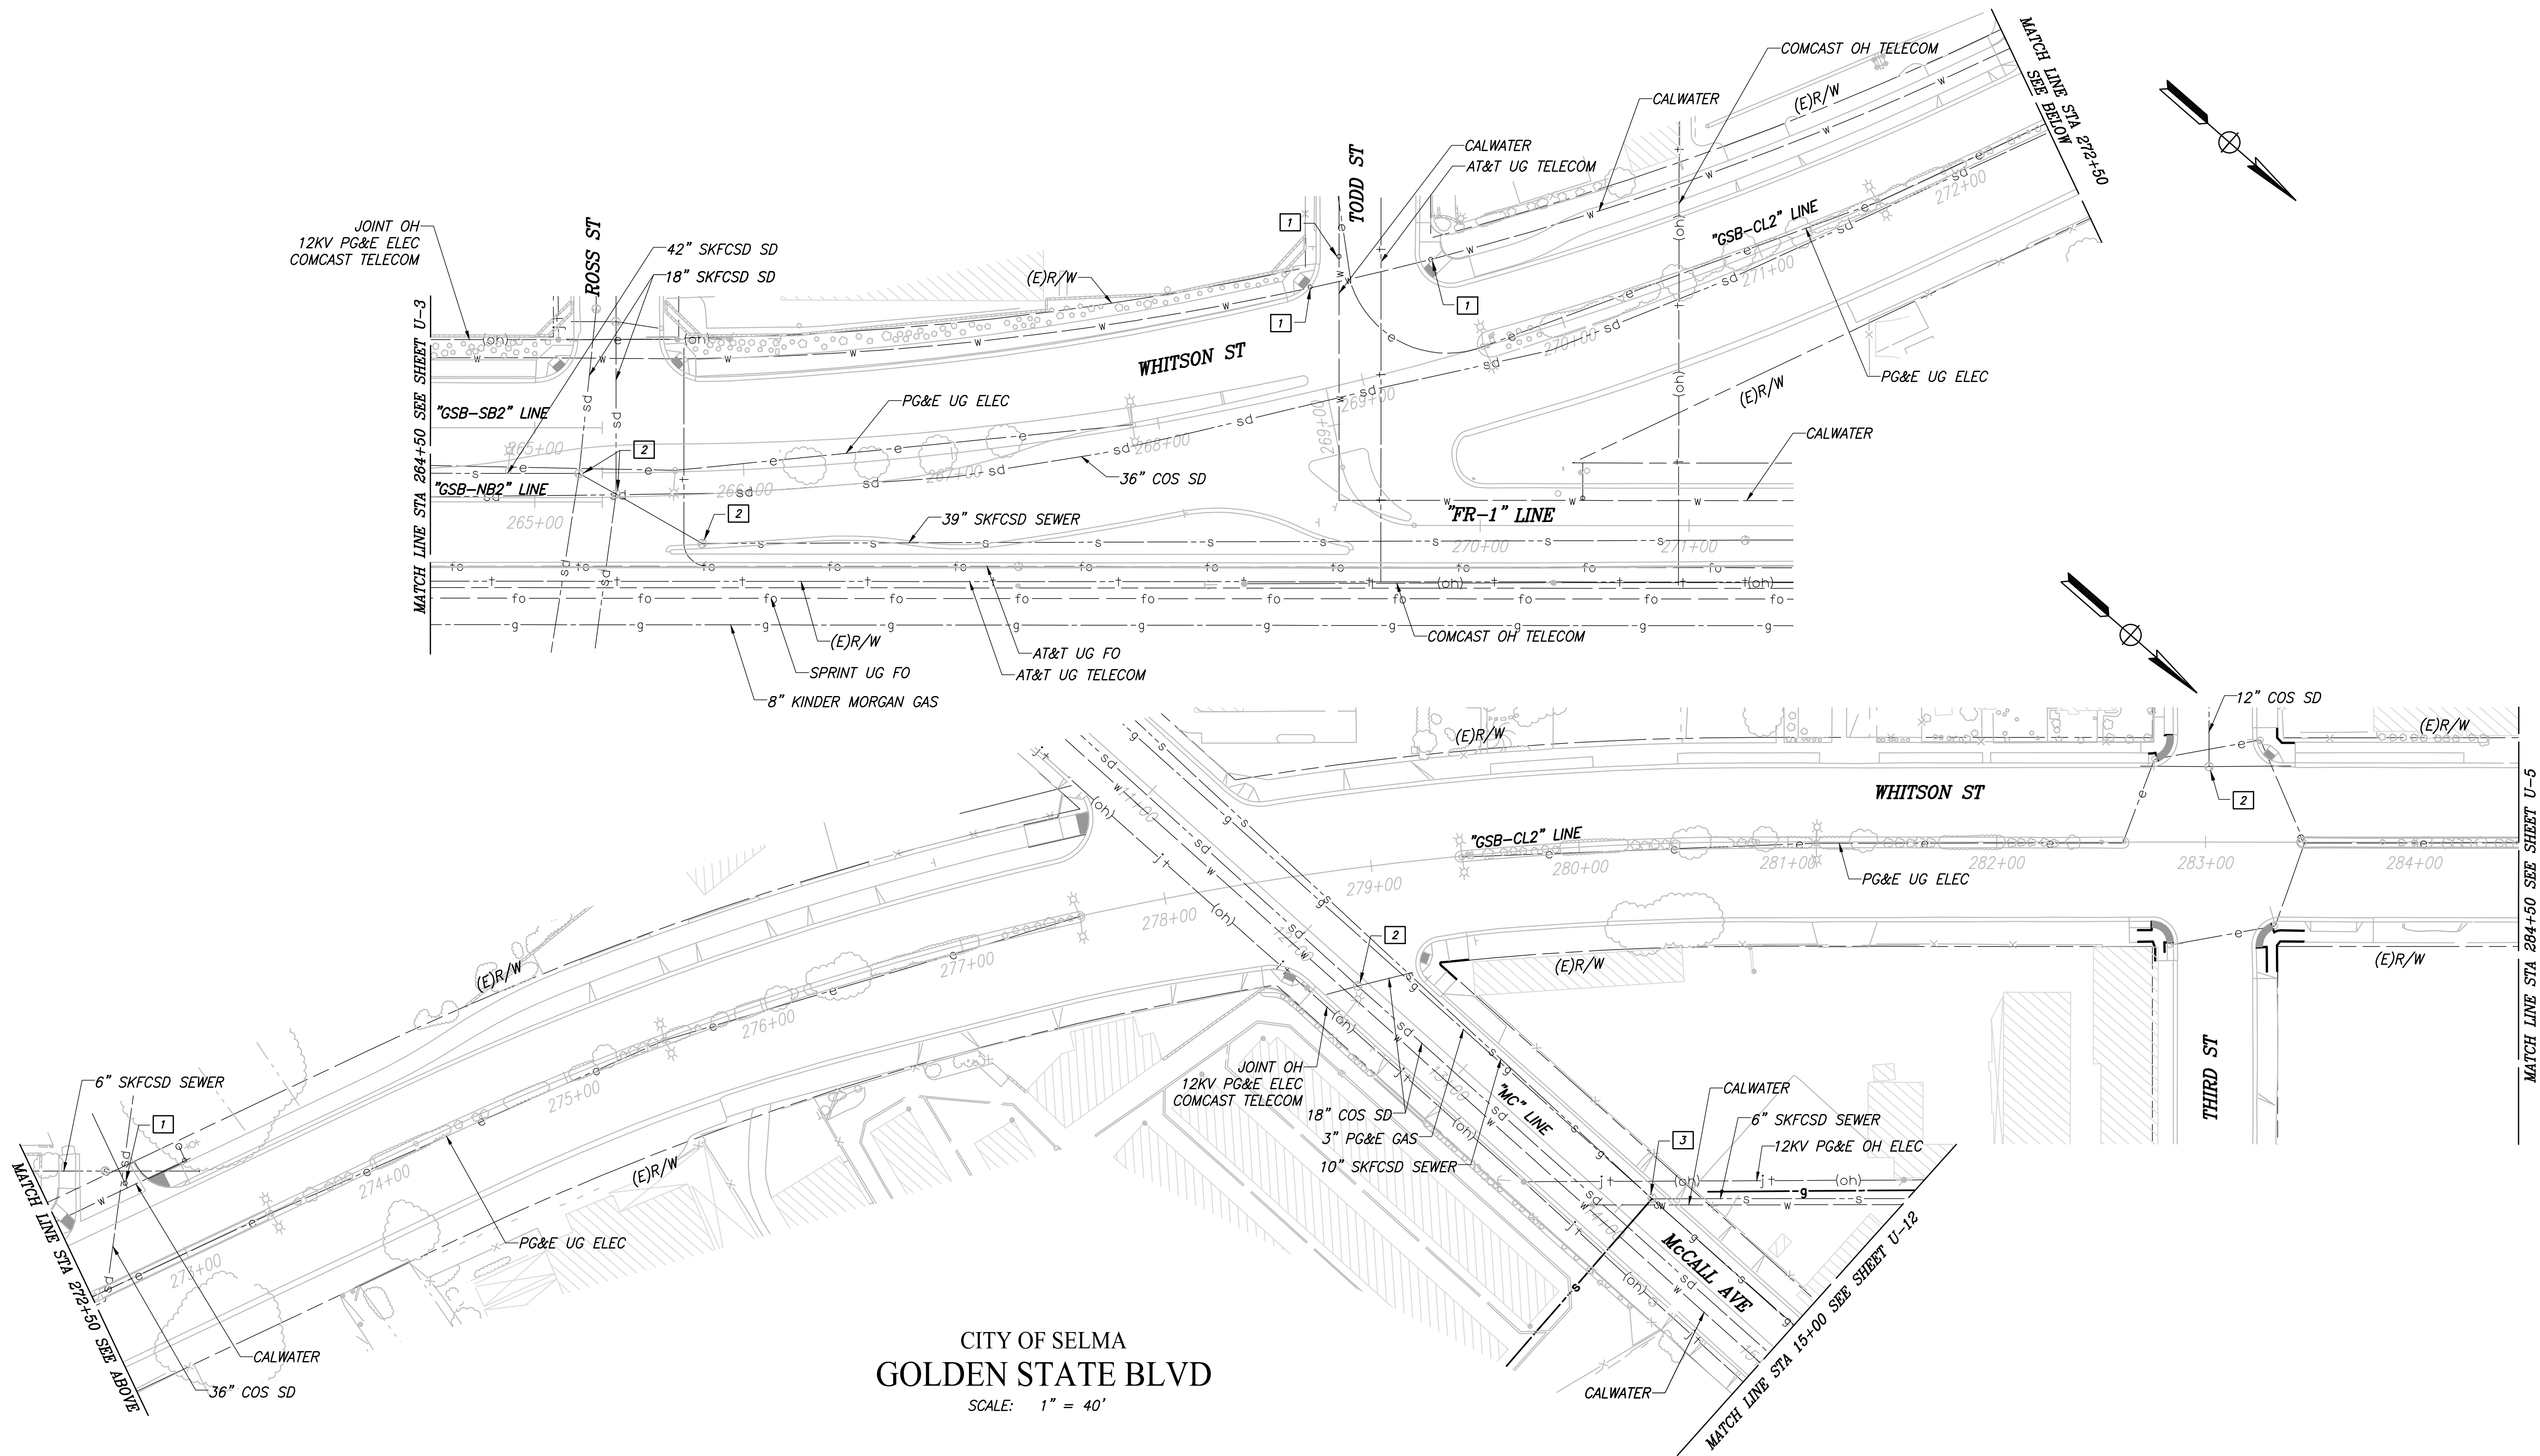


CITY OF SELMA
GOLDEN STATE BLVD
SCALE: 1" = 40'

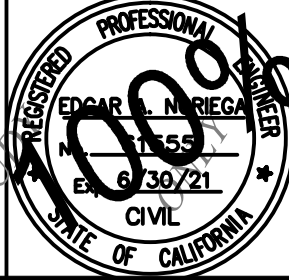
DESIGNED: CYNTHIA HORNER		DATE	RECORD DRAWING	
DRAWN: DILLON ALAMEDA		3/12/2021	RESIDENT ENGINEER	DATE
CHECKED: JAMES POLFER		3/12/2021		
FOR RIGHT OF WAY DATA AND ACCURATE ACCESS DETERMINATION, SEE DOCUMENTS IN THE DEPARTMENT OF PUBLIC WORKS AND PLANNING.				
				
CALL BEFORE YOU DIG		SUPERVISING ENGINEER		DATE
PROJECT		GOLDEN STATE CORRIDOR - ECONOMIC DEVELOPMENT AND INFRASTRUCTURE IMPROVEMENTS		
SELMA REGION				
DEPARTMENT OF PUBLIC WORKS AND PLANNING		UTILITY PLAN		
DRAWING NO. U-4		SHEET NO. 82		TOTAL 154

PLOT DATE: 3/12/2021 11:47:02 AM CAD USER: THARDY

PATH: J:\Fresno COG-FN-16105-GSB Final Design\CADD\Sheets\Region 2 - Selma\GSB_R2_U1-U7.dwg

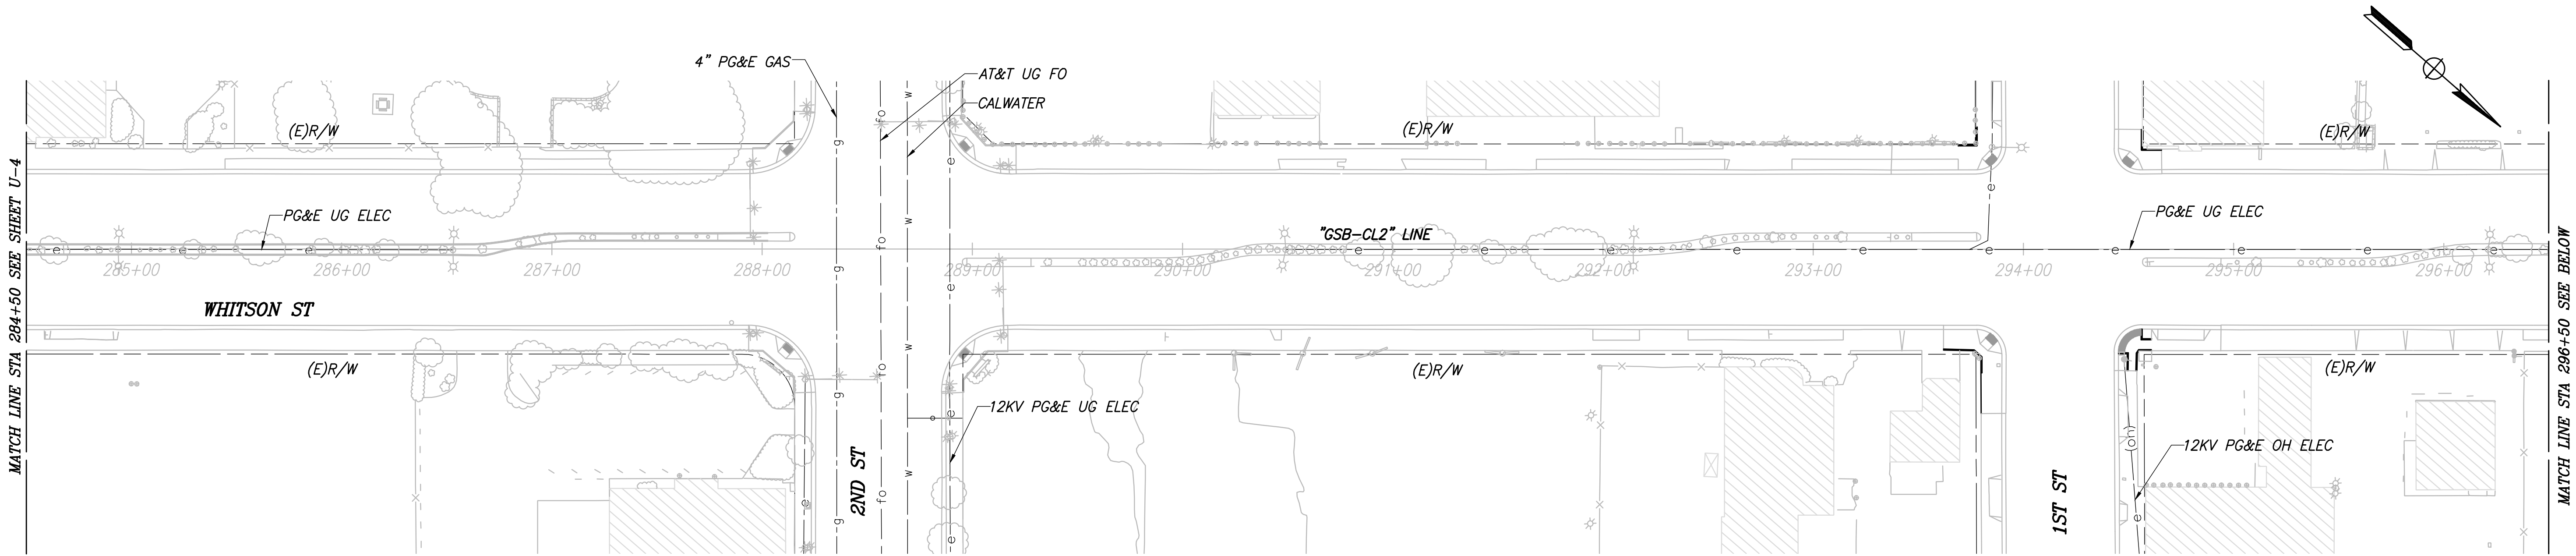


CITY OF SELMA
WHITSON ST
SCALE: 1" = 40'

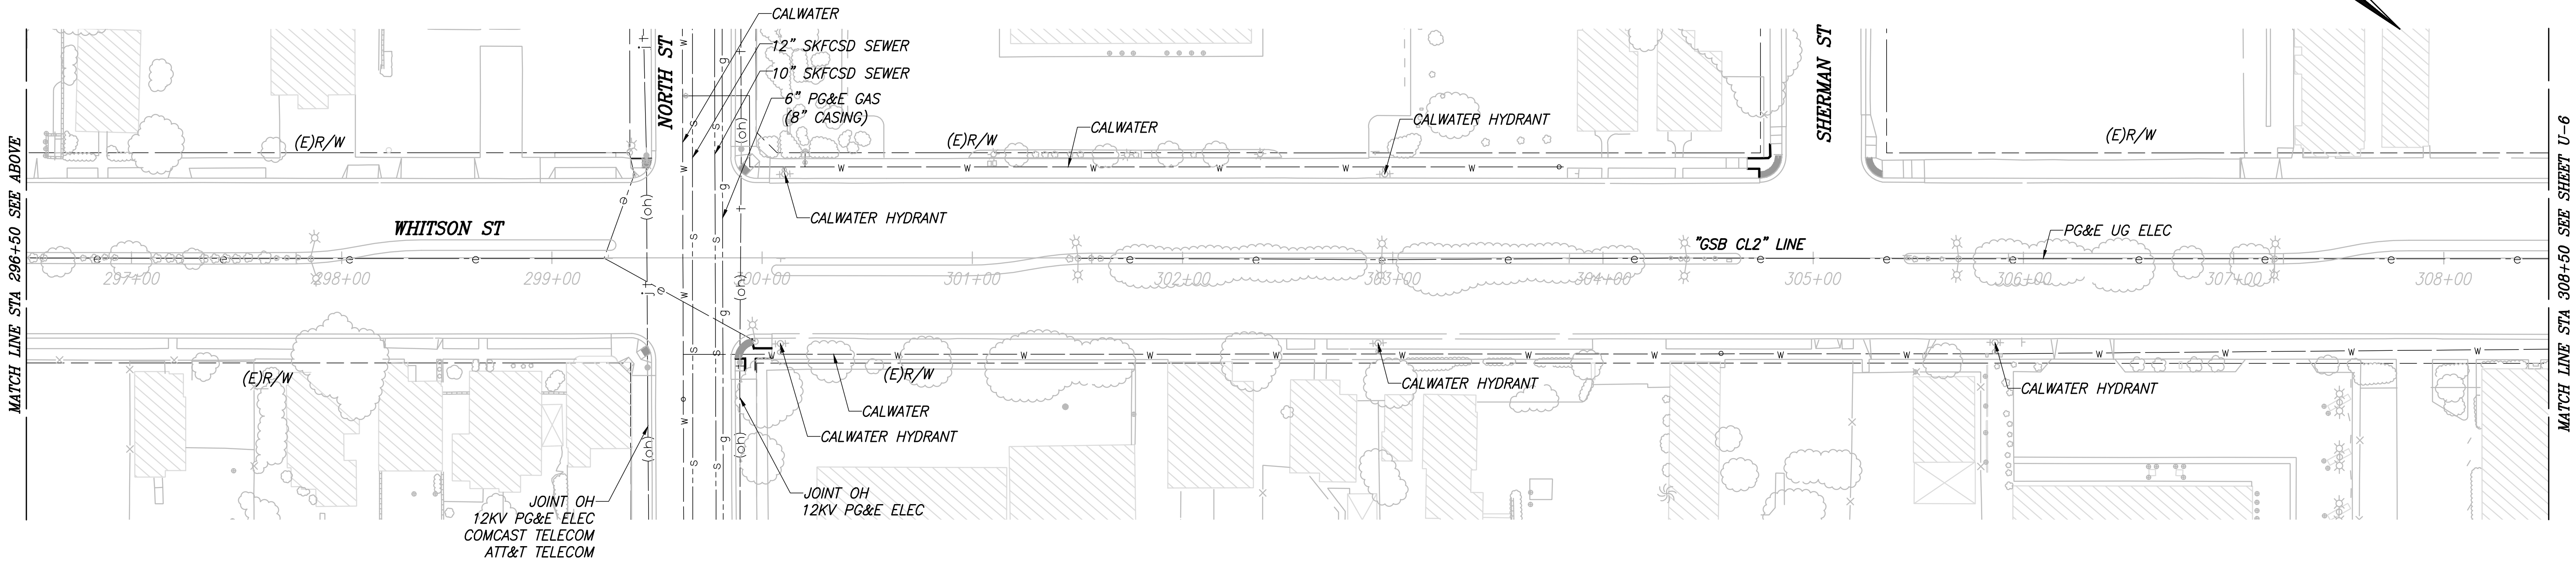

RECORD DRAWING	
DESIGNED: CYNTHIA HORNER	DATE: 3/12/2021
DRAWN: DILLON ALAMEDA	DATE: 3/12/2021
CHECKED: JAMES POLFER	DATE: 3/12/2021


FOR RIGHT OF WAY DATA AND ACCURATE ACCESS DETERMINATION, SEE DOCUMENTS IN THE DEPARTMENT OF PUBLIC WORKS AND PLANNING.

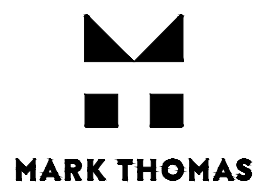

TENTATIVE PLANS FOR DESIGN
SUPERVISING ENGINEER
DATE



PROJECT
GOLDEN STATE CORRIDOR - ECONOMIC DEVELOPMENT
AND INFRASTRUCTURE IMPROVEMENTS
SELMA REGION

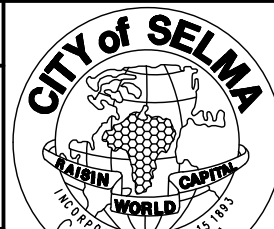


DEPARTMENT OF PUBLIC WORKS AND PLANNING
UTILITY PLAN


DRAWING NO. U-5 SHEET NO. 83 TOTAL 154

PLOT DATE: 3/12/2021 11:47:20 AM CAD USER: THARDY

PATH: J:\Fresno COG-FN-16105-GSB Final Design\CADD\Sheets\Region 2 - Selma\GSB_R2_U1-U7.dwg

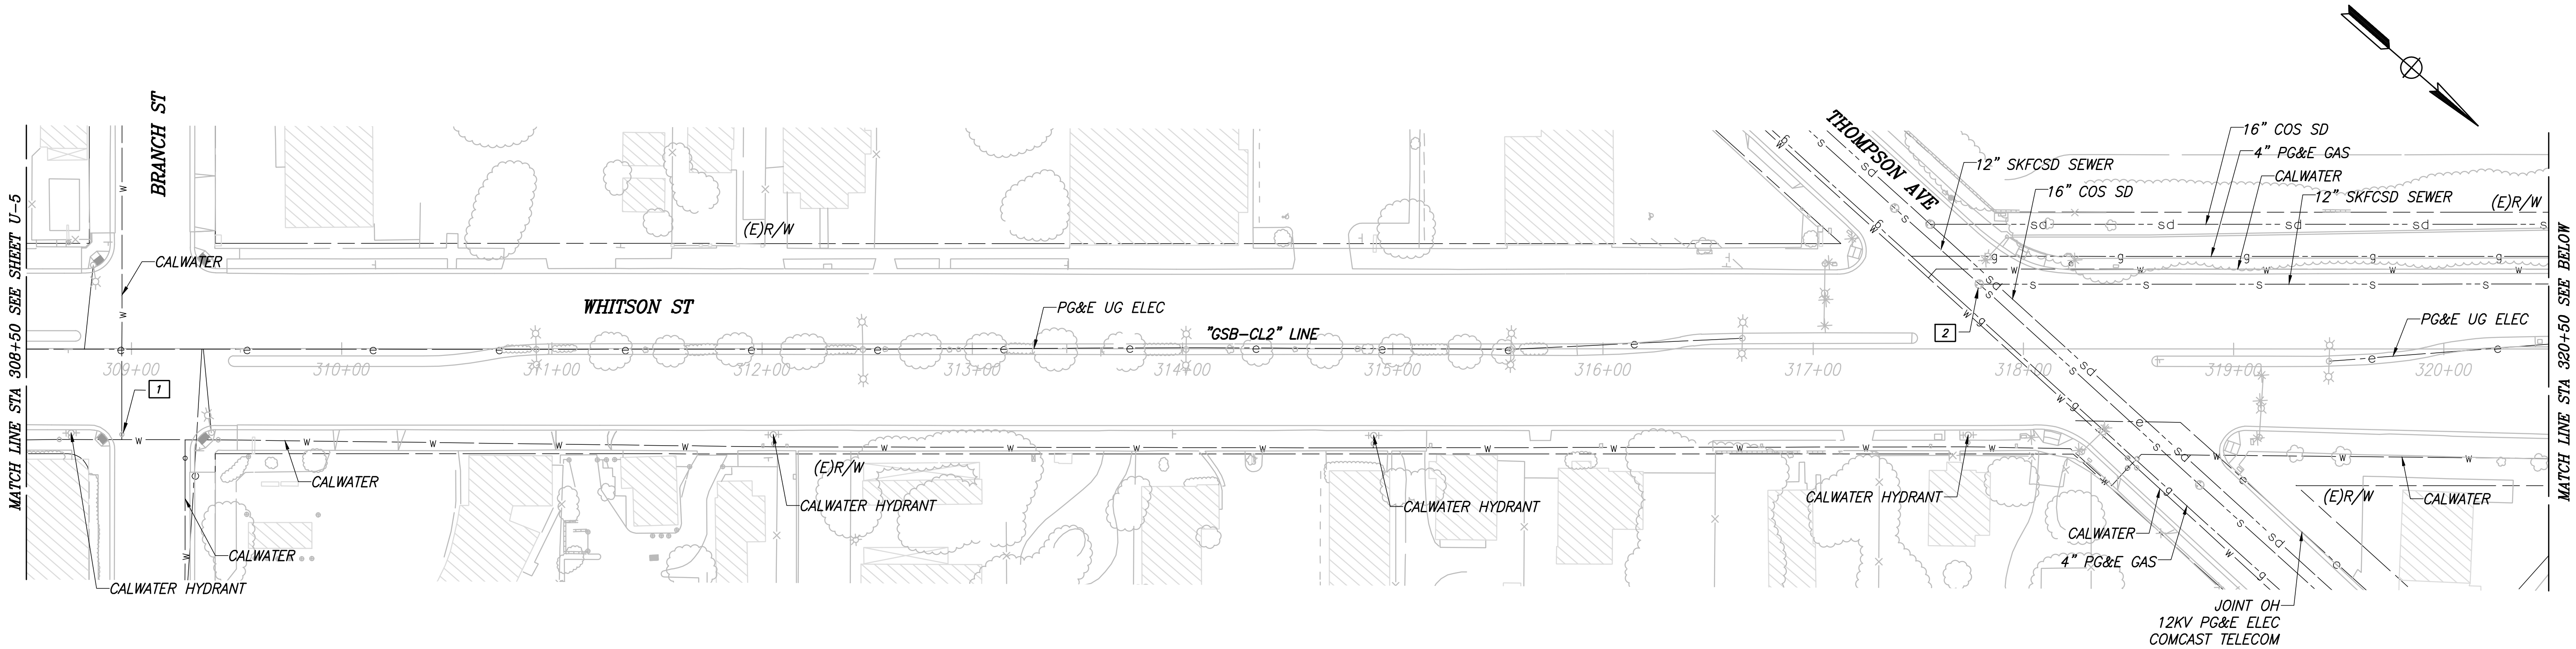


CITY OF SELMA
WHITSON ST
SCALE: 1" = 40'

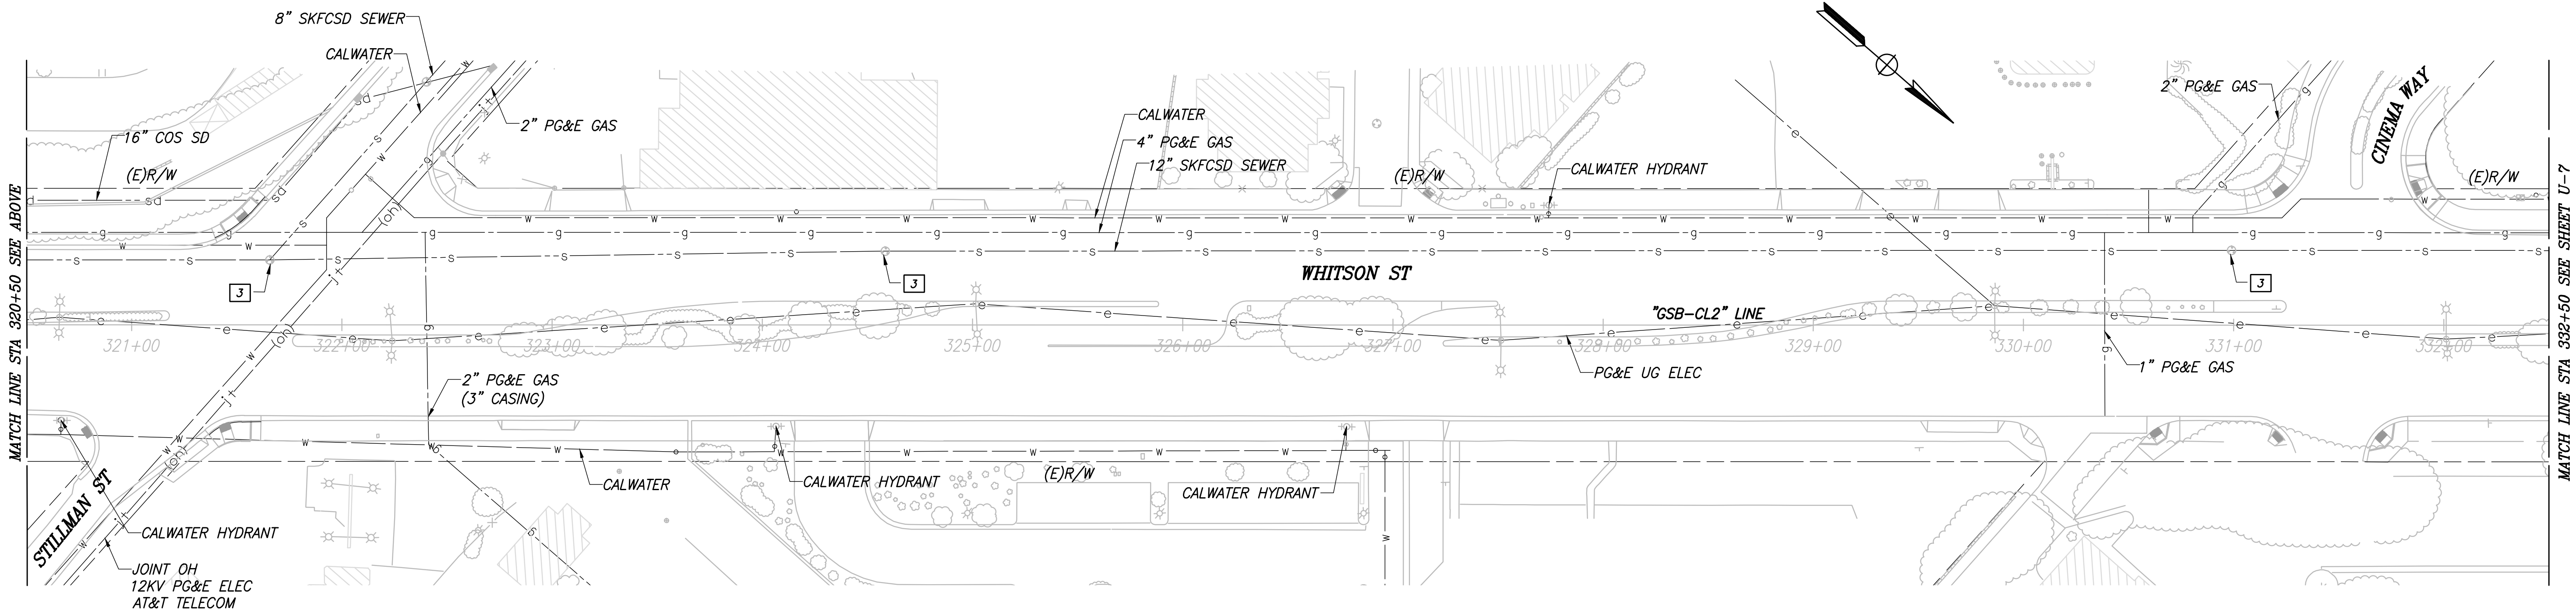

RECORD DRAWING	
DESIGNED: CYNTHIA HORNER	DATE: 3/12/2021
DRAWN: DILLON ALAMEDA	DATE: 3/12/2021
CHECKED: JAMES POLFER	DATE: 3/12/2021


FOR RIGHT OF WAY DATA AND ACCURATE ACCESS DETERMINATION, SEE DOCUMENTS IN THE DEPARTMENT OF PUBLIC WORKS AND PLANNING.

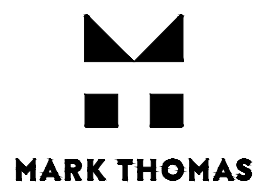

TENTATIVE
PLANS
FOR
DESIGN
DATE: 3/30/21
SUPERVISING ENGINEER




PROJECT
GOLDEN STATE CORRIDOR - ECONOMIC DEVELOPMENT
AND INFRASTRUCTURE IMPROVEMENTS
SELMA REGION

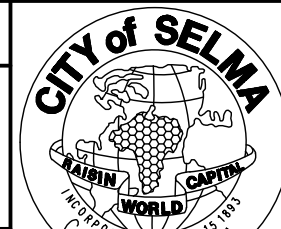

DEPARTMENT OF PUBLIC WORKS AND PLANNING
UTILITY PLAN

DRAWING NO. U-6 SHEET NO. 84 TOTAL 154

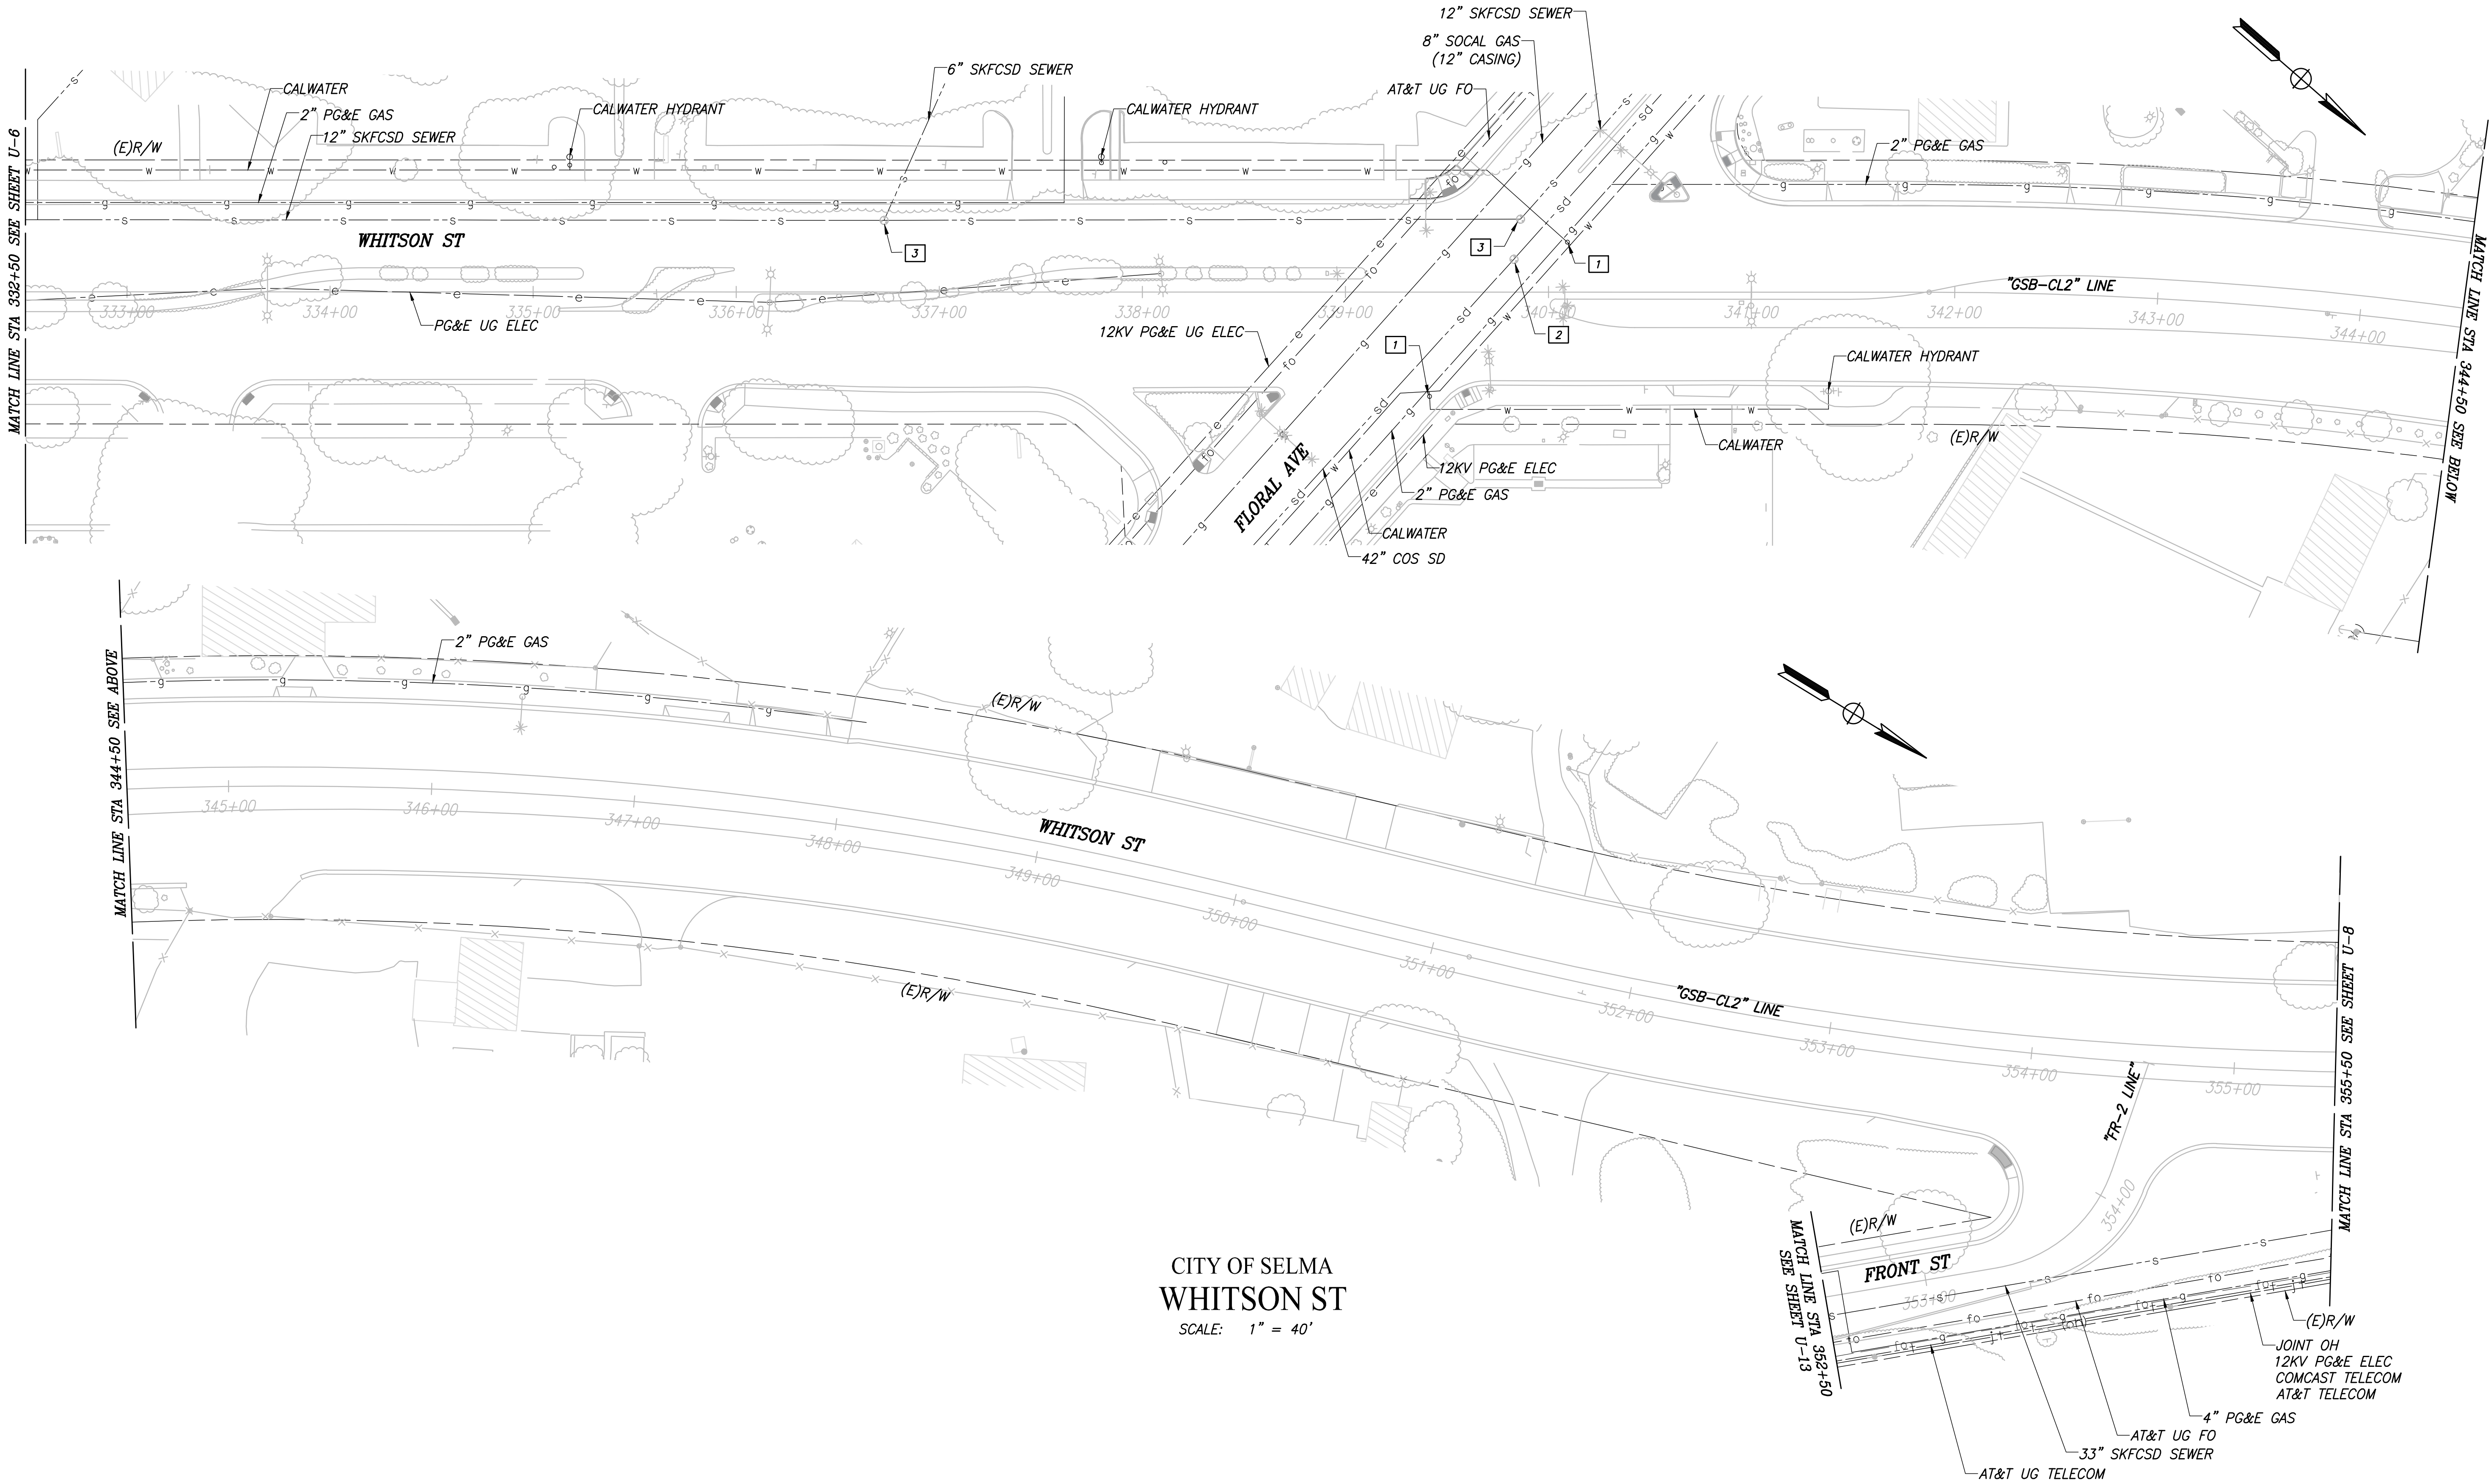

CITY OF SELMA
WHITSON ST
SCALE: 1" = 40'

RECORD DRAWING	
DESIGNED: CYNTHIA HORNER	DATE: 3/12/2021
DRAWN: DILLON ALAMEDA	DATE: 3/12/2021
CHECKED: JAMES POLFER	DATE: 3/12/2021


FOR RIGHT OF WAY DATA AND ACCURATE ACCESS DETERMINATION, SEE DOCUMENTS IN THE DEPARTMENT OF PUBLIC WORKS AND PLANNING.





TENTATIVE PLANS FOR DESIGN	DATE: 3/30/21
SUPERVISING ENGINEER	DATE: 3/30/21




PROJECT
GOLDEN STATE CORRIDOR - ECONOMIC DEVELOPMENT AND INFRASTRUCTURE IMPROVEMENTS
SELMA REGION

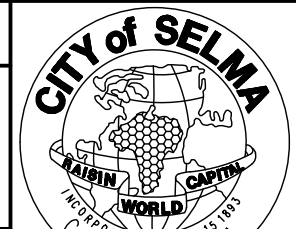


DEPARTMENT OF PUBLIC WORKS AND PLANNING		
UTILITY PLAN		
DRAWING NO. U-7	SHEET NO. 85	TOTAL 154

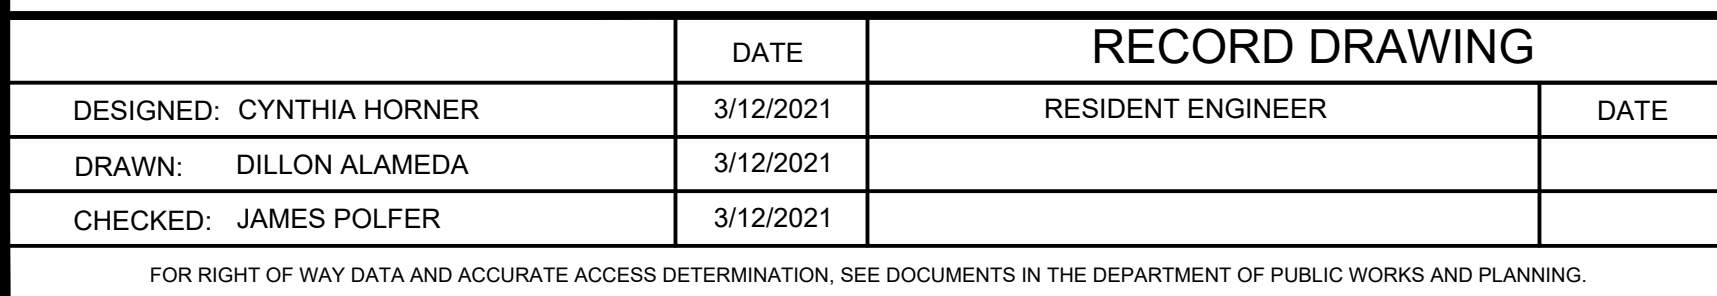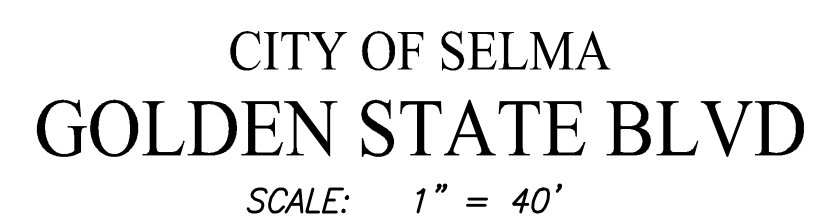

SUPERVISING ENGINEER

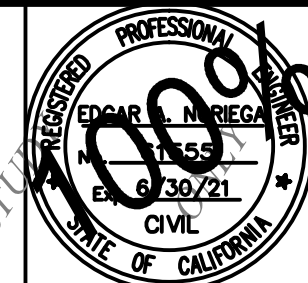


PROJECT
GOLDEN STATE CORRIDOR - ECONOMIC DEVELOPMENT AND INFRASTRUCTURE IMPROVEMENTS
SELMA REGION

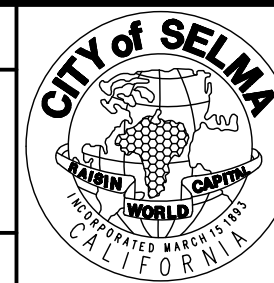


DEPARTMENT OF PUBLIC WORKS AND PLANNING			
UTILITY PLAN			
DRAWING NO. U-8	SHEET NO. 86	TOTAL	154

PLOT DATE: 3/12/2021 11:48:50 AM CAD USER: ECHIN

PATH: J:\Fresno COG-FN-16105-GSB Final Design\CADD\Sheets\Region 2 - Selma\GSB_R2_U8-U13.dwg

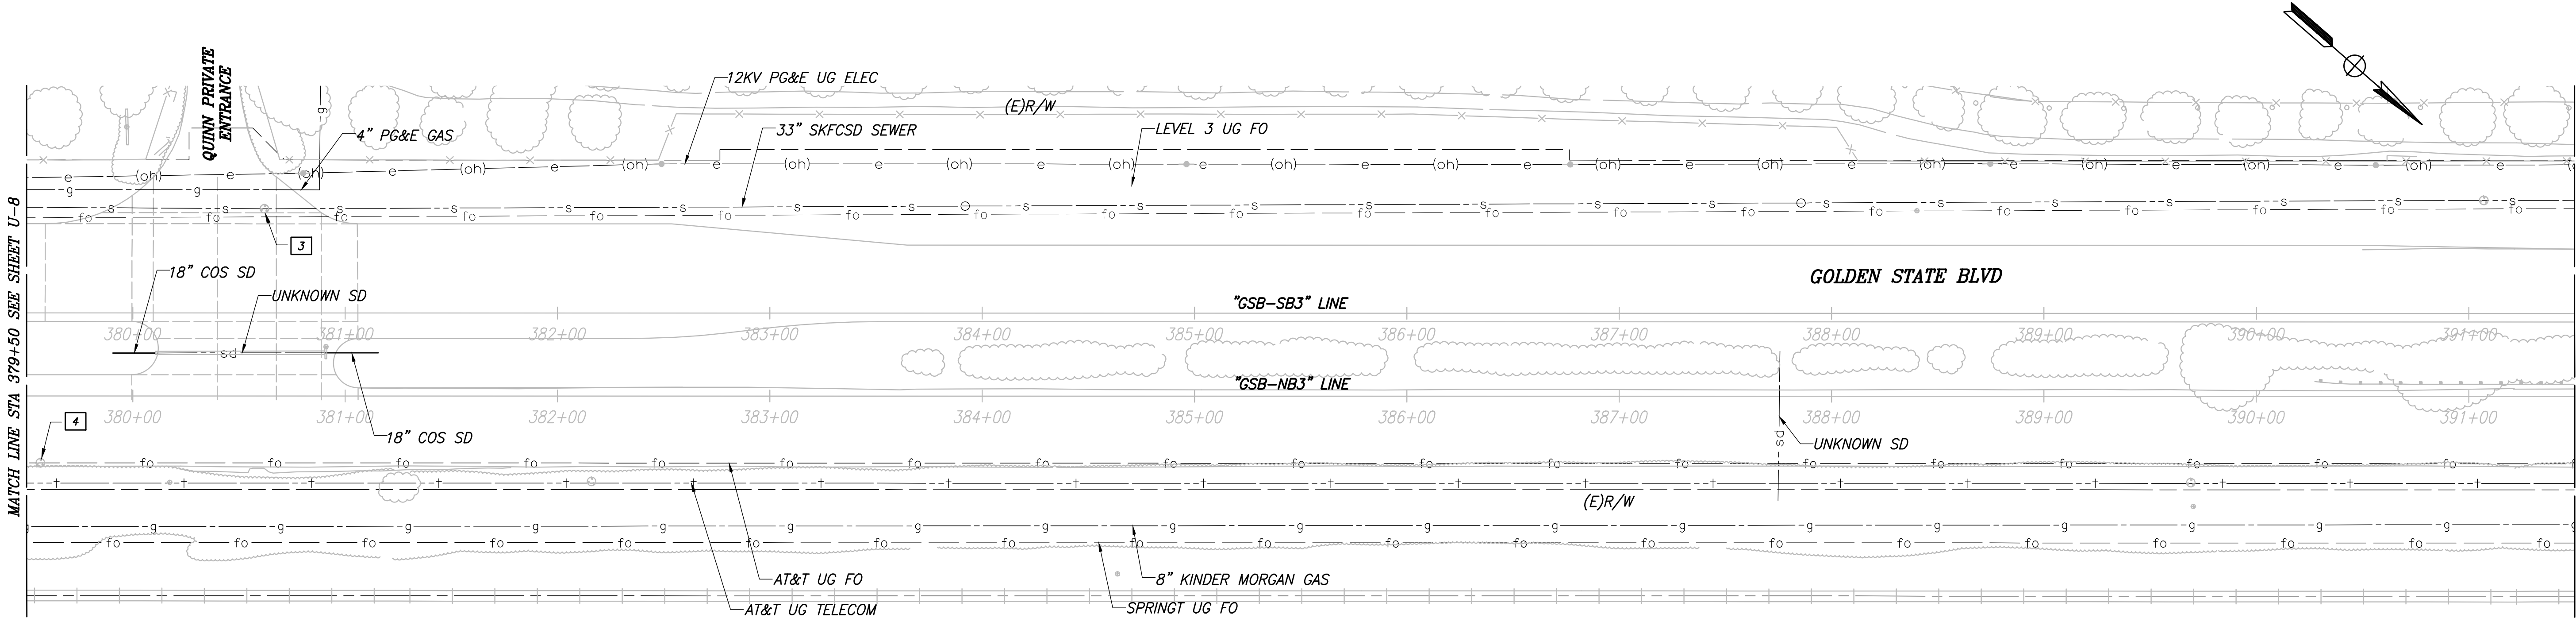


CITY OF SELMA
GOLDEN STATE BLVD
SCALE: 1" = 40'

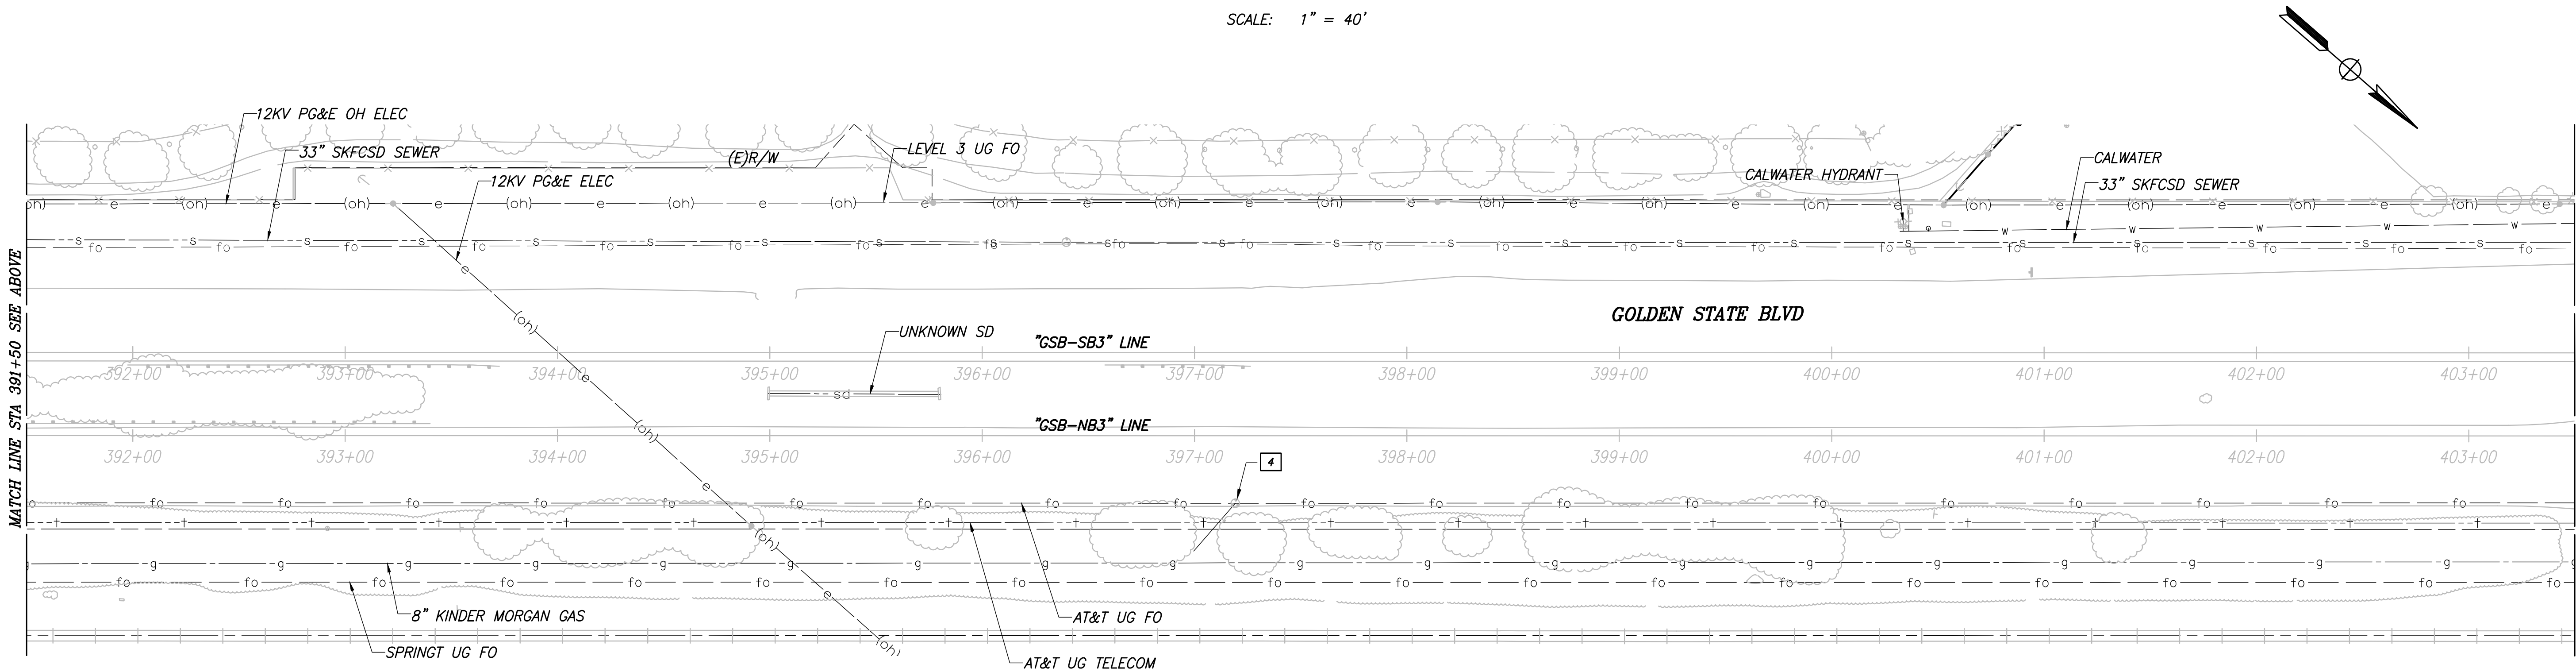

RECORD DRAWING		
DESIGNED: CYNTHIA HORNER	DATE: 3/12/2021	RESIDENT ENGINEER
DRAWN: DILLON ALAMEDA	DATE: 3/12/2021	
CHECKED: JAMES POLFER	DATE: 3/12/2021	


FOR RIGHT OF WAY DATA AND ACCURATE ACCESS DETERMINATION, SEE DOCUMENTS IN THE DEPARTMENT OF PUBLIC WORKS AND PLANNING.

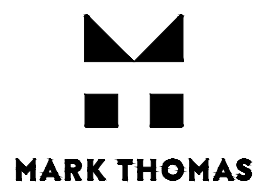

TENTATIVE PLANS FOR DESIGN
SUPERVISING ENGINEER
DATE



PROJECT
GOLDEN STATE CORRIDOR - ECONOMIC DEVELOPMENT AND INFRASTRUCTURE IMPROVEMENTS
SELMA REGION

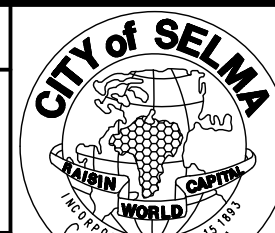


DEPARTMENT OF PUBLIC WORKS AND PLANNING
UTILITY PLAN


DRAWING NO. U-9 SHEET NO. 87 TOTAL 154

PLOT DATE: 3/12/2021 11:49:08 AM CAD USER: ECHIN

PATH: J:\Fresno COG-FN-16105-GSB Final Design\CADD\Sheets\Region 2 - Selma\GSB-R2-U8-U13.dwg

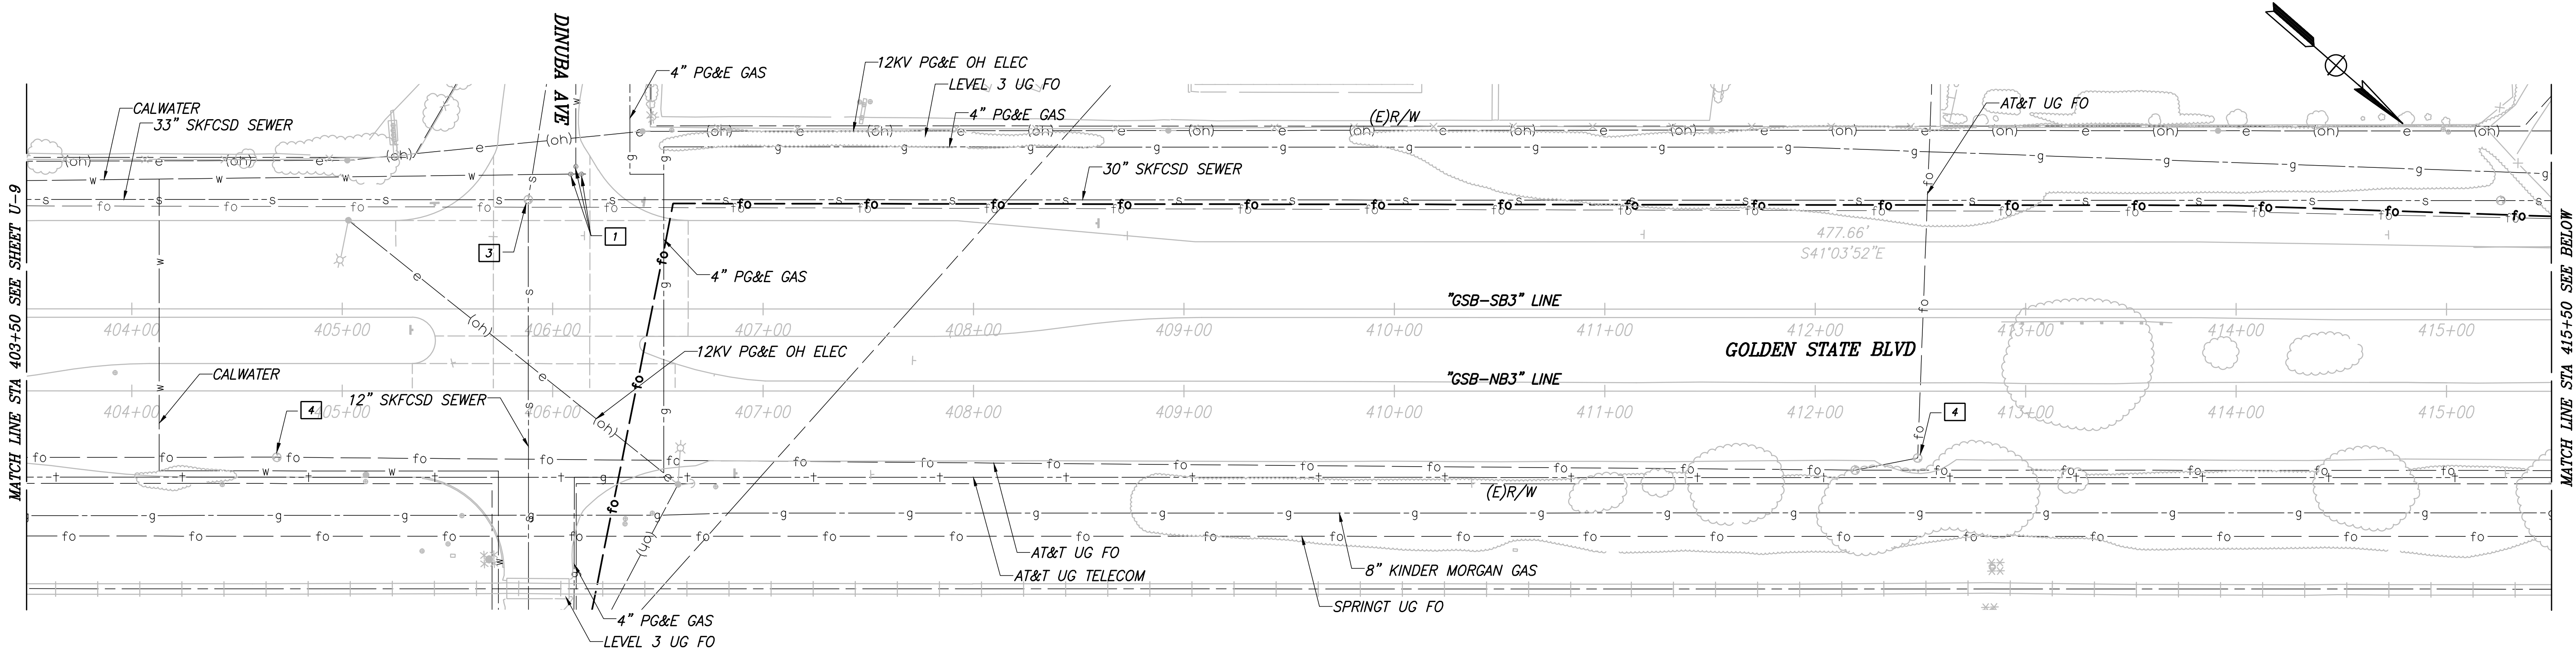

CITY OF SELMA
GOLDEN STATE BLVD
SCALE: 1" = 40'

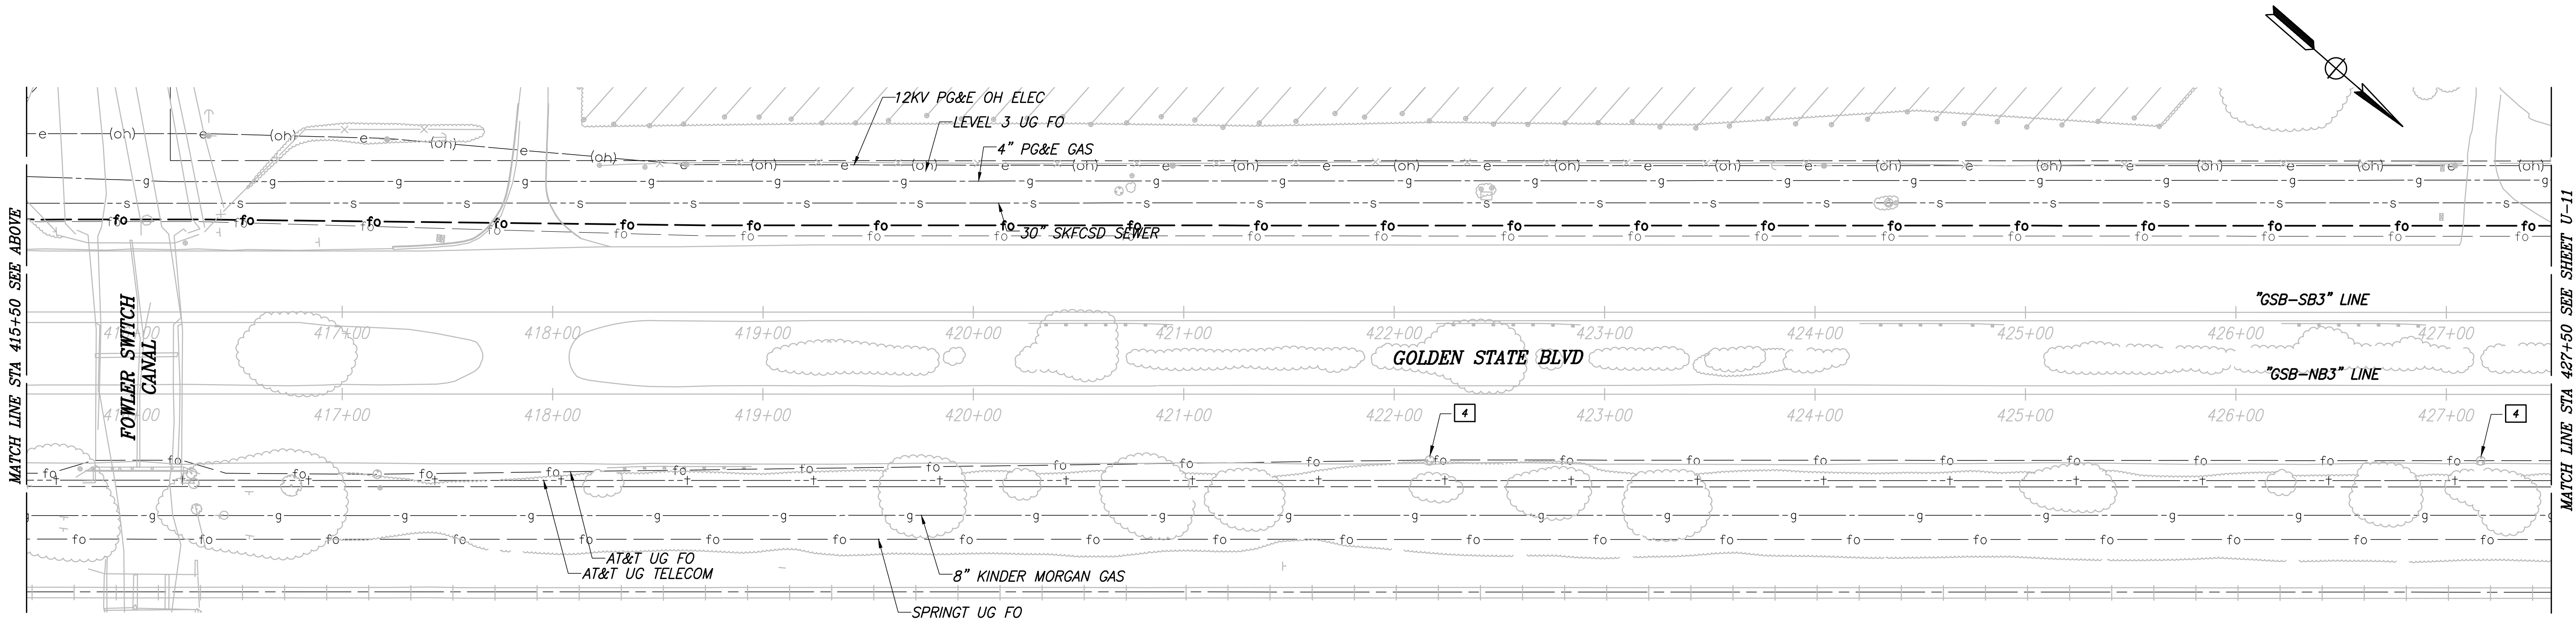

RECORD DRAWING	
DESIGNED: CYNTHIA HORNER	DATE: 3/12/2021
DRAWN: DILLON ALAMEDA	DATE: 3/12/2021
CHECKED: JAMES POLFER	DATE: 3/12/2021


FOR RIGHT OF WAY DATA AND ACCURATE ACCESS DETERMINATION, SEE DOCUMENTS IN THE DEPARTMENT OF PUBLIC WORKS AND PLANNING.




TENTATIVE PLANS FOR DESIGN	DATE
SUPERVISING ENGINEER	




PROJECT
GOLDEN STATE CORRIDOR - ECONOMIC DEVELOPMENT AND INFRASTRUCTURE IMPROVEMENTS
SELMA REGION

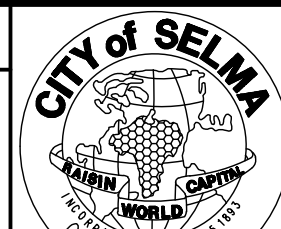

DEPARTMENT OF PUBLIC WORKS AND PLANNING		
UTILITY PLAN		
DRAWING NO. U-10	SHEET NO. 88	TOTAL 154

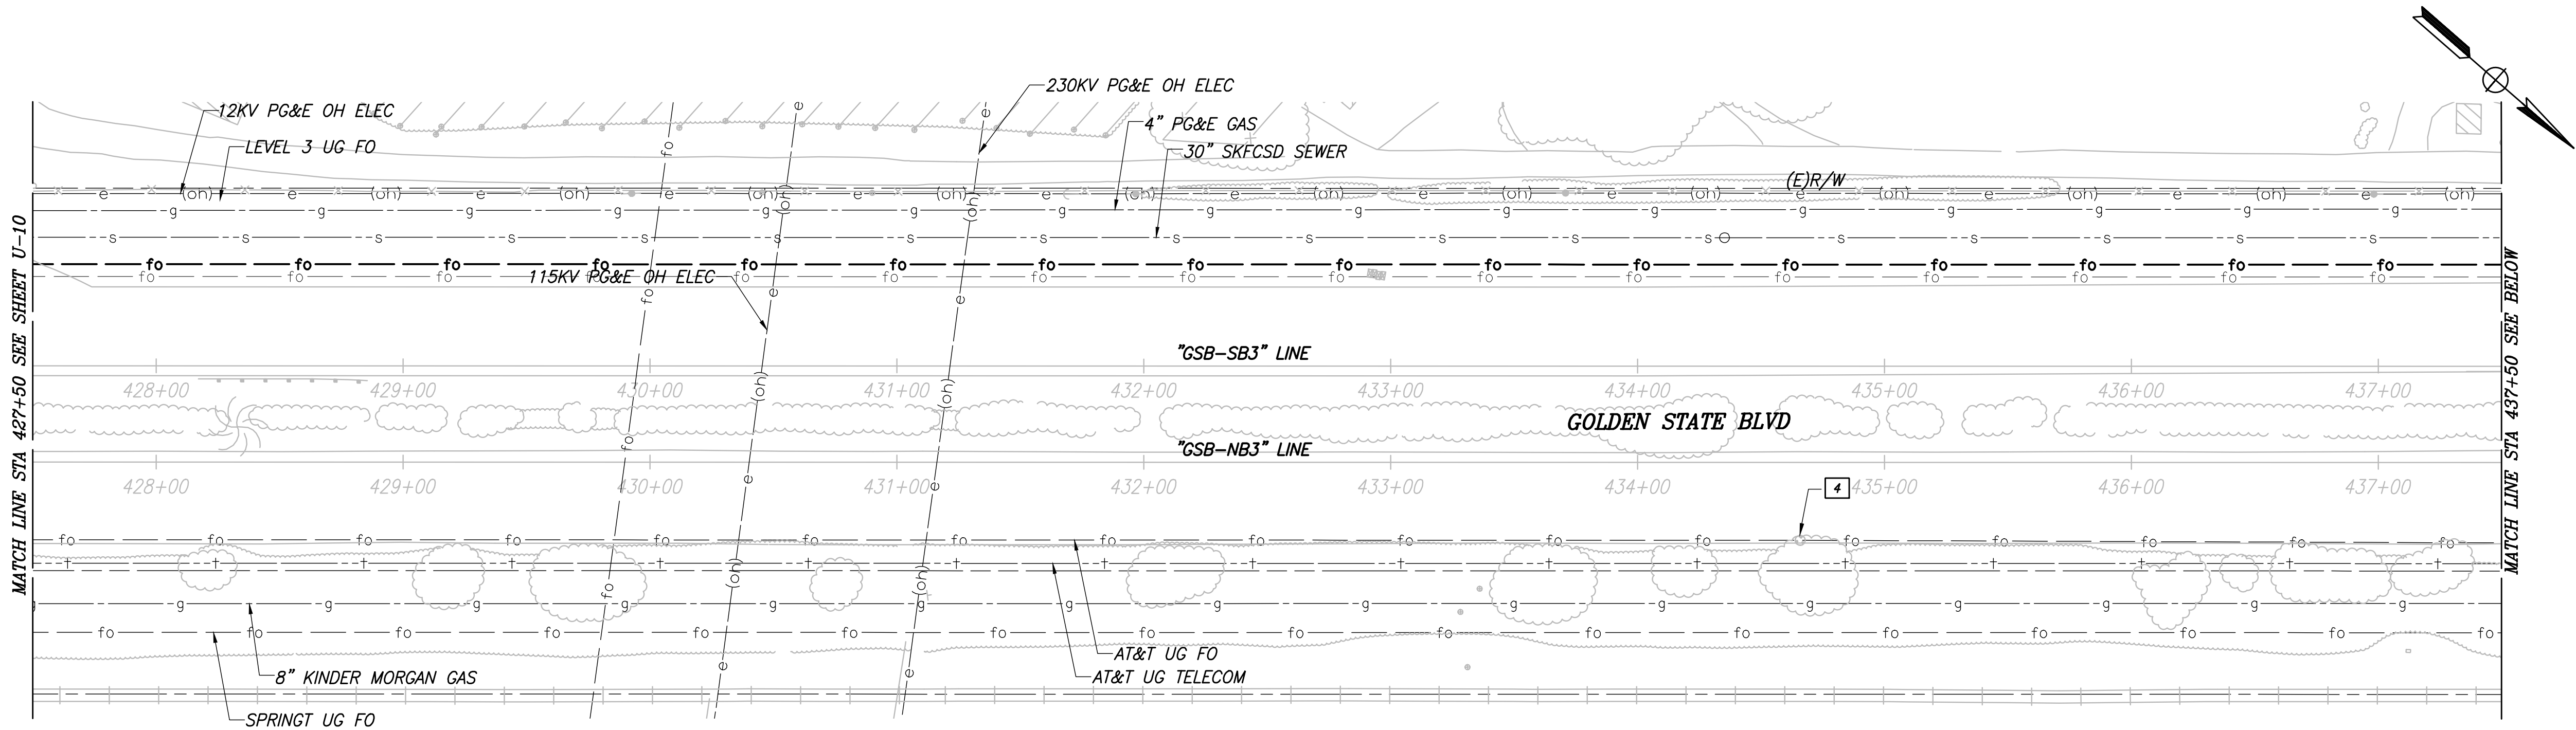

CITY OF SELMA
GOLDEN STATE BLVD
SCALE: 1" = 40'

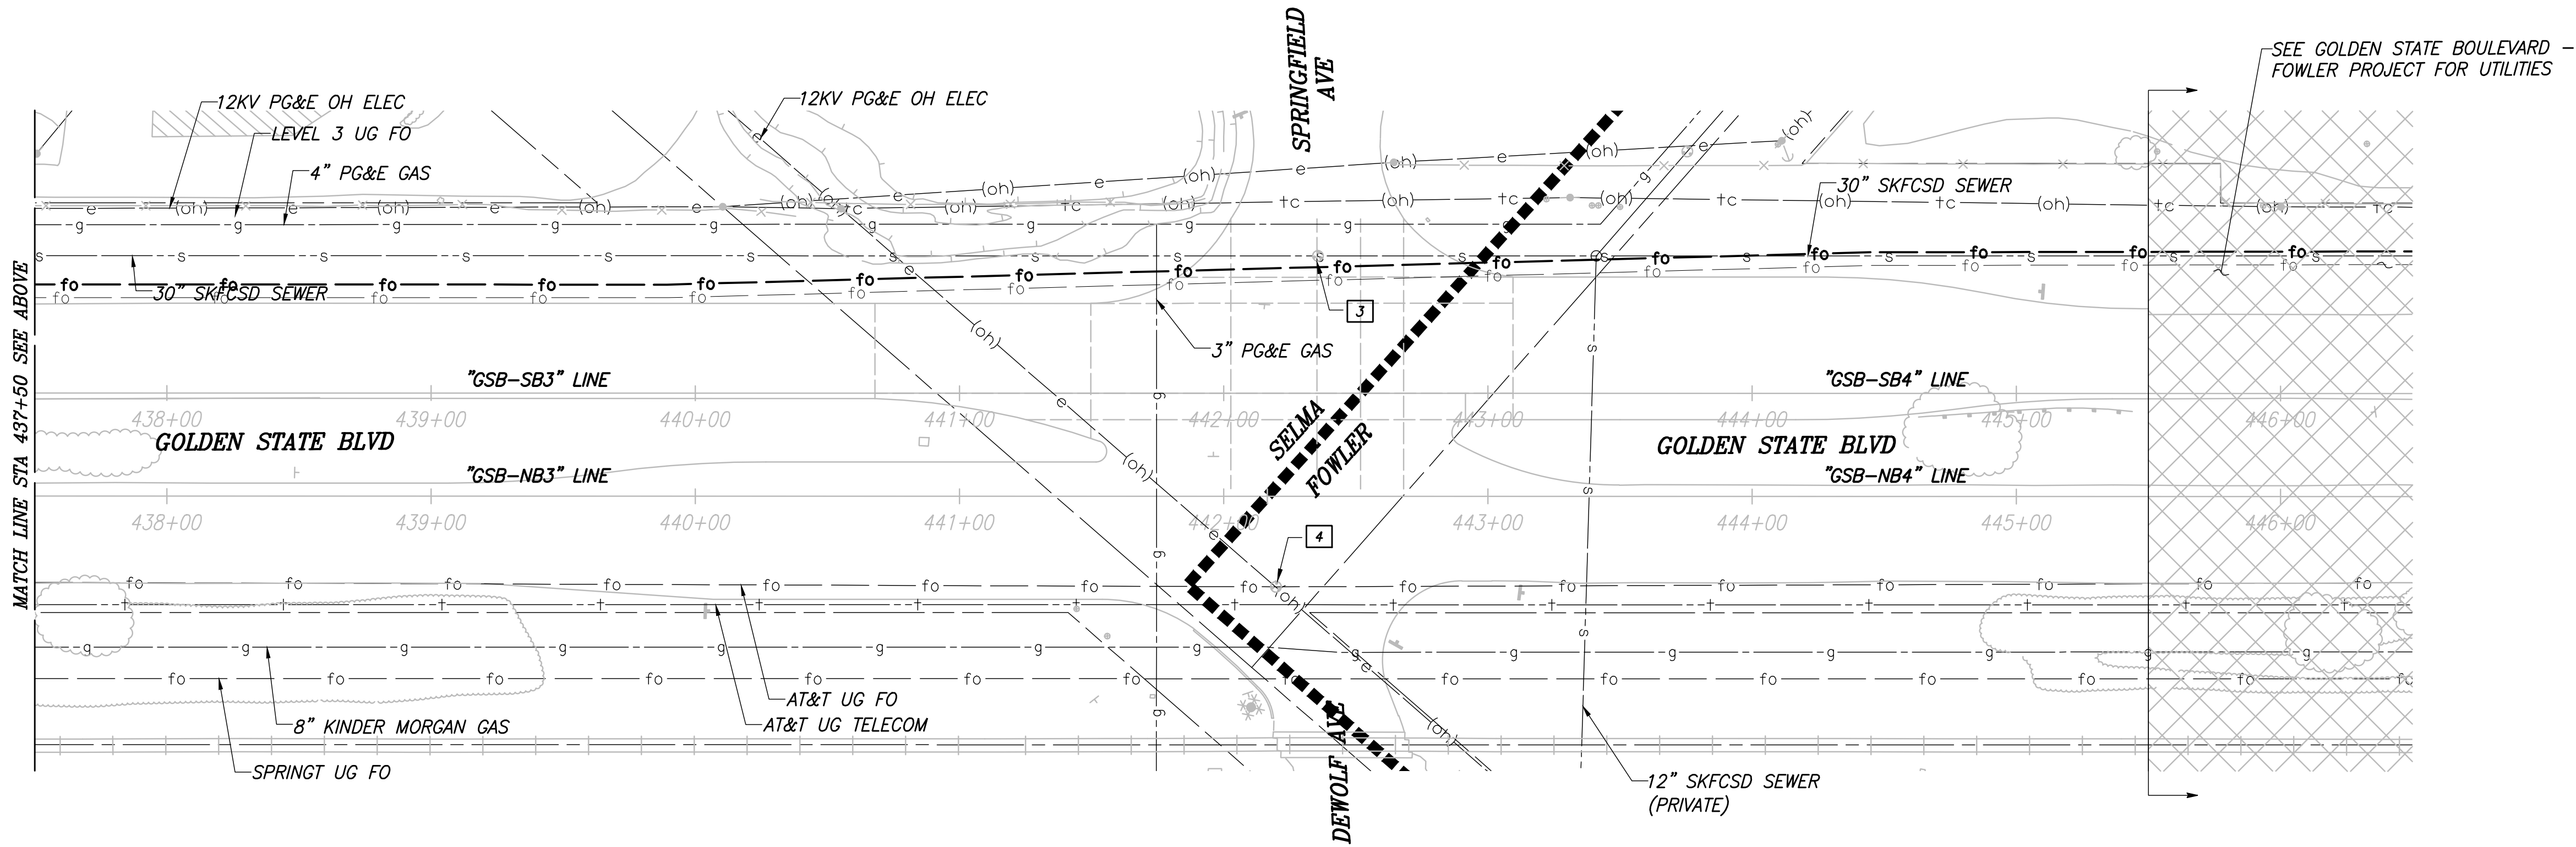

	DATE	RECORD DRAWING	
DESIGNED: CYNTHIA HORNER	3/12/2021	RESIDENT ENGINEER	DATE
DRAWN: DILLON ALAMEDA	3/12/2021		
CHECKED: JAMES POLFER	3/12/2021		


FOR RIGHT OF WAY DATA AND ACCURATE ACCESS DETERMINATION, SEE DOCUMENTS IN THE DEPARTMENT OF PUBLIC WORKS AND PLANNING.




TENTATIVE PLANS FOR DESIGN	
SUPERVISING ENGINEER	DATE



PROJECT
GOLDEN STATE CORRIDOR - ECONOMIC DEVELOPMENT AND INFRASTRUCTURE IMPROVEMENTS
SELMA REGION

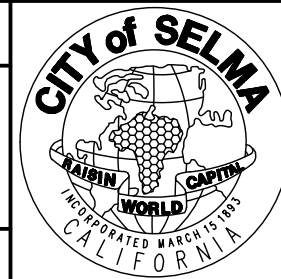


DEPARTMENT OF PUBLIC WORKS AND PLANNING		
UTILITY PLAN		
DRAWING NO. U-11	SHEET NO. 89	TOTAL 154

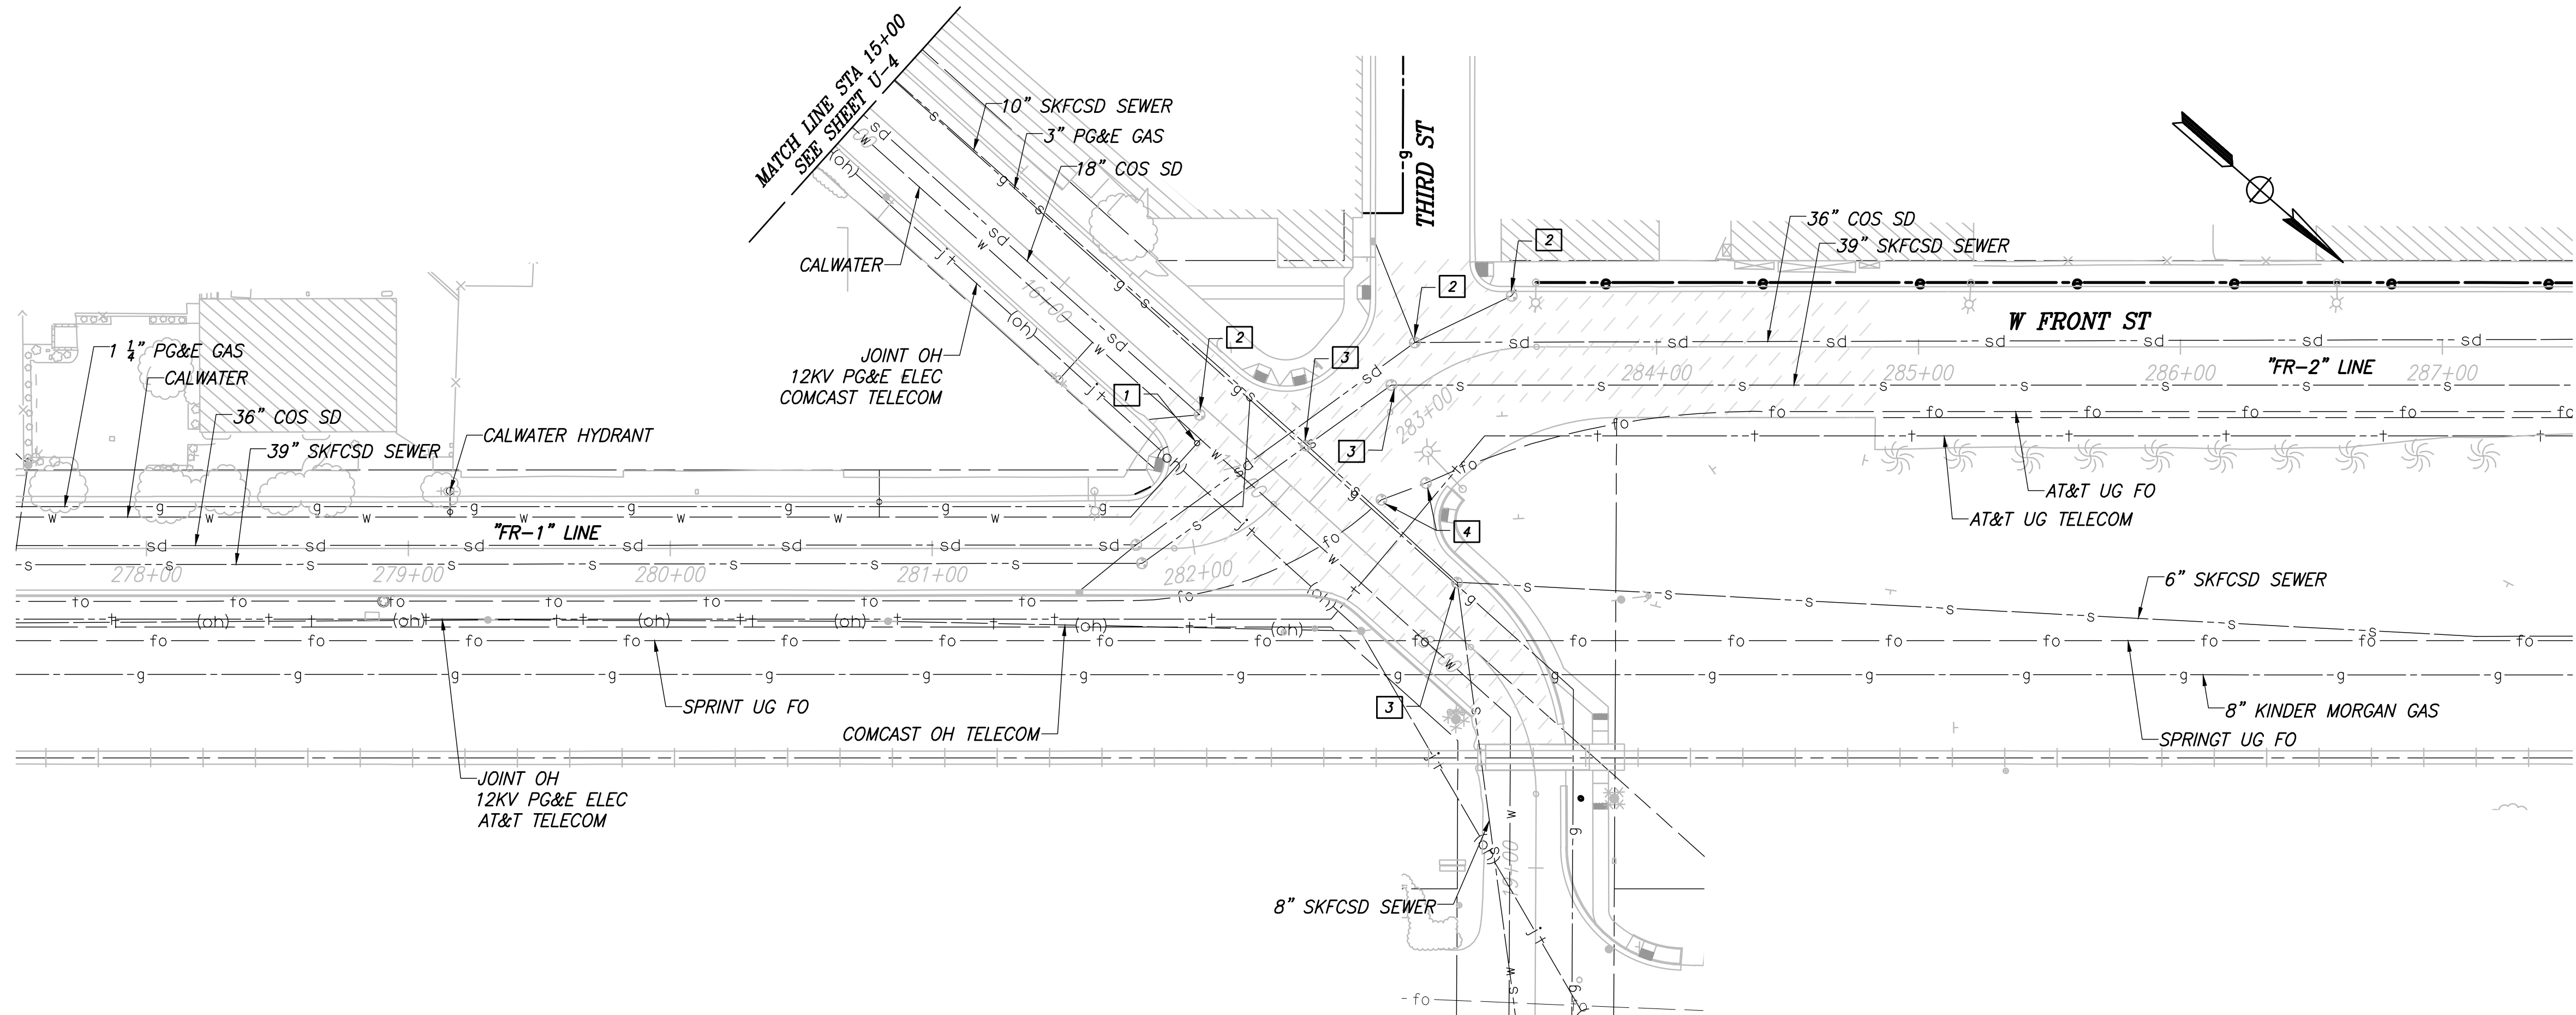


CITY OF SELMA
W FRONT ST

SCALE: 1" = 40'

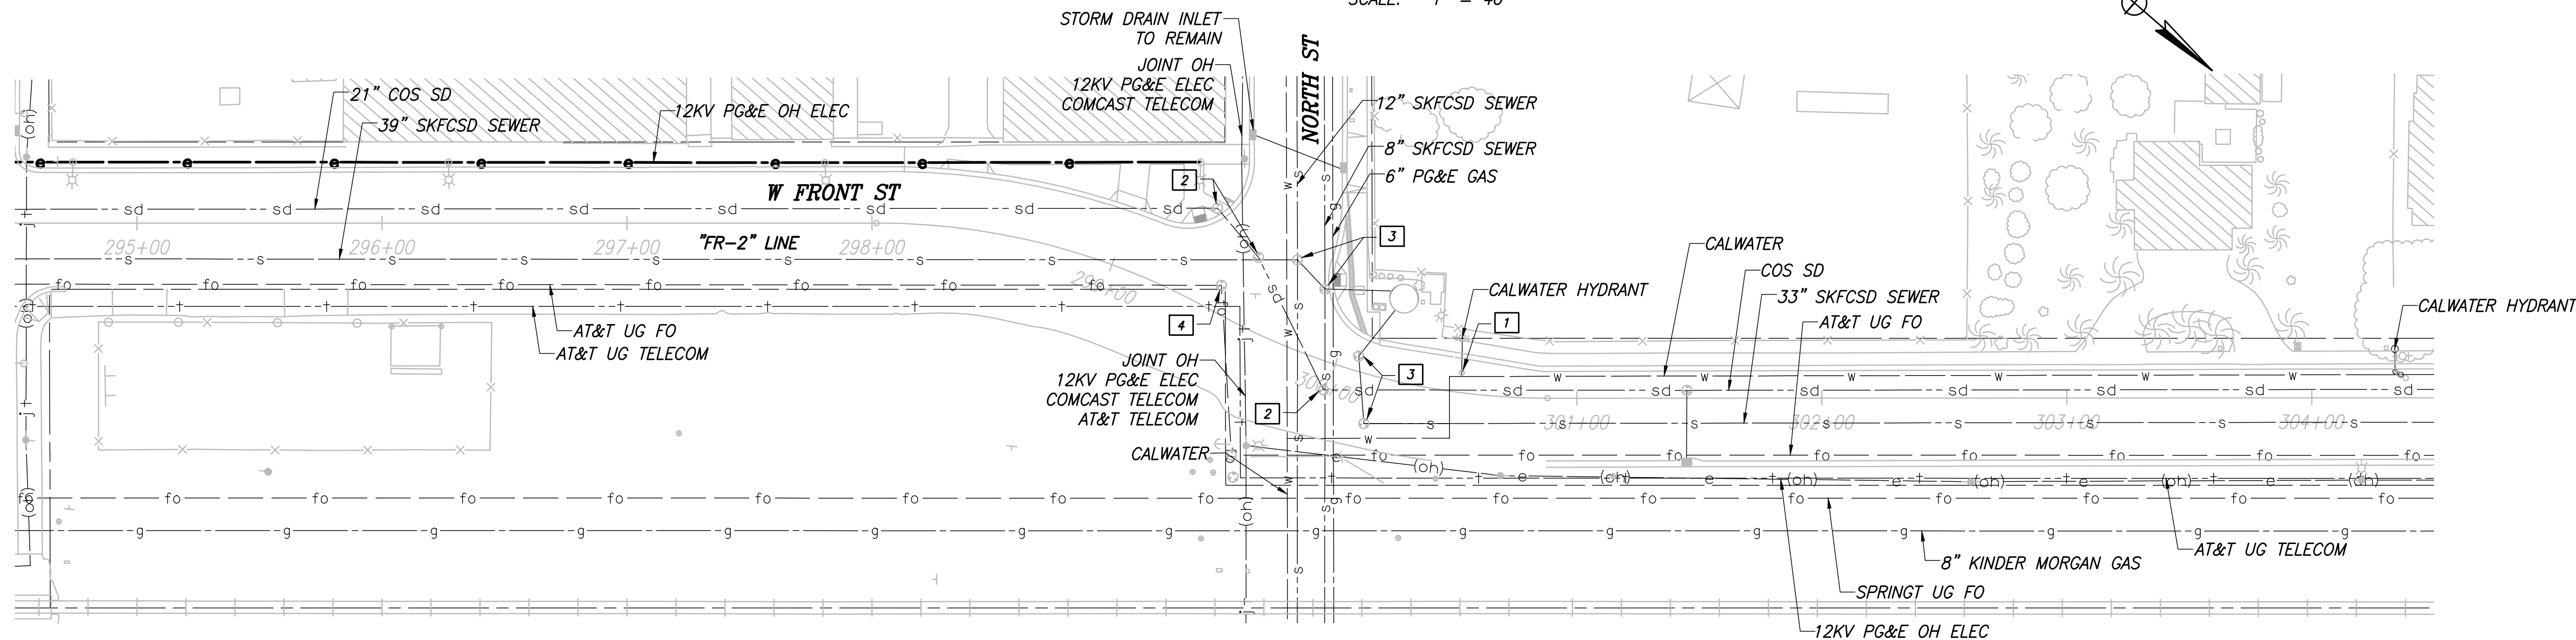

RECORD DRAWING	
DESIGNED: CYNTHIA HORNER	DATE: 3/12/2021
DRAWN: DILLON ALAMEDA	DATE: 3/12/2021
CHECKED: JAMES POLFER	DATE: 3/12/2021


FOR RIGHT OF WAY DATA AND ACCURATE ACCESS DETERMINATION, SEE DOCUMENTS IN THE DEPARTMENT OF PUBLIC WORKS AND PLANNING.

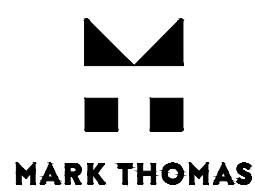


TENTATIVE PLANS FOR DESIGN	DATE
SUPERVISING ENGINEER	




PROJECT
GOLDEN STATE CORRIDOR - ECONOMIC DEVELOPMENT AND INFRASTRUCTURE IMPROVEMENTS
SELMA REGION


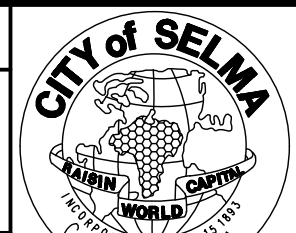


DEPARTMENT OF PUBLIC WORKS AND PLANNING		
UTILITY PLAN		
DRAWING NO. U-12	SHEET NO. 90	TOTAL 154

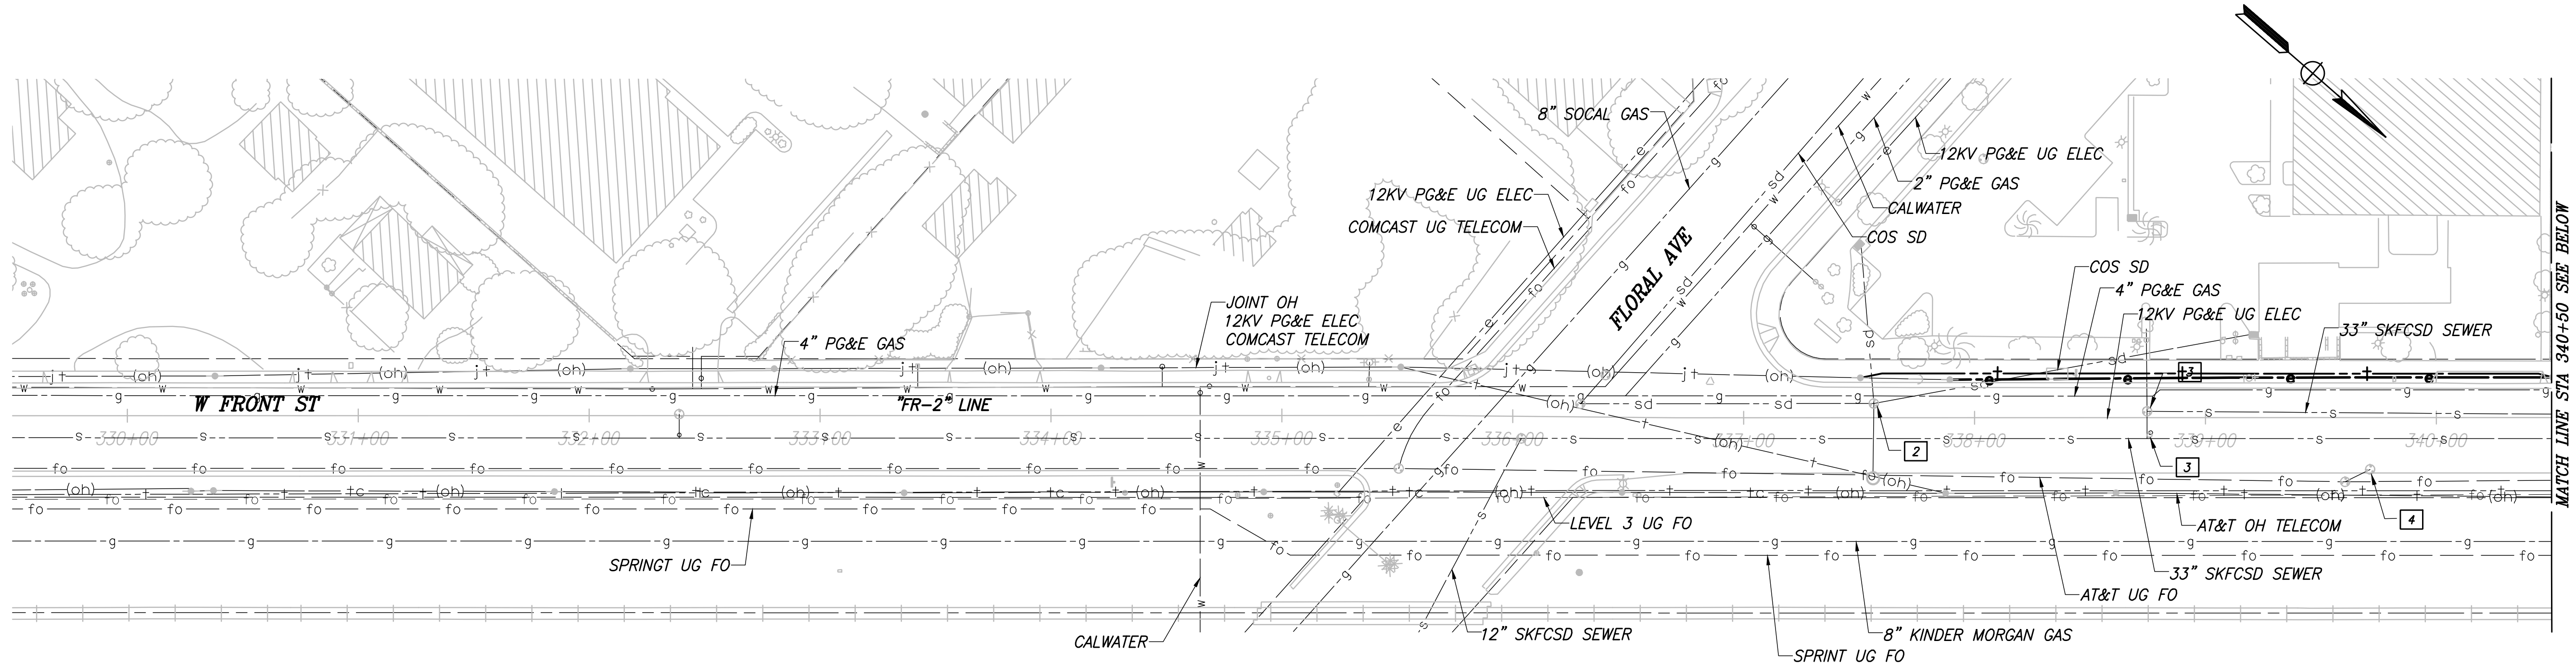

CITY OF SELMA
W FRONT ST
SCALE: 1" = 40'

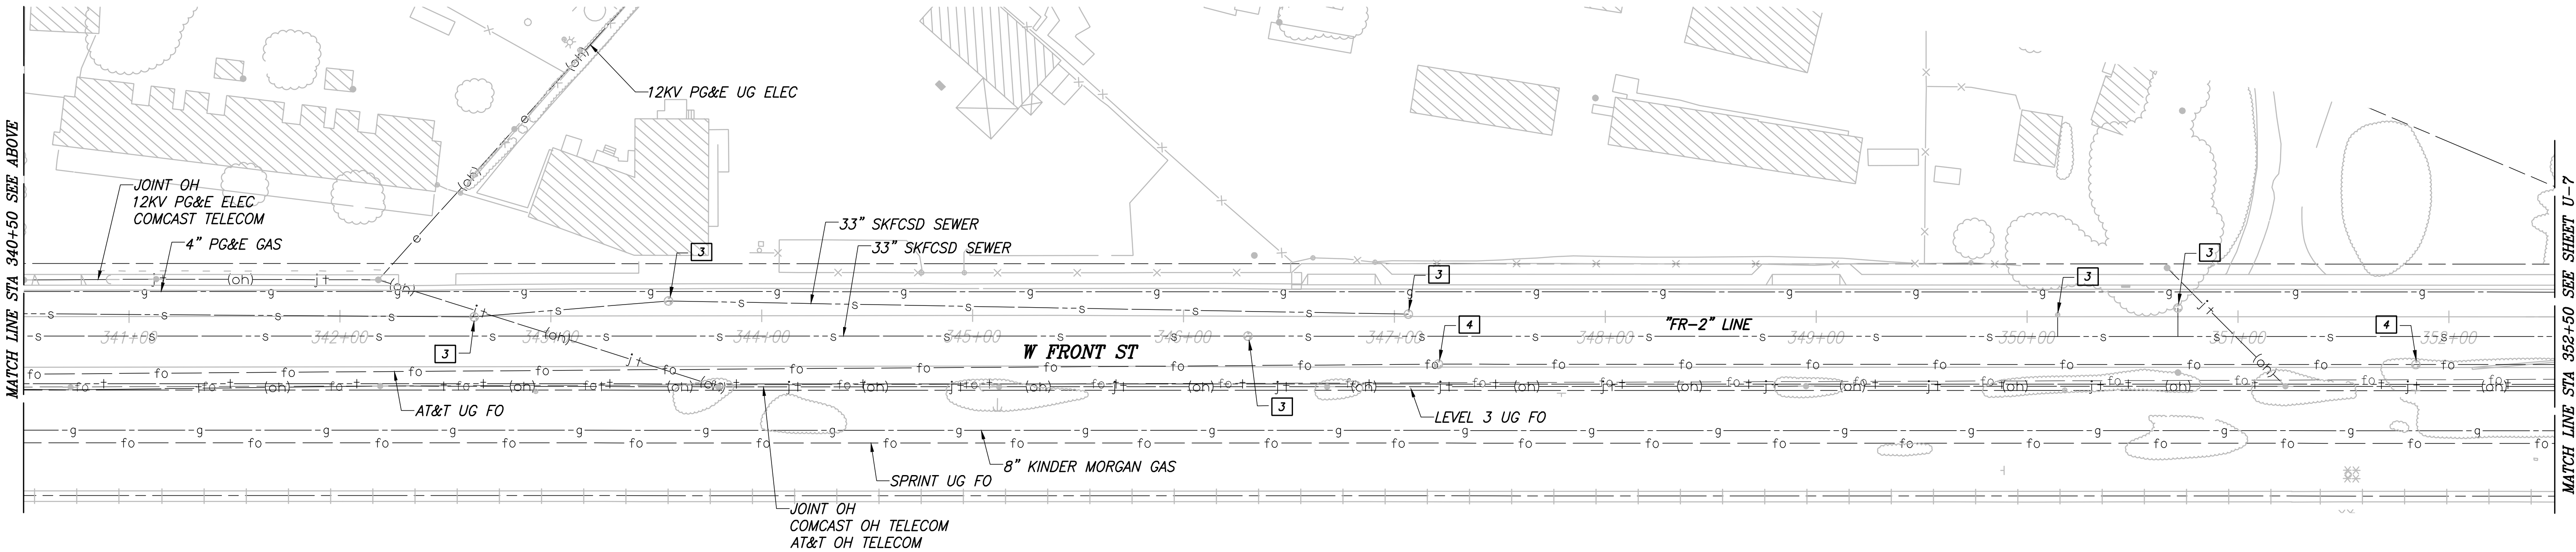

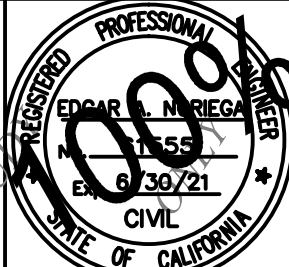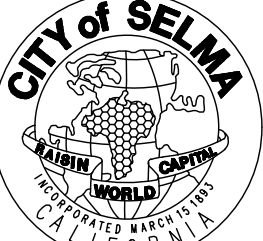DESIGNED: CYNTHIA HORNER		DATE	RECORD DRAWING	
DRAWN: DILLON ALAMEDA		3/12/2021	RESIDENT ENGINEER	DATE
CHECKED: JAMES POLFER		3/12/2021		
FOR RIGHT OF WAY DATA AND ACCURATE ACCESS DETERMINATION, SEE DOCUMENTS IN THE DEPARTMENT OF PUBLIC WORKS AND PLANNING.				
				
CALL BEFORE YOU DIG		TENTATIVE PLANS FOR DESIGN		DATE
SUPERVISING ENGINEER		PROJECT		DATE
		GOLDEN STATE CORRIDOR - ECONOMIC DEVELOPMENT AND INFRASTRUCTURE IMPROVEMENTS		
		SELMA REGION		
		DEPARTMENT OF PUBLIC WORKS AND PLANNING		
		UTILITY PLAN		
DRAWING NO. U-13		SHEET NO. 91		TOTAL 154


PATH: J:\Fresno COG-FN-16105-GSB Final Design\CADD\Sheets\Region 2 - Selma\GSB_R2_CS-1.dwg
PLOT DATE: 3/12/2021 1:54:42 PM
CAD USER: KBUCKALEW

NOTES

- 1. LOCATIONS OF CONSTRUCTION AREA SIGNS ARE APPROXIMATE. EXACT LOCATIONS TO BE DETERMINED BY THE ENGINEER.
- 2. ALL TRAFFIC CONTROL SHALL CONFORM WITH THE 2015 CALTRANS STANDARD PLANS AND THE CALIFORNIA MANUAL FOR UNIFORM TRAFFIC CONTROL DEVICES (MUTCD).
- 3. CHANGEABLE MESSAGE SIGNS SHALL BE PLACED TWO WEEKS PRIOR TO CONSTRUCTION.
- 4. CONTRACTOR TO PROVIDE REASONABLE MEANS FOR PROPERTY OWNERS ADJACENT CONSTRUCTION TO ACCESS PROPERTIES AT ALL TIMES.
- 5. CONTRACTOR TO COORDINATE ANY DRIVEWAY CLOSURES WITH PROPERTY OWNERS BEFORE REMOVING ACCESS.
- 6. CONTRACTOR TO PROVIDE A MINIMUM OF ONE-11' LANE, IN EACH DIRECTION, ACCESS ALONG GOLDEN STATE BOULEVARD, WHITSON STREET, AND W. FRONT STREET AT ALL TIMES.

LEGEND

- RECONSTRUCT ROADWAY AREA
- CONSTRUCTION AREA SIGN SINGLE POST
- TRAFFIC AREA DIRECTION
- CHANGEABLE MESSAGE SIGN (CMS)

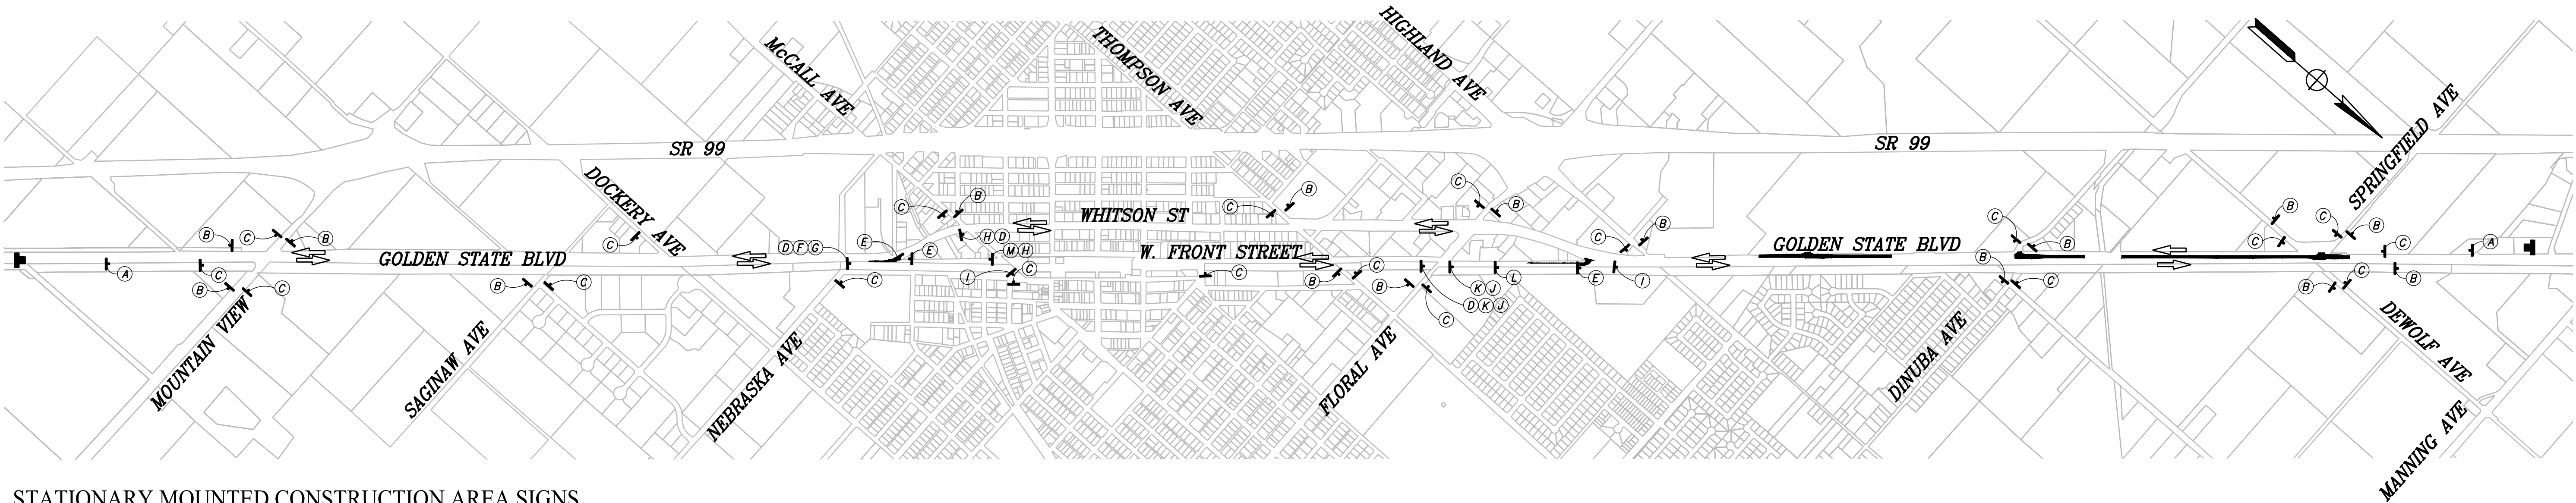

STATIONARY MOUNTED CONSTRUCTION AREA SIGNS

SIGN LETTER	SIGN CODE	PANEL SIZE	SIGN MESSAGE	EACH [N]
A	G20-1	90"x48"	ROAD WORK NEXT 3.5 MILES	2
B	G20-2	36"x18"	END ROAD WORK	16
C	W20-1	36"x18"	ROAD WORK AHEAD	20
D	CUSTOM	36"x18"	FRONT STREET	3
E	R11-2	36"x18"	ROAD CLOSED	3
F	M4-B	24"x12"	DETOUR	1
G	M5-2	21x15"	ADVANCE TURN ARROW	1
H	M4-10	48"x18"	DETOUR ARROW RIGHT	2
I	G20-2	90"x48"	END DETOUR	2
J	W20-1	36"x36"	DETOUR ARROW LEFT	1
K	R11-3A	60"x30"	ROAD CLOSED 0.3 MILES AHEAD LOCAL TRAFFIC ONLY	1
L	W20-3	36"x36"	ROAD CLOSED 1000 FEET	1
M	R11-4	60"x30"	ROAD CLOSED TO THRU TRAFFIC	1
TOTAL				54

[N] NOT A SEPARATE PAY ITEM, FOR INFORMATION ONLY.

DESIGNED: CYNTHIA HORNER

DRAWN: ERIK CHIN

CHECKED: JAMES POLFER

DATE

3/12/2021

3/12/2021

3/12/2021

RECORD DRAWING

DATE

FOR RIGHT OF WAY DATA AND ACCURATE ACCESS DETERMINATION, SEE DOCUMENTS IN THE DEPARTMENT OF PUBLIC WORKS AND PLANNING.

811

CALL BEFORE YOU DIG

MARK THOMAS

SUPERVISING ENGINEER

DATE

3/30/21

PROJECT

GOLDEN STATE CORRIDOR - ECONOMIC DEVELOPMENT AND INFRASTRUCTURE IMPROVEMENTS

SELMA REGION

CITY of SELMA

DEPARTMENT OF PUBLIC WORKS AND PLANNING

CONSTRUCTION AREA SIGNS

DRAWING NO. CS-1

SHEET NO. 92

TOTAL 154

CAD USER: KBUCKALEW
PLOT DATE: 3/12/2021 1:55:24 PM

PATH: J:\Fresno COG-FN-16105-GSB Final Design\CADD\Sheets\Region 2 - Selma\GSB_R2_SC1 1-2.dwg

NOTES

1. TRAFFIC CONTROL SHOWN ON PLANS, INCLUDING LOCATIONS OF CONSTRUCTION AREA SIGNS, ARE APPROXIMATE AND INTENDED TO BE UTILIZED FOR STAGING PURPOSES ONLY. ALL TRAFFIC CONTROL SHALL BE APPROVED BY CITY OF SELMA AND COUNTY OF FRESNO PUBLIC WORKS DEPARTMENT PRIOR TO CONSTRUCTION. ALL SIGN LOCATIONS SHALL BE APPROVED BY THE ENGINEER.
2. ALL TRAFFIC CONTROL SHALL CONFORM WITH THE 2015 CALTRANS STANDARD PLANS AND THE CALIFORNIA MANUAL FOR UNIFORM TRAFFIC CONTROL DEVICES (MUTCD).
3. CONTRACTOR TO PROVIDE A MINIMUM OF ONE-11' LANE OF ACCESS IN EACH DIRECTION ALONG GOLDEN STATE BOULEVARD DURING CONSTRUCTION AT ALL TIMES.
4. CONTRACTOR TO PROVIDE REASONABLE MEANS FOR PROPERTY OWNERS THAT ARE ADJACENT TO CONSTRUCTION TO ACCESS PROPERTIES AT ALL TIMES.
5. CONTRACTOR TO COORDINATE ANY DRIVEWAY CLOSURES WITH PROPERTY OWNERS BEFORE IMPACTING ACCESS.
6. CONTRACTOR SHALL COORDINATE WITH UPRR DURING ALL STAGES OF CONSTRUCTION.

TRAFFIC STAGE 1


1. WORK NOT NECESSARY FOR STAGING OPERATION CAN BE DONE AT ANY TIME AND IS NOT SHOWN.

LEGEND

- CONSTRUCTION THIS STAGE
- # CONSTRUCTION ITEM THIS STAGE

CONSTRUCTION STAGE 1

1. CONSTRUCT LEFT TURN LANES AND WIDENING AREAS AS SHOWN ON CD-SHEETS. DO NOT INSTALL FINAL LIFT OF HMA.
2. CONSTRUCT CURB, GUTTER, CURB RAMP, AND SIDEWALK AS SHOWN ON CD-SHEETS.
3. RECONSTRUCT TODD STREET/FRONT STREET INTERSECTION. DO NOT INSTALL FINAL LIFT OF HMA.
4. RECONSTRUCT NORTH AVENUE/FRONT STREET SIDEWALK.
5. CONSTRUCT CURB, GUTTER, CURB RAMP, SIDEWALK, WIDENING, AND INTERSECTION AT FRONT ST AND WHITSON ST.

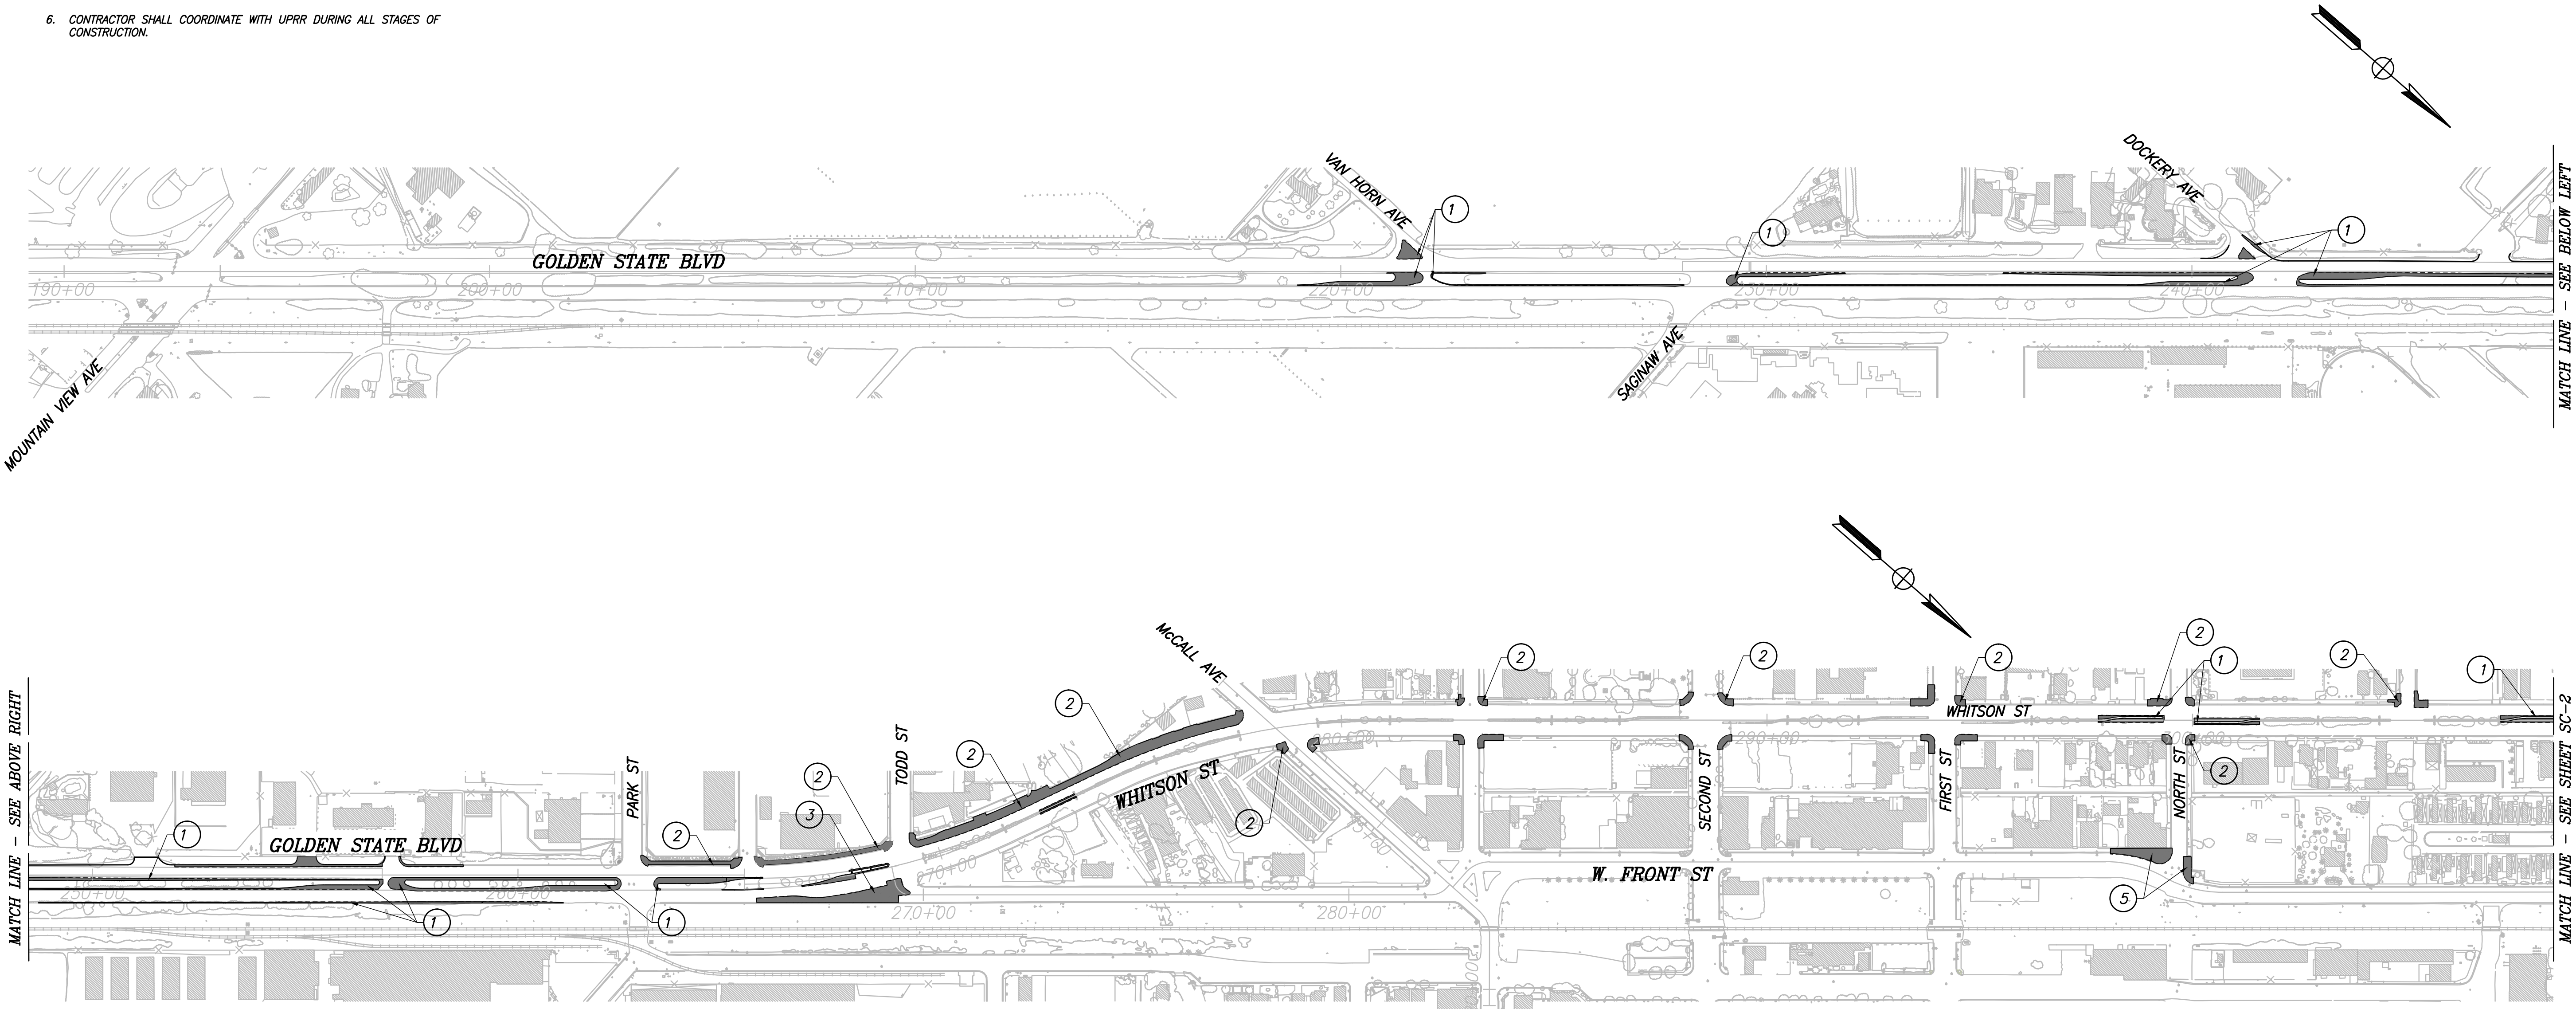

RECORD DRAWING			
DESIGNED:	DATE	3/12/2021	RESIDENT ENGINEER
DRAWN:	DATE	3/12/2021	
CHECKED:	DATE	3/12/2021	


FOR RIGHT OF WAY DATA AND ACCURATE ACCESS DETERMINATION, SEE DOCUMENTS IN THE DEPARTMENT OF PUBLIC WORKS AND PLANNING.



TENTATIVE PLANS FOR DESIGN	
SUPERVISING ENGINEER	DATE




PROJECT	
GOLDEN STATE CORRIDOR - ECONOMIC DEVELOPMENT AND INFRASTRUCTURE IMPROVEMENTS	
SELMA REGION	

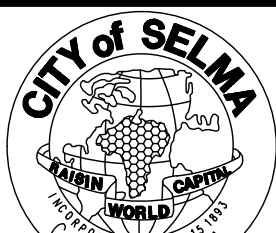

DEPARTMENT OF PUBLIC WORKS AND PLANNING		
STAGE CONSTRUCTION - STAGE 1		
DRAWING NO. SC-1	SHEET NO. 93	TOTAL 154

PATH: J:\Fresno COG-FN-16105-GSB Final Design\CADD\Sheets\Region 2 - Selma\GSB_R2_SC1 1-2.dwg
PLOT DATE: 3/12/2021 1:55:49 PM CAD USER: KBUCKALEW

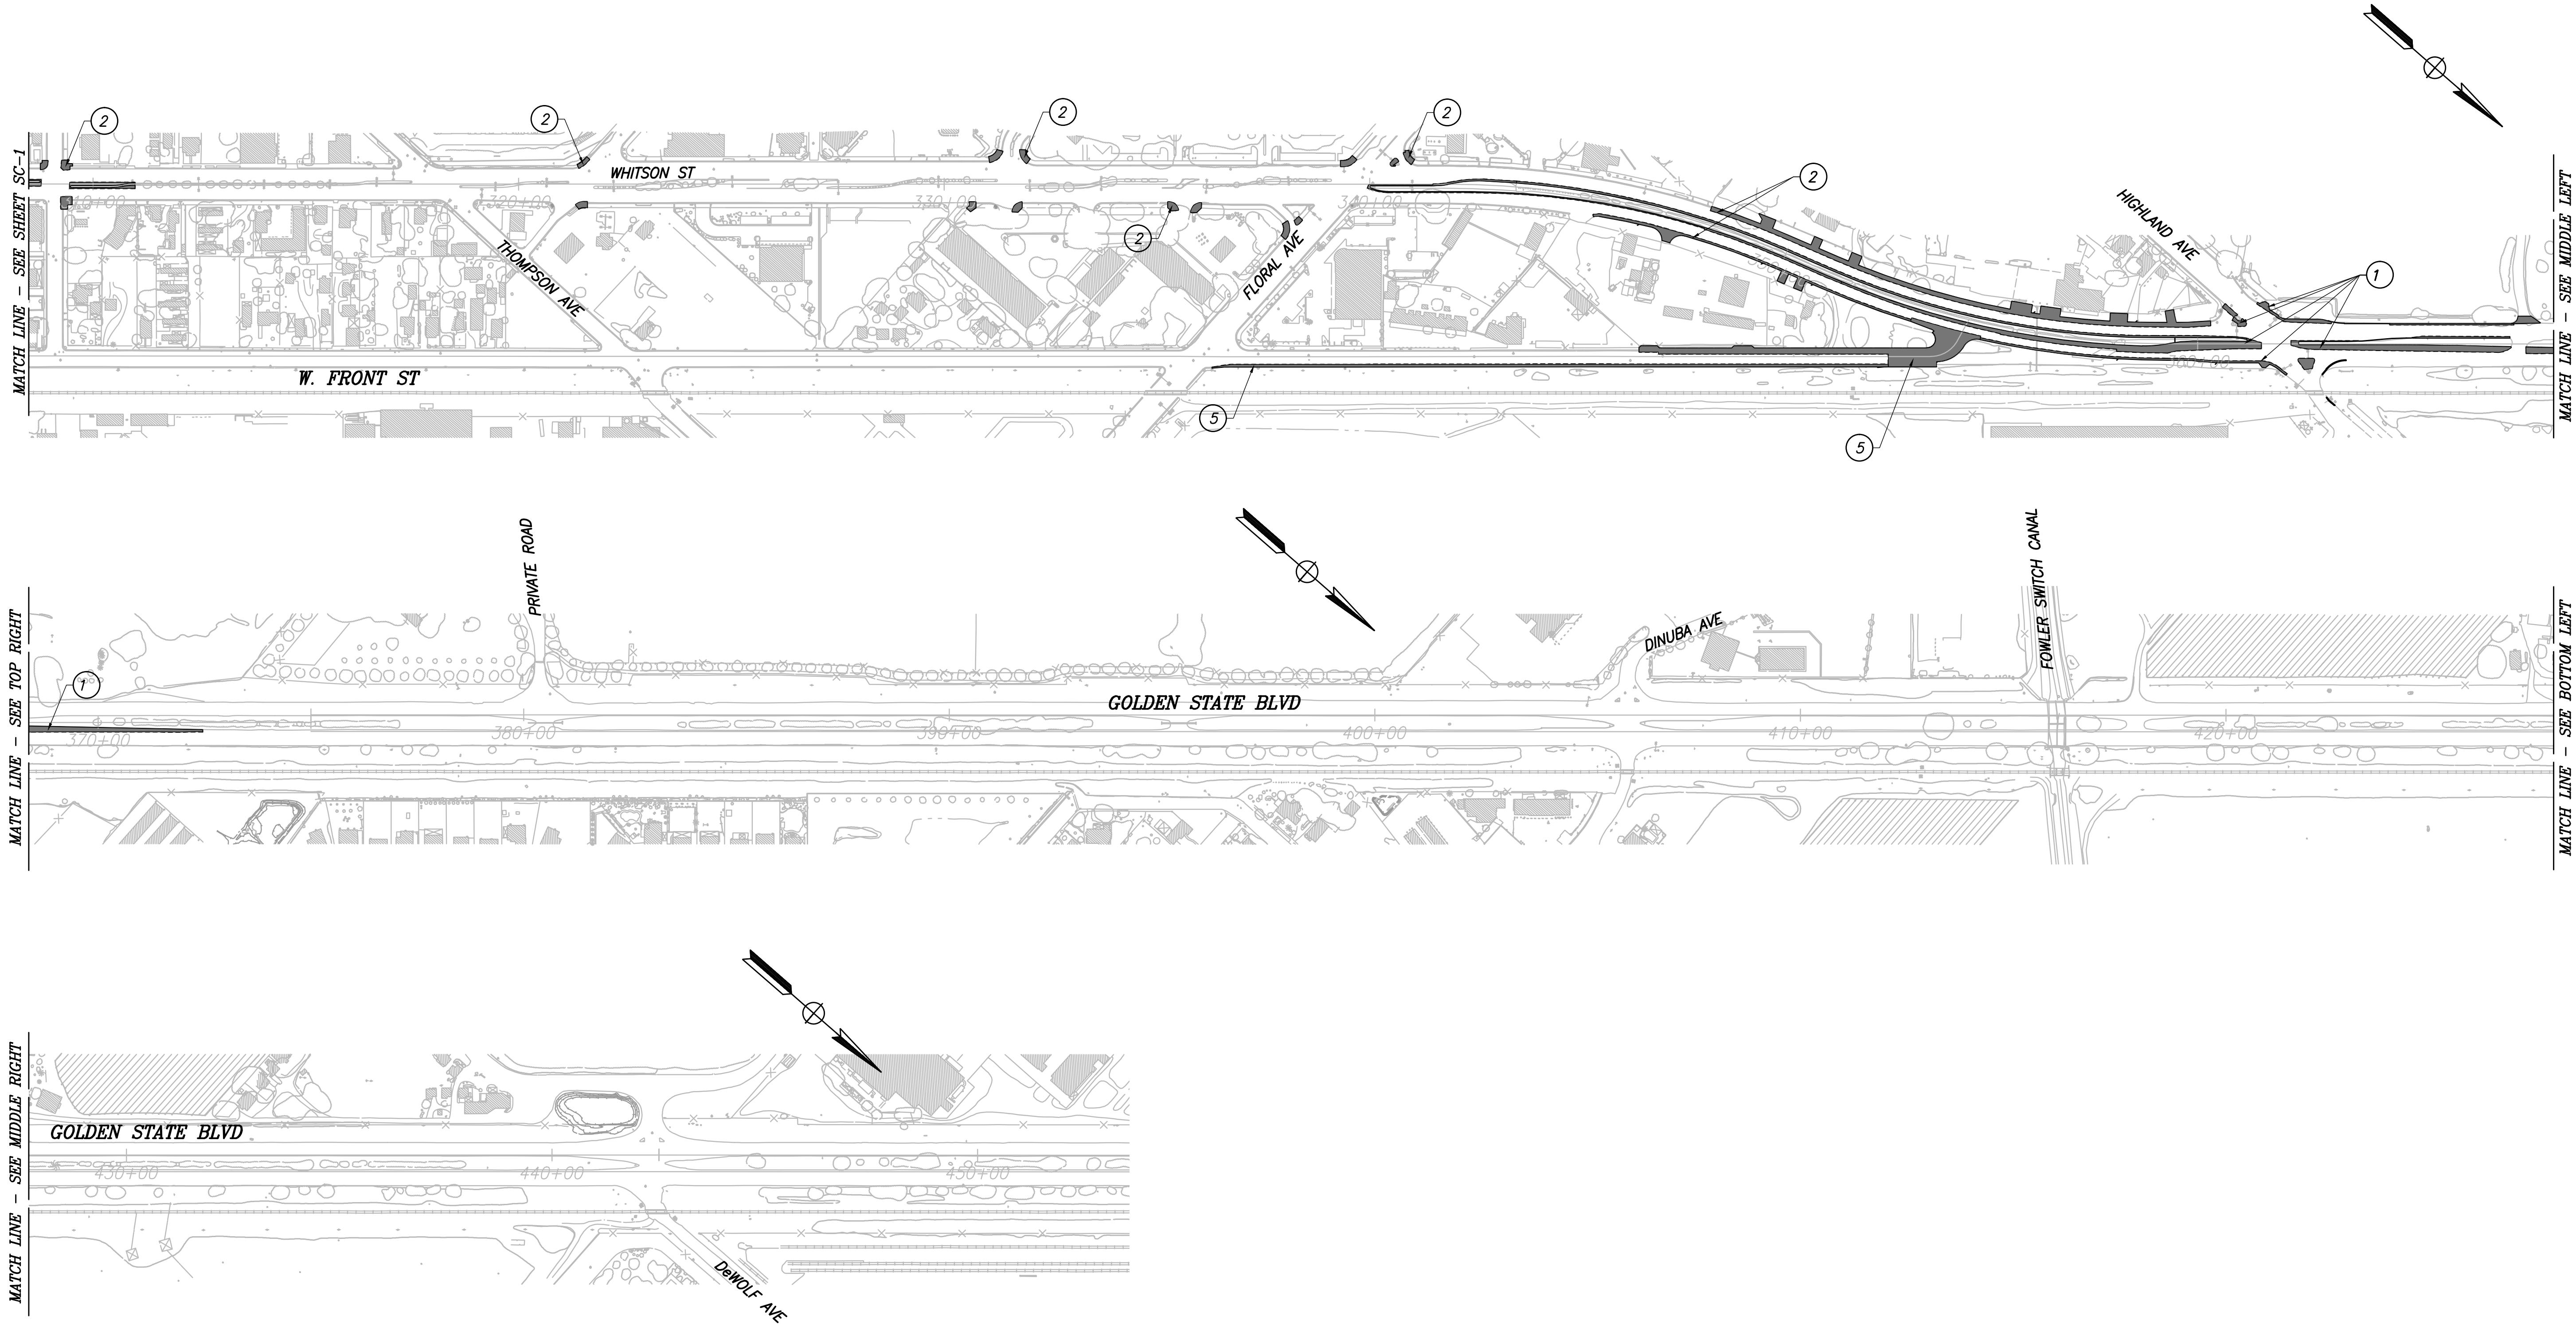

	DATE	RECORD DRAWING	
DESIGNED:	3/12/2021	RESIDENT ENGINEER	DATE
DRAWN:	3/12/2021		
CHECKED:	3/12/2021		


FOR RIGHT OF WAY DATA AND ACCURATE ACCESS DETERMINATION, SEE DOCUMENTS IN THE DEPARTMENT OF PUBLIC WORKS AND PLANNING.



TENTATIVE PLANS FOR DESIGN	DATE
SUPERVISING ENGINEER	



PROJECT
GOLDEN STATE CORRIDOR - ECONOMIC DEVELOPMENT AND INFRASTRUCTURE IMPROVEMENTS
SELMA REGION

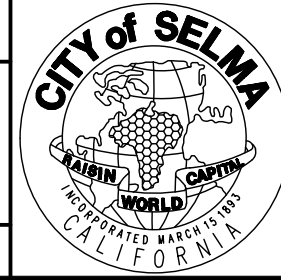

DEPARTMENT OF PUBLIC WORKS AND PLANNING		
STAGE CONSTRUCTION - STAGE 1		
DRAWING NO. SC-2	SHEET NO. 94	TOTAL 154

CAD USER: KBUCKALEW
PLOT DATE: 3/12/2021 1:56:53 PM

PATH: J:\Fresno COG-FN-16105-GSB Final Design\CADD\Sheets\Region 2 - Selma\GSB_R2_SC2 3-4.dwg

NOTES

1. TRAFFIC CONTROL SHOWN ON PLANS, INCLUDING LOCATIONS OF CONSTRUCTION AREA SIGNS, ARE APPROXIMATE AND INTENDED TO BE UTILIZED FOR STAGING PURPOSES ONLY. ALL TRAFFIC CONTROL SHALL BE APPROVED BY CITY OF SELMA AND COUNTY OF FRESNO PUBLIC WORKS DEPARTMENT PRIOR TO CONSTRUCTION. ALL SIGN LOCATIONS SHALL BE APPROVED BY THE ENGINEER.
2. ALL TRAFFIC CONTROL SHALL CONFORM WITH THE MOST RECENT CALTRANS STANDARD PLANS AND THE CALIFORNIA MANUAL FOR UNIFORM TRAFFIC CONTROL DEVICES (MUTCD).
3. CONTRACTOR TO PROVIDE A MINIMUM OF ONE-11' LANE OF ACCESS IN EACH DIRECTION ALONG GOLDEN STATE BOULEVARD DURING CONSTRUCTION AT ALL TIMES.
4. CONTRACTOR TO PROVIDE REASONABLE MEANS FOR PROPERTY OWNERS THAT ARE ADJACENT TO CONSTRUCTION TO ACCESS PROPERTIES AT ALL TIMES.
5. CONTRACTOR TO COORDINATE ANY DRIVEWAY CLOSURES WITH PROPERTY OWNERS BEFORE IMPACTING ACCESS.
6. CONTRACTOR SHALL COORDINATE WITH UPRR DURING ALL STAGES OF CONSTRUCTION.

TRAFFIC STAGE 2

1. DURING CLOSURE OF RAILROAD CROSSING AT MCCALL AVE, USE SECOND STREET FOR DETOUR.


LEGEND

- CONSTRUCTION THIS STAGE
- #

CONSTRUCTION ITEM THIS STAGE

CONSTRUCTION STAGE 2

1. CONSTRUCT IMPROVEMENTS FOR McCALL AVENUE/FRONT STREET INTERSECTION.
2. CONSTRUCT IMPROVEMENTS FOR PRIVATE ROAD/GOLDEN STATE BOULEVARD INTERSECTION. DO NOT CONSTRUCT FINAL LIFT OF HMA ON SOUTHBOUND LANES OF GOLDEN STATE BOULEVARD.
3. CONSTRUCT IMPROVEMENTS FOR DINUBA AVENUE/GOLDEN STATE BOULEVARD INTERSECTION. DO NOT CONSTRUCT FINAL LIFT OF HMA ON SOUTHBOUND LANES OF GOLDEN STATE BOULEVARD.
4. CONSTRUCT IMPROVEMENTS FOR DeWOLF AVENUE/GOLDEN STATE BOULEVARD INTERSECTION. DO NOT CONSTRUCT FINAL LIFT OF HMA ON SOUTHBOUND LANES OF GOLDEN STATE BOULEVARD.

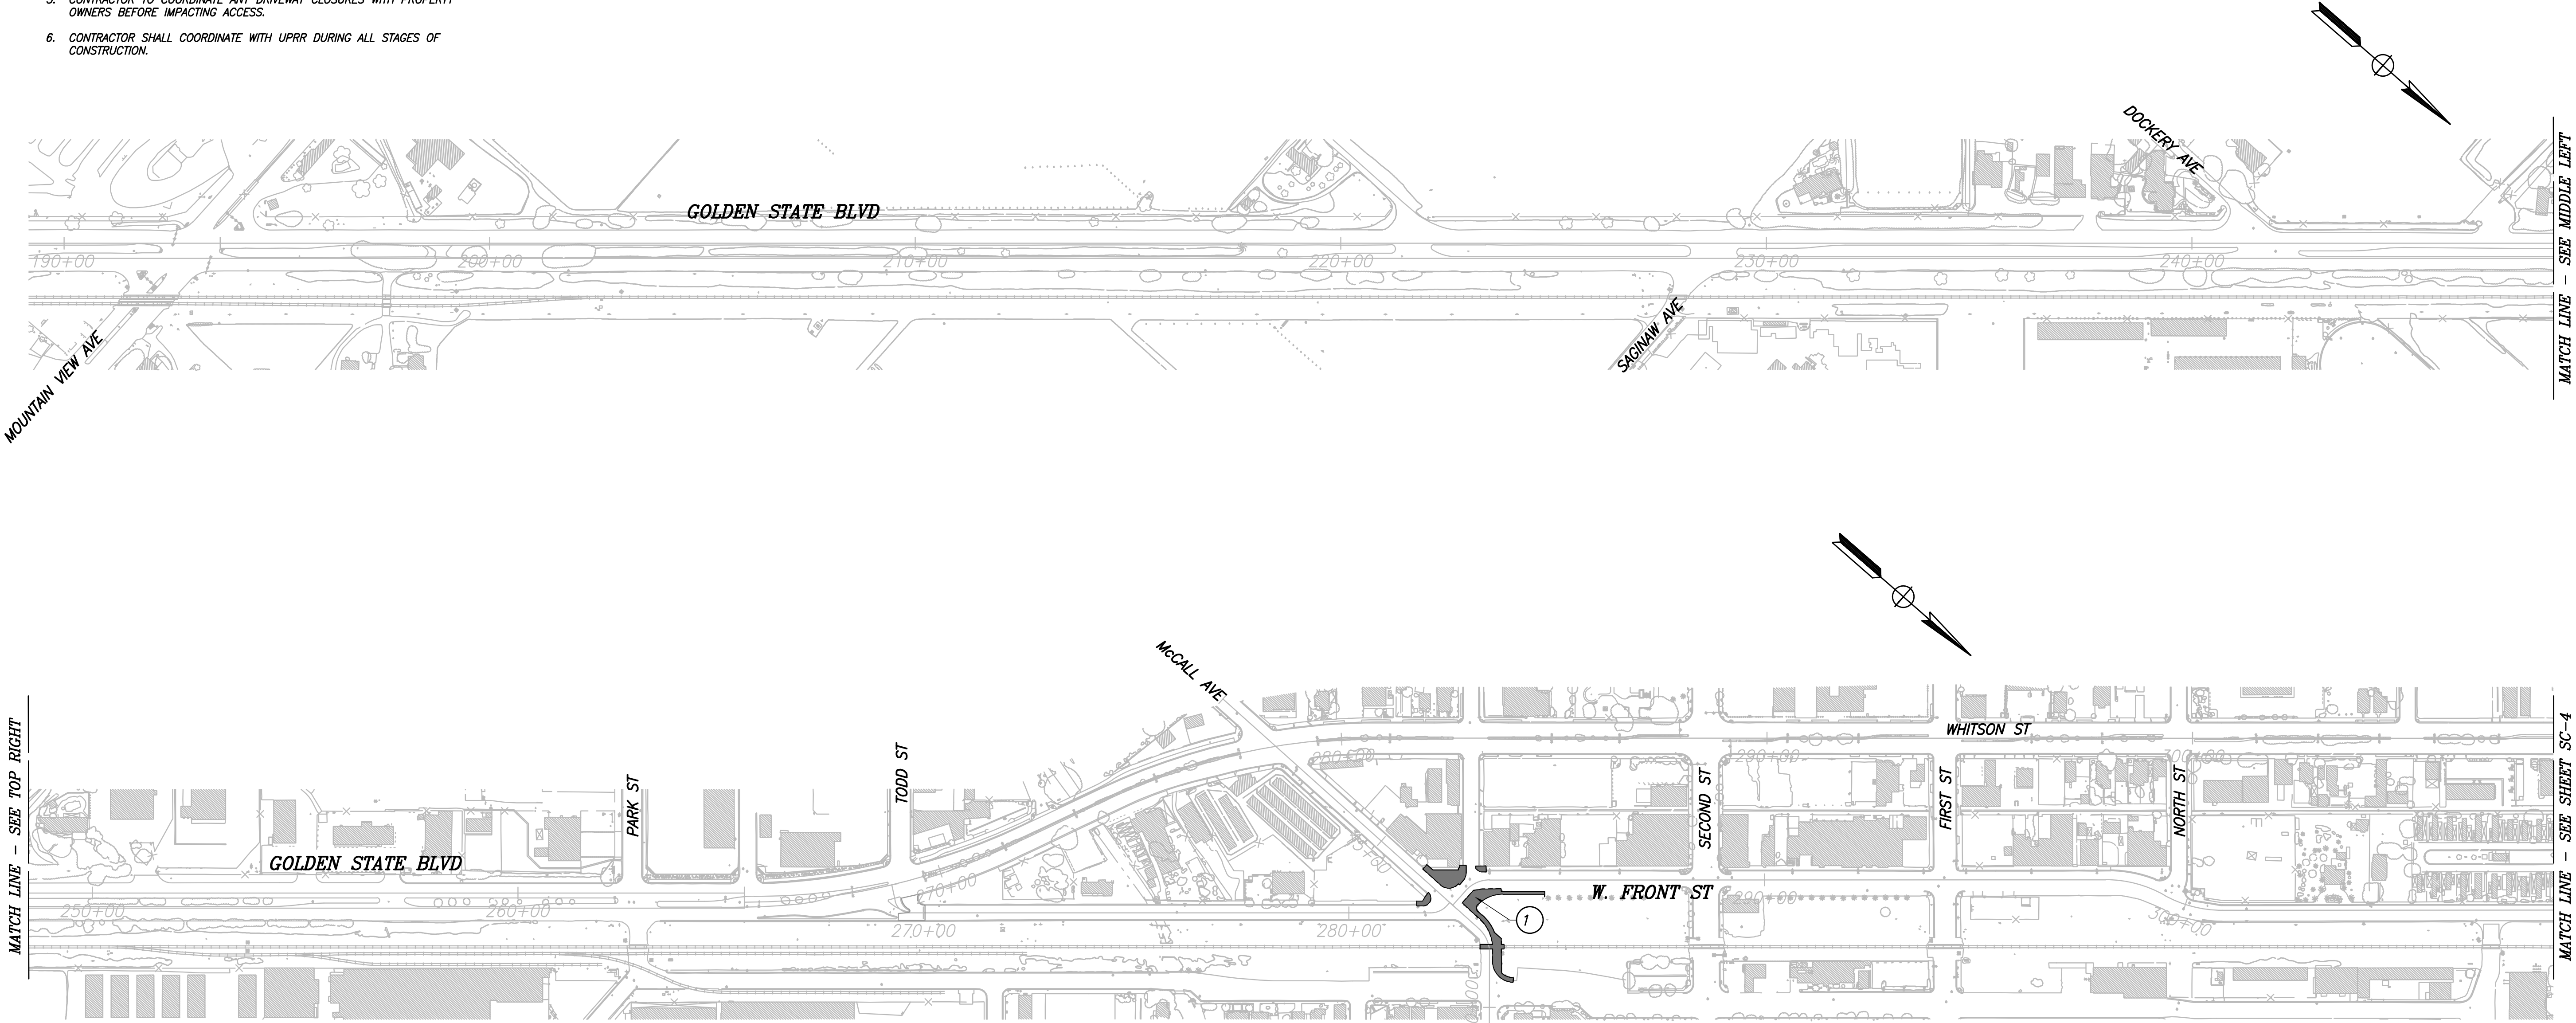

RECORD DRAWING	
DESIGNED:	DATE
DRAWN:	DATE
CHECKED:	DATE


FOR RIGHT OF WAY DATA AND ACCURATE ACCESS DETERMINATION, SEE DOCUMENTS IN THE DEPARTMENT OF PUBLIC WORKS AND PLANNING.



TENTATIVE PLANS FOR DESIGN	
SUPERVISING ENGINEER	DATE




PROJECT
GOLDEN STATE CORRIDOR - ECONOMIC DEVELOPMENT AND INFRASTRUCTURE IMPROVEMENTS
SELMA REGION

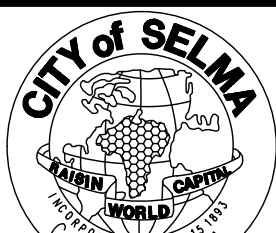

DEPARTMENT OF PUBLIC WORKS AND PLANNING		
STAGE CONSTRUCTION - STAGE 2		
DRAWING NO. SC-3	SHEET NO. 95	TOTAL 154

PATH: J:\Fresno COG-FN-16105-GSB Final Design\CADD\Sheets\Region 2 - Selma\GSB_R2_SC2_3-4.dwg
PLOT DATE: 3/12/2021 1:57:30 PM CAD USER: KBUCKALEW

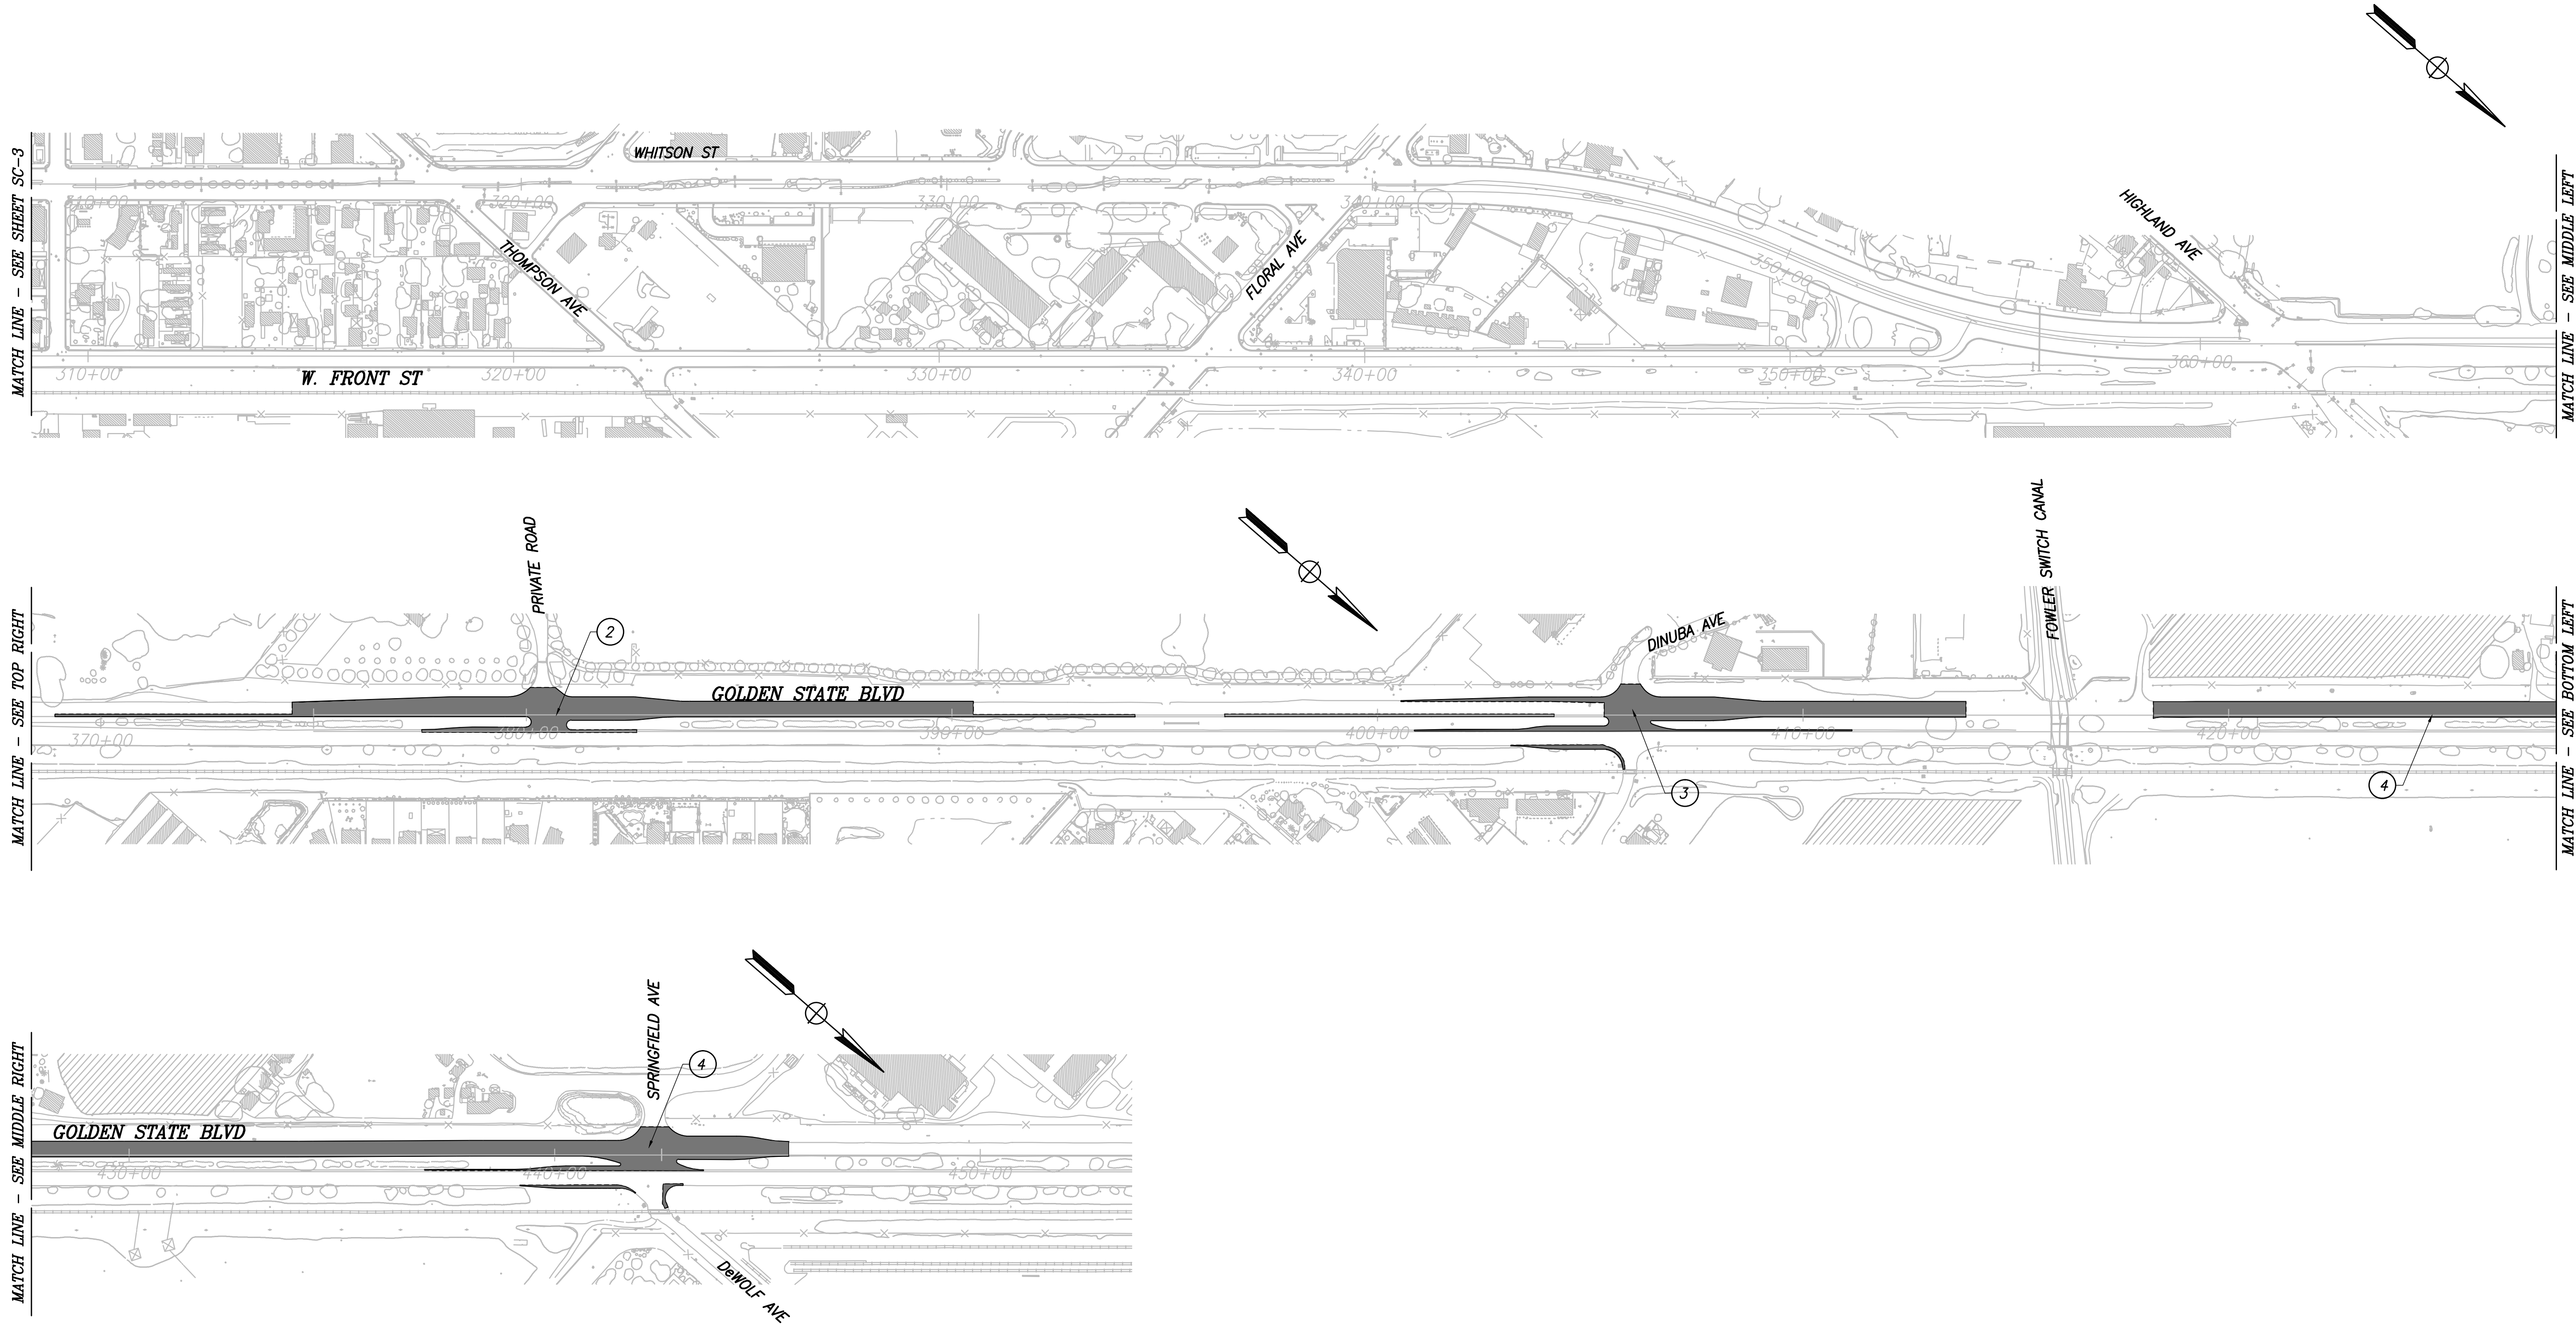

	DATE	RECORD DRAWING	
DESIGNED:	3/12/2021	RESIDENT ENGINEER	DATE
DRAWN:	3/12/2021		
CHECKED:	3/12/2021		


FOR RIGHT OF WAY DATA AND ACCURATE ACCESS DETERMINATION, SEE DOCUMENTS IN THE DEPARTMENT OF PUBLIC WORKS AND PLANNING.



TENTATIVE PLANS FOR DESIGN	DATE
SUPERVISING ENGINEER	



PROJECT
GOLDEN STATE CORRIDOR - ECONOMIC DEVELOPMENT AND INFRASTRUCTURE IMPROVEMENTS
SELMA REGION

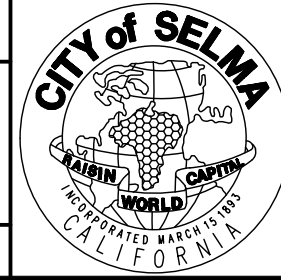

DEPARTMENT OF PUBLIC WORKS AND PLANNING		
STAGE CONSTRUCTION - STAGE 2		
DRAWING NO. SC-4	SHEET NO. 96	TOTAL 154

CAD USER: THARDY
PLOT DATE: 3/12/2021 1:58:19 PM
PATH: J:\Fresno COG-FN-16105-GSB Final Design\CADD\Sheets\Region 2 - Selma\GSB_R2_SC3 5-6.dwg

NOTES

1. TRAFFIC CONTROL SHOWN ON PLANS, INCLUDING LOCATIONS OF CONSTRUCTION AREA SIGNS, ARE APPROXIMATE AND INTENDED TO BE UTILIZED FOR STAGING PURPOSES ONLY. ALL TRAFFIC CONTROL SHALL BE APPROVED BY CITY OF SELMA AND COUNTY OF FRESNO PUBLIC WORKS DEPARTMENT PRIOR TO CONSTRUCTION. ALL SIGN LOCATIONS SHALL BE APPROVED BY THE ENGINEER.
2. ALL TRAFFIC CONTROL SHALL CONFORM WITH THE MOST RECENT CALTRANS STANDARD PLANS AND THE CALIFORNIA MANUAL FOR UNIFORM TRAFFIC CONTROL DEVICES (MUTCD).
3. CONTRACTOR TO PROVIDE A MINIMUM OF ONE-11' LANE OF ACCESS IN EACH DIRECTION ALONG GOLDEN STATE BOULEVARD DURING CONSTRUCTION AT ALL TIMES.
4. CONTRACTOR TO PROVIDE REASONABLE MEANS FOR PROPERTY OWNERS THAT ARE ADJACENT TO CONSTRUCTION TO ACCESS PROPERTIES AT ALL TIMES.
5. CONTRACTOR TO COORDINATE ANY DRIVEWAY CLOSURES WITH PROPERTY OWNERS BEFORE IMPACTING ACCESS.
6. CONTRACTOR SHALL COORDINATE WITH UPRR DURING ALL STAGES OF CONSTRUCTION.

TRAFFIC STAGE 3

1. DURING CLOSURE OF RAILROAD CROSSING AT McCALL AVENUE, USE SECOND STREET FOR DETOUR.

LEGEND

- CONSTRUCTION THIS STAGE
- CONSTRUCTION THIS STAGE
- #

CONSTRUCTION ITEM THIS STAGE

CONSTRUCTION STAGE 3

- 1

CONSTRUCT GRIND/OVERLAY BETWEEN SOUTHERN PROJECT LIMIT TO SAGINAW AVENUE.
- 2

CONSTRUCT GRIND/OVERLAY BETWEEN SAGINAW AVENUE AND PARK STREET.
- 3

CRACK AND SEAT PCC AND INSTALL SAMI-R AND RHMA OVERLAY BETWEEN SOUTHERN PROJECT LIMIT TO SAGINAW AVENUE
- 4

CRACK AND SEAT PCC AND INSTALL SAMI-R AND RHMA OVERLAY BETWEEN SAGINAW AVENUE AND PARK AVENUE
- 5

CONSTRUCT GRIND/OVERLAY BETWEEN PARK STREET AND McCALL AVENUE.
- 6

CONSTRUCT GRIND/OVERLAY BETWEEN McCALL AVENUE AND SECOND STREET.
- 7

CONSTRUCT GRIND/OVERLAY BETWEEN SECOND STREET AND NORTH STREET.
- 8

CONSTRUCT GRIND/OVERLAY BETWEEN NORTH STREET AND THOMPSON AVENUE.
- 9

CONSTRUCT GRIND/OVERLAY BETWEEN THOMPSON AVENUE AND FLORAL AVENUE.
- 10

CONSTRUCT GRIND/OVERLAY BETWEEN FLORAL AVENUE AND HIGHLAND AVENUE.
- 11

CONSTRUCT GRIND/OVERLAY BETWEEN HIGHLAND AVENUE AND PRIVATE ROAD.
- 12

COMPLETE FINAL LIFT OF HMA AT INTERSECTION OF PRIVATE ROAD AND GOLDEN STATE BOULEVARD.
- 13


CONSTRUCT GRIND/OVERLAY BETWEEN PRIVATE ROAD AND DINUBA AVENUE.
- 14

CONSTRUCT FINAL LIFT OF HMA AT INTERSECTION OF DINUBA AVENUE AND GOLDEN STATE BOULEVARD.
- 15

CONSTRUCT GRIND/OVERLAY BETWEEN DINUBA AVENUE AND NORTHERN PROJECT LIMIT.
- 16

COMPLETE FINAL LIFT OF HMA AT INTERSECTION OF DEWOLF AVENUE AND GOLDEN STATE BOULEVARD.
- 17

APPLY SLURRY SEAL.

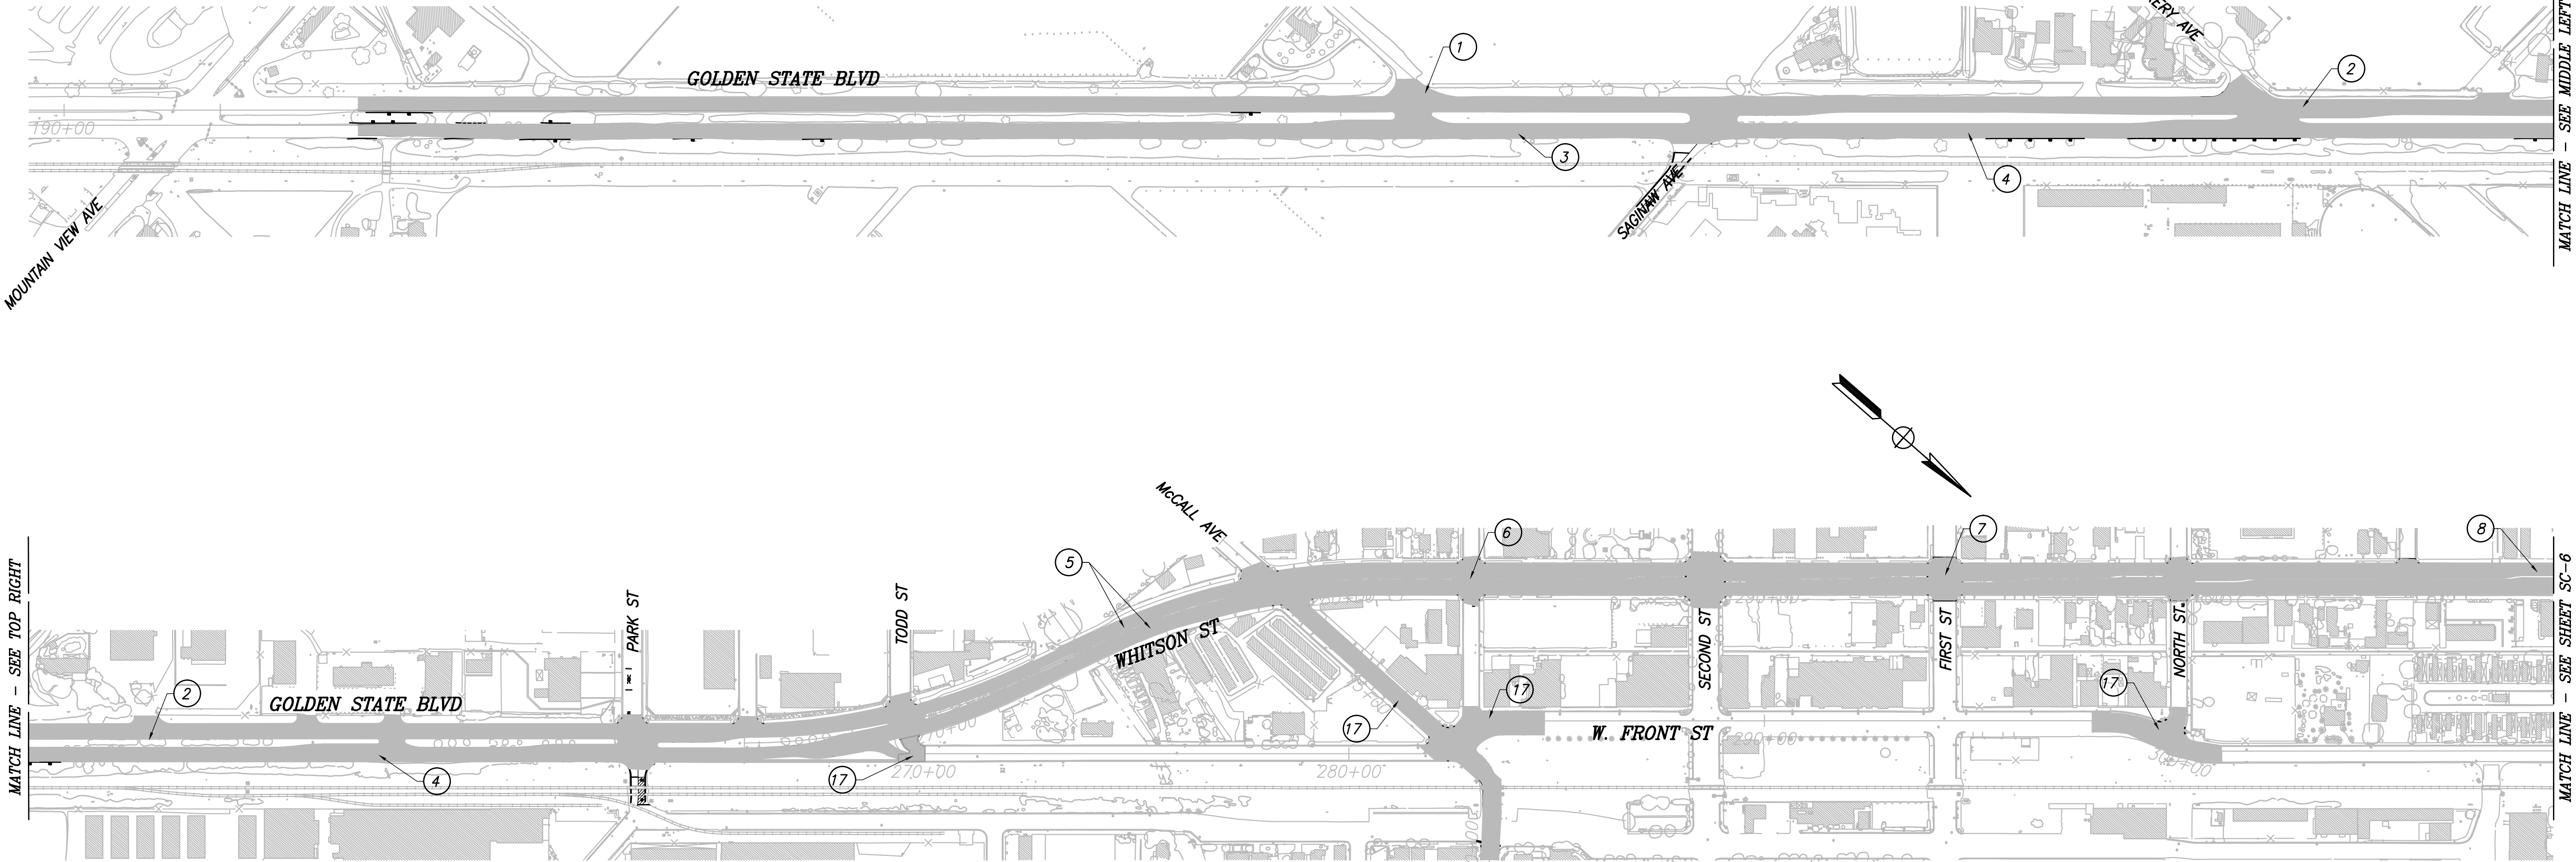

RECORD DRAWING	
DESIGNED:	DATE
DRAWN:	DATE
CHECKED:	DATE


FOR RIGHT OF WAY DATA AND ACCURATE ACCESS DETERMINATION, SEE DOCUMENTS IN THE DEPARTMENT OF PUBLIC WORKS AND PLANNING.



TENTATIVE PLANS FOR DESIGN	DATE
SUPERVISING ENGINEER	




PROJECT
GOLDEN STATE CORRIDOR - ECONOMIC DEVELOPMENT AND INFRASTRUCTURE IMPROVEMENTS
SELMA REGION

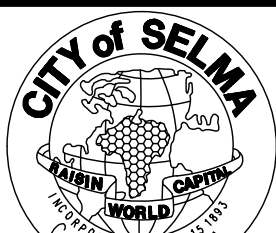

DEPARTMENT OF PUBLIC WORKS AND PLANNING		
STAGE CONSTRUCTION - STAGE 3		
DRAWING NO. SC-5	SHEET NO. 97	TOTAL 154

PATH: J:\Fresno COG-FN-16105-GSB Final Design\CADD\Sheets\Region 2 - Selma\GSB_R2_SC3 5-6.dwg
PLOT DATE: 3/12/2021 1:58:47 PM CAD USER: THARDY

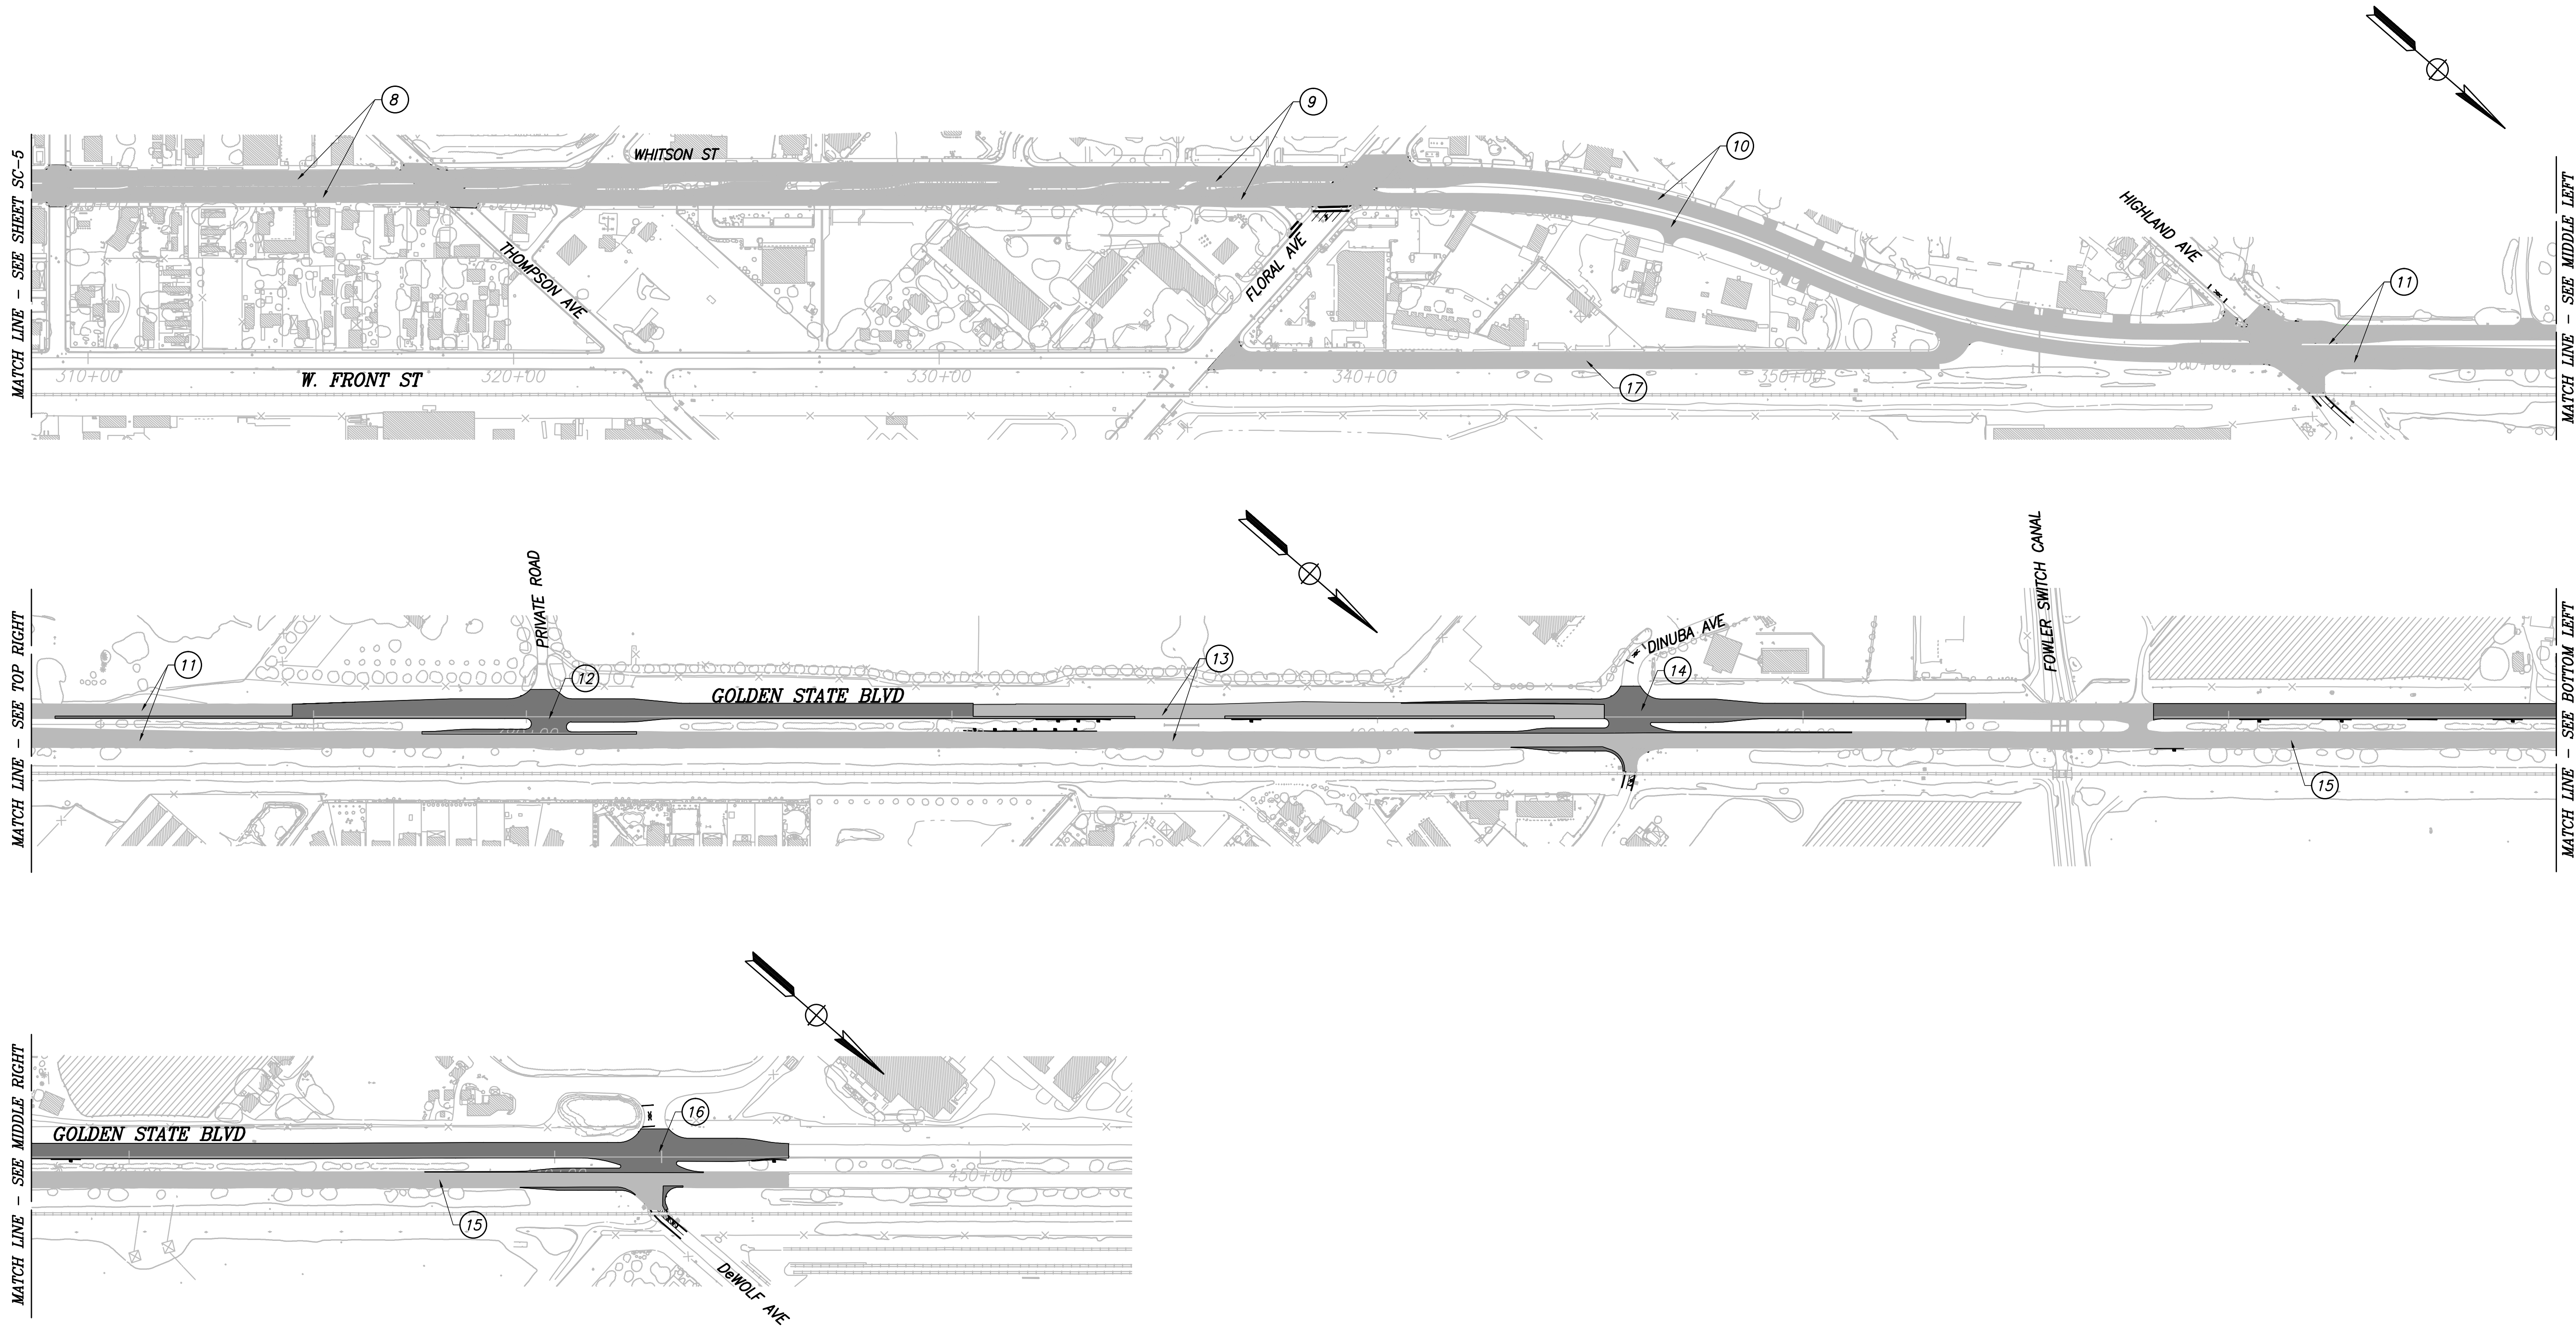

	DATE	RECORD DRAWING	
DESIGNED:	3/12/2021	RESIDENT ENGINEER	DATE
DRAWN:	3/12/2021		
CHECKED:	3/12/2021		


FOR RIGHT OF WAY DATA AND ACCURATE ACCESS DETERMINATION, SEE DOCUMENTS IN THE DEPARTMENT OF PUBLIC WORKS AND PLANNING.



TENTATIVE PLANS FOR DESIGN	DATE
SUPERVISING ENGINEER	



PROJECT
GOLDEN STATE CORRIDOR - ECONOMIC DEVELOPMENT AND INFRASTRUCTURE IMPROVEMENTS
SELMA REGION

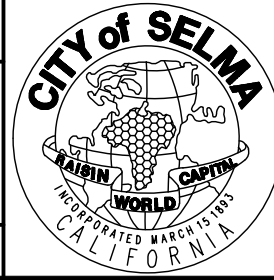

DEPARTMENT OF PUBLIC WORKS AND PLANNING		
STAGE CONSTRUCTION - STAGE 3		
DRAWING NO. SC-6	SHEET NO. 98	TOTAL 154

PATH: J:\Fresno COG-FN-16105-GSB Final Design\CADD\Sheets\Region 2 - Selma\GSB_R2_SS1-SS7.dwg PLOT DATE: 3/12/2021 1:59:43 PM CAD USER: ESERULVEDA

NOTES

1. CROSSWALK TO BE 10' WIDE PER COUNTY OF FRESNO STD ST 42 UNLESS OTHERWISE NOTED.
2. ALL PAVEMENT STRIPING AND PAVEMENT MARKINGS SHALL BE THERMOPLASTIC UNLESS OTHERWISE NOTED.

LEGEND



TYPE IV (L) ARROW PER CALTRANS STD PLAN A24A



TYPE IV (R) ARROW PER CALTRANS STD PLAN A24A



RAILROAD CROSSING SYMBOL PER CLATRANS STD PLAN A24B



TYPE VI ARROW PER CALTRANS STD PLAN A24A



TYPE II (R) ARROW PER CALTRANS STD PLAN A24B



TYPE 1 ARROW PER CALTRANS STD PLAN A24A



"AHEAD" MARKING PER CALTRANS STD PLAN A24D



"SIGNAL" MARKING PER CALTRANS STD PLAN A24D



"STOP" MARKING PER CALTRANS STD PLAN A24D



BIKE LANE LEGEND (SEE DETAIL THIS SHEET)



12" WIDE WHITE CROSSWALK LINE PER CALTRANS STD PLAN A24F



12" WIDE WHITE LIMIT LINE PER CALTRANS RSP A24E



24" WIDE WHITE LIMIT LINE PER CALTRANS STD PLAN A24B



DENOTES PROPOSED DETAIL NUMBER PER CALTRANS STD PLANS



DENOTES EXISTING DETAIL NUMBER PER CALTRANS STD PLANS



CHANGE IN TRAFFIC STRIPE



STREET NAME SIGN



EXISTING SINGLE POST ROADSIDE SIGN



PROPOSED SINGLE POST ROADSIDE SIGN



GREEN DASHED MARKINGS IN MERGING AREAS (SEE DETAIL SHEET SS-8)



EXISTING SIGN TO BE SALVAGED AND REPLACED



EXISTING SIGN TO REMAIN





EXISTING SIGN TO BE RESET OR RELOCATED





EXISTING SIGN TO BE REMOVED AND SALVAGED





INSTALL ROADSIDE SIGN

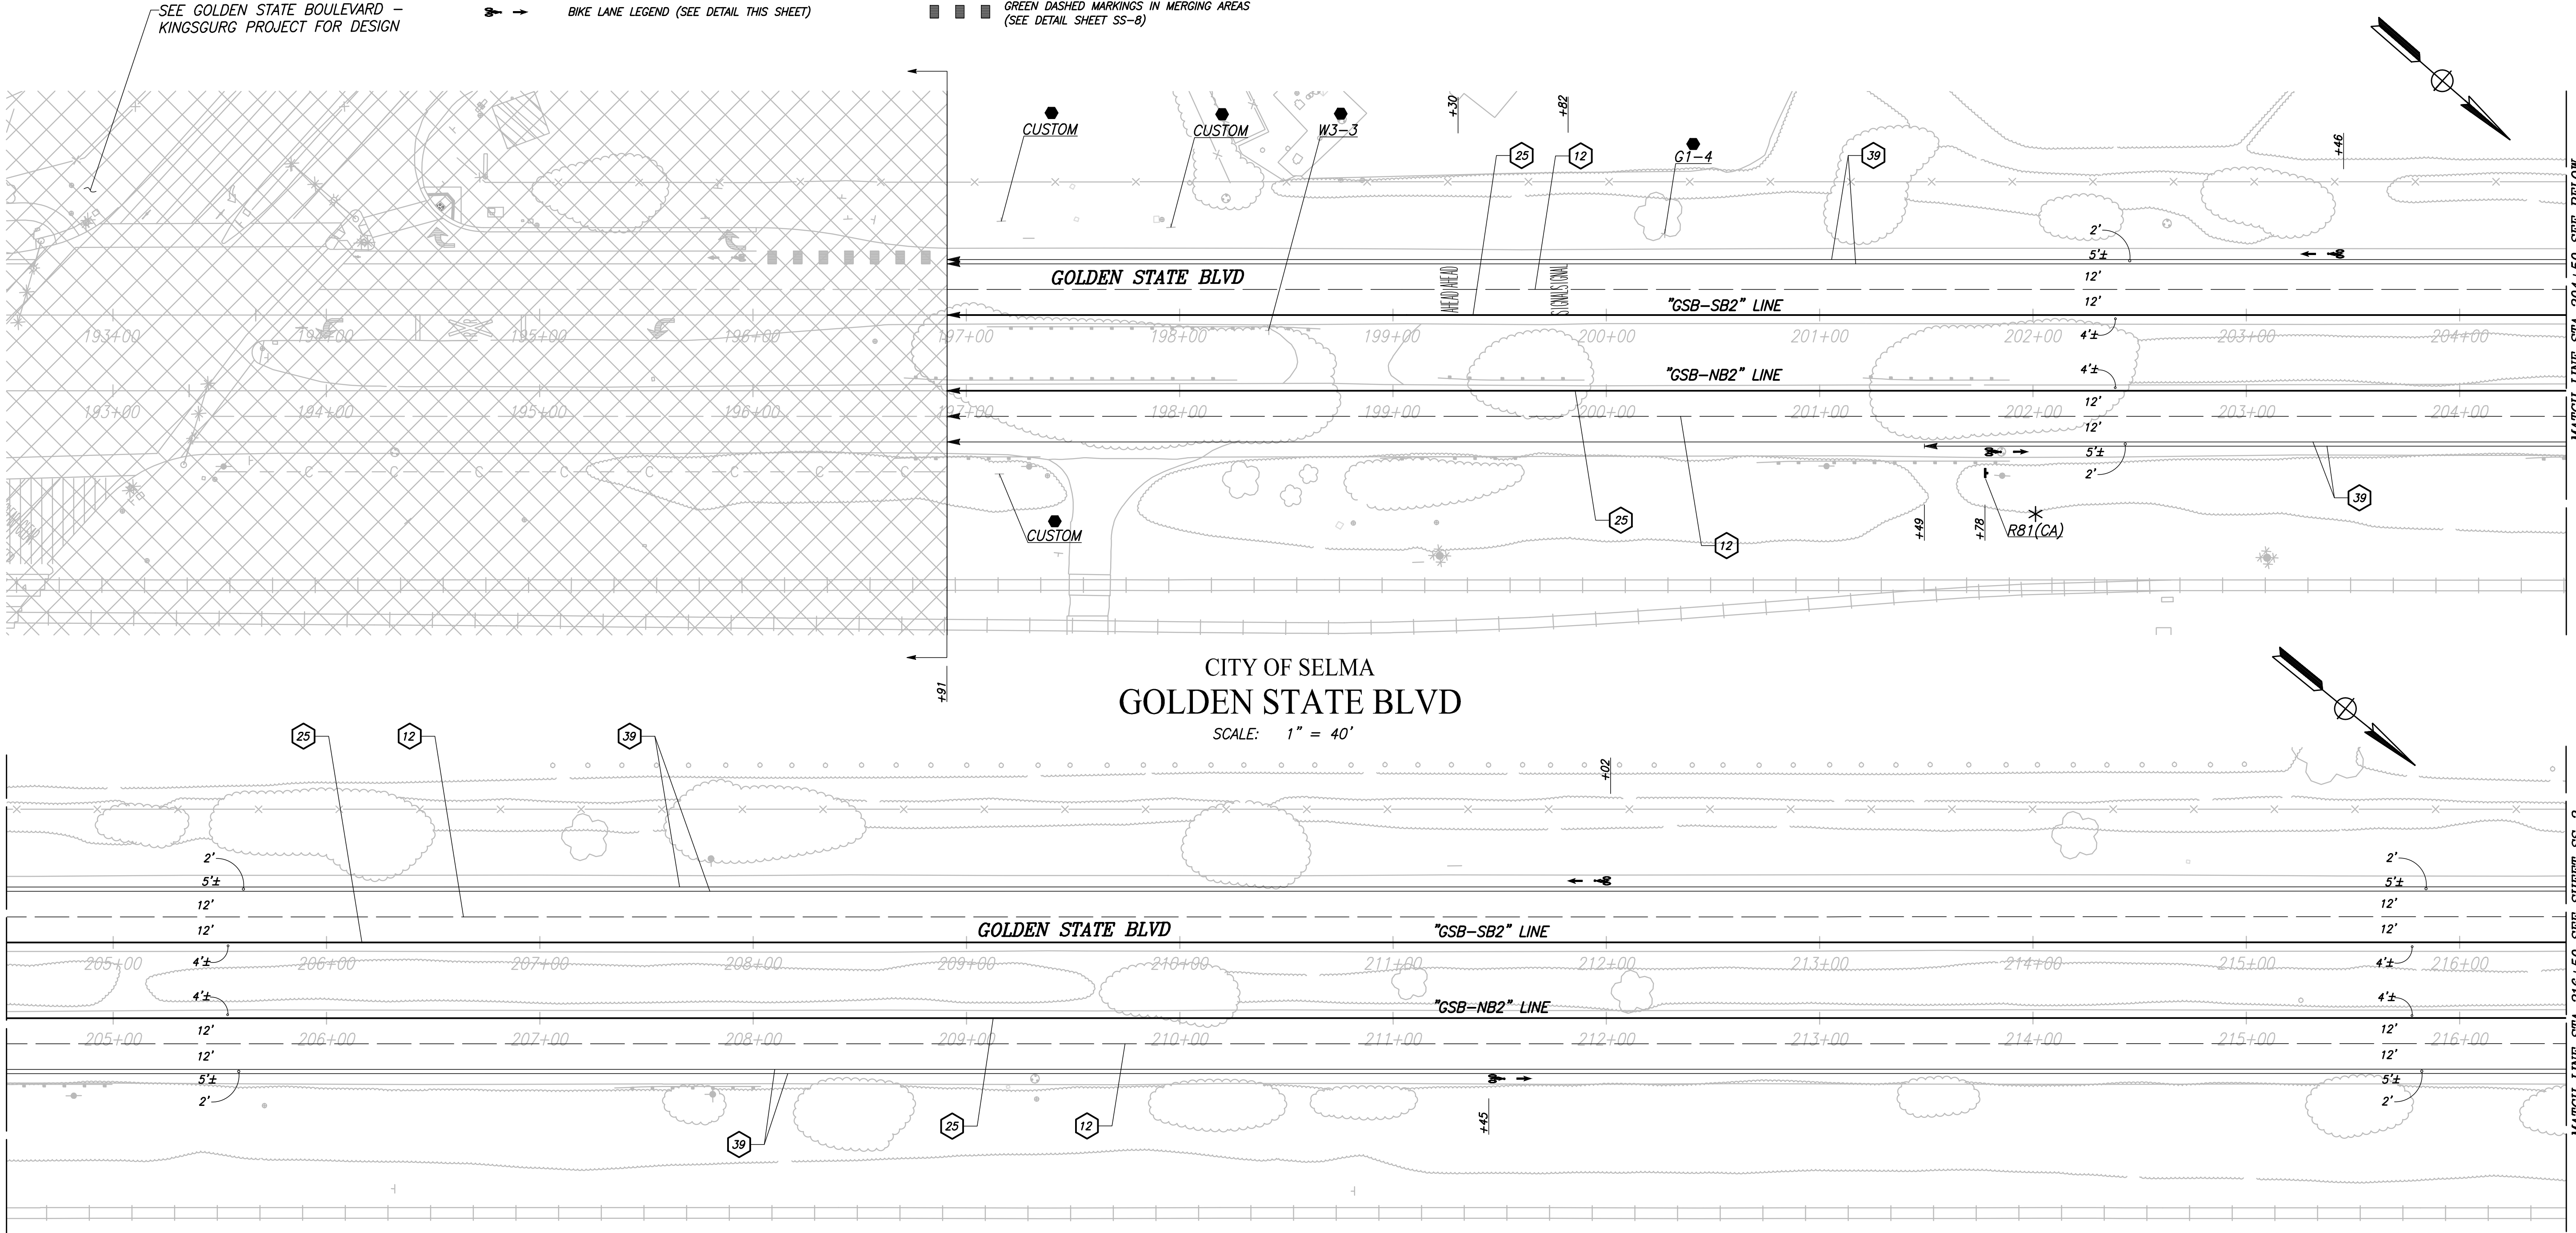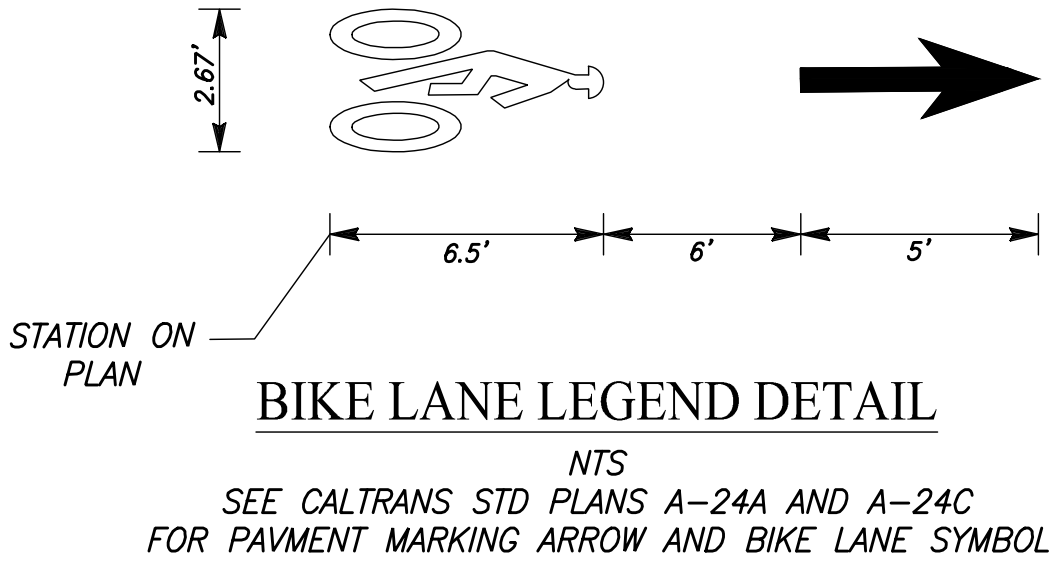

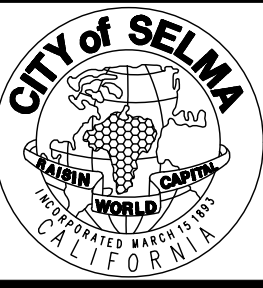DESIGNED: CYNTHIA HORNER		DATE	RECORD DRAWING	
DRAWN: DEREK MAXWELL		3/12/2021	RESIDENT ENGINEER	DATE
CHECKED: JAMES POLFER		3/12/2021		
FOR RIGHT OF WAY DATA AND ACCURATE ACCESS DETERMINATION, SEE DOCUMENTS IN THE DEPARTMENT OF PUBLIC WORKS AND PLANNING.				
				
CALL BEFORE YOU DIG		SUPERVISING ENGINEER		DATE
PROJECT		GOLDEN STATE CORRIDOR - ECONOMIC DEVELOPMENT AND INFRASTRUCTURE IMPROVEMENTS		
SELMA REGION				
DEPARTMENT OF PUBLIC WORKS AND PLANNING		SIGNING AND STRIPING		
DRAWING NO. SS-1		SHEET NO. 99		TOTAL 154

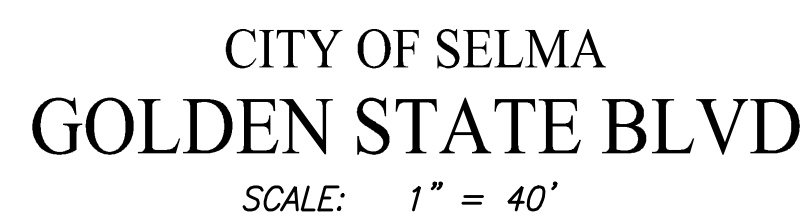


	DATE	RECORD DRAWING		 CALL BEFORE YOU DIG	 MARK THOMAS	TENTATIVE PLANS FOR DESIGN	SUPERVISING ENGINEER	DATE		PROJECT			DEPARTMENT OF PUBLIC WORKS AND PLANNING		
DESIGNED: CYNTHIA HORNER	3/12/2021	RESIDENT ENGINEER	DATE							GOLDEN STATE CORRIDOR - ECONOMIC DEVELOPMENT AND INFRASTRUCTURE IMPROVEMENTS			SIGNING AND STRIPING		
DRAWN: DEREK MAXWELL	3/12/2021														
CHECKED: JAMES POLFER	3/12/2021														
FOR RIGHT OF WAY DATA AND ACCURATE ACCESS DETERMINATION, SEE DOCUMENTS IN THE DEPARTMENT OF PUBLIC WORKS AND PLANNING.										SELMA REGION		DRAWING NO. SS-2	SHEET NO. 100	TOTAL 154	

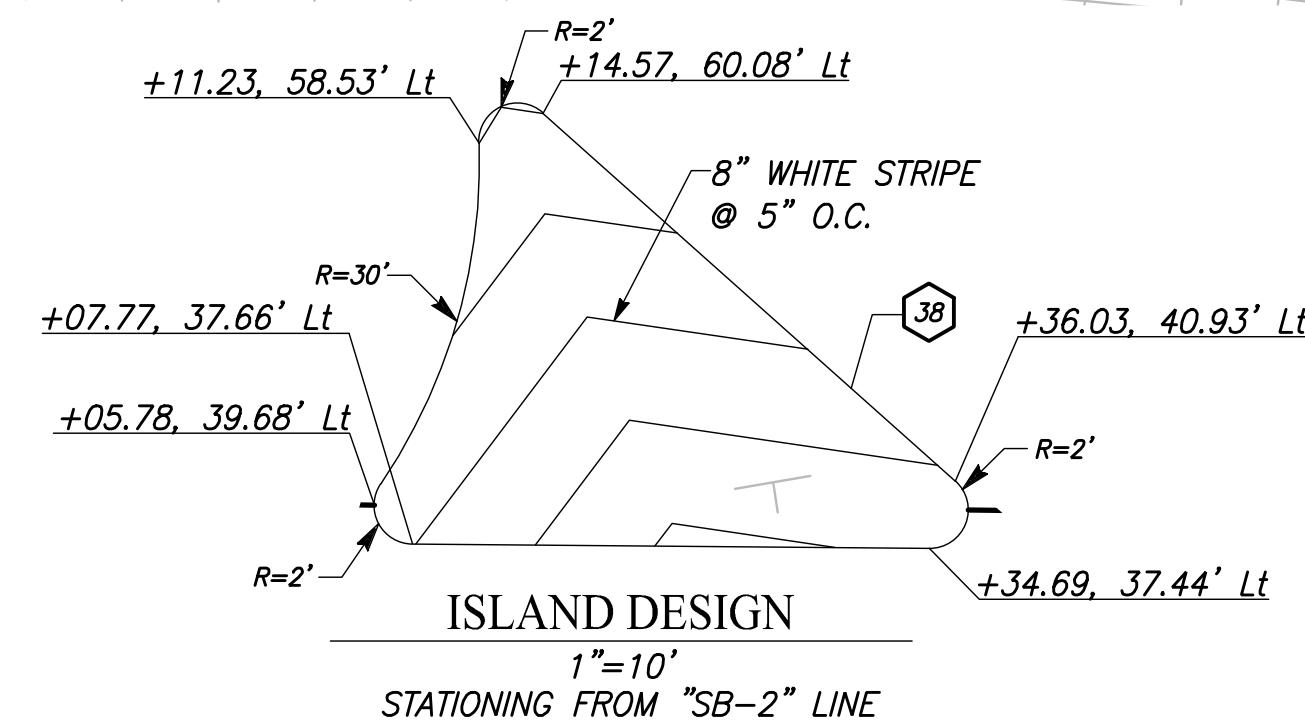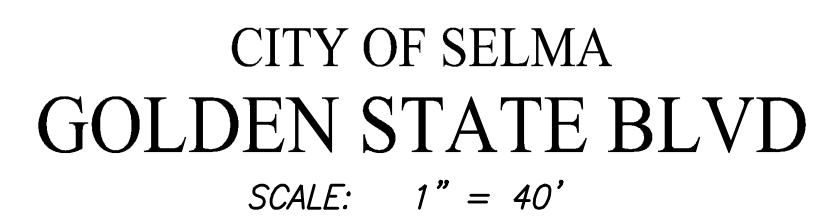

	DATE	RECORD DRAWING		 CALL BEFORE YOU DIG	 MARK THOMAS	 TENTATIVE PLANS	 TENTATIVE PLANS	PROJECT		 CITY OF SELMA	DEPARTMENT OF PUBLIC WORKS AND PLANNING			
DESIGNED: CYNTHIA HORNER	3/12/2021	RESIDENT ENGINEER	DATE					GOLDEN STATE CORRIDOR - ECONOMIC DEVELOPMENT AND INFRASTRUCTURE IMPROVEMENTS			SIGNING AND STRIPING			
DRAWN: DEREK MAXWELL	3/12/2021													
CHECKED: JAMES POLFER	3/12/2021													
FOR RIGHT OF WAY DATA AND ACCURATE ACCESS DETERMINATION, SEE DOCUMENTS IN THE DEPARTMENT OF PUBLIC WORKS AND PLANNING.						SUPERVISING ENGINEER	DATE	SELMA REGION			DRAWING NO. SS-3	SHEET NO. 101	TOTAL 154	

PATH: J:\Fresno COG-FN-16105-GSB Final Design\CADD\Sheets\Region 2 - Selma\GSB_R2_SS1-SS7.dwg
PLOT DATE: 3/12/2021 2:01:01 PM
CAD USER: ESERULVEDA

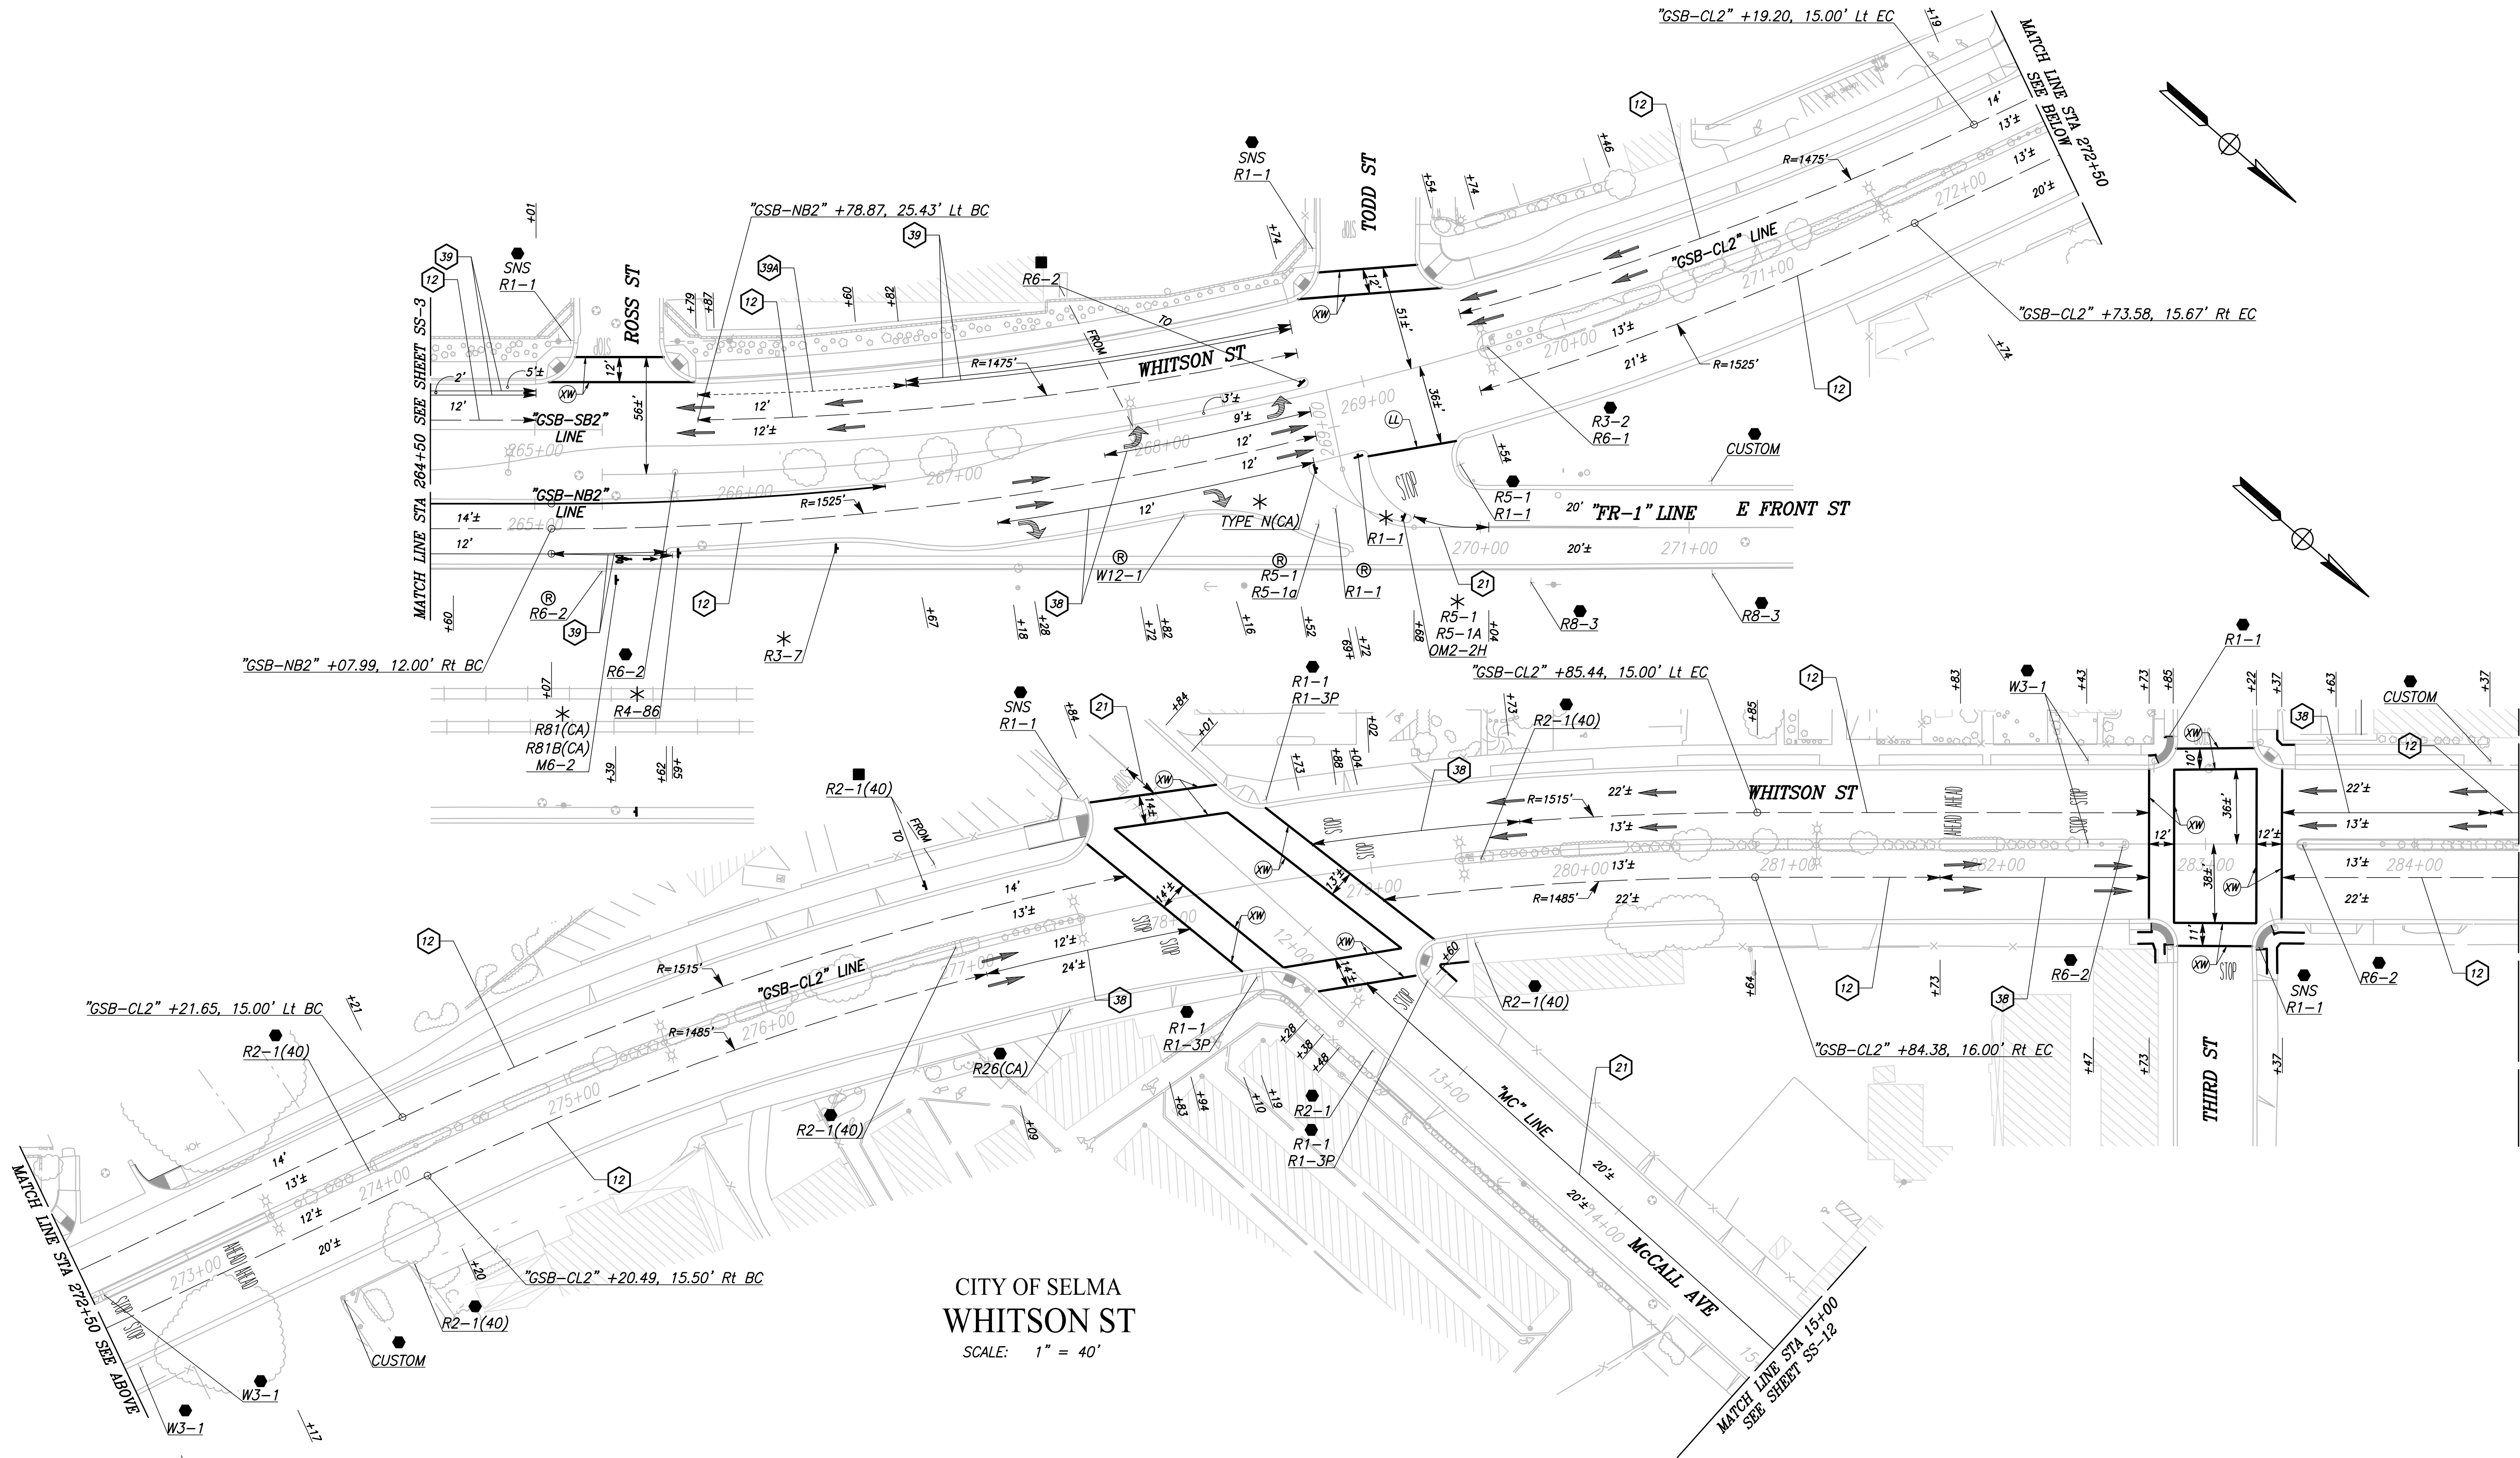

CITY OF SELMA
WHITSON ST
SCALE: 1" = 40'


RECORD DRAWING	
DESIGNED: CYNTHIA HORNER	DATE: 3/12/2021
DRAWN: DEREK MAXWELL	DATE: 3/12/2021
CHECKED: JAMES POLFER	DATE: 3/12/2021



TENTATIVE PLANS FOR DESIGN	DATE
SUPERVISING ENGINEER	




PROJECT
GOLDEN STATE CORRIDOR - ECONOMIC DEVELOPMENT AND INFRASTRUCTURE IMPROVEMENTS
SELMA REGION

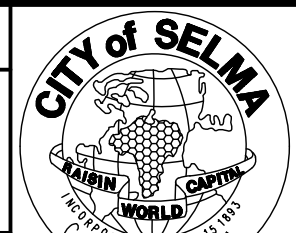


DEPARTMENT OF PUBLIC WORKS AND PLANNING		
SIGNING AND STRIPING		
DRAWING NO. SS-4	SHEET NO. 102	TOTAL 154

PLOT DATE: 3/12/2021 2:01:22 PM CAD USER: ESPRILVEDA

PATH: J:\Fresno COG-FN-16105-GSB Final Design\CADD\Sheets\Region 2 - Selma\GSB_R2_SS1-SS7.dwg

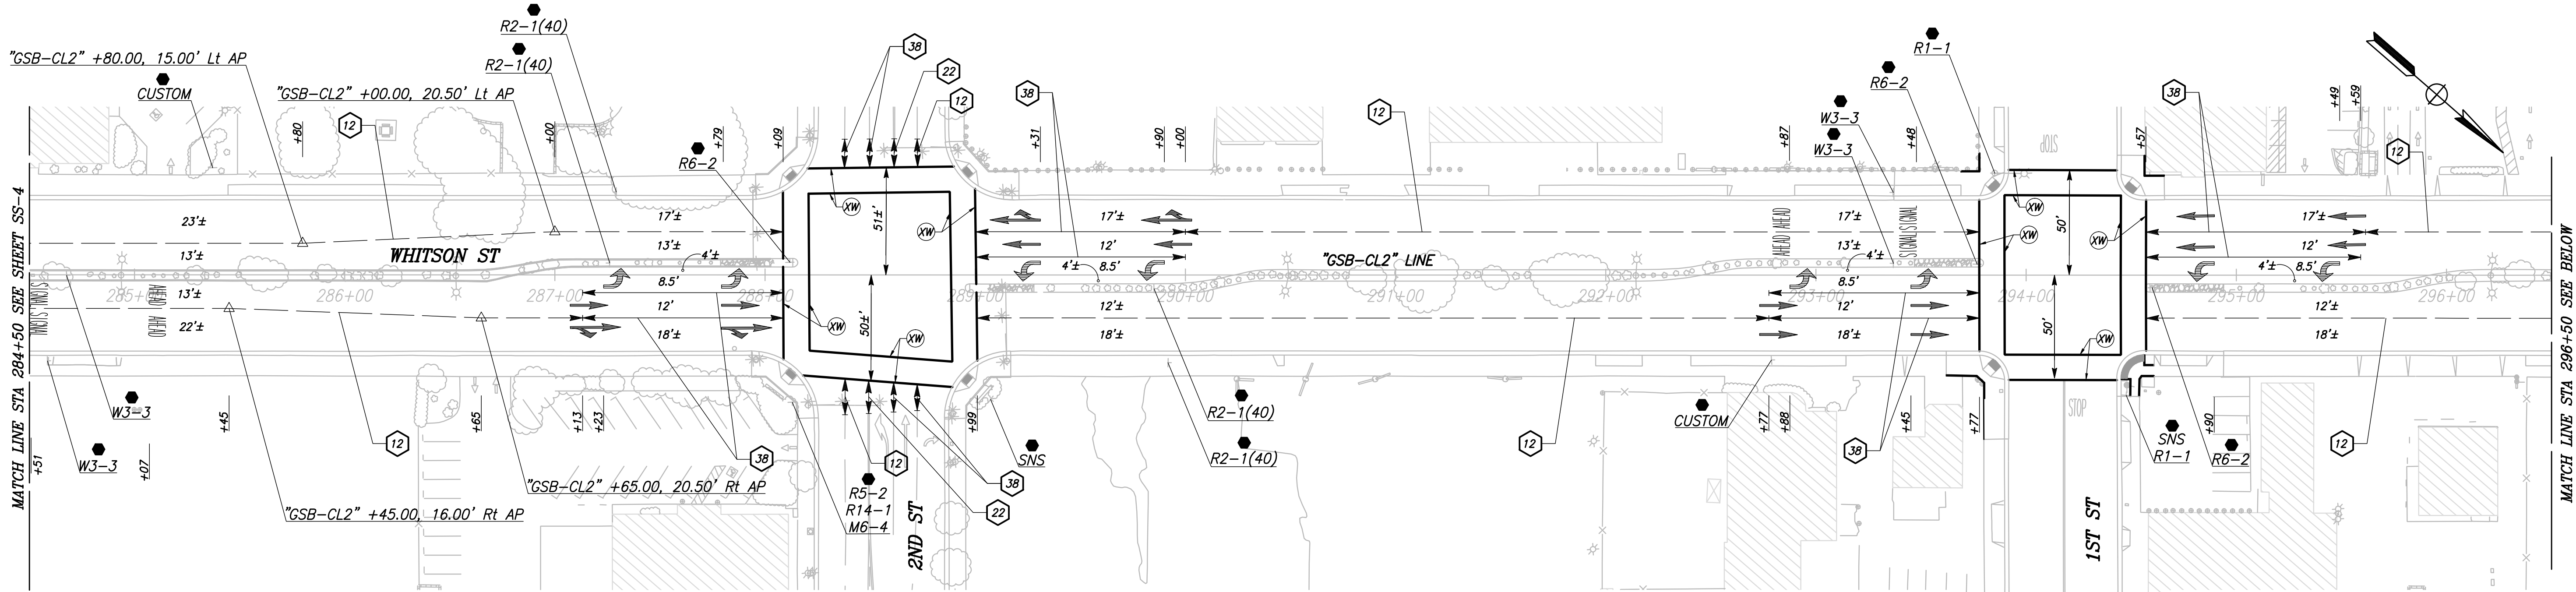


CITY OF SELMA
GOLDEN STATE BLVD
SCALE: 1" = 40'

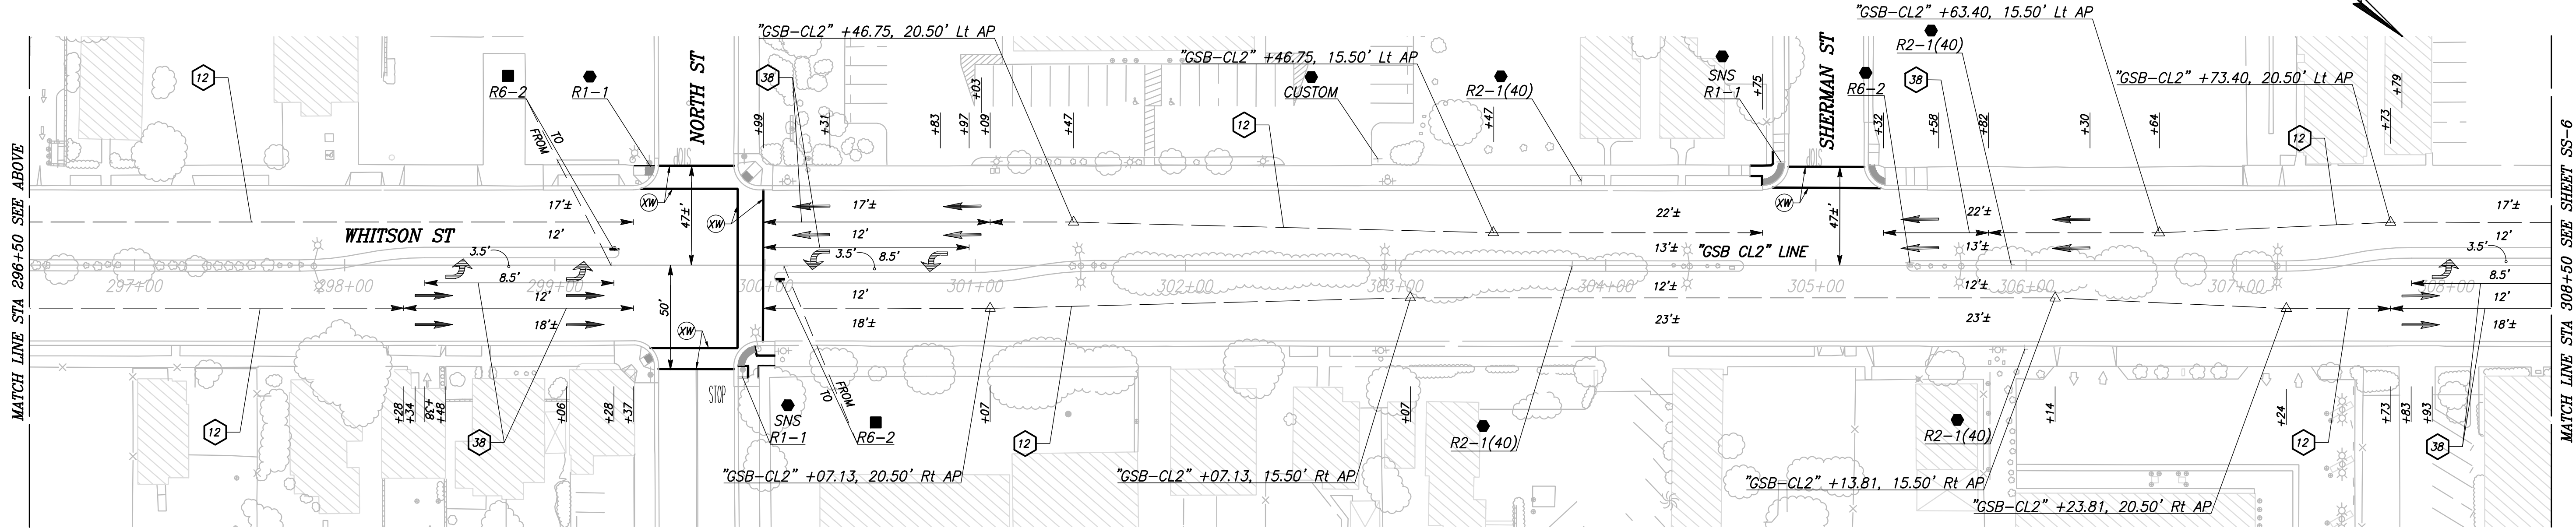

RECORD DRAWING	
DESIGNED: CYNTHIA HORNER	DATE: 3/12/2021
DRAWN: DEREK MAXWELL	DATE: 3/12/2021
CHECKED: JAMES POLFER	DATE: 3/12/2021


FOR RIGHT OF WAY DATA AND ACCURATE ACCESS DETERMINATION, SEE DOCUMENTS IN THE DEPARTMENT OF PUBLIC WORKS AND PLANNING.

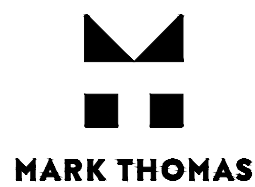


TENTATIVE PLANS FOR DESIGN	DATE: 3/30/21
SUPERVISING ENGINEER	DATE: 3/30/21




PROJECT
GOLDEN STATE CORRIDOR - ECONOMIC DEVELOPMENT AND INFRASTRUCTURE IMPROVEMENTS
SELMA REGION

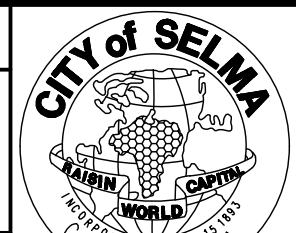

DEPARTMENT OF PUBLIC WORKS AND PLANNING		
SIGNING AND STRIPING		
DRAWING NO. SS-5	SHEET NO. 103	TOTAL 154

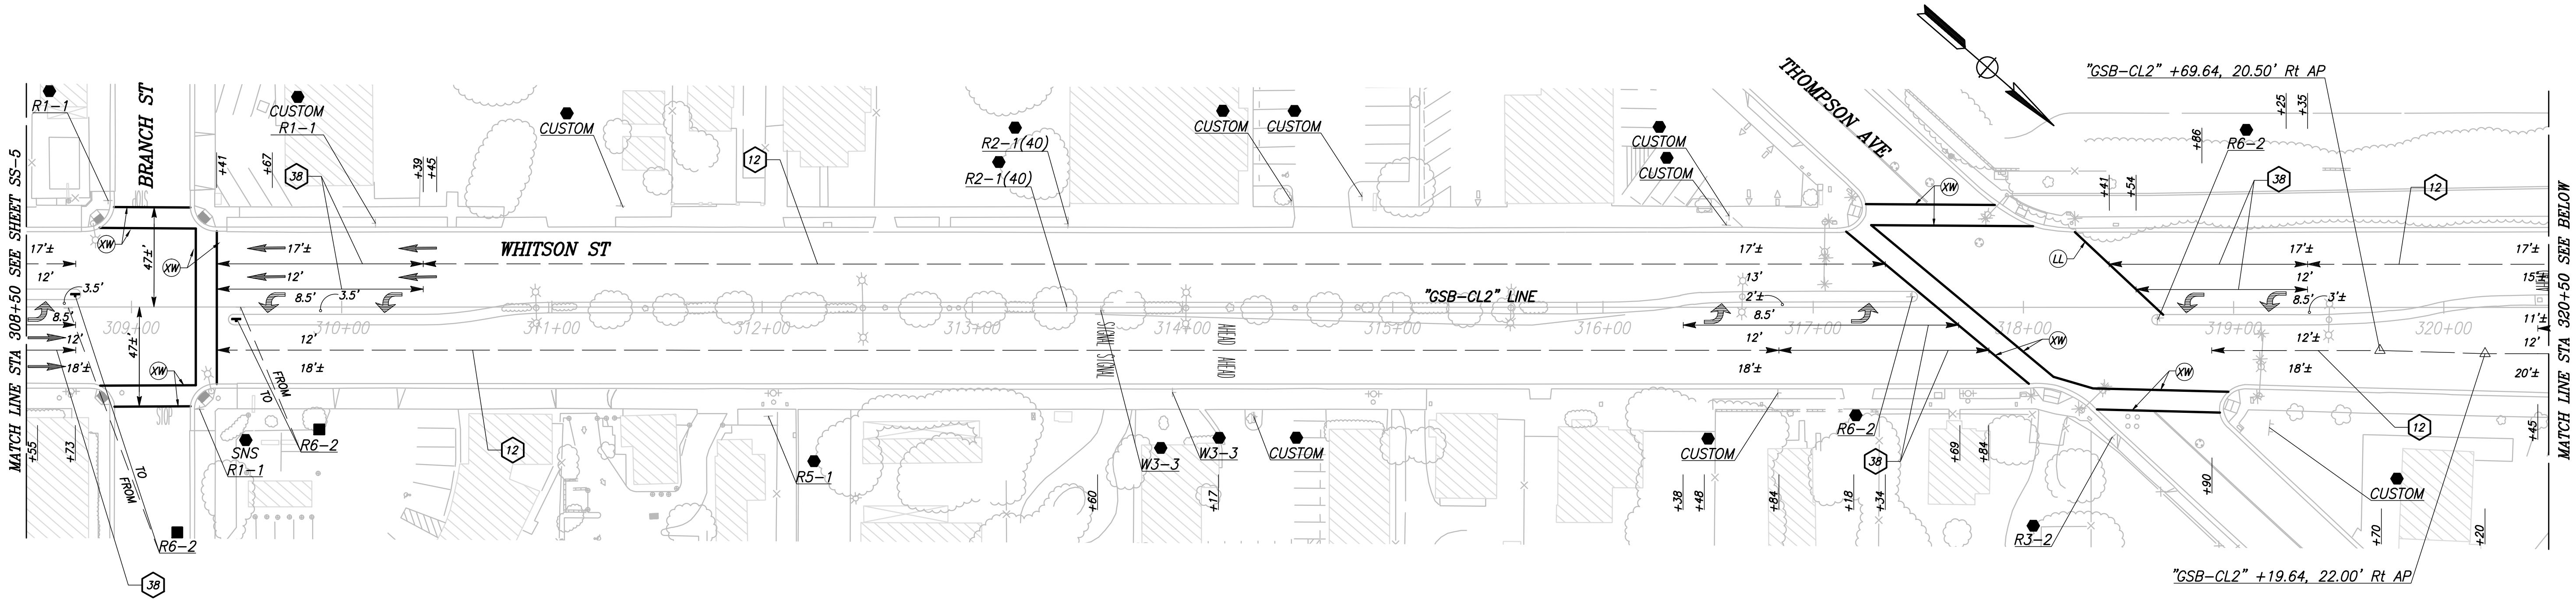

CITY OF SELMA
GOLDEN STATE BLVD
SCALE: 1" = 40'

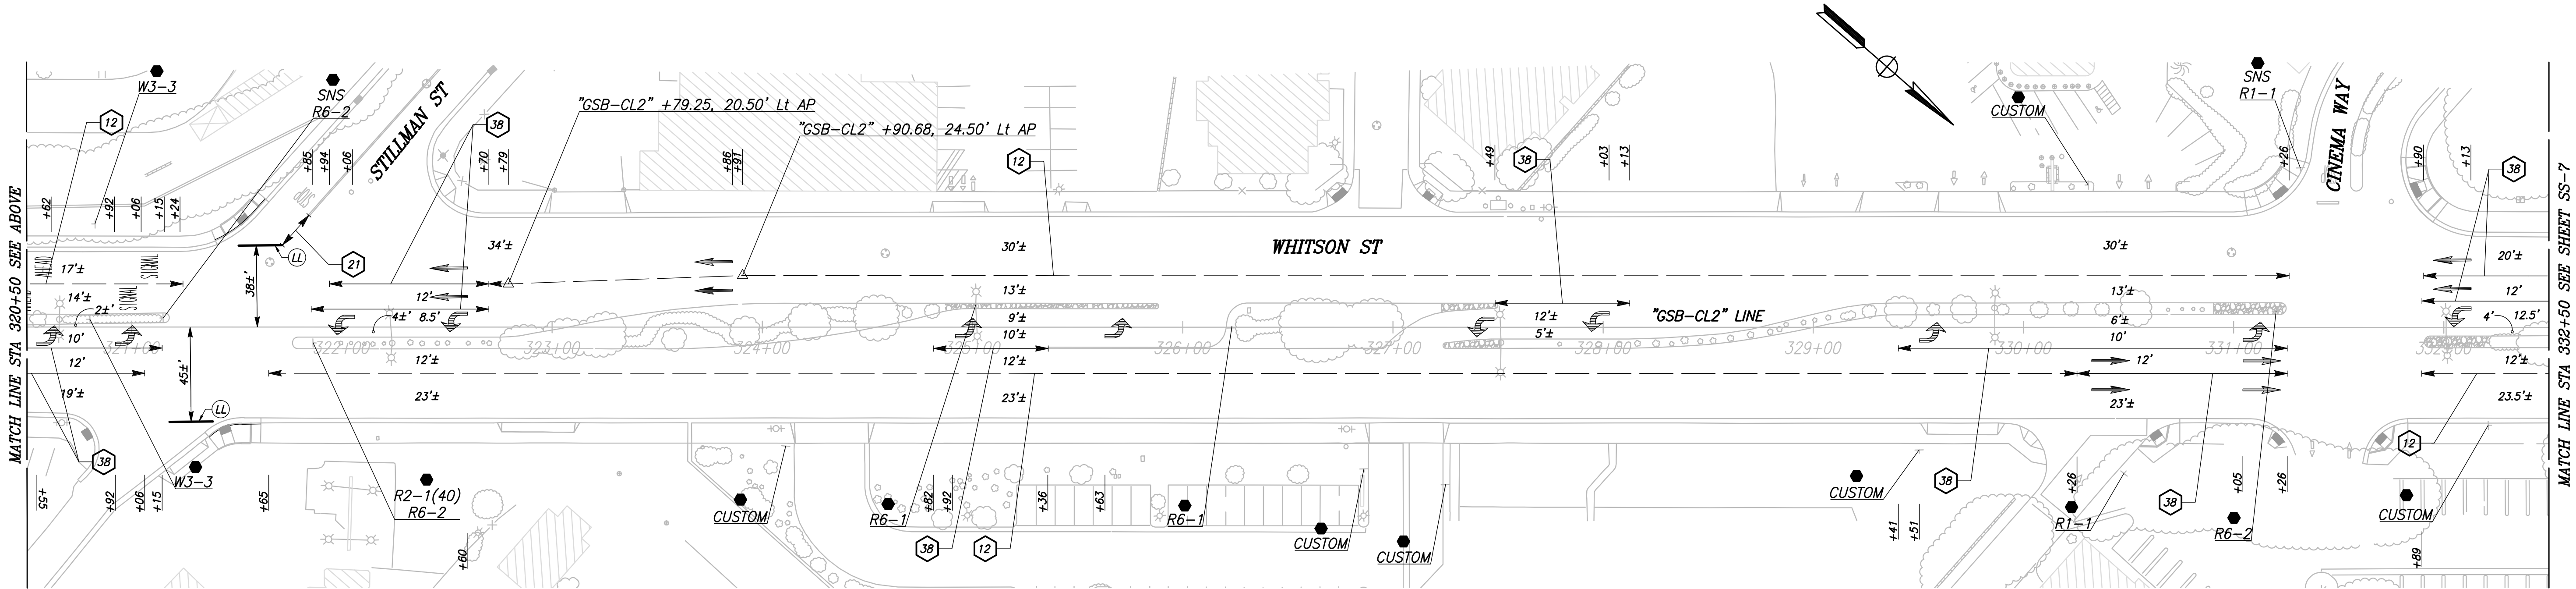

RECORD DRAWING	
DESIGNED: CYNTHIA HORNER	DATE: 3/12/2021
DRAWN: DEREK MAXWELL	DATE: 3/12/2021
CHECKED: JAMES POLFER	DATE: 3/12/2021

FOR RIGHT OF WAY DATA AND ACCURATE ACCESS DETERMINATION, SEE DOCUMENTS IN THE DEPARTMENT OF PUBLIC WORKS AND PLANNING.




TENTATIVE PLANS FOR DESIGN
SUPERVISING ENGINEER
DATE: 3/30/21




PROJECT
GOLDEN STATE CORRIDOR - ECONOMIC DEVELOPMENT AND INFRASTRUCTURE IMPROVEMENTS
SELMA REGION



DEPARTMENT OF PUBLIC WORKS AND PLANNING
SIGNING AND STRIPING
DRAWING NO. SS-6
SHEET NO. 104
TOTAL 154

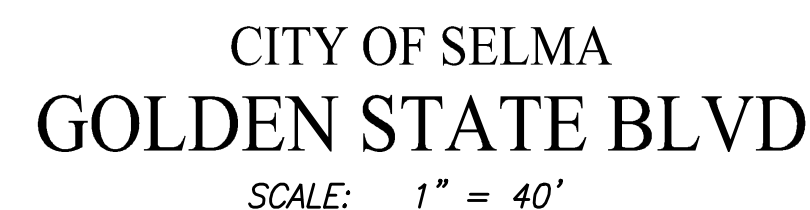


	DATE	RECORD DRAWING		  	PROJECT			DEPARTMENT OF PUBLIC WORKS AND PLANNING	
DESIGNED: CYNTHIA HORNER	3/12/2021	RESIDENT ENGINEER	DATE		GOLDEN STATE CORRIDOR - ECONOMIC DEVELOPMENT AND INFRASTRUCTURE IMPROVEMENTS			SIGNING AND STRIPING	
DRAWN: DEREK MAXWELL	3/12/2021								
CHECKED: JAMES POLFER	3/12/2021								
FOR RIGHT OF WAY DATA AND ACCURATE ACCESS DETERMINATION, SEE DOCUMENTS IN THE DEPARTMENT OF PUBLIC WORKS AND PLANNING.				CALL BEFORE YOU DIG		DATE	SELMA REGION		DRAWING NO. SS-7 SHEET NO. 105 TOTAL 154

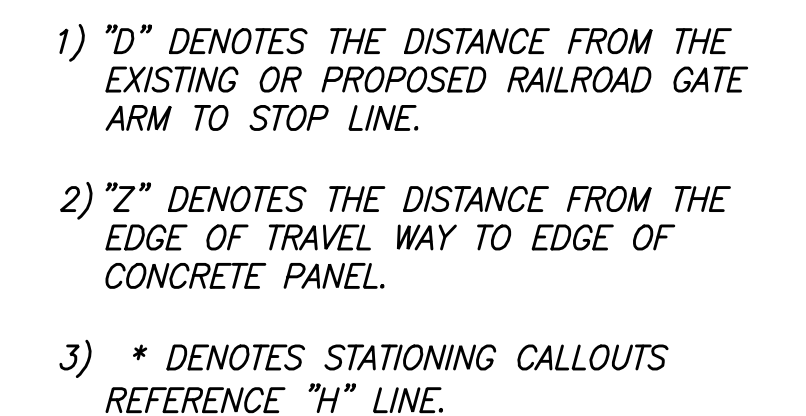


	DATE	RECORD DRAWING					PROJECT			DEPARTMENT OF PUBLIC WORKS AND PLANNING		
DESIGNED: CYNTHIA HORNER	3/12/2021	RESIDENT ENGINEER	DATE				GOLDEN STATE CORRIDOR - ECONOMIC DEVELOPMENT AND INFRASTRUCTURE IMPROVEMENTS			SIGNING AND STRIPING		
DRAWN: DEREK MAXWELL	3/12/2021						SELMA REGION			DRAWING NO. SS-8 SHEET NO. 106 TOTAL 154		
CHECKED: JAMES POLFER	3/12/2021											
FOR RIGHT OF WAY DATA AND ACCURATE ACCESS DETERMINATION, SEE DOCUMENTS IN THE DEPARTMENT OF PUBLIC WORKS AND PLANNING.					CALL BEFORE YOU DIG							

PLOT DATE: 3/12/2021 2:03:16 PM CAD USER: THARDY

PATH: J:\Fresno COG-FN-16105-GSB Final Design\CADD Sheets\Region 2 - Selma\GSB_R2_SS8-SS13.dwg

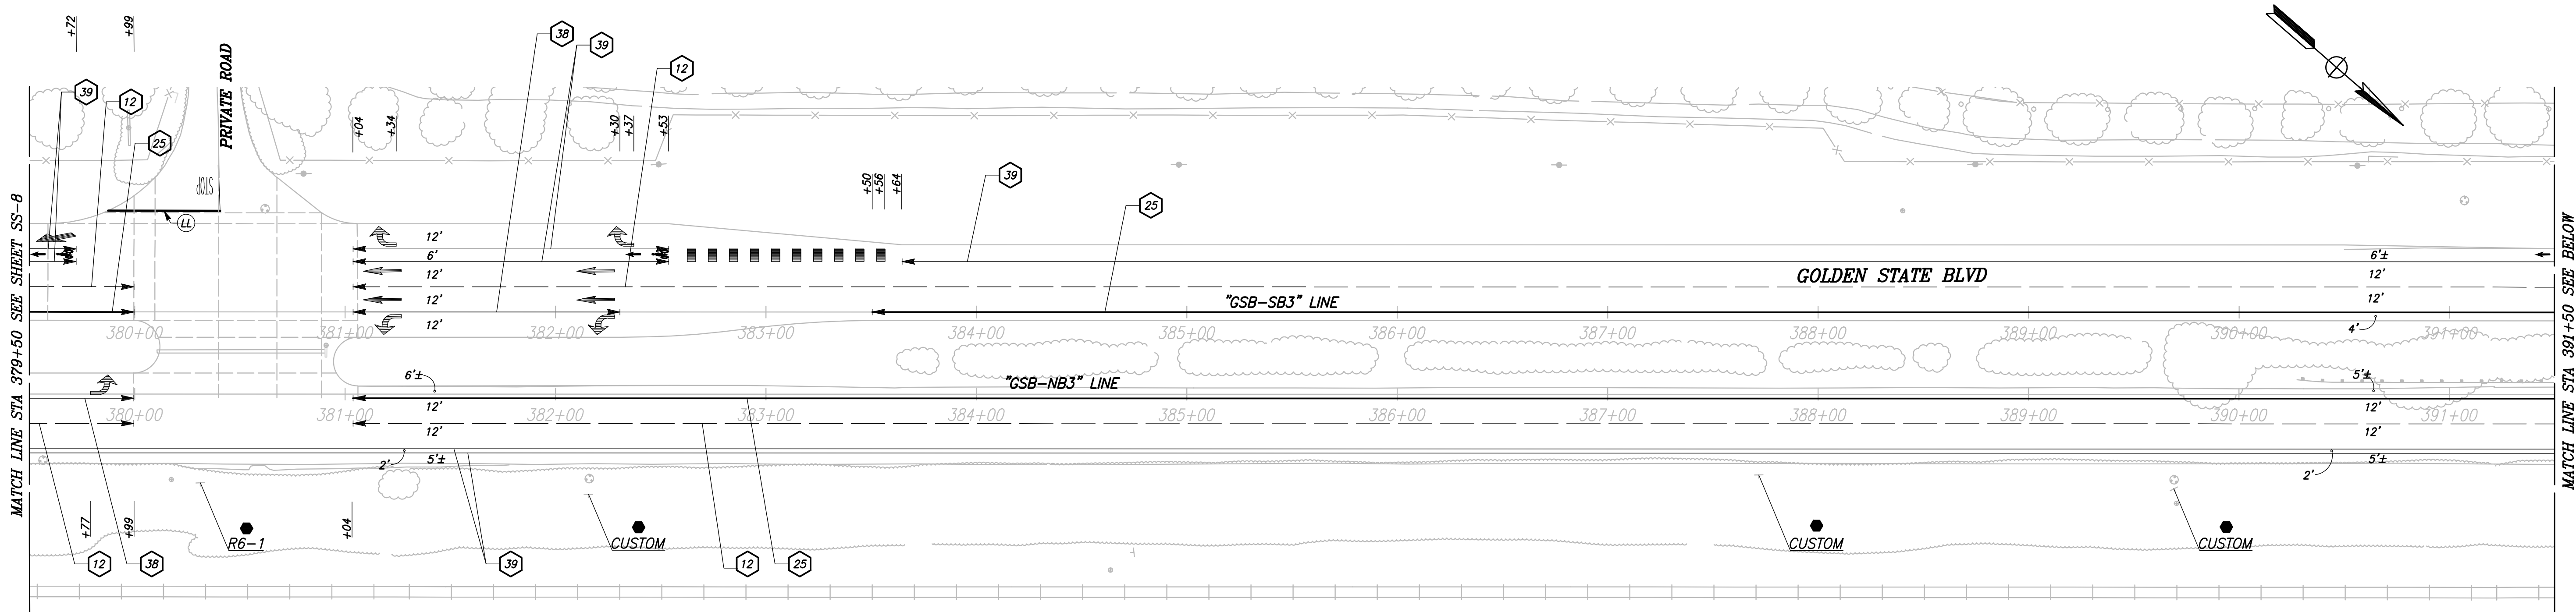

CITY OF SELMA
GOLDEN STATE BLVD
SCALE: 1" = 40'

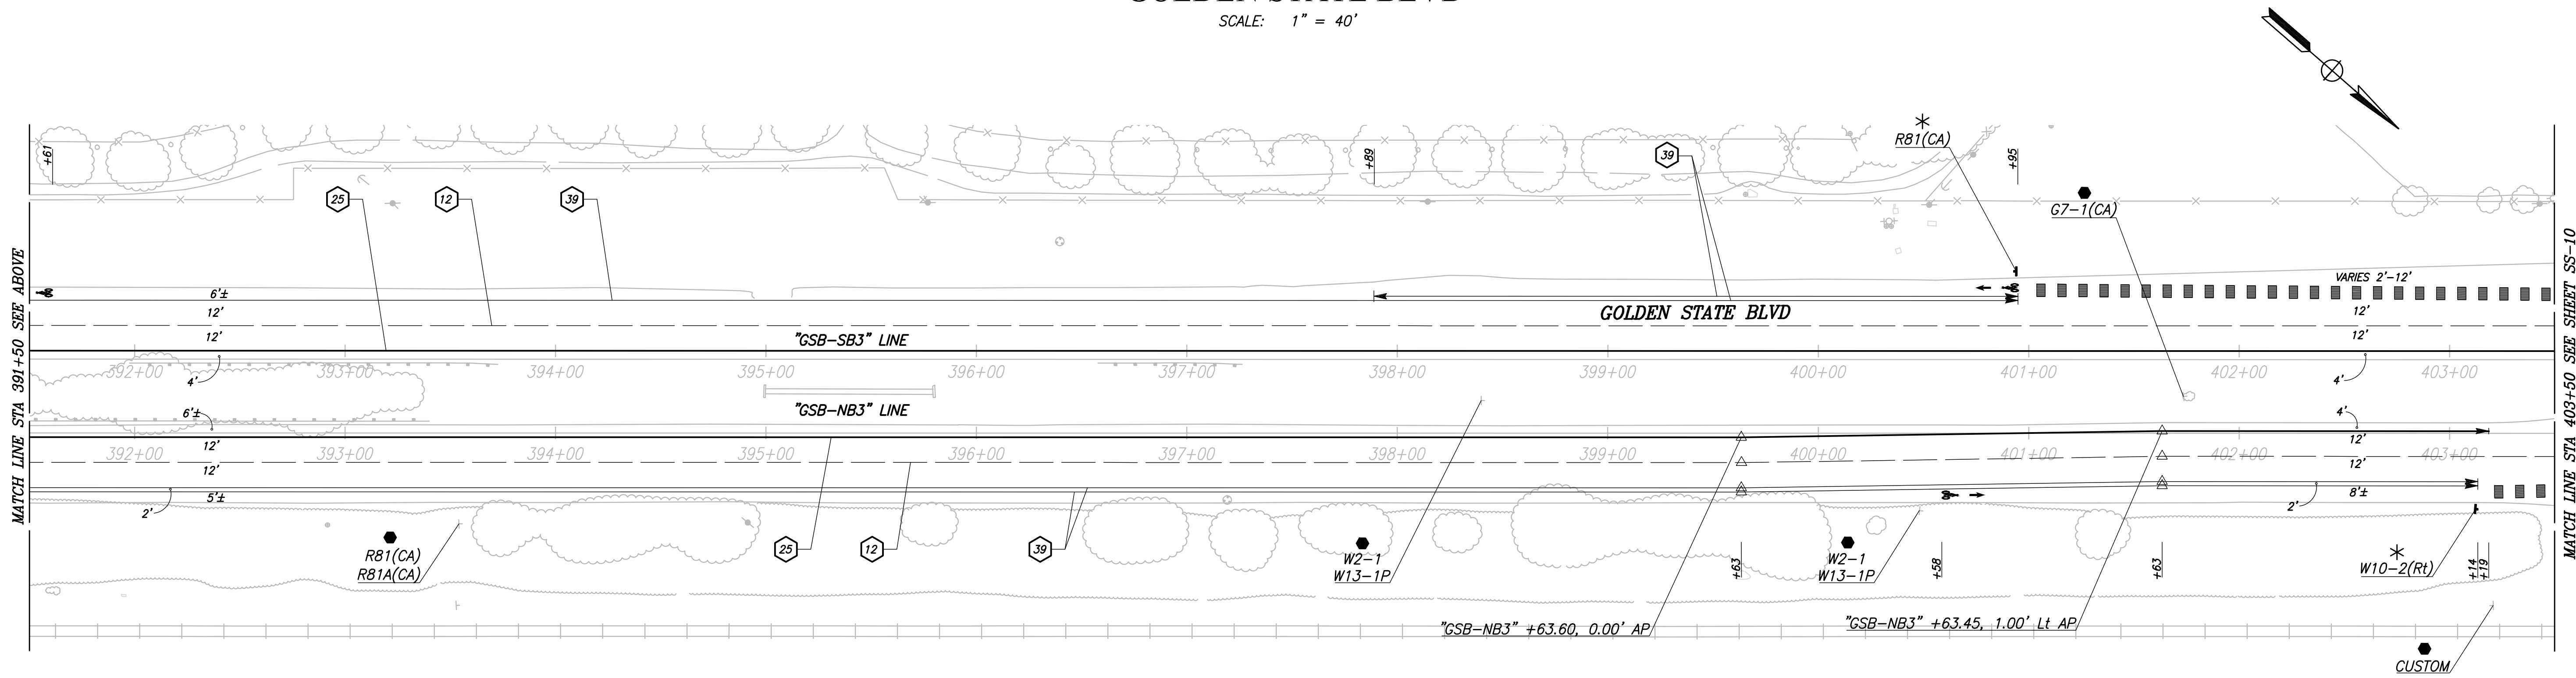

RECORD DRAWING	
DESIGNED: CYNTHIA HORNER	DATE: 3/12/2021
DRAWN: DEREK MAXWELL	DATE: 3/12/2021
CHECKED: JAMES POLFER	DATE: 3/12/2021


FOR RIGHT OF WAY DATA AND ACCURATE ACCESS DETERMINATION, SEE DOCUMENTS IN THE DEPARTMENT OF PUBLIC WORKS AND PLANNING.



TENTATIVE PLANS FOR DESIGN
SUPERVISING ENGINEER
DATE



PROJECT
GOLDEN STATE CORRIDOR - ECONOMIC DEVELOPMENT AND INFRASTRUCTURE IMPROVEMENTS
SELMA REGION

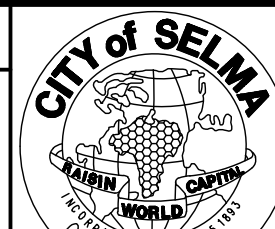


DEPARTMENT OF PUBLIC WORKS AND PLANNING
SIGNING AND STRIPING

DRAWING NO. SS-9 SHEET NO. 107 TOTAL 154

- 1) "D" DENOTES THE DISTANCE FROM THE EXISTING OR PROPOSED RAILROAD GATE ARM TO RR STOP LINE.
- 2) "Z" DENOTES THE DISTANCE FROM THE EDGE OF TRAVEL WAY TO EDGE OF CONCRETE PANEL




		DATE		RECORD DRAWING		 CALL BEFORE YOU DIG	 MARK THOMAS		PROJECT			DEPARTMENT OF PUBLIC WORKS AND PLANNING							
DESIGNED: CYNTHIA HORNER		3/12/2021		RESIDENT ENGINEER					DATE			GOLDEN STATE CORRIDOR - ECONOMIC DEVELOPMENT AND INFRASTRUCTURE IMPROVEMENTS		SIGNING AND STRIPING					
DRAWN: DEREK MAXWELL		3/12/2021																	
CHECKED: JAMES POLFER		3/12/2021																	
FOR RIGHT OF WAY DATA AND ACCURATE ACCESS DETERMINATION, SEE DOCUMENTS IN THE DEPARTMENT OF PUBLIC WORKS AND PLANNING.								SUPERVISING ENGINEER		DATE		SELMA REGION		DRAWING NO. SS-10		SHEET NO. 108		TOTAL 154	

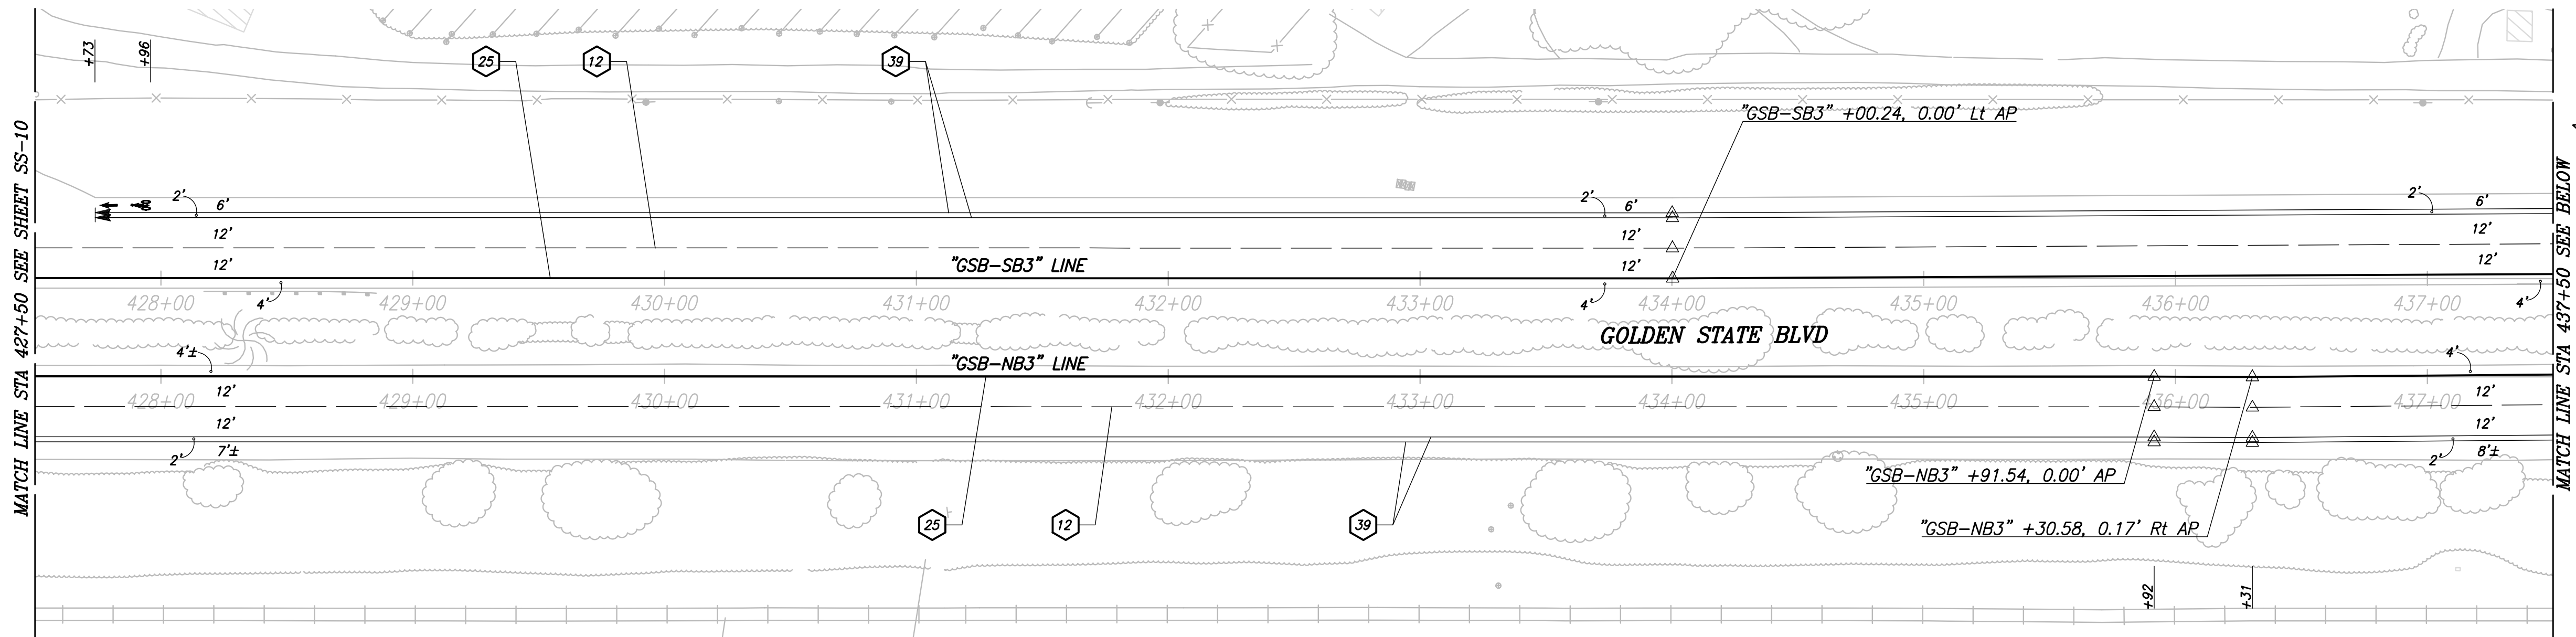


CITY OF SELMA
GOLDEN STATE BLVD
SCALE: 1" = 40'

NOTES: FOR THIS SHEET ONLY

- 1) "D" DENOTES THE DISTANCE FROM THE EXISTING OR PROPOSED RAILROAD GATE ARM TO RR STOP LINE.
2) "Z" DENOTES THE DISTANCE FROM THE EDGE OF TRAVEL WAY TO EDGE OF CONCRETE PANEL



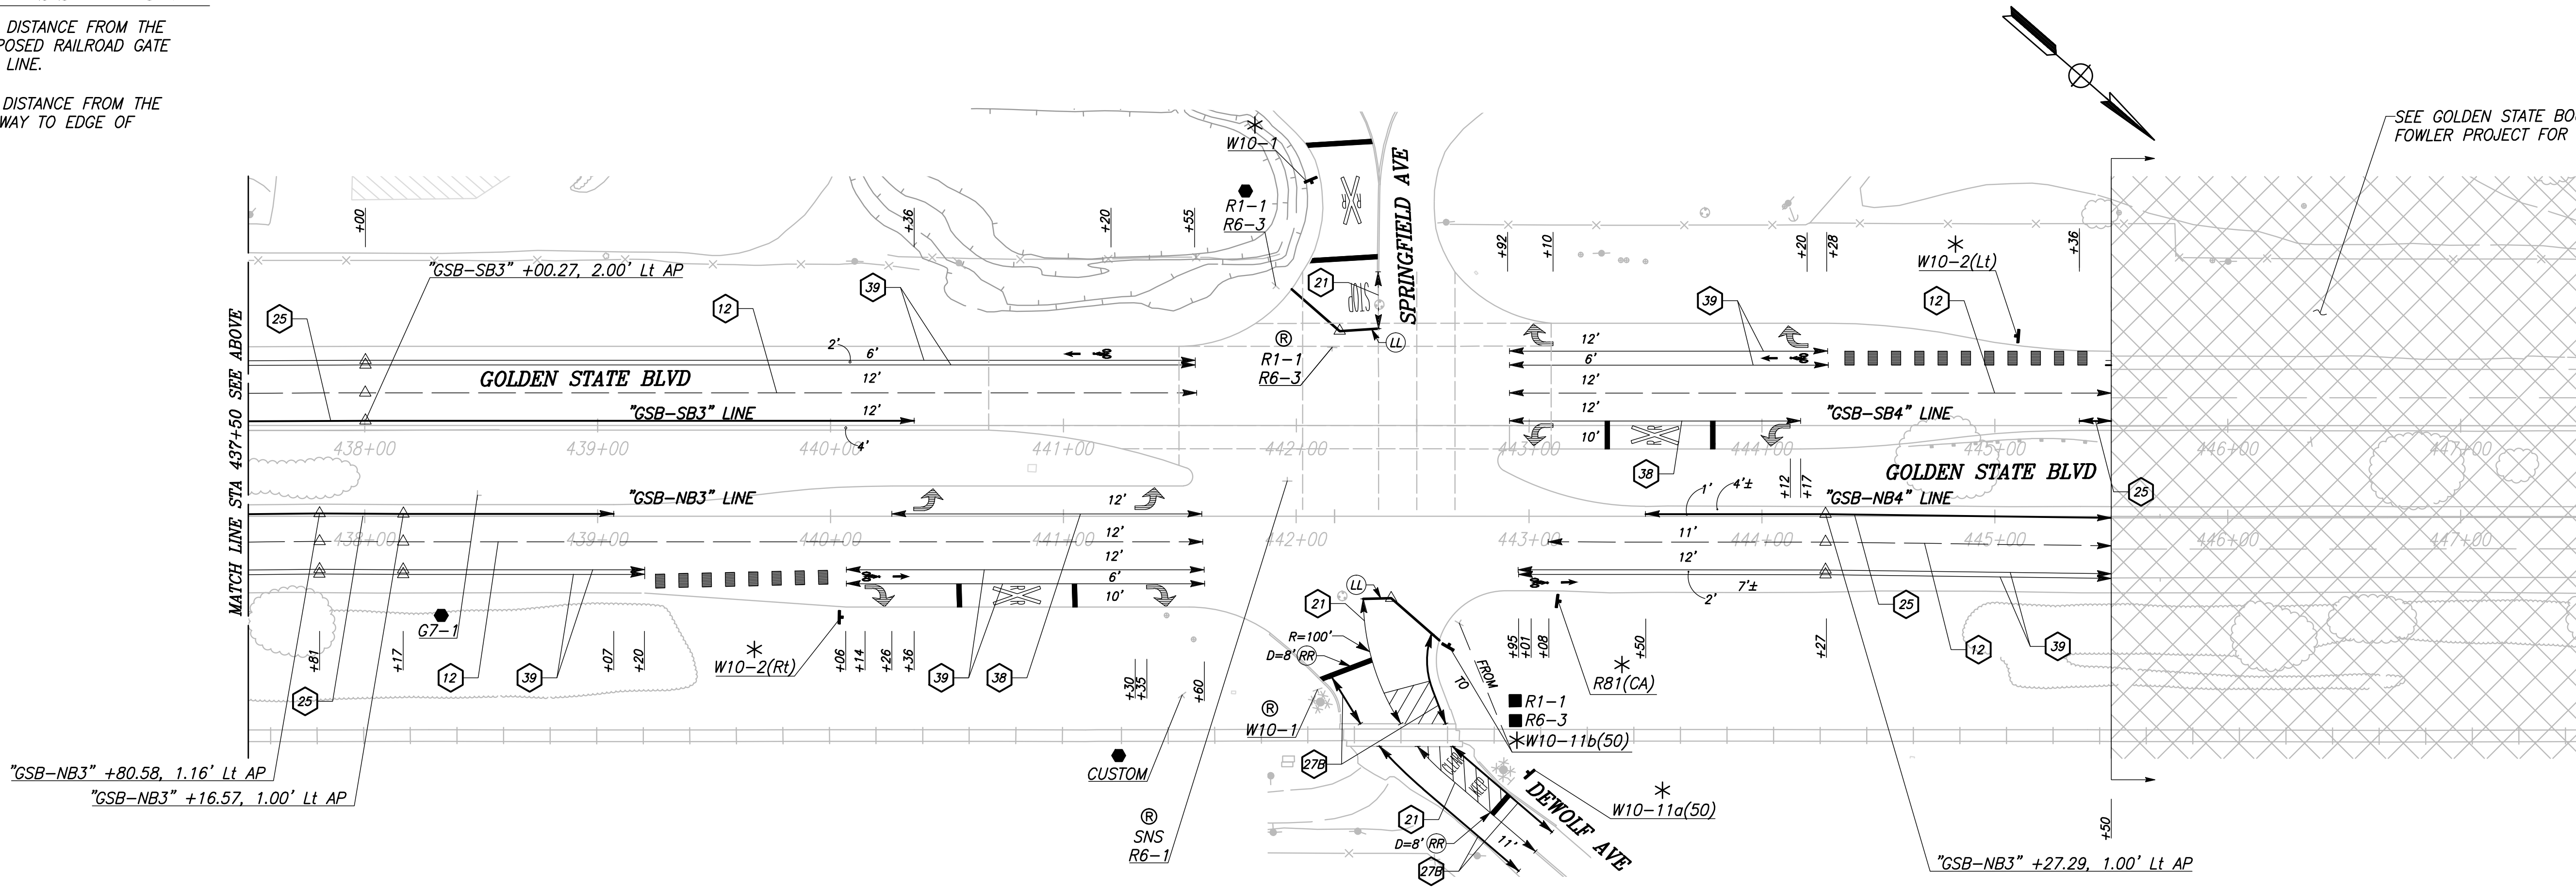


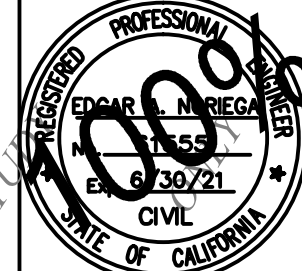DESIGNED: CYNTHIA HORNER		DATE	RECORD DRAWING	
DRAWN: DEREK MAXWELL		3/12/2021	RESIDENT ENGINEER	DATE
CHECKED: JAMES POLFER		3/12/2021		
FOR RIGHT OF WAY DATA AND ACCURATE ACCESS DETERMINATION, SEE DOCUMENTS IN THE DEPARTMENT OF PUBLIC WORKS AND PLANNING.				
				
CALL BEFORE YOU DIG		SUPERVISING ENGINEER		DATE
TENTATIVE PLANS FOR DESIGN		PROJECT		GOLDEN STATE CORRIDOR - ECONOMIC DEVELOPMENT AND INFRASTRUCTURE IMPROVEMENTS
		SELMA REGION		
		DEPARTMENT OF PUBLIC WORKS AND PLANNING		SIGNING AND STRIPING
DRAWING NO. SS-11		SHEET NO. 109		TOTAL 154

PATH:\J:\Fresno COG-FN-16105-GSB Final Design\CADD\Sheets\Region 2 - Selma\GSB_R2_SS8-SS13.dwg PLOT DATE: 3/12/2021 2:04:16 PM CAD USER: THARDY

NOTES: FOR THIS SHEET ONLY

- 1) "D" DENOTES THE DISTANCE FROM THE EXISTING OR PROPOSED RAILROAD GATE ARM TO RR STOP LINE.
- 2) "Z" DENOTES THE DISTANCE FROM THE EDGE OF TRAVEL WAY TO EDGE OF CONCRETE PANEL

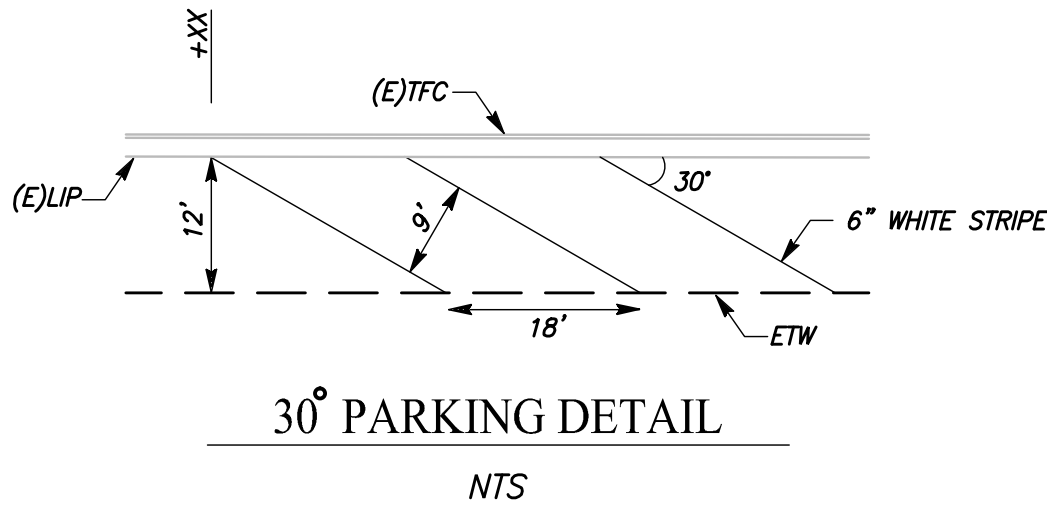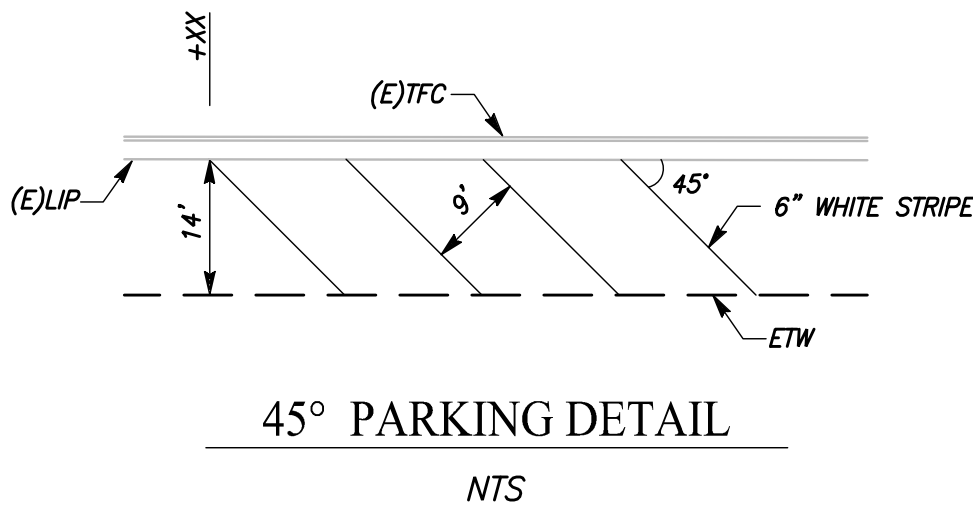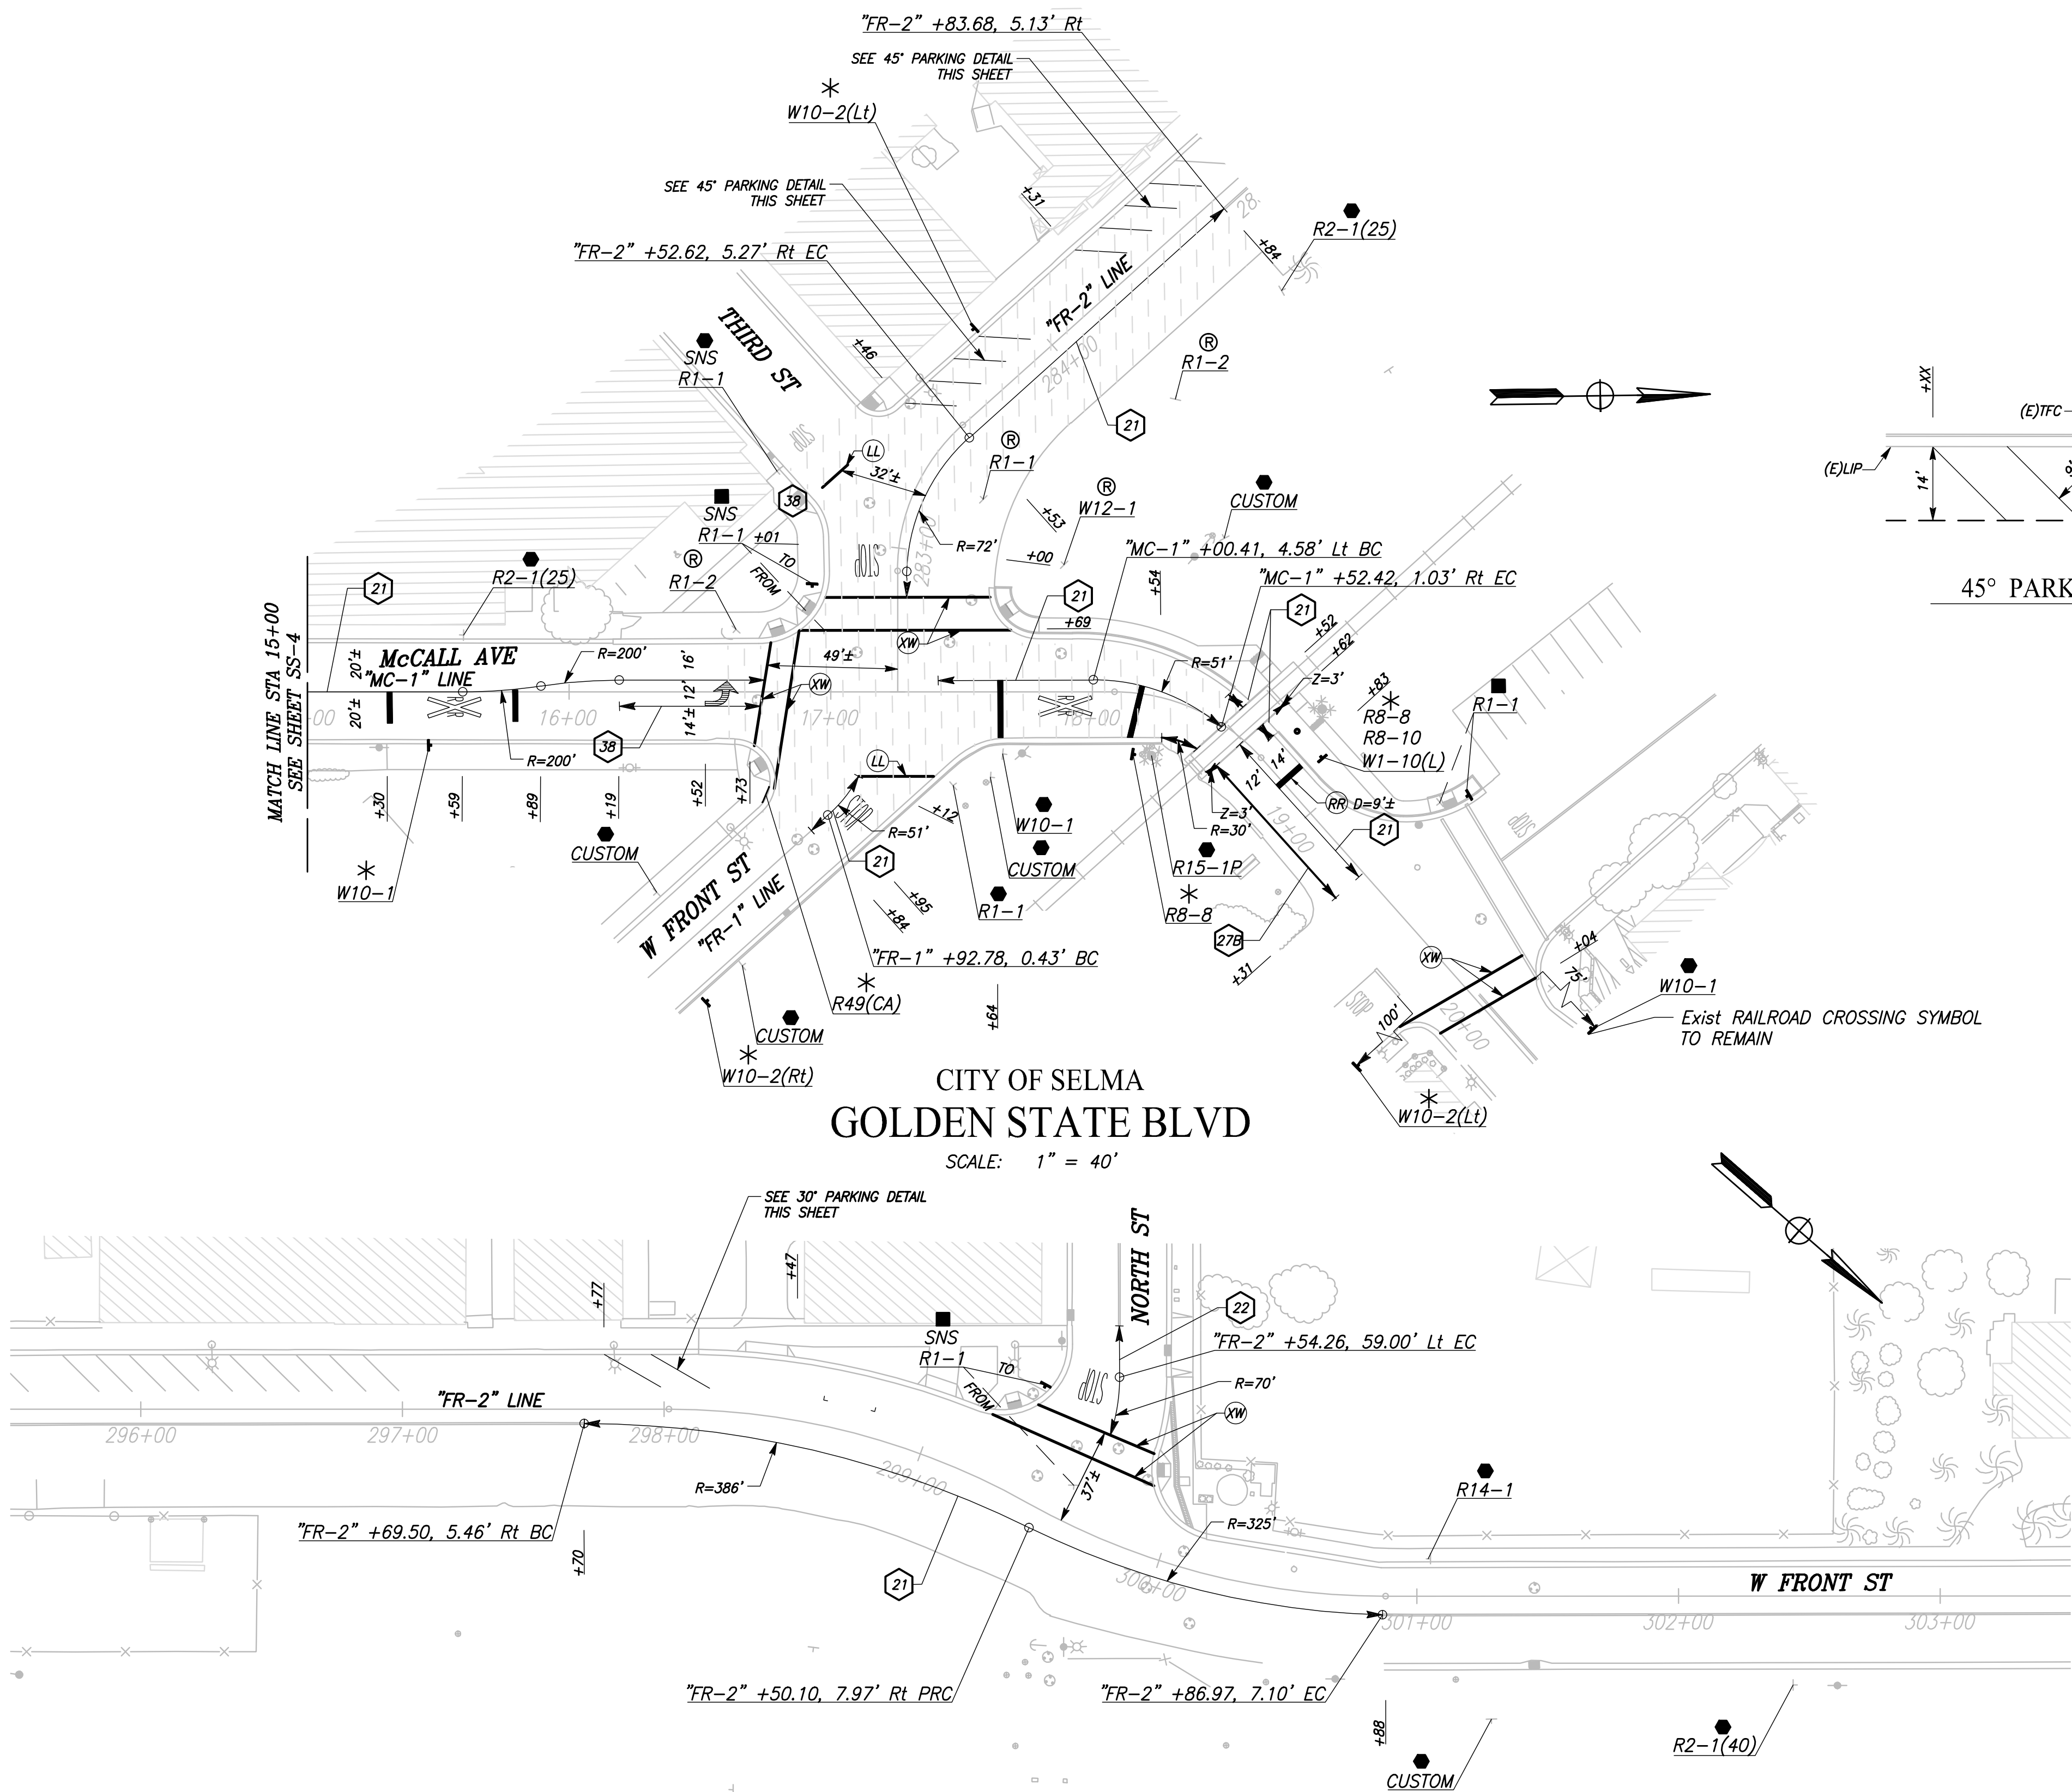

RECORD DRAWING	
DESIGNED: CYNTHIA HORNER	DATE: 3/12/2021
DRAWN: DEREK MAXWELL	DATE: 3/12/2021
CHECKED: JAMES POLFER	DATE: 3/12/2021


FOR RIGHT OF WAY DATA AND ACCURATE ACCESS DETERMINATION, SEE DOCUMENTS IN THE DEPARTMENT OF PUBLIC WORKS AND PLANNING.




TENTATIVE PLANS FOR DESIGN	
SUPERVISING ENGINEER	DATE





PROJECT	
GOLDEN STATE CORRIDOR - ECONOMIC DEVELOPMENT AND INFRASTRUCTURE IMPROVEMENTS	
SELMA REGION	

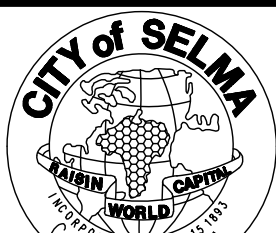

DEPARTMENT OF PUBLIC WORKS AND PLANNING		
SIGNING AND STRIPING		
DRAWING NO. SS-12	SHEET NO. 110	TOTAL 154

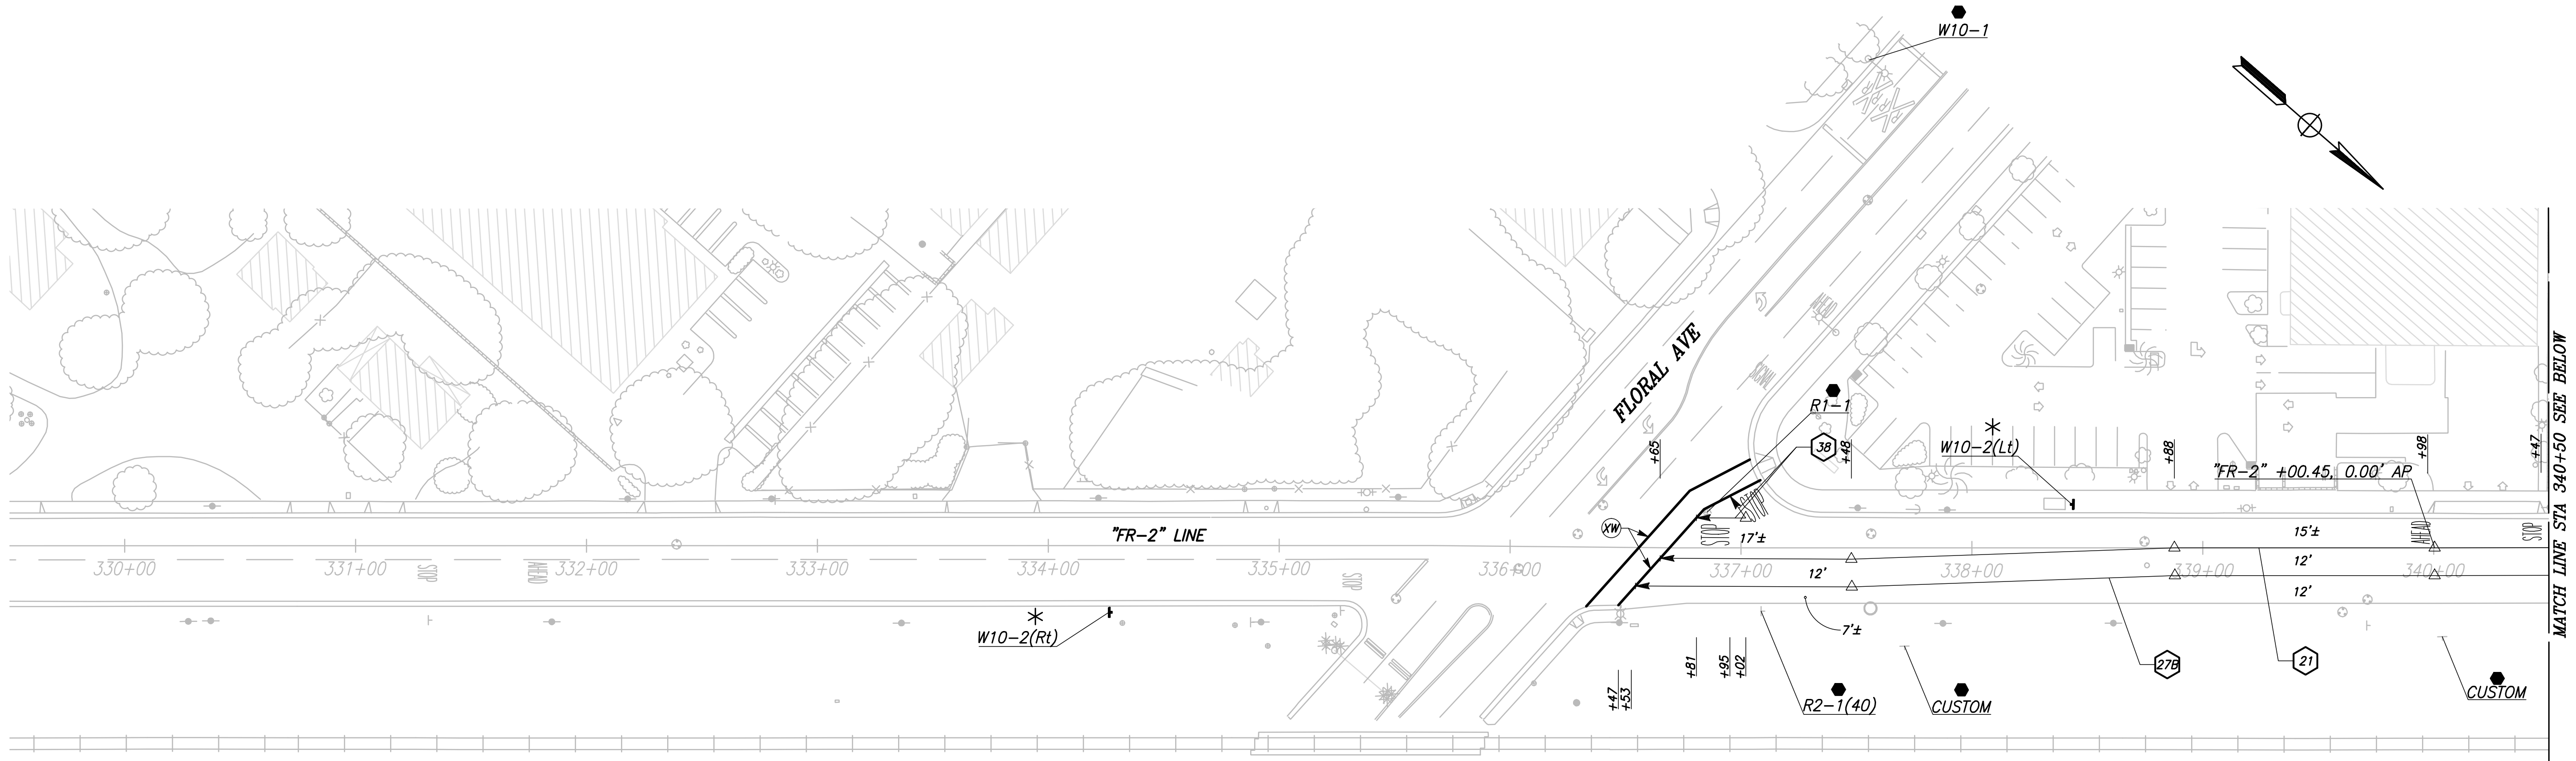

CITY OF SELMA
 GOLDEN STATE BLVD
 SCALE: 1" = 40'

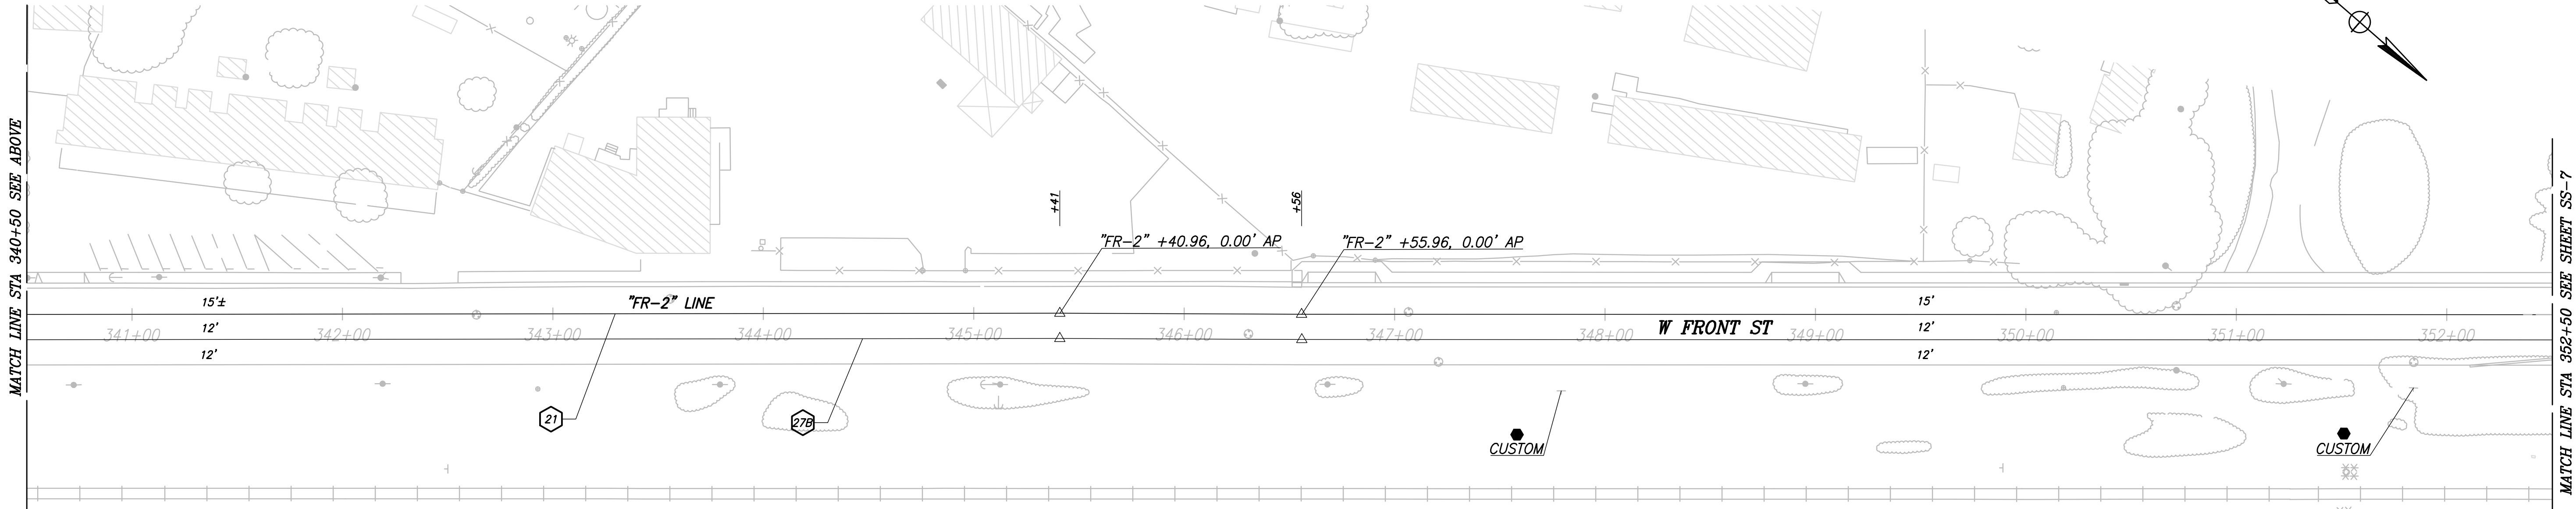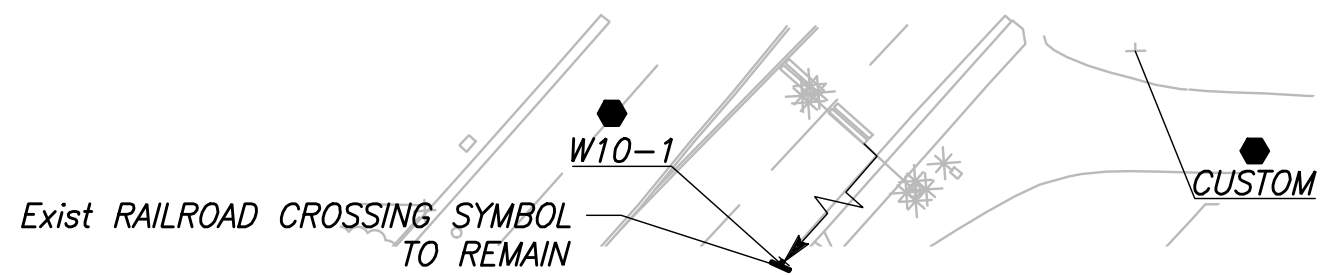

	DATE	RECORD DRAWING	
DESIGNED: CYNTHIA HORNER	3/12/2021	RESIDENT ENGINEER	DATE
DRAWN: DEREK MAXWELL	3/12/2021		
CHECKED: JAMES POLFER	3/12/2021		


FOR RIGHT OF WAY DATA AND ACCURATE ACCESS DETERMINATION, SEE DOCUMENTS IN THE DEPARTMENT OF PUBLIC WORKS AND PLANNING.



TENTATIVE	PLANS	FOR	DESIGN
SUPERVISING ENGINEER	DATE		




PROJECT
GOLDEN STATE CORRIDOR - ECONOMIC DEVELOPMENT AND INFRASTRUCTURE IMPROVEMENTS
SELMA REGION

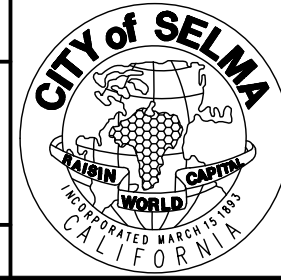

DEPARTMENT OF PUBLIC WORKS AND PLANNING		
SIGNING AND STRIPING		
DRAWING NO. SS-13	SHEET NO. 111	TOTAL 154

PLOT DATE: 2/23/2021 2:29:16 PM
C:\Users\CAVALA\OneDrive\Documents\Projects\009-Fresno County\009-009 Golden State PS&E - Selma Lighting.dwg
P:\TH\Z\01 Projects\009 Fresno County\009-009 Golden State PS&E - Selma Lighting.dwg

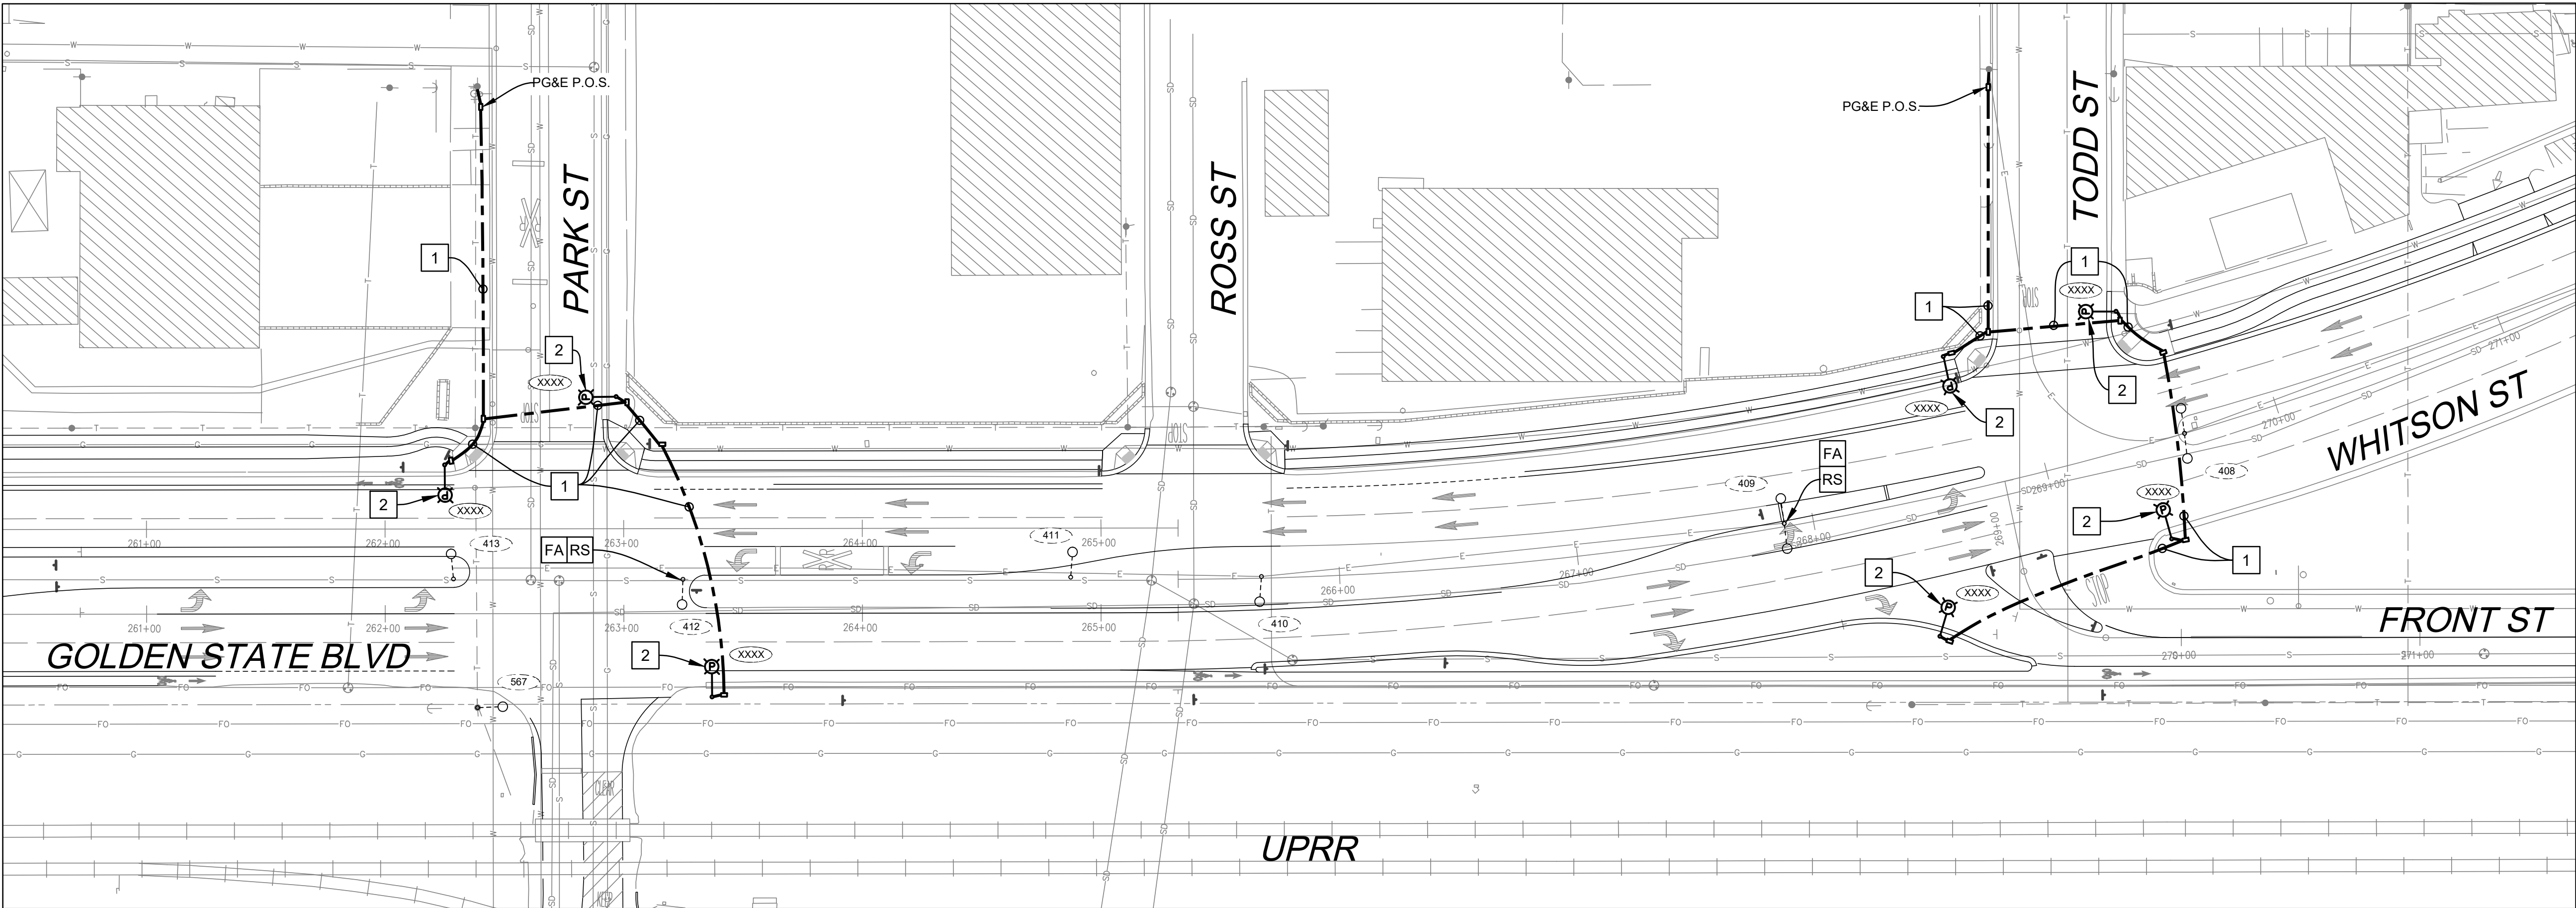

STREET LIGHTING LEGEND (SHEETS E-1 THROUGH E-3 ONLY):

- EXISTING LUMINAIRE.
- PG&E STREET LIGHT PER STANDARD DRAWING NUMBER 015136.
- INSTALL 3/4" PULL BOX UNLESS OTHERWISE NOTED.
- EXISTING STREET LIGHT NUMBER.
- CONTRACTOR SHALL PROVIDE AN AS-BUILT WITH THE PG&E STREET LIGHT NUMBER.
- FOUNDATION TO BE ABANDONED. REMOVE TOP OF FOUNDATION TO A POINT 36" BELOW THE FINISH GRADE.
- REMOVE AND SALVAGE EQUIPMENT.

CONSTRUCTION NOTES (SHEETS E-1 THROUGH E-3 ONLY):

- FURNISH AND INSTALL 2" C SCHEDULE 80 PVC. UPON INSPECTION AND APPROVAL BY PG&E, PG&E WILL INSTALL LIGHTING CONDUCTORS.
- FURNISH AND INSTALL THE STREET LIGHT ANCHOR BOLTS AND LIGHTING FOUNDATION PURSUANT TO PG&E STREET LIGHTING STANDARD DRAWING NUMBER 015136. ALL STREET LIGHTING CONDUITS AND PULL BOXES REQUIRE THE INSPECTION OF PG&E AND THE CITY OF SELMA. PG&E TO FURNISH AND INSTALL THE STREET LIGHT STANDARD, LUMINAIRE MAST ARM AND LUMINAIRE.
- FURNISH AND INSTALL 4" C, 2 #6 (LTG), 1 #8 (BOND).
- FURNISH AND INSTALL 2" C, 2 #6 (LTG), 1 #8 (BOND).
- FURNISH AND INSTALL TYPE III-AF SERVICE ENCLOSURE (TESCO 26-100 OR APPROVED EQUAL). CONTRACTOR SHALL COORDINATE WITH PG&E FOR THE POINT OF SERVICE CONNECTION AND METER SET.
- FURNISH AND INSTALL 2" C, 3 #2 (SERVICE).



PROJECT NOTES (SHEETS E-1 THROUGH E-3 ONLY):

- ALL WORK SHALL CONFORM TO APPLICABLE SECTIONS OF THE LATEST EDITION OF THE STATE OF CALIFORNIA "STANDARD SPECIFICATIONS", ISSUED BY THE CALIFORNIA DEPARTMENT OF TRANSPORTATION, THE NATIONAL ELECTRICAL CODE.
- UPON COMPLETION OF CONSTRUCTION, CONTRACTOR SHALL PROVIDE AN AS-BUILT WITH THE PG&E STREET LIGHT NUMBERS.




DESIGNED: J. BENAVIDES		DATE: 02/23/2021		RECORD DRAWING	
DRAWN: C. AYALA-MAGANA		DATE: 02/23/2021		RESIDENT ENGINEER	
CHECKED: J. RIOS		DATE: 02/23/2021		DATE	
FOR RIGHT OF WAY DATA AND ACCURATE ACCESS DETERMINATION, SEE DOCUMENTS IN THE DEPARTMENT OF PUBLIC WORKS AND PLANNING.					
516 W. SHAW AVE., STE. 103 FRESNO, CA 93704 PHONE: (559) 570-8991 EMAIL: info@JLBtraffic.com		SUPERVISING ENGINEER		DATE	
		PROJECT		GOLDEN STATE CORRIDOR - ECONOMIC DEVELOPMENT AND INFRASTRUCTURE IMPROVEMENTS	
		SELMA REGION		DEPARTMENT OF PUBLIC WORKS AND PLANNING	
DRAWING NO. E-1		SHEET NO. 112		TOTAL 154	
GOLDEN STATE BOULEVARD STREET LIGHTING PLAN					


PLOT DATE: 2/23/2021 4:45:37 PM
C:\Users\CAVALA\OneDrive\Documents\Projects\009-Golden State PS&E\Street Lighting\Design\Selma\009-009 Golden State PS&E - Selma Lighting.dwg
P:\H-Z\01 Projects\009 Fresno County\009-009 Golden State PS&E\Street Lighting\Design\Selma\009-009 Golden State PS&E - Selma Lighting.dwg

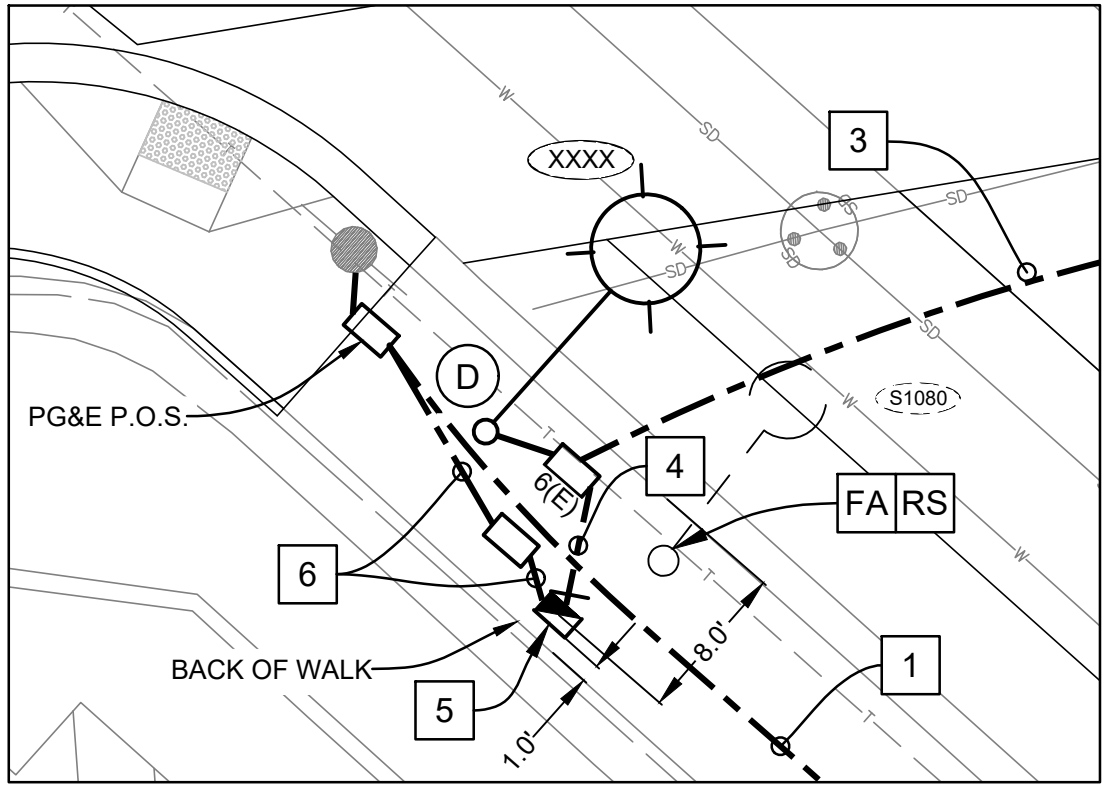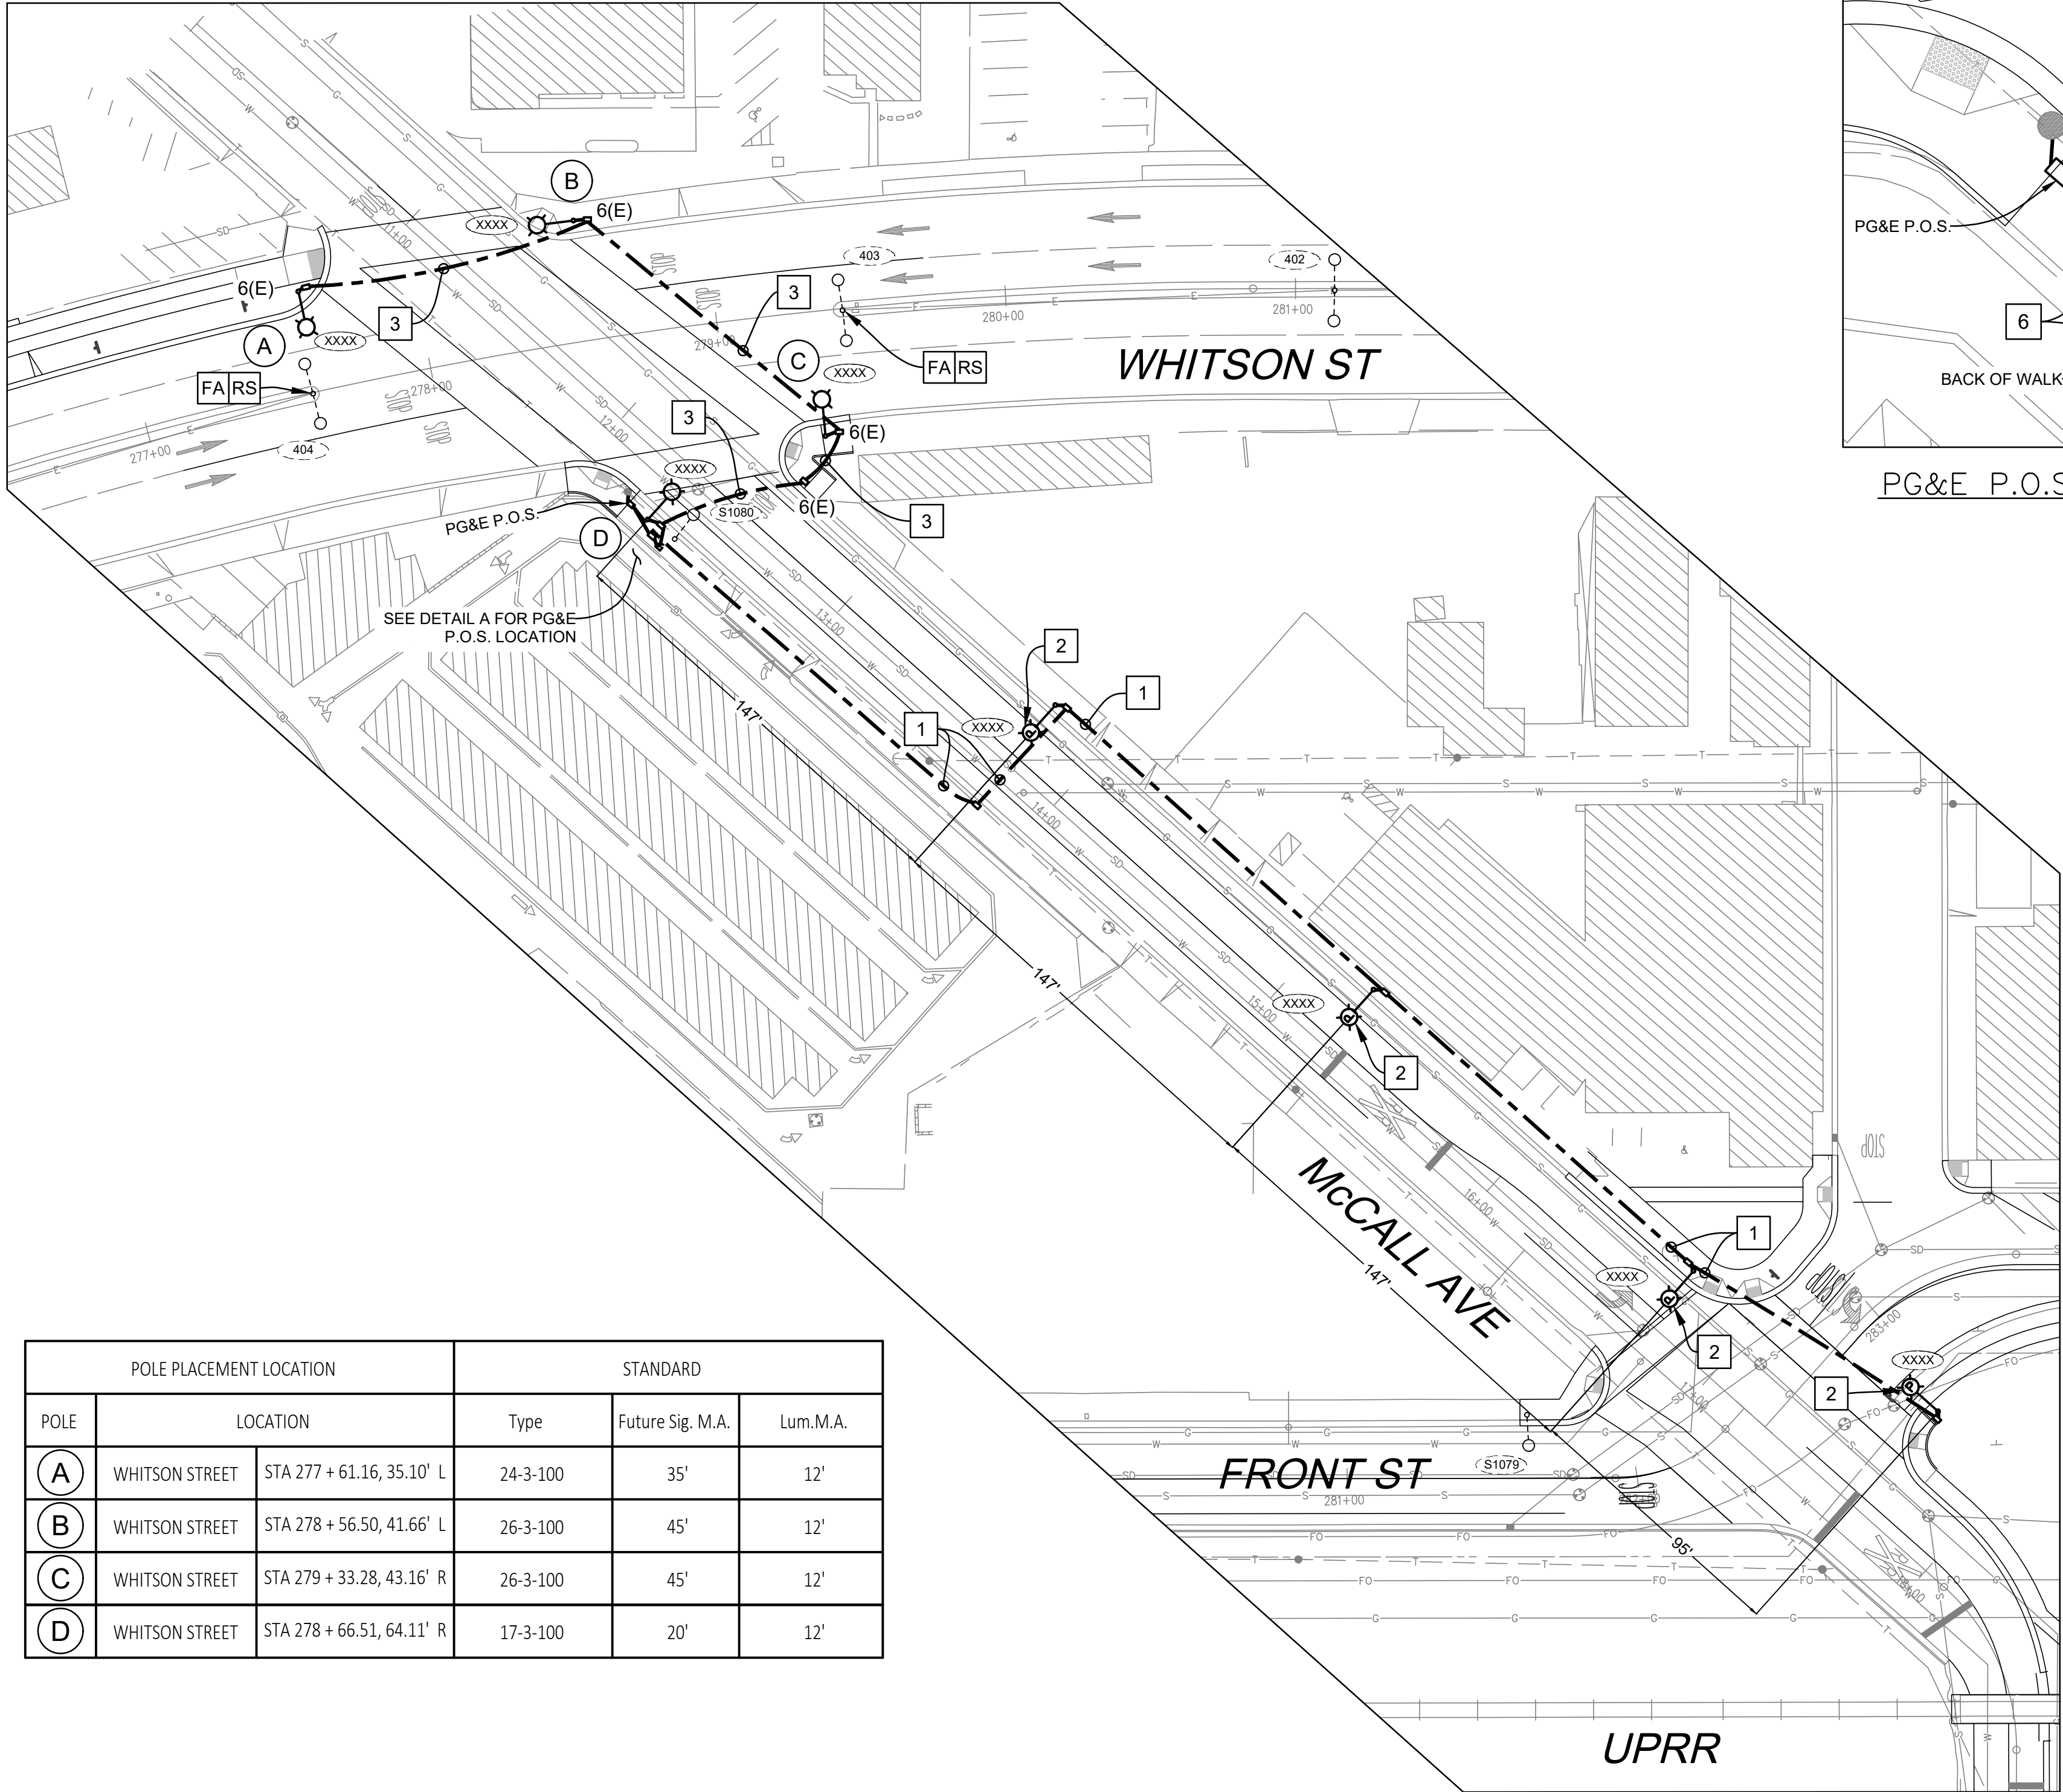

PG&E P.O.S. LOCATION — DETAIL A
NO SCALE

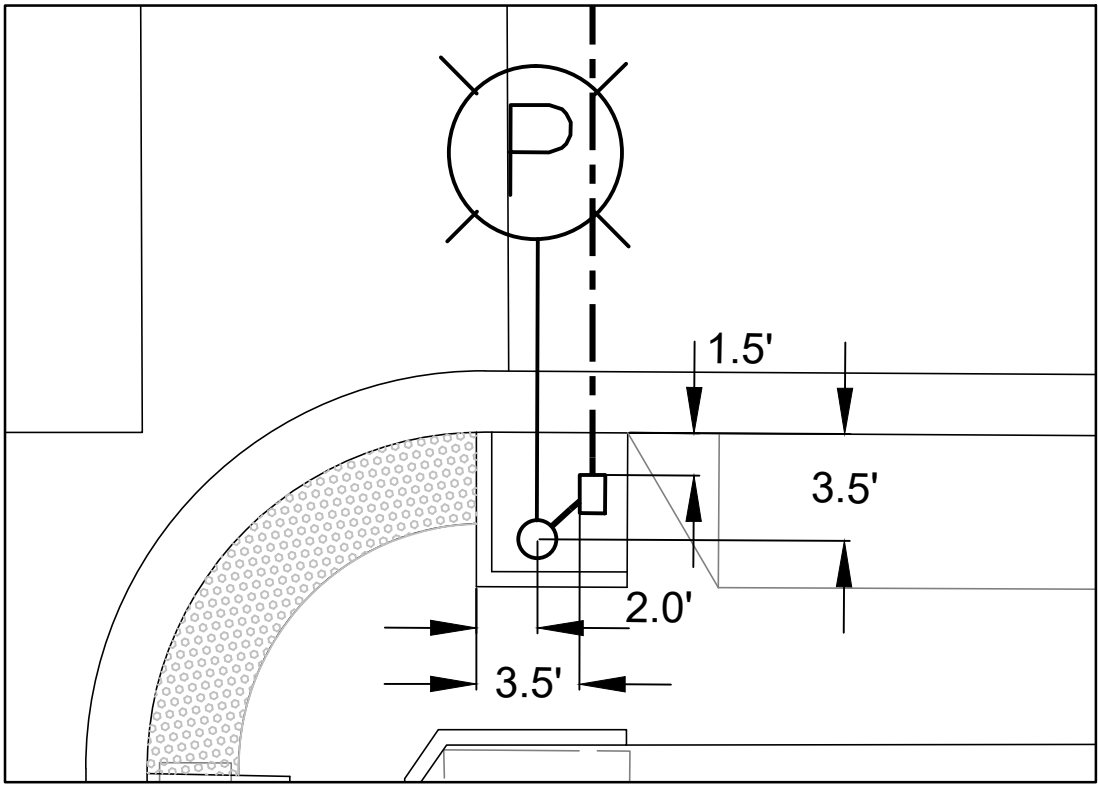

EQUIPMENT PLACEMENT — DETAIL B
NO SCALE

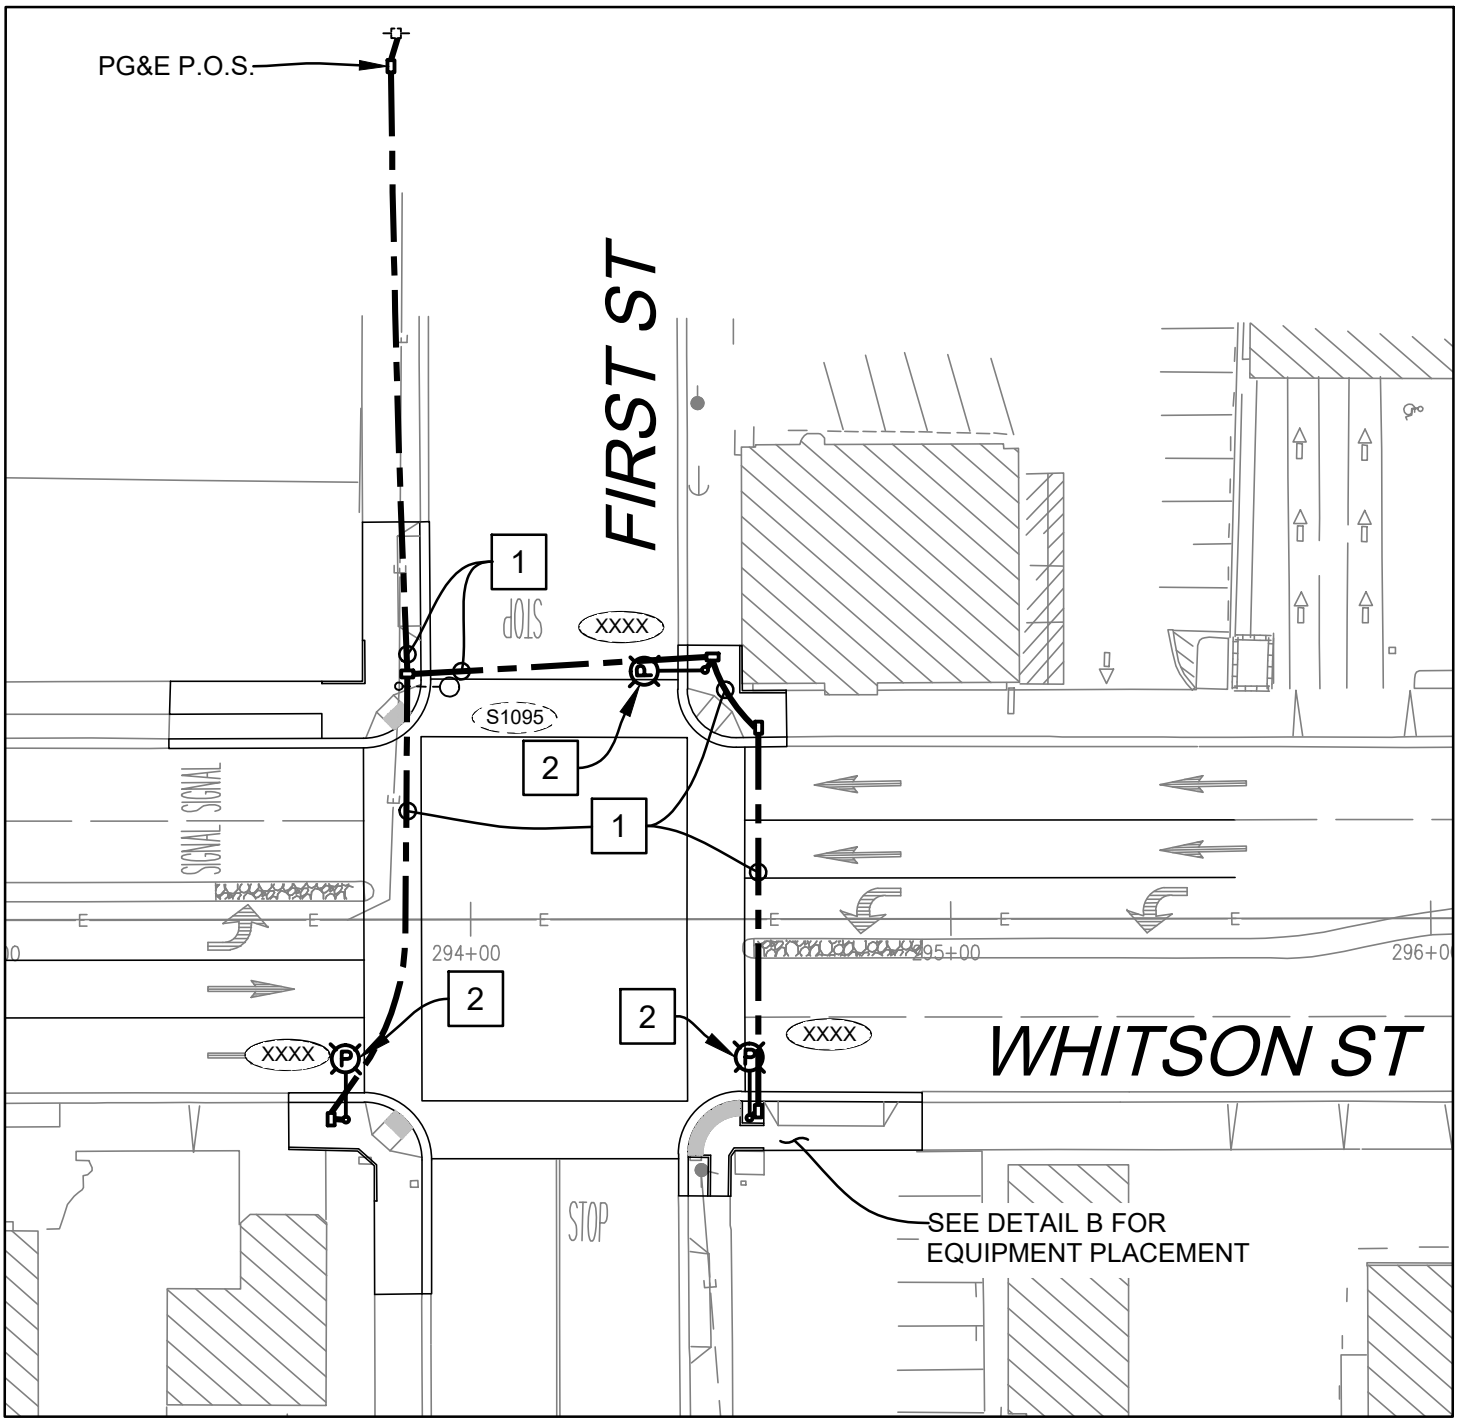


POLE PLACEMENT LOCATION			STANDARD		
POLE	LOCATION		Type	Future Sig. M.A.	Lum.M.A.
A	WHITSON STREET	STA 277 + 61.16, 35.10' L	24-3-100	35'	12'
B	WHITSON STREET	STA 278 + 56.50, 41.66' L	26-3-100	45'	12'
C	WHITSON STREET	STA 279 + 33.28, 43.16' R	26-3-100	45'	12'
D	WHITSON STREET	STA 278 + 66.51, 64.11' R	17-3-100	20'	12'



DESIGNED: J. BENAVIDES		DATE: 02/23/2021		RECORD DRAWING	
DRAWN: C. AYALA-MAGANA		DATE: 02/23/2021		RESIDENT ENGINEER	
CHECKED: J. RIOS		DATE: 02/23/2021		DATE	
FOR RIGHT OF WAY DATA AND ACCURATE ACCESS DETERMINATION, SEE DOCUMENTS IN THE DEPARTMENT OF PUBLIC WORKS AND PLANNING.					
					
CALL BEFORE YOU DIG		516 W. SHAW AVE., STE. 103 FRESNO, CA 93704 PHONE: (559) 570-8991 EMAIL: info@JLBtraffic.com		STATE OF CALIFORNIA	
PRELIMINARY NOT FOR CONSTRUCTION		SUPERVISING ENGINEER		DATE	
PROJECT				GOLDEN STATE CORRIDOR - ECONOMIC DEVELOPMENT AND INFRASTRUCTURE IMPROVEMENTS	
SELMA REGION				CITY OF SELMA	
DEPARTMENT OF PUBLIC WORKS AND PLANNING				GOLDEN STATE BOULEVARD STREET LIGHTING PLAN	
DRAWING NO. E-2		SHEET NO. 113		TOTAL 154	


CAD USER: CAYALA
PLOT DATE: 2/23/2021 2:30:24 PM
PATH: Z:\01 Projects\009 Fresno County\009-009 Golden State PS&E - Selma Lighting.dwg

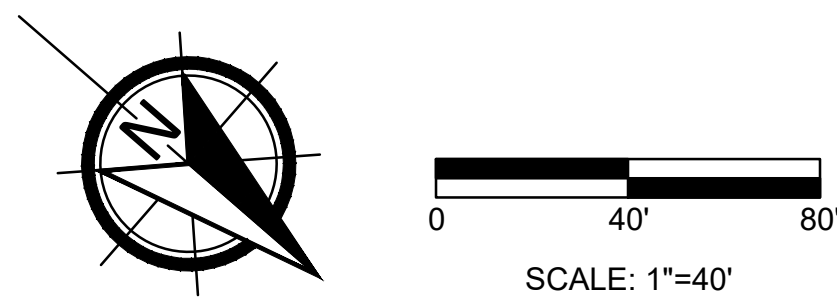

		DATE	RECORD DRAWING		 CALL BEFORE YOU DIG	 516 W. SHAW AVE., STE. 103 FRESNO, CA 93704 PHONE: (559) 570-8991 EMAIL: info@JLBtraffic.com	 PRELIMINARY NOT FOR CONSTRUCTION SUPERVISING ENGINEER DATE	 J. BENAVIDES REGISTERED PROFESSIONAL ENGINEER CIVIL No. 00000000 Exp. 02/23/2024 STATE OF CALIFORNIA	PROJECT		 CITY & SELMA CALIFORNIA	DEPARTMENT OF PUBLIC WORKS AND PLANNING		
DESIGNED: J. BENAVIDES	02/23/2021	RESIDENT ENGINEER	DATE	GOLDEN STATE CORRIDOR - ECONOMIC DEVELOPMENT AND INFRASTRUCTURE IMPROVEMENTS					GOLDEN STATE BOULEVARD STREET LIGHTING PLAN					
DRAWN: C. AYALA-MAGANA	02/23/2021			SELMA REGION					DRAWING NO. E-3 SHEET NO. 114 TOTAL 154					
CHECKED: J. RIOS	02/23/2021													
FOR RIGHT OF WAY DATA AND ACCURATE ACCESS DETERMINATION, SEE DOCUMENTS IN THE DEPARTMENT OF PUBLIC WORKS AND PLANNING.														

PATH: Z:\01 Projects\009 Fresno County\009-009 Golden State PS&E\Traffic Signal Designs\2a Whitson at Floral Ave\Whitson at Floral Ave.dwg
PLOT DATE: 2/23/2021 4:06:32 PM
CAD USER: CAYALA


EXISTING STEADY DEMAND SEQUENCE

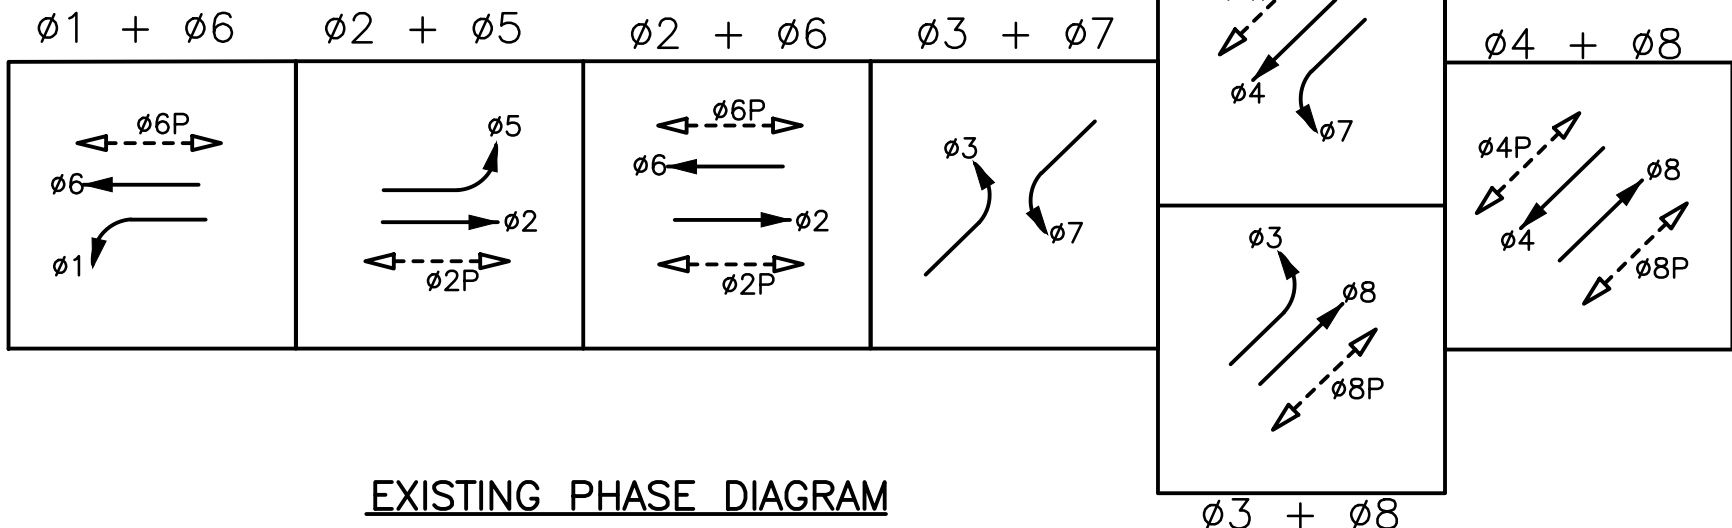

EXISTING PHASE DIAGRAM

EMERGENCY VEHICLE PREEMPTION (EVP)

- EVA = 02 + 05
- EVB = 04 + 07
- EVC = 01 + 06
- EVD = 03 + 08

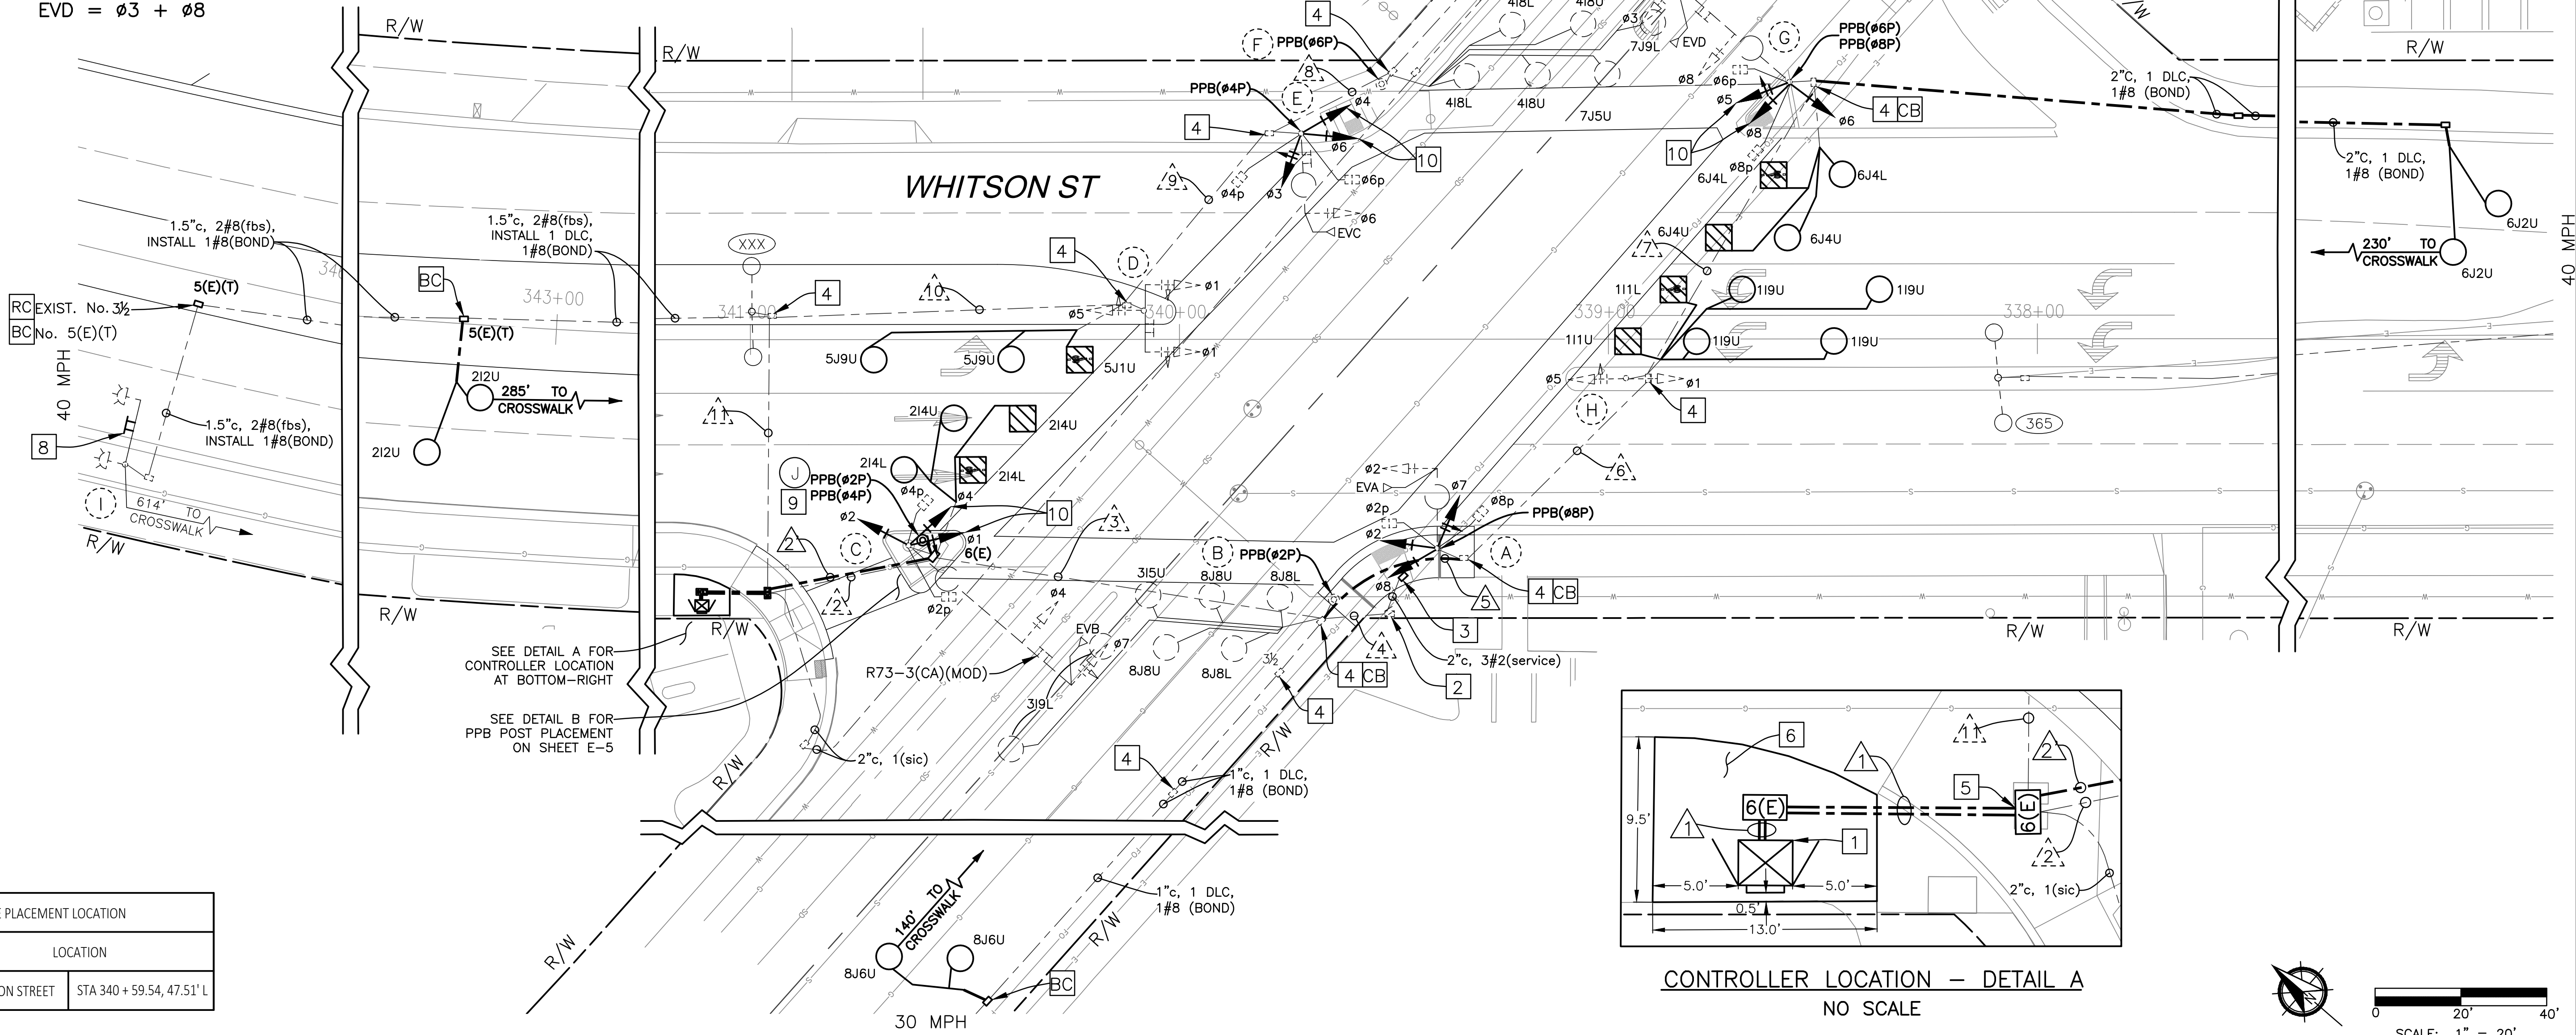

POLE PLACEMENT LOCATION	
POLE	LOCATION
J	WHITSON STREET STA 340 + 59.54, 47.51' L

		DATE	RECORD DRAWING		 CALL BEFORE YOU DIG	 516 W. SHAW AVE., STE. 103 FRESNO, CA. 93704 PHONE: (559) 570-8991 EMAIL: info@JLBtraffic.com	 SUPERVISING ENGINEER	DATE	 DATE	PROJECT		 CITY OF SELMA SANTA CLARA COUNTY CALIFORNIA	DEPARTMENT OF PUBLIC WORKS AND PLANNING						
DESIGNED:	J. BENAVIDES	02/23/2021	RESIDENT ENGINEER	DATE						GOLDEN STATE CORRIDOR - ECONOMIC DEVELOPMENT AND INFRASTRUCTURE IMPROVEMENTS			WHITSON ST AT FLORAL AVE TRAFFIC SIGNAL PLAN						
DRAWN:	C. AYALA-MAGANA	02/23/2021																	
CHECKED:	J. RIOS	02/23/2021																	
FOR RIGHT OF WAY DATA AND ACCURATE ACCESS DETERMINATION, SEE DOCUMENTS IN THE DEPARTMENT OF PUBLIC WORKS AND PLANNING.																			
										SELMA REGION				DRAWING NO. E-4		SHEET NO. 115		TOTAL 154	

CAD USER: CAYALA
PLOT DATE: 2/23/2021 4:50:25 PM
PATH: Z:\01 Projects\009 Fresno County\009-009 Golden State PS&E\Traffic Signal Designs\2a Whitson at Floral Ave.dwg

PROJECT NOTES (SHEETS E-4 TO E-7 ONLY):

- 1

FURNISH AND INSTALL TYPE 2070LX (76.13P FIRMWARE) AND NEW 332L CABINET WITH ALL ANCILLARY DEVICES FOR A FULL EIGHT PHASE OPERATION. FRONT DOOR OF CABINET SHALL FACE NORTHWEST. FURNISH AND INSTALL NEW BATTERY BACK-UP SYSTEM PER THE STATE SPECIAL PROVISIONS. BATTERY BACK-UP EXTERNAL CABINET SHALL BE ON THE SOUTHWEST SIDE OF THE CONTROLLER ASSEMBLY.
- 2

EXISTING SERVICE CABINET.
- 3

EXISTING PG&E POINT OF SERVICE. COORDINATE WITH PG&E TO MATCH NEW GRADE.
- 4

RS

EXISTING PULL BOX LID AND INSTALL VANDAL RESISTANT PULL BOX LID.
- 5

RC

TWO EXISTING 5(e) PULL BOXES AND BC ONE No. 6(E) PULL BOX.
- 6

INSTALL 111 SQUARE FEET OF 3.5" PCC PAD.
- 7

RS

EXISTING 5(e) PULL BOX AND BC No. 6(E) PULL BOX. NEW PULL BOX SHALL CONFORM TO PROPOSED GRADE AND NOT HAVE ANY PORTION OF IT ENCROACH ONTO THE TRUNCATED DOMES.
- 8

INSTALL W3-3 SIGN ON SMA COMPLETE WITH MOUNTING HARDWARE.
- 9

2 ½" PPB POST SHALL BE INSTALLED PURSUANT TO DETAIL B ON THIS SHEET AND DETAIL B OF CALTRANS STANDARD PLANS ES-7A.
- 10

INSTALL DIRECTIONAL LOUVERS TO ENSURE THAT THE VEHICULAR SIGNAL HEAD IS ONLY VISIBLE TO TRAFFIC IT IS INTENDED FOR.

LEGEND (FOR SHEETS E-4 TO E-7 ONLY):

- TYPE E CIRCULAR LOOP DETECTOR CONFIGURATION PER STATE STANDARD PLAN ES-5B. LOOP SEALANT SHALL BE STATE APPROVED ELASTOMERIC SEALANT OR HOT MELT RUBBERIZED.
- EXISTING TYPE E LOOP DETECTOR.
- TYPE D RECTANGULAR LOOP DETECTOR CONFIGURATION PER STATE STANDARD PLAN ES-5B. LOOP SEALANT SHALL BE STATE APPROVED ELASTOMERIC SEALANT OR HOT MELT RUBBERIZED. BICYCLE DETECTOR SYMBOL TO BE INSTALLED PER CALTRANS STANDARD PLAN A24-C ON CENTER OF THE DETECTOR. ARROW SIGNIFIES DIRECTION OF TRAVEL.
- EXISTING TYPE A LOOP DETECTOR.
- EXISTING EMERGENCY VEHICLE PREEMPTION (EVP DETECTION UNIT)
EVA (DENOTES CHANNEL).
- NEW CONDUIT
- EXISTING CONDUIT
- EXISTING LUMINAIRE POLE
- EXISTING DOUBLE LUMINAIRE POLE
- AB

ABANDON, IF APPLIED TO CONDUIT, REMOVE CONDUCTORS.
- RS

REMOVE AND SALVAGE EQUIPMENT.
- RC


EQUIPMENT OR MATERIAL TO BE REMOVED SHALL BECOME THE PROPERTY OF THE CONTRACTOR.
- FA

FOUNDATION TO BE ABANDONED. REMOVE TOP OF FOUNDATION TO A POINT 24" BELOW THE ADJACENT PROPOSED PAVING GRADE.
- CC


CONNECT NEW AND EXISTING CONDUIT. REMOVE EXISTING CONDUCTORS AND INSTALL CONDUCTORS AS INDICATED.
- CB

INSTALL NEW CONDUIT INTO EXISTING PULL BOX.
- BC

INSTALL PULL BOX IN EXISTING CONDUIT RUN.

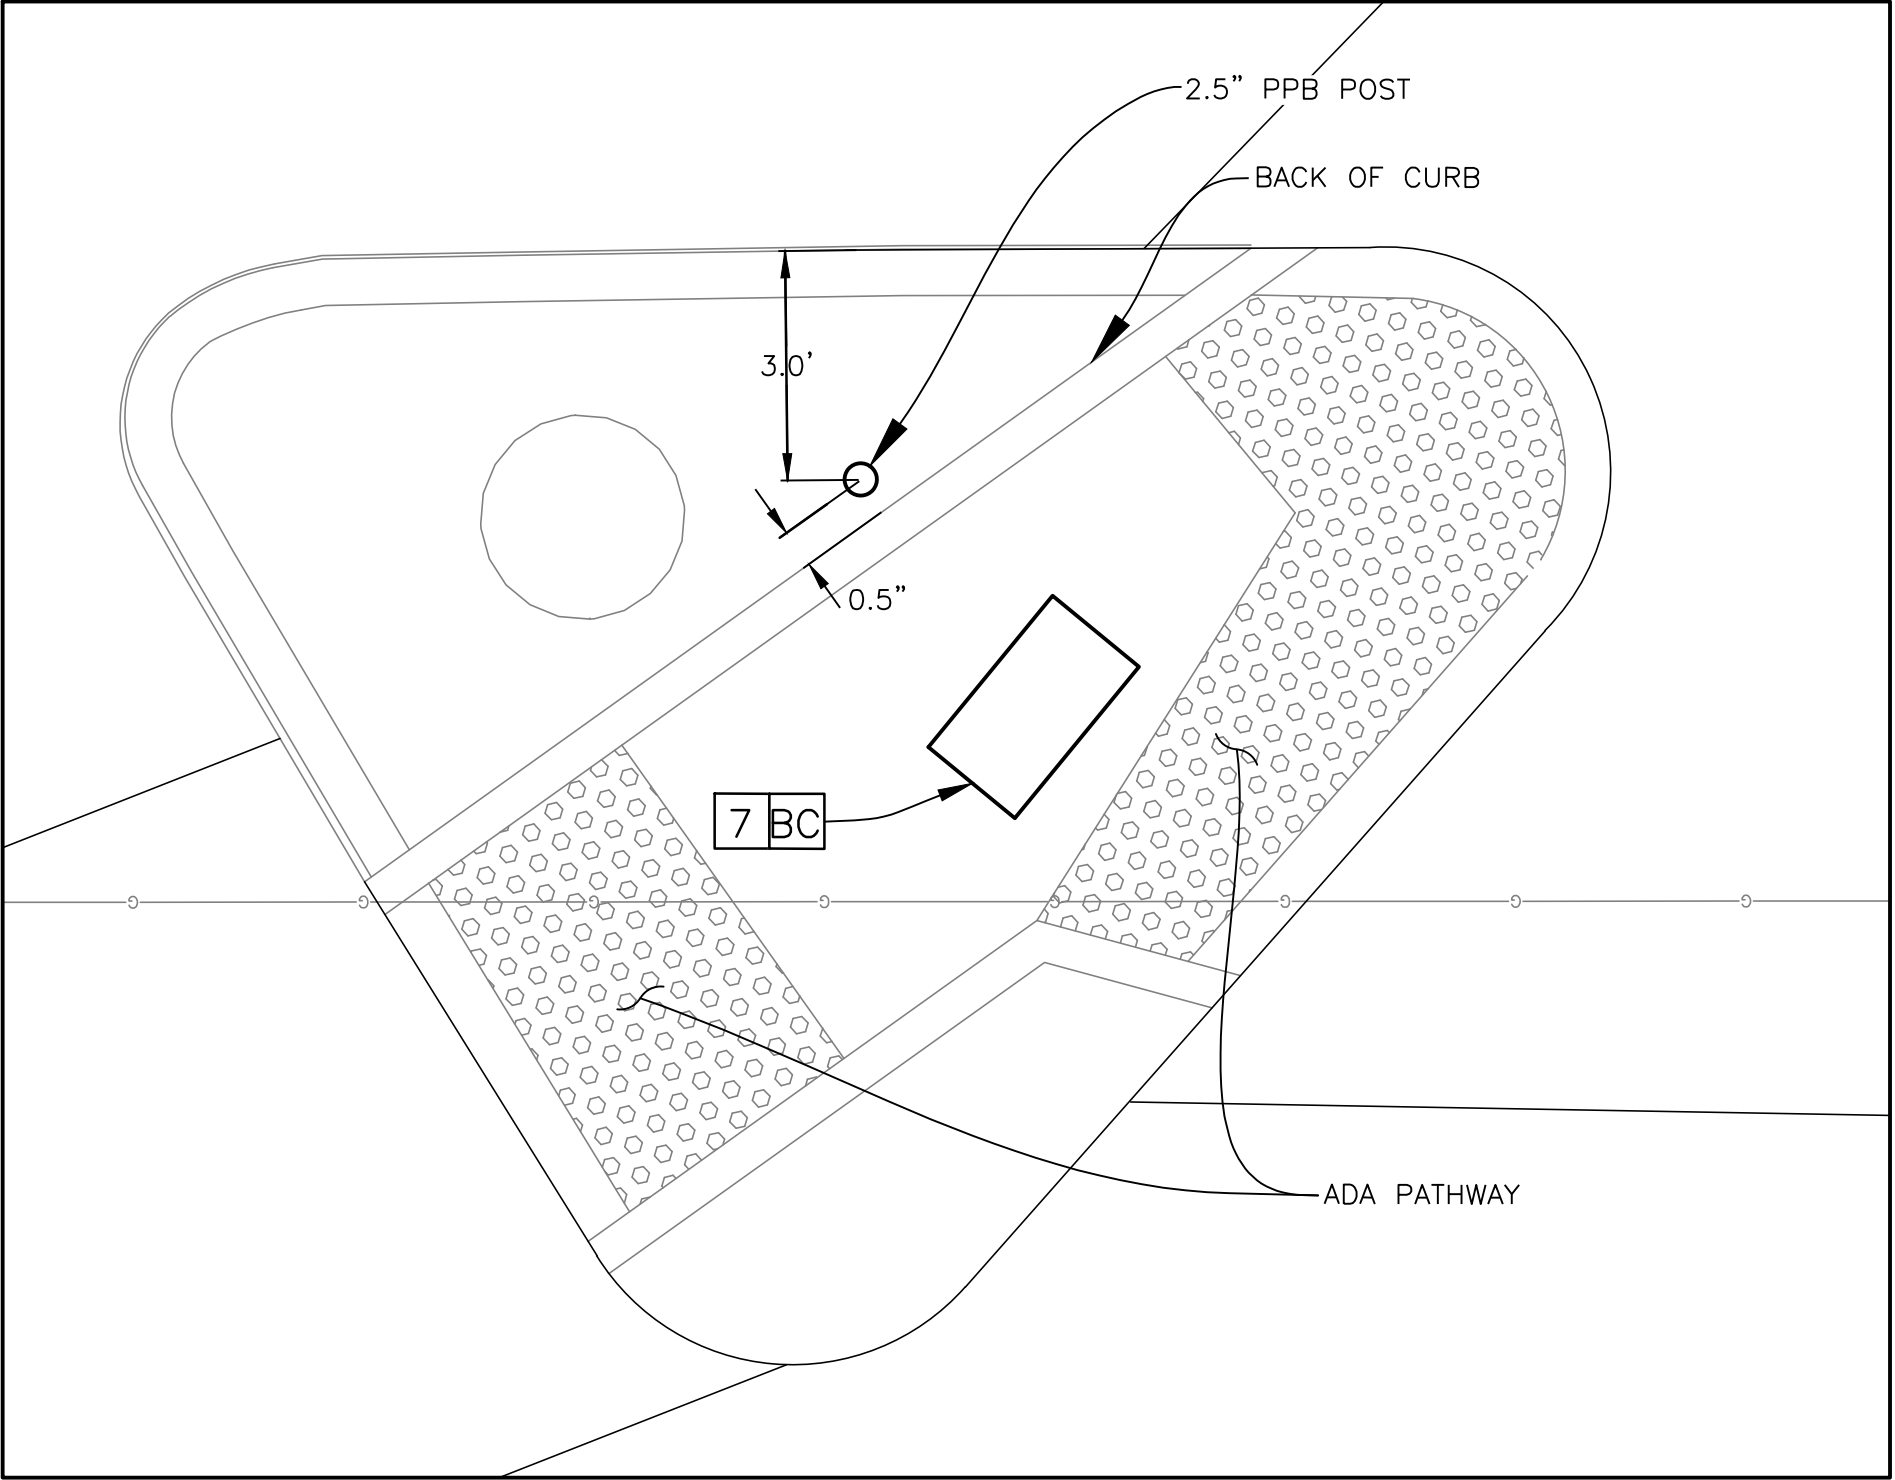

PPB POST PLACEMENT – DETAIL B
NO SCALE

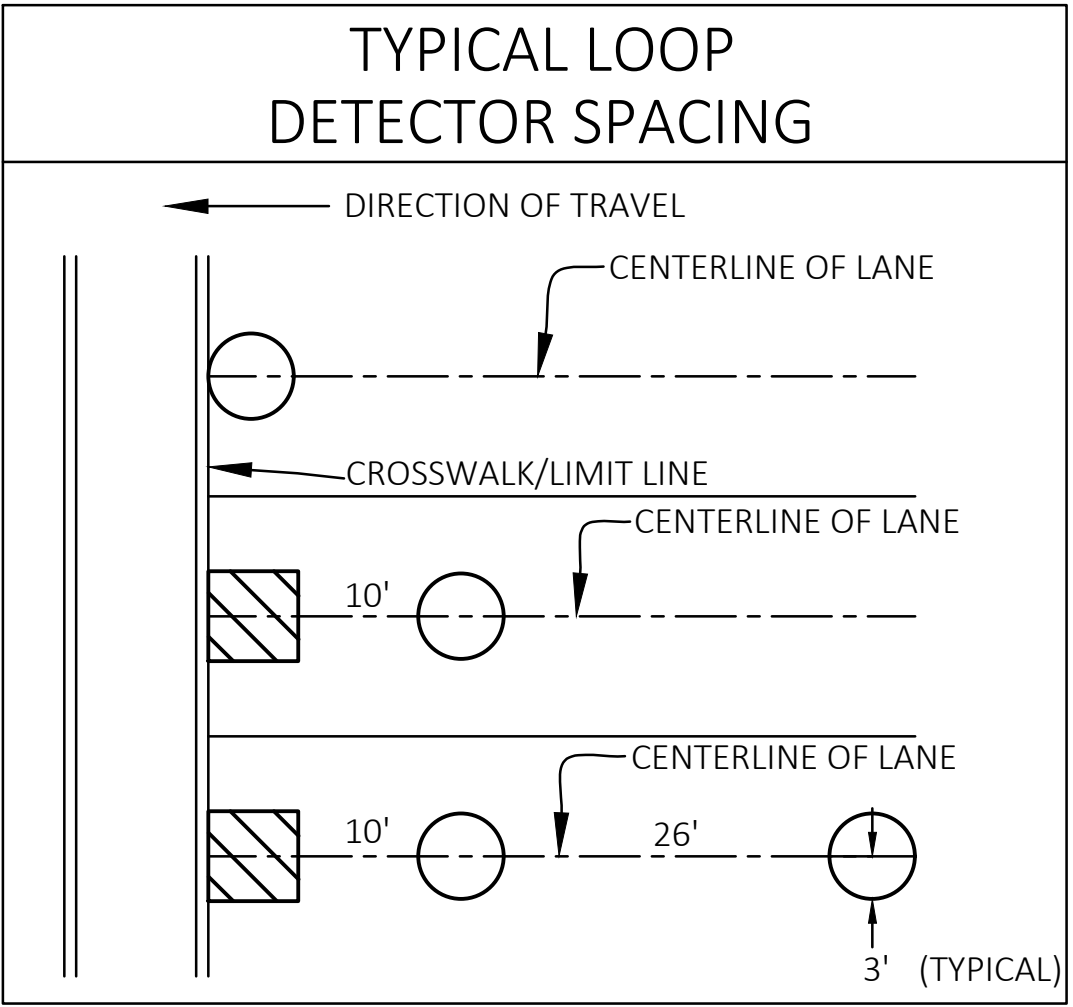

TYPICAL LOOP DETECTOR PLACEMENT – DETAIL C
NO SCALE

CONSTRUCTION NOTES (SHEETS E-4 TO E-7 ONLY):

1. ALL PULL BOXES ACCESSED BY CONTRACTOR SHALL BE CLEANED OF ALL DIRT AND DEBRIS, ANY CRACKS GROUTED AND ALL CONDUITS DUCT SEALED.
2. REPLACE ALL PULLBOXES IN DIRT AREAS WITH TRAFFIC RATED PULLBOXES.
3. ALL PULLBOXES SHALL BE LEVELED TO FINISH GRADE (NEW AND EXISTING).
4. ALL PULLBOXES IN DIRT AREAS SHALL HAVE 1' COLLAR PER GENERAL NOTE 10 (NEW AND EXISTING).
5. ANY BROKEN/DAMAGED PULLBOXES SHALL BE REPLACED.
6. ALL PULLBOXES SHALL HAVE LOCKING LIDS. TRAFFIC RATED LIDS SHALL BE WELDED CLOSED AFTER FINAL INSPECTION.
7. ALL UNUSED CONDUCTORS SHALL BE REMOVED.

	DATE	RECORD DRAWING		 CALL BEFORE YOU DIG	 516 W. SHAW AVE., STE. 103 FRESNO, CA 93704 PHONE: (559) 570-8991 EMAIL: info@JLBtraffic.com		PROJECT			DEPARTMENT OF PUBLIC WORKS AND PLANNING			
DESIGNED:	J. BENAVIDES	02/23/2021	RESIDENT ENGINEER				DATE	GOLDEN STATE CORRIDOR - ECONOMIC DEVELOPMENT AND INFRASTRUCTURE IMPROVEMENTS		WHITSON ST AT FLORAL AVE DETAILS AND NOTES			
DRAWN:	C. AYALA-MAGANA	02/23/2021											
CHECKED:	J. RIOS	02/23/2021											
FOR RIGHT OF WAY DATA AND ACCURATE ACCESS DETERMINATION, SEE DOCUMENTS IN THE DEPARTMENT OF PUBLIC WORKS AND PLANNING.													
					TENTATIVE PLANS FOR DESIGN		SUPERVISING ENGINEER		DATE	SELMA REGION			
										DRAWING NO. E-5 SHEET NO. 116 TOTAL 154			

PLOT DATE: 2/23/2021 8:28:54 AM CAD USER: CAYALA PATH: Z:\01 Projects\009 Fresno County\009-009 Golden State PS&E\Traffic Signal Designs\2a Whitson at Floral Ave.dwg

CONDUCTOR SCHEDULE														
AWG OR CABLE	POLE	Ø	CONDUIT RUN NUMBER AND SIZE											
			1	2	2	3	4	5	6	7	8	9	10	11
			2-4"	3"	4"	3"	1.5"	4"	2.5"	2"	1.5"	2.5"	2.5"	2.5"
CONDUIT FILL			19%	16%	18%	36%	17%	17%	31%	33%	24%	26%	33%	34%
7 COND. CABLE (VEH.) *	A	2,7,8 2P,8P	2 1	/	2 1	/	2 1	/	/	/	/	/	/	/
	C	1,2,4,7 2P,4P	2 1	/	2 1	/	/	/	/	/	/	/	/	/
	D	1,5 -	1 -	/	/	/	/	/	/	/	/	1 -	1 -	/
	E	3,4,6 4P,6P	2 1	/	/	/	/	/	/	/	2 1	2 1	2 1	/
	G	3,5,6,8 6P,8P	2 1	/	2 1	/	2 1	2 1	2 1	/	/	/	/	/
	H	1,5 -	1 -	/	1 -	/	1 -	1 -	/	/	/	/	/	/
TOTAL			10 4	/	7 3	5 2	/	5 2	3 1	2 1	/	2 1	3 1	3 1
3 COND. CABLE (PPB)	A	2P & 8P	1	/	1	1	/	1	/	/	/	/	/	/
	C	2P & 4P	1	/	1	/	/	/	/	/	/	/	/	/
	E	4P & 6P	1	/	/	/	/	/	/	/	1	1	1	/
	G	6P & 8P	1	/	1	1	/	1	1	1	/	/	/	/
TOTAL			4	/	3	2	/	2	1	1	/	1	1	1
TYPE B DETECTOR LEAD-IN CABLE	Ø1		3	3	/	3	/	3	3	/	/	/	/	/
	Ø2		3	2	/	/	/	/	/	/	/	/	1	/
	Ø3		2	2	/	2	/	/	/	/	/	/	/	/
	Ø4		3	/	/	/	/	/	/	3	3	3	3	/
	Ø5		2	/	/	/	/	/	/	/	/	2	2	/
	Ø6		3	3	/	3	/	3	3	3	/	/	/	/
	Ø7		2	/	/	/	/	/	/	2	2	2	2	/
	Ø8		3	3	/	3	/	/	/	/	2	2	2	/
	PED PUSH BUTTON		/	/	/	/	1	/	/	1	/	/	/	
	TOTAL DLC	21	13	/	11	/	7	6	3	6	5	7	8	
# 6	SIGNAL POWER	2	2	/	2	2	/	/	/	/	/	/	/	
# 8	SAFETY LIGHTS	/	/	2	2	2	2	2	2	/	2	2	2	
# 8	BONDING WIRE	1	1	1	1	1	1	1	1	1	1	1	1	
#10	110V NEUTRAL	2	/	1	1	/	1	1	1	/	1	1	1	
#12	12V NEUTRAL	2	/	1	1	/	1	1	1	/	1	1	1	
EVP CABLE 3 COND.	EVA (S/B)	1	/	1	1	/	1	/	/	/	/	/	/	
	EVb (W/B)	1	/	1	/	/	/	/	/	/	/	/	/	
	EVC (N/B)	1	/	/	/	/	/	/	/	/	1	1	1	
	EVD (E/B)	1	/	1	1	/	1	1	1	/	/	/	/	

* NUMBER INDICATIONS ARE THE NUMBER OF CABLES WITHIN CONDUIT. ALL CONDUCTORS ARE NEW UNLESS OTHERWISE INDICATED WITH "()".

EQUIPMENT SCHEDULE														
No.	STANDARD			VEH SIG MTG		PED SIGNAL		PPB		HPS EQUIV. LUMINAIRE WATTAGE	PG&E POLE #	SPECIAL REQUIREMENTS		
	Type	Sig.	M.A.	Lum.M.A.	Mast Arm	Pole	Ø MTG	Ø	ARROW					
A	17-2-70	18'		12'	MAS	SV-3-T (N)	2 8	SP-2-T	8 (N) LEFT (N)	73 LED	XXXX	REMOVE AND SALVAGE EXISTING PED PUSH BUTTON AND POLE MOUNTED VEHICLE HEADS. FURNISH AND INSTALL NEW PED PUSH BUTTON ASSEMBLY AND VEHICLE HEADS. EXISTING SNS "Floral" ON POLE AND EVA ON SMA TO REMAIN.		
B	PPB POST (2 1/2")	-		-	-	-	-	-	2 (N) RIGHT (N)	-		REMOVE AND SALVAGE EXISTING PED PUSH BUTTON ASSEMBLY. FURNISH AND INSTALL NEW PED PUSH BUTTON ASSEMBLY.		
C	29-5-70	50'		12'	MAT MAS	SV-3-T (N)	2 4	SP-2-T	-	XXXX	XXXX	REMOVE AND SALVAGE EXISTING PED PUSH BUTTONS. EXISTING SNS "Whitson" ON POLE AND R73-3 (CA)(MOD) AND EVB ON SMA TO REMAIN.		
D	33	9' LEFT 5' RIGHT		-	MAS MAS	SV-1-T	-	-	-	-		REMOVE AND SALVAGE EXISTING PED PUSH BUTTON ASSEMBLY. EXISTING R73-5 (CA) SIGN ON EXISTING POLE TO REMAIN.		
E	17-2-70	18'		12'	MAS	SV-3-T (N)	4 6	SP-2-T	4 (N) LEFT (N)	XXXX	XXXX	REMOVE AND SALVAGE EXISTING PED PUSH BUTTON AND POLE MOUNTED VEHICLE HEADS. FURNISH AND INSTALL NEW PED PUSH BUTTON ASSEMBLY AND VEHICLE HEADS. EXISTING SNS "Floral" ON POLE AND EVC AND R73-2 (CA) SIGN ON EXISTING SMA TO REMAIN.		
F	PPB POST	-		-	-	-	-	-	6 (N) RIGHT (N)	-		REMOVE AND SALVAGE EXISTING PED PUSH BUTTON ASSEMBLY. FURNISH AND INSTALL NEW PED PUSH BUTTON ASSEMBLY.		
G	24-3-70	35'		12'	MAT MAS	SV-3-T (N)	6 8	SP-2-T	(N) 6 (N) 8 (N) RIGHT (N) LEFT	61 LED	XXXX	REMOVE AND SALVAGE EXISTING PED PUSH BUTTONS. FURNISH AND INSTALL NEW PED PUSH BUTTON ASSEMBLIES. EXISTING SNS "Whitson" ON POLE AND R73-2 (CA)(MOD) SIGN AND EVD ON EXISTING SMA TO REMAIN.		
H	1-A (10')	-		-	-	LT-2-T	-	-	-	-		REMOVE AND SALVAGE EXISTING PED PUSH BUTTON ASSEMBLY. EXISTING R73-2 (CA)(MOD) SIGN ON 1-A POLE TO REMAIN.		
I	15-FBS	-		-	-		-	-	-	-		EXISTING FLASHING BEACON CONTROL ASSEMBLY ON POLE TO REMAIN. FURNISH AND INSTALL W3-3 SIGN ON SMA COMPLETE WITH MOUNTING HARDWARE.		
J	PPB POST (2 1/2") (N)	-		-	-	-	-	-	(N) 2 (N) 4 (N) LEFT (N) RIGHT	-		FURNISH AND INSTALL NEW PED PUSH BUTTON ASSEMBLY. 2 1/2 PPB POST SHALL BE PERSUANT TO DETAIL B OF CALTRANS STANDARD PLANS ES-7A.		

- NOTES:
- ALL EQUIPMENT IS EXISTING UNLESS NOTED WITH (N).
 - STREET NAME SIGNS SHALL BE WHITE LETTERS ON BLUE BACKGROUND 12" UPPERCASE 9" LOWERCASE, 4" BLOCK NUMBERS, 4" WIDE ARROWS, SERIES "D" TEXT ON TYPE XI DIAMOND GRADE SHEETING, 3M TYPE XI DG3 OR APPROVED EQUAL.

GENERAL NOTES:

1. WORK SHALL BE DONE IN ACCORDANCE WITH THE STATE OF CALIFORNIA DEPARTMENT OF TRANSPORTATION STANDARD PLANS AND SPECIFICATIONS, 2015 EDITION, THE LATEST CALTRANS ADOPTED EDITION OF THE CALIFORNIA MANUAL ON UNIFORM TRAFFIC CONTROL DEVICES (CA-MUTCD), THE LATEST EDITION OF THE CITY OF SELMA STANDARD SPECIFICATIONS AND DRAWINGS.

2. THESE PLANS ARE ACCURATE FOR ELECTRICAL WORK ONLY.

3. NO ABOVE GROUND WORK, EXCEPT SERVICE EQUIPMENT, SHALL BE PERFORMED UNTIL THE CONTRACTOR HAS ALL MATERIALS ON HAND TO COMPLETE THAT PARTICULAR SIGNAL LOCATION OR LIGHTING CIRCUIT.

4. THE CONTRACTOR IS RESPONSIBLE FOR VERIFICATION OF ALL EXISTING UTILITIES WHETHER OR NOT THEY ARE SHOWN ON THESE PLANS, AND SHALL PROVIDE PROTECTION PRIOR TO, DURING AND AFTER TRENCHING, JACKING AND/ OR BORING. THE CONTRACTOR SHALL CONTACT UNDERGROUND SERVICE ALERT (USA), BY CALLING 1-800-227-2600 AT LEAST TWO (2) WORKING DAYS BEFORE BEGINNING WORK.

5. CONDUIT INSTALLATION ACROSS ROADWAYS SHALL BE BY JACKING AND DIRECTIONAL DRILLING METHODS UNLESS OTHERWISE NOTED ON THE PLANS.

6. CONTRACTOR SHALL ARRANGE WITH UTILITY COMPANIES FOR ALL REQUIRED UTILITY REALLOCATIONS, INCLUDING OVERHEAD CONFLICTS.

7. ALL TRAFFIC SIGNAL AND LIGHTING FACILITIES, INCLUDING CABINETS, STANDARDS, PULL BOXES, CONDUITS AND LOOP DETECTORS, ARE SHOWN IN THEIR APPROXIMATE LOCATIONS. AFTER ALL UNDERGROUND UTILITIES ARE MARKED, THE CONTRACTOR SHALL MARK FINAL LOCATIONS IN THE FIELD AND NOTIFY THE ENGINEER AT LEAST TWO (2) WORKING DAYS PRIOR TO COMMENCING WORK TO VERIFY THE MARKED LOCATIONS.

8. PULL BOXES SHALL BE NO. 5(E), UNLESS OTHERWISE NOTED ON THE PLANS. PULL BOXES SHALL NOT BE INSTALLED IN CURB RAMPS. ALL PULL BOXES SHALL BE AT A MAXIMUM OF 200' APART.

9. ALL PULL BOXES INSTALLED IN NON-CONCRETE AREAS SHALL BE SURROUNDED BY A ONE (1) FOOT WIDE CONCRETE COLLAR, TO A DEPTH EQUAL TO THE PULL BOX AND EXTENSION, PER CITY OF FRESNO SPECIFICATIONS. ALL CONDUIT ENTRIES INTO ADVANCE DETECTION, INTERMEDIATE DETECTION, AND STREET LIGHTING PULL BOXES INSTALLED IN NON-CONCRETE AREAS SHALL ENTER THE PULL BOX FROM THE BOTTOM, USING 90 DEGREE ELBOWS AND EXTENDING 3 TO 5 INCHES ABOVE THE FINISHED GROUT.

10. ALL CONDUITS SHALL HAVE BUSHINGS INSTALLED PRIOR TO INSTALLING CONDUCTORS. STEEL CONDUITS SHALL HAVE LAY IN STYLE LUGS THAT ARE CAST INTEGRAL WITH THE BUSHING.

11. CONDUIT BENDS OF 90 DEGREES ARE PROHIBITED UNLESS OTHERWISE NOTED OR WRITTEN PERMISSION IS GIVEN BY THE CITY OF SELMA ENGINEER.

12. ALL NEUTRAL CONDUCTORS SHALL BE WHITE IN COLOR THROUGHOUT THEIR ENTIRE LENGTH.

13. TRAFFIC SIGNAL CABLE SHALL NOT BE SPLICED BETWEEN THE CONTROLLER CABINET AND THE TERMINAL COMPARTMENTS MOUNTED ON THE POLES. DETECTOR CABLES SHALL NOT BE SPLICED BETWEEN THE CONTROLLER CABINET AND THE PULL BOX ADJACENT TO THE DETECTOR LEAD-IN.

14. SEAL CONDUIT WITH AN APPROVED DUCT SEAL AFTER ALL CONDUCTORS HAVE BEEN INSTALLED.
15. SEALANT FOR FILLING THE SAWCUT LOOPS SLOTS SHALL BE HOT-MELT RUBBERIZED ASPHALT SEALANT PER STATE OF CALIFORNIA SPECIFICATIONS. OR LOOP SEALANT SHALL BE ELASTOMERIC SEALANT 3M, BLACK 5000.

16. PEDESTRIAN PUSH BUTTONS SHALL HAVE 2" DIAMETER ACTUATORS AND COMPLY WITH THE AMERICANS WITH DISABILITIES ACT (ADA).

17. ALL VEHICLE AND PEDESTRIAN SIGNAL SECTIONS SHALL UTILIZE LIGHT EMITTING DIODE (LED) SIGNAL MODULES IN ACCORDANCE WITH THE STANDARD SPECIFICATIONS. VEHICLE SIGNAL SECTIONS SHALL HAVE 12" (300 mm) DIAMETER LENSES WITH BACKPLATES AND TUNNEL VISORS. ALL VEHICLE AND PEDESTRIAN SIGNAL SECTIONS SHALL HAVE METAL AND RUBBER WASHERS INSTALLED ON THE INSIDE OF THE HEAD.

18. FIXTURE BALLAST SHALL HAVE HIGH POWER FACTOR.

19. PEDESTRIAN SIGNAL UNITS SHALL BE FULL SYMBOL, MUTCD COMPLIANT, LED TYPE A. SIGNAL ALIGNMENT SHALL BE AS DIRECTED BY THE ENGINEER.

20. ALL SIGNS SHALL BE 3M-3930HIP TYPE III & IV SERIES REFLECTIVE SHEETING AND BE COVERED WITH 1160A PREMIUM OVERLAY ANTI-GRAFFITI FILM OR AVERY DENNISON T6500 SERIES REFLECTIVE SHEETING AND SHALL BE COVERED WITH AVERY DENNISON OL1000 ANTI-GRAFFITI OVERLAY FILM.

21. TONEABLE CONDUIT SHALL BE CHECKED FOR CONTINUITY AND BONDED TO EARTH GROUND.

22. CONDUITS EXITING THE CONTROLLER FOUNDATION AND ENTERING INTO THE CONTROLLER CABINET SHALL BE ALIGNED TO ENTER WITHIN THE TEES SPECIFIED CABINETS WITHOUT ANY MODIFICATIONS TO THE CABINET BASE.

23. ALL RESURFACING SHALL MATCH EXISTING SURFACES AFTER SIGNAL FACILITIES ARE REMOVED AND/OR RELOCATED.

24. ALL LUMINARE CIRCUITS SHALL BE FUSED. THE FUSE SHALL BE LOCATED IN THE POLE HAND HOLE AT EACH POLE (5 AMP KTK FUSE IN TRON HEB TYPE FUSE HOLDER).

25. THE CONTRACTOR SHALL FURNISH AND INSTALL POLE NUMBERS WHEN PG&E INDICATES THE NUMBER. POLE NUMBERS SHALL BE SHOWN ON THE AS-BUILT DRAWINGS.

26. THE CONTRACTOR SHALL FURNISH AND INSTALL AN ACCESSIBLE (AUDIBLE) PEDESTRIAN SIGNAL (APS) SYSTEM (2-WIRE POLARA NAVIGATOR OR APPROVED EQUAL) IN CONFORMANCE WITH THE PROJECT SPECIFICATIONS. THE APS SHALL PROVIDE BOTH A VIBRATING ARROW BUTTON AND AUDIBLE SOUNDS DURING THE "WALK" INTERVAL, AS WELL AS A LOCATING TONE DURING THE PEDESTRIAN CLEARANCE AND DON'T WALK INTERVALS. CONTRACTOR SHALL PROVIDE TO THE CITY OF SELMA A MEANS OF PROGRAMMING THE LATEST VERSION OF THE (APS) SYSTEM.

DESIGNED: J. BENAVIDES

DRAWN: C. AYALA-MAGANA

CHECKED: J. RIOS

DATE 02/23/2021

DATE 02/23/2021

DATE 02/23/2021

RECORD DRAWING

RESIDENT ENGINEER

DATE

811

CALL BEFORE YOU DIG

JLB TRAFFIC ENGINEERING, INC.

516 W. SHAW AVE., STE. 103
FRESNO, CA 93704
PHONE: (559) 570-8991
EMAIL: info@JLBtraffic.com

TENTATIVE PLANS FOR DESIGN

SUPERVISING ENGINEER

DATE

PROFESSIONAL SEAL

REGISTERED PROFESSIONAL ENGINEER
CIVIL
No. 00000000
Exp. 12/31/2022
STATE OF CALIFORNIA

PROJECT

GOLDEN STATE CORRIDOR - ECONOMIC DEVELOPMENT AND INFRASTRUCTURE IMPROVEMENTS

SELMA REGION


CITY OF SELMA

DEPARTMENT OF PUBLIC WORKS AND PLANNING

WHITSON ST AT FLORAL AVE
EQUIPMENT AND CONDUCTOR SCHEDULE

DRAWING NO. E-6 SHEET NO. 117 TOTAL 154

PLOT DATE: 2/23/2021 8:29:27 AM
C:\Users\AYALA\OneDrive\Documents\Projects\009 Fresno County\009-009 Golden State PS&E\Traffic Signal Designs\2a Whitson at Floral Ave.dwg
P:\H-Z\01 Projects\009 Fresno County\009-009 Golden State PS&E\Traffic Signal Designs\2a Whitson at Floral Ave.dwg


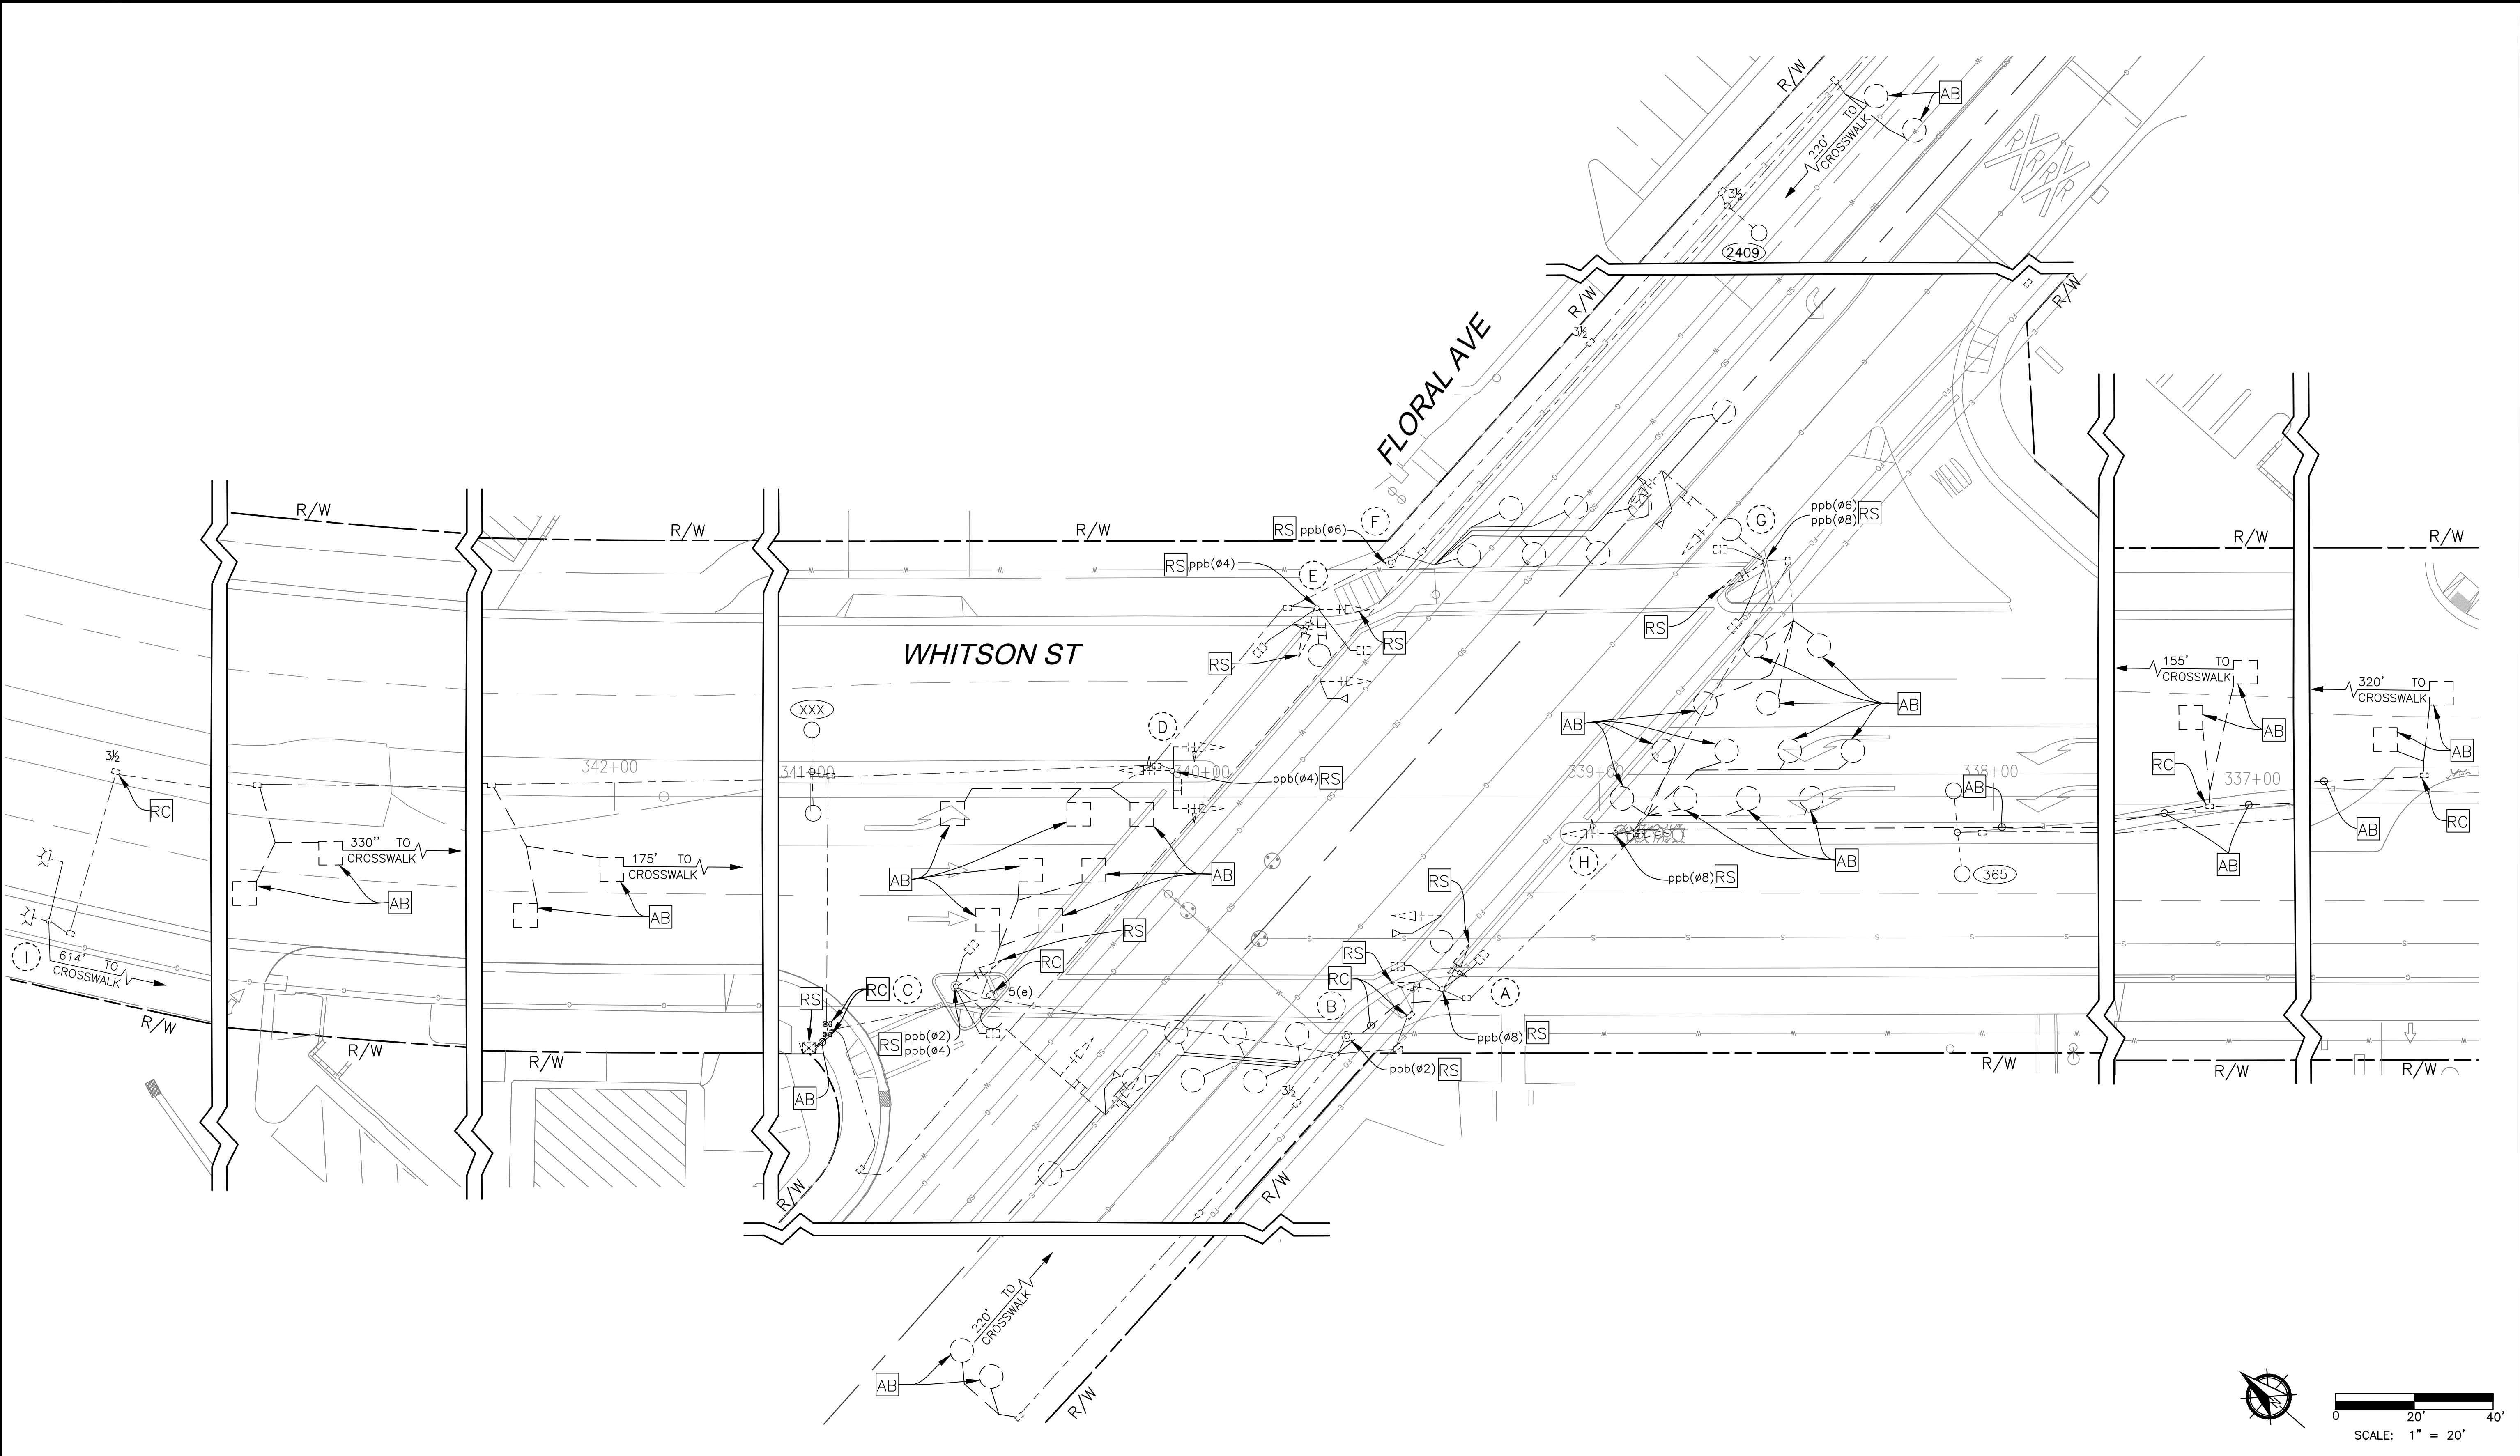


		DATE	RECORD DRAWING		 CALL BEFORE YOU DIG	 516 W. SHAW AVE., STE. 103 FRESNO, CA 93704 PHONE: (559) 570-8991 EMAIL: info@JLBtraffic.com		PROJECT			DEPARTMENT OF PUBLIC WORKS AND PLANNING			
DESIGNED:	J. BENAVIDES	02/23/2021	RESIDENT ENGINEER					DATE	GOLDEN STATE CORRIDOR - ECONOMIC DEVELOPMENT AND INFRASTRUCTURE IMPROVEMENTS		WHITSON ST AT FLORAL AVE DEMOLITION PLAN			
DRAWN:	C. AYALA-MAGANA	02/23/2021												
CHECKED:	J. RIOS	02/23/2021												
FOR RIGHT OF WAY DATA AND ACCURATE ACCESS DETERMINATION, SEE DOCUMENTS IN THE DEPARTMENT OF PUBLIC WORKS AND PLANNING.														
						TENTATIVE PLANS FOR DESIGN		SUPERVISING ENGINEER		DATE				
								SELMA REGION						
										DRAWING NO. E-7 SHEET NO. 118 TOTAL 154				


PATH: Z:\01 Projects\009 Fresno County\009-009 Golden State Blvd at Highland Ave\Golden State Blvd at Highland Ave\Golden State Blvd at Highland Ave.dwg PLOT DATE: 2/23/2021 9:53:04 AM CAD USER: CAYALA

POLE PLACEMENT LOCATION		
POLE	LOCATION	
(B')	GOLDEN STATE BLVD	STA 362 + 67.85, 40.03' R
(J)	GOLDEN STATE BLVD	STA 362 + 60.61, 67.21' R
(K)	GOLDEN STATE BLVD	STA 361 + 45.81, 47.95' R
(L)	GOLDEN STATE BLVD	STA 361 + 68.57, 85.51' L
(M)	HIGHLAND AVE	STA 15 + 2.19, 19.93' L

PROPOSED PHASE DIAGRAM – GOLDEN STATE BLVD AT HIGHLAND AVE

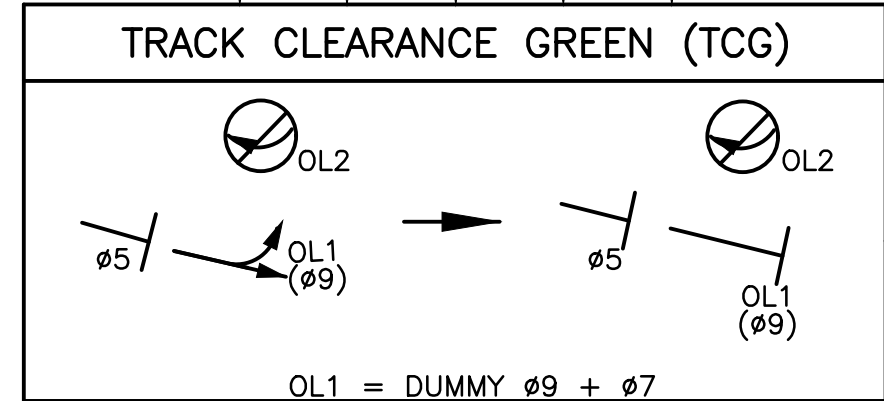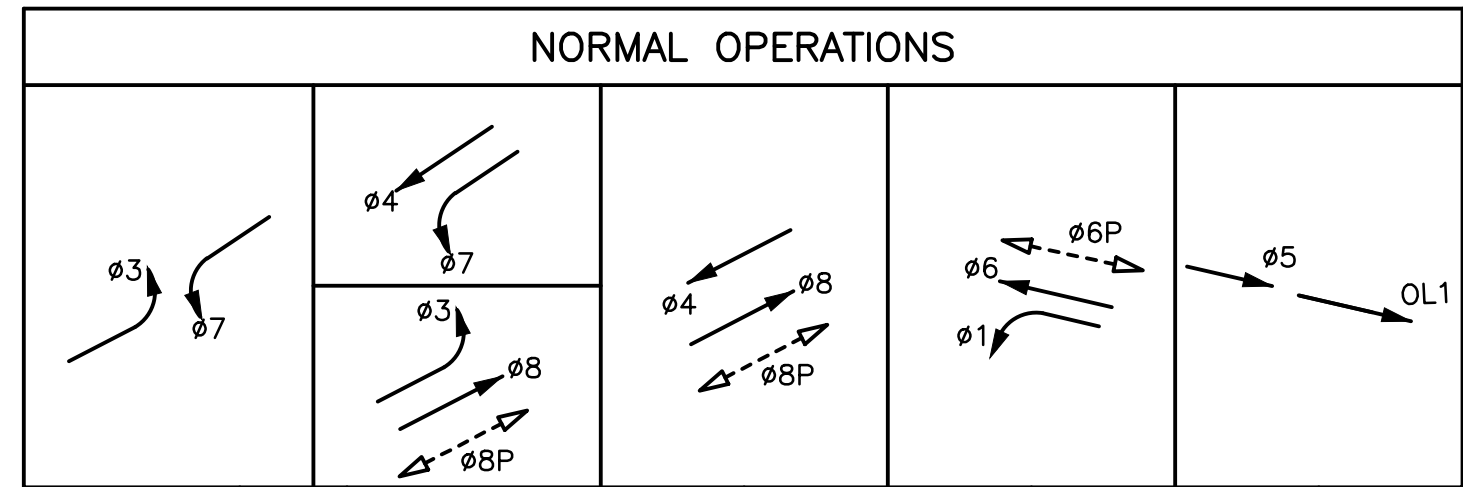

ADVANCE TO LIMITED SERVICE OPERATIONS WHEN FULL TCG TIME HAS BEEN PROVIDED AND AT LEAST 4 SECONDS AFTER GD CIRCUIT CLOSURE.


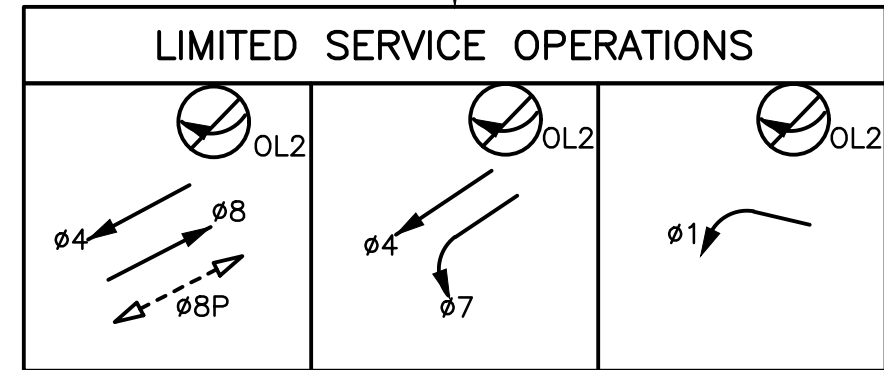


TCR = TRAFFIC CONTROL RELAY. PROVIDES ADVANCED PREEMPTION NOTIFICATION.
XR = CROSSING RELAY. PROVIDES NOTIFICATION THAT GRADE CROSSING WARNING DEVICES HAVE BEEN ACTIVATED.
GD = GATE DOWN RELAY. PROVIDES NOTIFICATION THAT RR ENTRANCE GATE DESCENT IS ALMOST COMPLETE.


* = "NO RIGHT-TURN" BLANKOUT SIGN IS ILLUMINATED WHILE XR CIRCUIT IS ACTIVE.

EMERGENCY VEHICLE PREEMPTION (EVP)


EVA = OL1 + 05
EVB = 04 + 07
EVC = 01 + 06
EVD = 03 + 08

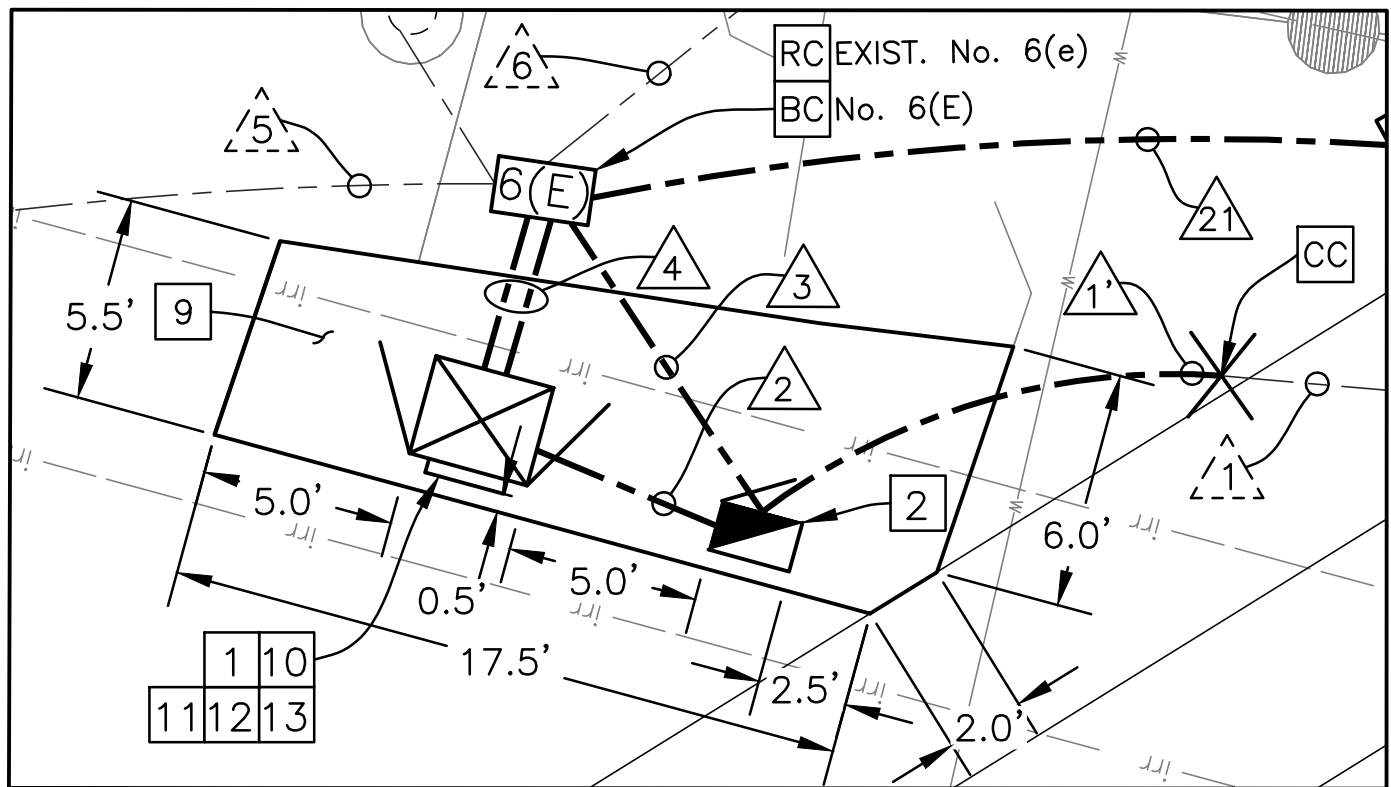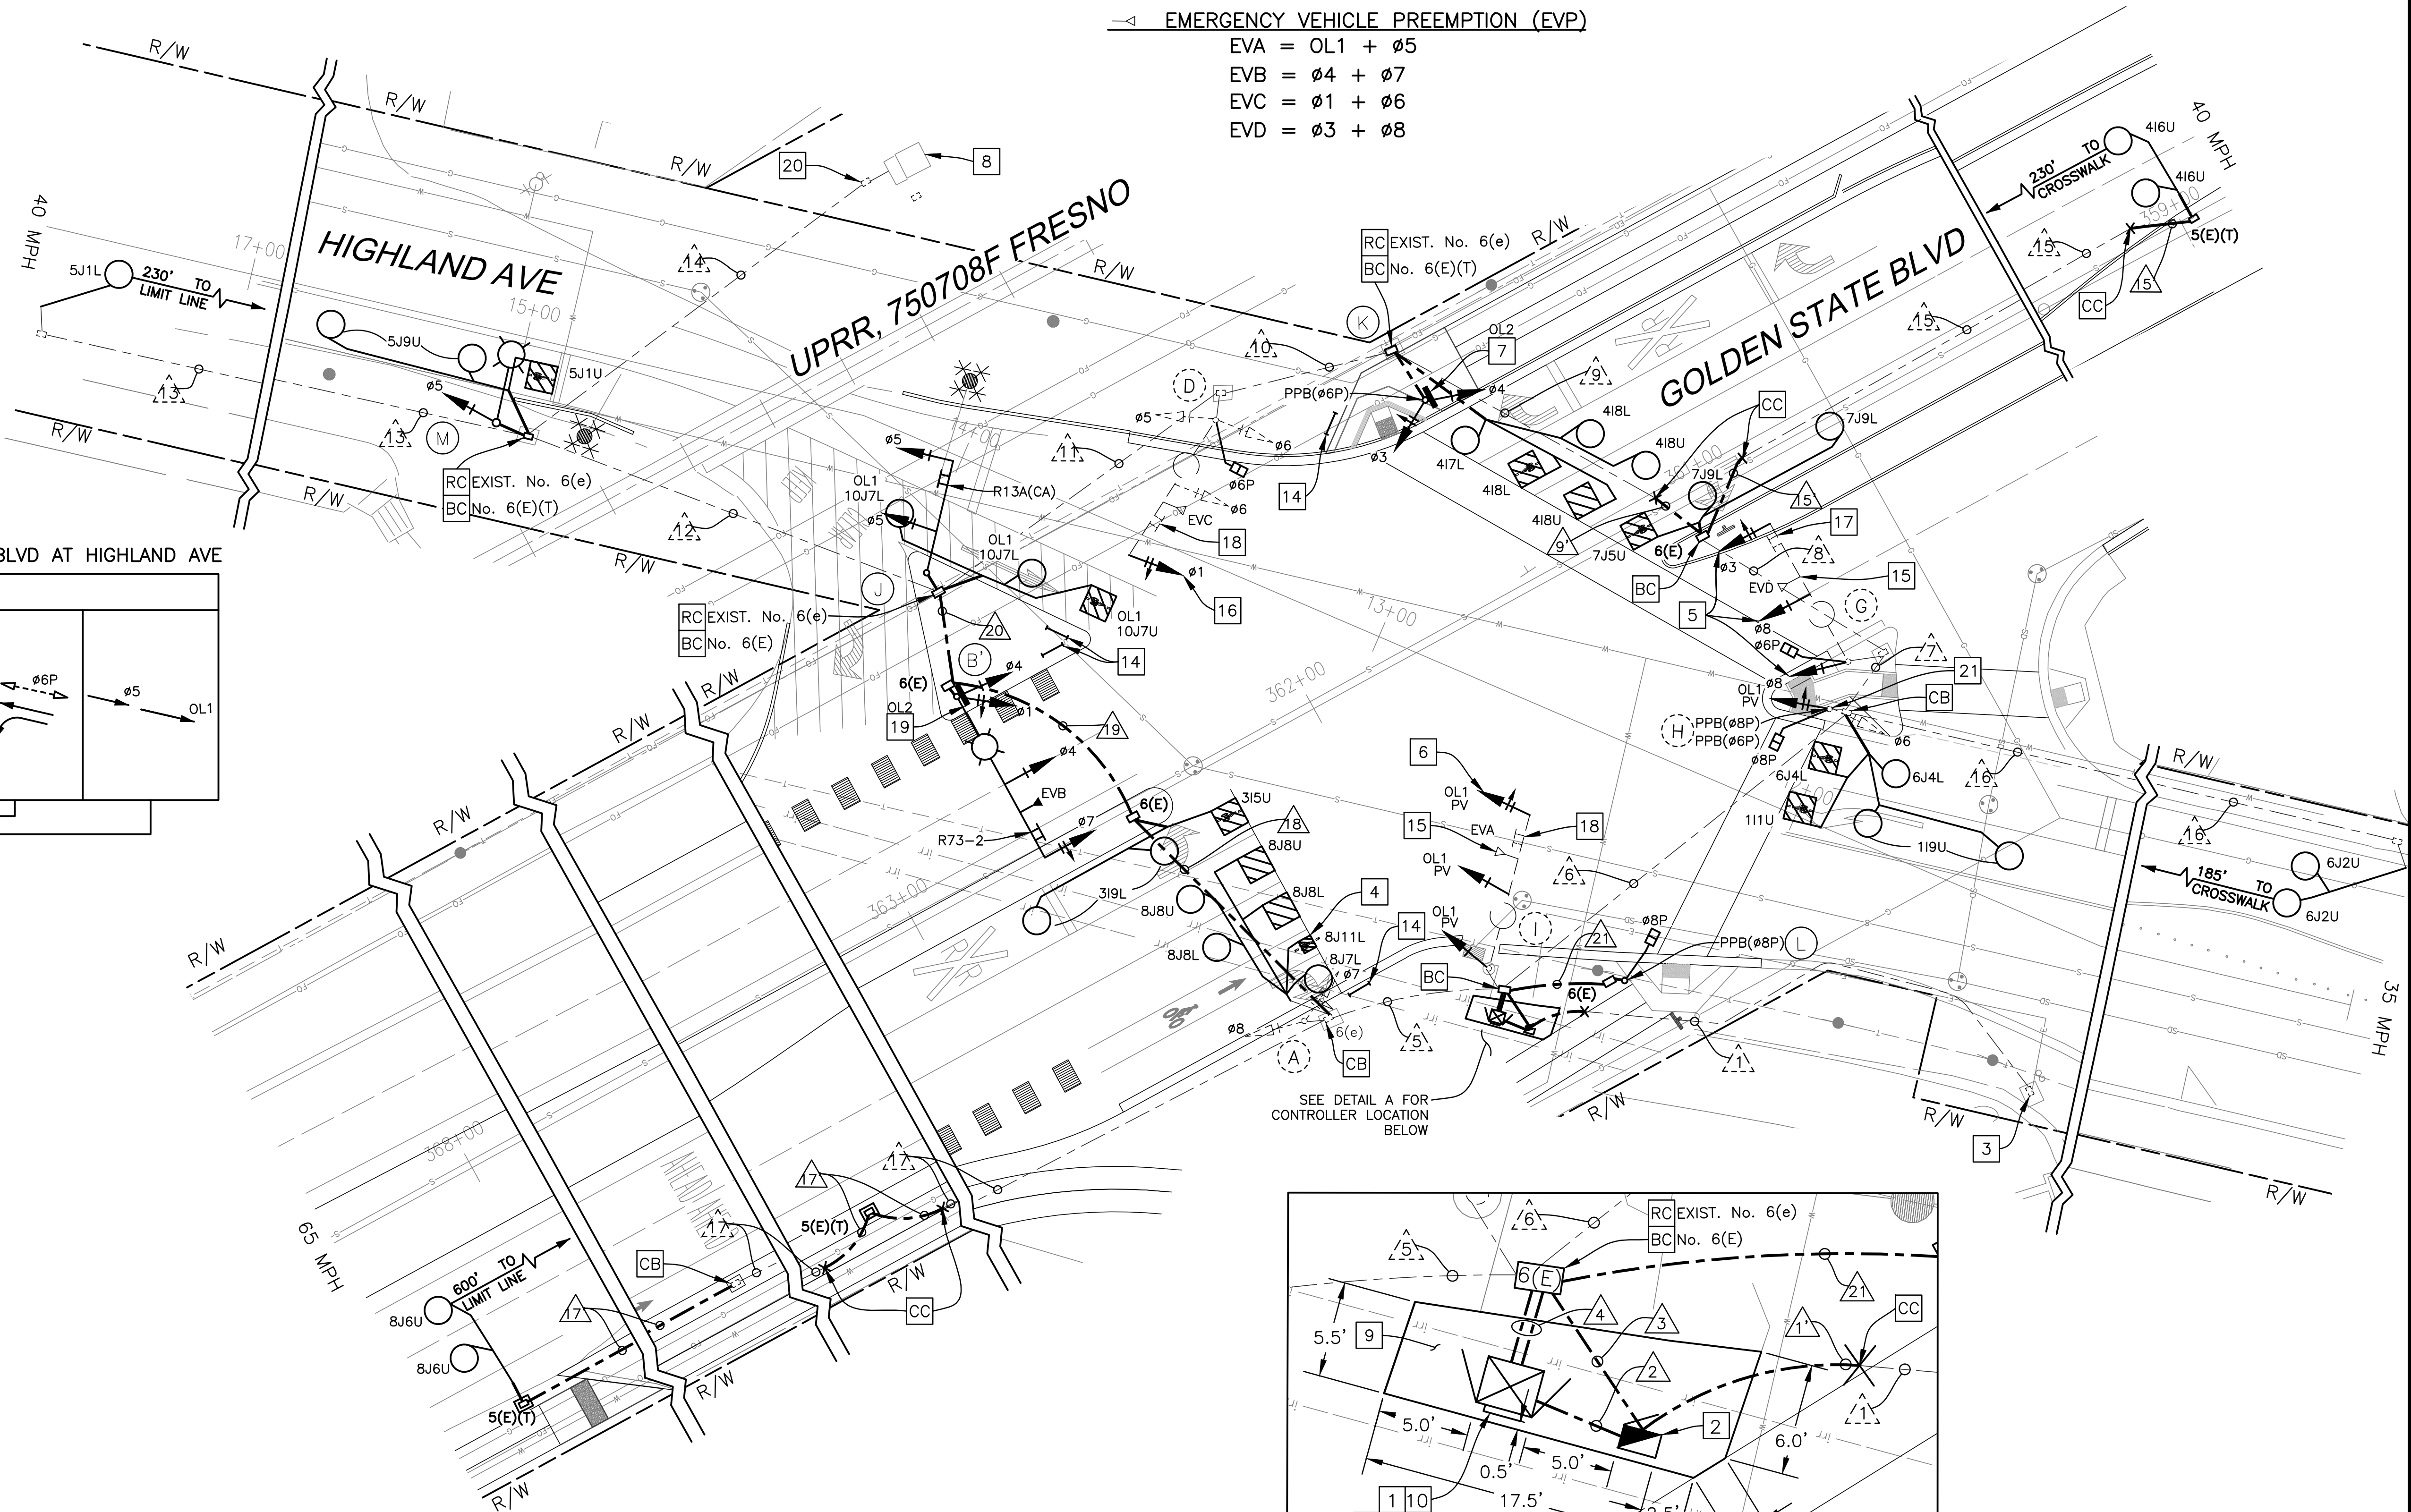

CONTROLLER LOCATION – DETAIL A
NO SCALE

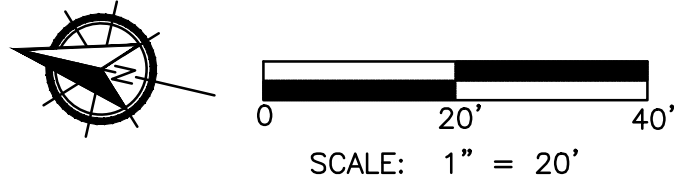

DESIGNED:		DATE	RECORD DRAWING	
J. BENAVIDES		02/23/2021	RESIDENT ENGINEER	
DRAWN:		DATE	DATE	
C. AYALA-MAGANA		02/23/2021		
CHECKED:		DATE	DATE	
J. RIOS		02/23/2021		

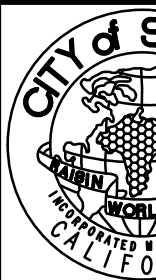

CAD USER: CAYALA
PLOT DATE: 2/23/2021 8:33:28 AM
PATH: Z:\01 Projects\009 Fresno County\009-Golden State Blvd at Highland Ave\Golden State Blvd at Highland Ave.dwg

PROJECT NOTES (FOR SHEETS E-8 THROUGH E-11 ONLY):

- 1

FURNISH AND INSTALL TYPE 2070LX (76.13P FIRMWARE) AND NEW 332L CABINET WITH ALL ANCILLARY DEVICES FOR A FULL EIGHT PHASE OPERATION. FRONT DOOR OF CABINET SHALL FACE NORTHWEST. FURNISH AND INSTALL NEW BATTERY BACK-UP SYSTEM PER THE STATE SPECIAL PROVISIONS. BATTERY BACK-UP EXTERNAL CABINET SHALL BE ON THE SOUTHWEST SIDE OF THE CONTROLLER ASSEMBLY.
- 2

INSTALL NEW TYPE III-AF SERVICE CABINET (TESCO 26-100 OR APPROVED EQUAL). CONTRACTOR SHALL COORDINATE WITH PG&E FOR DISCONNECT AND RECONNECT TO THE EXISTING POINT OF SERVICE.
- 3

EXISTING PG&E POINT OF SERVICE PULL BOX.
- 4

INSTALL 3'X3' BIKE LOOP PER DETAIL C.
- 5

INSTALL DIRECTIONAL LOUVERS TO ENSURE THAT THE VEHICULAR SIGNAL HEAD IS ONLY VISIBLE TO TRAFFIC IT IS INTENDED FOR.
- 6

INSTALL 4-SECTION SIGNAL HEAD PER DETAIL D.
- 7

FURNISH AND INSTALL R3-1 (24" x 24") INTERNALLY ILLUMINATED BLANK OUT SIGN PER DETAIL E AND DETAIL F.
- 8

EXISTING RAILROAD CONTROLLER TO REMAIN. INTERCONNECTION TO THE RR SIGNAL SYSTEM SHALL BE MAINTAINED AT ALL TIMES DURING CONSTRUCTION.
- 9

INSTALL 122 SQUARE FEET OF 3.5" PCC PAD.
- 10

THE ADVANCED PREEMPTION INTERCONNECTION SHALL BE CONFIGURED AS A "SUPERVISED" CIRCUIT. A PREEMPTION INTERCONNECTION CIRCUIT SHALL BE IMPLEMENTED IN THE TRAFFIC SIGNAL CONTROLLER. CONTRACTOR SHALL WORK WITH RAILROAD, AND BE RESPONSIBLE FOR APPROVAL, TO CONNECT TO THE ADVANCED PREEMPTION CIRCUIT. A "GATE-DOWN" CIRCUIT SHALL BE IMPLEMENTED IN THE TRAFFIC SIGNAL CONTROLLER. THE RAILROAD WILL PROVIDE THE GATE DOWN CIRCUIT FOR CONNECTION TO THE TRAFFIC SIGNAL CONTROLLER AS PART OF THE RAILROAD'S STANDARD DESIGN. A TRAFFIC SIGNAL HEALTH CIRCUIT SHALL BE IMPLEMENTED INTO THE SIGNAL CONTROLLER.
- 11

CONTRACTOR SHALL INSTALL THE FOLLOWING WARNING LABEL WITHIN THE TRAFFIC SIGNAL CONTROLLER CABINET:
 - IF THE TRAFFIC SIGNAL ENTERS FLASHING MODE, NOTIFY THE RAILROAD AND PROVIDE FOR THE SAFE MOVEMENT OF ROADWAY USERS OVER THE GRADE CROSSING.
 - IF THE TRAFFIC SIGNAL LOSES POWER OR ALL OF THE SIGNALS ARE DARK, NOTIFY THE RAILROAD AND PROVIDE FOR THE SAFE MOVEMENT OF THE ROADWAY USERS OVER THE GRADE CROSSING.
 - NOTIFY THE RAILROAD ONCE THE SIGNAL SYSTEM HAS BEEN RESTORED TO NORMAL OPERATION.
 - IF SIGNAL MAINTENANCE IS REQUIRED TO PERFORM A JOINT TEST OF THE PREEMPTION SYSTEM, NOTIFY THE RAILROAD.
- 12

CONTRACTOR SHALL INSTALL WARNING LABEL WITHIN CONTROLLER CABINET AS RECOMMENDED IN THE USDOT HIGHWAY RAIL GRADE CROSSING TECHNICAL WORKING GROUP RECOMMENDATIONS TO ALERT TRAFFIC SIGNAL TECHNICIANS TO THE PRESENCE OF THE INTERCONNECTION WITH THE RAILROAD. SEE SAMPLE TO THE RIGHT.
- 13

COORDINATE WITH UPRR FOR THE INSTALLATION OF RAILROAD PREEMPTION CABLING AND TESTING OF THE REQUIRED RAILROAD PREEMPTION CIRCUITS. CONTACT UPRR PRIOR TO ANY WORK WITHIN UPRR RIGHT-OF-WAY OR ANY WORK AFFECTING GRADE CROSSING OPERATIONS.
- 14

FURNISH AND INSTALL NEW TYPE I PED BARRICADE WITH R9-3A.
- 15

EXISTING EVP SHALL BE PROTECTED AND RELOCATED TO NEW SIGNAL HEAD MOUNTING.
- 16

FURNISH AND INSTALL NEW 3-SECTION ARROW SIGNAL HEAD.
- 17

EXISTING R73-2 ON SMA.
- 18


EXISTING R73-3 ON SMA.
- 19

FURNISH AND INSTALL R3-1 (24" x 24") INTERNALLY ILLUMINATED BLANK OUT SIGN PER DETAIL E AND DETAIL G.
- 20


COORDINATE WITH UPRR FOR THE INSTALLATION OF RAILROAD PREEMPTION CABLING AND TESTING OF THE REQUIRED RAILROAD PREEMPTION CIRCUITS. CONTACT UPRR PRIOR TO ANY WORK WITHIN UPRR RIGHT OF WAY OR ANY WORK AFFECTING GRADE CROSSING OPERATIONS.
- 21

INSTALL 1 DLC FROM PPB(Ø6) TO PPB(Ø8)

POLE	PG&E POLE NUMBER
B	3929
B'	3929
D	3930
G	3931
I	3932

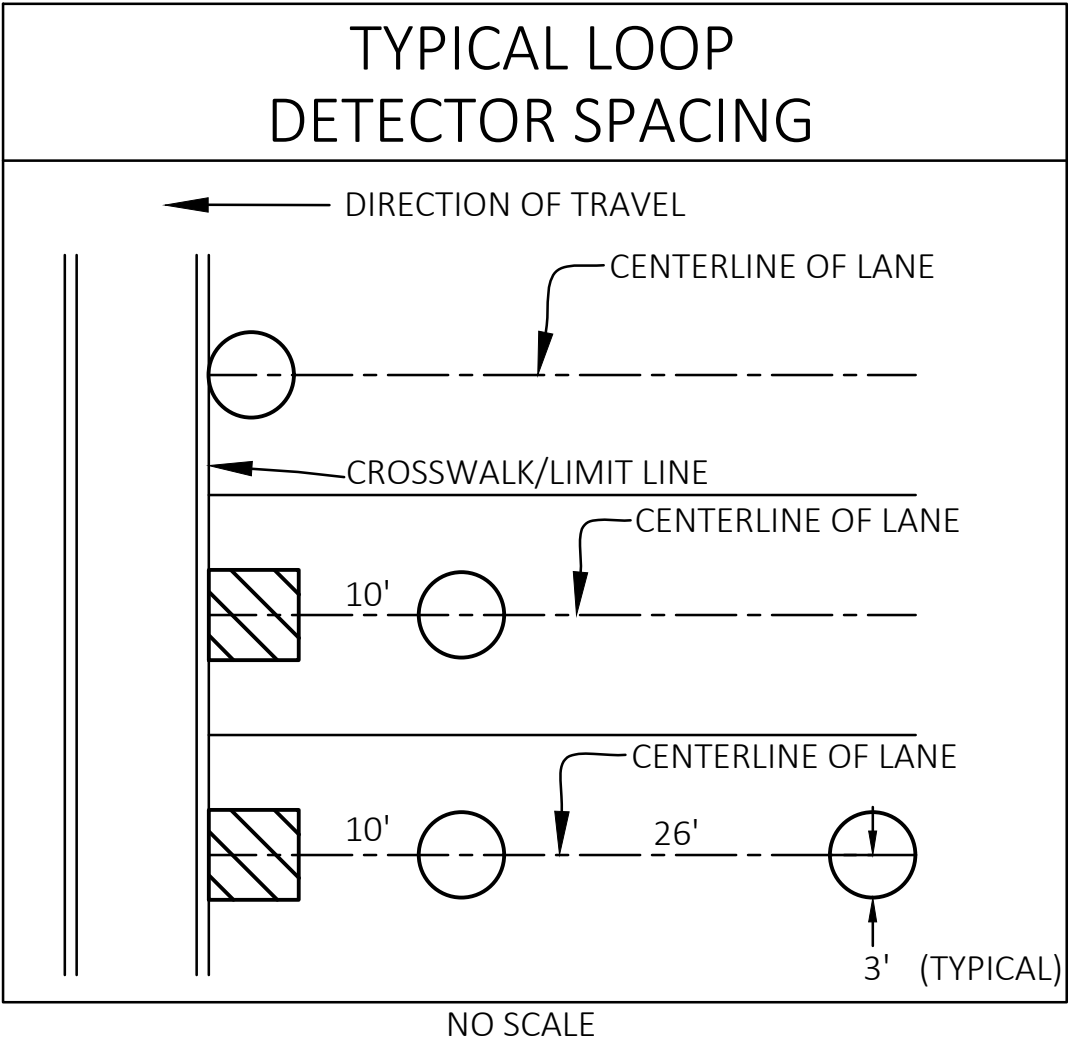

TYPICAL LOOP DETECTOR PLACEMENT – DETAIL B

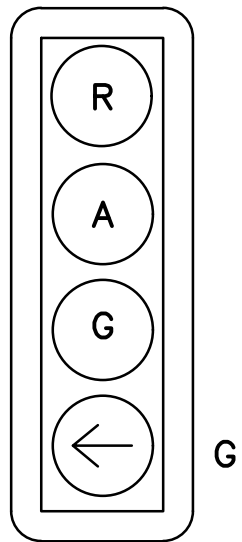


4-SECTION SIGNAL HEAD – DETAIL D

DETAIL D NOTES


- 1

ROUND CORNERS OF ACUTE ANGLE SAWCUTS TO PREVENT DAMAGE TO CONDUCTORS.
- 2

INSTALL 3 TURNS WHEN ONLY ONE BIKE LOOP IS ON A SENSOR UNIT CHANNEL. INSTALL 5 TURNS WHEN ONE BIKE LOOP IS CONNECTED IN SERIES WITH 3 ADDITIONAL 6' X6' LOOPS ON A SENSOR UNIT CHANNEL.

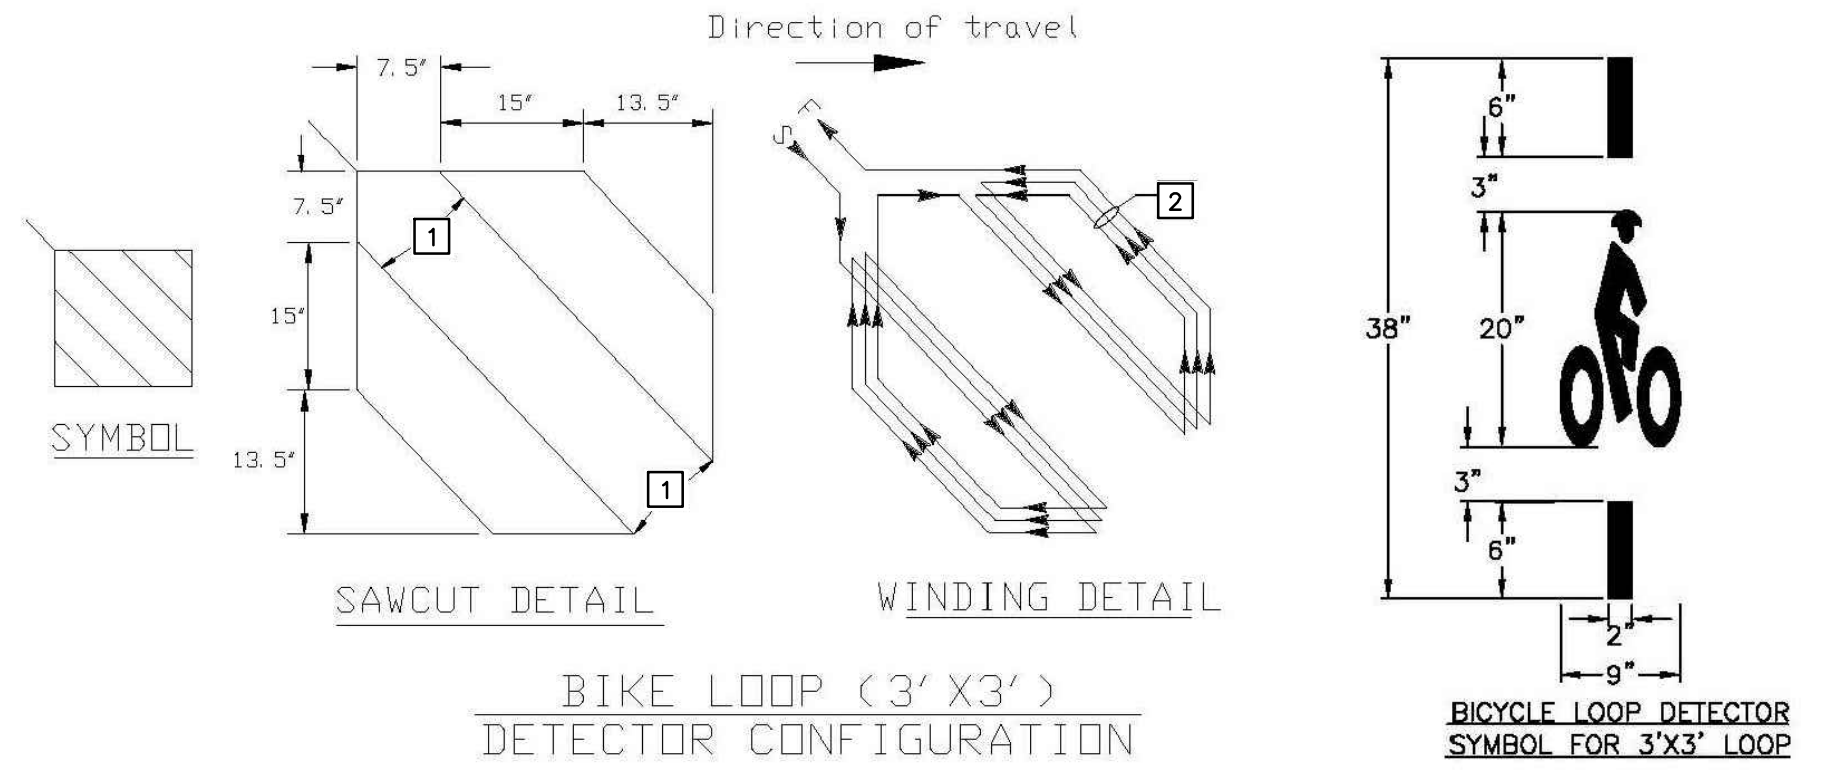

TYPE D 3'X3' BIKE LOOP – DETAIL C
NO SCALE

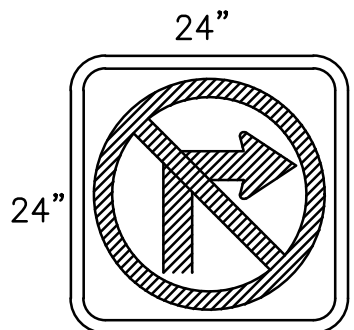

R3-1 BLANK OUT SIGN (24" x 24") – DETAIL E

LEGEND (FOR SHEETS E-8 THROUGH E-11 ONLY):

- TYPE E CIRCULAR LOOP DETECTOR CONFIGURATION PER STATE STANDARD PLAN ES-5B. LOOP SEALANT SHALL BE STATE APPROVED ELASTOMERIC SEALANT OR HOT MELT RUBBERIZED.
- EXISTING TYPE E LOOP DETECTOR.
- TYPE D RECTANGULAR LOOP DETECTOR CONFIGURATION PER STATE STANDARD PLAN ES-5B. LOOP SEALANT SHALL BE STATE APPROVED ELASTOMERIC SEALANT OR HOT MELT RUBBERIZED. BICYCLE DETECTOR SYMBOL TO BE INSTALLED PER CALTRANS STANDARD PLAN A24-C ON CENTER OF THE DETECTOR.
- EMERGENCY VEHICLE PREEMPTION (EVP) DETECTION UNIT EVA (DENOTES CHANNEL).
- EXISTING EMERGENCY VEHICLE PREEMPTION (EVP DETECTION UNIT).

- NEW CONDUIT
- EXISTING CONDUIT

- PROGRAMMABLE VISIBILITY VEHICLE SIGNAL HEAD
- ABANDON, IF APPLIED TO CONDUIT, REMOVE CONDUCTORS.
- REMOVE AND SALVAGE EQUIPMENT.
- EQUIPMENT OR MATERIAL TO BE REMOVED SHALL BECOME THE PROPERTY OF THE CONTRACTOR.
- FOUNDATION TO BE ABANDONED. REMOVE TOP OF FOUNDATION TO A POINT 36" BELOW THE FINISH GRADE.
- CONNECT NEW AND EXISTING CONDUIT. REMOVE EXISTING CONDUCTORS AND INSTALL CONDUCTORS AS INDICATED.
- INSTALL NEW CONDUIT INTO EXISTING PULL BOX.
- INSTALL PULL BOX IN EXISTING CONDUIT RUN.
- SPLICE NEW TO EXISTING CONDUCTORS.

CONSTRUCTION NOTES (FOR SHEETS E-8 THROUGH E-11 ONLY):

1.

ALL PULL BOXES ACCESSED BY CONTRACTOR SHALL BE CLEANED OF ALL DIRT AND DEBRIS, ANY CRACKS GROUTED AND ALL CONDUITS DUCT SEALED.
2.

REPLACE ALL PULLBOXES IN DIRT AREAS WITH TRAFFIC RATED PULLBOXES.
3.


ALL PULLBOXES SHALL BE LEVELED TO FINISH GRADE (NEW AND EXISTING).
4.

ALL PULLBOXES IN DIRT AREAS SHALL HAVE 1" COLLAR PER GENERAL NOTE 10 (NEW AND EXISTING).
5.


ANY BROKEN/DAMAGED PULLBOXES SHALL BE REPLACED.
6.

ALL PULLBOXES SHALL HAVE LOCKING LIDS. TRAFFIC RATED LIDS SHALL BE WELDED CLOSED AFTER FINAL INSPECTION.
7.

ALL UNUSED CONDUCTORS SHALL BE REMOVED.

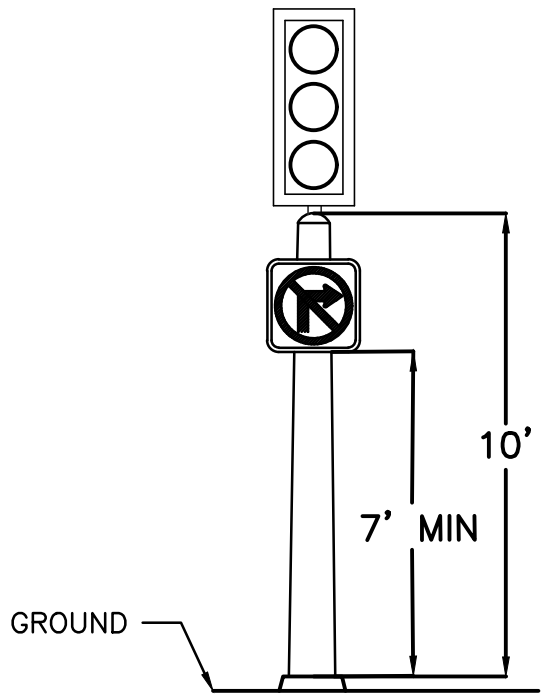

1-A (10') BLANK-OUT SIGN PLACEMENT – DETAIL F
NO SCALE

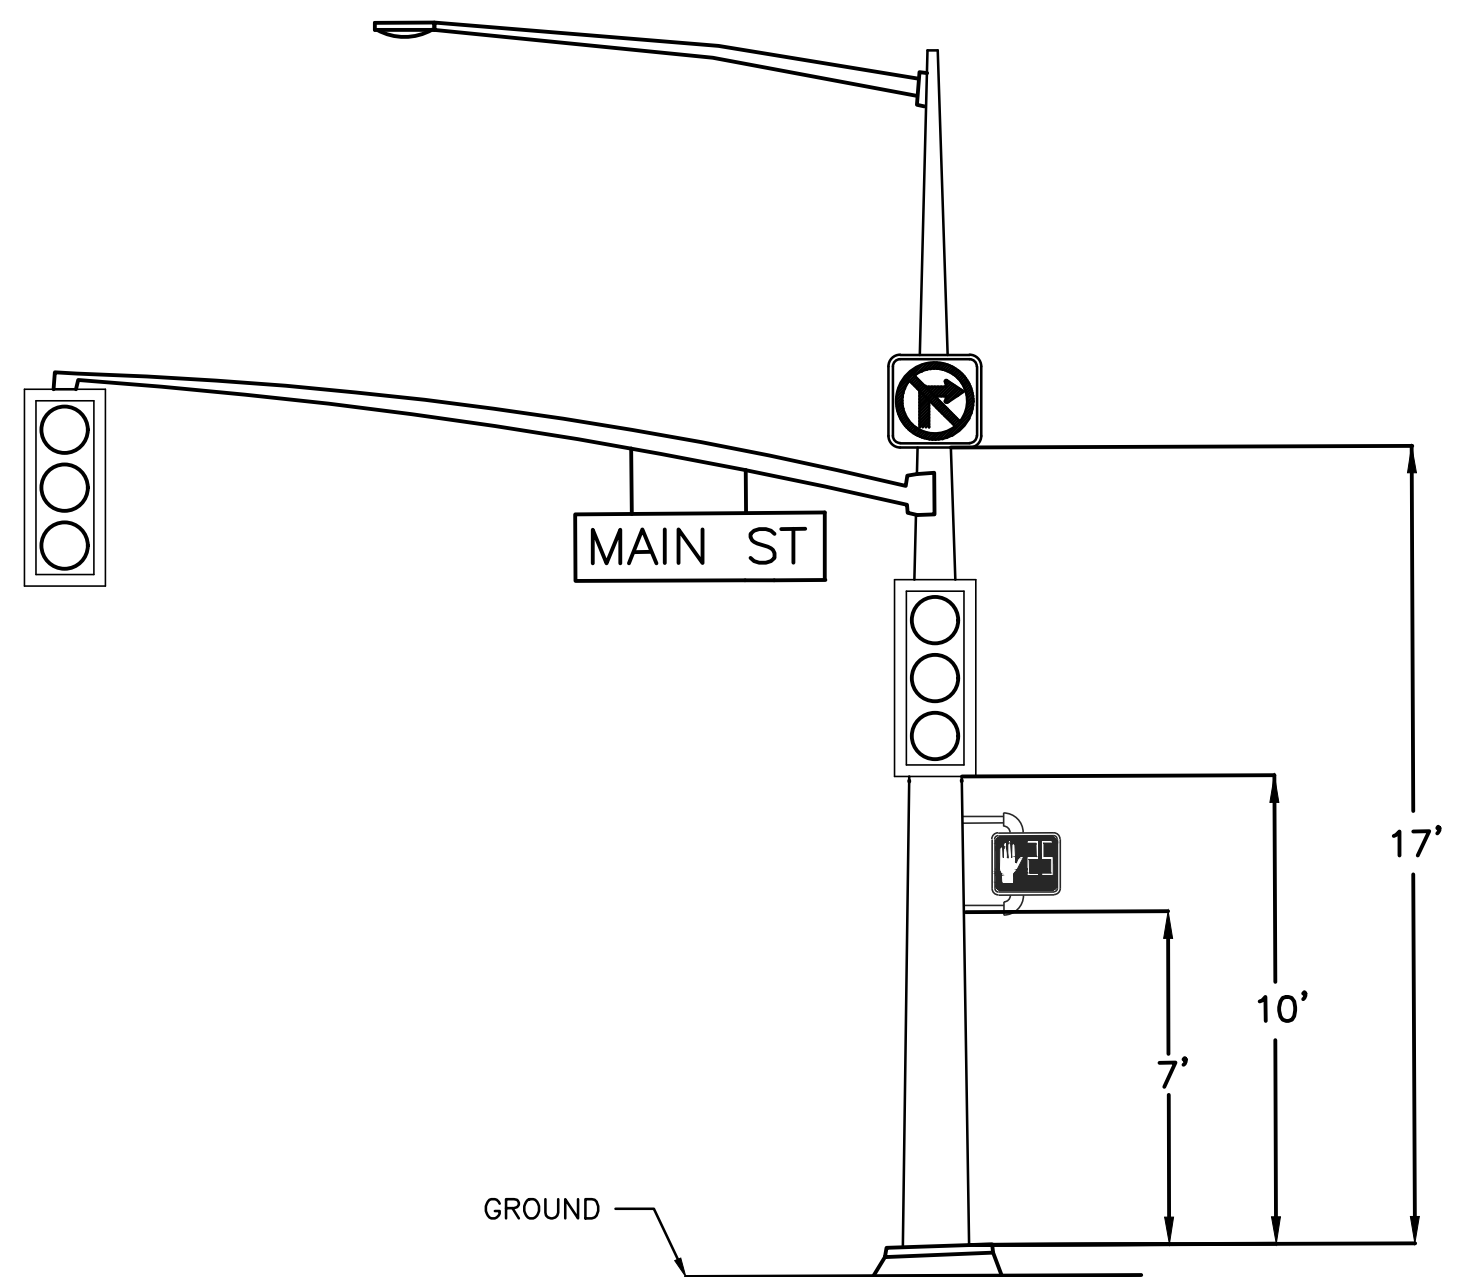

BLANK-OUT SIGN PLACEMENT – DETAIL G
NO SCALE

		DATE	RECORD DRAWING			 516 W. SHAW AVE., STE. 103 FRESNO, CA 93704 PHONE: (559) 570-8991 EMAIL: info@JLBtraffic.com		PROJECT			DEPARTMENT OF PUBLIC WORKS AND PLANNING			
DESIGNED:	J. BENAVIDES	02/23/2021	RESIDENT ENGINEER	DATE				GOLDEN STATE CORRIDOR - ECONOMIC DEVELOPMENT AND INFRASTRUCTURE IMPROVEMENTS			GOLDEN STATE BLVD AT HIGHLAND AVE DETAILS AND NOTES			
DRAWN:	C. AYALA-MAGANA	02/23/2021						SELMA REGION			DRAWING NO. E-9		SHEET NO. 120	TOTAL 154
CHECKED:	J. RIOS	02/23/2021												
FOR RIGHT OF WAY DATA AND ACCURATE ACCESS DETERMINATION, SEE DOCUMENTS IN THE DEPARTMENT OF PUBLIC WORKS AND PLANNING.														

CAD USER: CAYALA
PLOT DATE: 2/23/2021 1:22:50 PM
PATH: Z:\01 Projects\009 Fresno County\009-009 Golden State PS&E\Traffic Signal Designs\21 Golden State Blvd at Highland Ave.dwg

CONDUCTOR SCHEDULE																												
AWG OR CABLE	POLE	Ø	CONDUIT RUN NUMBER AND SIZE																									
			1	1	2	3	4	5	6	7	8	9	9	10	11	12	13	14	15	15	16	17	17	18	19	20	21	
			(2")	2"	2"	2"	2-4"	(3")	(3")	(3")	(3")	(3")	3"	(3")	(3")	(2")	(2")	(2")	(1.5")	(2")	2"	(2")	(2")	2"	4"	4"	4"	4"
CONDUIT FILL			13%	13%	8%	7%	19%	32%	33%	24%	19%	17%	17%	11%	1%	29%	4%	22%	4%	4%	4%	4%	4%	15%	14%	10%	15%	
7 COND. CABLE (VEH.) *	A	7,8	-	/	/	/	/	1	-	1	-	/	/	/	/	/	/	/	/	/	/	/	/	/	/	/	/	/
	B'	1,4,7	-	/	/	/	/	2	-	2	-	/	/	/	/	/	/	/	/	/	/	/	/	2	-	2	-	/
	D	1,5,6	6P	/	/	/	/	2	/	/	2	2	2	2	2	2	2	2	2	2	2	2	/	/	/	/	/	/
	G	3,8	6P	/	/	/	/	1	/	1	/	1	1	1	1	1	1	1	1	1	1	1	/	/	/	/	/	/
	H	0L1,6	8P	/	/	/	/	1	/	1	/	1	1	1	1	1	1	1	1	1	1	1	/	/	/	/	/	/
	I	0L1	-	/	/	/	/	1	-	/	/	/	/	/	/	/	/	/	/	/	/	/	/	/	/	/	/	/
	J	5	-	/	/	/	/	1	-	1	-	/	/	/	/	/	/	/	/	/	/	/	/	1	-	1	-	1
	K	3,4	-	/	/	/	/	1	-	/	-	1	-	1	-	1	-	/	/	/	/	/	/	/	/	/	/	/
	L	-	8P	/	/	/	/	-	/	/	/	/	/	/	/	/	/	/	/	/	/	/	/	/	/	/	/	-
	M	5	-	/	/	/	/	1	-	1	-	/	/	/	/	/	1	-	/	/	/	/	/	/	1	-	1	-
TOTAL							11	5	5	4	3	3	3	2	1	1	-	/	/	/	/	/	4	4	2	-	-	1
3 COND. CABLE (PPB)	H	6,8					1		1																			
	K	6					1		1	1	1	1	1															
	L	8					1																					1
TOTAL							3		2	1	1	1	1															1
TYPE C DETECTOR LEAD-IN CABLE	Ø1						2		2																			
	Ø3						2	2																2				
	Ø4						4		4	4	4	3	3					1	1									
	Ø5						3	3								3	1							3	3	3		
	Ø6						2		2											1								
	Ø7						2		2	2	2										1							
	Ø8						5	5													1	1						
	0L1						2	2															2	2	2			
TOTAL DLC							22	12	10	6	6	3	3			3	1		1	1	1	1	7	5	5			
# 2	SERVICE		3	3																								
# 4	SIGNAL POWER				2																							
# 6	SAFETY LIGHTS				2			2	2	2	2	2	2	2	2	2							2	2	2			
# 8	BONDING WIRE				1	1		1	1	1	1	1	1	1	1	1	1	1	1	1	1	1	1	1	1	1	1	
# 14	BLANK OUT SIGN						4	4						2	2									4	4	2		
12 COND. CABLE (#14 AWG)	R,R INTERCONNECT						1	1								1		1						1	1	1		
EVP CABLE 3 COND.	EVA (S/B)						1																					
	EVb (W/B)						1	1																1	1			
	EVC (N/B)						1		1	1	1	1	1	1														
	EVD (E/B)						1		1	1																		

* NUMBER INDICATIONS ARE THE NUMBER OF CABLES WITHIN CONDUIT.
ALL CONDUCTORS ARE NEW UNLESS OTHERWISE INDICATED WITH "(I)".

EQUIPMENT SCHEDULE													
No.	STANDARD			VEH SIG MTG		PED SIGNAL		PPB		LED LUMINAIRE WATTAGE	EV PREEMPT	SPECIAL REQUIREMENTS	
	Type	Sig.	M.A.	Lum.M.A.	Mast Arm	Pole	Ø	MTG	Ø	ARROW			
A	1-A (10')	-	-	-	-	TV-2-T	-	-	-	-	-		
B	26-4-70	40'	15'	MAT MAS	SV-2-T	-	-	-	-	90W	-	RS	EXISTING POLE AND ALL EQUIPMENT ATTACHED TO IT.
B'	26-4-100 (N)	40' (N)	15' (N)	MAT (N) MAS (N)	SV-2-T (N) SV-1-T (N)	-	-	-	-	95W (N)	EVb (N)		FURNISH AND INSTALL EVb AND R73-2 SIGN ON SMA COMPLETE WITH MOUNTING HARDWARE. FURNISH AND INSTALL 3-SECTION ARROW HEAD ON SMA. R3-1 INTERNALLY ILLUMINATED BLANK OUT SIGN ON POLE COMPLETE WITH MOUNTING HARDWARE.
C	1-A (10')	-	-	-	TV-1-T	-	-	-	-	-	-	RS	EXISTING POLE AND ALL EQUIPMENT ATTACHED TO IT.
D	24-4-70	35'	15'	MAT (N) MAS	SV-2-T	6 (N)	SP-1-T (N)	-	-	90W	EVC	RS	EXISTING EVC AND SNS "Golden State" MOUNTED ON SIGNAL POLE TO REMAIN. FURNISH AND INSTALL 3-SECTION ARROW HEAD ON SMA. EXISTING ø6 SP-1-T MOUNTED PED SIGNAL. FURNISH AND INSTALL NEW PEDESTRIAN HEAD.
E	1-A (10')	-	-	-	TV-2-T	-	-	6	RIGHT	-	-	RS	EXISTING POLE AND ALL EQUIPMENT ATTACHED TO IT.
F	PPB POST (2 1/2")	-	-	-	-	-	-	6	RIGHT LEFT	-	-	RS	EXISTING POLE AND ALL EQUIPMENT ATTACHED TO IT.
G	24-4-70	35'	15'	MAT (N) MAS (N)	SV-1-T (N)	6 (N)	SP-1-T (N)	-	-	90W	EVD	RS	EXISTING SNS "Highland" ON POLE TO REMAIN. EXISTING EVD SHALL BE PROTECTED AND RELOCATED TO NEW SIGNAL HEAD. FURNISH AND INSTALL NEW VEHICULAR SIGNAL HEADS WITH DIRECTIONAL LOUVERS TO ENSURE THAT THE VEHICULAR SIGNAL HEADS ARE ONLY VISIBLE TO TRAFFIC IT IS INTENDED FOR. EXISTING ø6 SP-1-T MOUNTED PED SIGNAL AND EXISTING ø6 PPB. FURNISH AND INSTALL NEW PEDESTRIAN HEAD.
H	1-A (10')	-	-	-	TV-2-T	8 (N)	SP-1-T (N)	6 (N)	RIGHT (N) RIGHT (N)	-	-		FURNISH AND INSTALL NEW PEDESTRIAN HEAD AND PUSH BUTTON ASSEMBLY. REMOVE AND SALAVAGE EXISTING ø2 VEHICULAR HEAD AND FURNISH AND INSTALL NEW PV HEAD.
I	24-4-70	35'	12'	MAT (N) MAS (N)	SV-1-T (N)	-	-	-	-	90W	EVA		EXISTING SNS "Golden State" ON POLE TO REMAIN. EXISTING EVA SHALL BE PROTECTED AND RELOCATED TO NEW SIGNAL HEAD. REMOVE AND SALAVAGE EXISTING ø2 VEHICULAR HEADS AND FURNISH AND INSTALL NEW PV HEADS. MAT SHALL BE A 4-SECTION HEAD.
J	18-3-100 (N)	25' (N)	-	MAT (N) MAS (N)	-	-	-	-	-	-	-		FURNISH AND INSTALL R13A(CA) ON SMA COMPLETE WITH MOUNTING HARDWARE.
K	1-A (10') (N)	-	-	-	TV-2-T (N) SV-1-T (N)	-	-	6 (N)	RIGHT (N)	-	-		FURNISH AND INSTALL R3-1 INTERNALLY ILLUMINATED BLANK OUT SIGN ON POLE COMPLETE WITH MOUNTING HARDWARE.
L	1-A (10') (N)	-	-	-	-	8 (N)	TP-1-T (N)	8 (N)	RIGHT (N)	-	-		
M	15TS (N)	-	15' (N)	-	SV-1-T (N)	-	-	-	-	95W (N)	-		



- NOTES:
- ALL EQUIPMENT IS EXISTING UNLESS NOTED WITH (N).
 - ALL INDICATIONS SHALL BE 12" LED MODULES.
 - LUMINAIRES SHALL LED TYPE IN THE HPS EQUIVALENT WATTAGE SPECIFIED.
 - STREET NAME SIGNS SHALL BE WHITE LETTERS ON GREEN BACKGROUND 12" UPPERCASE 9" LOWERCASE, 4" BLOCK NUMBERS, 4" WIDE ARROWS, SERIES "D" TEXT ON TYPE XI DIAMOND GRADE SHEETING, 3M TYPE XI DG3 OR APPROVED EQUAL.

GENERAL NOTES:

- WORK SHALL BE DONE IN ACCORDANCE WITH THE STATE OF CALIFORNIA DEPARTMENT OF TRANSPORTATION STANDARD PLANS AND SPECIFICATIONS, 2015 EDITION, THE LATEST CALTRANS ADOPTED EDITION OF THE CALIFORNIA MANUAL ON UNIFORM TRAFFIC CONTROL DEVICES (CA-MUTCD), THE LATEST EDITION OF THE CITY OF SELMA STANDARD SPECIFICATIONS AND DRAWINGS.
- THESE PLANS ARE ACCURATE FOR ELECTRICAL WORK ONLY.
- NO ABOVE GROUND WORK, EXCEPT SERVICE EQUIPMENT, SHALL BE PERFORMED UNTIL THE CONTRACTOR HAS ALL MATERIALS ON HAND TO COMPLETE THAT PARTICULAR SIGNAL LOCATION OR LIGHTING CIRCUIT.
- THE CONTRACTOR IS RESPONSIBLE FOR VERIFICATION OF ALL EXISTING UTILITIES WHETHER OR NOT THEY ARE SHOWN ON THESE PLANS, AND SHALL PROVIDE PROTECTION PRIOR TO, DURING AND AFTER TRENCHING, JACKING AND/ OR BORING. THE CONTRACTOR SHALL CONTACT UNDERGROUND SERVICE ALERT (USA), BY CALLING 1-800-227-2600 AT LEAST TWO (2) WORKING DAYS BEFORE BEGINNING WORK.
- CONDUIT INSTALLATION ACROSS ROADWAYS SHALL BE BY JACKING AND DIRECTIONAL DRILLING METHODS UNLESS OTHERWISE NOTED ON THE PLANS.
- CONTRACTOR SHALL ARRANGE WITH UTILITY COMPANIES FOR ALL REQUIRED UTILITY REALLOCATIONS, INCLUDING OVERHEAD CONFLICTS.
- ALL TRAFFIC SIGNAL AND LIGHTING FACILITIES, INCLUDING CABINETS, STANDARDS, PULL BOXES, CONDUITS AND LOOP DETECTORS, ARE SHOWN IN THEIR APPROXIMATE LOCATIONS. AFTER ALL UNDERGROUND UTILITIES ARE MARKED, THE CONTRACTOR SHALL MARK FINAL LOCATIONS IN THE FIELD AND NOTIFY THE ENGINEER AT LEAST TWO (2) WORKING DAYS PRIOR TO COMMENCING WORK TO VERIFY THE MARKED LOCATIONS.
- PULL BOXES SHALL BE NO. 5(E), UNLESS OTHERWISE NOTED ON THE PLANS. PULL BOXES SHALL NOT BE INSTALLED IN CURB RAMPS. ALL PULL BOXES SHALL BE AT A MAXIMUM OF 200' APART.
- ALL PULL BOXES INSTALLED IN NON-CONCRETE AREAS SHALL BE SURROUNDED BY A ONE (1) FOOT WIDE CONCRETE COLLAR, TO A DEPTH EQUAL TO THE PULL BOX AND EXTENSION, PER CITY OF FRESNO SPECIFICATIONS. ALL CONDUIT ENTRIES INTO ADVANCE DETECTION, INTERMEDIATE DETECTION, AND STREET LIGHTING PULL BOXES INSTALLED IN NON-CONCRETE AREAS SHALL ENTER THE PULL BOX FROM THE BOTTOM, USING 90 DEGREE ELBOWS AND EXTENDING 3 TO 5 INCHES ABOVE THE FINISHED GROUT.
- ALL CONDUITS SHALL HAVE BUSHINGS INSTALLED PRIOR TO INSTALLING CONDUCTORS. STEEL CONDUITS SHALL HAVE LAY IN STYLE LUGS THAT ARE CAST INTEGRAL WITH THE BUSHING.
- CONDUIT BENDS OF 90 DEGREES ARE PROHIBITED UNLESS OTHERWISE NOTED OR WRITTEN PERMISSION IS GIVEN BY THE CITY OF SELMA ENGINEER.
- ALL NEUTRAL CONDUCTORS SHALL BE WHITE IN COLOR THROUGHOUT THEIR ENTIRE LENGTH.
- TRAFFIC SIGNAL CABLE SHALL NOT BE SPLICED BETWEEN THE CONTROLLER CABINET AND THE TERMINAL COMPARTMENTS MOUNTED ON THE POLES. DETECTOR CABLES SHALL NOT BE SPLICED BETWEEN THE CONTROLLER CABINET AND THE PULL BOX ADJACENT TO THE DETECTOR LEAD-IN.
- SEAL CONDUIT WITH AN APPROVED DUCT SEAL AFTER ALL CONDUCTORS HAVE BEEN INSTALLED.
- SEALANT FOR FILLING THE SAWCUT LOOPS SLOTS SHALL BE HOT-MELT RUBBERIZED ASPHALT SEALANT PER STATE OF CALIFORNIA SPECIFICATIONS OR LOOP SEALANT SHALL BE ELASTOMERIC SEALANT 3M, BLACK 5000.
- PEDESTRIAN PUSH BUTTONS SHALL HAVE 2" DIAMETER ACTUATORS AND COMPLY WITH THE AMERICANS WITH DISABILITIES ACT (ADA).
- ALL VEHICLE AND PEDESTRIAN SIGNAL SECTIONS SHALL UTILIZE LIGHT EMITTING DIODE (LED) SIGNAL MODULES IN ACCORDANCE WITH THE STANDARD SPECIFICATIONS. VEHICLE SIGNAL SECTIONS SHALL HAVE 12" (300 mm) DIAMETER LENSES WITH BACKPLATES AND TUNNEL VISORS. ALL VEHICLE AND PEDESTRIAN SIGNAL SECTIONS SHALL HAVE METAL AND RUBBER WASHERS INSTALLED ON THE INSIDE OF THE HEAD.
- FIXTURE BALLAST SHALL HAVE HIGH POWER FACTOR.
- PEDESTRIAN SIGNAL UNITS SHALL BE FULL SYMBOL, MUTCD COMPLIANT, LED TYPE A. SIGNAL ALIGNMENT SHALL BE AS DIRECTED BY THE ENGINEER.
- ALL SIGNS SHALL BE 3M-3930HIP TYPE III & IV SERIES REFLECTIVE SHEETING AND BE COVERED WITH 1160A PREMIUM OVERLAY ANTI-GRAFFITI FILM OR AVERY DENNISON T6500 SERIES REFLECTIVE SHEETING AND SHALL BE COVERED WITH AVERY DENNISON OL1000 ANTI-GRAFFITI OVERLAY FILM.
- TONABLE CONDUIT SHALL BE CHECKED FOR CONTINUITY AND BONDED TO EARTH GROUND.
- CONDUITS EXITING THE CONTROLLER FOUNDATION AND ENTERING INTO THE CONTROLLER CABINET SHALL BE ALIGNED TO ENTER WITHIN THE TEES SPECIFIED CABINETS WITHOUT ANY MODIFICATIONS TO THE CABINET BASE.
- ALL RESURFACING SHALL MATCH EXISTING SURFACES AFTER SIGNAL FACILITIES ARE REMOVED AND/OR RELOCATED.
- ALL LUMINARE CIRCUITS SHALL BE FUSED. THE FUSE SHALL BE LOCATED IN THE POLE HAND HOLE AT EACH POLE (5 AMP KTK FUSE IN TRON HEB TYPE FUSE HOLDER).
- THE CONTRACTOR SHALL FURNISH AND INSTALL POLE NUMBERS WHEN PG&E INDICATES THE NUMBER. POLE NUMBERS SHALL BE SHOWN ON THE AS-BUILT DRAWINGS.
- THE CONTRACTOR SHALL FURNISH AND INSTALL AN ACCESSIBLE (AUDIBLE) PEDESTRIAN SIGNAL (APS) SYSTEM (2-WIRE POLARA NAVIGATOR OR APPROVED EQUAL) IN CONFORMANCE WITH THE PROJECT SPECIFICATIONS. THE APS SHALL PROVIDE BOTH A VIBRATING ARROW BUTTON AND AUDIBLE SOUNDS DURING THE "WALK" INTERVAL, AS WELL AS A LOCATING TONE DURING THE PEDESTRIAN CLEARANCE AND DON'T WALK INTERVALS. CONTRACTOR SHALL PROVIDE TO THE CITY OF SELMA A MEANS OF PROGRAMMING THE LATEST VERSION OF THE (APS) SYSTEM.

DESIGNED: J. BENAVIDES		DATE: 02/23/2021	RECORD DRAWING	
DRAWN: C. AYALA-MAGANA		DATE: 02/23/2021	RESIDENT ENGINEER	DATE
CHECKED: J. RIOS		DATE: 02/23/2021		
FOR RIGHT OF WAY DATA AND ACCURATE ACCESS DETERMINATION, SEE DOCUMENTS IN THE DEPARTMENT OF PUBLIC WORKS AND PLANNING.				
				
CALL BEFORE YOU DIG		TENTATIVE PLANS FOR DESIGN		GOLDEN STATE CORRIDOR - ECONOMIC DEVELOPMENT AND INFRASTRUCTURE IMPROVEMENTS
516 W. SHAW AVE., STE. 103 FRESNO, CA 93704 PHONE: (559) 570-8991 EMAIL: info@JLBtraffic.com		SUPERVISING ENGINEER		SELMA REGION
		DEPARTMENT OF PUBLIC WORKS AND PLANNING		
DRAWING NO. E-10		SHEET NO. 121		TOTAL 154

CAD USER: CAYALA
PLOT DATE: 2/23/2021 8:42:38 AM
PATH: Z:\01 Projects\009 Fresno County\009-Golden State PS&E\Traffic Signal Designs\2h Whitson at Thompson\Whitson at Thompson Ave.dwg

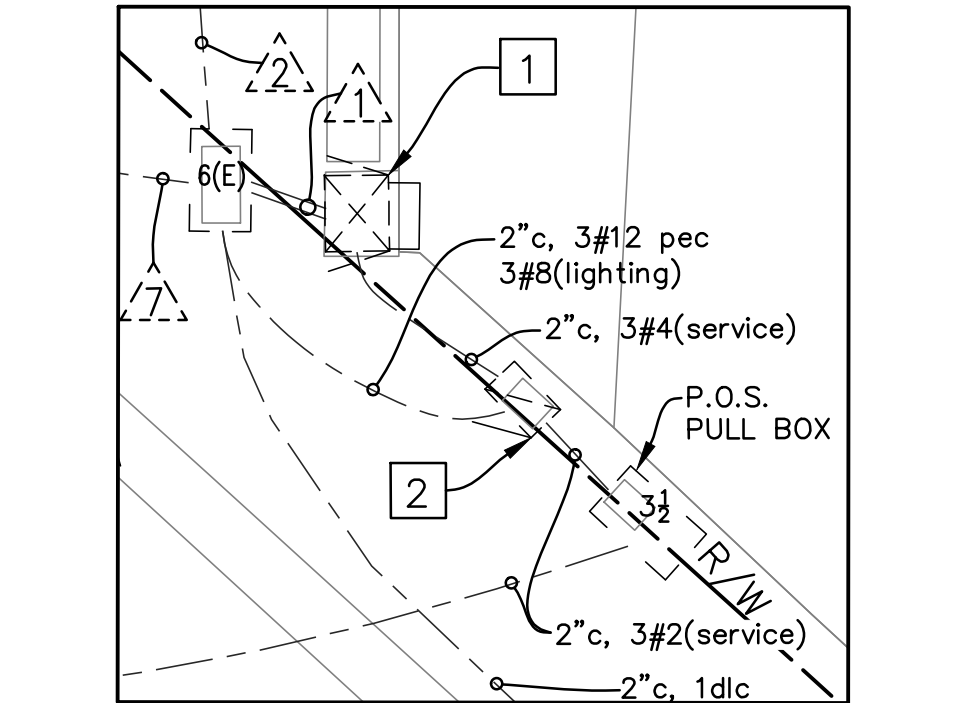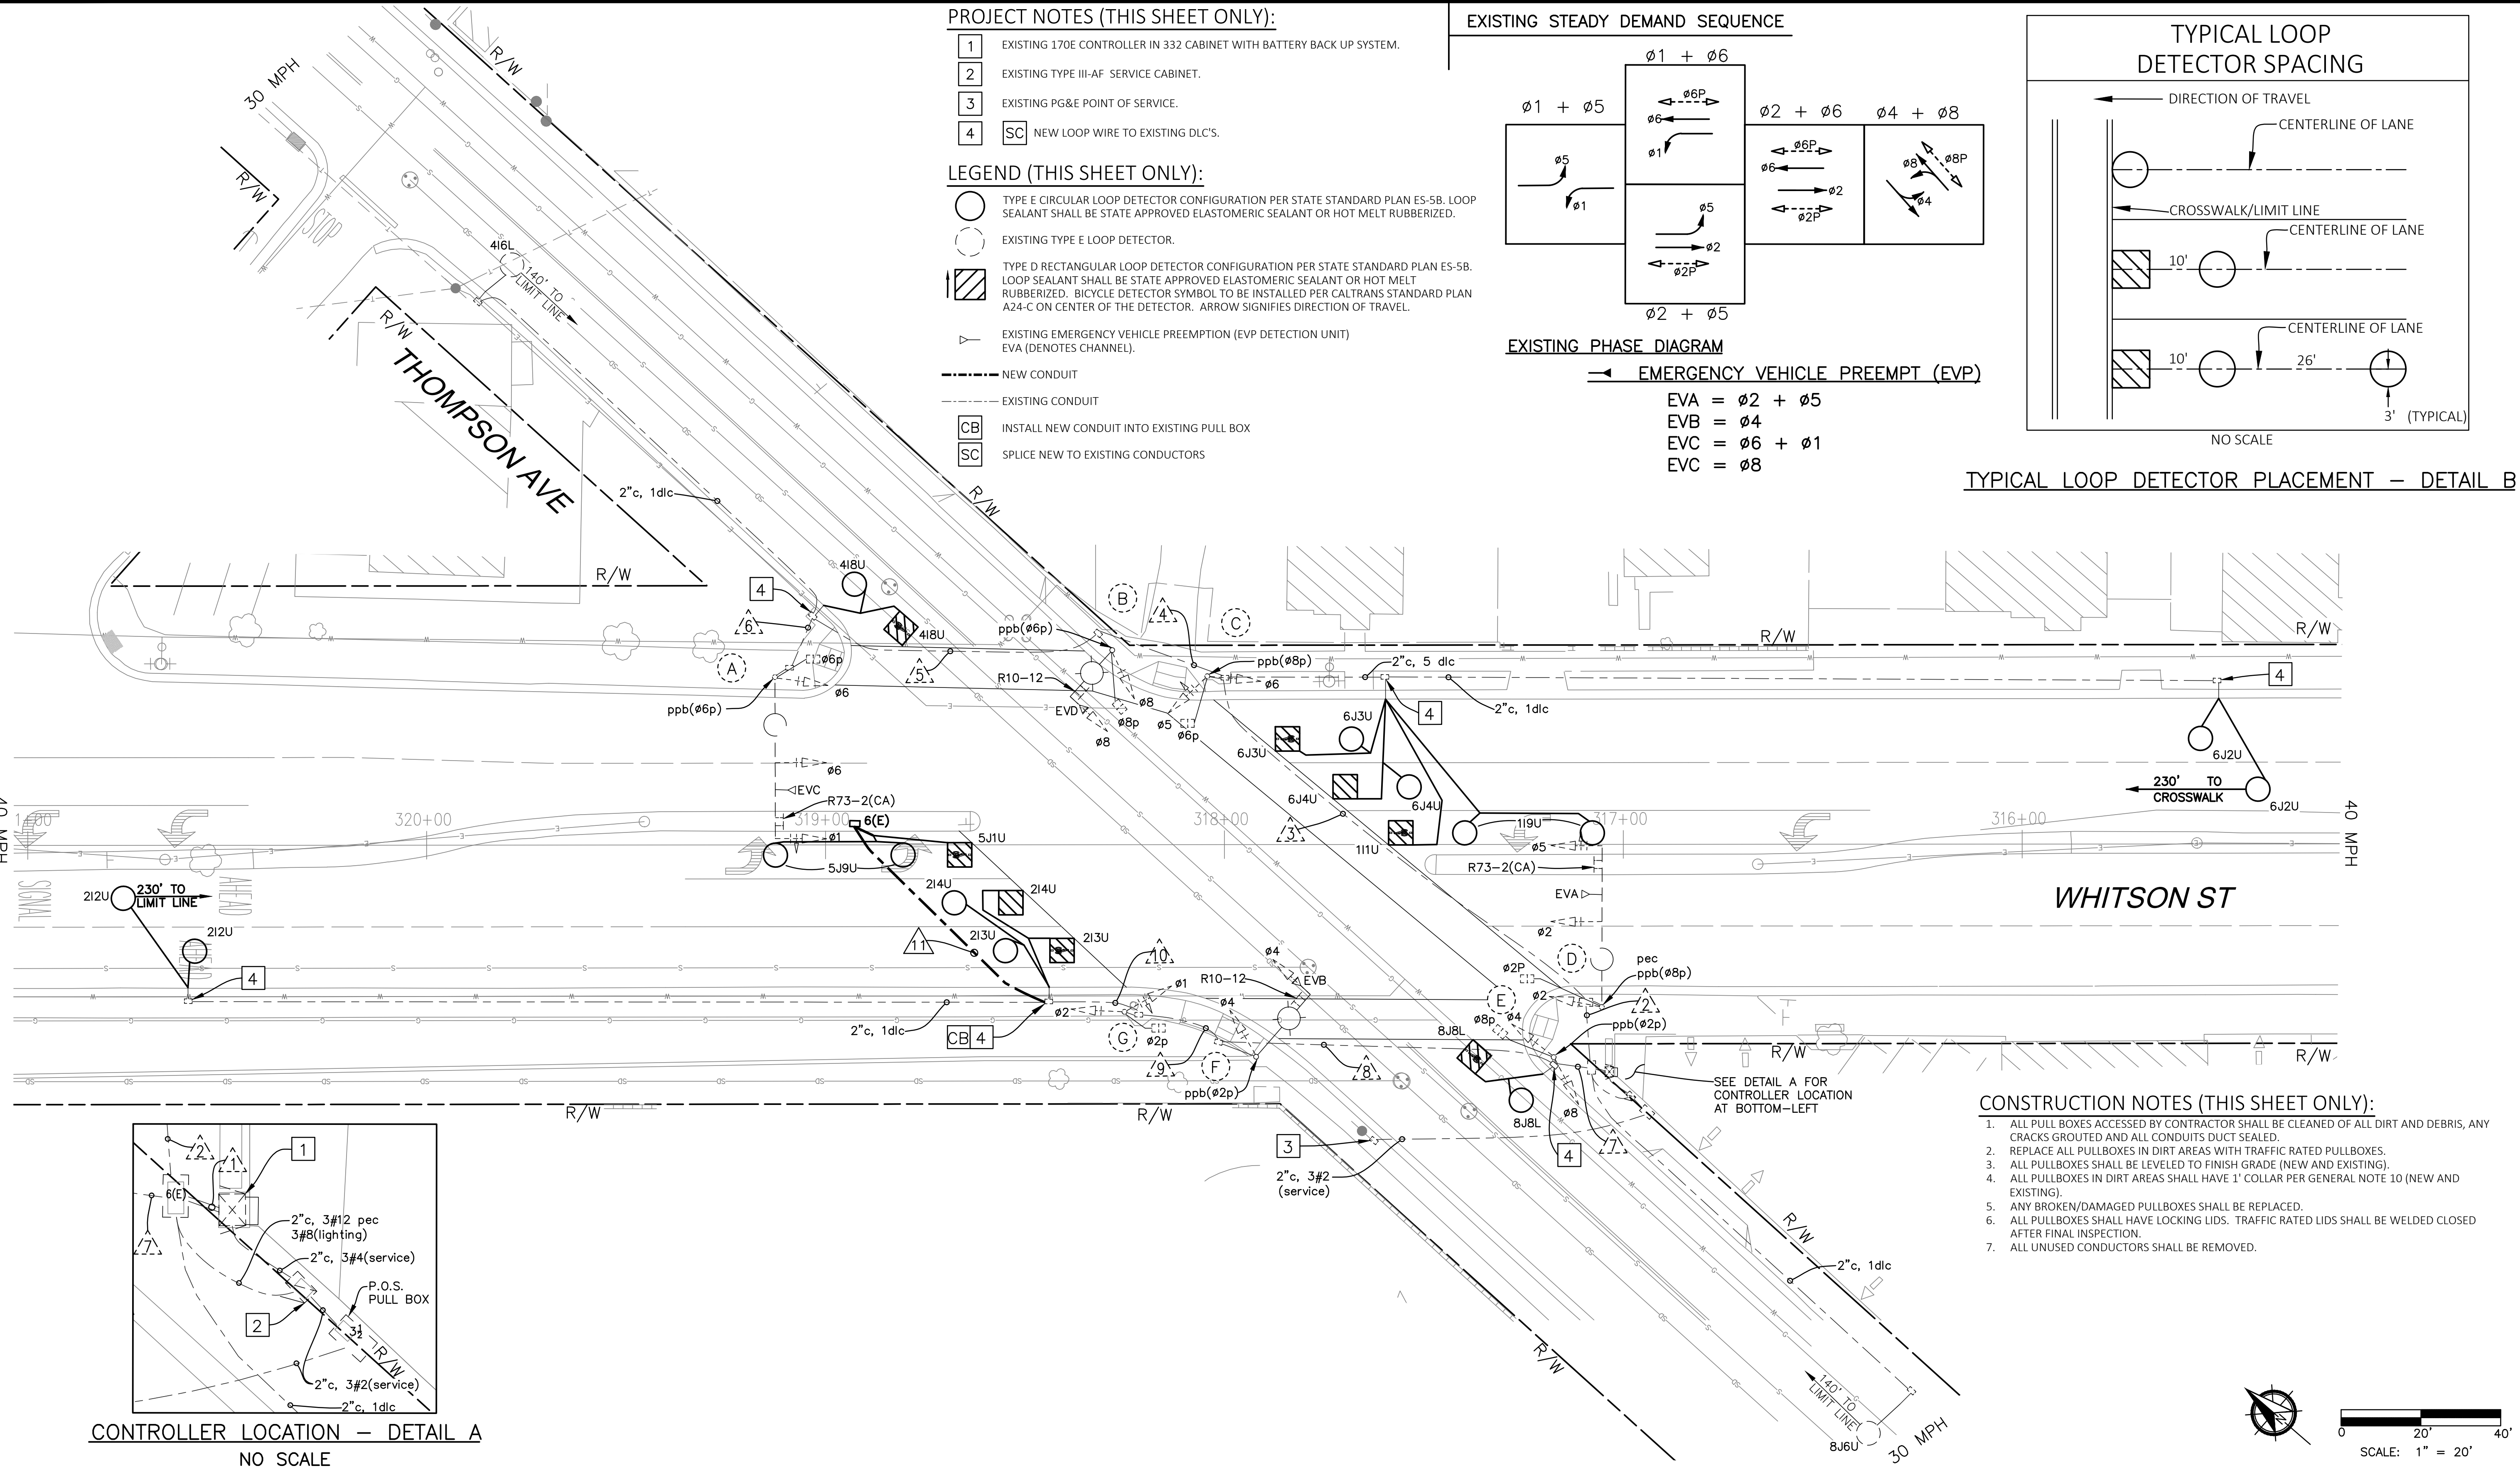

CONTROLLER LOCATION - DETAIL A
NO SCALE

DESIGNED: J. BENAVIDES		DATE: 02/23/2021	RECORD DRAWING		DATE
DRAWN: C. AYALA-MAGANA		DATE: 02/23/2021	RESIDENT ENGINEER		
CHECKED: J. RIOS		DATE: 02/23/2021			

FOR RIGHT OF WAY DATA AND ACCURATE ACCESS DETERMINATION, SEE DOCUMENTS IN THE DEPARTMENT OF PUBLIC WORKS AND PLANNING.

811
CALL BEFORE YOU DIG

JLB TRAFFIC
ENGINEERING, INC.
516 W. SHAW AVE., STE. 103
FRESNO, CA 93704
PHONE: (559) 570-8991
EMAIL: info@JLBtraffic.com

TENTATIVE PLANS FOR DESIGN

SUPERVISING ENGINEER DATE

PROFESSIONAL SEAL
JULIO BENAVIDES
No. 00000000000000000000
Exp. 02/23/2022
STATE OF CALIFORNIA

PROJECT
GOLDEN STATE CORRIDOR - ECONOMIC DEVELOPMENT AND INFRASTRUCTURE IMPROVEMENTS
SELMA REGION

CITY OF SELMA
SEALMA REGION
CALIFORNIA

DEPARTMENT OF PUBLIC WORKS AND PLANNING
WHITSON ST AT THOMPSON AVE
TRAFFIC SIGNAL MODIFICATION PLAN

DRAWING NO. E-12 SHEET NO. 123 TOTAL 154

CAD USER: CAYALA
PLOT DATE: 2/23/2021 8:42:53 AM
PATH: Z:\01 Projects\009 Fresno County\009-Golden State PS&E\Traffic Signal Designs\2h Whitson at Thompson Ave.dwg

CONDUCTOR SCHEDULE														
AWG OR CABLE	POLE	Ø	CONDUIT RUN NUMBER AND SIZE											
			1	2	3	4	5	6	7	8	9	10	11	
			2-3"	3"	3"	2"	2"	2"	3"	3"	2"	2"	(3")	
CONDUIT FILL			31%	40%	31%	43%	26%	22%	28%	20%	24%	13%	3%	
12 COND. CABLE (VEH.) (PED.) *	A	1,6,6P 6P	1	1	1	1	1	1						
	B	8,8P 6P	1	1	1	1	1	1						
	C	5,6,6P 8P	1	1	1									
	D	2,5,2P 8P	1	1										
	E	4,8,8P 2P	1						1					
	F	4 2P	1						1	1				
	G	1,2,2P -	1	-					1	-	1	-		
TOTAL			7 6	4 4	3 3	2 2	1 1	1 1	3 2	2 1	1 -			
TYPE B DETECTOR LEAD-IN CABLE	Ø1		2	2	2									
	Ø2		3						3	3	3	3		
	Ø4		2	2	2	2	2							
	Ø5	(2)							(2)	(2)	(2)	(2)	(2)	
	Ø6		3	3	3									
	Ø8		2						1					
	TOTAL DLC	12(2)	7	7	2	2		4(2)	3(2)	3(2)	3(2)	(2)		
# 8	SAFETY LIGHTS			2	2	2	2	2	2					
# 8	BONDING WIRE			1	1	1	1	1	1	1	(1)	(1)	(1)	
#12	PEC CONTROL			3										
EVP CABLE 3 COND.	EVA (S/B)	1	1											
	EVb (W/B)	1							1	1				
	EVC (N/B)	1	1	1	1	1	1							
	EVD (E/B)	1	1	1	1									
	TOTAL	4	3	2	2	1	1	1	1					

* NUMBER INDICATIONS ARE THE NUMBER OF CABLES WITHIN CONDUIT.
ALL CONDUCTORS ARE EXISTING UNLESS OTHERWISE INDICATED WITH "()".

EQUIPMENT SCHEDULE														
No.	STANDARD			VEH SIG MTG		PED SIGNAL		PPB		LED LUMINAIRE WATTAGE	PG&E POLE No.	SPECIAL REQUIREMENTS		
	Type	Sig.	M.A.	Lum.M.A.	Mast Arm	Pole	Ø	MTG	Ø	ARROW				
(A)	26-4-100	40'		12'	MAT MAS	SV-1-T	6	SP-1-T	6	LEFT	4228	EXISTING SNS "Thompson Ave" ON SIGNAL POLE, EVC AND R73-2(CA) ON SMA TO REMAIN.		
(B)	17-3-70	15'		12'	MAS	SV-1-T	8	SP-1-T	6	LEFT	4249	EXISTING SNS "Whitson Ave" ON SIGNAL POLE, EVD AND R10-12 ON SMA TO REMAIN.		
(C)	1-A (10')	-		-	-	TV-2-T	6	SP-1-T	8	RIGHT	-			
(D)	26-4-100	40'		12'	MAT MAS	SV-1-T	2	SP-1-T	8	LEFT	4250	EXISTING SNS "Thompson Ave" ON SIGNAL POLE, EVA AND R73-2(CA) ON SMA TO REMAIN.		
(E)	1-A (10')	-		-	-	TV-2-T	8	SP-1-T	2	RIGHT	-			
(F)	19-4-70	20'		12'	MAS	SV-1-T	-	-	2	LEFT	4251	EXISTING SNS "Whitson Ave" ON SIGNAL POLE, EVB AND R10-12 ON SMA TO REMAIN.		
(G)	1-A (10')	-		-	-	TV-2-T	2	SP-1-T	-	-	-			

NOTES: * ALL EQUIPMENT IS EXISTING UNLESS NOTED WITH (N).

GENERAL NOTES:

1. WORK SHALL BE DONE IN ACCORDANCE WITH THE STATE OF CALIFORNIA DEPARTMENT OF TRANSPORTATION STANDARD PLANS AND SPECIFICATIONS, 2015 EDITION, THE LATEST CALTRANS ADOPTED EDITION OF THE CALIFORNIA MANUAL ON UNIFORM TRAFFIC CONTROL DEVICES (CA-MUTCD), THE LATEST EDITION OF THE CITY OF SELMA STANDARD SPECIFICATIONS AND DRAWINGS.

2. THESE PLANS ARE ACCURATE FOR ELECTRICAL WORK ONLY.

3. NO ABOVE GROUND WORK, EXCEPT SERVICE EQUIPMENT, SHALL BE PERFORMED UNTIL THE CONTRACTOR HAS ALL MATERIALS ON HAND TO COMPLETE THAT PARTICULAR SIGNAL LOCATION OR LIGHTING CIRCUIT.

4. THE CONTRACTOR IS RESPONSIBLE FOR VERIFICATION OF ALL EXISTING UTILITIES WHETHER OR NOT THEY ARE SHOWN ON THESE PLANS, AND SHALL PROVIDE PROTECTION PRIOR TO, DURING AND AFTER TRENCHING, JACKING AND/ OR BORING. THE CONTRACTOR SHALL CONTACT UNDERGROUND SERVICE ALERT (USA), BY CALLING 1-800-227-2600 AT LEAST TWO (2) WORKING DAYS BEFORE BEGINNING WORK.

5. CONDUIT INSTALLATION ACROSS ROADWAYS SHALL BE BY JACKING AND DIRECTIONAL DRILLING METHODS UNLESS OTHERWISE NOTED ON THE PLANS.

6. CONTRACTOR SHALL ARRANGE WITH UTILITY COMPANIES FOR ALL REQUIRED UTILITY REALLOCATIONS, INCLUDING OVERHEAD CONFLICTS.

7. ALL TRAFFIC SIGNAL AND LIGHTING FACILITIES, INCLUDING CABINETS, STANDARDS, PULL BOXES, CONDUITS AND LOOP DETECTORS, ARE SHOWN IN THEIR APPROXIMATE LOCATIONS. AFTER ALL UNDERGROUND UTILITIES ARE MARKED, THE CONTRACTOR SHALL MARK FINAL LOCATIONS IN THE FIELD AND NOTIFY THE ENGINEER AT LEAST TWO (2) WORKING DAYS PRIOR TO COMMENCING WORK TO VERIFY THE MARKED LOCATIONS.

8. PULL BOXES SHALL BE NO. 5(E), UNLESS OTHERWISE NOTED ON THE PLANS. PULL BOXES SHALL NOT BE INSTALLED IN CURB RAMPS. ALL PULL BOXES SHALL BE AT A MAXIMUM OF 200' APART.

9. ALL PULL BOXES INSTALLED IN NON-CONCRETE AREAS SHALL BE SURROUNDED BY A ONE (1) FOOT WIDE CONCRETE COLLAR, TO A DEPTH EQUAL TO THE PULL BOX AND EXTENSION, PER CITY OF FRESNO SPECIFICATIONS. ALL CONDUIT ENTRIES INTO ADVANCE DETECTION, INTERMEDIATE DETECTION, AND STREET LIGHTING PULL BOXES INSTALLED IN NON-CONCRETE AREAS SHALL ENTER THE PULL BOX FROM THE BOTTOM, USING 90 DEGREE ELBOWS AND EXTENDING 3 TO 5 INCHES ABOVE THE FINISHED GROUT.

10. ALL CONDUITS SHALL HAVE BUSHINGS INSTALLED PRIOR TO INSTALLING CONDUCTORS. STEEL CONDUITS SHALL HAVE LAY IN STYLE LUGS THAT ARE CAST INTEGRAL WITH THE BUSHING.

11. CONDUIT BENDS OF 90 DEGREES ARE PROHIBITED UNLESS OTHERWISE NOTED OR WRITTEN PERMISSION IS GIVEN BY THE CITY OF SELMA ENGINEER.
12. ALL NEUTRAL CONDUCTORS SHALL BE WHITE IN COLOR THROUGHOUT THEIR ENTIRE LENGTH.

13. TRAFFIC SIGNAL CABLE SHALL NOT BE SPLICED BETWEEN THE CONTROLLER CABINET AND THE TERMINAL COMPARTMENTS MOUNTED ON THE POLES. DETECTOR CABLES SHALL NOT BE SPLICED BETWEEN THE CONTROLLER CABINET AND THE PULL BOX ADJACENT TO THE DETECTOR LEAD-IN.

14. SEAL CONDUIT WITH AN APPROVED DUCT SEAL AFTER ALL CONDUCTORS HAVE BEEN INSTALLED.

15. SEALANT FOR FILLING THE SAWCUT LOOPS SLOTS SHALL BE HOT-MELT RUBBERIZED ASPHALT SEALANT PER STATE OF CALIFORNIA SPECIFICATIONS. OR LOOP SEALANT SHALL BE ELASTOMERIC SEALANT 3M, BLACK 5000.

16. PEDESTRIAN PUSH BUTTONS SHALL HAVE 2" DIAMETER ACTUATORS AND COMPLY WITH THE AMERICANS WITH DISABILITIES ACT (ADA).

17. ALL VEHICLE AND PEDESTRIAN SIGNAL SECTIONS SHALL UTILIZE LIGHT EMITTING DIODE (LED) SIGNAL MODULES IN ACCORDANCE WITH THE STANDARD SPECIFICATIONS. VEHICLE SIGNAL SECTIONS SHALL HAVE 12" (300 mm) DIAMETER LENSES WITH BACKPLATES AND TUNNEL VISORS. ALL VEHICLE AND PEDESTRIAN SIGNAL SECTIONS SHALL HAVE METAL AND RUBBER WASHERS INSTALLED ON THE INSIDE OF THE HEAD.

18. FIXTURE BALLAST SHALL HAVE HIGH POWER FACTOR.

19. PEDESTRIAN SIGNAL UNITS SHALL BE FULL SYMBOL, MUTCD COMPLIANT, LED TYPE A. SIGNAL ALIGNMENT SHALL BE AS DIRECTED BY THE ENGINEER.

20. ALL SIGNS SHALL BE 3M-3930HIP TYPE III & IV SERIES REFLECTIVE SHEETING AND BE COVERED WITH 1160A PREMIUM OVERLAY ANTI-GRAFFITI FILM OR AVERY DENNISON T6500 SERIES REFLECTIVE SHEETING AND SHALL BE COVERED WITH AVERY DENNISON OL1000 ANTI-GRAFFITI OVERLAY FILM.


21. TONEABLE CONDUIT SHALL BE CHECKED FOR CONTINUITY AND BONDED TO EARTH GROUND.

22. CONDUITS EXITING THE CONTROLLER FOUNDATION AND ENTERING INTO THE CONTROLLER CABINET SHALL BE ALIGNED TO ENTER WITHIN THE TEES SPECIFIED CABINETS WITHOUT ANY MODIFICATIONS TO THE CABINET BASE.

23. ALL RESURFACING SHALL MATCH EXISTING SURFACES AFTER SIGNAL FACILITIES ARE REMOVED AND/OR RELOCATED.

24. ALL LUMINARE CIRCUITS SHALL BE FUSED. THE FUSE SHALL BE LOCATED IN THE POLE HAND HOLE AT EACH POLE (5 AMP KTK FUSE IN TRON HEB TYPE FUSE HOLDER).

	DATE	RECORD DRAWING	
DESIGNED: J. BENAVIDES	02/23/2021	RESIDENT ENGINEER	DATE
DRAWN: C. AYALA-MAGANA	02/23/2021		
CHECKED: J. RIOS	02/23/2021		
FOR RIGHT OF WAY DATA AND ACCURATE ACCESS DETERMINATION, SEE DOCUMENTS IN THE DEPARTMENT OF PUBLIC WORKS AND PLANNING.			

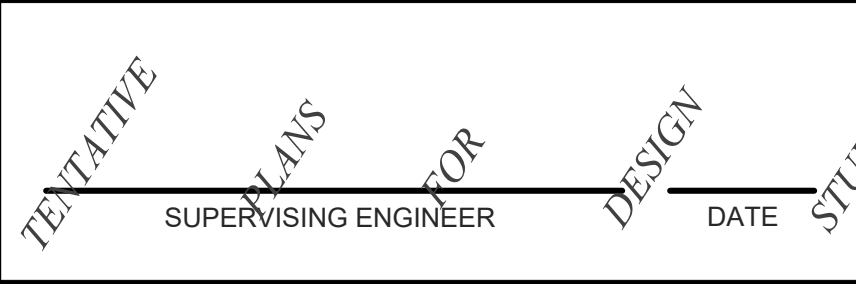


PROJECT	
GOLDEN STATE CORRIDOR - ECONOMIC DEVELOPMENT AND INFRASTRUCTURE IMPROVEMENTS	
SELMA REGION	



DEPARTMENT OF PUBLIC WORKS AND PLANNING			
WHITSON ST AT THOMPSON AVE EQUIPMENT AND CONDUCTOR SCHEDULE			
DRAWING NO.	E-13	SHEET NO.	124 TOTAL 154

PATH: D:\Dropbox (DL252)\DL252 Team Folder\PROJECTS\2015\15-05-006 Golden State\05-CAD\15.01-PLANS\15.01-5-LANDSCAPE PLAN\15.01-5.1-WORKING\LOT DATE: 2/22/2021 5:08:07 PM CAD USER: KONNI
DRAWING: V2\1001\15-05-006\K2\100-PPNew.dwg

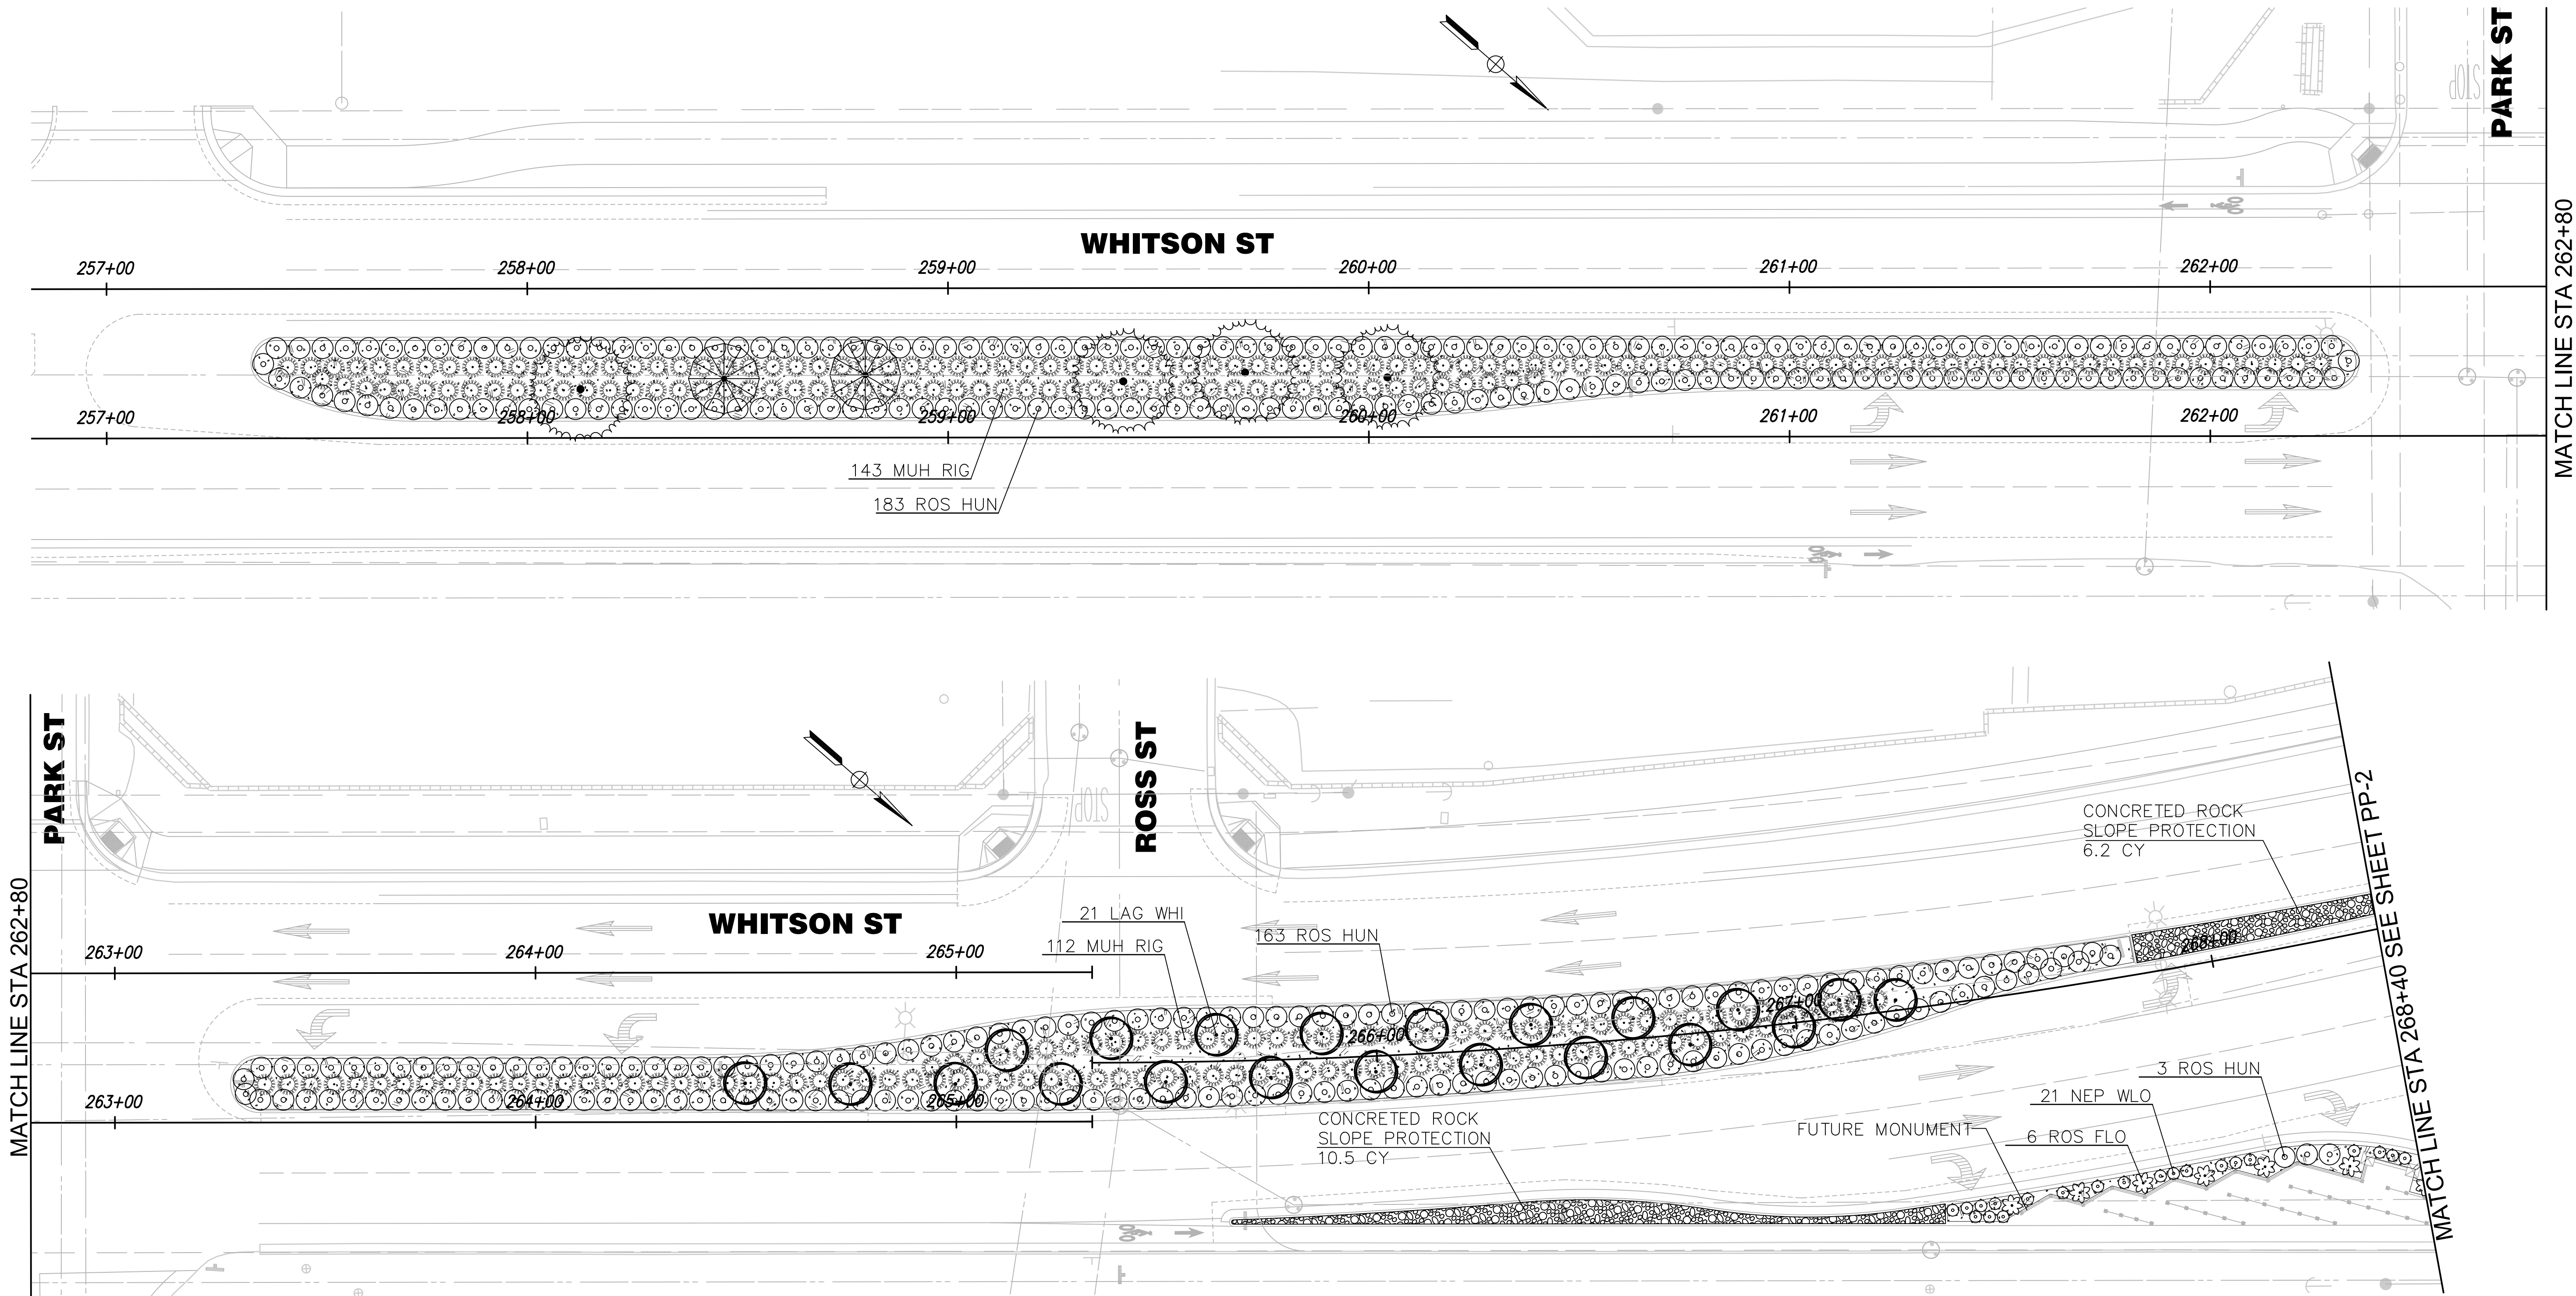

SCALE: 1"=20'-0"

RECORD DRAWING			
DESIGNED: PB	DATE 12/14/20	RESIDENT ENGINEER	DATE
DRAWN: KJ	12/14/20		
CHECKED: PB	01/19/21		

FOR RIGHT OF WAY DATA AND ACCURATE ACCESS DETERMINATION, SEE DOCUMENTS IN THE DEPARTMENT OF PUBLIC WORKS AND PLANNING.

designlab 252

P.O. Box 27616 Fresno, CA 93729
Studio: 559.472.9966 Fax: 559.472.9969

TENTATIVE

PLANS

FOR


DESIGN

SUPERVISING ENGINEER

DATE



PROJECT
GOLDEN STATE BOULEVARD
CITY OF SELMA, CA

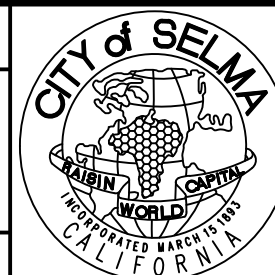

DEPARTMENT OF PUBLIC WORKS AND PLANNING


PLANTING PLAN

DRAWING NO. PP-1

SHEET NO. 127

TOTAL 154

PATH: D:\Dropbox\DL252\Term_Folder\PROJECTS\2015\15-05-006 Golden State\05-CAD\5.01-PLANS\5.01-5-LANDSCAPE PLAN\5.01-5.1-WORKING\LOT DATE: 2/22/2021 5:08:09 PM CAD USER: KONNI

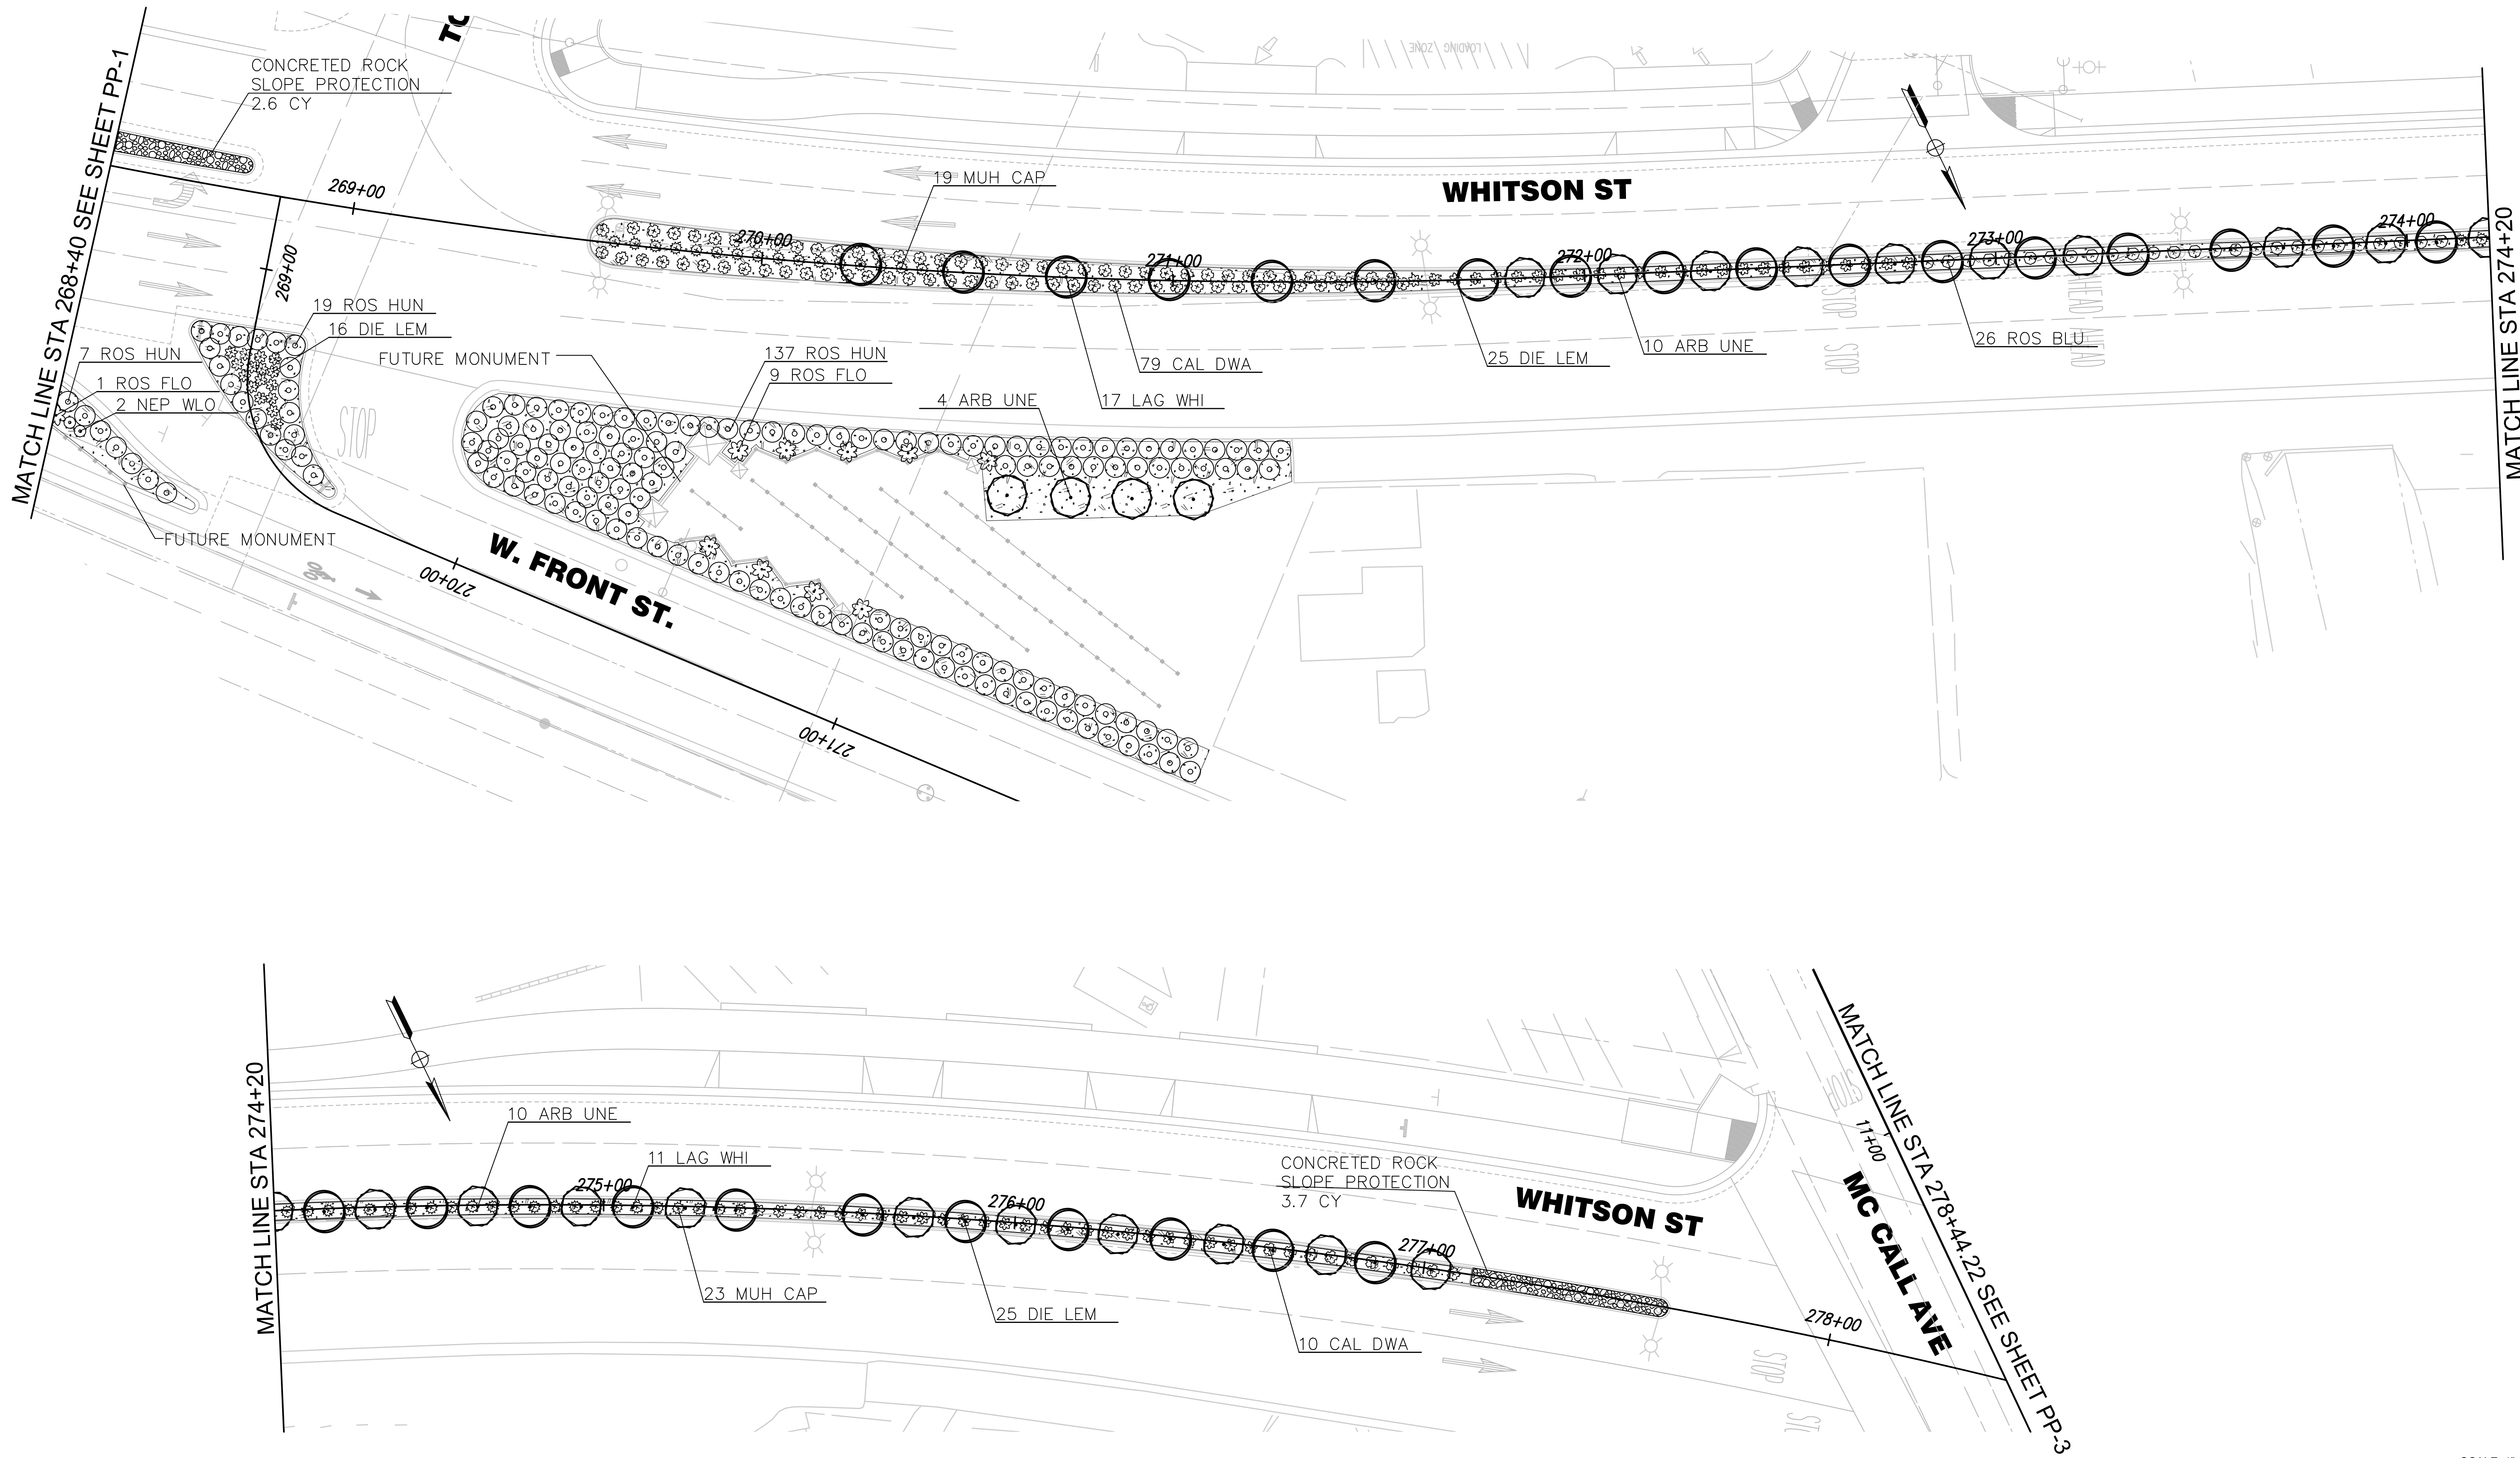

SCALE: 1"=20'-0"

RECORD DRAWING	
DESIGNED: PB	DATE 12/14/20
DRAWN: KJ	DATE 12/14/20
CHECKED: PB	DATE 01/19/21

designlab 252

P.O. Box 27616 Fresno, CA 93729
Studio: 559.472.9966 Fax: 559.472.9969

TENTATIVE PLANS FOR DESIGN

SUPERVISING ENGINEER DATE



PROJECT

GOLDEN STATE BOULEVARD
CITY OF SELMA, CA




DEPARTMENT OF PUBLIC WORKS AND PLANNING

PLANTING PLAN

DRAWING NO. PP-2 SHEET NO. 128 TOTAL 154

PATH: D:\Dropbox\DL252\Team Folder\PROJECTS\2015\15-05-006 Golden State\05-CAD\5.01-PLANS\5.01-5-LANDSCAPE PLAN\5.01.5.1-WORKING\LOT DATE: 2/22/2021 5:08:11 PM CAD USER: KONNI
DRAWING: V2\1001\15-05-006R2\100_PPlan.dwg

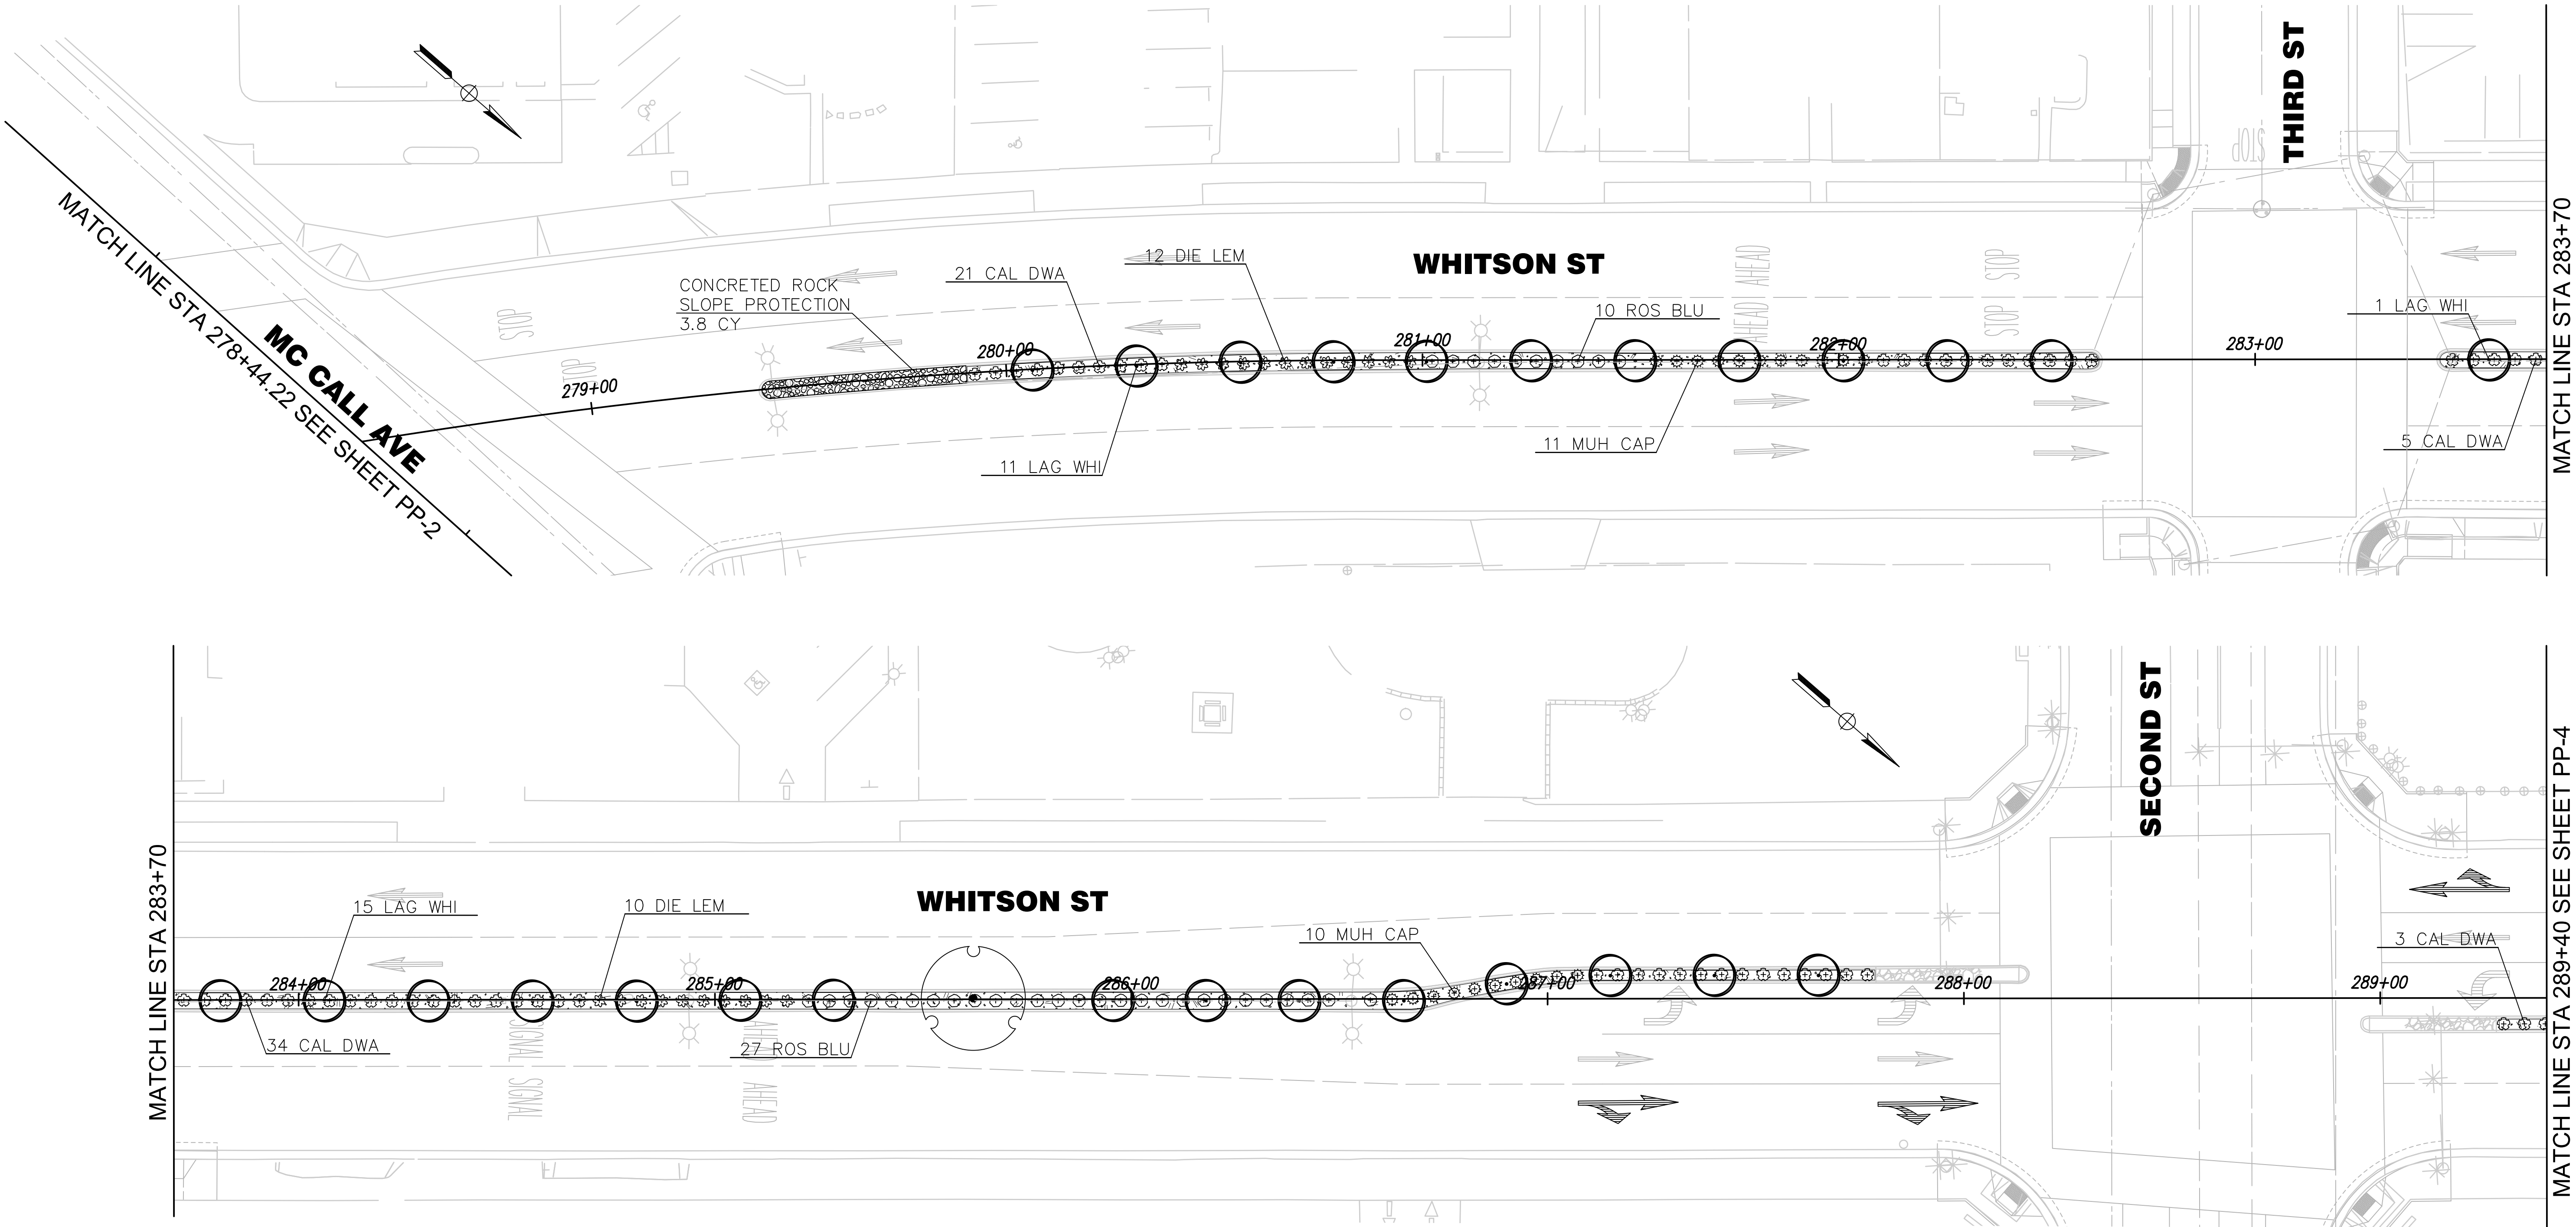

SCALE: 1"=20'-0"

	DATE	RECORD DRAWING	
DESIGNED: PB	12/14/20	RESIDENT ENGINEER	DATE
DRAWN: KJ	12/14/20		
CHECKED: PB	01/19/21		

FOR RIGHT OF WAY DATA AND ACCURATE ACCESS DETERMINATION, SEE DOCUMENTS IN THE DEPARTMENT OF PUBLIC WORKS AND PLANNING.

designlab 252
P.O. Box 27616 Fresno, CA 93729
Studio: 559.472.9966 Fax: 559.472.9969


TENTATIVE

PLANS


SUPERVISING ENGINEER

FOR DESIGN

DATE

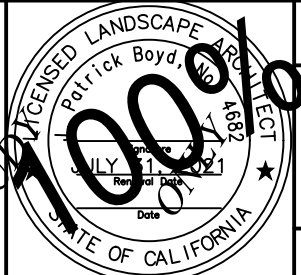

PROJECT
GOLDEN STATE BOULEVARD
CITY OF SELMA, CA

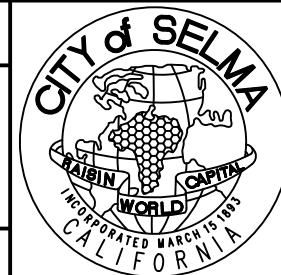

DEPARTMENT OF PUBLIC WORKS AND PLANNING


PLANTING PLAN

DRAWING NO. PP-3

SHEET NO. 129

TOTAL 154

PATH: D:\projects\01252\01252_05-05-006 Golden State\05-CAD\05-01-PLANS\05-01-5-LANDSCAPE PLAN\05-01-5-1-WORKING\LOT DATE: 2/22/2021 5:08:12 PM CAD USER: KONNI

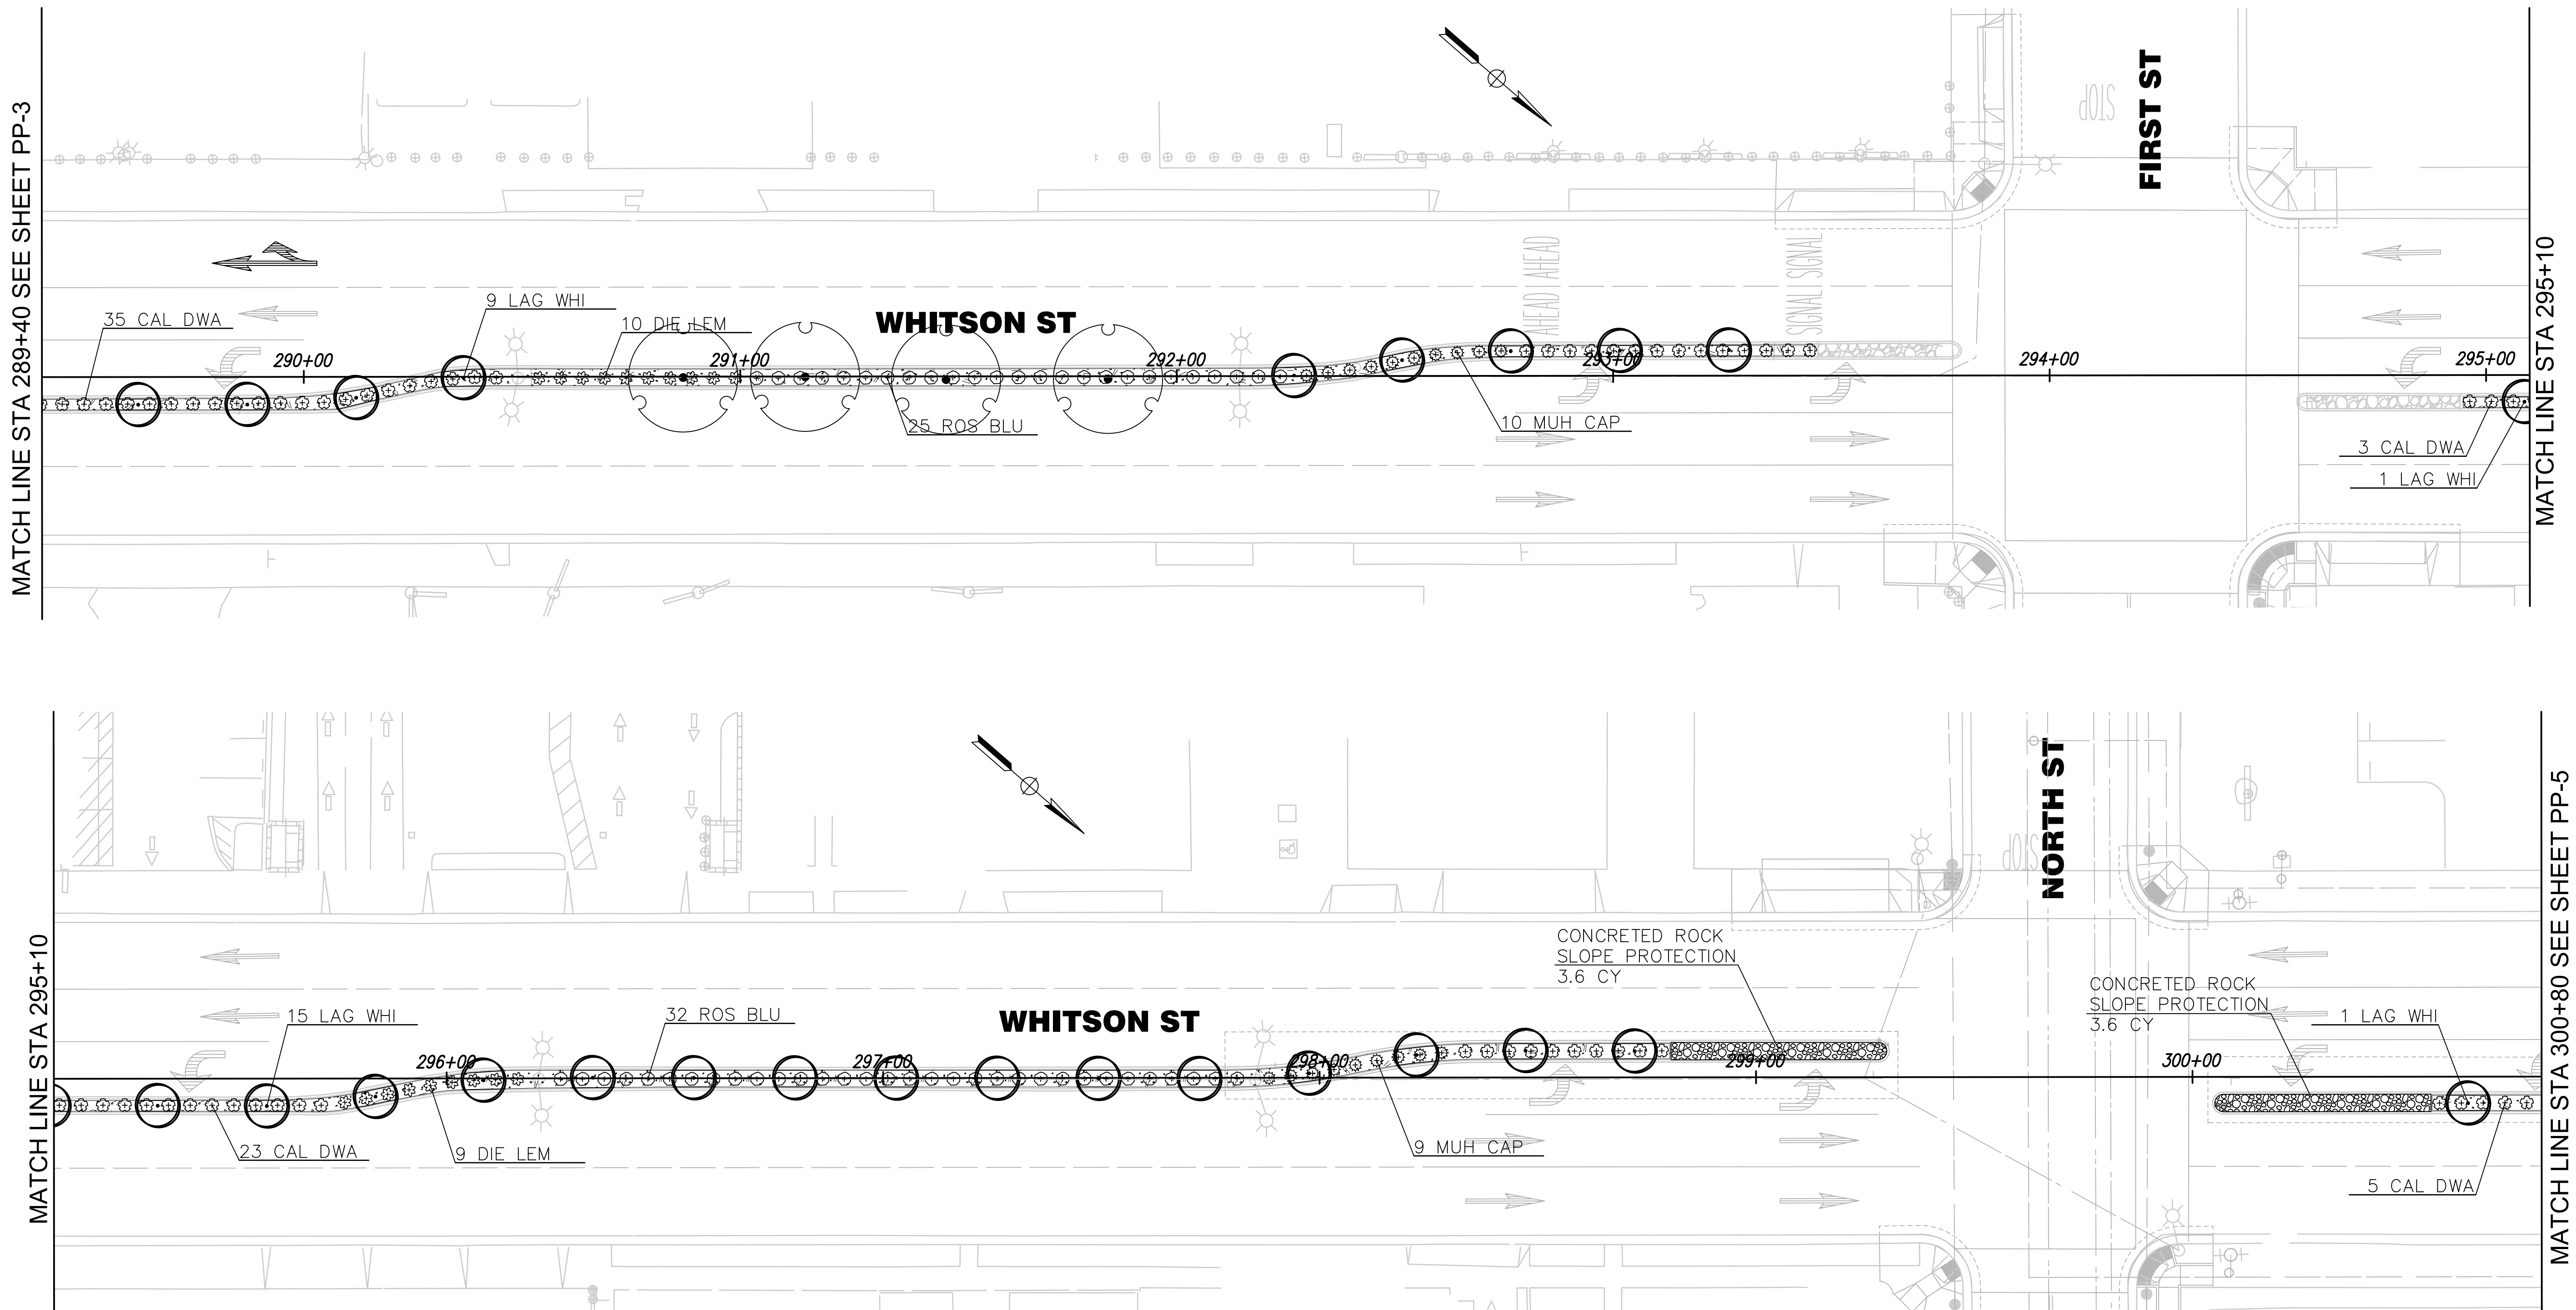

SCALE: 1"=20'-0"

	DATE	RECORD DRAWING	
DESIGNED: PB	12/14/20	RESIDENT ENGINEER	DATE
DRAWN: KJ	12/14/20		
CHECKED: PB	01/19/21		


FOR RIGHT OF WAY DATA AND ACCURATE ACCESS DETERMINATION, SEE DOCUMENTS IN THE DEPARTMENT OF PUBLIC WORKS AND PLANNING.

designlab 252
P.O. Box 27616 Fresno, CA 93729
Studio: 559.472.9966 Fax: 559.472.9969

TENTATIVE PLANS FOR DESIGN
SUPERVISING ENGINEER DATE



PROJECT
GOLDEN STATE BOULEVARD
CITY OF SELMA, CA


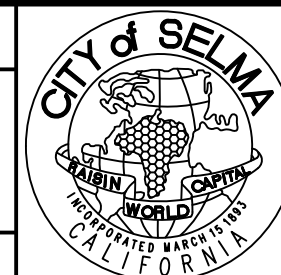


DEPARTMENT OF PUBLIC WORKS AND PLANNING

PLANTING PLAN

DRAWING NO. PP-4 SHEET NO. 130 TOTAL 154

PATH: D:\Dropbox (DL252)\DL252 Team Folder\PROJECTS\2015\15-05-006 Golden State\05-CAD\5.01-PLANS\5.01-5-LANDSCAPE PLAN\5.01-5.1-WORKING\LOT DATE: 2/22/2021 5:08:13 PM CAD USER: KONNI

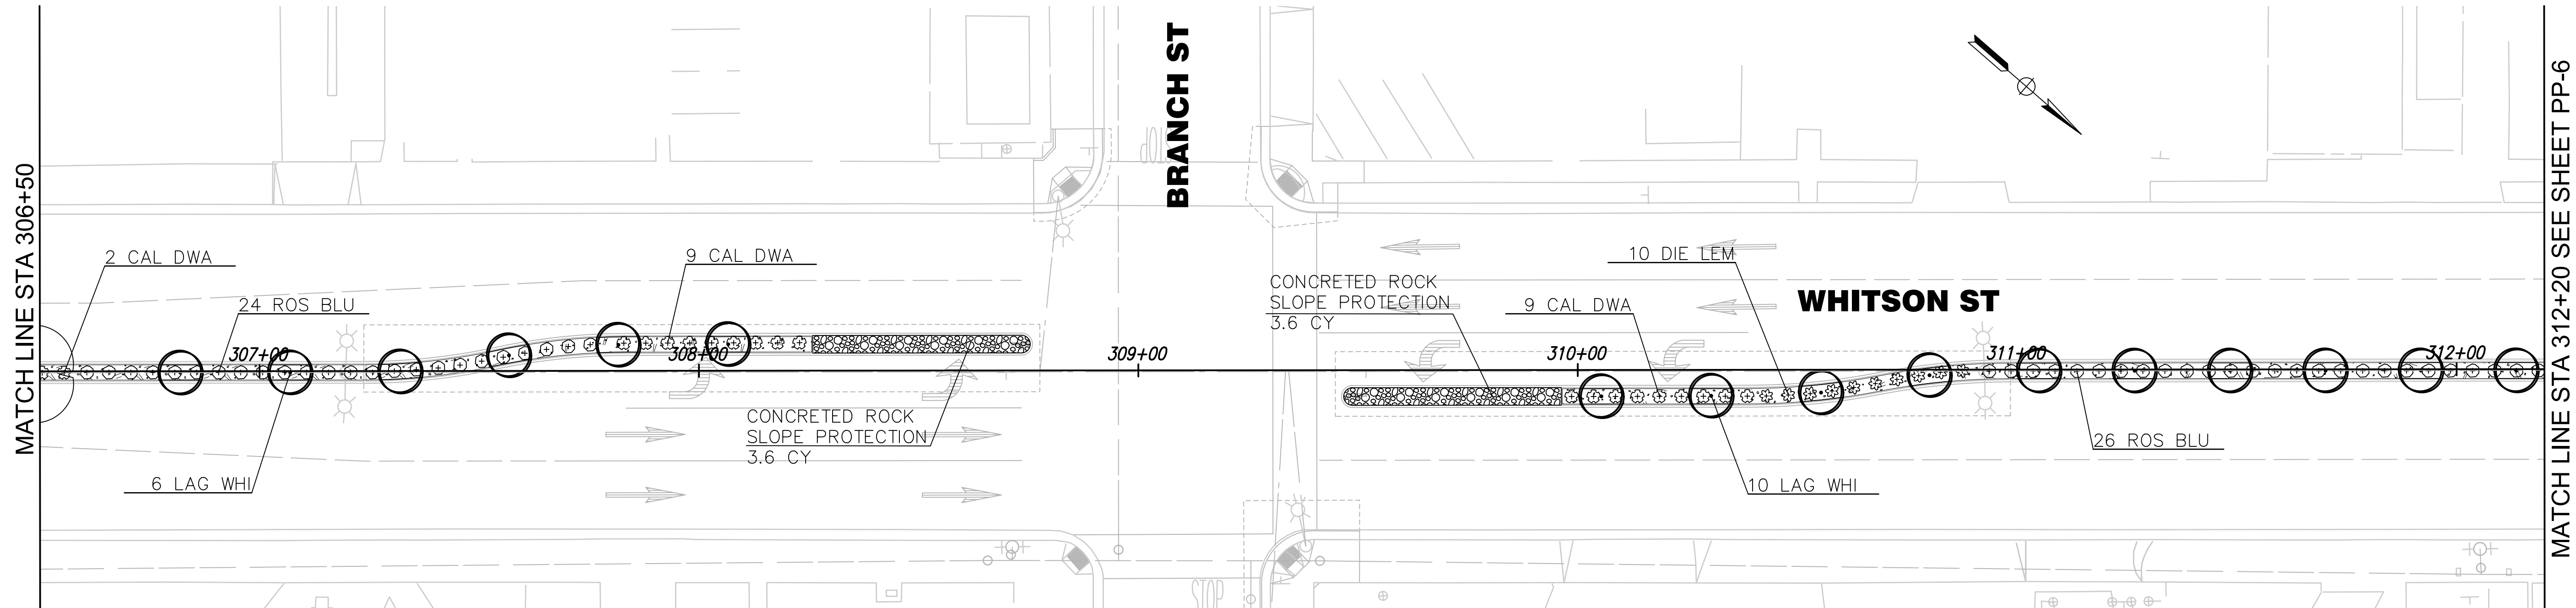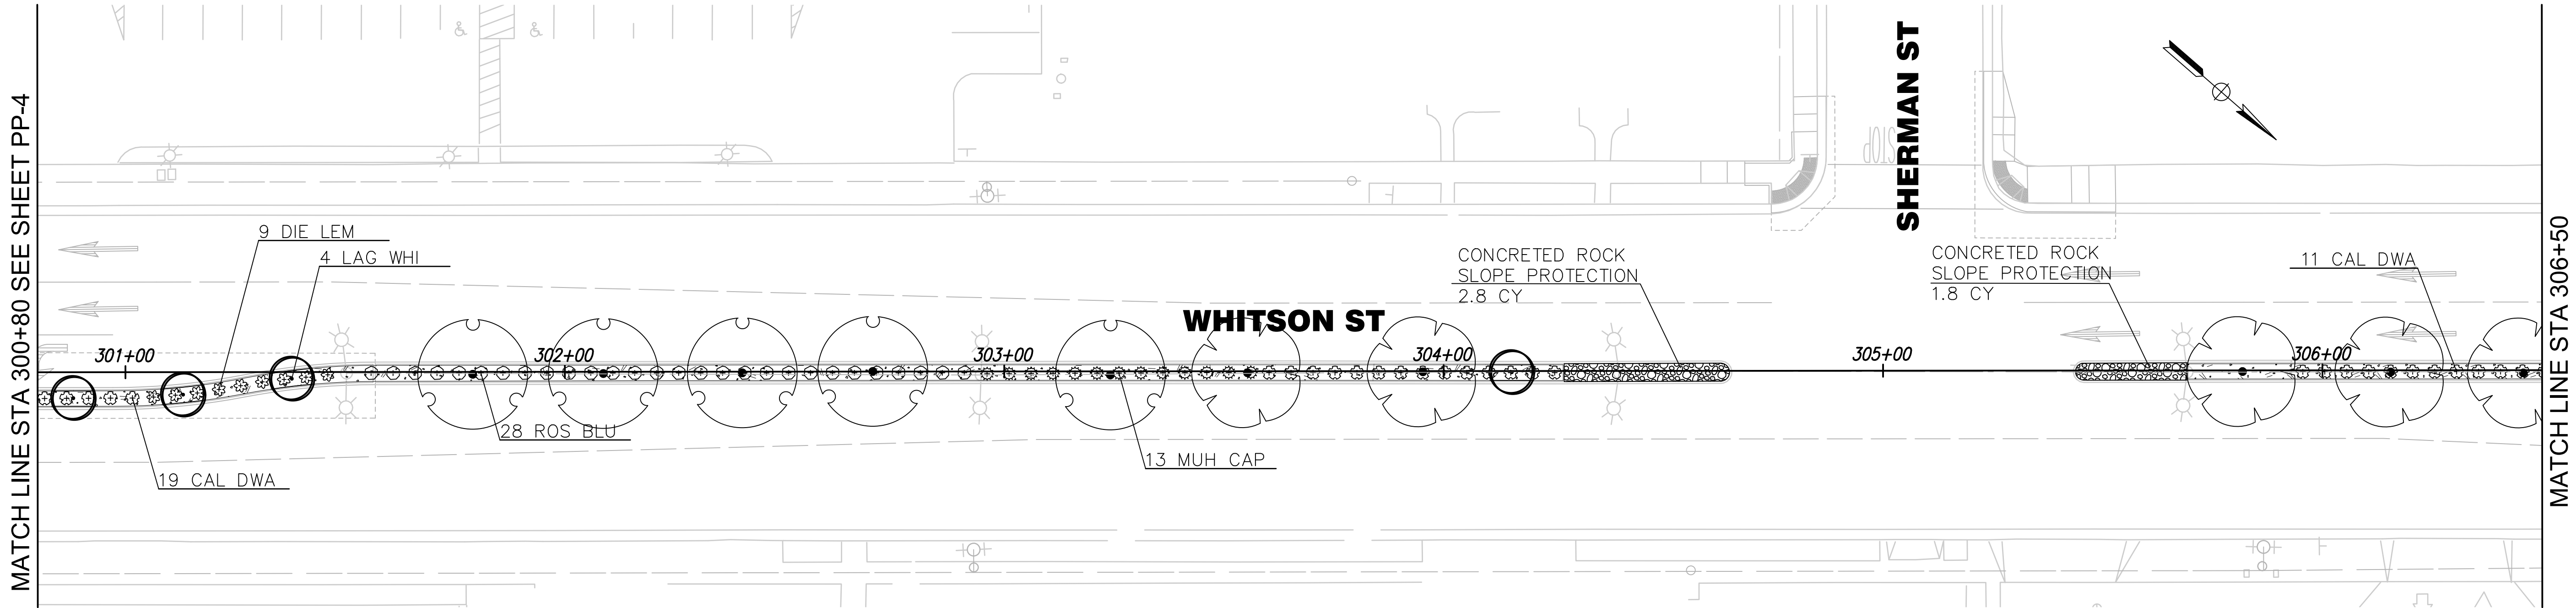

SCALE: 1"=20'-0"


RECORD DRAWING	
DESIGNED: PB	DATE 12/14/20
DRAWN: KJ	DATE 12/14/20
CHECKED: PB	DATE 01/19/21

designlab 252
P.O. Box 27616 Fresno, CA 93729
Studio: 559.472.9966 Fax: 559.472.9969

TENTATIVE PLANS FOR DESIGN
SUPERVISING ENGINEER DATE



PROJECT
GOLDEN STATE BOULEVARD
CITY OF SELMA, CA

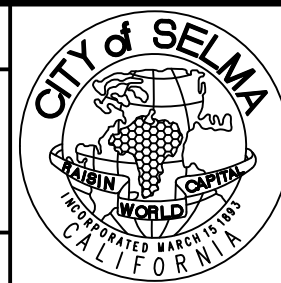


DEPARTMENT OF PUBLIC WORKS AND PLANNING

PLANTING PLAN

DRAWING NO. PP-5 SHEET NO. 131 TOTAL 154

PATH: D:\Dropbox\DL252\Temp_Folder\PROJECTS\2015\15-05-006 Golden State\05-CAD\5.01-PLANS\5.01.5-LANDSCAPE PLAN\5.01.5.1-WORKING\LOT DATE: 2/22/2021 5:08:15 PM CAD USER: KONNI
DRAWING: V2\1001\15-05-006\K2\100_PPnew.dwg

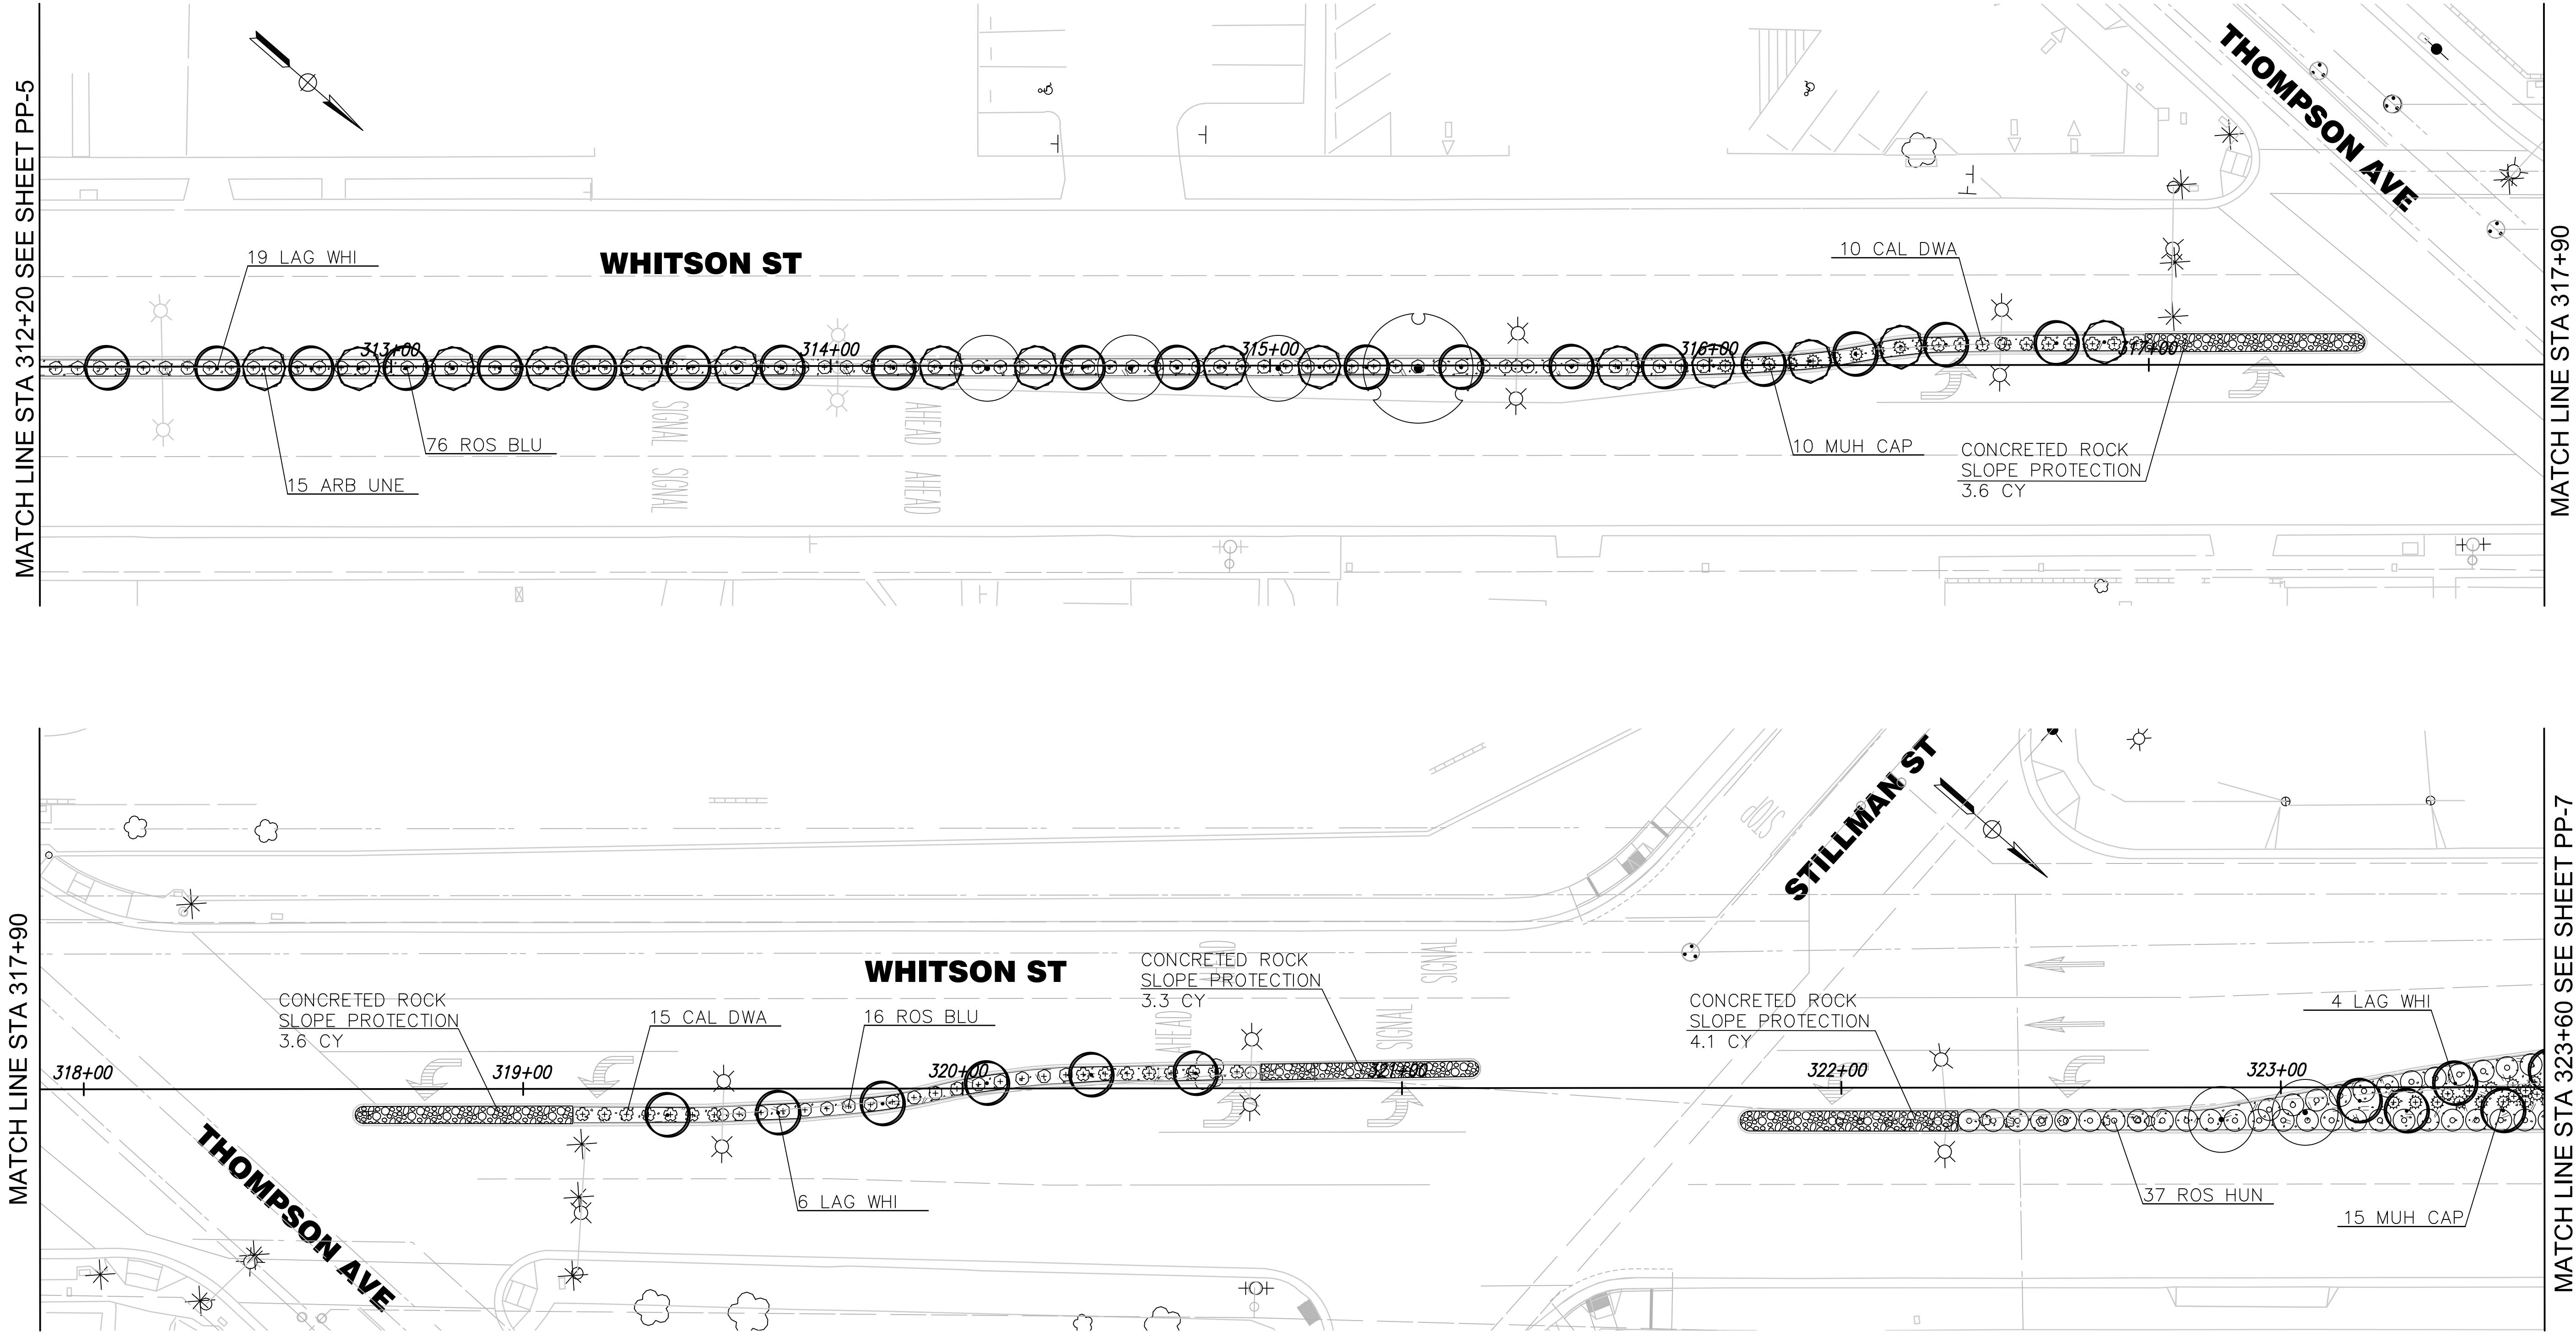

SCALE: 1"=20'-0"

RECORD DRAWING		DATE
DESIGNED: PB	12/14/20	
DRAWN: KJ	12/14/20	
CHECKED: PB	01/19/21	

designlab 252
P.O. Box 27616 Fresno, CA 93729
Studio: 559.472.9966 Fax: 559.472.9969

TENTATIVE PLANS FOR DESIGN
SUPERVISING ENGINEER DATE





PROJECT
GOLDEN STATE BOULEVARD
CITY OF SELMA, CA



DEPARTMENT OF PUBLIC WORKS AND PLANNING		
PLANTING PLAN		
DRAWING NO. PP-6	SHEET NO. 132	TOTAL 154

PATH: D:\Dropbox (DL252)\DL252 Team Folder\PROJECTS\2015\15-05-006 Golden State\05-CAD\5.01-PLANS\5.01.5-LANDSCAPE PLAN\5.01.5.1-WORKING\LOT DATE: 2/22/2021 5:08:16 PM CAD USER: KONNI

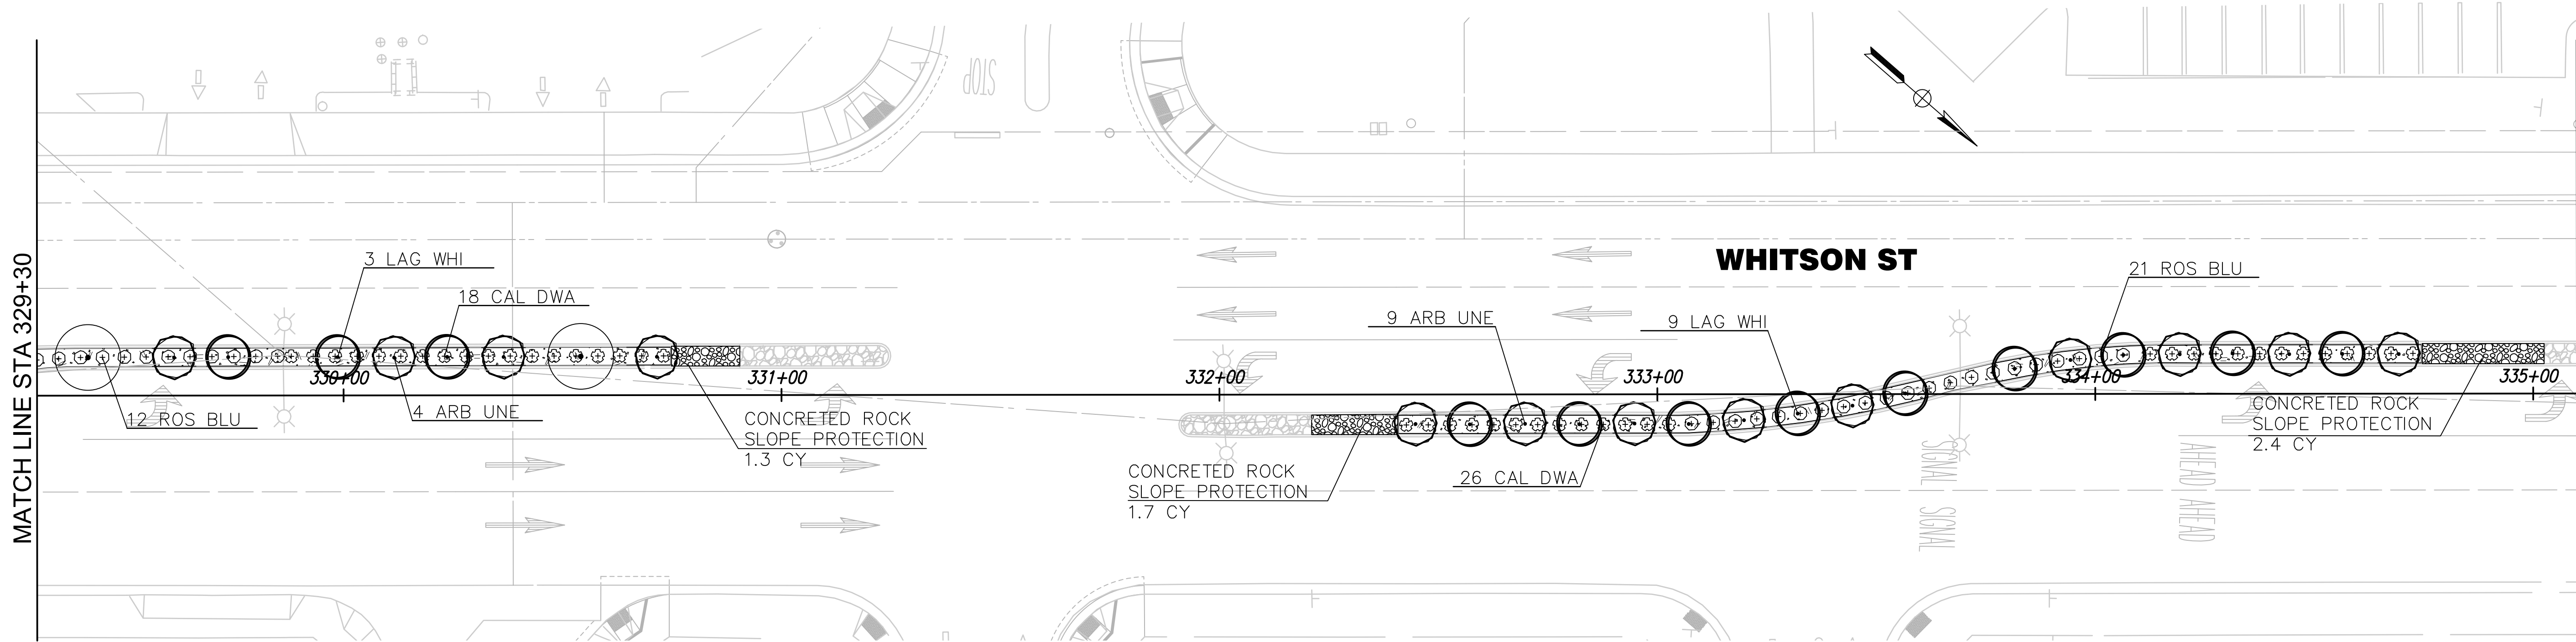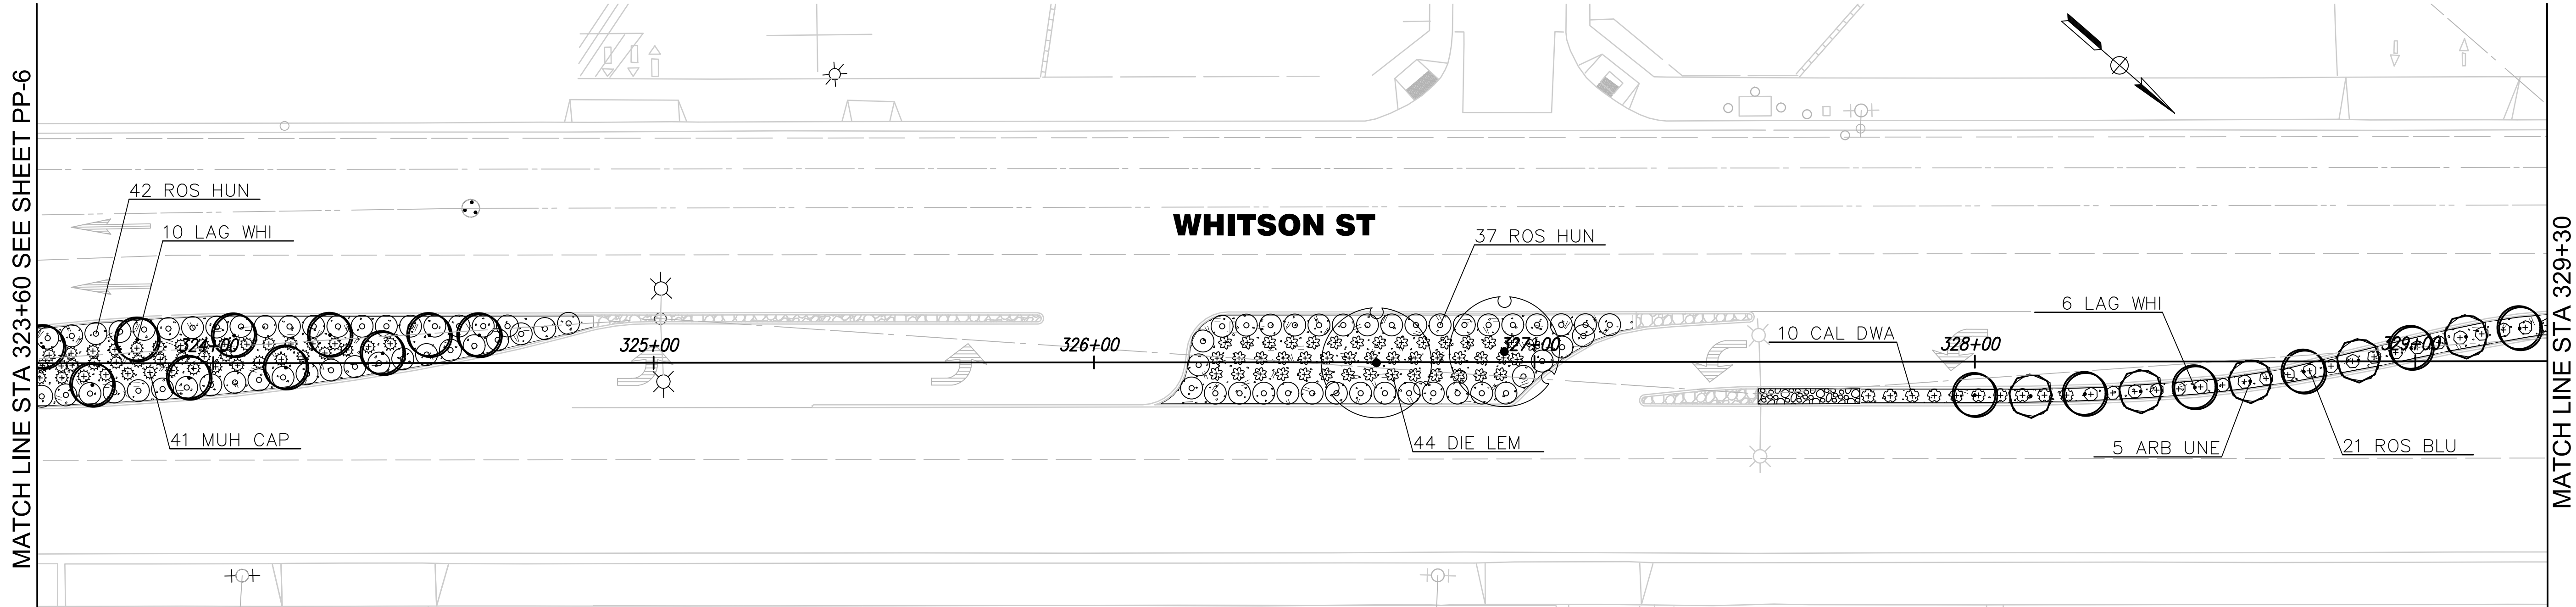

SCALE: 1"=20'-0"

	DATE	RECORD DRAWING	
DESIGNED: PB	12/14/20	RESIDENT ENGINEER	DATE
DRAWN: KJ	12/14/20		
CHECKED: PB	01/19/21		

FOR RIGHT OF WAY DATA AND ACCURATE ACCESS DETERMINATION, SEE DOCUMENTS IN THE DEPARTMENT OF PUBLIC WORKS AND PLANNING.

designlab 252

P.O. Box 27616 Fresno, CA 93729
Studio: 559.472.9966 Fax: 559.472.9969

TENTATIVE

PLANS

FOR


DESIGN

SUPERVISING ENGINEER

DATE



PROJECT
GOLDEN STATE BOULEVARD
CITY OF SELMA, CA

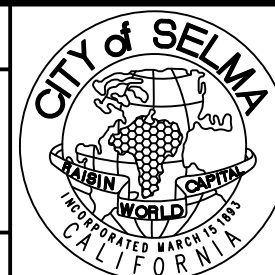

DEPARTMENT OF PUBLIC WORKS AND PLANNING


PLANTING PLAN

DRAWING NO. PP-7

SHEET NO. 133

TOTAL 154

PATH: D:\projects\01252\01252_05-05-006 Golden State\05-CAD\5.01-PLANS\5.01-5-LANDSCAPE PLAN\5.01-5.1-WORKING\LOT DATE: 2/22/2021 5:08:18 PM CAD USER: KONNI
DRAWING: 100119-05-006R2_100_PPlan.dwg

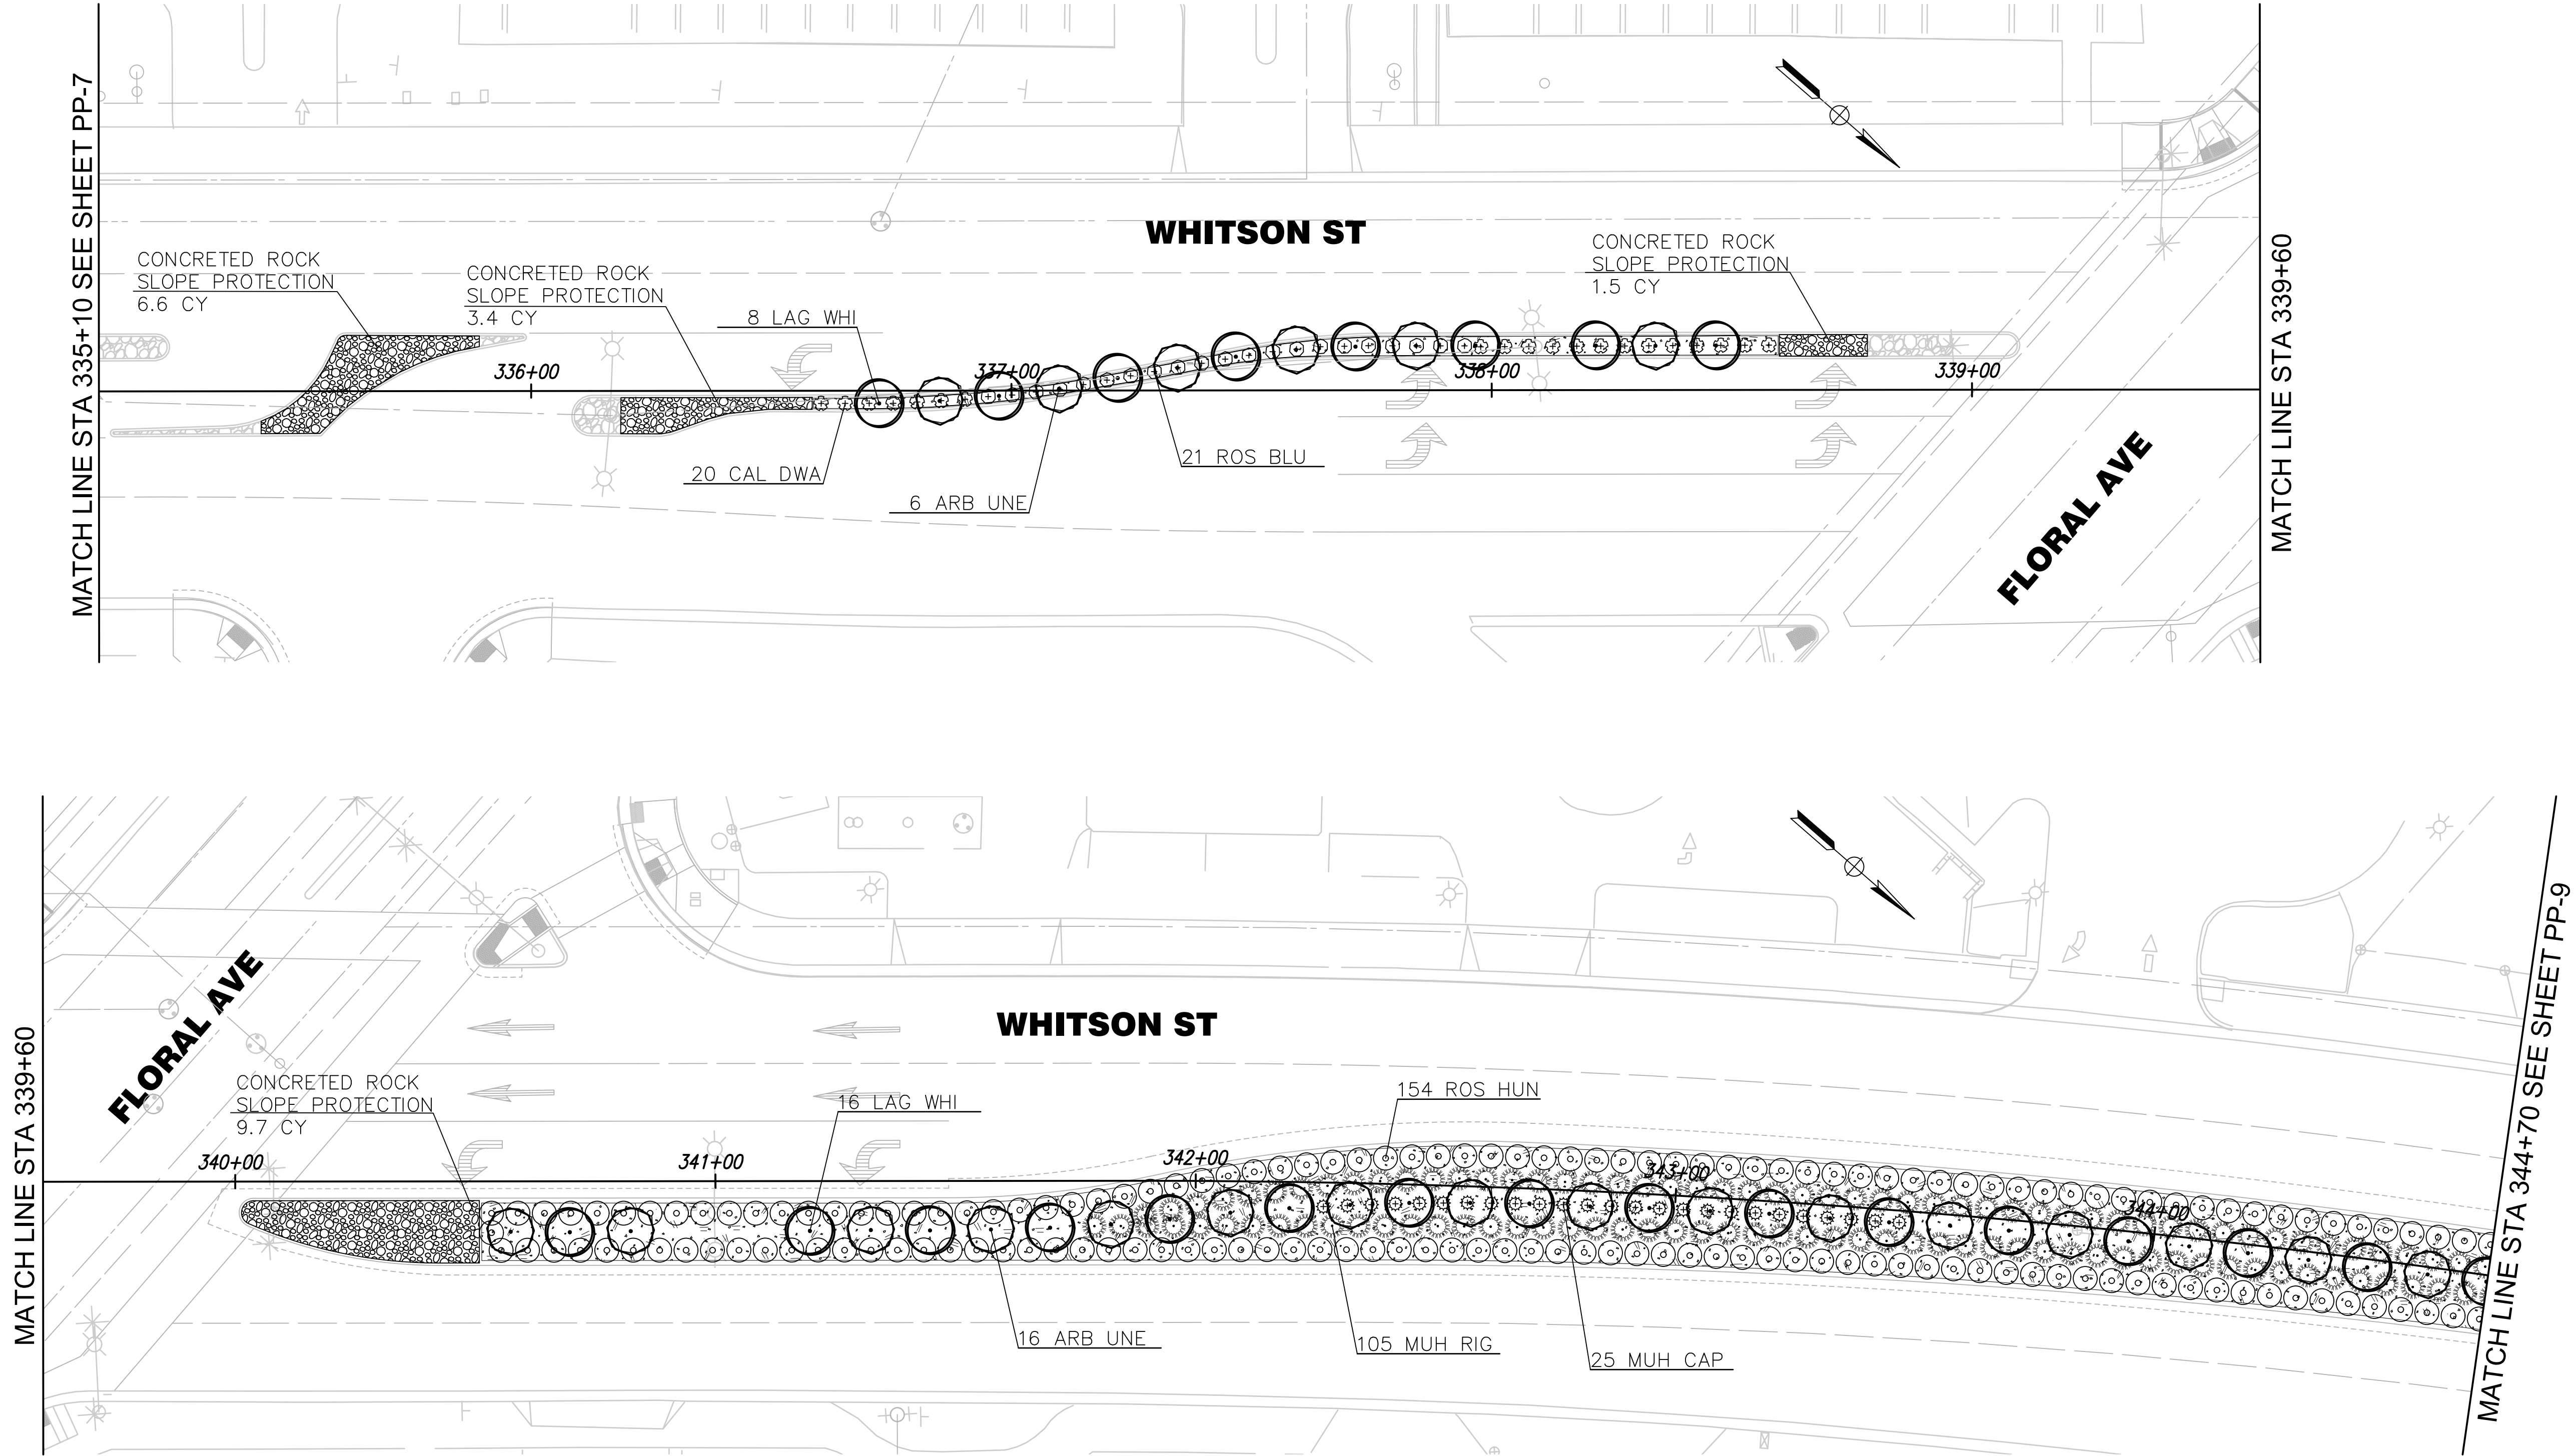

SCALE: 1"=20'-0"

RECORD DRAWING	
DESIGNED: PB	DATE 12/14/20
DRAWN: KJ	DATE 12/14/20
CHECKED: PB	DATE 01/19/21

designlab 252

P.O. Box 27616 Fresno, CA 93729
Studio: 559.472.9966 Fax: 559.472.9969

TENTATIVE PLANS FOR DESIGN
SUPERVISING ENGINEER DATE



PROJECT
GOLDEN STATE BOULEVARD
CITY OF SELMA, CA




DEPARTMENT OF PUBLIC WORKS AND PLANNING

PLANTING PLAN

DRAWING NO. PP-8 SHEET NO. 134 TOTAL 154

PATH: D:\Dropbox\DL252\Term Folder\Projects\2015\15-05-006 Golden State\05-CAD\5.01-PLANS\5.01.5-LANDSCAPE PLAN\5.01.5.1-WORKING\LOT DATE: 2/22/2021 5:08:19 PM CAD USER: KONNI
DRAWING: V:\001\15-05-006\K2\100_PPnew.dwg

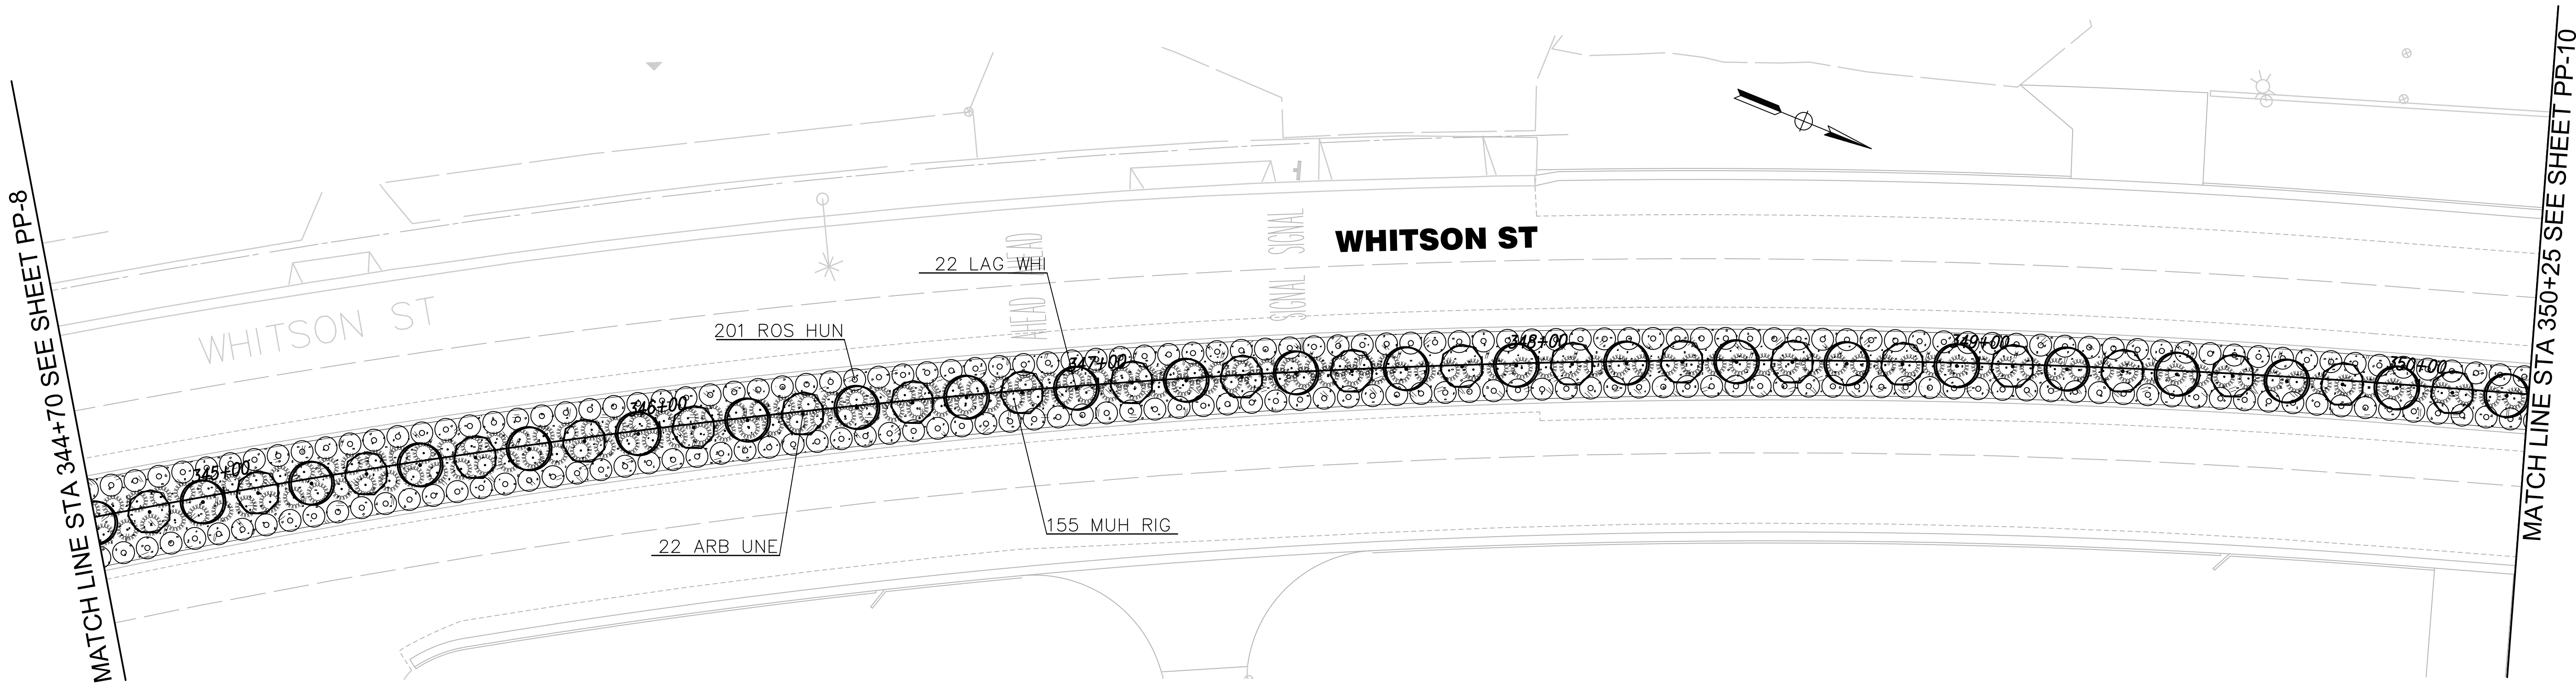

SCALE: 1"=20'-0"


RECORD DRAWING	
DESIGNED: PB	12/14/20
DRAWN: KJ	12/14/20
CHECKED: PB	01/19/21

designlab 252
P.O. Box 27616 Fresno, CA 93729
Studio: 559.472.9966 Fax: 559.472.9969

TENTATIVE PLANS FOR DESIGN
SUPERVISING ENGINEER DATE




PROJECT
GOLDEN STATE BOULEVARD
CITY OF SELMA, CA

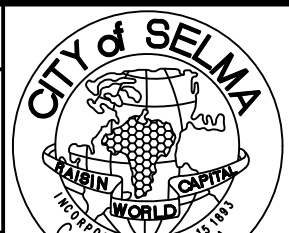

DEPARTMENT OF PUBLIC WORKS AND PLANNING
PLANTING PLAN
DRAWING NO. PP-9 SHEET NO. 135 TOTAL 154

PATH: D:\projects\01252\01252_05-006 Golden State\05-CAD\05-01-PLANS\05-01-5-LANDSCAPE PLAN\05-01-5-1-WORKING\LOT DATE: 2/22/2021 5:08:21 PM CAD USER: KONNI
DRAWING: 01252-05-006-001-PP-10.dwg

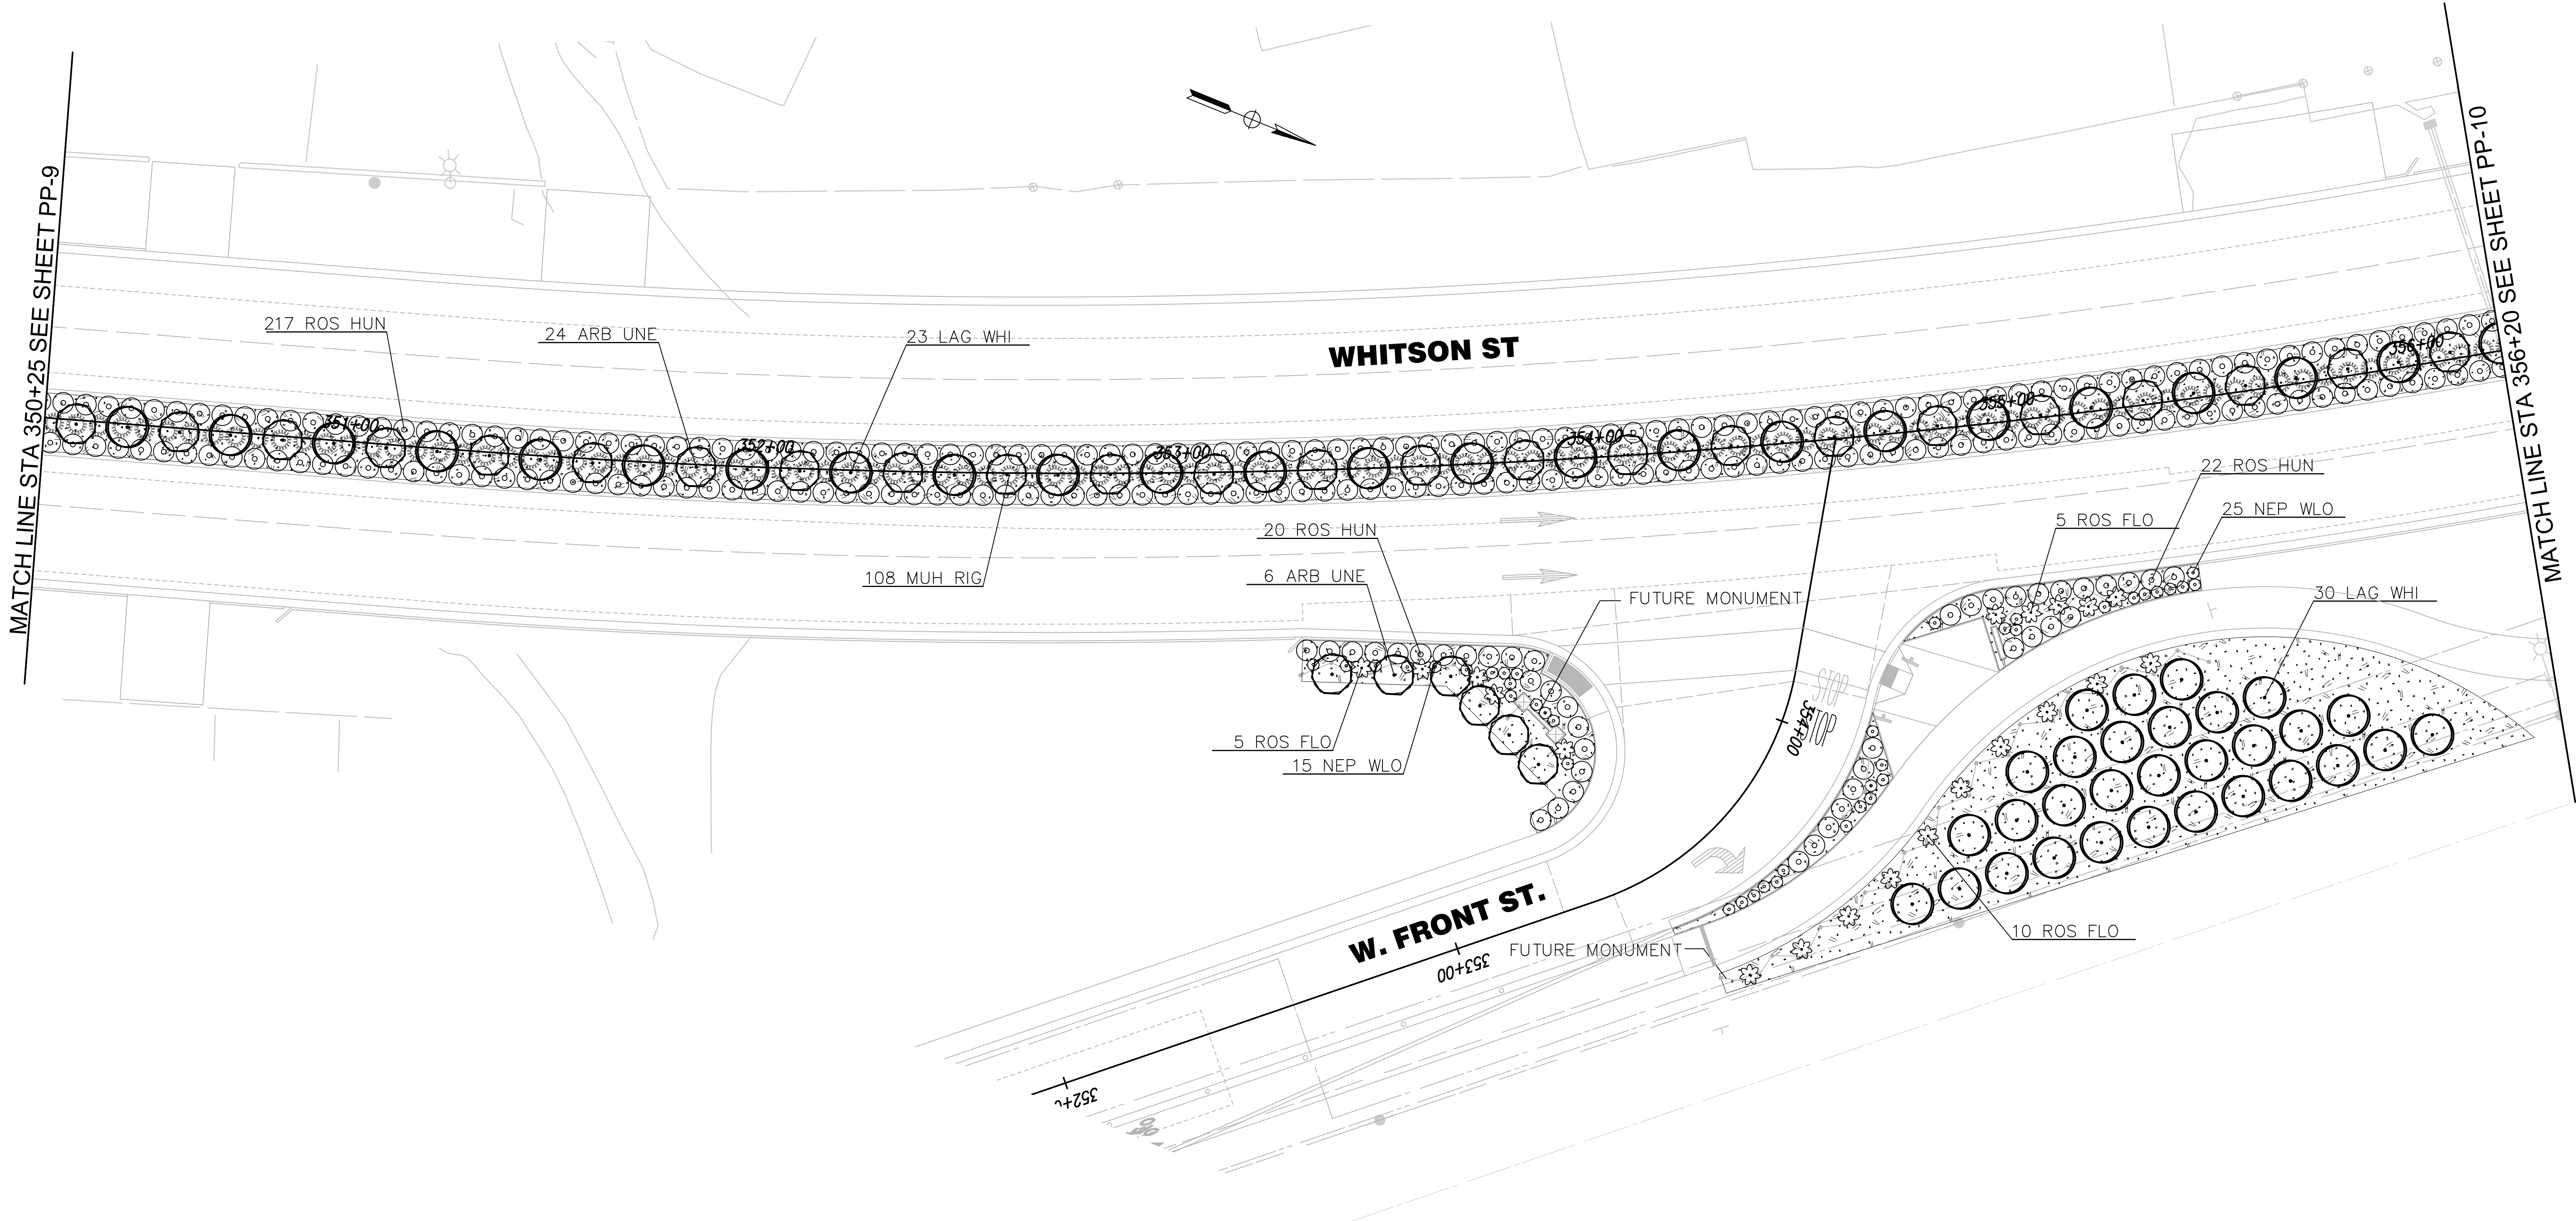


SCALE: 1"=20'-0"


RECORD DRAWING	
DESIGNED: PB	DATE 12/14/20
DRAWN: KJ	DATE 12/14/20
CHECKED: PB	DATE 01/19/21

designlab 252
P.O. Box 27616 Fresno, CA 93729
Studio: 559.472.9966 Fax: 559.472.9969

TENTATIVE PLANS FOR DESIGN
SUPERVISING ENGINEER DATE

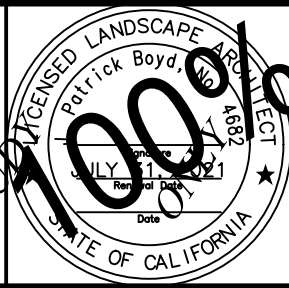


PROJECT
GOLDEN STATE BOULEVARD
CITY OF SELMA, CA

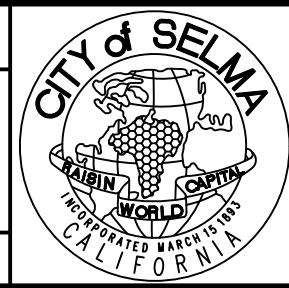

DEPARTMENT OF PUBLIC WORKS AND PLANNING
PLANTING PLAN
DRAWING NO. PP-10 SHEET NO. 136 TOTAL 154

PATH: D:\Dropbox\DL252\Term Folder\PROJECTS\2015\15-05-006 Golden State\05-CAD\5.01-PLANS\5.01-5-LANDSCAPE PLAN\5.01.5.1-WORKING\LOT DATE: 2/22/2021 5:08:22 PM CAD USER: KONNI
DRAWING: 15-05-006-KZ-100-PPnew.dwg

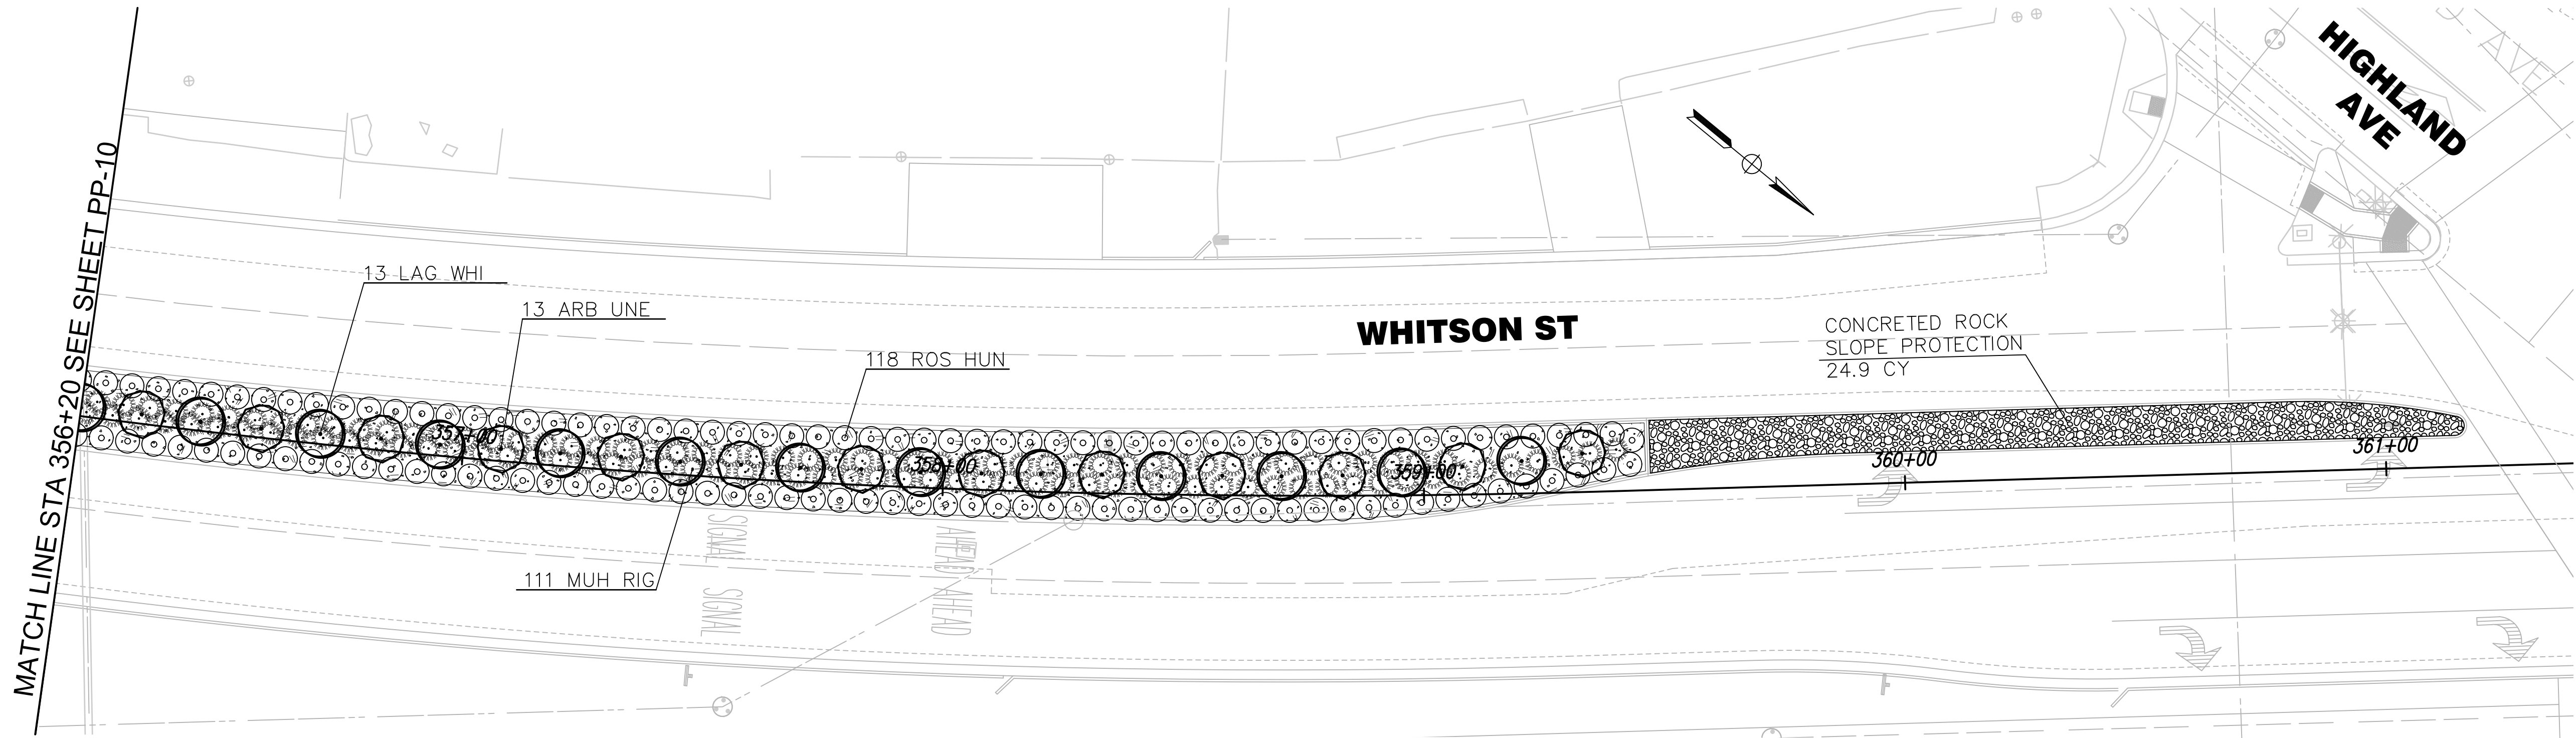

SCALE: 1"=20'-0"

	DATE	RECORD DRAWING	
DESIGNED: PB	12/14/20	RESIDENT ENGINEER	DATE
DRAWN: KJ	12/14/20		
CHECKED: PB	01/19/21		


FOR RIGHT OF WAY DATA AND ACCURATE ACCESS DETERMINATION, SEE DOCUMENTS IN THE DEPARTMENT OF PUBLIC WORKS AND PLANNING.

des:gnlab 252
P.O. Box 27616 Fresno, CA 93729
Studio: 559.472.9966 Fax: 559.472.9969

TENTATIVE PLANS FOR DESIGN
SUPERVISING ENGINEER DATE



PROJECT
GOLDEN STATE BOULEVARD
CITY OF SELMA, CA

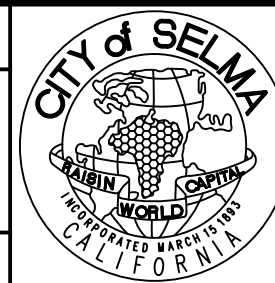


DEPARTMENT OF PUBLIC WORKS AND PLANNING


PLANTING PLAN

DRAWING NO. PP-11 SHEET NO. 137 TOTAL 154

PATH: D:\Dropbox (DL252)\DL252 Team Folder\PROJECTS\2015\15-05-006 Golden State\05-CAD\5.01-PLANS\5.01-5-LANDSCAPE PLAN\5.01.5.1-WORKING\LOT DATE: 2/22/2021 5:08:24 PM CAD USER: KONNI
DRAWING: V2\1001\15-05-006\K2_100_PPnew.dwg

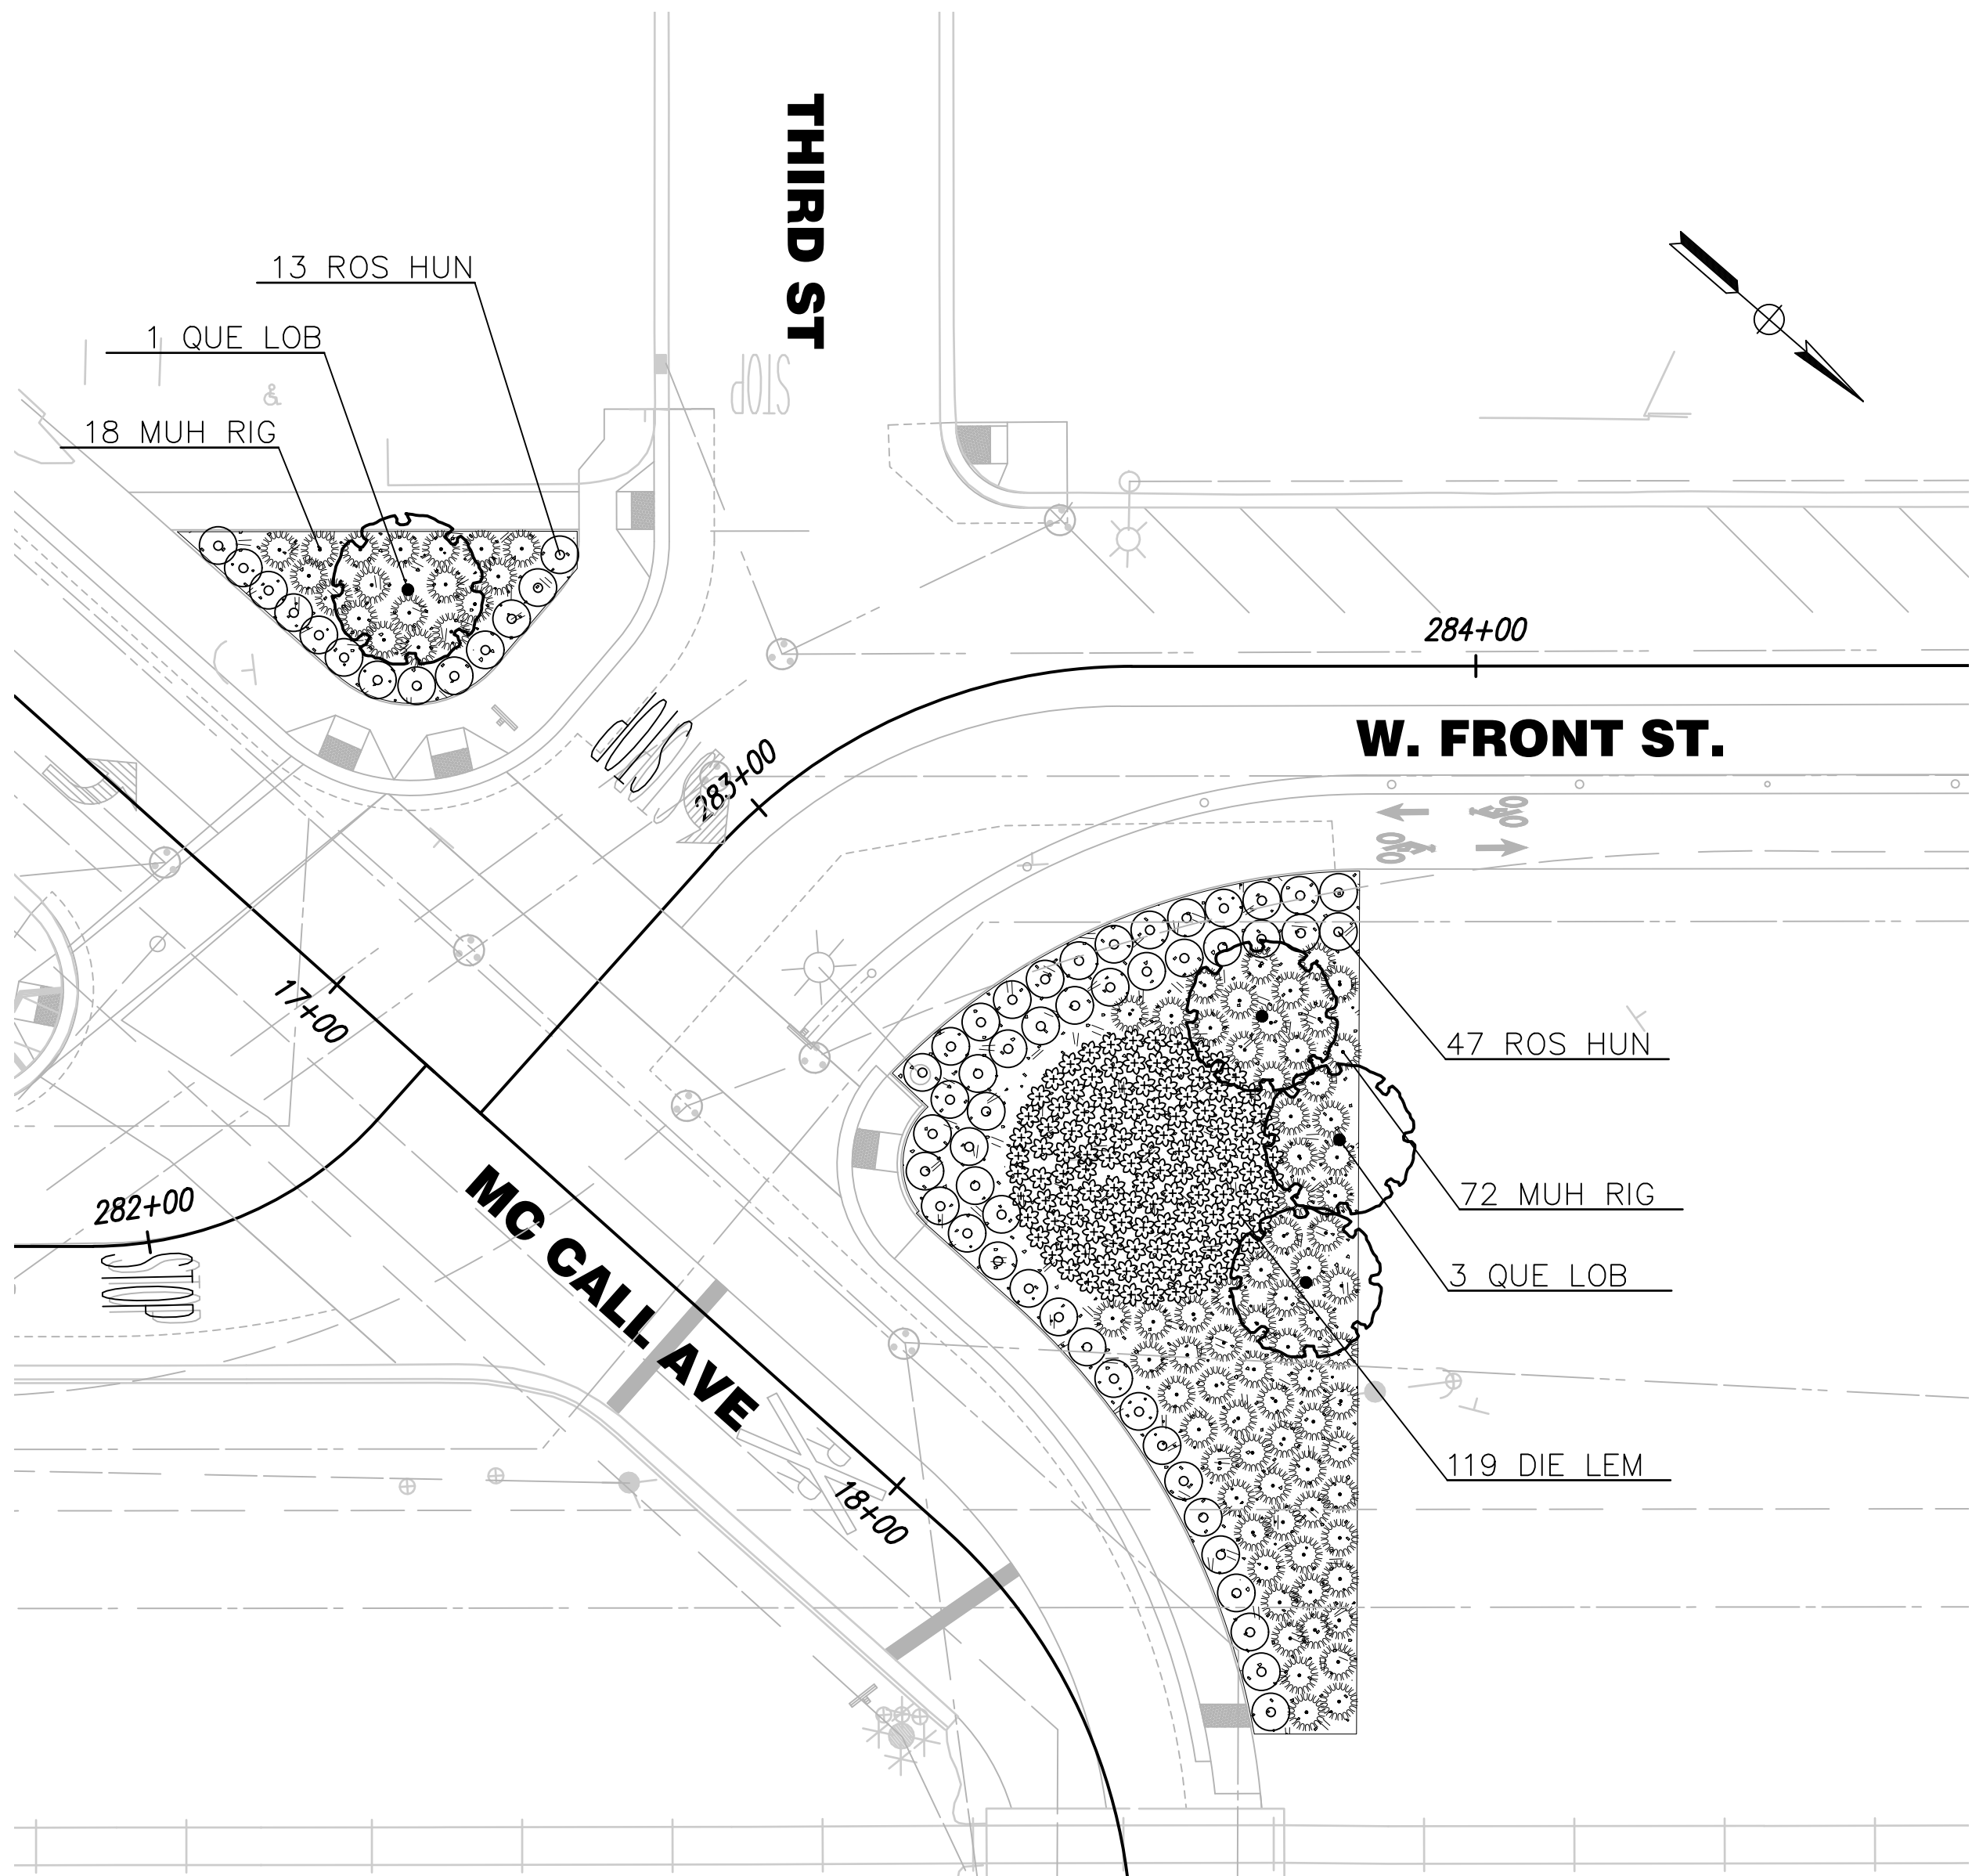

W. FRONT STREET AT McCALL AVE

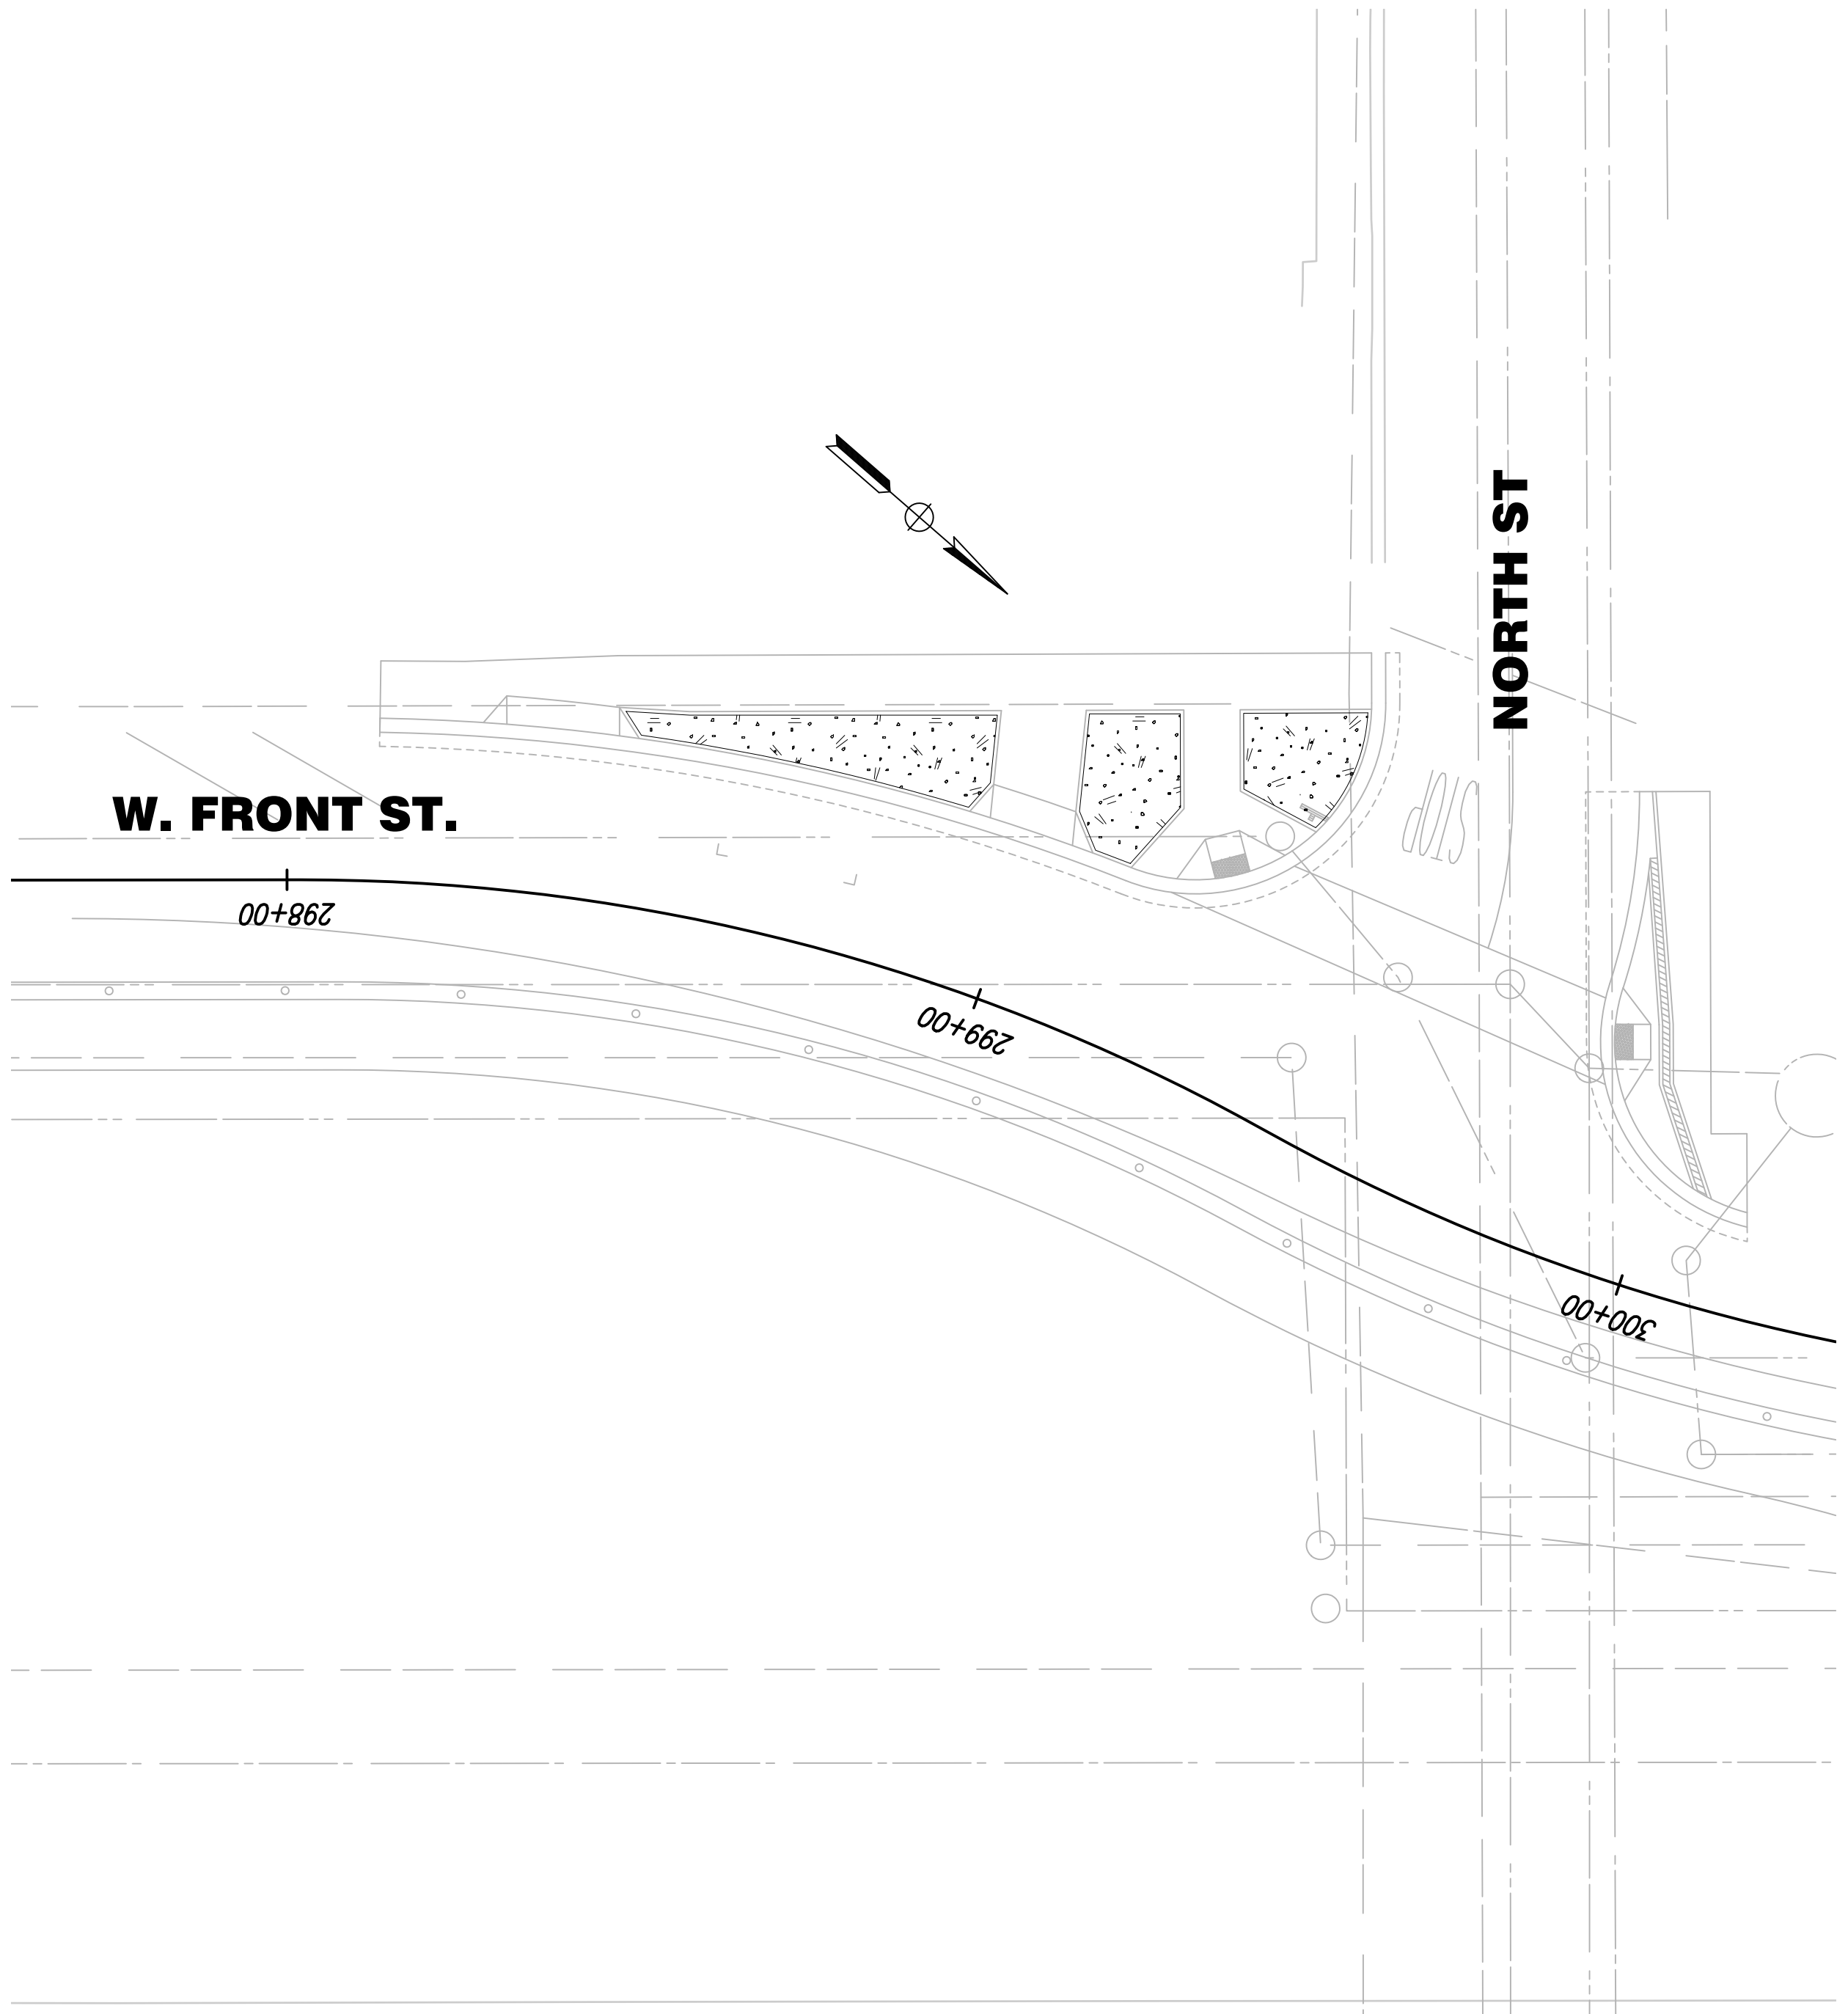

W. FRONT STREET AT NORTH ST

SCALE: 1"=20'-0"

RECORD DRAWING	
DESIGNED: PB	DATE 12/14/20
DRAWN: KJ	DATE 12/14/20
CHECKED: PB	DATE 01/19/21

designlab 252

P.O. Box 27616 Fresno, CA 93729
Studio: 559.472.9966 Fax: 559.472.9969

TENTATIVE PLANS FOR DESIGN
SUPERVISING ENGINEER DATE



PROJECT
GOLDEN STATE BOULEVARD
CITY OF SELMA, CA





DEPARTMENT OF PUBLIC WORKS AND PLANNING

PLANTING PLAN


DRAWING NO. PP-12 SHEET NO. 138 TOTAL 154

FOR RIGHT OF WAY DATA AND ACCURATE ACCESS DETERMINATION, SEE DOCUMENTS IN THE DEPARTMENT OF PUBLIC WORKS AND PLANNING.

PATH: D:\projects\DL252\Temp_Folder\PROJECTS\2015\15-05-006 Golden State\05-CAD\5.01-PLANS\5.01.5-LANDSCAPE PLAN\5.01.5.1-WORKING\LOT DATE: 2/22/2021 5:08:24 PM CAD USER: KONNI
DRAWING: V2\100\15-05-006r2\100_PPlan.dwg

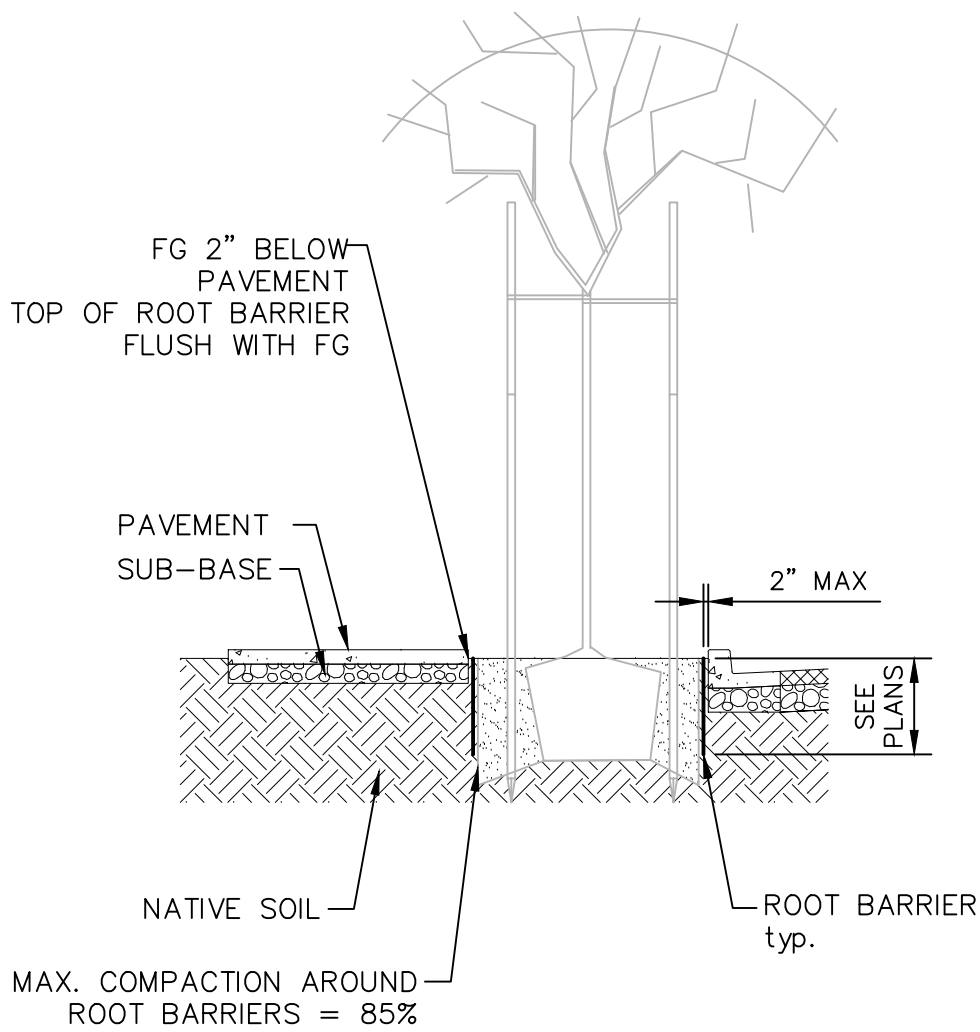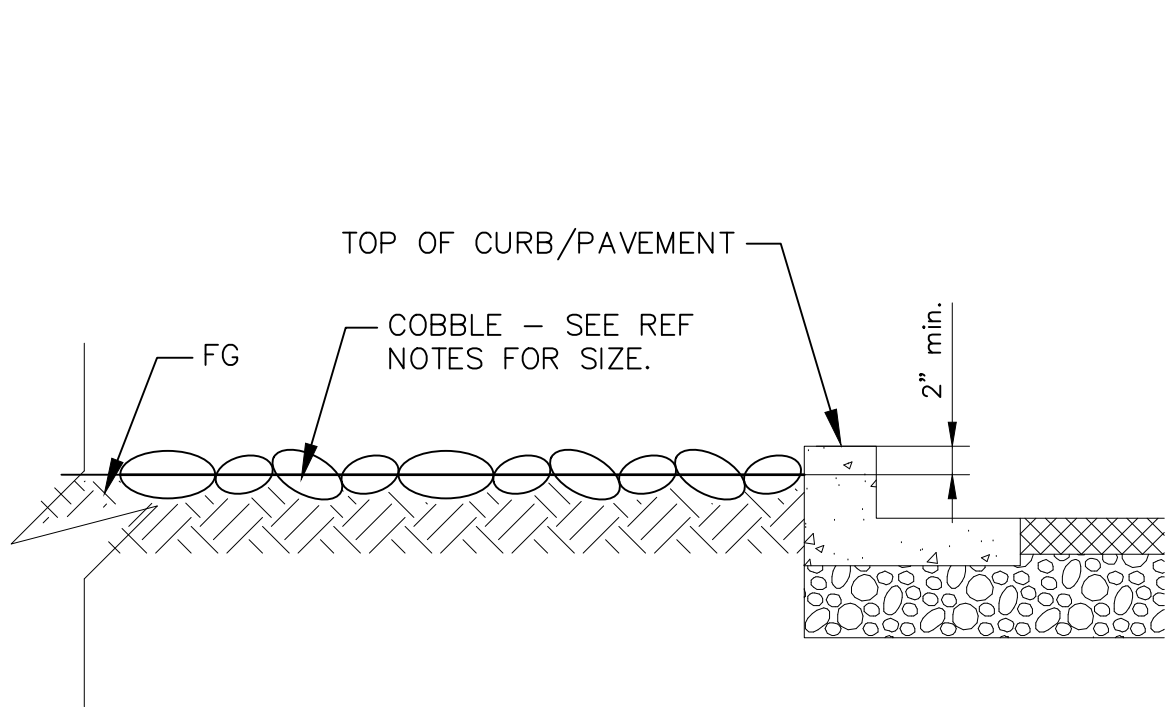

1 CONCRETED ROCK SLOPE PROTECTION
3/4" = 1'-0" DL-HA-STO-01

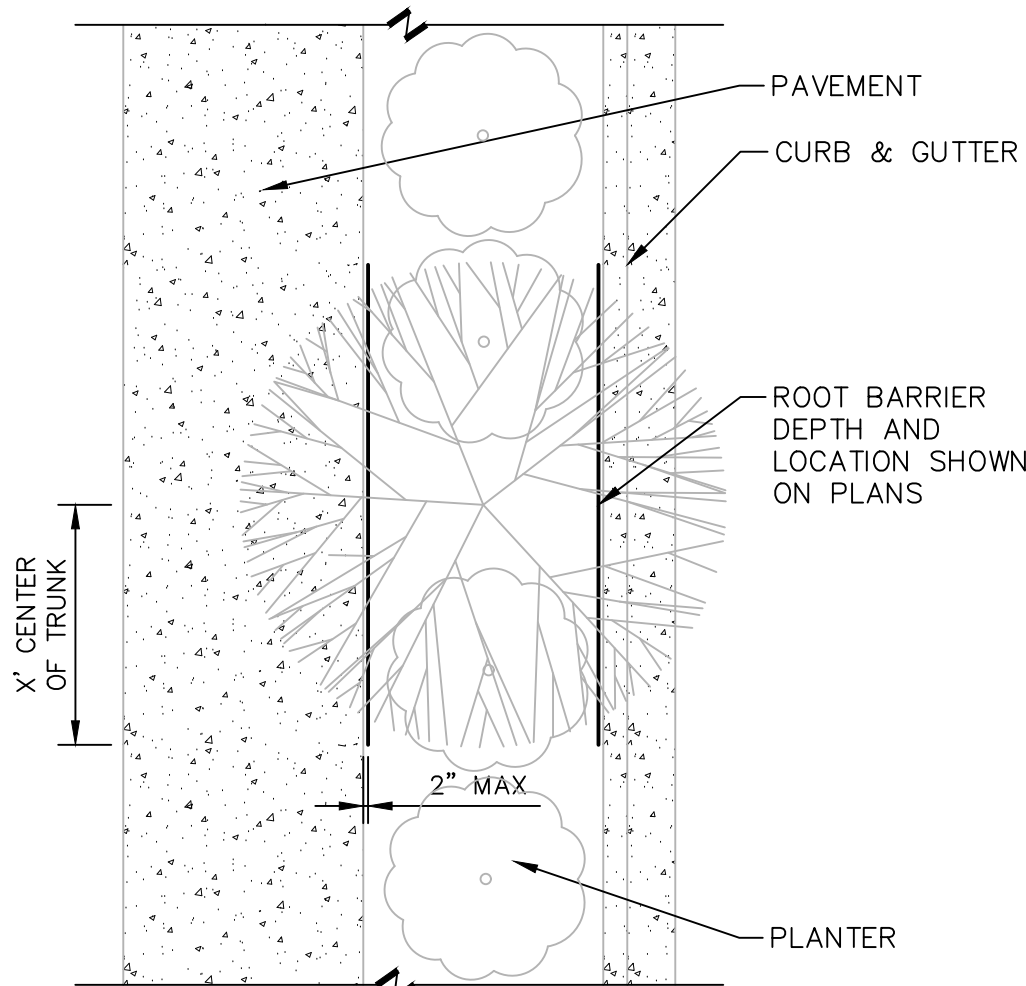

NOTE:
1. ROOT BARRIERS SHALL BE INSTALLED PER MANUFACTURERS SPECIFICATIONS.
2. LENGTH AND DEPTH INDICATED ON PLANS.

2 LINEAR ROOT BARRIER
1/4" = 1'-0" DL-PL-TRE-11

RECORD DRAWING		DATE	
DESIGNED: PB	12/14/20	RESIDENT ENGINEER	DATE
DRAWN: KJ	12/14/20		
CHECKED: PB	01/19/21		

FOR RIGHT OF WAY DATA AND ACCURATE ACCESS DETERMINATION, SEE DOCUMENTS IN THE DEPARTMENT OF PUBLIC WORKS AND PLANNING.

designlab 252
P.O. Box 27616 Fresno, CA 93729
Studio: 559.472.9966 Fax: 559.472.9969

TENTATIVE PLANS FOR DESIGN
SUPERVISING ENGINEER DATE



 
PROJECT
GOLDEN STATE BOULEVARD
CITY OF SELMA, CA








DEPARTMENT OF PUBLIC WORKS AND PLANNING
LANDSCAPE DETAILS
DRAWING NO. LD-1 SHEET NO. 139 TOTAL 154

PATH: D:\Dropbox (DL252)\DL252 Team Folder\PROJECTS\2015\15-05-006 Golden State\05-CAD\5.01-PLANS\5.01.5-LANDSCAPE PLAN\5.01.5.1-WORKING\LOT DATE: 2/22/2021 5:11:26 PM CAD USER: KONNI

IRRIGATION SCHEDULE

SYMBOL	MANUFACTURER/MODEL/DESCRIPTION	QTY	ARC	PSI	GPM	RADIUS
	TREE WELL SPRINKLER ASSEMBLY 0.25 GPH HEADS	938	360	20	0.25	3'
SYMBOL	MANUFACTURER/MODEL/DESCRIPTION	QTY				
	DRIP VALVE ASSEMBLY 1" 0.10GPM-30.0GPM.	19				
	FLUSH VALVE PLUMBED TO FLUSH MANIFOLD AT LOW POINT.	35				
	AREA TO RECEIVE DRIPLINE DRIPLINE DRIPLINE- IN PRESSURE COMPENSATING LANDSCAPE DRIPLINE. 0.53 GPH EMITTERS AT 18" O.C. DRIPLINE LATERALS SPACED AT 24" APART, WITH EMITTERS OFFSET FOR TRIANGULAR PATTERN.	58,589 L.F.				
SYMBOL	MANUFACTURER/MODEL/DESCRIPTION	QTY				
	REMOTE CONTROL VALVE 1"	20				
	BALL VALVE BRASS OR BRONZE. LINE SIZE.	17				
	GATE VALVE IRON OR BRONZE. LINE SIZE	5				
	MASTER VALVE 2"	5				
	BACKFLOW PREVENTER ASSEMBLY 2" REDUCED PRESSURE BACKFLOW PREVENTER IN CAGE	5				
	IRRITROL MC-12-E WITH CLIMATE LOGIC 12- STATION, COMMERCIAL-GRADE CONTROLLER. EQUIPPED IN A RUGGED, LOCKABLE, VANDAL-PROOF, WEATHER RESISTANT STEEL CABINET IN PEDESTAL P-2B.	1				
	IRRITROL MC-12-E WITH CLIMATE LOGIC 12- STATION, COMMERCIAL-GRADE CONTROLLER. EQUIPPED IN A RUGGED, LOCKABLE, VANDAL-PROOF, WEATHER RESISTANT STEEL CABINET IN PEDESTAL P-2B.	1				
	IRRITROL MC-12-E WITH CLIMATE LOGIC 12- STATION, COMMERCIAL-GRADE CONTROLLER. EQUIPPED IN A RUGGED, LOCKABLE, VANDAL-PROOF, WEATHER RESISTANT STEEL CABINET IN PEDESTAL P-2B.	1				
	IRRITROL MC-12-E WITH CLIMATE LOGIC 12- STATION, COMMERCIAL-GRADE CONTROLLER. EQUIPPED IN A RUGGED, LOCKABLE, VANDAL-PROOF, WEATHER RESISTANT STEEL CABINET IN PEDESTAL P-2B.	1				
	IRRITROL MC-12-E WITH CLIMATE LOGIC 12- STATION, COMMERCIAL-GRADE CONTROLLER. EQUIPPED IN A RUGGED, LOCKABLE, VANDAL-PROOF, WEATHER RESISTANT STEEL CABINET IN PEDESTAL P-2B.	1				

    IRRIGATION SCHEDULE

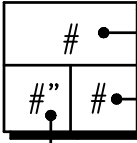SYMBOL	MANUFACTURER/MODEL/DESCRIPTION	QTY
	WATER METER 2" PROPOSED LOCATION WM #1	1
	WATER METER 2" PROPOSED LOCATION WM #2	1
	WATER METER 2" PROPOSED LOCATION WM #3	1
	WATER METER 2" PROPOSED LOCATION WM #4	1
	WATER METER 2" PROPOSED LOCATION WM #5	1
	IRRIGATION LATERAL LINE: PVC SCHEDULE 40 3/4"	11,024 L.F.
	IRRIGATION LATERAL LINE: PVC SCHEDULE 40 1"	1,404 L.F.
	IRRIGATION LATERAL LINE: PVC SCHEDULE 40 1 1/4"	1,062 L.F.
	IRRIGATION LATERAL LINE: PVC SCHEDULE 40 1 1/2"	570.4 L.F.
	IRRIGATION LATERAL LINE: PVC SCHEDULE 40 2"	1,188 L.F.
	IRRIGATION MAINLINE: PVC SCHEDULE 40 2"	7,306 L.F.
	PIPE SLEEVE: PVC CLASS 315 SDR 13.5	2,191 L.F.
Valve Callout		
	#	Valve Number
	#"	Valve Flow
	#	Valve Size

	DATE	RECORD DRAWING	
DESIGNED: PB	12/14/20	RESIDENT ENGINEER	DATE
DRAWN: KJ	12/14/20		
CHECKED: PB	01/19/21		
FOR RIGHT OF WAY DATA AND ACCURATE ACCESS DETERMINATION, SEE DOCUMENTS IN THE DEPARTMENT OF PUBLIC WORKS AND PLANNING.			

designlab 252
P.O. Box 27616 Fresno, CA 93729
Studio: 559.472.9966 Fax: 559.472.9969

TENTATIVE PLANS FOR DESIGN

SUPERVISING ENGINEER

DATE




PROJECT
GOLDEN STATE BOULEVARD CITY OF SELMA, CA



DEPARTMENT OF PUBLIC WORKS AND PLANNING		
IRRIGATION LEGEND		
DRAWING NO. IL-1	SHEET NO. 140	TOTAL 154

PATH: D:\Dropbox\DL252\Team Folder\PROJECTS\2015\15-05-006 Golden State\05-CAD\5.01-PLANS\5.01.5-LANDSCAPE PLAN\5.01.5.1-WORKING\LOT DATE: 2/22/2021 5:11:31 PM CAD USER: KONNI
DRAWING: V2\1001\15-05-006\K2_1001.P.dwg

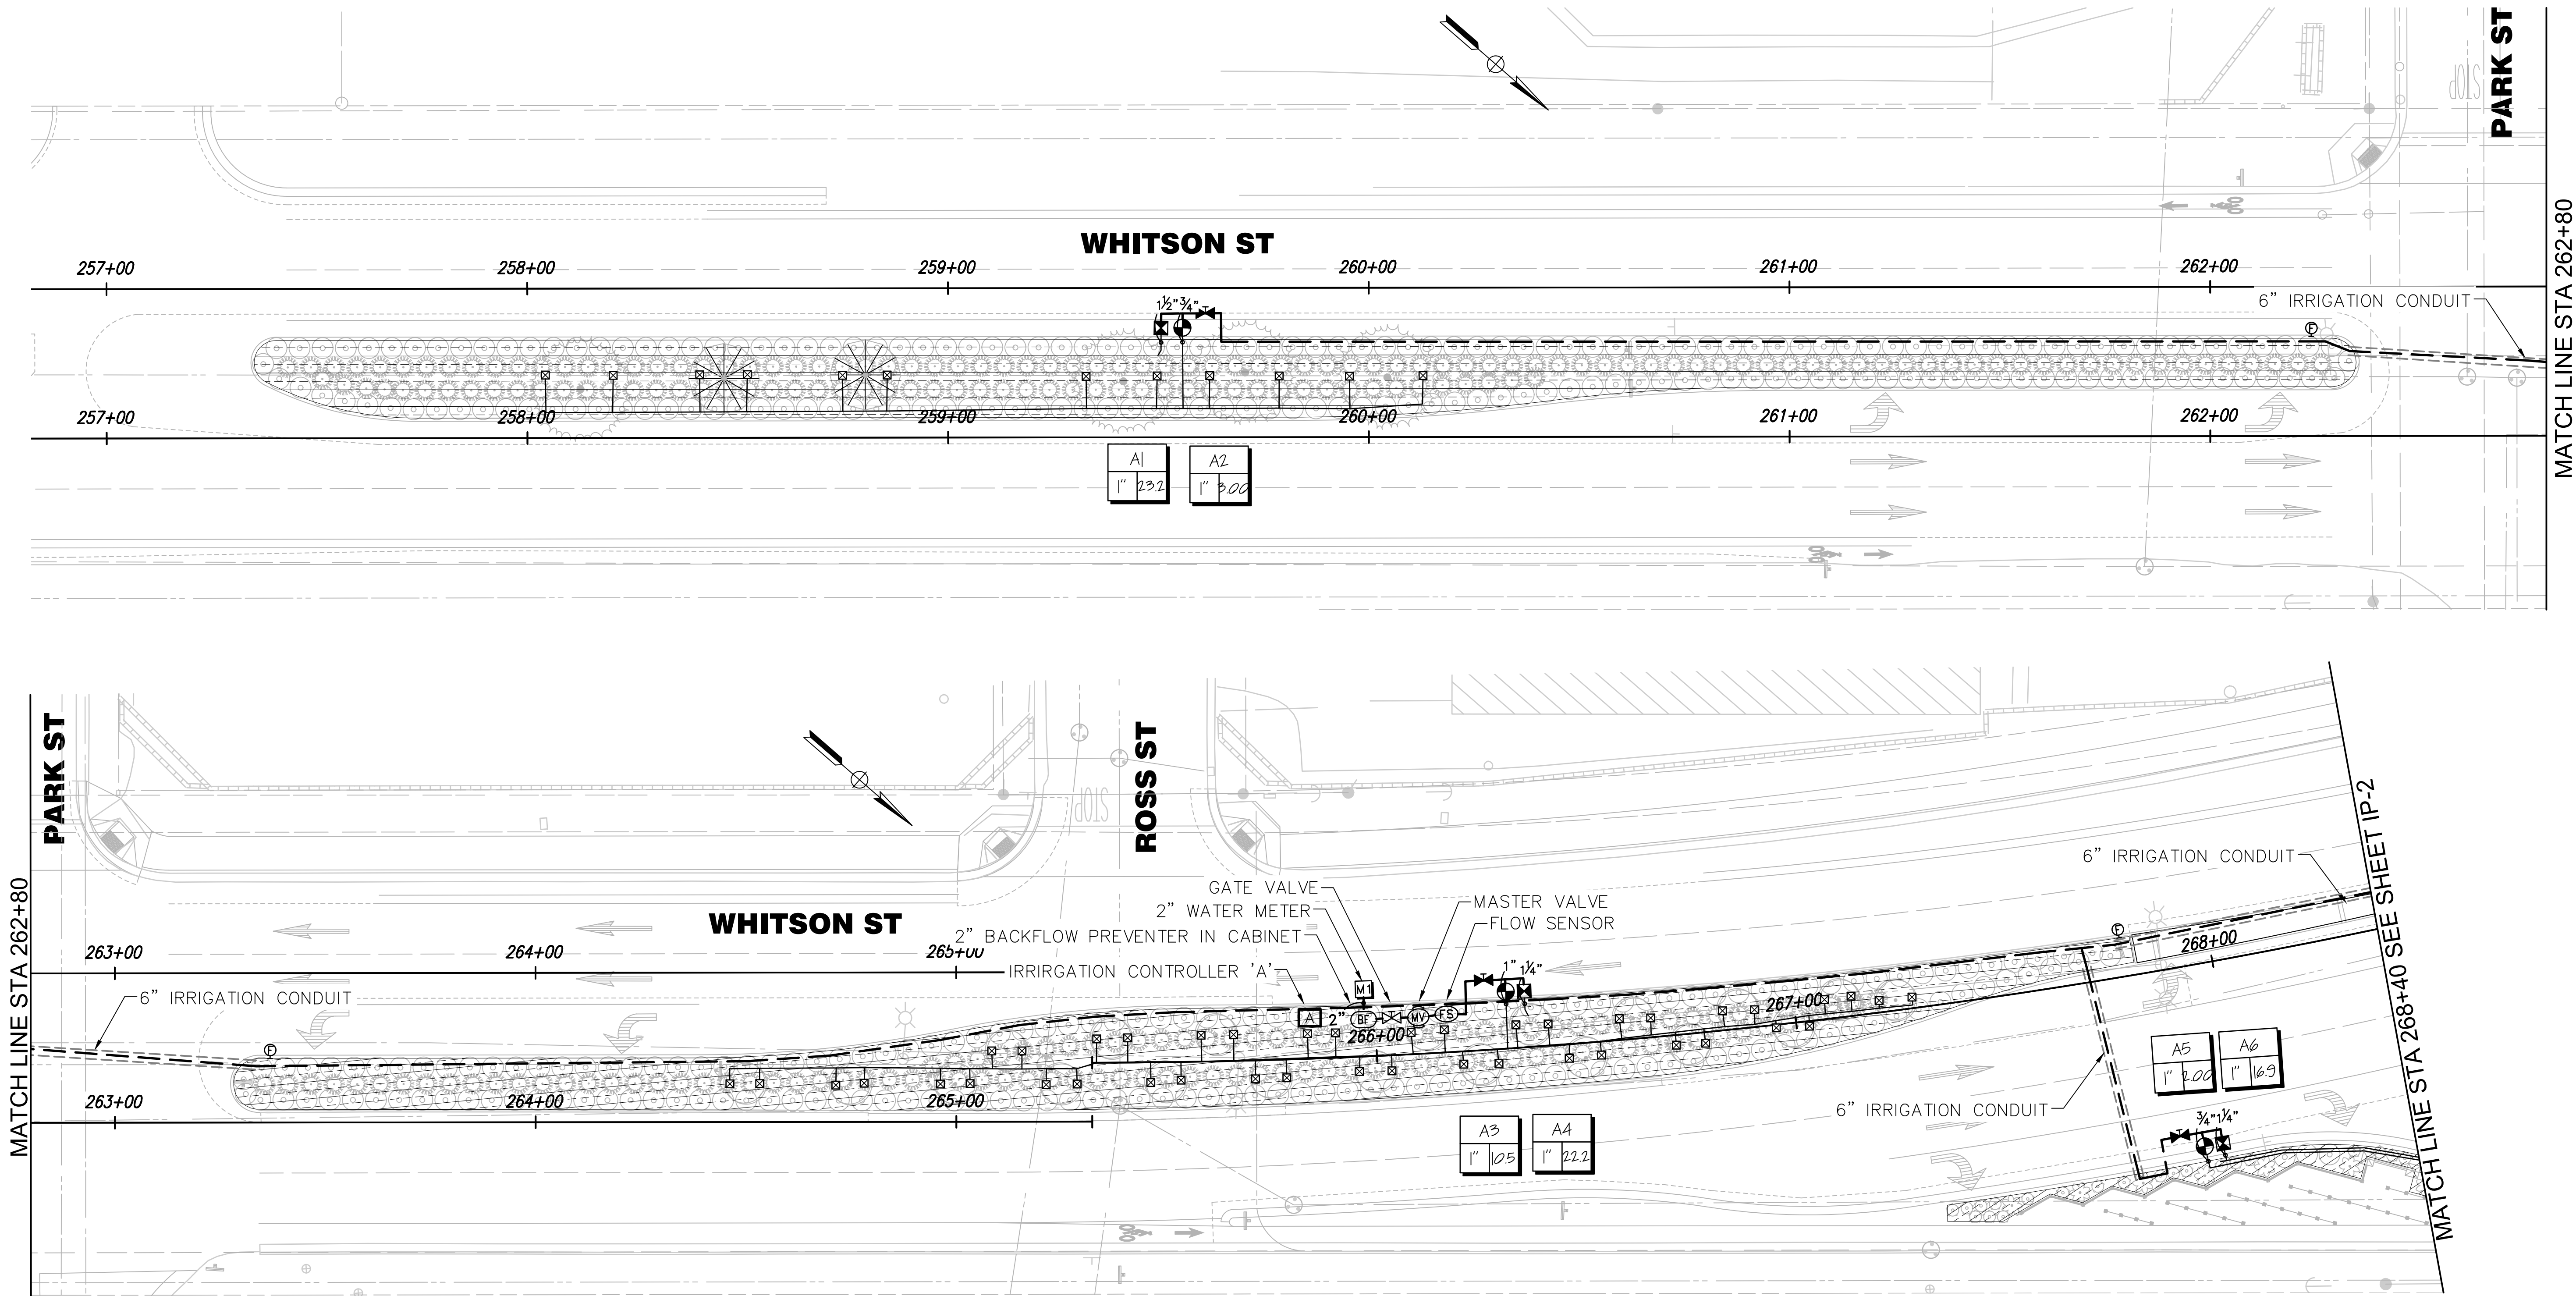

SCALE: 1"=20'-0"


RECORD DRAWING	
DESIGNED: PB	DATE 12/14/20
DRAWN: KJ	DATE 12/14/20
CHECKED: PB	DATE 01/19/21

designlab 252
P.O. Box 27616 Fresno, CA 93729
Studio: 559.472.9966 Fax: 559.472.9969


TENTATIVE PLANS FOR DESIGN
SUPERVISING ENGINEER DATE



PROJECT
GOLDEN STATE BOULEVARD
CITY OF SELMA, CA

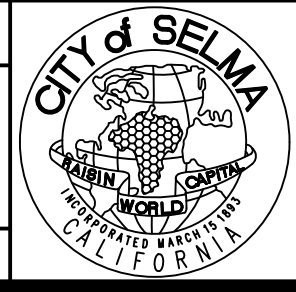

 DEPARTMENT OF PUBLIC WORKS AND PLANNING
IRRIGATION PLAN
DRAWING NO. IP-1 SHEET NO. 141 TOTAL 154



	DATE	RECORD DRAWING	
DESIGNED: PB	12/14/20	RESIDENT ENGINEER	DATE
DRAWN: KJ	12/14/20		
CHECKED: PB	01/19/21		
FOR RIGHT OF WAY DATA AND ACCURATE ACCESS DETERMINATION, SEE DOCUMENTS IN THE DEPARTMENT OF PUBLIC WORKS AND PLANNING.			


des:gnlab 252

P.O. Box 27616 Fresno, CA 93729
Studio: 559.472.9966 Fax: 559.472.9969


PLANS
SUPERVISIN

FOR
G ENGINEER


DATE _____

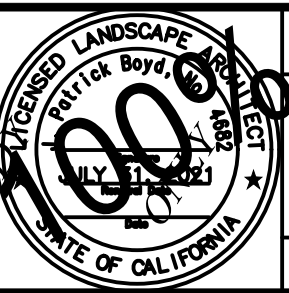

PROJECT
GOLDEN STATE BOULEVARD
CITY OF SELMA, CA

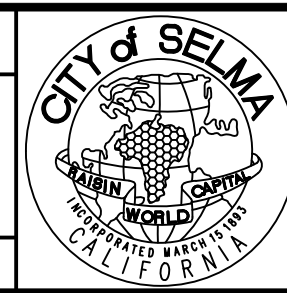



DEPARTMENT OF PUBLIC WORKS AND PLANNING			
IRRIGATION PLAN			
DRAWING NO.	IP-2	SHEET NO.	142
TOTAL		154	

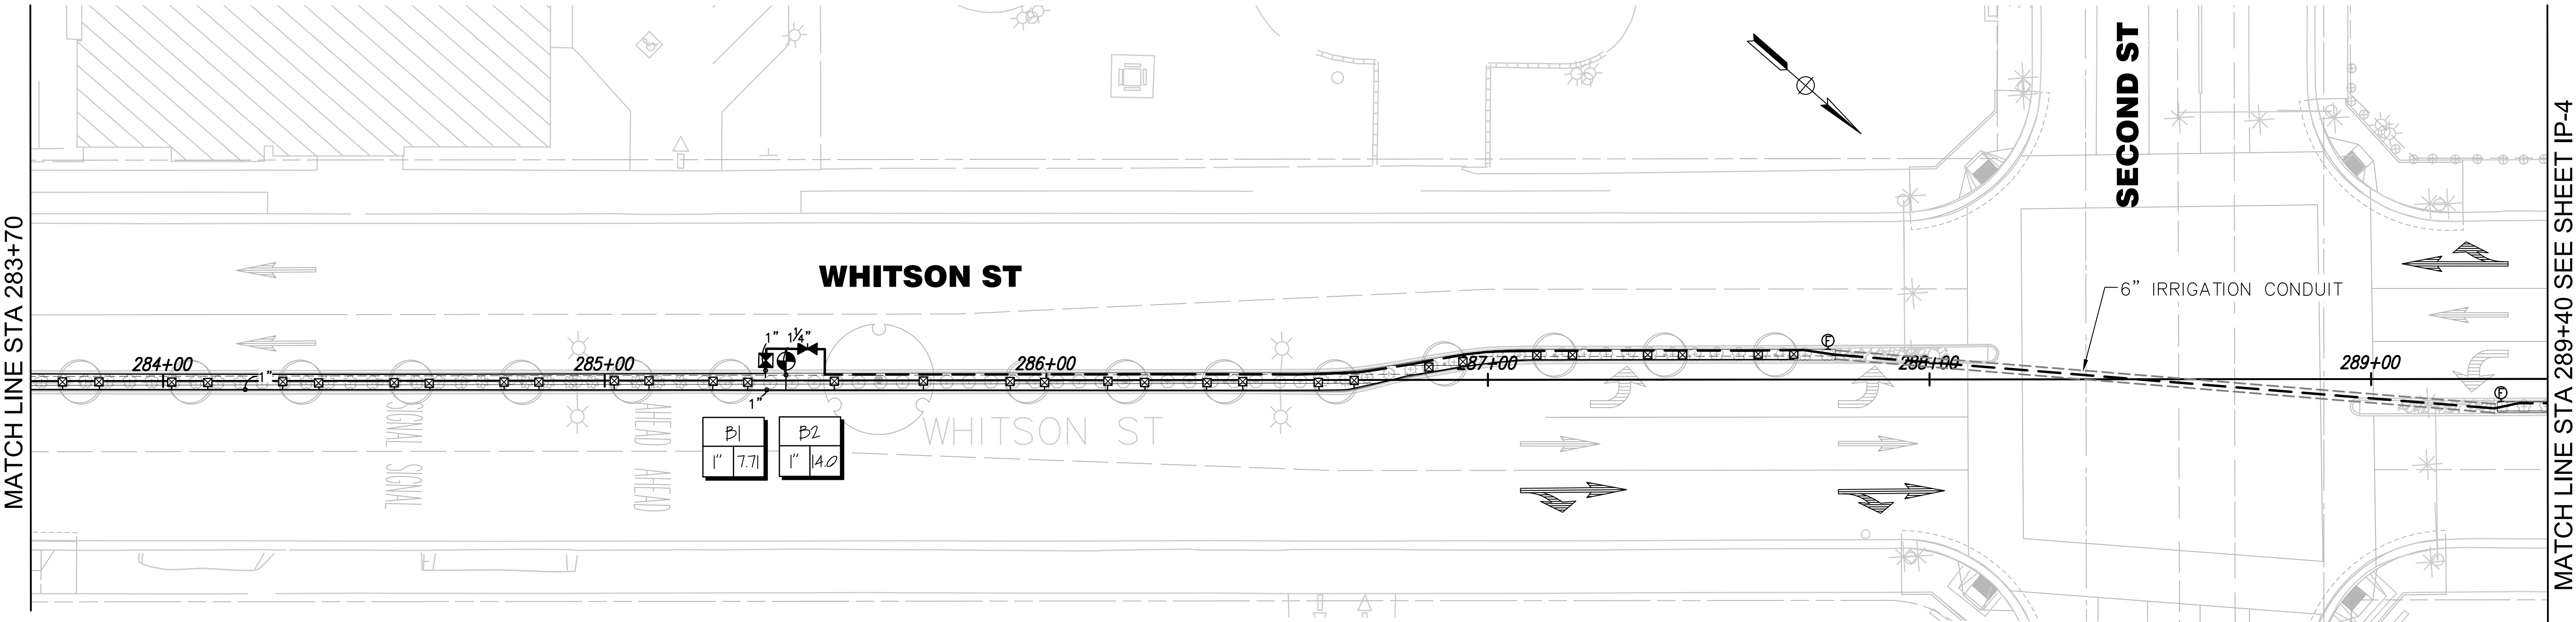

SCALE: 1"=20'-0"

	DATE	RECORD DRAWING		des:gnlab252 P.O. Box 27616 Fresno, CA 93729 Studio: 559.472.9966 Fax: 559.472.9969	TENTATIVE PLANS FOR DESIGN SUPERVISING ENGINEER DATE STAMP 100% LANDSCAPE ARCHITECT DAVID BOYLSTON 50814 STATE OF CALIFORNIA	PROJECT		CITY & SELMA SEAL 1892 2020 LANDSCAPE ARCHITECT DAVID BOYLSTON 50814 STATE OF CALIFORNIA	DEPARTMENT OF PUBLIC WORKS AND PLANNING		
DESIGNED: PB	12/14/20	RESIDENT ENGINEER	DATE			GOLDEN STATE BOULEVARD			IRRIGATION PLAN		
DRAWN: KJ	12/14/20					CITY OF SELMA, CA					
CHECKED: PB	01/19/21										
FOR RIGHT OF WAY DATA AND ACCURATE ACCESS DETERMINATION, SEE DOCUMENTS IN THE DEPARTMENT OF PUBLIC WORKS AND PLANNING.									DRAWING NO. IP-3 SHEET NO. 143 TOTAL 154		

PATH: D:\projects\01252\01252 Team Folder\Projects\2015\15-05-006 Golden State\05-CAD\15.01-PLANS\15.01-5-LANDSCAPE PLAN\15.01-5.1-WORKING\LOT DATE: 2/22/2021 5:11:46 PM CAD USER: KONNI

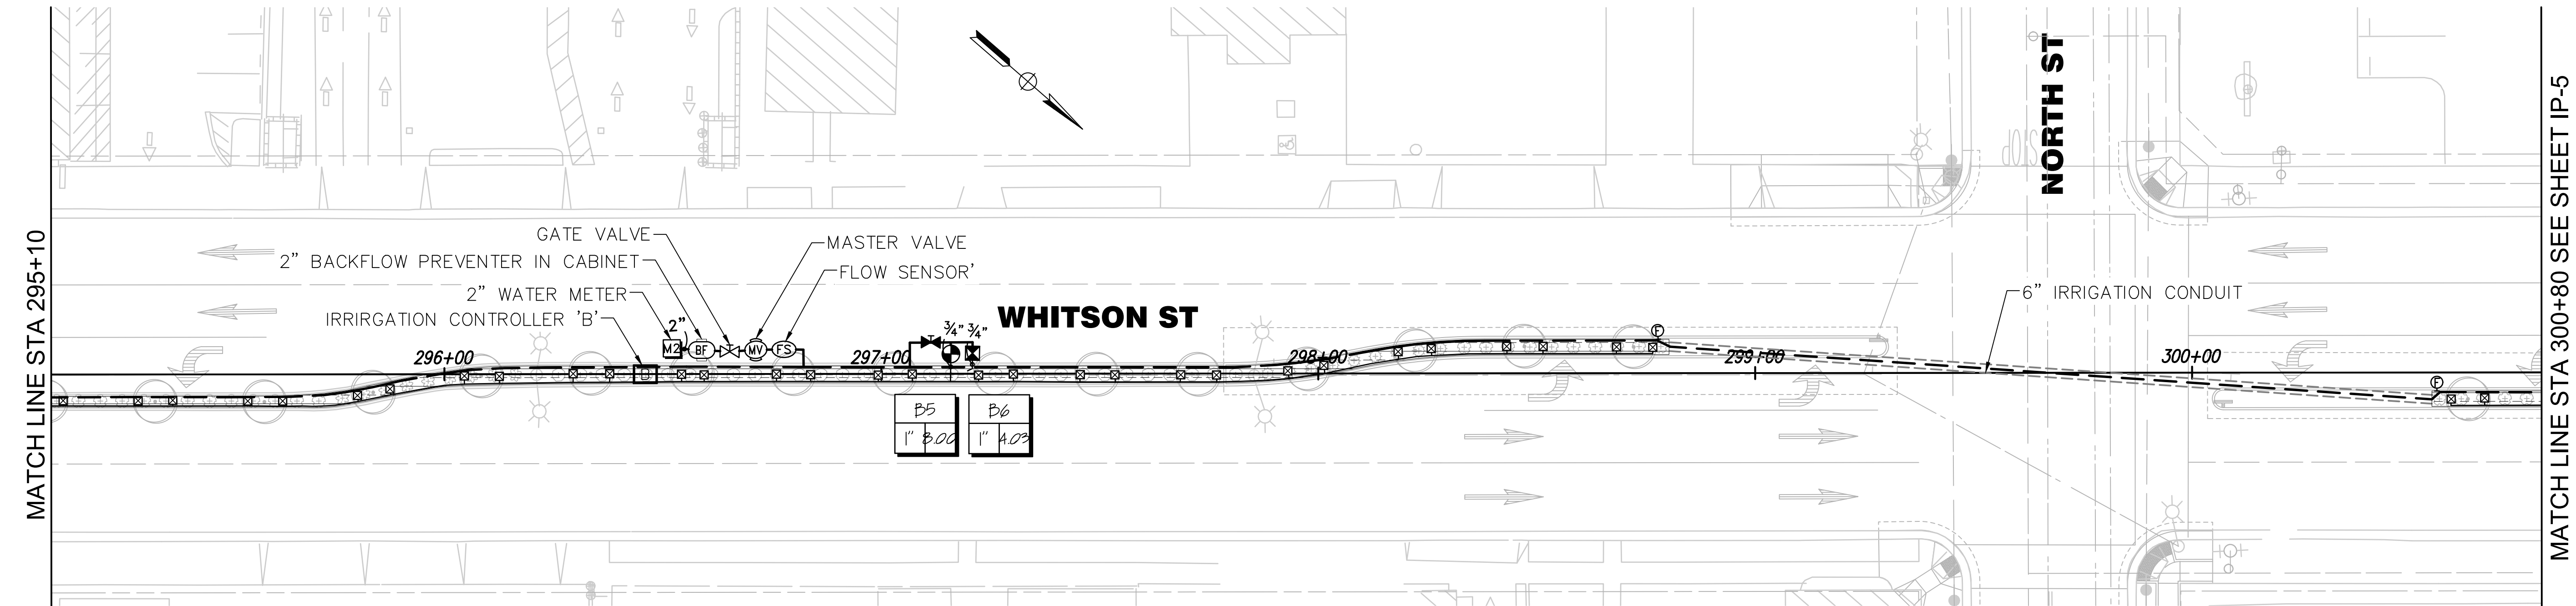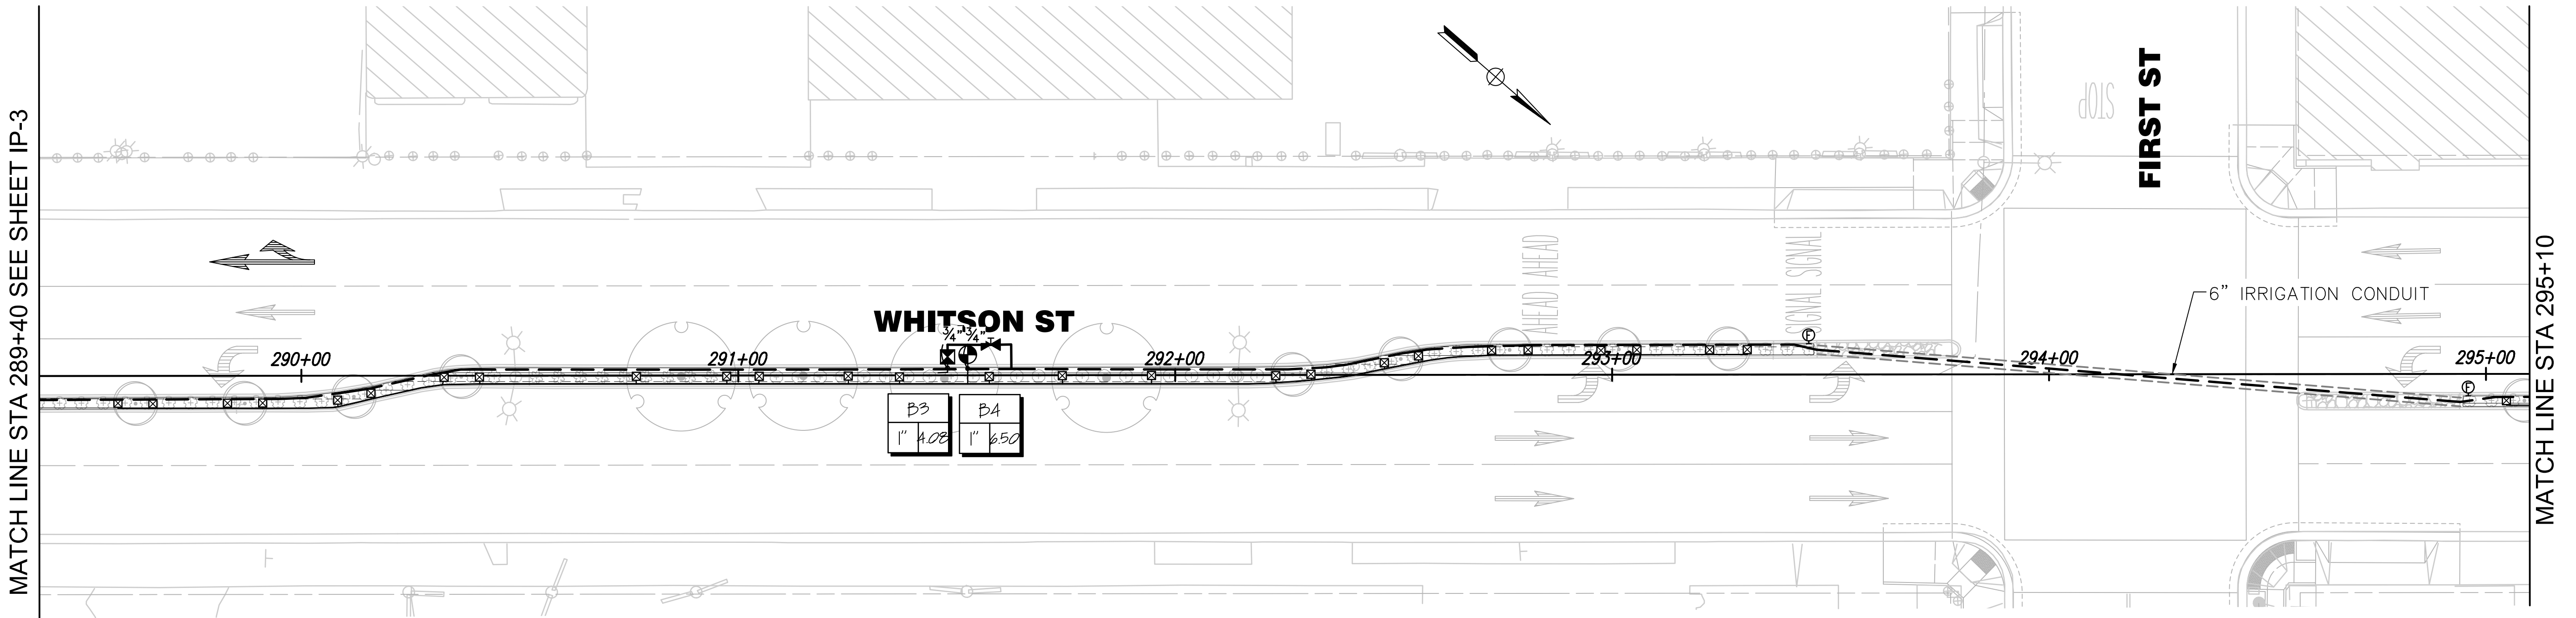

SCALE: 1"=20'-0"

DESIGNED: PB	DATE	RECORD DRAWING	
DRAWN: KJ	12/14/20	RESIDENT ENGINEER	DATE
CHECKED: PB	01/19/21		

FOR RIGHT OF WAY DATA AND ACCURATE ACCESS DETERMINATION, SEE DOCUMENTS IN THE DEPARTMENT OF PUBLIC WORKS AND PLANNING.

designlab 252

P.O. Box 27616 Fresno, CA 93729
Studio: 559.472.9966 Fax: 559.472.9969

TENTATIVE PLANS FOR DESIGN

SUPERVISING ENGINEER


DATE



PROJECT

GOLDEN STATE BOULEVARD

CITY OF SELMA, CA


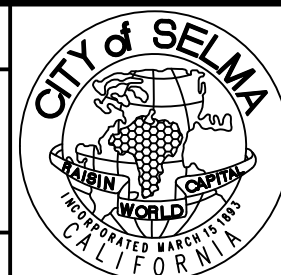


DEPARTMENT OF PUBLIC WORKS AND PLANNING

IRRIGATION PLAN

DRAWING NO. IP-4 SHEET NO. 144 TOTAL 154

PATH: D:\projects\01252\15-05-006 Golden State\05-CAD\15.01-PLANS\15.01-5-LANDSCAPE PLAN\15.01-5.1-WORKING\LOT DATE: 2/22/2021 5:11:50 PM CAD USER: KONNI

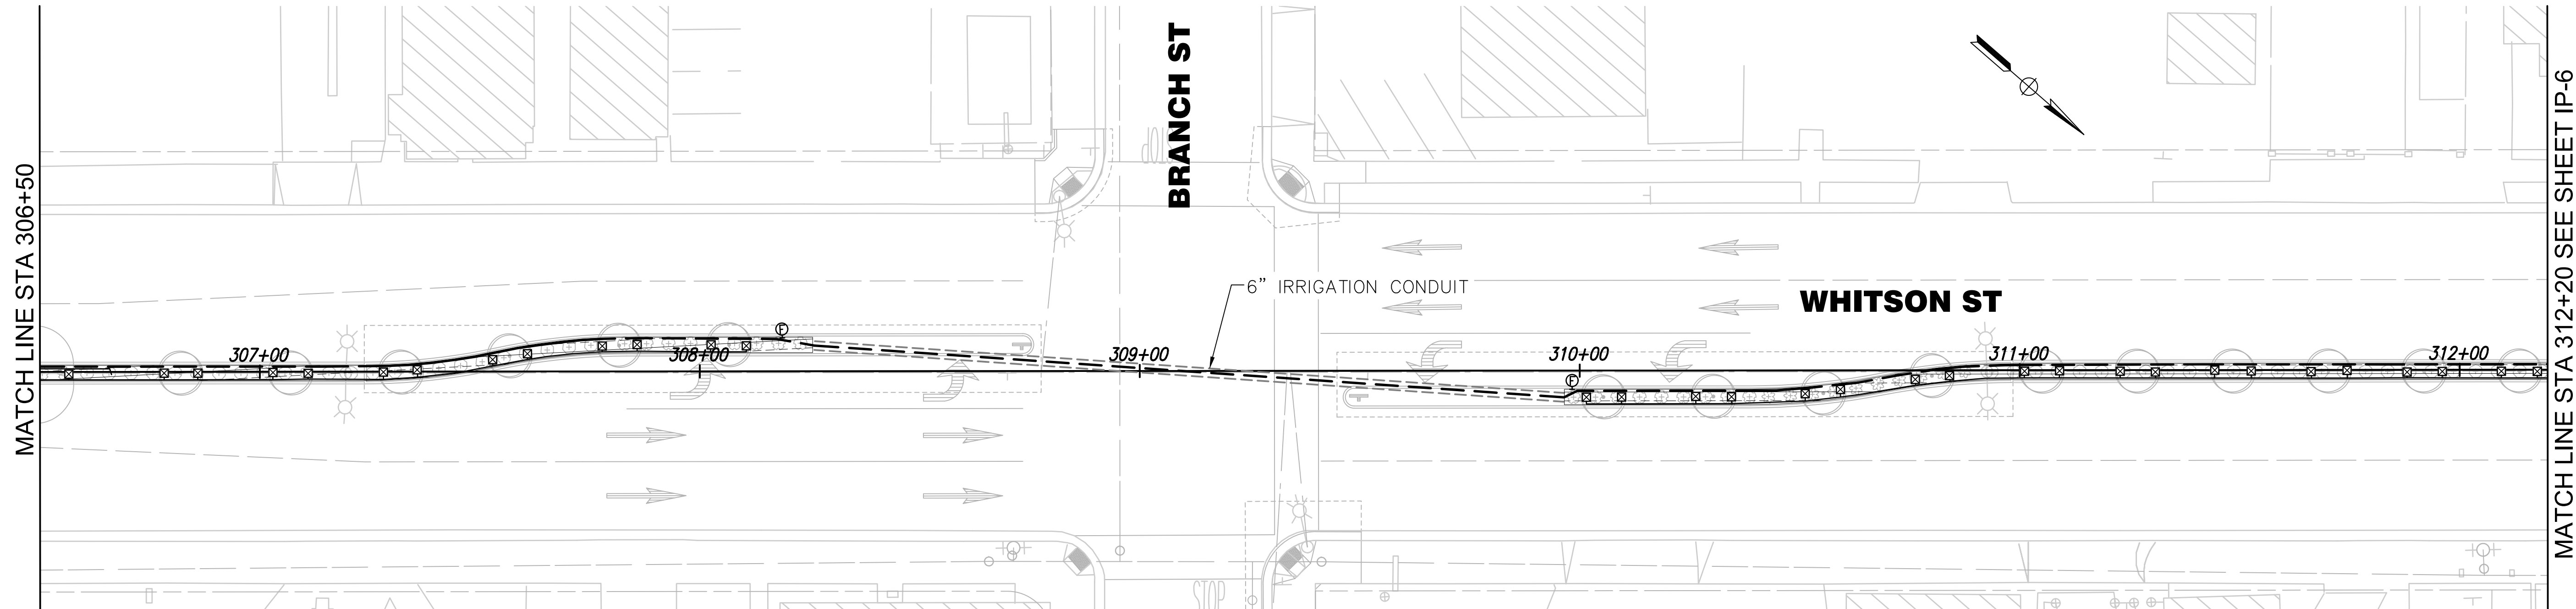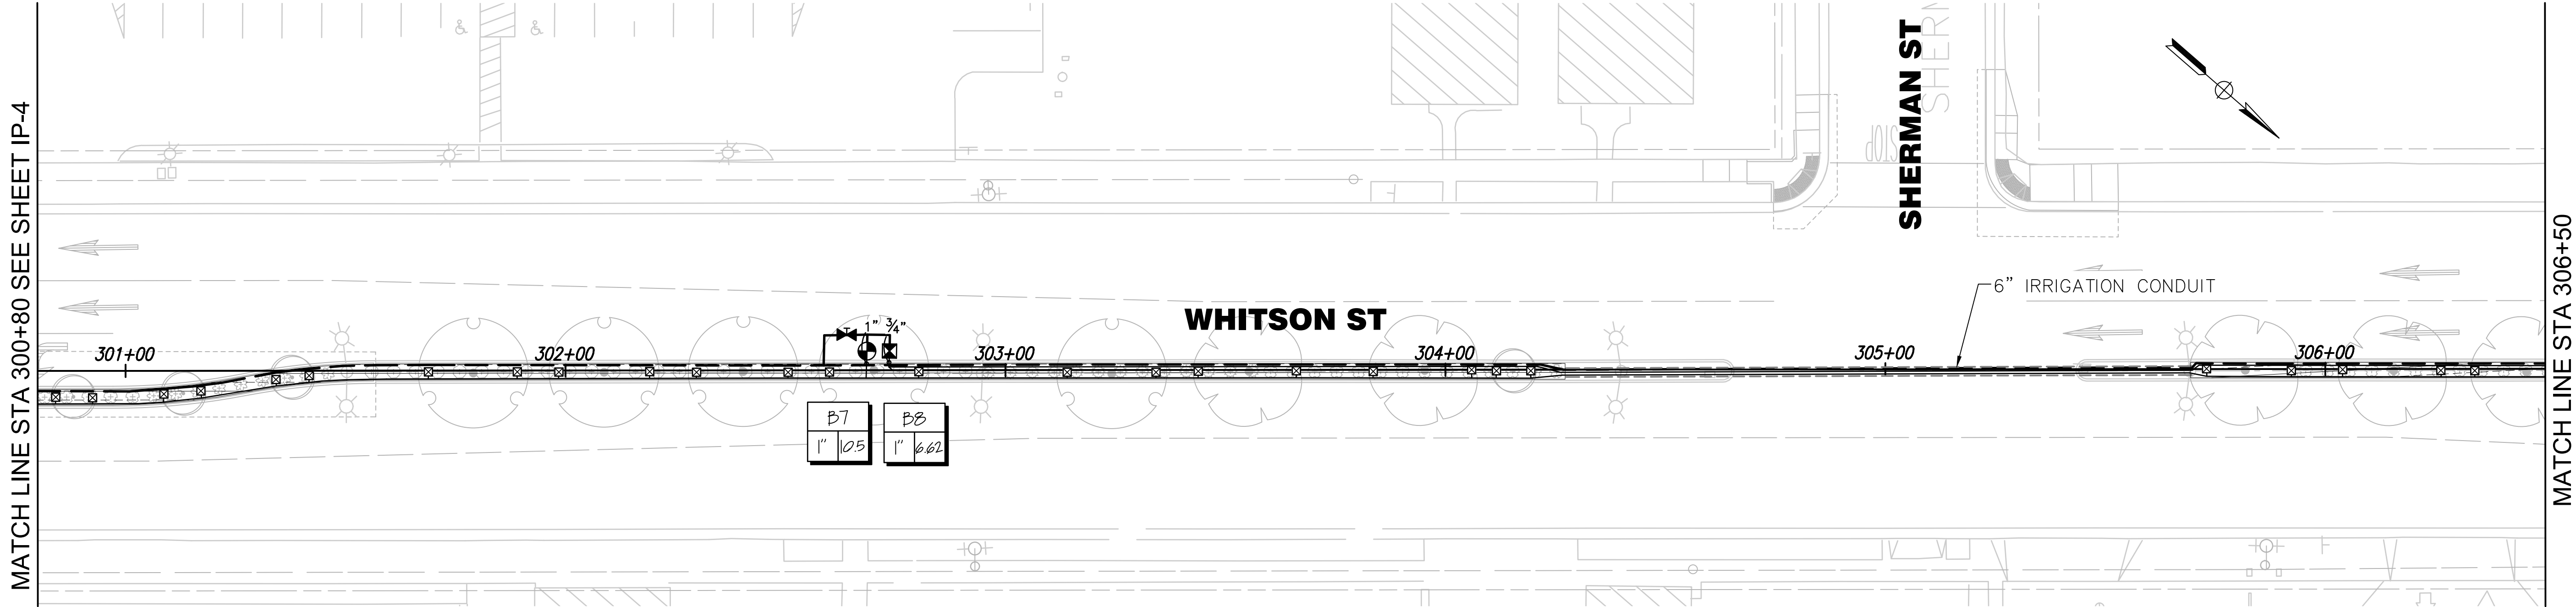

SCALE: 1"=20'-0"

	DATE	RECORD DRAWING	
DESIGNED: PB	12/14/20	RESIDENT ENGINEER	DATE
DRAWN: KJ	12/14/20		
CHECKED: PB	01/19/21		

FOR RIGHT OF WAY DATA AND ACCURATE ACCESS DETERMINATION, SEE DOCUMENTS IN THE DEPARTMENT OF PUBLIC WORKS AND PLANNING.

designlab 252

P.O. Box 27616 Fresno, CA 93729

Studio: 559.472.9966 Fax: 559.472.9969

TENTATIVE

PLANS

SUPERVISING ENGINEER

FOR DESIGN


DATE



PROJECT

GOLDEN STATE BOULEVARD

CITY OF SELMA, CA

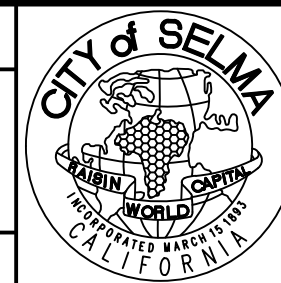


DEPARTMENT OF PUBLIC WORKS AND PLANNING

IRRIGATION PLAN

DRAWING NO. IP-5 SHEET NO. 145 TOTAL 154

PATH: D:\Dropbox (DL252)\DL252 Team Folder\PROJECTS\2015\15-05-006 Golden State\05-CAD\5.01-PLANS\5.01.5-LANDSCAPE PLAN\5.01.5.1-WORKING\LOT DATE: 2/22/2021 5:11:55 PM CAD USER: KONNI
DRAWING: V2\1001\15-05-006\K2\1001P.dwg

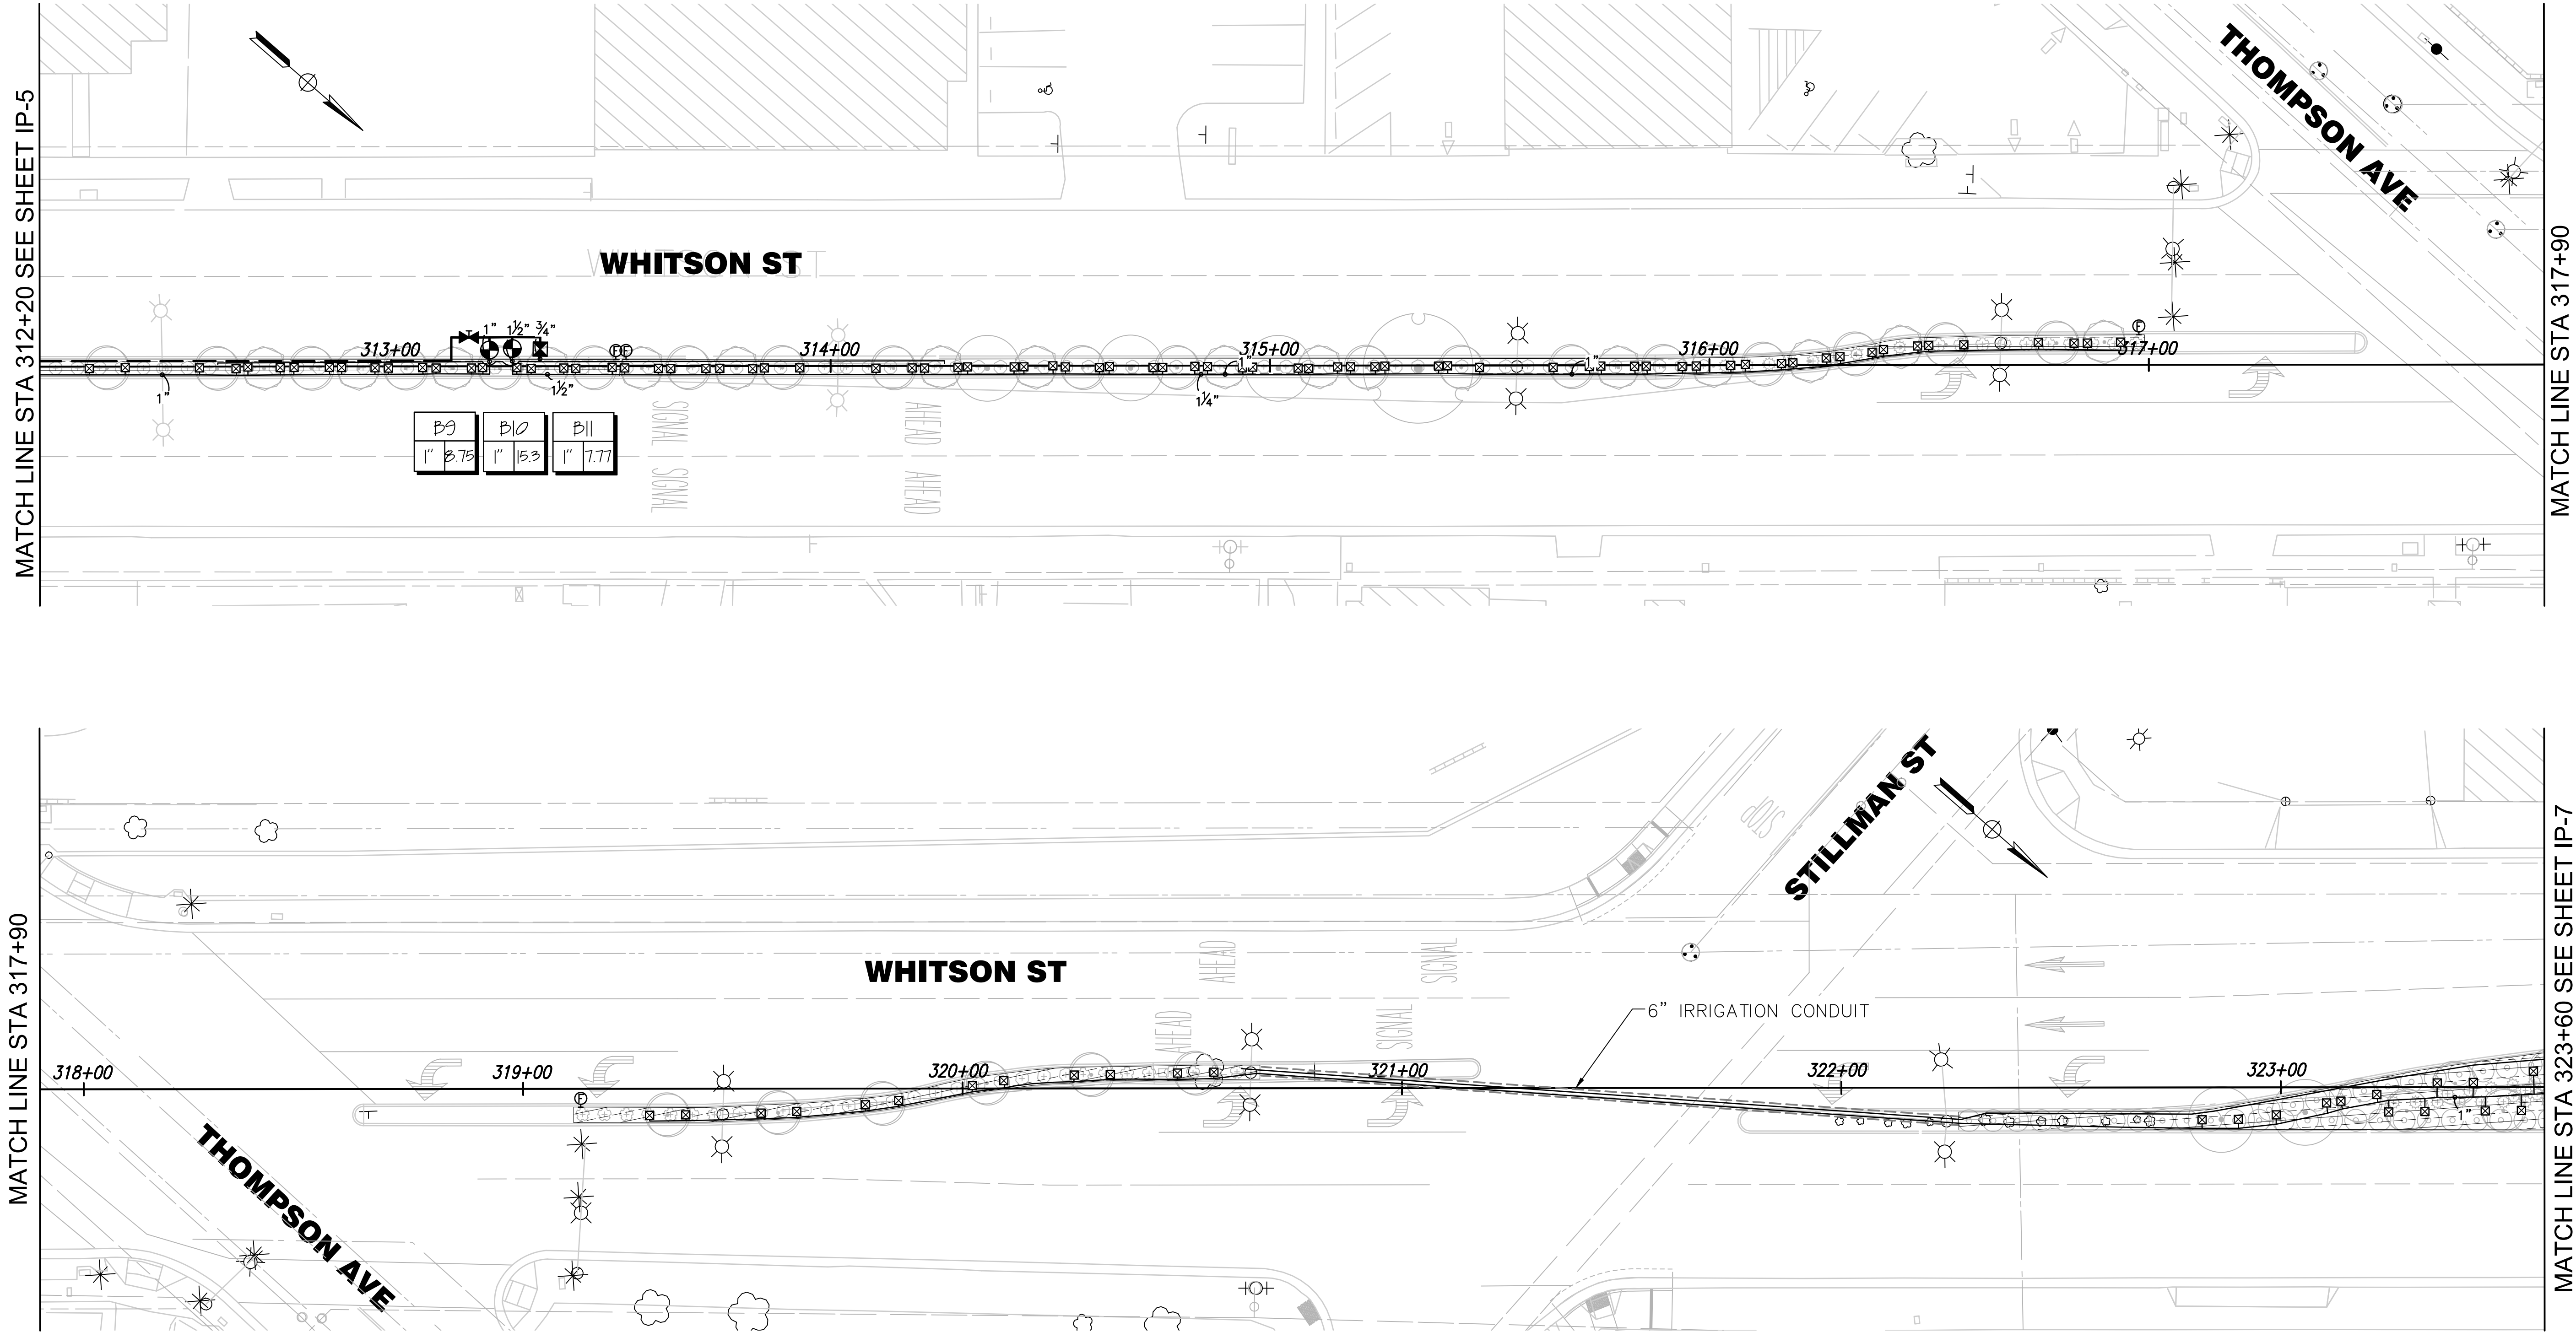

SCALE: 1"=20'-0"

RECORD DRAWING	
DESIGNED: PB	DATE 12/14/20
DRAWN: KJ	DATE 12/14/20
CHECKED: PB	DATE 01/19/21

FOR RIGHT OF WAY DATA AND ACCURATE ACCESS DETERMINATION, SEE DOCUMENTS IN THE DEPARTMENT OF PUBLIC WORKS AND PLANNING.

designlab 252
P.O. Box 27616 Fresno, CA 93729
Studio: 559.472.9966 Fax: 559.472.9969

TENTATIVE PLANS FOR DESIGN
SUPERVISING ENGINEER DATE



PROJECT
GOLDEN STATE BOULEVARD
CITY OF SELMA, CA





DEPARTMENT OF PUBLIC WORKS AND PLANNING

IRRIGATION PLAN

DRAWING NO. IP-6 SHEET NO. 146 TOTAL 154

PATH: D:\Dropbox (DL252)\DL252 Team Folder\PROJECTS\2015\15-05-006 Golden State\05-CAD\5.01-PLANS\5.01-5-LANDSCAPE PLAN\5.01-5.1-WORKING\LOT DATE: 2/22/2021 5:11:59 PM CAD USER: KONNI

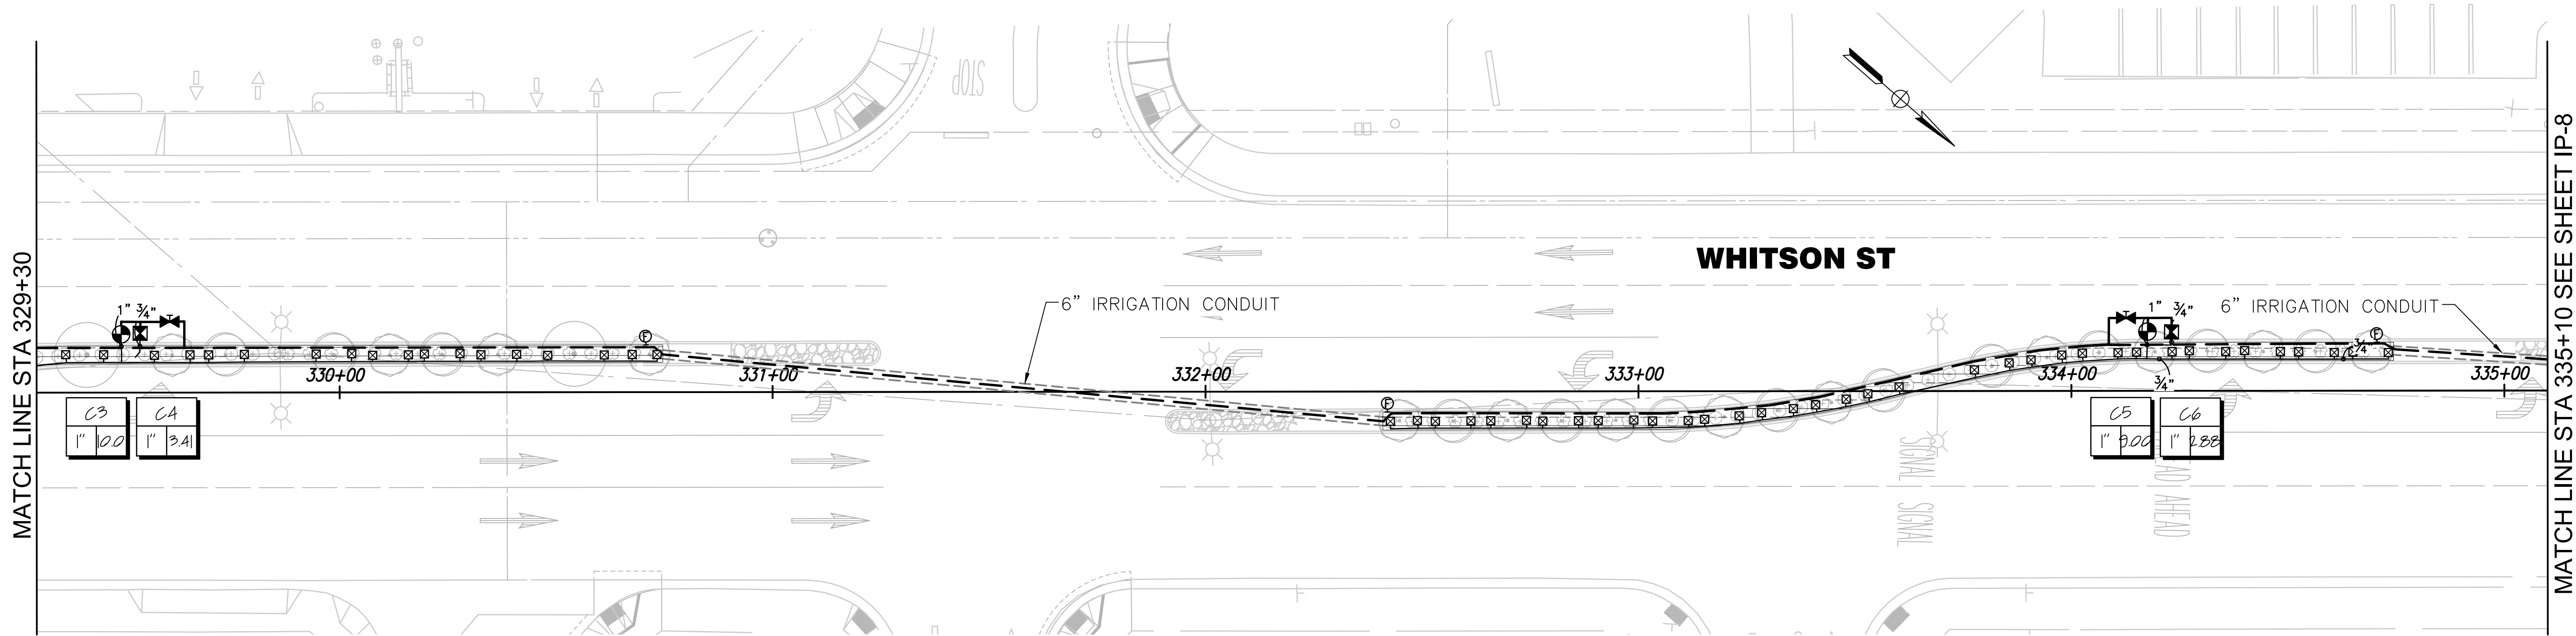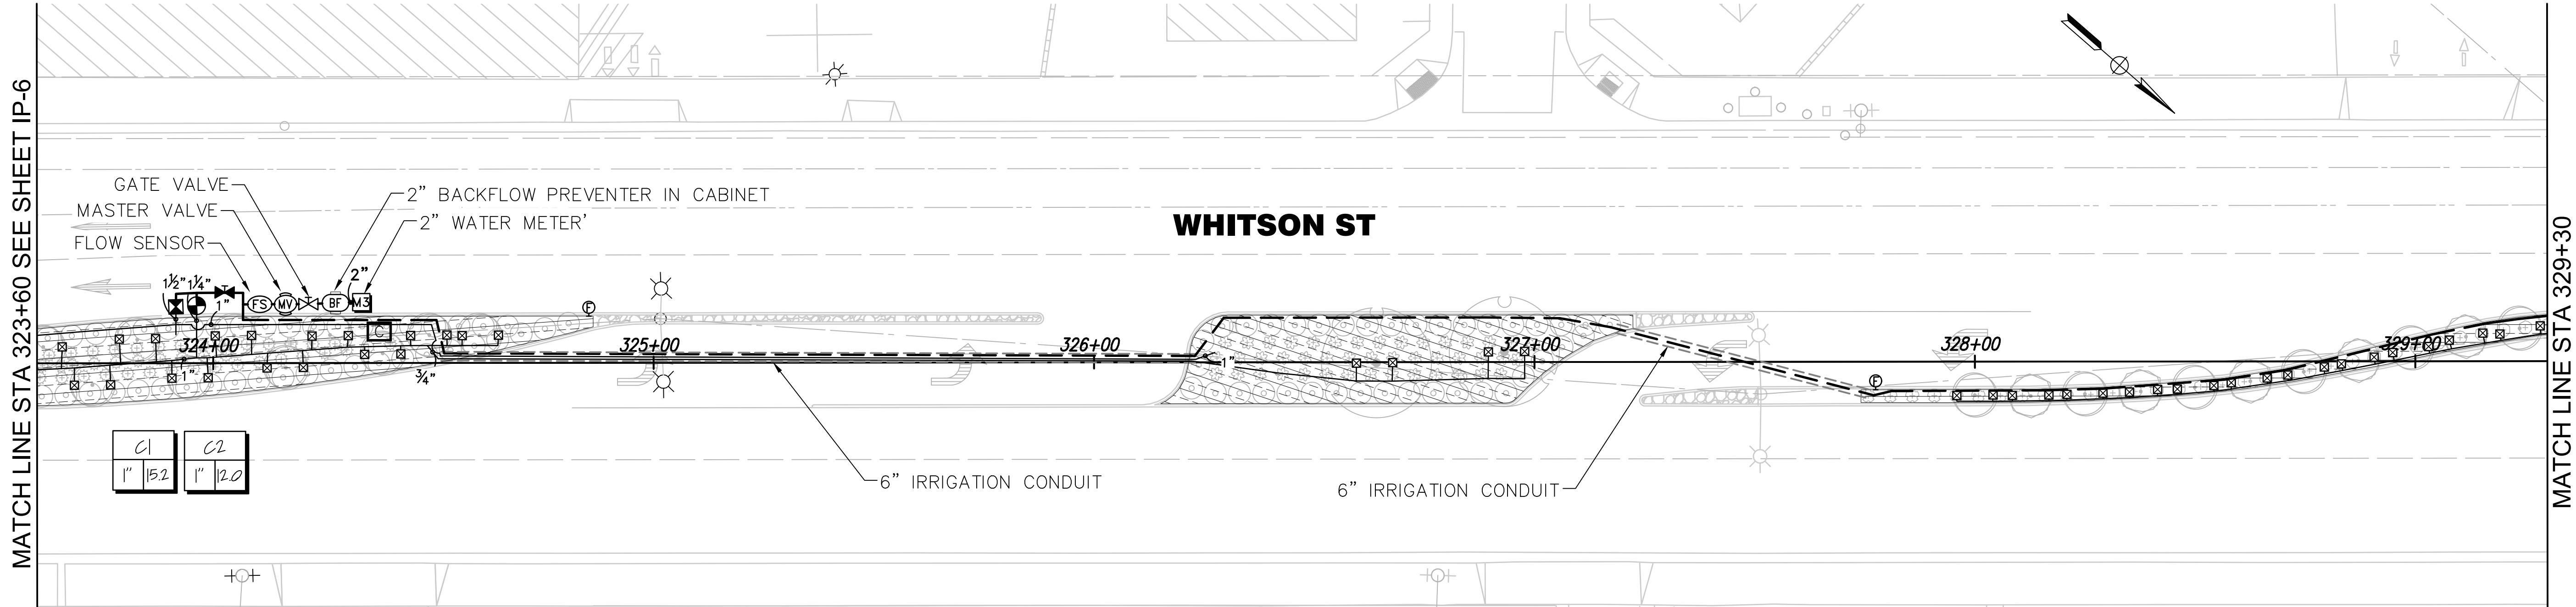

SCALE: 1"=20'-0"

	DATE	RECORD DRAWING	
DESIGNED: PB	12/14/20	RESIDENT ENGINEER	DATE
DRAWN: KJ	12/14/20		
CHECKED: PB	01/19/21		

FOR RIGHT OF WAY DATA AND ACCURATE ACCESS DETERMINATION, SEE DOCUMENTS IN THE DEPARTMENT OF PUBLIC WORKS AND PLANNING.


designlab 252

P.O. Box 27616 Fresno, CA 93729

Studio: 559.472.9966 Fax: 559.472.9969

TENTATIVE PLANS FOR DESIGN


SUPERVISING ENGINEER DATE

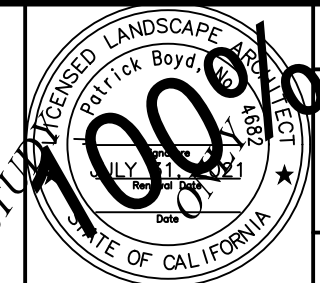

PROJECT

GOLDEN STATE BOULEVARD

CITY OF SELMA, CA

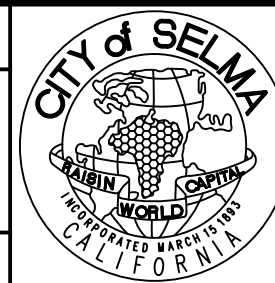


DEPARTMENT OF PUBLIC WORKS AND PLANNING

IRRIGATION PLAN

DRAWING NO. IP-7 SHEET NO. 147 TOTAL 154

PATH: D:\Projects\DL252\Term Folder\Projects\2015\15-05-006 Golden State\05-CAD\5.01-PLANS\5.01.5-LANDSCAPE PLAN\5.01.5.1-WORKING\LOT DATE: 2/22/2021 5:12:04 PM CAD USER: KONNI
DRAWING: V2\1001\15-05-006R2\1001P.dwg

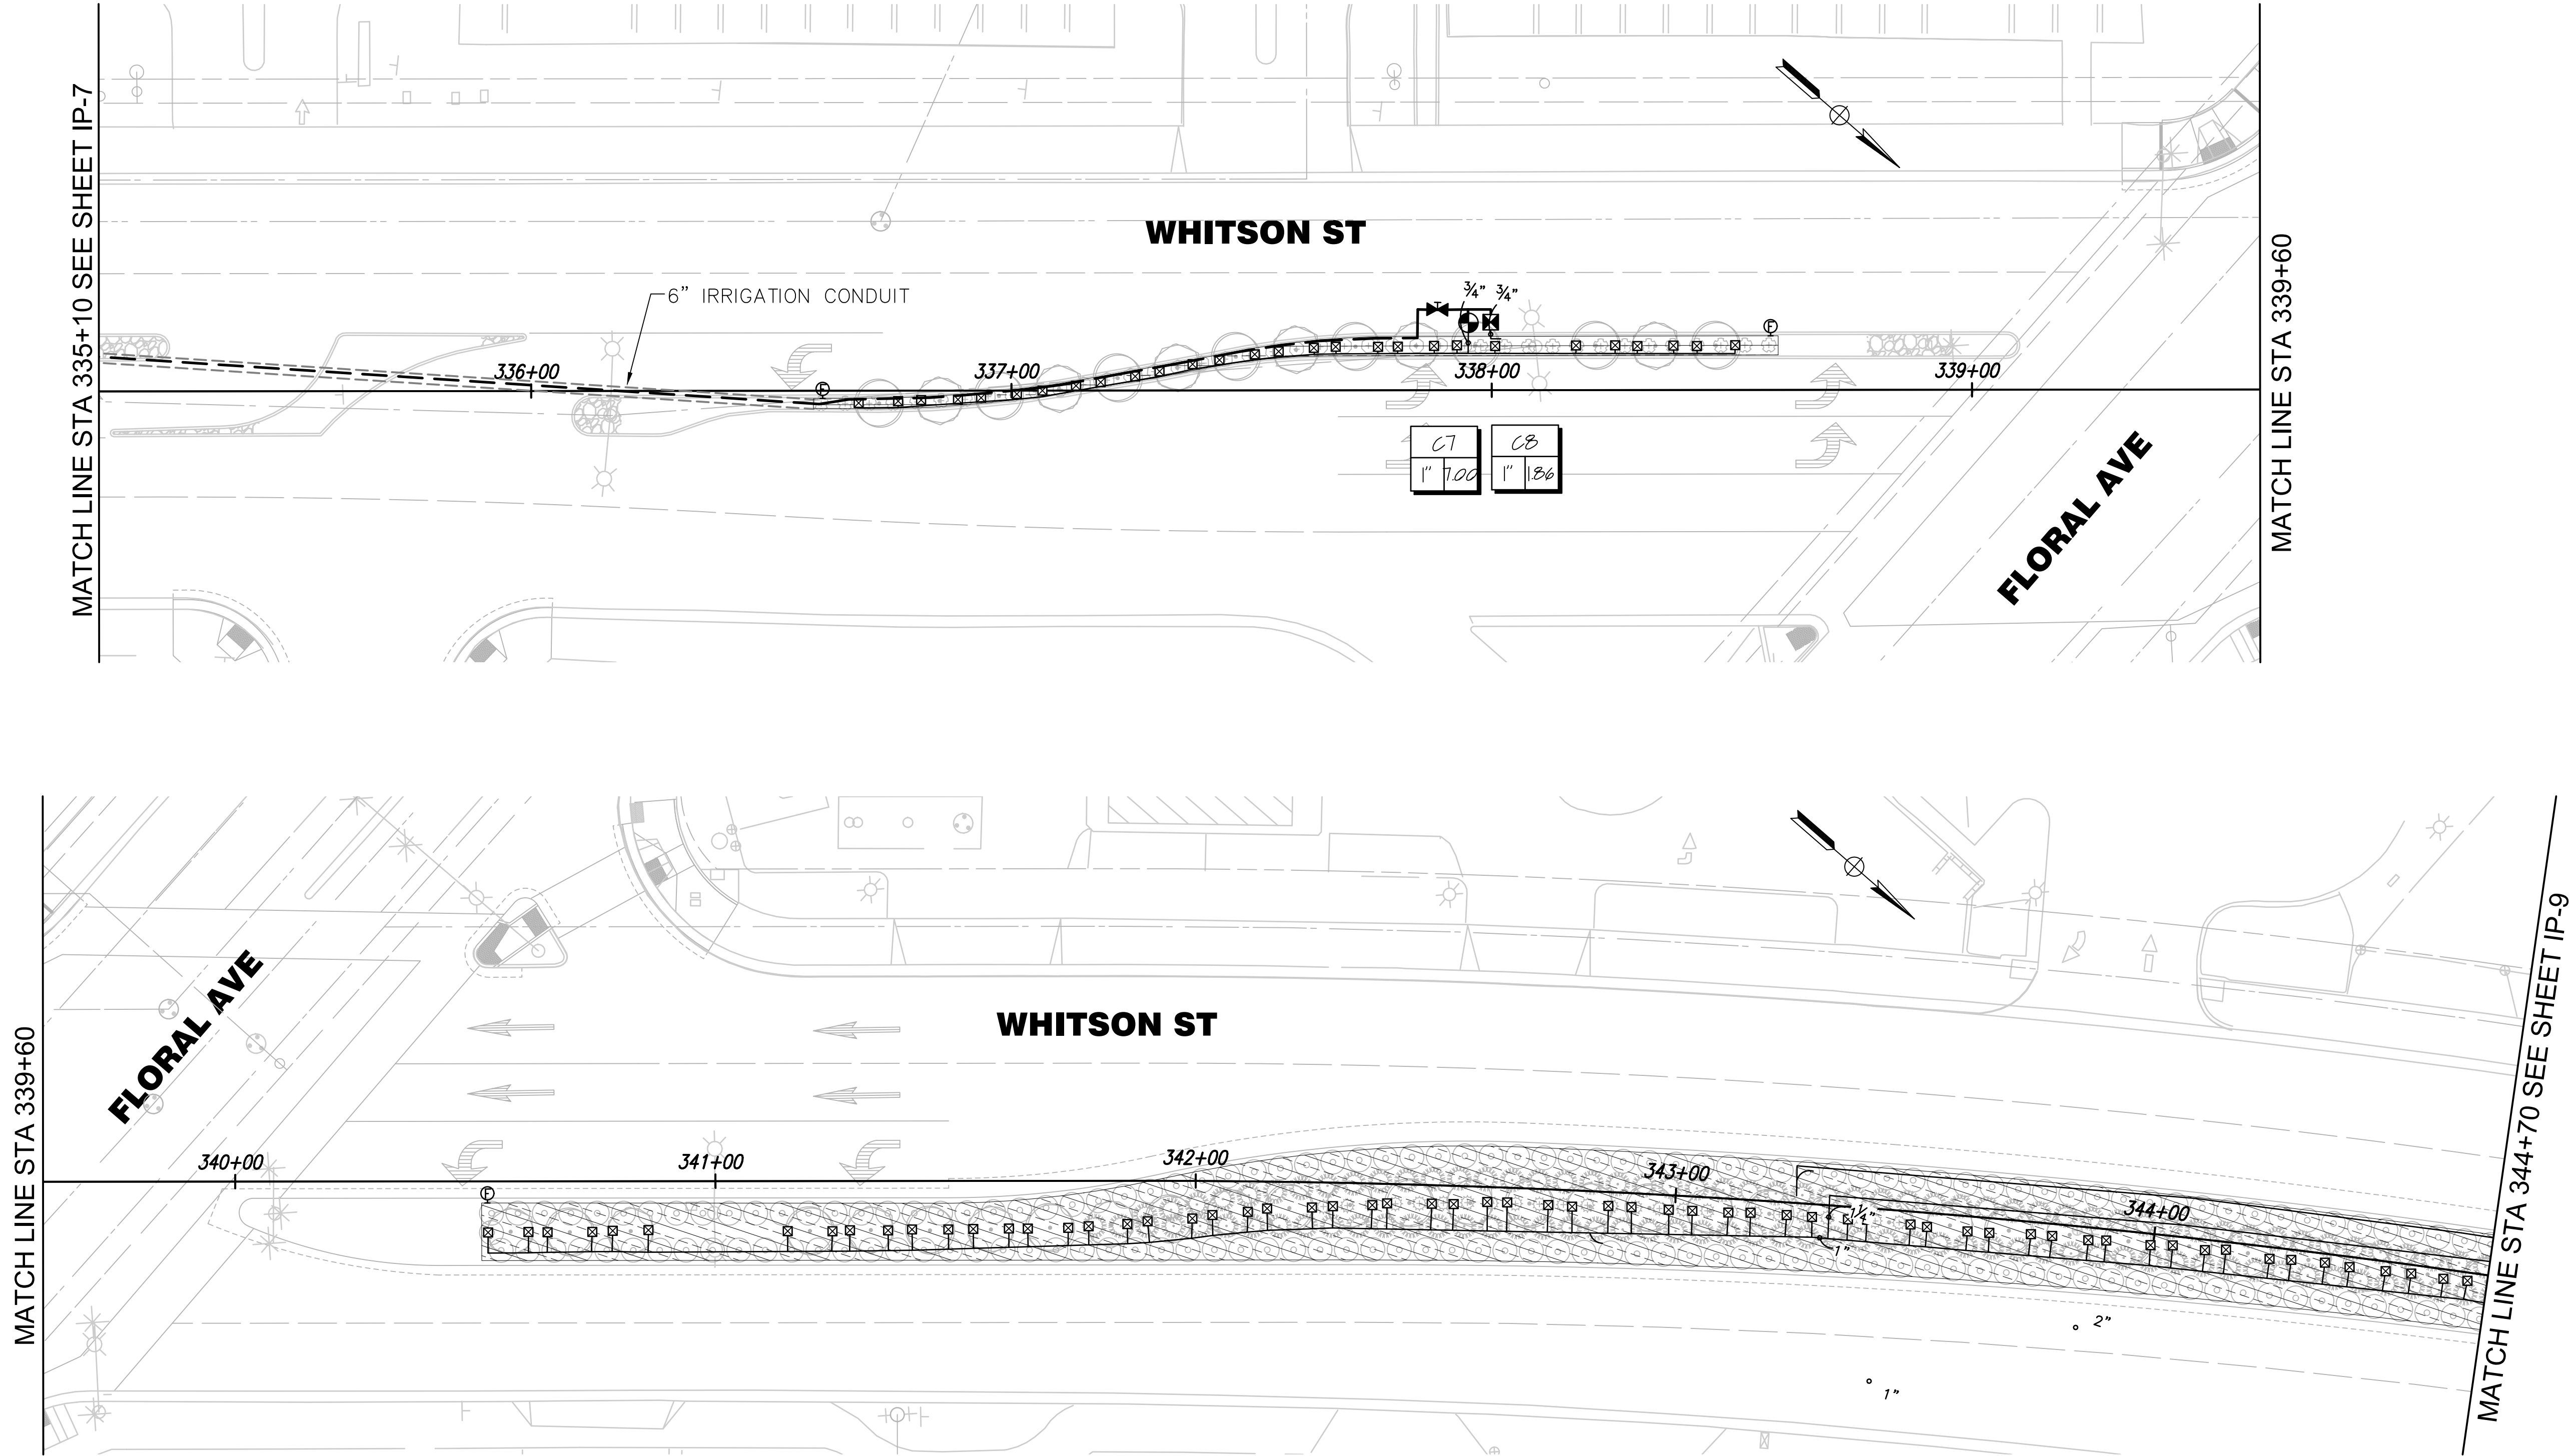

SCALE: 1"=20'-0"

RECORD DRAWING	
DESIGNED: PB	DATE 12/14/20
DRAWN: KJ	DATE 12/14/20
CHECKED: PB	DATE 01/19/21

FOR RIGHT OF WAY DATA AND ACCURATE ACCESS DETERMINATION, SEE DOCUMENTS IN THE DEPARTMENT OF PUBLIC WORKS AND PLANNING.

designlab 252

P.O. Box 27616 Fresno, CA 93729
Studio: 559.472.9966 Fax: 559.472.9969

TENTATIVE PLANS FOR DESIGN
SUPERVISING ENGINEER DATE



 
PROJECT
GOLDEN STATE BOULEVARD
CITY OF SELMA, CA



DEPARTMENT OF PUBLIC WORKS AND PLANNING


IRRIGATION PLAN

DRAWING NO. IP-8 SHEET NO. 148 TOTAL 154



		DATE	RECORD DRAWING		des:gnlab 252		PROJECT		CITY OF SELMA		DEPARTMENT OF PUBLIC WORKS AND PLANNING	
DESIGNED: PB		12/14/20	RESIDENT ENGINEER		P.O. Box 27616 Fresno, CA 93729		GOLDEN STATE BOULEVARD		CITY OF SELMA, CA		IRRIGATION PLAN	
DRAWN: KJ		12/14/20			Studio: 559.472.9966 Fax: 559.472.9969						DRAWING NO. IP-9	
CHECKED: PB		01/19/21									SHEET NO. 149	
FOR RIGHT OF WAY DATA AND ACCURATE ACCESS DETERMINATION, SEE DOCUMENTS IN THE DEPARTMENT OF PUBLIC WORKS AND PLANNING.											TOTAL 154	

PATH: D:\Dropbox\DL252\DL252 Team Folder\PROJECTS\2015\15-05-006 Golden State\05-CAD\15.01-PLANS\15.01-5-LANDSCAPE PLAN\15.01-5.1-WORKING\LOT DATE: 2/22/2021 5:12:09 PM CAD USER: KONNI

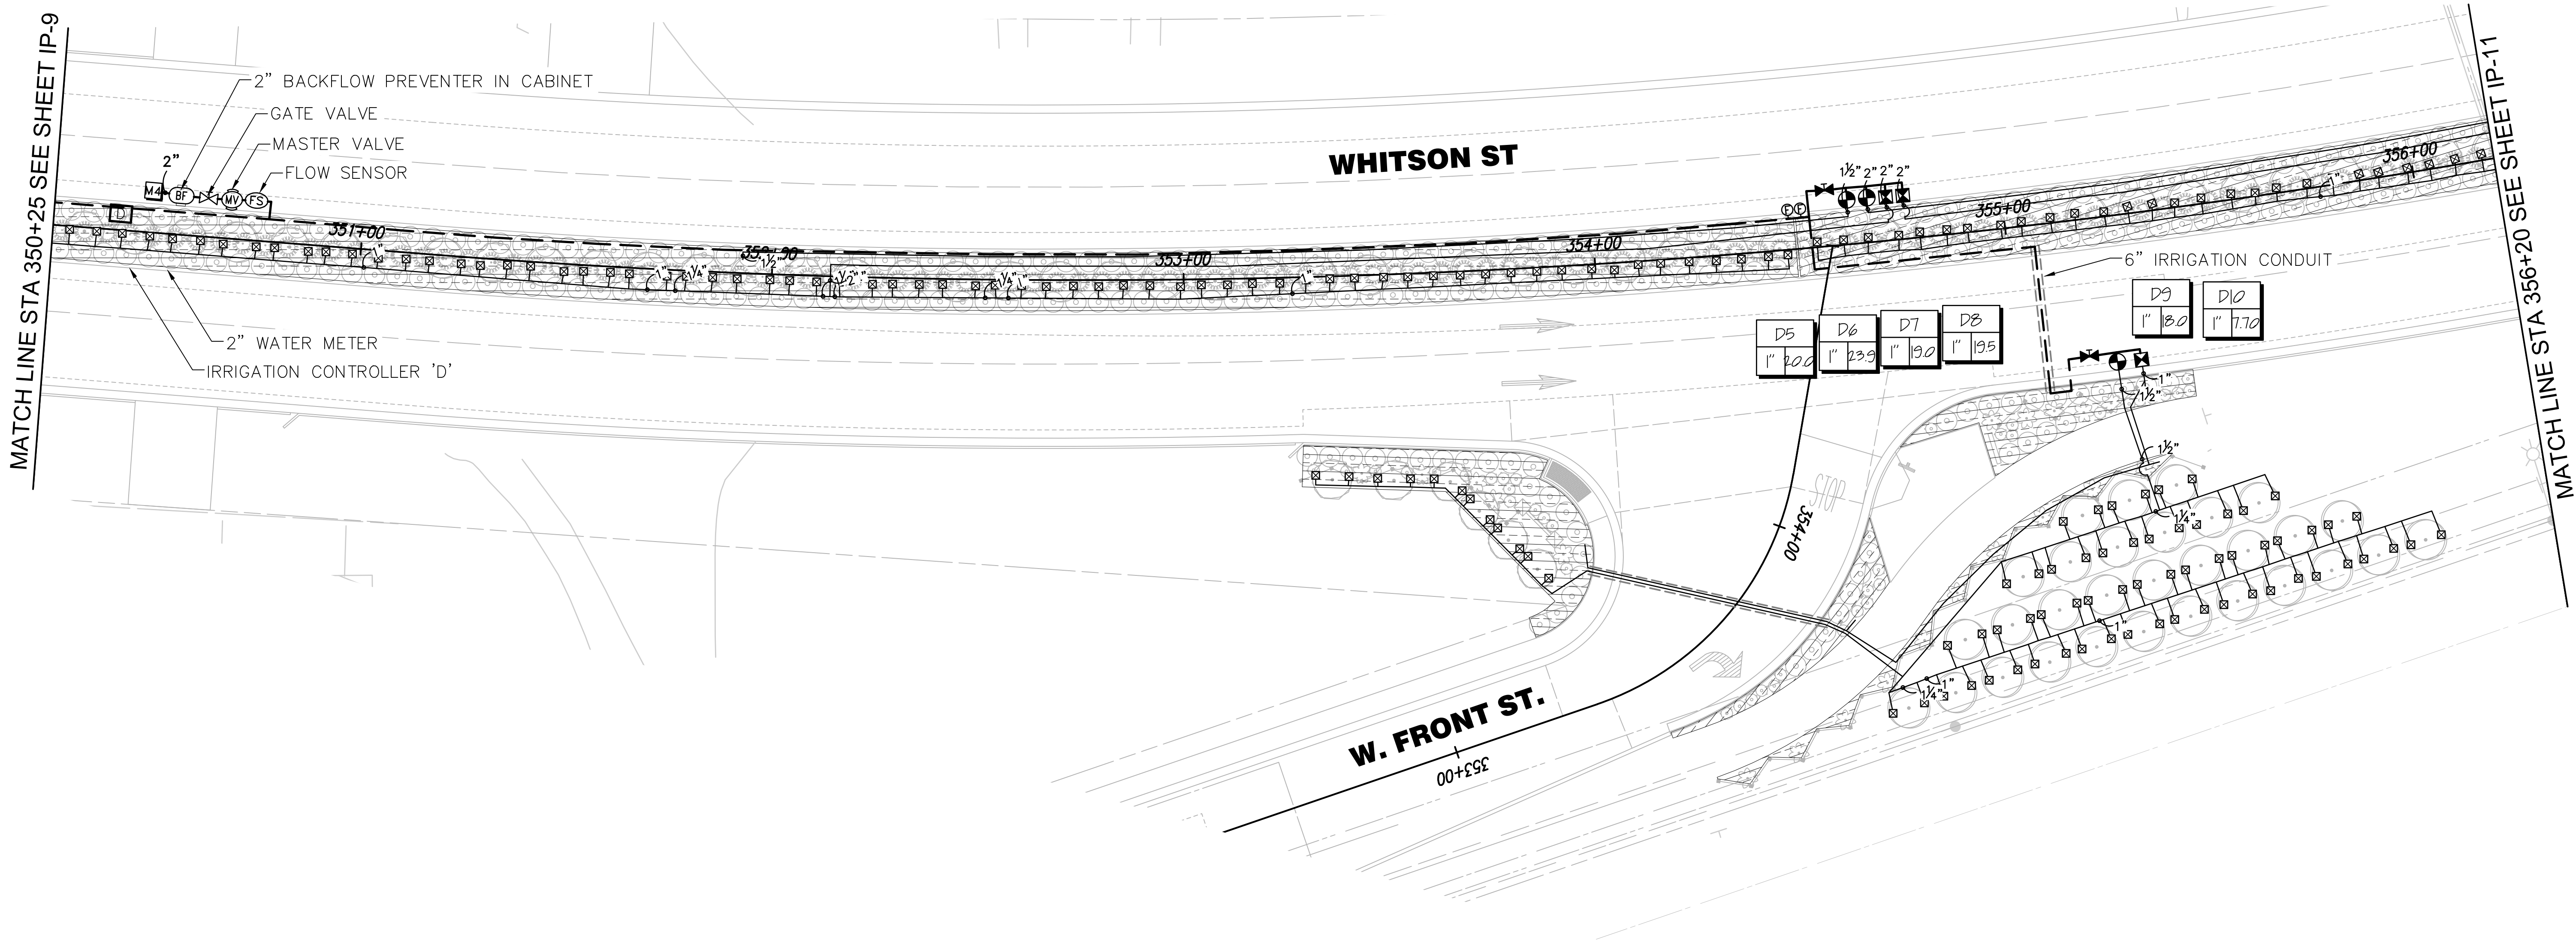

SCALE: 1"=20'-0"

RECORD DRAWING	
DESIGNED: PB	DATE 12/14/20
DRAWN: KJ	DATE 12/14/20
CHECKED: PB	DATE 01/19/21

FOR RIGHT OF WAY DATA AND ACCURATE ACCESS DETERMINATION, SEE DOCUMENTS IN THE DEPARTMENT OF PUBLIC WORKS AND PLANNING.

designlab252

P.O. Box 27616 Fresno, CA 93729
Studio: 559.472.9966 Fax: 559.472.9969

TENTATIVE PLANS FOR DESIGN

SUPERVISING ENGINEER DATE

STUDY

100%

STATE OF CALIFORNIA

PROJECT

GOLDEN STATE BOULEVARD
CITY OF SELMA, CA




DEPARTMENT OF PUBLIC WORKS AND PLANNING

IRRIGATION PLAN

DRAWING NO. IP-9 SHEET NO. 150 TOTAL 154

PATH: D:\Dropbox\DL252\Team Folder\PROJECTS\2015\15-05-006 Golden State\05-CAD\5.01-PLANS\5.01-5-LANDSCAPE PLAN\5.01.5.1-WORKING\LOT DATE: 2/22/2021 5:12:11 PM CAD USER: KONNI
DRAWING: V2\1001\15-05-006R2_1001P.dwg

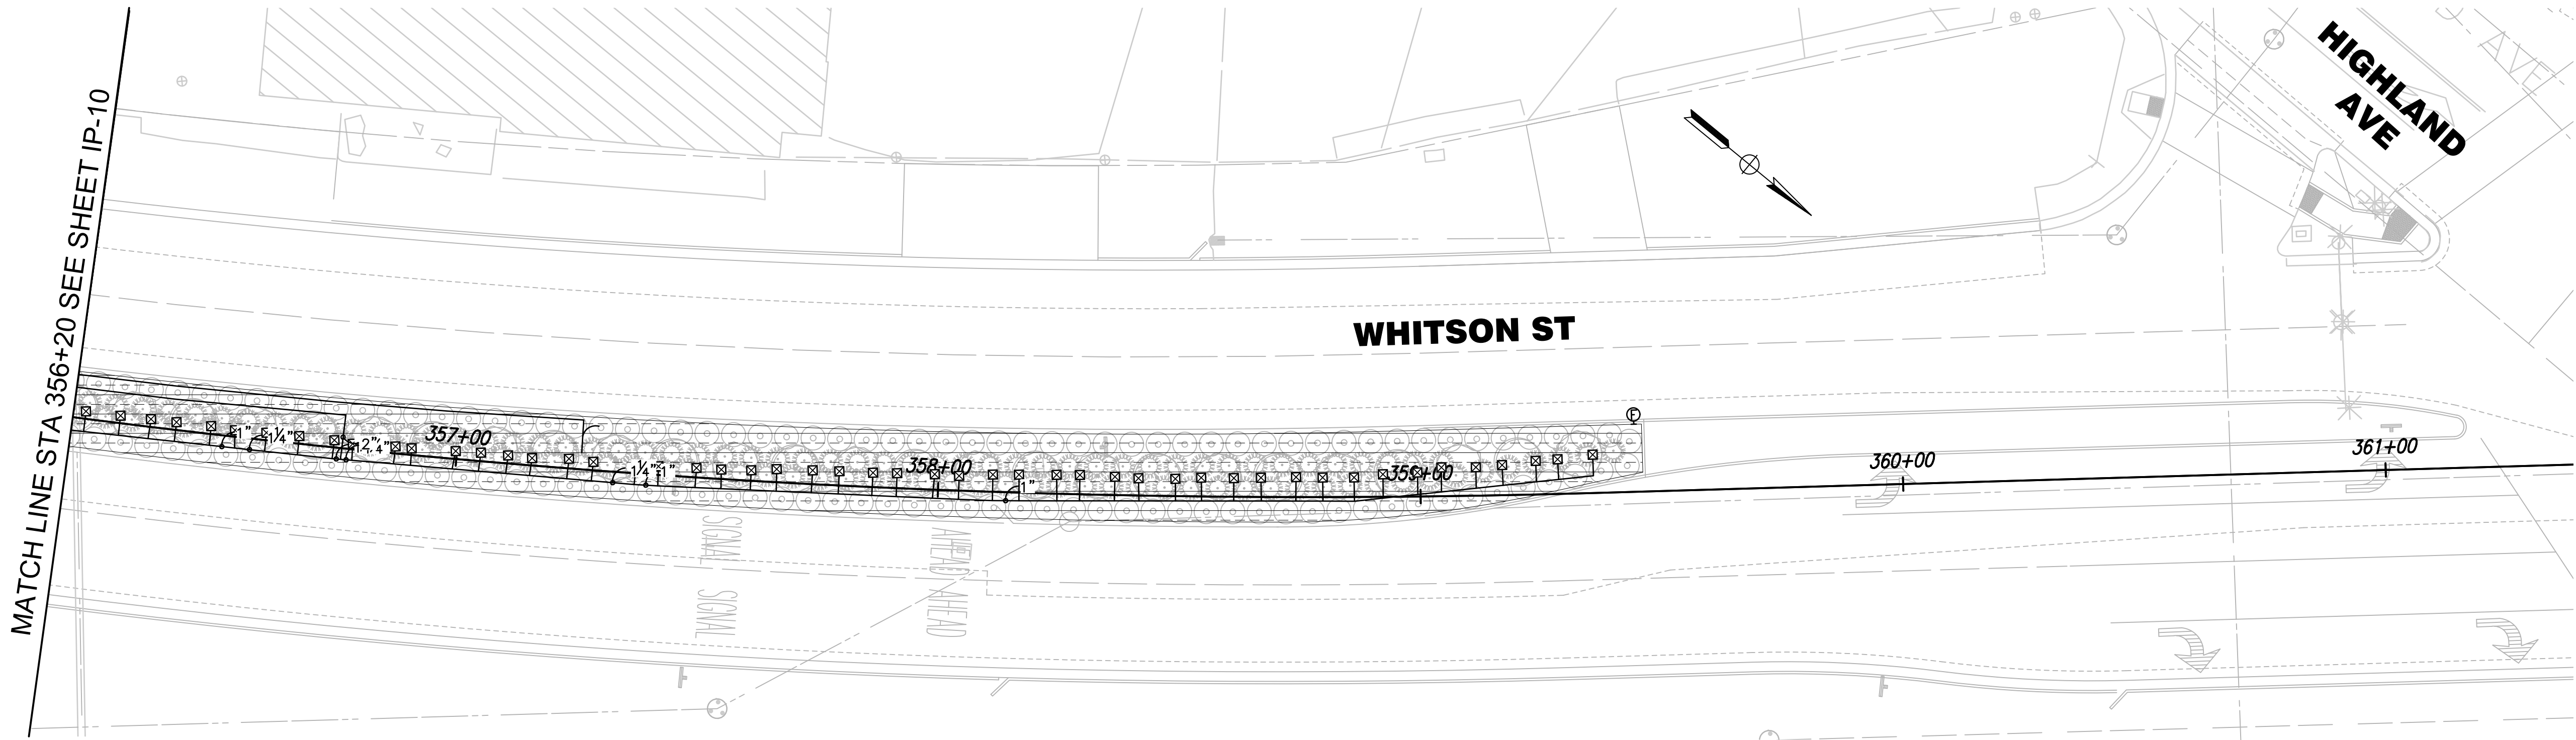

SCALE: 1"=20'-0"

RECORD DRAWING	
DESIGNED: PB	12/14/20
DRAWN: KJ	12/14/20
CHECKED: PB	01/19/21

des:gnlab 252
P.O. Box 27616 Fresno, CA 93729
Studio: 559.472.9966 Fax: 559.472.9969


TENTATIVE PLANS FOR DESIGN
SUPERVISING ENGINEER DATE



PROJECT
GOLDEN STATE BOULEVARD
CITY OF SELMA, CA




DEPARTMENT OF PUBLIC WORKS AND PLANNING		
IRRIGATION PLAN		
DRAWING NO. IP-11	SHEET NO. 151	TOTAL 154

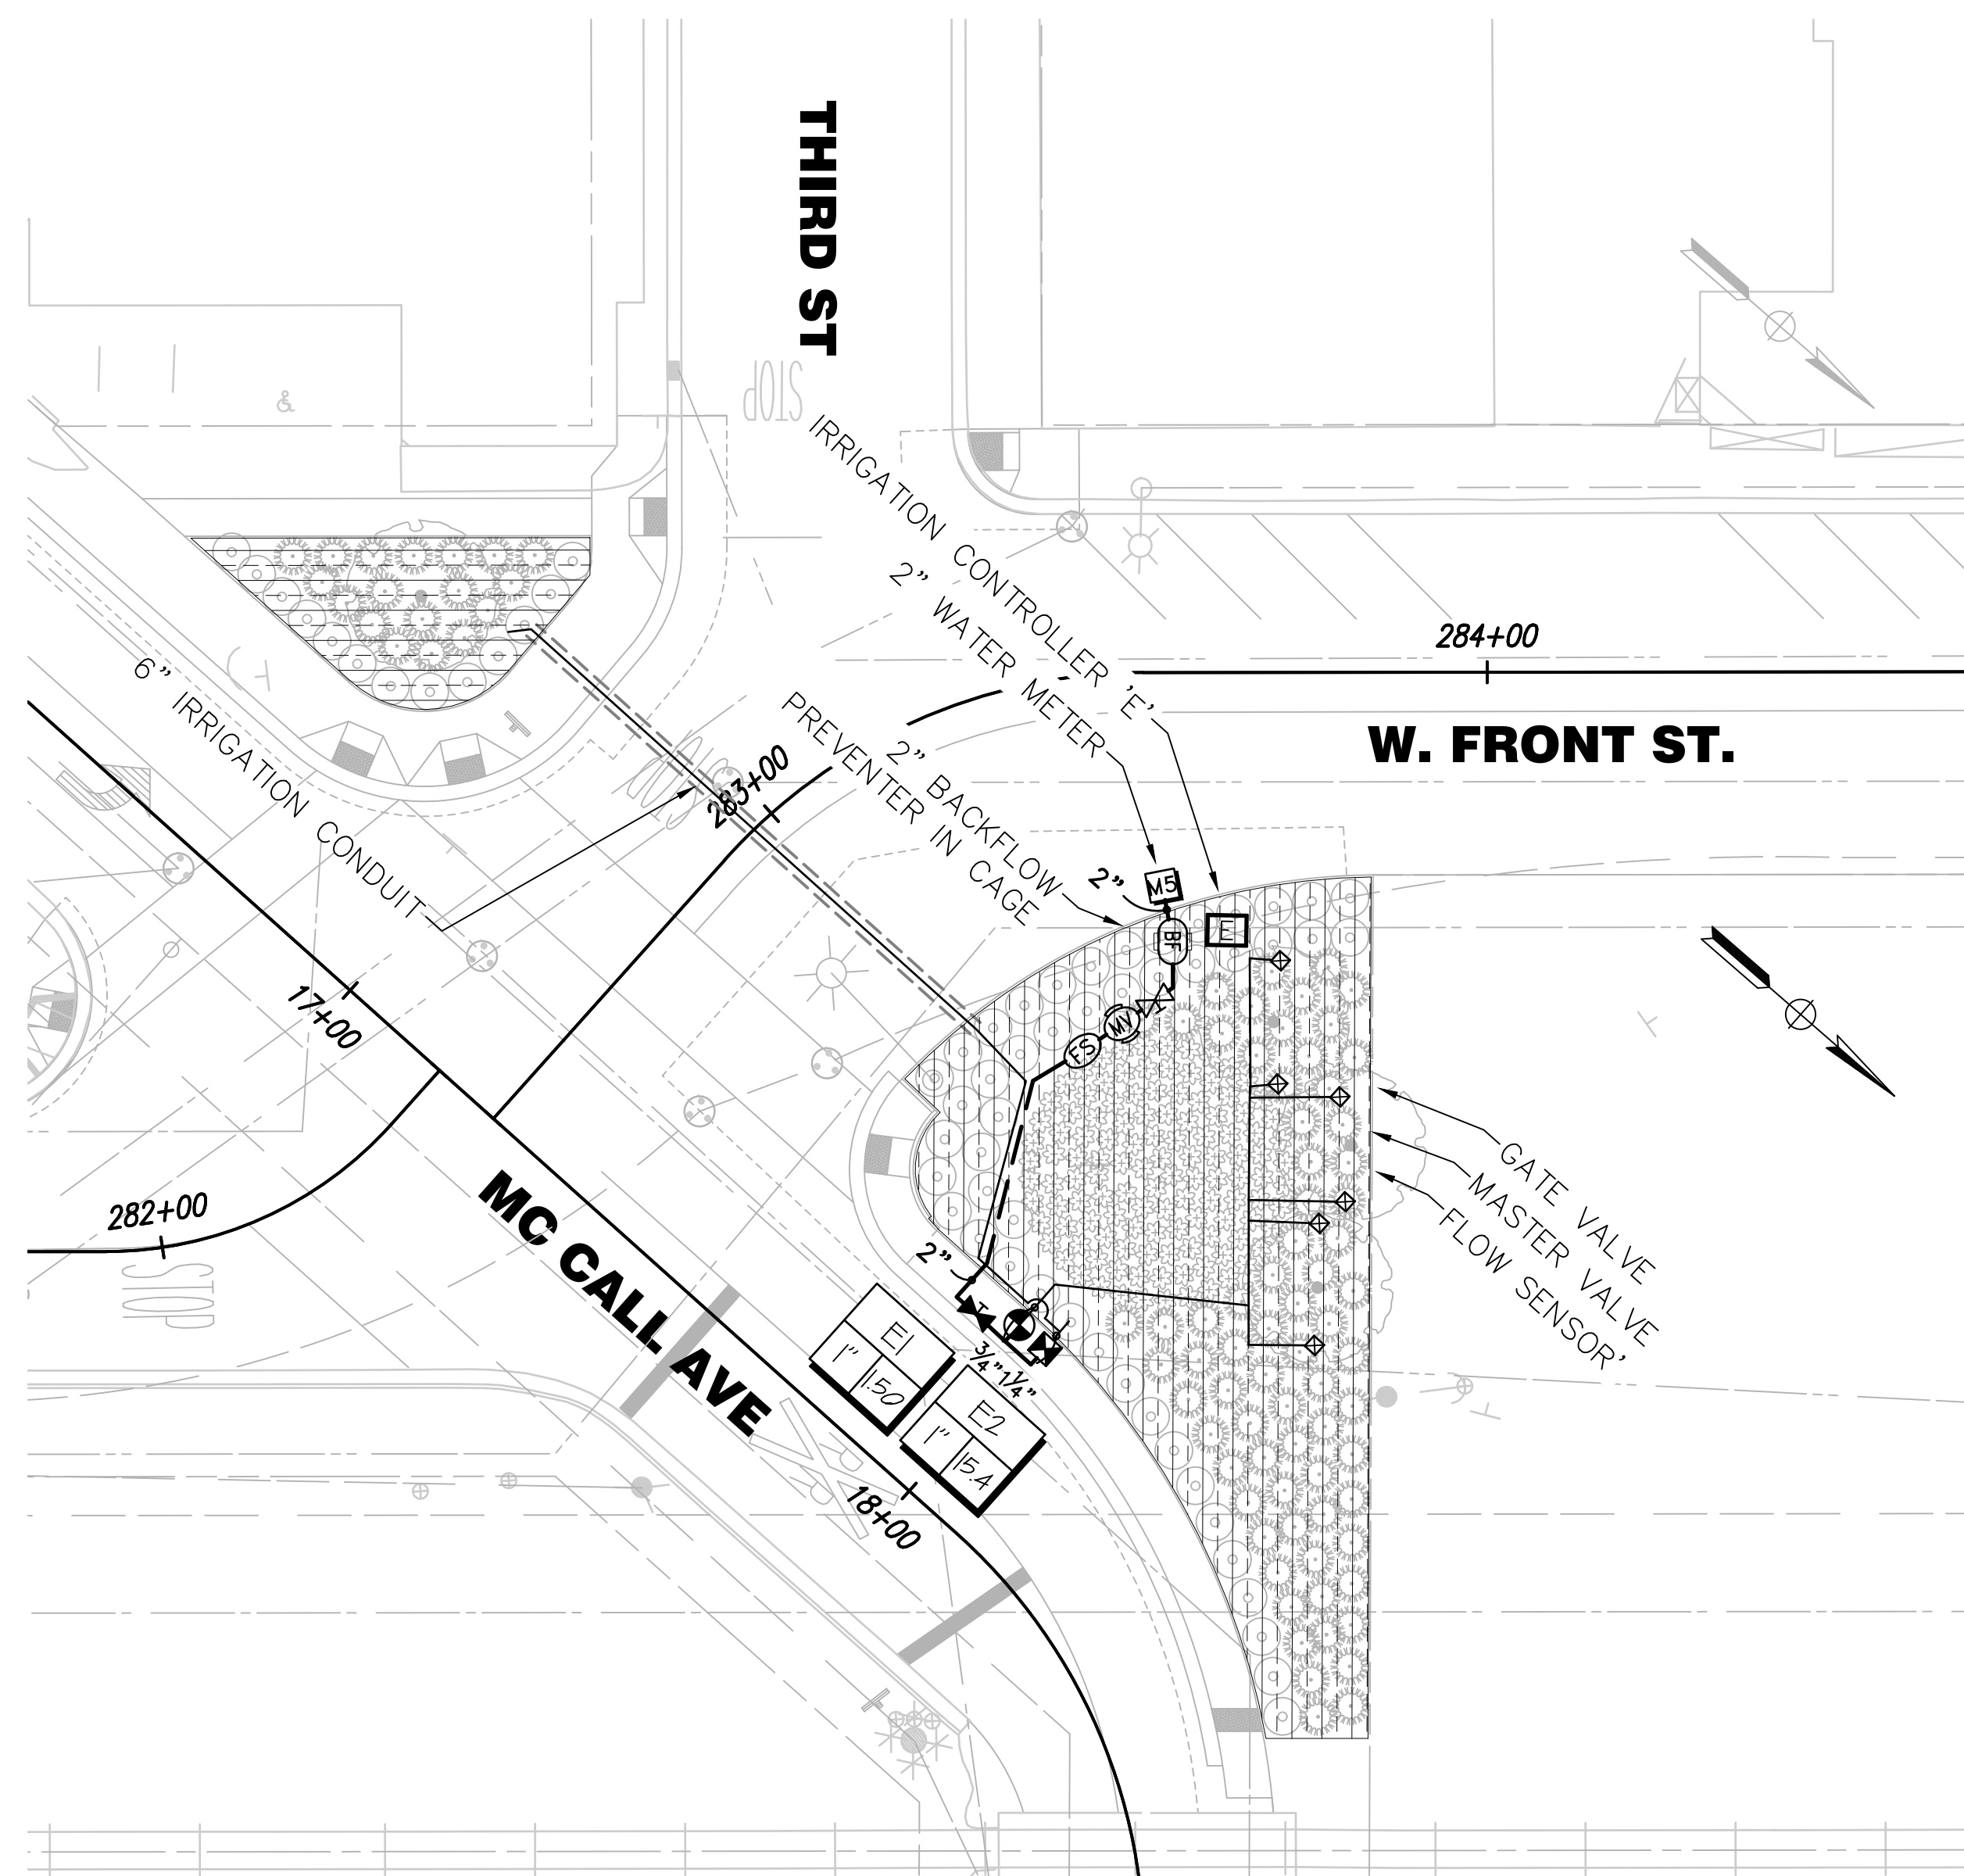


SCALE: 1"=20'-0"

		DATE	RECORD DRAWING		des:gnlab 252 P.O. Box 27616 Fresno, CA 93729 Studio: 559.472.9966 Fax: 559.472.9969	TENTATIVE SUPERVISING ENGINEER DATE	PROFESSIONAL LANDSCAPE ARCHITECT Erik Boyd No. 50869 STATE OF CALIFORNIA 100%	PROJECT		CITY OF SELMA SEAL OFFICE OF THE CITY CLERK SELMA, CALIFORNIA	DEPARTMENT OF PUBLIC WORKS AND PLANNING	
DESIGNED: PB		12/14/20	RESIDENT ENGINEER	DATE				GOLDEN STATE BOULEVARD			IRRIGATION PLAN	
DRAWN: KJ		12/14/20						CITY OF SELMA, CA				
CHECKED: PB		01/19/21										
FOR RIGHT OF WAY DATA AND ACCURATE ACCESS DETERMINATION, SEE DOCUMENTS IN THE DEPARTMENT OF PUBLIC WORKS AND PLANNING.												


PATH: D:\projects\DL252\Drawings\05-05-006 Golden State\05-CAD\05.01-PLANS\05.01.5-LANDSCAPE PLAN\05.01.5.1-WORKING\LOT DATE: 2/22/2021 5:12:14 PM CAD USER: KONNI

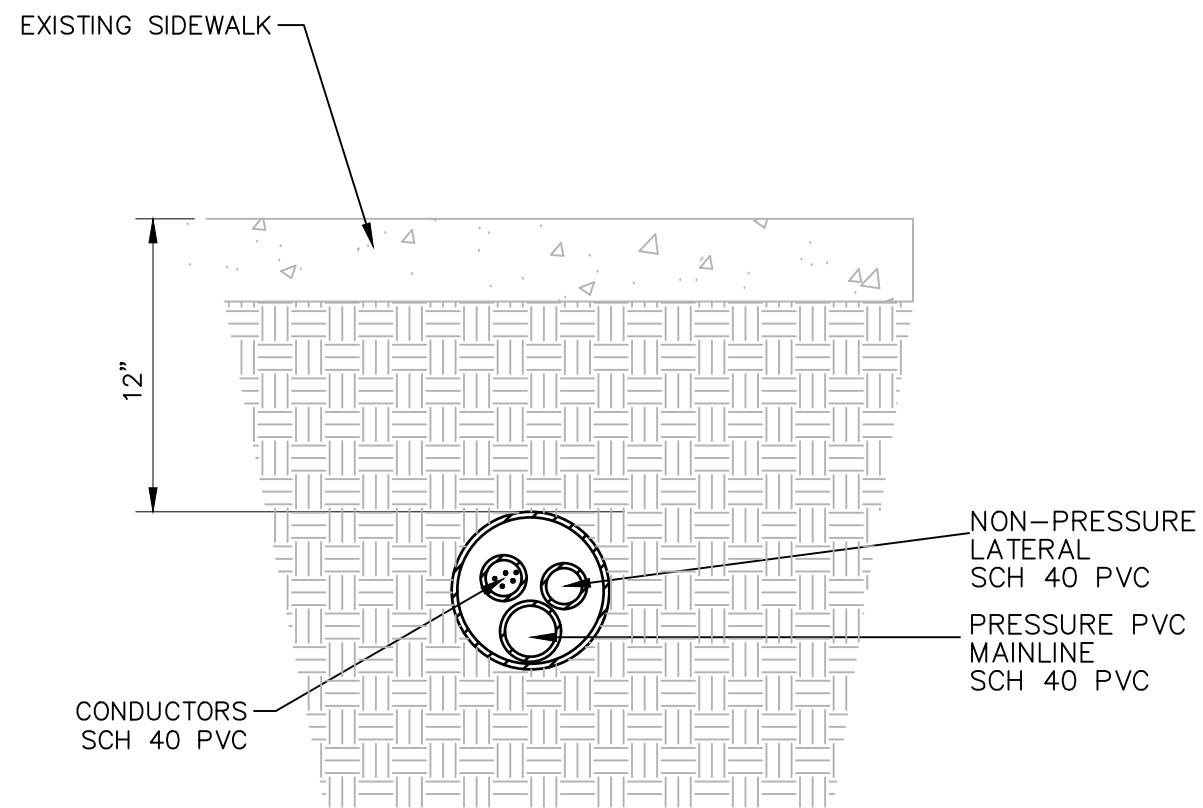


1 IRRIGATION SLEEVE - BORE
1 1/2" = 1'-0" DL-IR-PIP-03

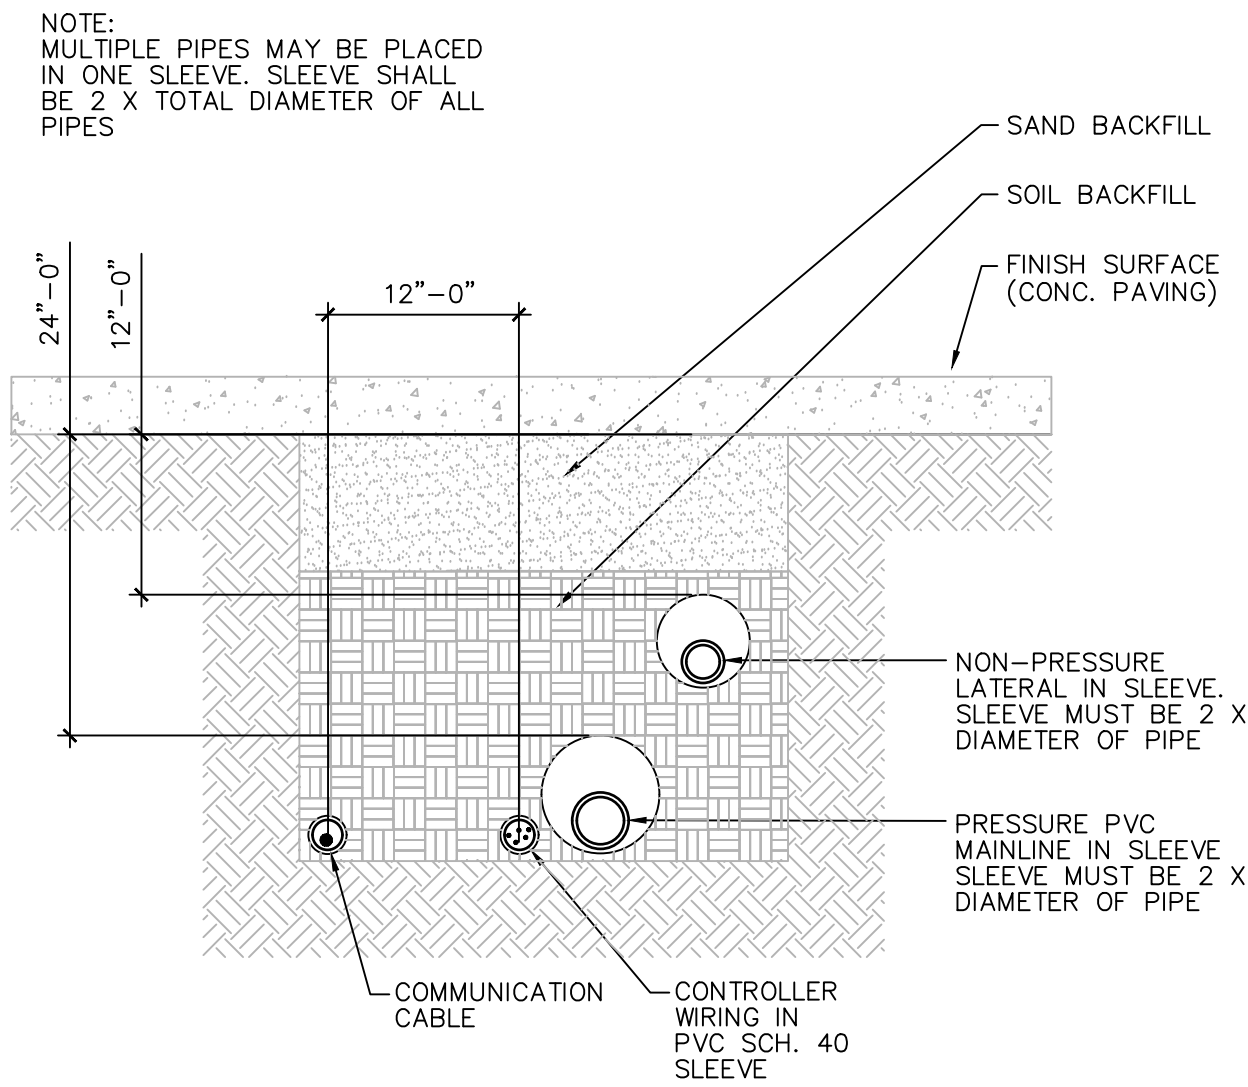


2 IRRIGATION SLEEVE - TRENCH
1" = 1'-0" DL-IR-PIP-05

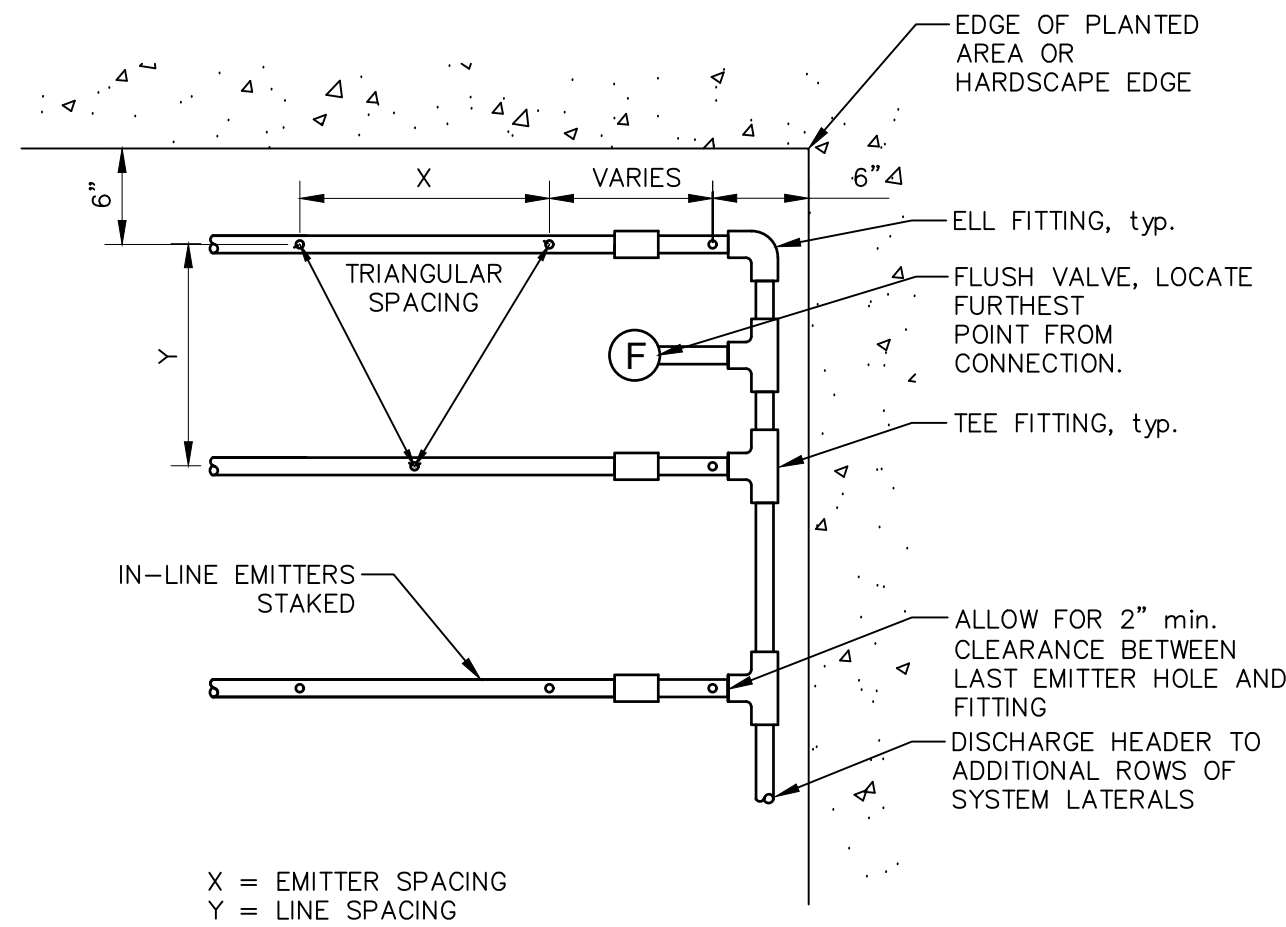


3 DRIPLINE LAYOUT
1" = 1'-0" DL-IR-SPR-DRIP-02

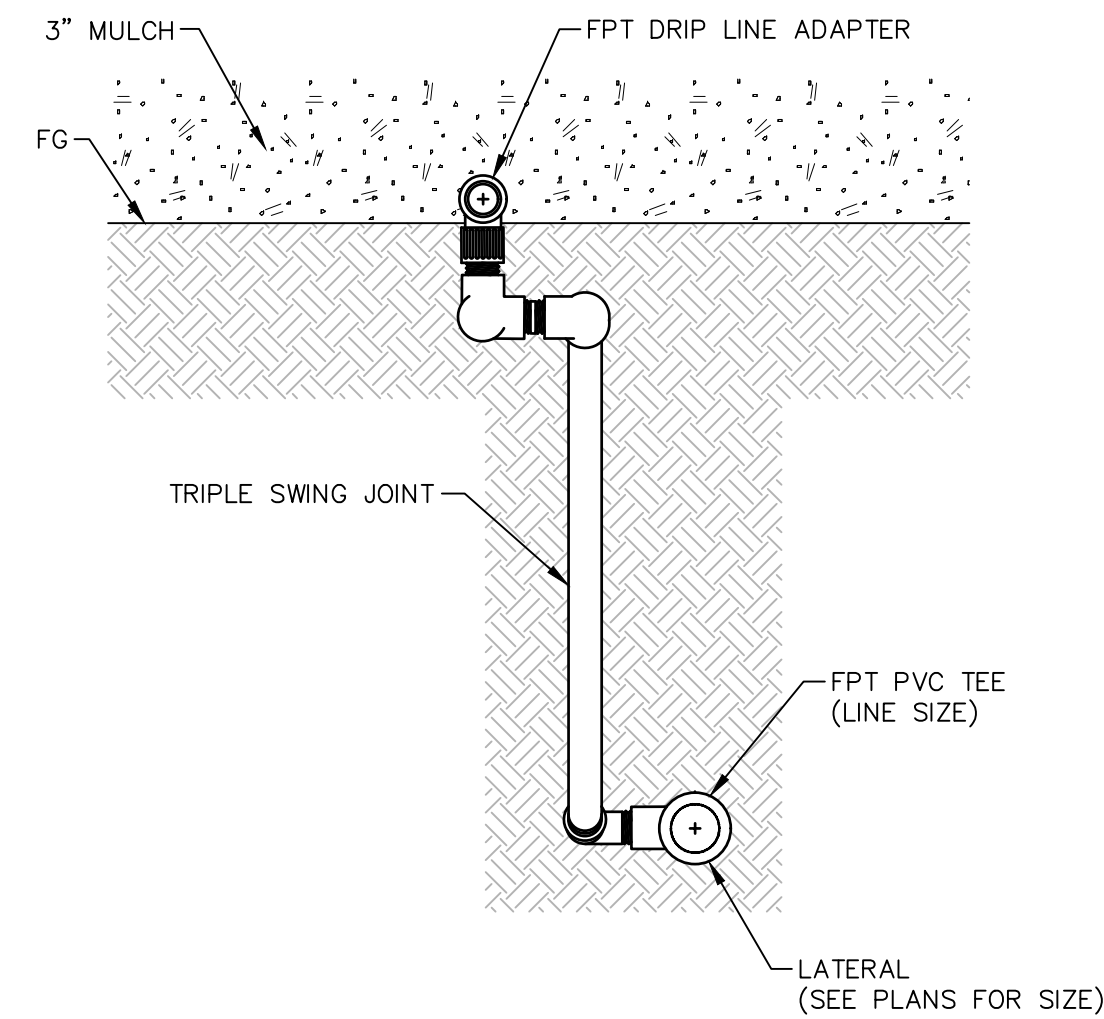


4 DRIP-LINE RISER DETAIL
3" = 1'-0" DL-IR-SPR-DRIP-35

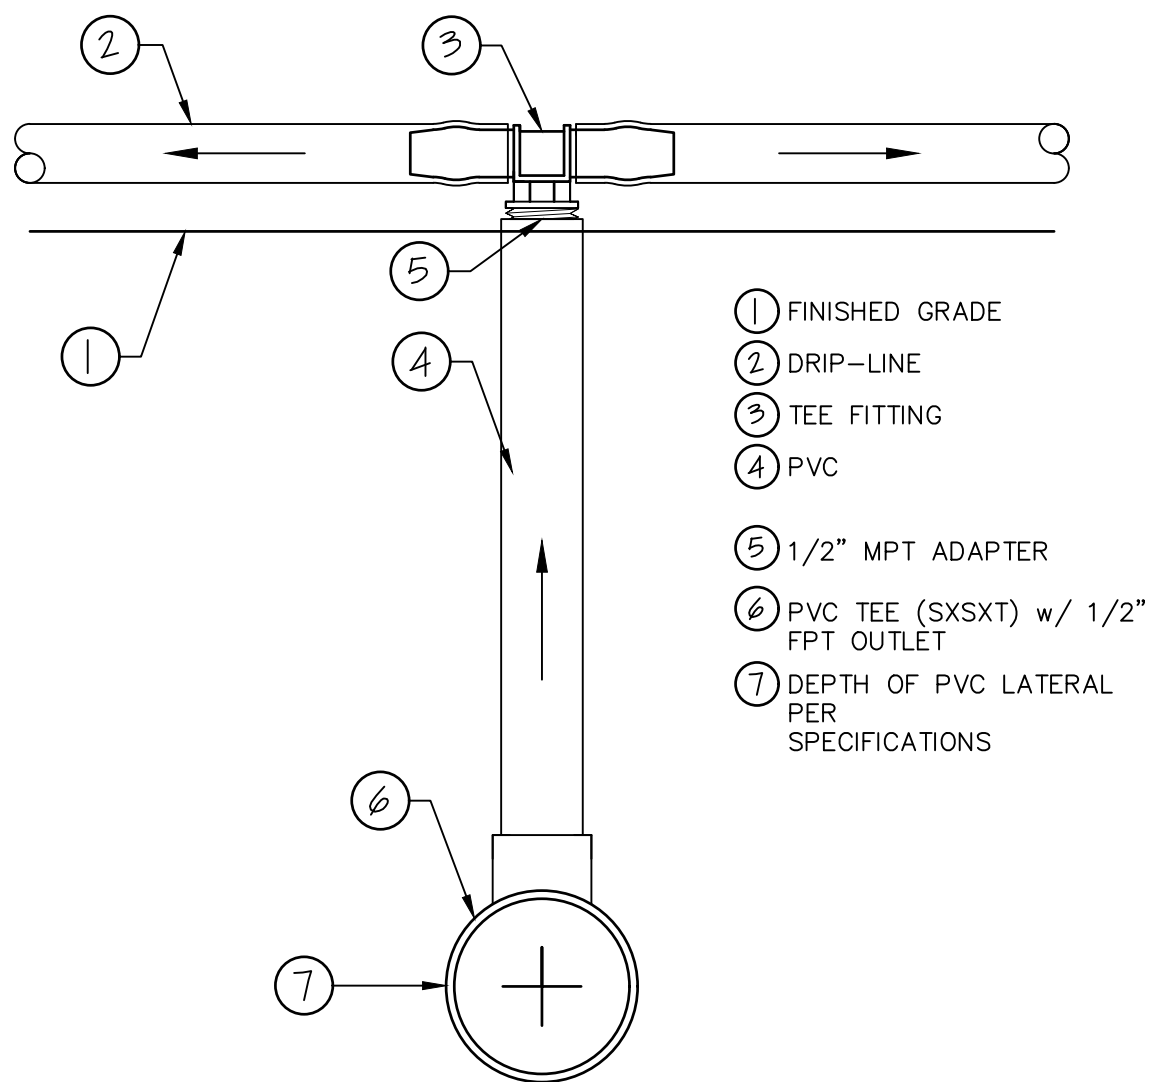

5 DRIPLINE LATERAL CONNECTION
6" = 1'-0" DL-IR-SPR-DRIP-38

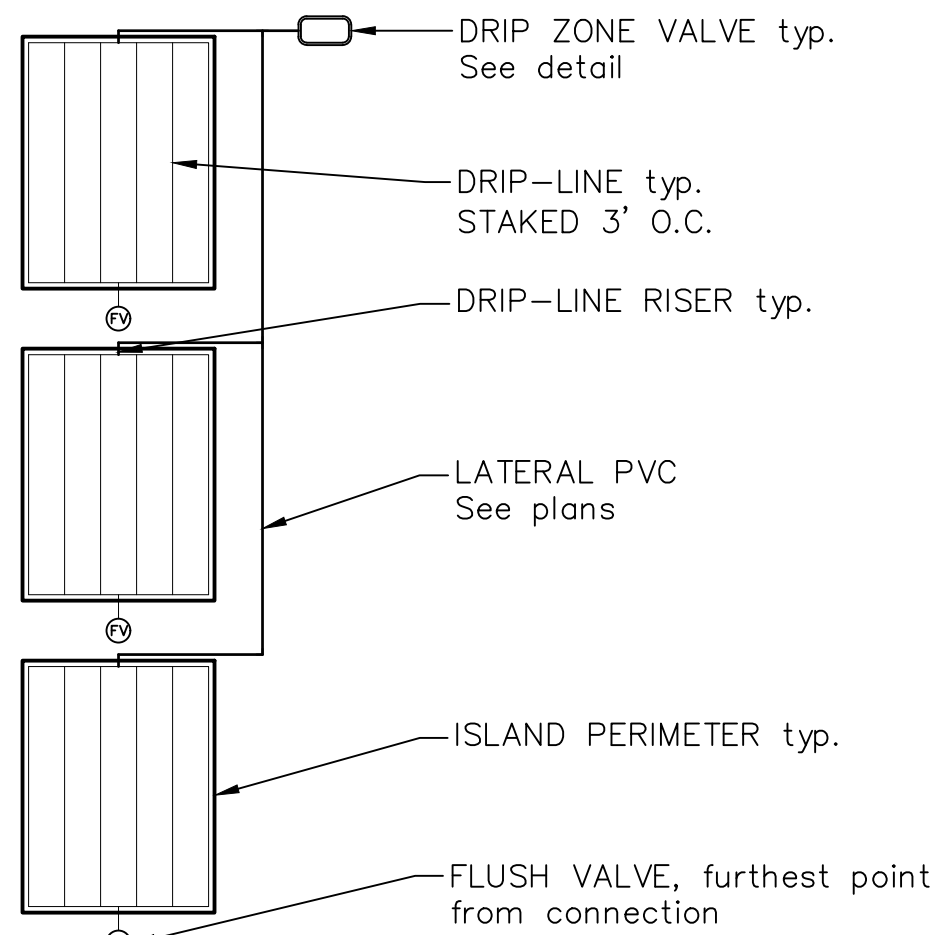

6 DRIPLINE MANIFOLD LAYOUT
1/8" = 1'-0" DL-IR-SPR-DRIP-39

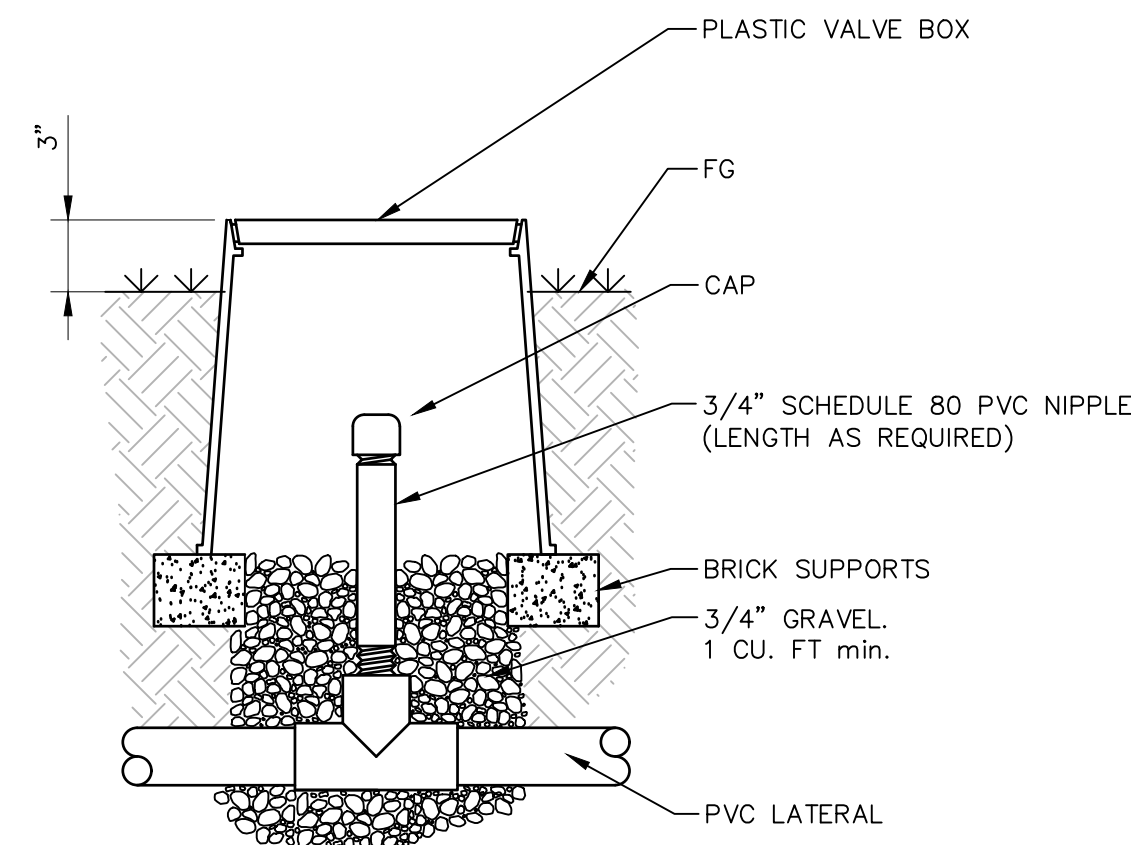

7 FLUSH VALVE - MANUAL - CAP
1 1/2" = 1'-0" DL-IR-SPR-DRIP-32

RECORD DRAWING		DATE	
DESIGNED: PB	12/14/20	RESIDENT ENGINEER	DATE
DRAWN: KJ	12/14/20		
CHECKED: PB	01/19/21		


designlab 252

P.O. Box 27616 Fresno, CA 93729

Studio: 559.472.9966 Fax: 559.472.9969

TENTATIVE PLANS FOR DESIGN


SUPERVISING ENGINEER DATE

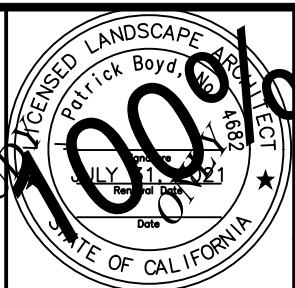

PROJECT

GOLDEN STATE BOULEVARD

CITY OF SELMA, CA

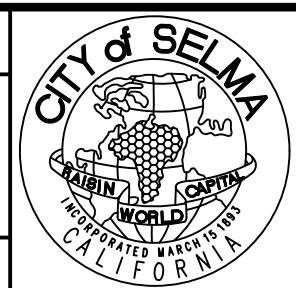

DEPARTMENT OF PUBLIC WORKS AND PLANNING

IRRIGATION DETAILS

DRAWING NO. ID-1 SHEET NO. 153 TOTAL 154

PATH: D:\Dropbox (DL252)\DL252 Temp Folder\PROJECTS\2015\15-05-006 Golden State\05-CAD\5.01-5.1-LANDSCAPE PLAN\5.01.5-1-WORKING\LOT DATE: 2/22/2021 5:12:14 PM
DRAWING: V:\21001\15-05-006\2-100-F-010

CAD USER: KONNI

GENERAL PROJECT INFORMATION

Date:3/24/2020

Project Name:Golden State Medians

Project Type:☒ Commercial ☐ Residential

Name of Project Applicant:Patrick Boyd

Telephone No. 559-472-9966

Fax No.

Title:Landscape Architect

Company:Designlab 252

City:Fresno

Email Address:Patrick@designlab252.com

Street Address:371 E Everglade Avenue

State:CA

Zip Code:93720

Project Address and Location

Street Address:

City:Selma

State:CA

Parcel, tract or lot number, if available:

Latitude/Longitude (optional):

Zip Code:

Property Owner or his/her designee:

Name:CITY OF SELMA

Telephone No.

Fax No.

Title:

Company:

City:

Email Address:

Street Address:

State:

Zip Code:

Water Purveyor:CITY

Compliance Type:FULL COMPLIANCE

Insert monthly Eto and Precipitation totals where:

Eto=Reference Evapotranspiration/month for Project Location (See Water Efficient Landscape Document)

Precip.=Precipitation /month for Project Location (see Wuculs or local weather station data on internet.)

Eppt=Effective precipitation (25% of monthly Precip)

LOCATION:SELMA, CA

	JAN	FEB	MAR	APR	MAY	JUN	JUL	AUG	SEP	OCT	NOV	DEC	ANNUAL TOTAL
Eto/Mo	1.0	1.5	3.4	4.8	6.6	7.7	8.4	7.2	5.3	3.4	1.4	0.7	51.4
Precip.													0.00
Eppt													0.00

	JAN	FEB	MAR	APR	MAY	JUN	JUL	AUG	SEP	OCT	NOV	DEC	TOTAL
Eto-Eppt	1.0	1.5	3.4	4.8	6.6	7.7	8.4	7.2	5.3	3.4	1.4	0.7	51.4

15-05-006 MWELO DATA.xlsx
GENERAL PROJECT INFORMATION

WATER EFFICIENT LANDSCAPE

This worksheet is filled out by the project applicant and it is a required element of the Landscape Documentation Package

Reference Evapotranspiration (Eto)51.4Project type ETAF0.45

HYDROZONE#/PLANTING DESCRIPTION	HYDROZONE	PF	IRRIGATION METHOD**	Irrigation Efficiency (IE)	ETAF (PF/IE)	LANDSCAPE AREA (Sq. Ft.)	ETAF X AREA	ESTIMATED TOTAL WATER USE (ETWU)
Regular Landscape Areas								
TREES	VERY LOW	0.1	B1/DR	0.81	0.12	0	0	0
	LOW	0.3	B1/DR	0.81	0.37	40,686	15,069	480,215
	MEDIUM	0.5	B1/DR	0.81	0.62	0	0	0
SHRUBS/GC	HIGH	0.8	B1/DR	0.81	0.99	0	0	0
	VERY LOW	0.1	B2/DL	0.81	0.12	0	0	0
	LOW	0.3	B2/DL	0.81	0.37	69,865	25,876	824,614
TURF/GC	MEDIUM	0.5	B2/DL	0.81	0.62	8,194	5,058	161,189
	HIGH	0.8	B2/DL	0.81	0.99	0	0	0
	VERY LOW	0.1	R/S	0.75	0.13	0	0	0
TEMPORARY WATER FEATURE	LOW	0.3	R/S	0.75	0.67	0	0	0
	HIGH	0.8	R/S	0.75	1.07	0	0	0
	LOW	0.3				0	0	0
TOTALS						118,745	46,003	1,466,018
Special Landscape Areas								
					1.00	0	0	0
					1.00	0	0	0
					1.00	0	0	0
TOTALS						0	0	0
ETWU TOTAL							1,466,018.49	
[MAXIMUM ALLOWED WATER ALLOWANCE] MAWA							1,702,874.55	

ETAF Calculations

Regular Landscape Areas

Total ETAF x area46,003

Total Area118,745

Average ETAF0.39

All Landscape Areas

Total ETAF x area46,003

Total Area118,745

Sitewide ETAF0.39

MAWA =Eto X 0.62 [ETAF x LA + (1-ETAF) X SLA

ETWU=Eto X 0.62 x ETAF X AREA

Average ETAF for Regular Landscape Areas must be 0.55 or below for residential areas, and 0.45 or below for non residential areas

15-05-006 MWELO DATA.xlsx
WATER EFFICIENT LANDSCAPE

HYDROZONE AREA (A & B)

				A				B				C				D	E
				*Trees (B1/DR)				Shrubs/GC (B2/DL)				Turf/GC (S/R)				Temp	Water Feature
	Type	Hydrozone	Area	VL	LW	MW	HW	VL	LW	MW	HW	VL	LW	MW	HW	LW	HW
VALVE NUMBER	A1	B	LW	7725	0	0	0	0	0	7725	0	0	0	0	0	0	0
	A2	A	LW	2946	0	2946	0	0	0	0	0	0	0	0	0	0	0
	A3	A	LW	1648.5	0	1649	0	0	0	0	0	0	0	0	0	0	0
	A4	B	LW	7288	0	0	0	0	0	7288	0	0	0	0	0	0	0
	A5	A	LW	314	0	314	0	0	0	0	0	0	0	0	0	0	0
	A6	B	MW	5627	0	0	0	0	0	0	5627	0	0	0	0	0	0
	A7	A	LW	3768	0	3768	0	0	0	0	0	0	0	0	0	0	0
	A8	B	LW	3696	0	0	0	0	0	3696	0	0	0	0	0	0	0
	B1	B	LW	2570	0	0	0	0	0	2570	0	0	0	0	0	0	0
	B2	A	LW	2198	0	2198	0	0	0	0	0	0	0	0	0	0	0
	B3	B	LW	1360	0	0	0	0	0	1360	0	0	0	0	0	0	0
	B4	A	LW	1020.5	0	1021	0	0	0	0	0	0	0	0	0	0	0
	B5	A	LW	1256	0	1256	0	0	0	0	0	0	0	0	0	0	0
	B6	B	LW	1343	0	0	0	0	0	1343	0	0	0	0	0	0	0
	B7	A	LW	1648.5	0	1649	0	0	0	0	0	0	0	0	0	0	0
	B8	B	LW	2207	0	0	0	0	0	2207	0	0	0	0	0	0	0
B9	A	LW	3061.5	0	3062	0	0	0	0	0	0	0	0	0	0	0	
TOTALS				0	17861	0	0	0	26189	5627	0	0	0	0	0	0	

* Hydrozone area for all tree valves calculated by using the mature canopy of trees

*Hydro zone	Water Use	Plant Factor	Project Value
VL	Very Low	0-0.1	0.1
LW	Low	0.1-0.3	0.3
MW	Medium	0.4-0.6	0.5
HW	High	0.7-1.0	0.8
SLA	Special	1	1

** Irrigation Method		
B1	Drip Bubbler Tree	0.81
B2	Drip Bubbler Shru	0.81
DL/DR	Drip line/Drip Rin	0.81
R	Rotor	0.75
S	Spray	0.75

Type
A
B
C
D
E

15-05-006 MWELO DATA.xlsx
HYDROZONE AREA (A & B)

HYDROZONE AREA (C,D & E)

				A				B				C				D	E
				*Trees (B1/DR)				Shrubs/GC (B2/DL)				Turf/GC (S/R)				Temp	Water Feature
	Type	Hydrozone	Area	VL	LW	MW	HW	VL	LW	MW	HW	VL	LW	MW	HW	LW	HW
VALVE NUMBER	C1	B	LW	5057	0	0	0	0	0	5057	0	0	0	0	0	0	0
	C2	A	LW	1884	0	1884	0	0	0	0	0	0	0	0	0	0	0
	C3	A	LW	1570	0	1570	0	0	0	0	0	0	0	0	0	0	0
	C4	B	LW	1137	0	0	0	0	0	1137	0	0	0	0	0	0	0
	C5	A	LW	1413	0	1413	0	0	0	0	0	0	0	0	0	0	0
	C6	B	LW	961	0	0	0	0	0	961	0	0	0	0	0	0	0
	C7	A	LW	1099	0	1099	0	0	0	0	0	0	0	0	0	0	0
	C8	B	LW	620	0	0	0	0	0	620	0	0	0	0	0	0	0
	D1	B	LW	8559	0	0	0	0	0	8559	0	0	0	0	0	0	0
	D2	B	LW	7585	0	0	0	0	0	7585	0	0	0	0	0	0	0
	D3	A	LW	2747.5	0	2748	0	0	0	0	0	0	0	0	0	0	0
	D4	A	LW	2904.5	0	2905	0	0	0	0	0	0	0	0	0	0	0
	D5	A	LW	3140	0	3140	0	0	0	0	0	0	0	0	0	0	0
	D6	A	LW	3768	0	3768	0	0	0	0	0	0	0	0	0	0	0
	D7	B	LW	6667	0	0	0	0	0	6667	0	0	0	0	0	0	0
	D8	B	LW	7968	0	0	0	0	0	7968	0	0	0	0	0	0	0
D9	A	LW	2826	0	2826	0	0	0	0	0	0	0	0	0	0	0	
D10	B	MW	2567	0	0	0	0	0	0	2567	0	0	0	0	0	0	
E1	A	LW	1473	0	1473	0	0	0	0	0	0	0	0	0	0	0	
E2	B	LW	5122	0	0	0	0	0	5122	0	0	0	0	0	0	0	
TOTALS				0	22825	0	0	0	43676	2567	0	0	0	0	0	0	

* Hydrozone area for all tree valves calculated by using the mature canopy of trees

*Hydro zone	Water Use	Plant Factor	Project Value
VL	Very Low	0-0.1	0.1
LW	Low	0.1-0.3	0.3
MW	Medium	0.4-0.6	0.5
HW	High	0.7-1.0	0.8
SLA	Special	1	1

** Irrigation Method		
B1	Drip Bubbler Tree	0.81
B2	Drip Bubbler Shru	0.81
DL/DR	Drip line/Drip Rin	0.81
R	Rotor	0.75
S	Spray	0.75

Type
A
B
C
D
E

15-05-006 MWELO DATA.xlsx
HYDROZONE AREA (C,D & E)

DESIGNED: PB		DATE	RECORD DRAWING	
DRAWN: KJ		12/14/20	RESIDENT ENGINEER	DATE
CHECKED: PB		01/19/21		
FOR RIGHT OF WAY DATA AND ACCURATE ACCESS DETERMINATION, SEE DOCUMENTS IN THE DEPARTMENT OF PUBLIC WORKS AND PLANNING.				

designlab252

P.O. Box 27616 Fresno, CA 93729

Studio: 559.472.9966 Fax: 559.472.9969

TENTATIVE

PLANS

FOR

DESIGN

DATE

STAMP

PROJECT

GOLDEN STATE BOULEVARD

CITY OF SELMA, CA

CITY of SELMA

DEPARTMENT OF PUBLIC WORKS AND PLANNING

DEPARTMENT OF PUBLIC WORKS AND PLANNING

MWELO DATA

DRAWING NO. ID-2 SHEET NO. 154 TOTAL 154